

Dist	COUNTY	ROUTE	POST MILES TOTAL PROJECT	SHEET No.	TOTAL SHEETS
11	SD	8,54,67,94, 125, etc.	Var	201	231



Randell D. Hiatt  
REGISTERED CIVIL ENGINEER

July 19, 2013  
PLANS APPROVAL DATE

THE STATE OF CALIFORNIA OR ITS OFFICERS OR AGENTS SHALL NOT BE RESPONSIBLE FOR THE ACCURACY OR COMPLETENESS OF SCANNED COPIES OF THIS PLAN SHEET.

REGISTERED PROFESSIONAL ENGINEER  
No. C50200  
Exp. 6-30-15  
CIVIL  
STATE OF CALIFORNIA


TO ACCOMPANY PLANS DATED 01-11-16

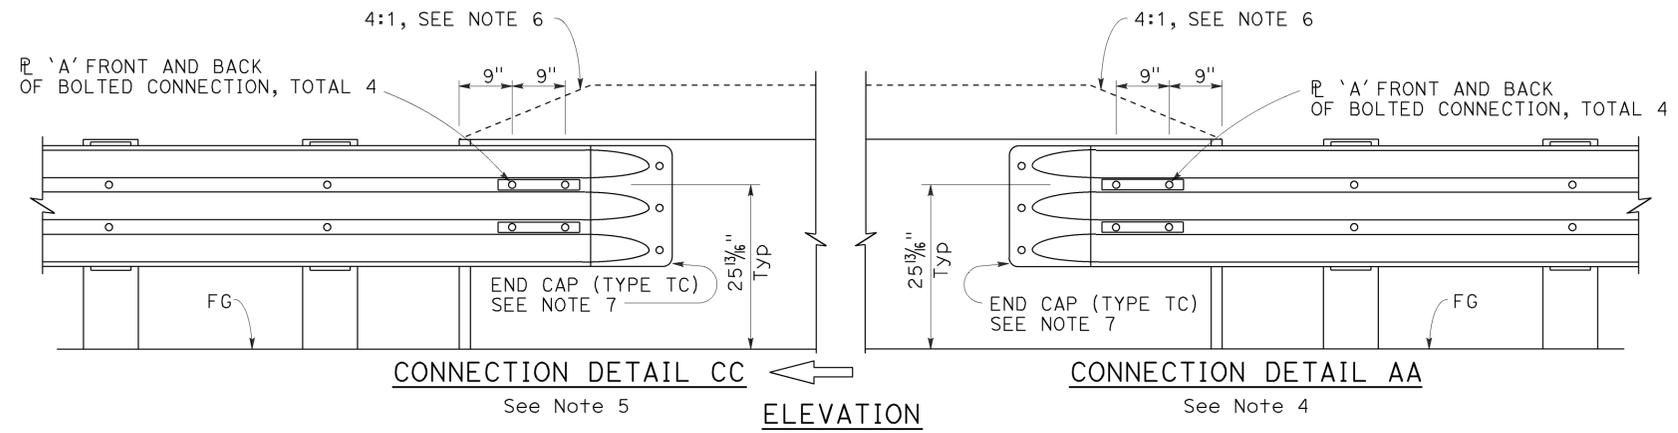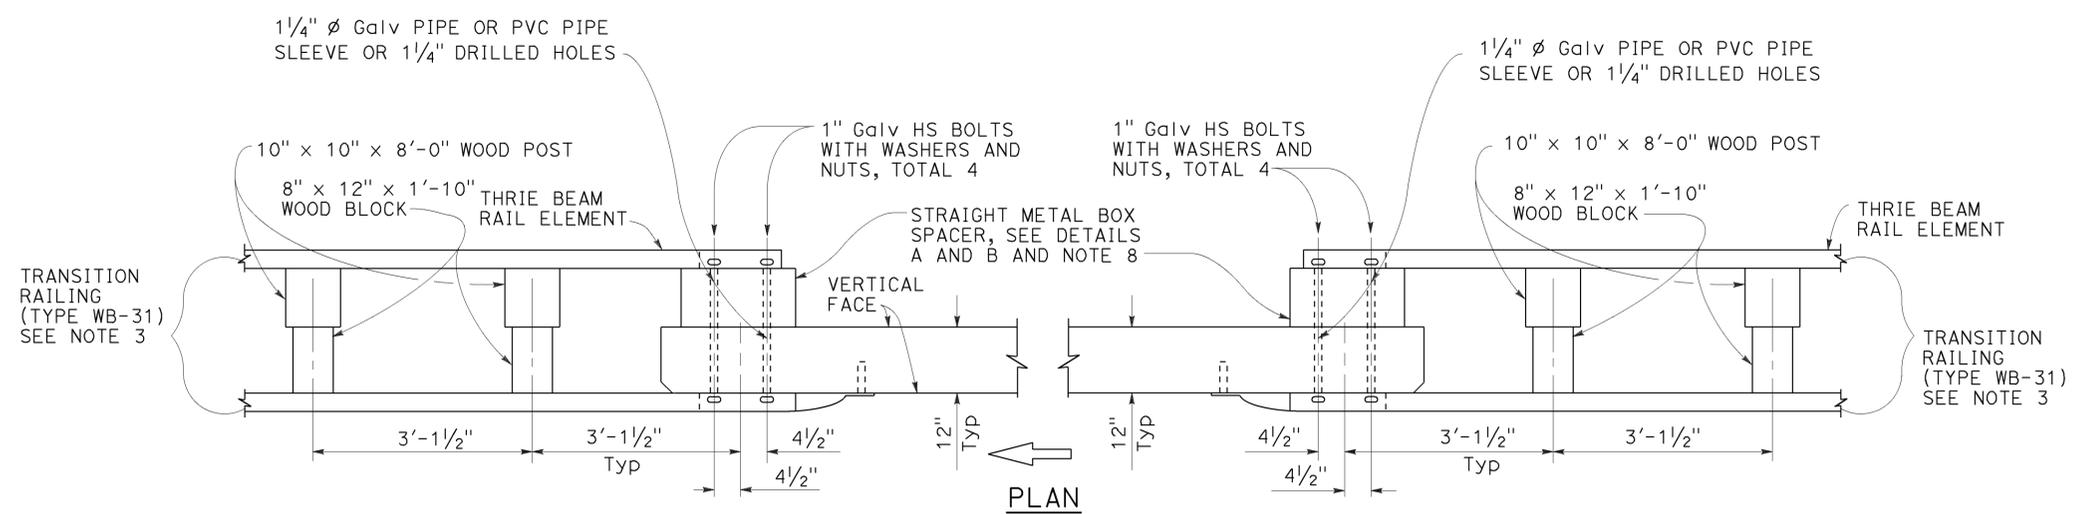

**MIDWEST GUARDRAIL SYSTEM CONNECTION TO BRIDGE RAILING WITHOUT SIDEWALK**

**NOTES:**

1. See Revised Standard Plan RSP A77U1 for additional connection details to bridges without sidewalks.
2. Additional details of posts, blocks and hardware are shown on Revised Standard Plans RSP A77M1, RSP A77N1 and RSP A77N2.
3. For additional details of Transition Railing (Type WB-31), see Revised Standard Plan RSP A77U4. Transition Railing (Type WB-31) transitions the 12 gauge MGS railing section to a heavier gage nested thrie beam railing section which is connected to the concrete bridge railing.
4. For typical use of Connection Detail AA, see Layout Types 12A and 12B on Revised Standard Plan RSP A77Q1, Layout Types 12C and 12D on Revised Standard Plan RSP A77Q2, and Layout Type 12E on Revised Standard Plan RSP A77Q3.
5. For typical use of Connection Detail CC, see Layout Types 12AA and 12BB on Revised Standard Plan RSP A77Q4 and Layout Type 12CC on Revised Standard Plan RSP A77Q5.
6. Where the height of the bridge railing exceeds the height of the thrie beam railing by more than 1" at Connection Detail AA and connection Detail CC, taper the top of the end of the bridge railing at 4:1 to match the top elevation of the thrie beam railing.
7. For details of End Cap (Type TC), see Revised Standard Plan RSP A77U4.
8. See Revised Standard Plan RSP A77U4 for additional details regarding depth dimension for straight metal box spacer.

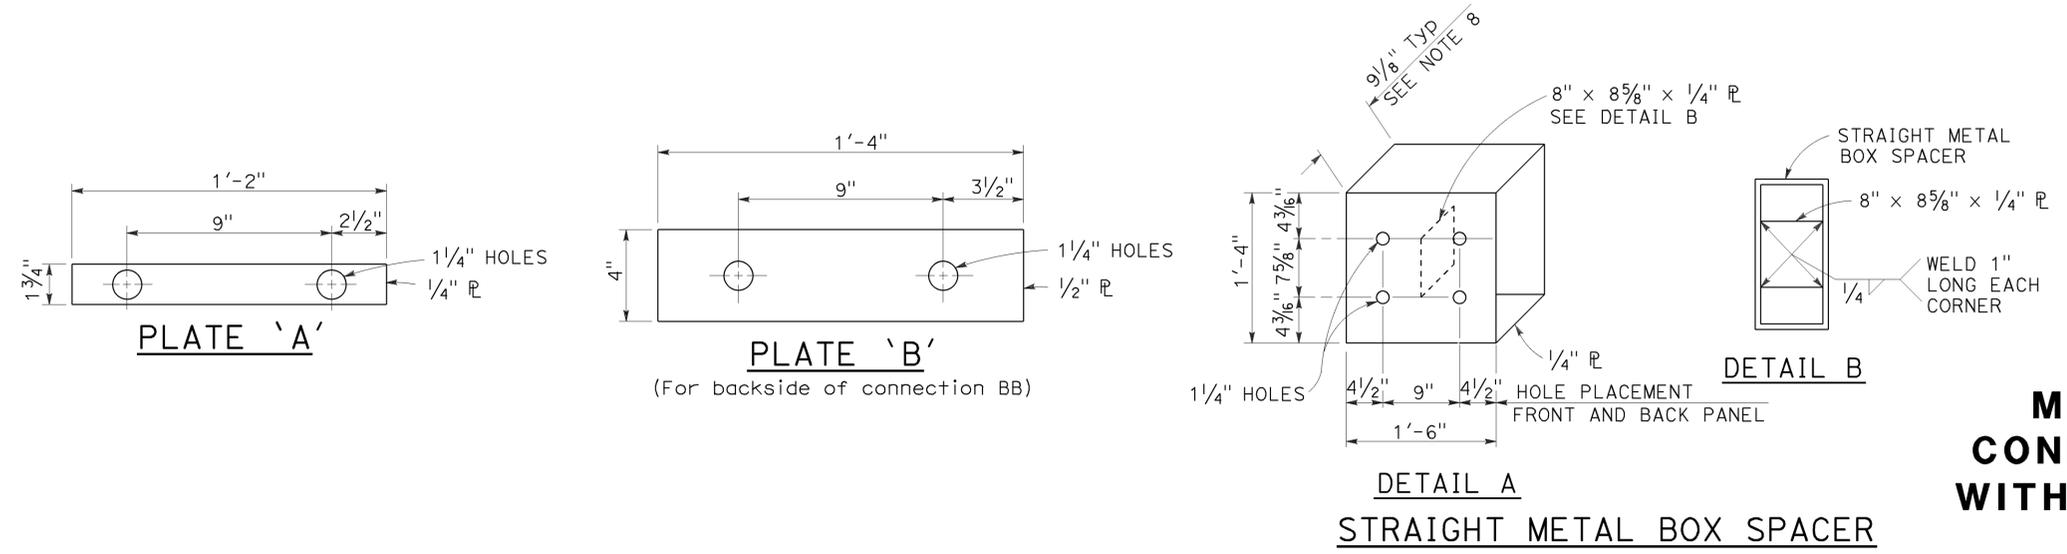

STATE OF CALIFORNIA  
DEPARTMENT OF TRANSPORTATION

**MIDWEST GUARDRAIL SYSTEM  
CONNECTIONS TO BRIDGE RAILINGS  
WITHOUT SIDEWALKS DETAILS No. 2**

NO SCALE

RSP A77U2 DATED JULY 19, 2013 SUPPLEMENTS THE STANDARD PLANS BOOK DATED 2010.

**REVISED STANDARD PLAN RSP A77U2**

2010 REVISED STANDARD PLAN RSP A77U2

Dist	COUNTY	ROUTE	POST MILES TOTAL PROJECT	SHEET No.	TOTAL SHEETS
11	SD	8,54,67,94, 125, etc.	Var	202	231


**Randell D. Hiatt**  
REGISTERED CIVIL ENGINEER

July 19, 2013  
PLANS APPROVAL DATE

THE STATE OF CALIFORNIA OR ITS OFFICERS OR AGENTS SHALL NOT BE RESPONSIBLE FOR THE ACCURACY OR COMPLETENESS OF SCANNED COPIES OF THIS PLAN SHEET.




TO ACCOMPANY PLANS DATED 01-11-16

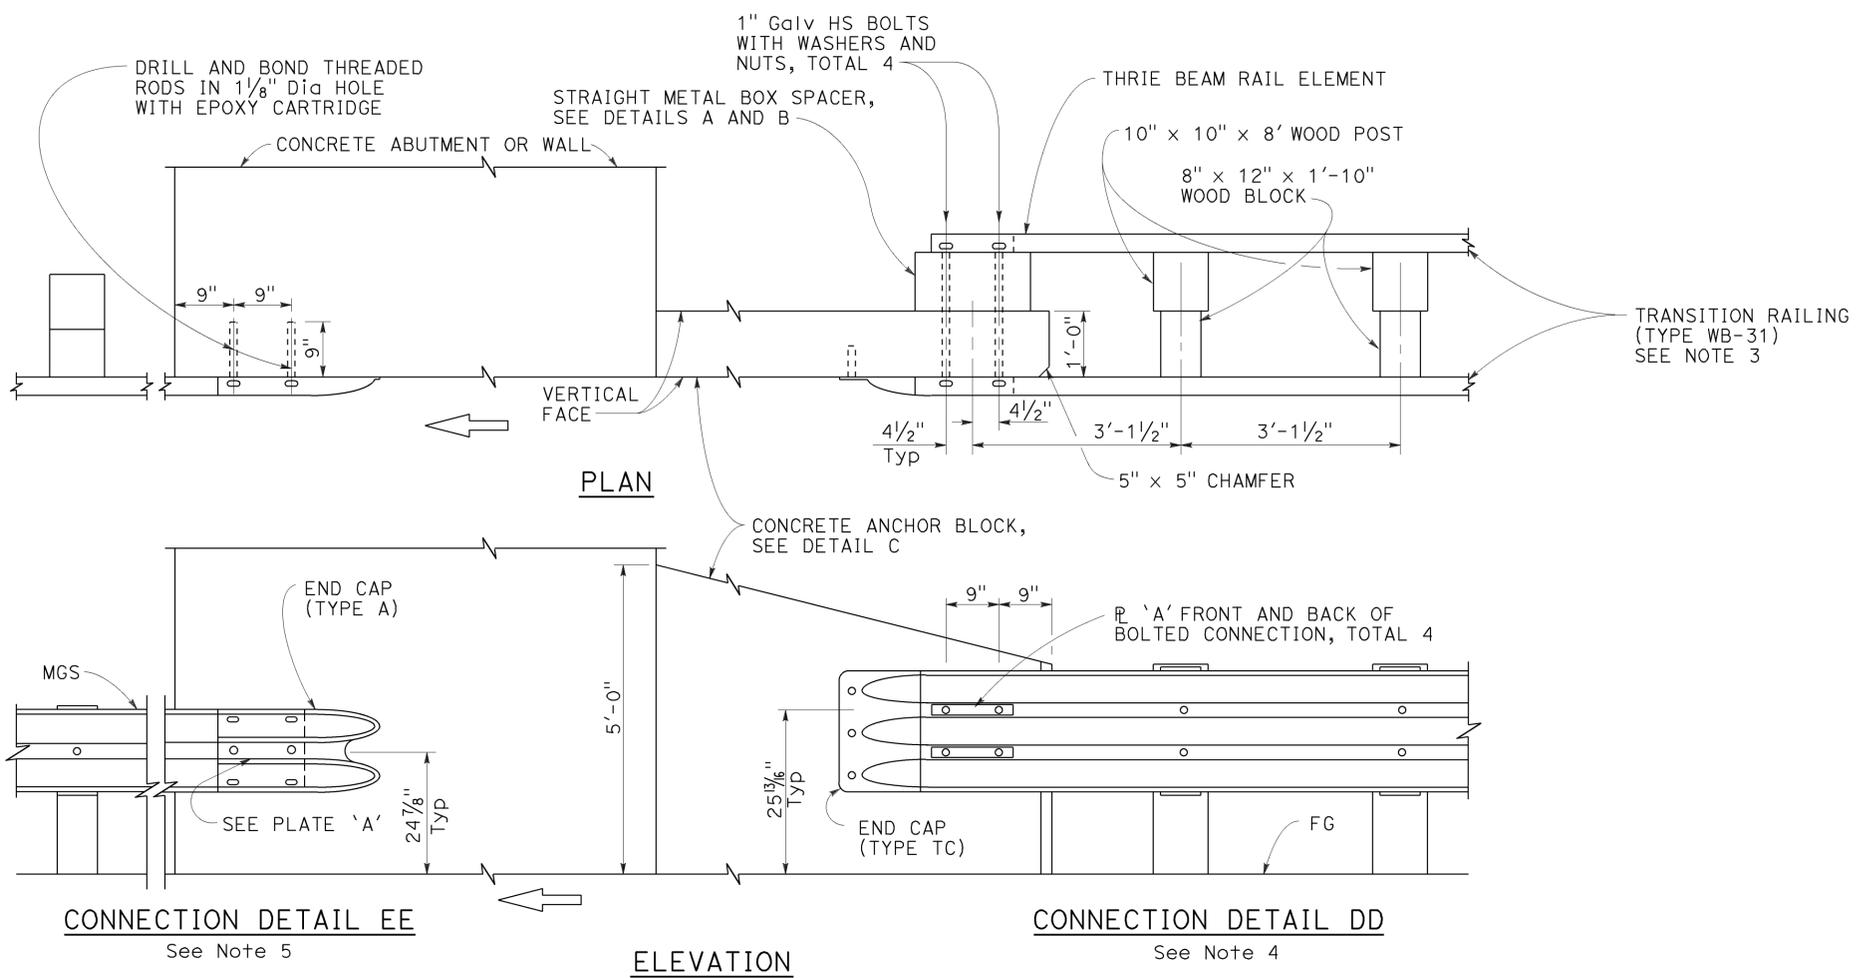

**NOTES:**

1. These connection details apply to abutments and walls.
2. Additional details of posts, blocks and hardware are shown on Revised Standard Plans RSP A77M1, RSP A77N1 and RSP A77N2.
3. For additional details of Transition Railing (Type WB-31), see Revised Standard Plan RSP A77U4. Transition Railing (Type WB-31) transitions the 12 gauge MGS railing section to a heavier gage nested thrie beam railing section which is connected to the concrete anchor block.
4. For typical use of Connection Details DD, see Layout Types 12A and 12B on Revised Standard Plan RSP A77Q1 and Layout Types 12C and 12D on Revised Standard Plan RSP A77Q2.
5. For typical use of Connection Detail EE, see Layout Type 12D on Revised Standard Plan RSP A77Q2 and Layout Type 12DD on Revised Standard Plan RSP A77Q5.

**MIDWEST GUARDRAIL SYSTEM CONNECTION TO ABUTMENT OR WALL**

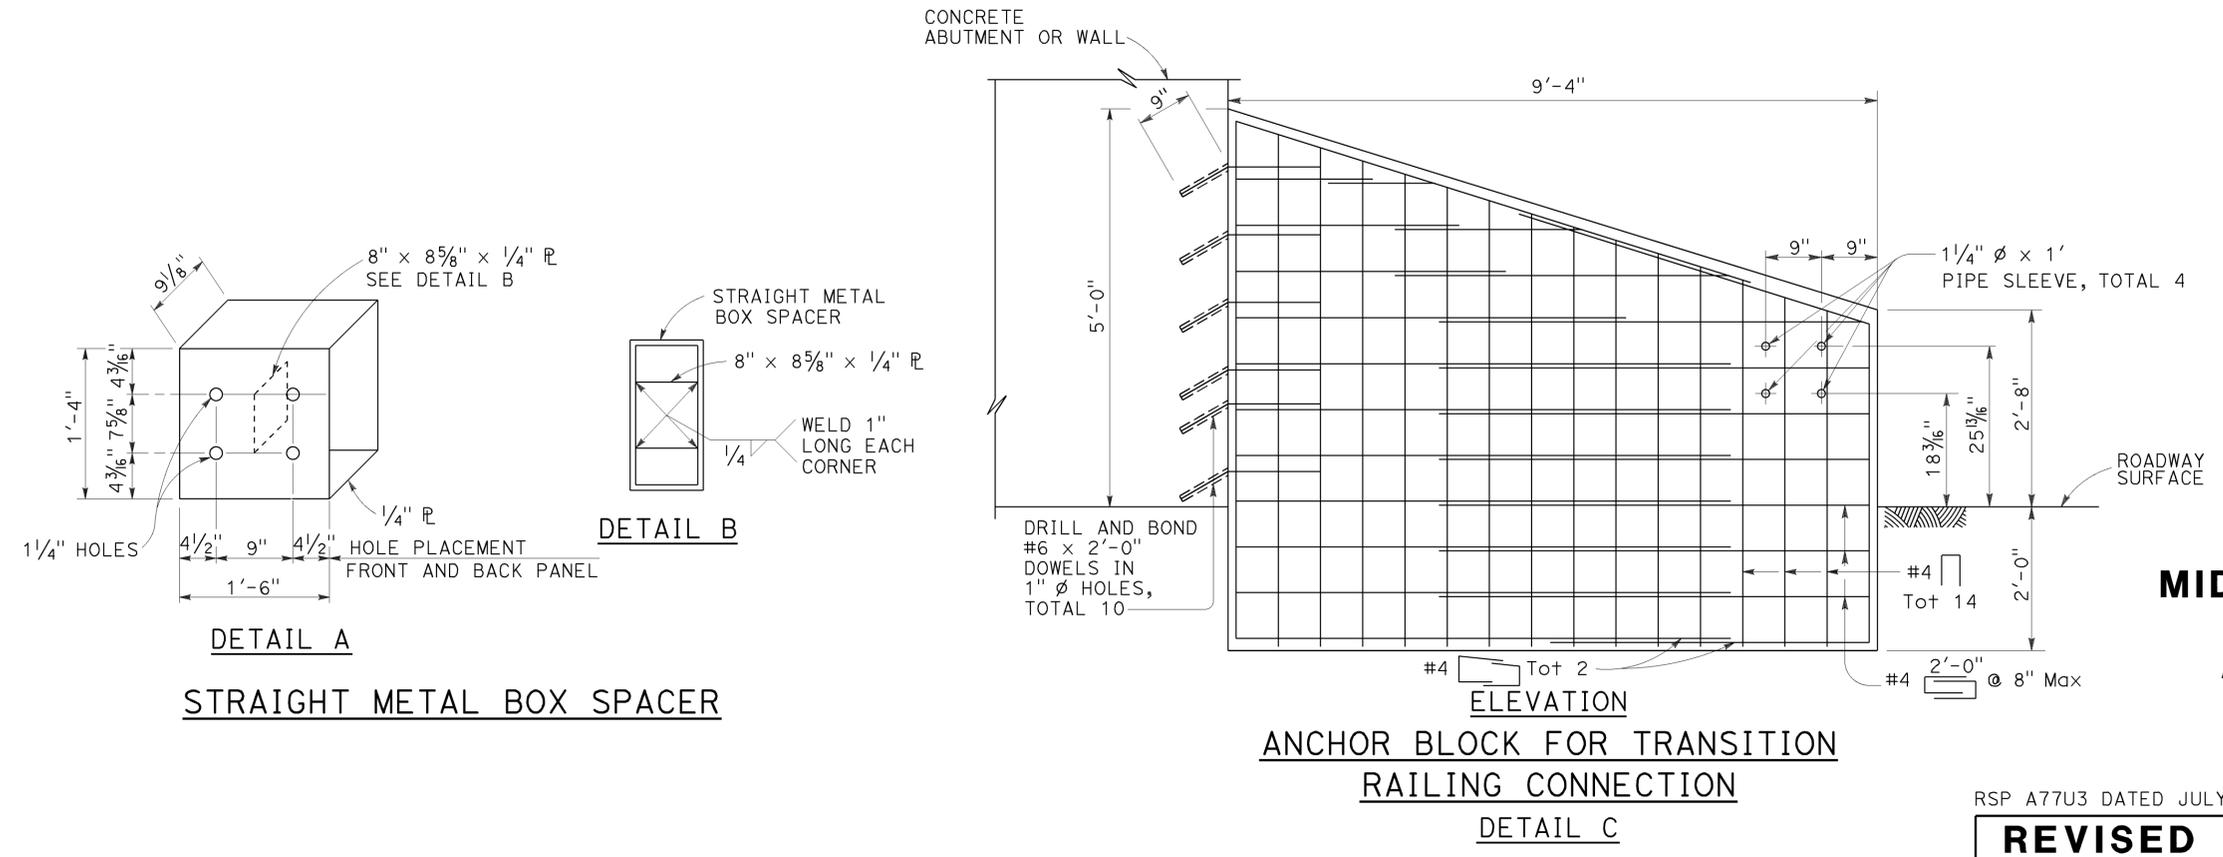

**MIDWEST GUARDRAIL SYSTEM CONNECTIONS TO ABUTMENTS AND WALLS**

STATE OF CALIFORNIA  
DEPARTMENT OF TRANSPORTATION

NO SCALE

RSP A77U3 DATED JULY 19, 2013 SUPPLEMENTS THE STANDARD PLANS BOOK DATED 2010.

**REVISED STANDARD PLAN RSP A77U3**

2010 REVISED STANDARD PLAN RSP A77U3








Dist	COUNTY	ROUTE	POST MILES TOTAL PROJECT	SHEET No.	TOTAL SHEETS
11	SD	8,54,67,94, 125, etc.	Var	203	231

**Randell D. Hiatt**  
REGISTERED CIVIL ENGINEER

January 23, 2015  
PLANS APPROVAL DATE

THE STATE OF CALIFORNIA OR ITS OFFICERS OR AGENTS SHALL NOT BE RESPONSIBLE FOR THE ACCURACY OR COMPLETENESS OF SCANNED COPIES OF THIS PLAN SHEET.

REGISTERED PROFESSIONAL ENGINEER  
No. C50200  
Exp. 6-30-15  
CIVIL  
STATE OF CALIFORNIA

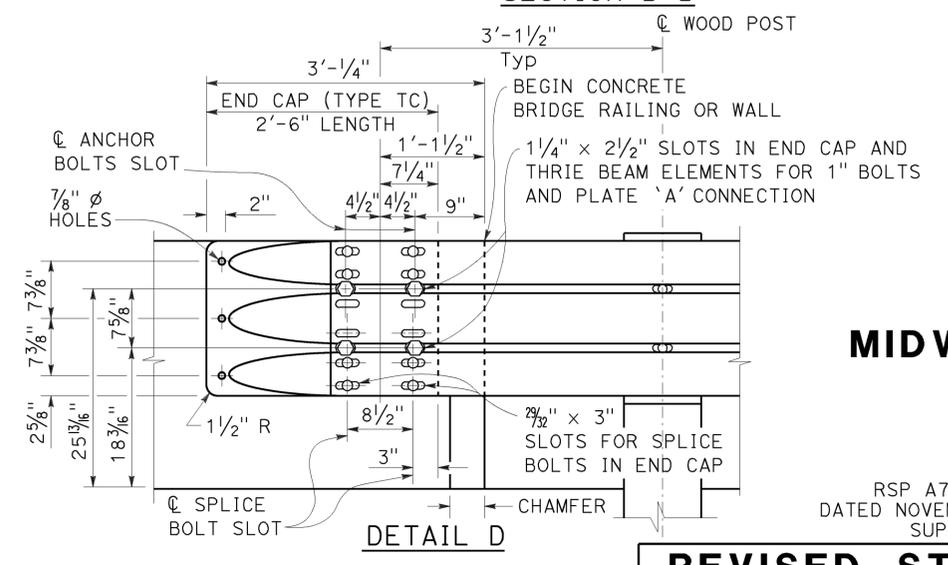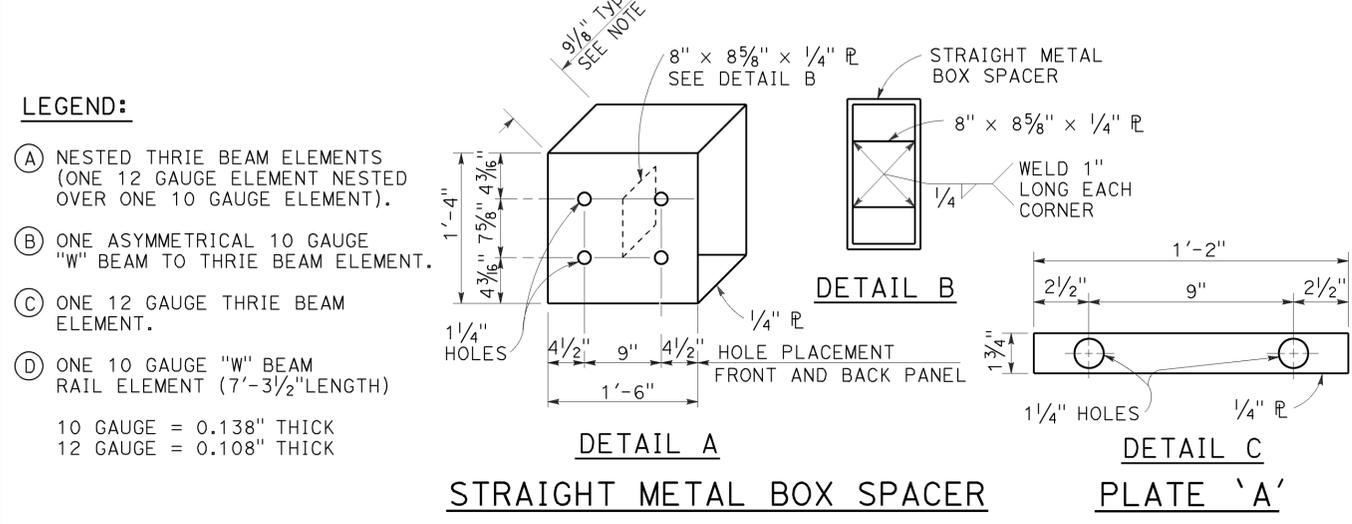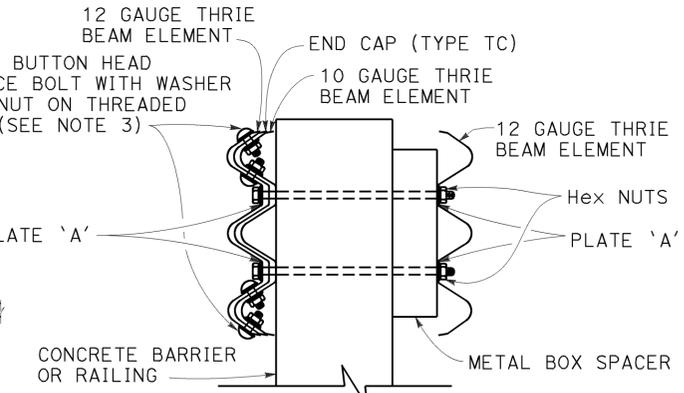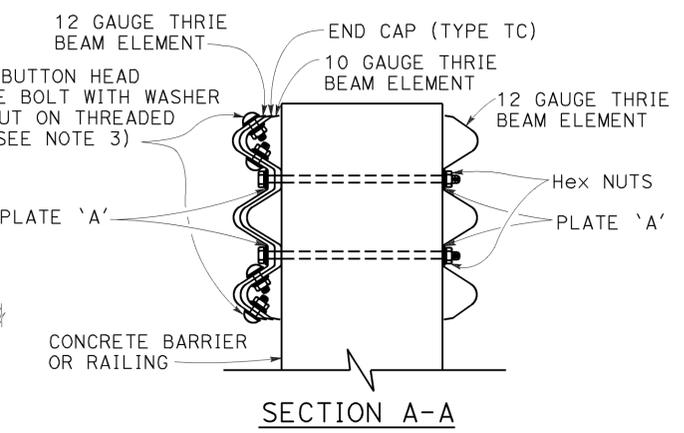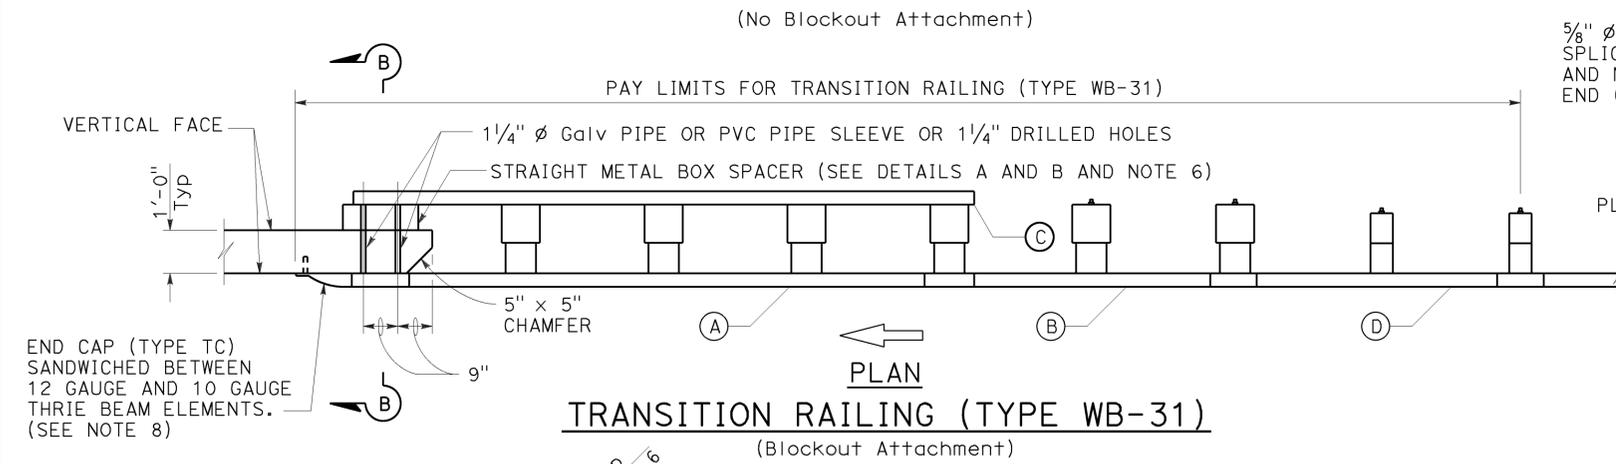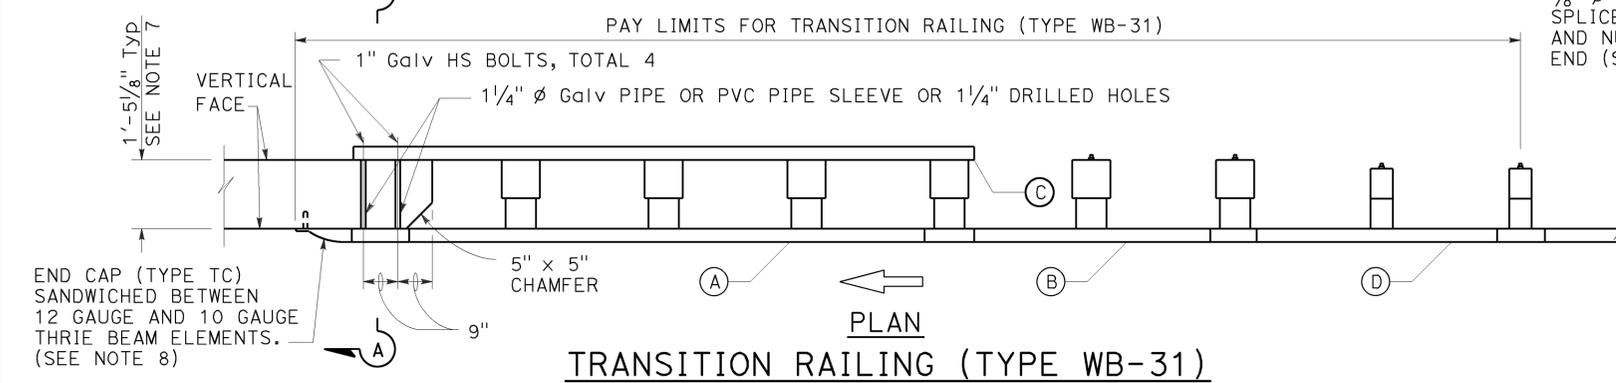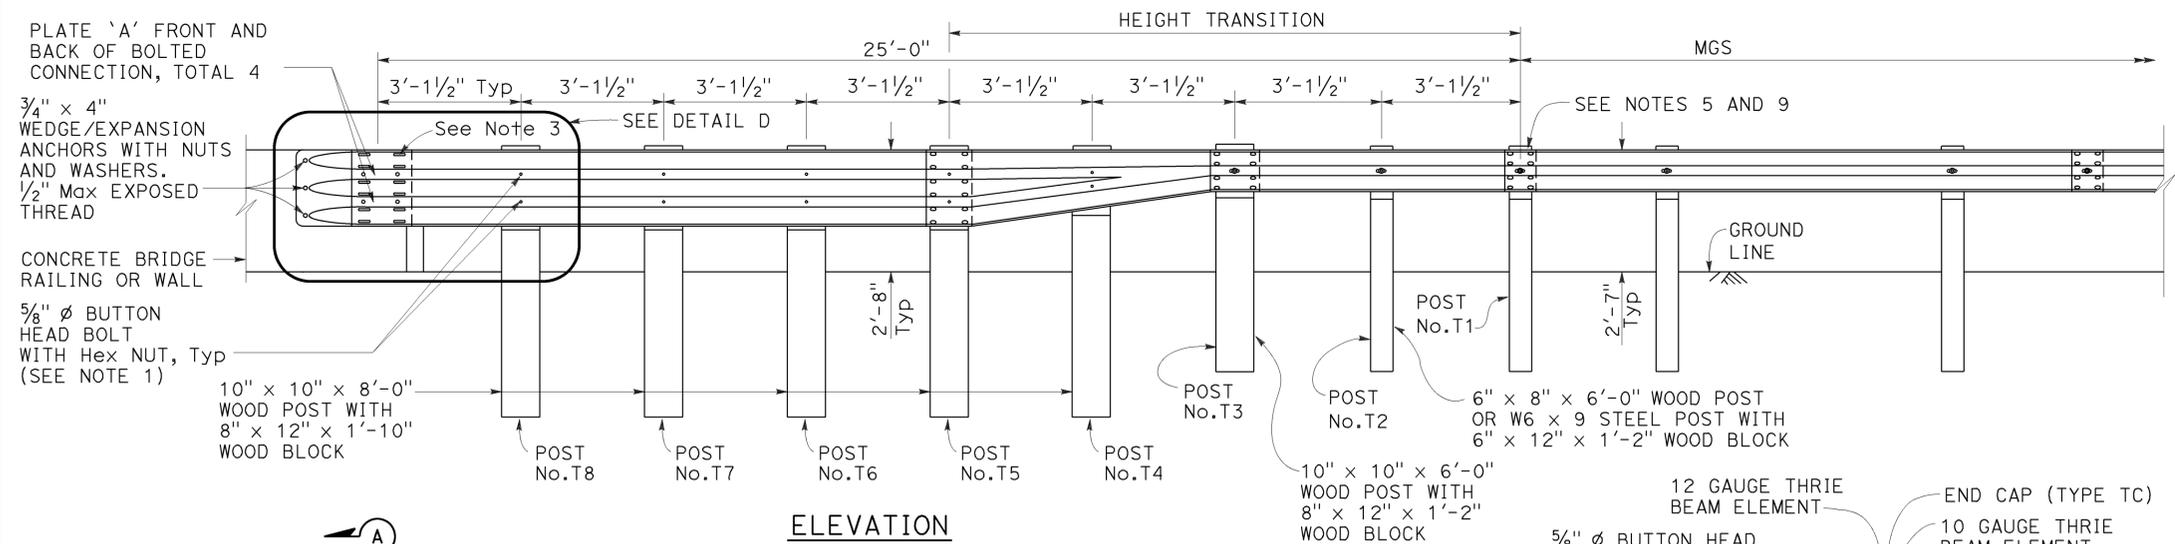

- NOTES:** TO ACCOMPANY PLANS DATED 01-11-16
- Use 5/8" ø Button head bolts and hex nuts for connections to posts. No washer on rail face for bolted connections to post.
  - The nested rail elements, end cap, and 'W' beam to thrie beam element may be spliced together prior to bolting the elements to the wood post and concrete barrier or railing.
  - Exterior splice bolt holes for rail element splices at Post No. T5 and the connection to the concrete barrier or railing shall be the standard 2 1/2" x 1 1/8" slot size. Interior splice bolt holes at these locations may be increased up to 1 1/4" ø. Only the top 4 and the bottom 4 splice bolts with washers and nuts are required for rail splices at Post No. T5 and the connection to the concrete barrier or railing.
  - The top elevation of Posts No. T2 through No. T7 shall not project more than 1" above the top elevation of the rail element.
  - Typically, the railing connected to Transition Railing (Type WB-31) will be either standard railing section of MGS with height transition ratio of 150:1 or a Caltrans approved 31" end treatment attached to Post No. T1.
  - The depth of the metal box spacer varies from the 9/8" to 1 1/2" and is dependent on the width of the concrete railing or wall. The combined dimension for the depth of the metal box spacer plus the width of railing or wall is typically 21 1/8". Where the space between the backside of the concrete railing or wall and the rear thrie beam element is less than 1 1/2", metal plates similar to Plate 'A' are to be used as spacers.
  - Where the width of the concrete railing or wall is greater than 17 1/8", wood blocks are to be used to fill the space created between the backside of Posts No. T5 through No. T8 and the rear thrie beam element. These wood blocks shall be 8" in width and 1'-2" in length. The dimension between the front thrie beam element and the rear thrie beam element is to match the width of the concrete railing or wall.
  - End cap may be installed over 12 gauge and 10 gauge thrie beam elements where transition railing is installed on the departure end of bridge railing.
  - Conform standard railing section height to 31" at Post No. T1 using height transition ratio of 150:1.

STATE OF CALIFORNIA  
DEPARTMENT OF TRANSPORTATION

**MIDWEST GUARDRAIL SYSTEM  
TRANSITION RAILING  
(TYPE WB-31)**

NO SCALE


RSP A77U4 DATED JANUARY 23, 2015 SUPERSEDES RSP A77U4 DATED NOVEMBER 15, 2013 AND RSP A77U4 DATED JULY 19, 2013 THAT SUPPLEMENTS THE STANDARD PLANS BOOK DATED 2010.

**REVISED STANDARD PLAN RSP A77U4**


2010 REVISED STANDARD PLAN RSP A77U4




TO ACCOMPANY PLANS DATED 01-11-16

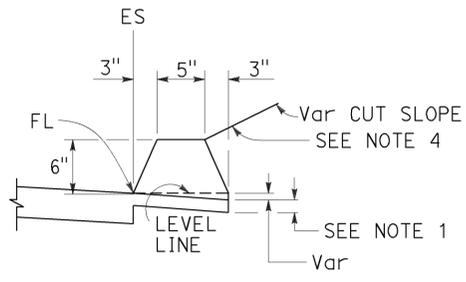


**TYPE A**  
See Note 3

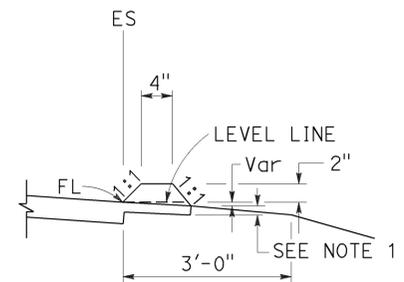


**TYPE C**

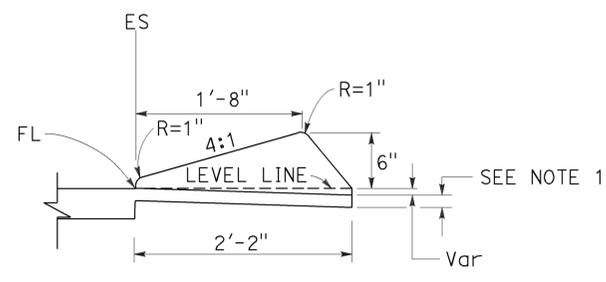

**TYPE D**

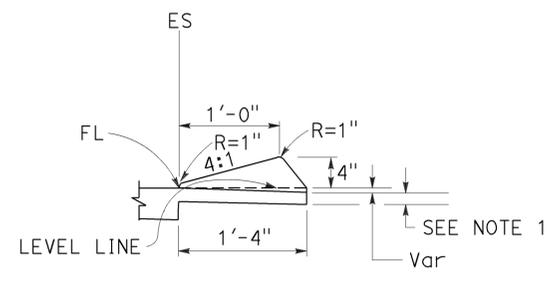


**TYPE E**

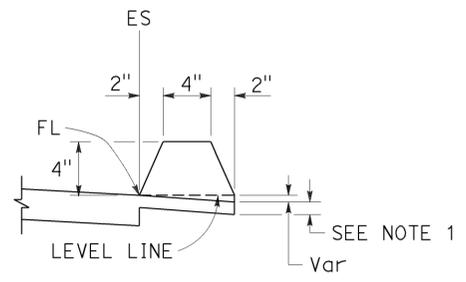


**TYPE F**  
See Note 5


**DIKES**

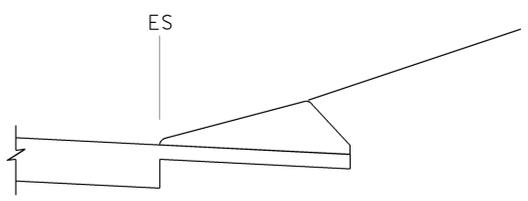


**CASE C-1**  
Cut Slope

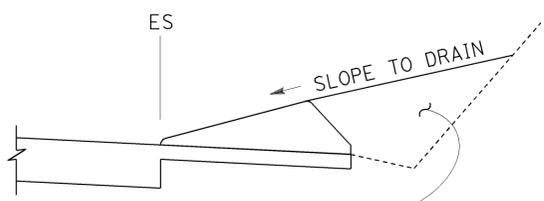

**CASE C-2**  
Cut Slope

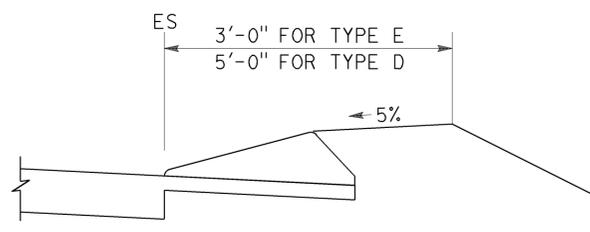

**CASE F**

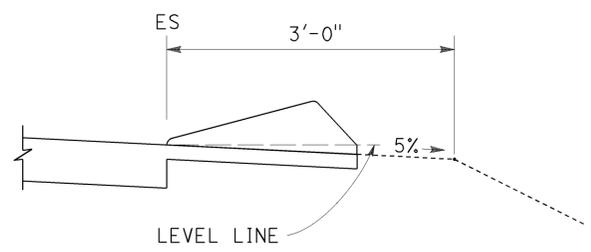

**CASE R**  
See Note 2

**TYPE D AND E BACKFILL DETAILS**

**NOTES:**

- For HMA shoulders only, extend top layer of HMA placed on the shoulder under dike with no joint at the ES. For projects with OGFC shoulders, do not extend OGFC under dike. See project plans for modified dike detail.
- Case R applies to retrofit only projects where restrictive conditions do not provide enough width for Case F backfill.
- Type A dike only to be used where restrictive slope conditions do not provide enough width to use Type D or Type E dike.
- Fill and compact with excavated material to top of dike.
- Use Type F dike, where dike is required with guard railing installations. See Revised Standard Plan RSP A77N4 for dike positioning details.

**DIKE QUANTITIES**

TYPE	CUBIC YARDS PER LINEAR FOOT
A	0.0135
C	0.0038
D	0.0293
E	0.0130
F	0.0066

Quantities based on 5% cross slope.

STATE OF CALIFORNIA  
DEPARTMENT OF TRANSPORTATION

**HOT MIX ASPHALT DIKES**


NO SCALE

RSP A87B DATED JULY 19, 2013 SUPERSEDES STANDARD PLAN A87B DATED MAY 20, 2011 - PAGE 120 OF THE STANDARD PLANS BOOK DATED 2010.


**REVISED STANDARD PLAN RSP A87B**

2010 REVISED STANDARD PLAN RSP A87B





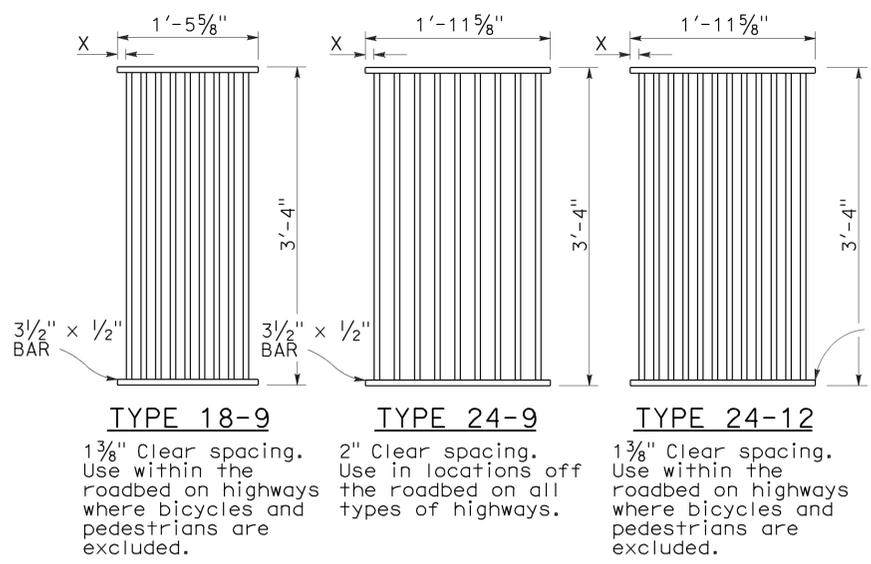




**RECTANGULAR GRATE DETAILS**  
(See table below)

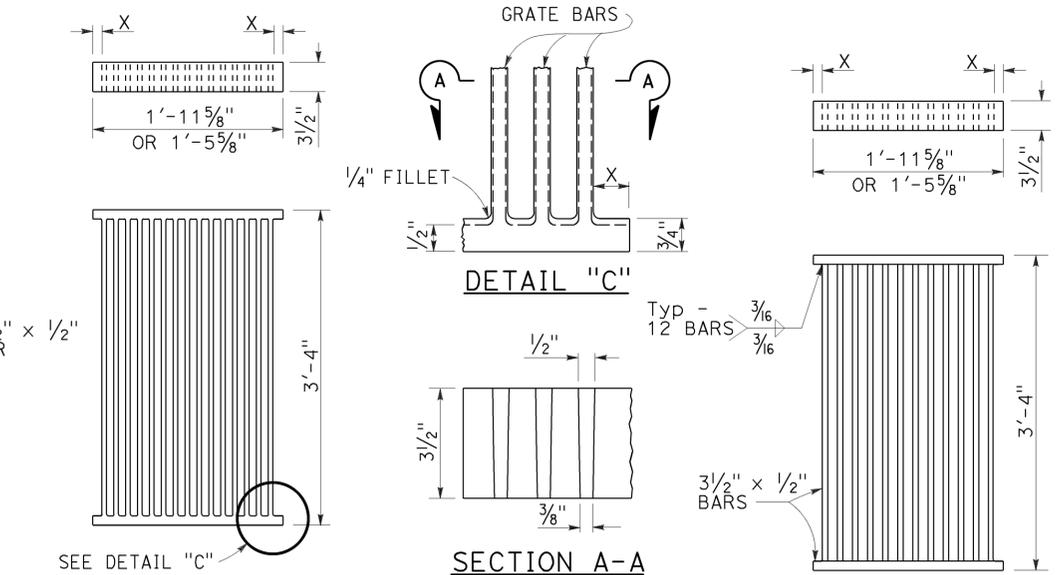


**ALTERNATIVE CAST DUCTILE IRON GRATE OR CAST CARBON STEEL GRATE**  
**ALTERNATIVE WELDED GRATE**

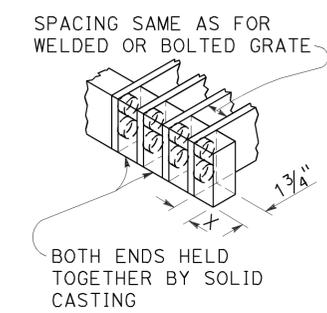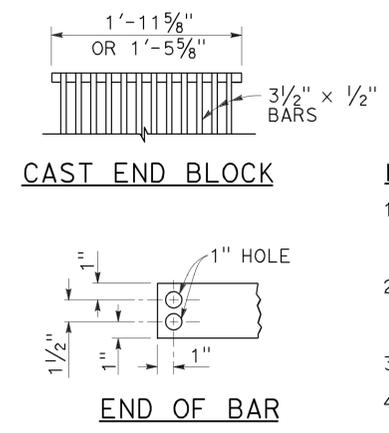

**ALTERNATIVE CAST DUCTILE IRON OR CAST CARBON STEEL END BLOCK GRATE**

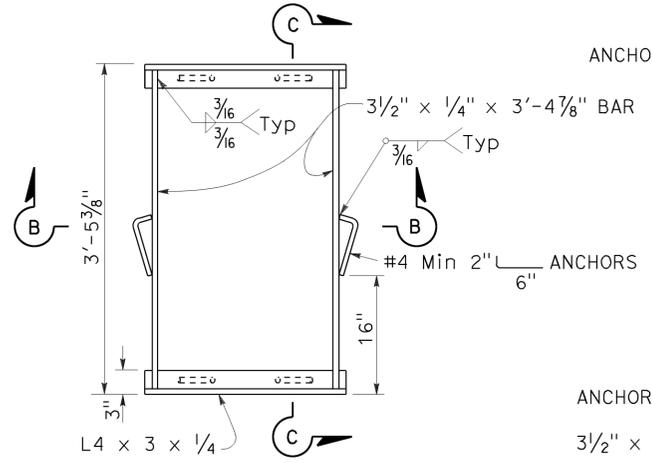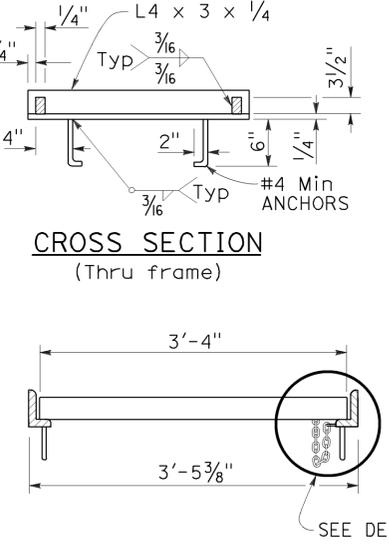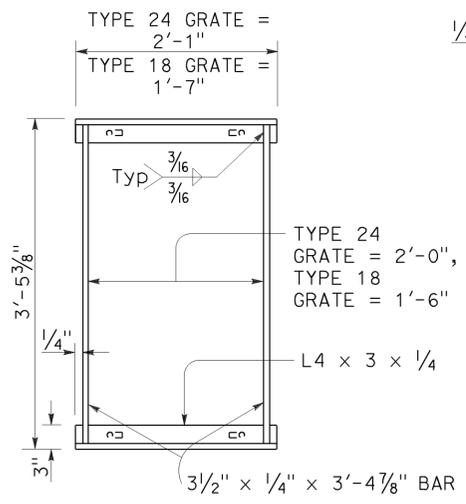

**TYPICAL FRAME**  
**ALTERNATIVE ANCHOR FOR RECTANGULAR FRAME**  
(For details not shown, See Rectangular Frame Details)

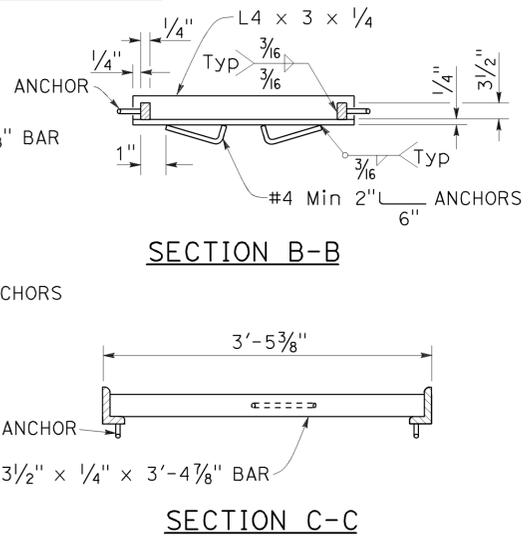

**SECTION B-B**  
**SECTION C-C**


**RECTANGULAR FRAME DETAILS**  
(For all rectangular grates)

**GRATE BAR SPACING TABLE**


TYPE	NO. OF BARS	CLEAR BAR SPACING	X
18-9	9	1 3/8"	1 1/16"
24-9	9	2"	1 9/16"
24-12	12	1 3/8"	1 1/4"

INLET TYPE	COVER TYPE	WEIGHT LB
OS	PLATE	174
OL-7	PLATE	170
OL-10	PLATE	170
OL-14	PLATE	170
OL-21	PLATE	170
OCPI	PLATE	112
OCPI	PLATE	112
OCPI	REDWOOD	42
OMP	PLATE	177
OMPI	PLATE	177


INLET TYPE	GRATE TYPE	NO. OF GRATES	WEIGHT LB
GDO	24-12	2	634
GOL-7	24-12	1	326
GOL-10	24-12	1	326
G0,G1,G2,G3,G4 (TYPE 24)	24-9	1	263
	24-12	1	326
G4 (TYPE 18),G5,G6	18-9	1	249
GT1	18-9	2	498
GT2	18-9	2	498
GT3	24-12	2	652
GT4	24-12	2	652
TRASH RACK			22
GRATE CHAIN			3

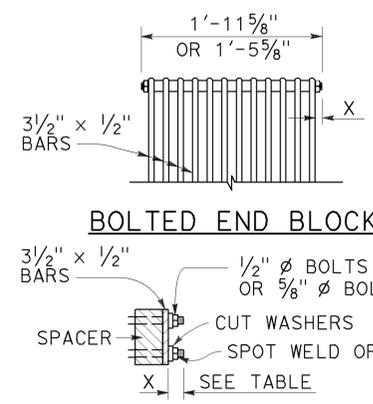

**BOLTED END BLOCK**  
**BOLTING DETAIL**  
**ALTERNATIVE BOLTED GRATE**

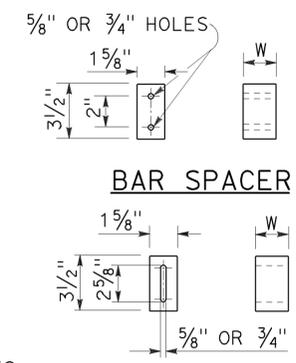

**ALTERNATIVE SPACER**  
W = 1 3/8" or 2"

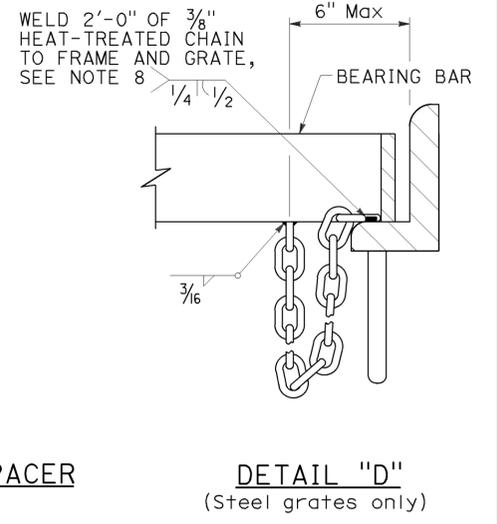

**DETAIL "D"**  
(Steel grates only)

**GRATE DETAILS No. 1**  
NO SCALE

**BASIS FOR MISC IRON & STEEL FINAL PAY WEIGHTS FOR DRAINAGE INLETS**  
(See Note 7)

RSP D77A DATED APRIL 19, 2013 SUPERSEDES RSP D77A DATED JULY 20, 2012 AND STANDARD PLAN D77A DATED MAY 20, 2011 - PAGE 164 OF THE STANDARD PLANS BOOK DATED 2010.

**REVISED STANDARD PLAN RSP D77A**


2010 REVISED STANDARD PLAN RSP D77A

Dist	COUNTY	ROUTE	POST MILES TOTAL PROJECT	SHEET No.	TOTAL SHEETS
11	SD	8,54,67,94, 125, etc.	Var	207	231


William K. Farnbach  
 REGISTERED CIVIL ENGINEER  
 October 30, 2015  
 PLANS APPROVAL DATE  
 THE STATE OF CALIFORNIA OR ITS OFFICERS OR AGENTS SHALL NOT BE RESPONSIBLE FOR THE ACCURACY OR COMPLETENESS OF SCANNED COPIES OF THIS PLAN SHEET.

REGISTERED PROFESSIONAL ENGINEER  
 William K. Farnbach  
 No. C49042  
 Exp. 9-30-16  
 STATE OF CALIFORNIA


TO ACCOMPANY PLANS DATED 01-11-16

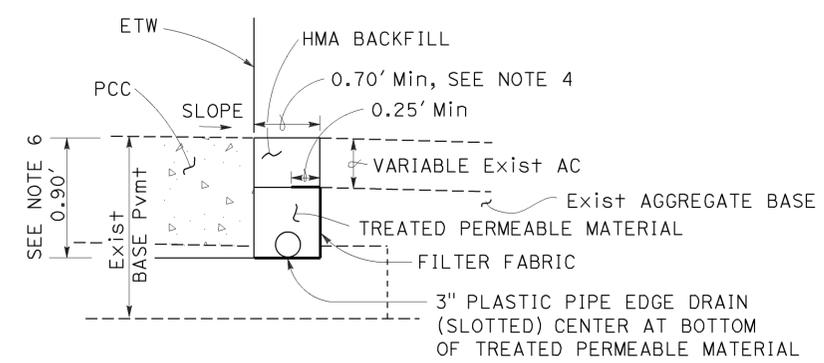


**TYPE 1 PAVEMENT STRUCTURE DRAINAGE SYSTEM**  
(For existing highway facility)

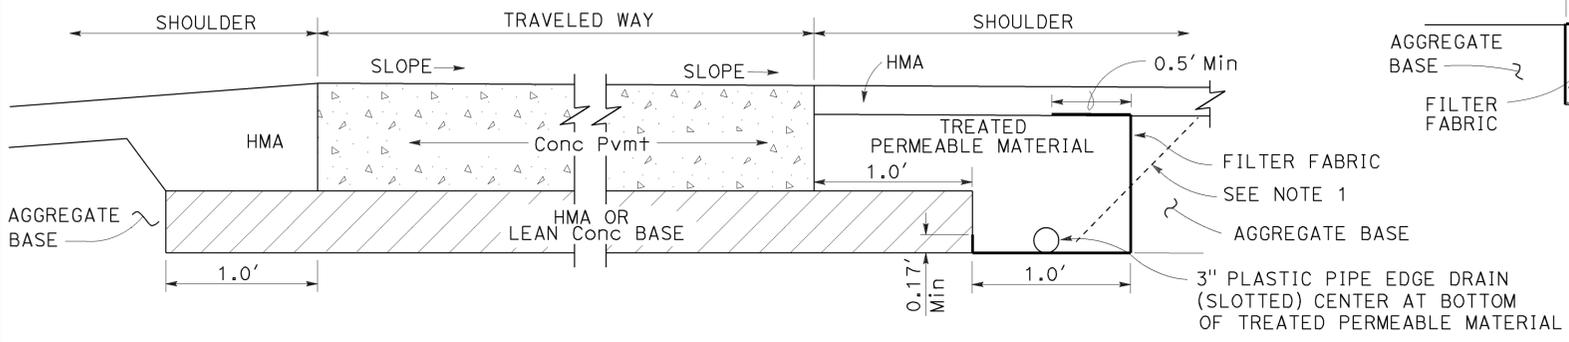


**TYPE 2 PAVEMENT STRUCTURE DRAINAGE SYSTEM**  
(New construction)

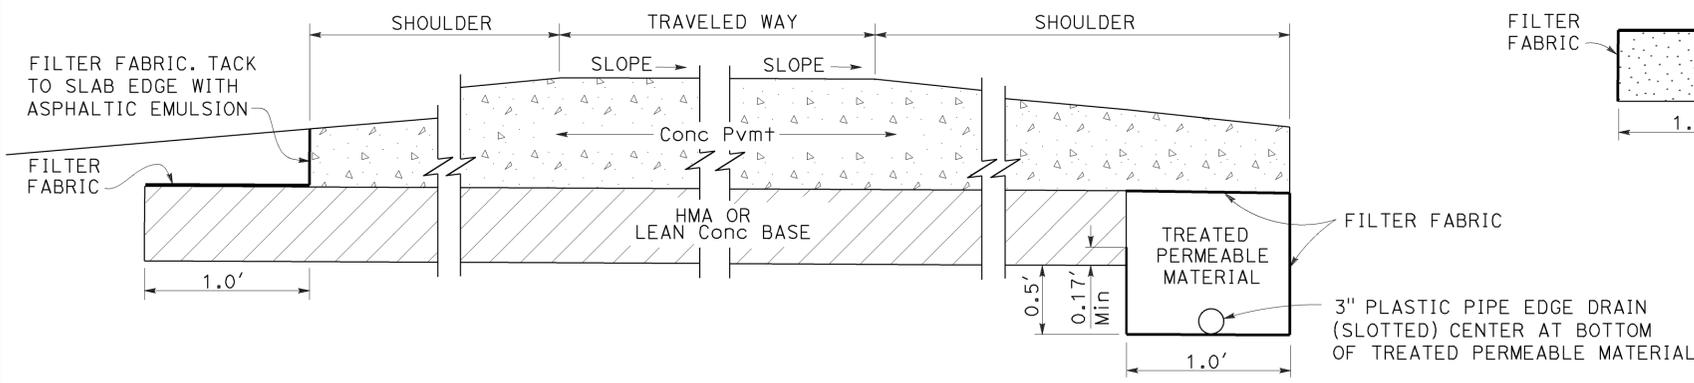


**TYPE 3 PAVEMENT STRUCTURE DRAINAGE SYSTEM**  
(New construction)

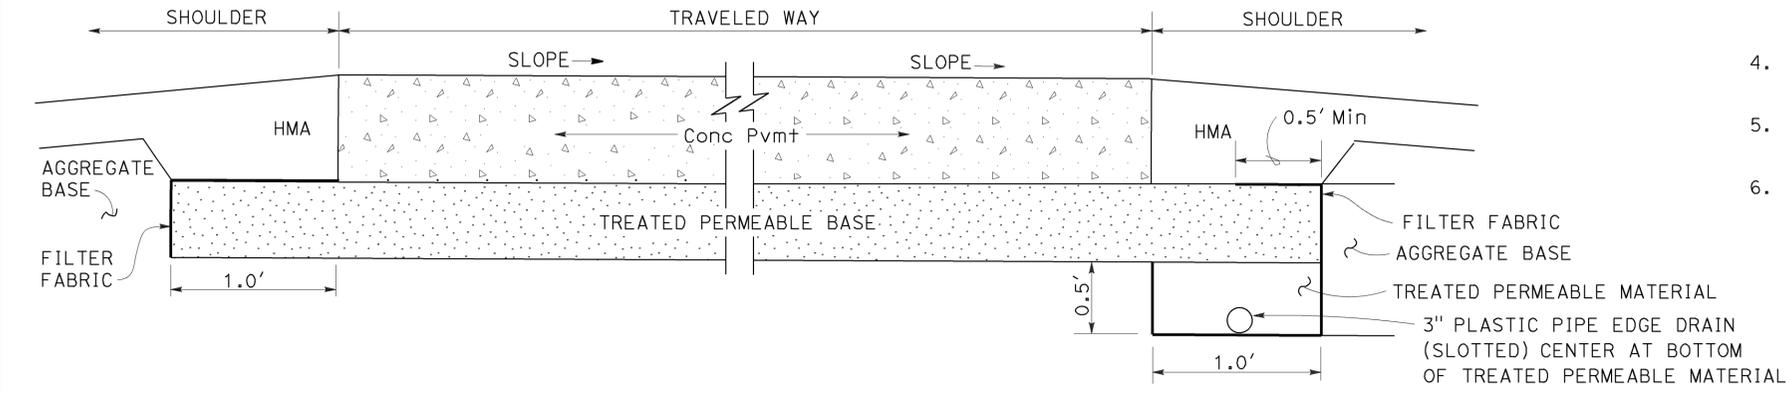

**TYPE 4 PAVEMENT STRUCTURE DRAINAGE SYSTEM**  
(New construction)

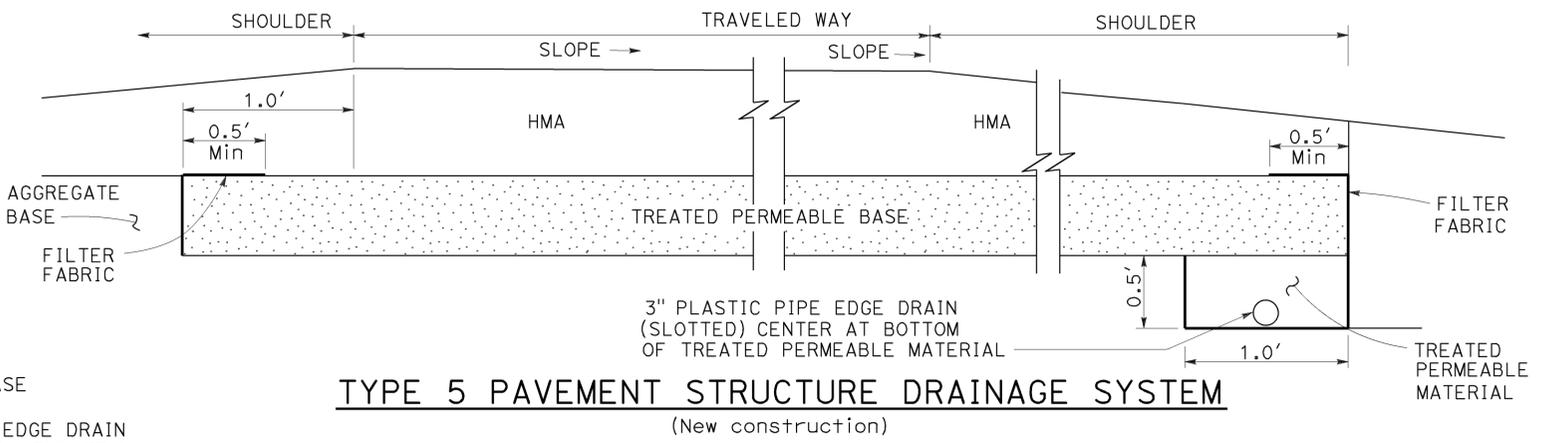

**TYPE 5 PAVEMENT STRUCTURE DRAINAGE SYSTEM**  
(New construction)

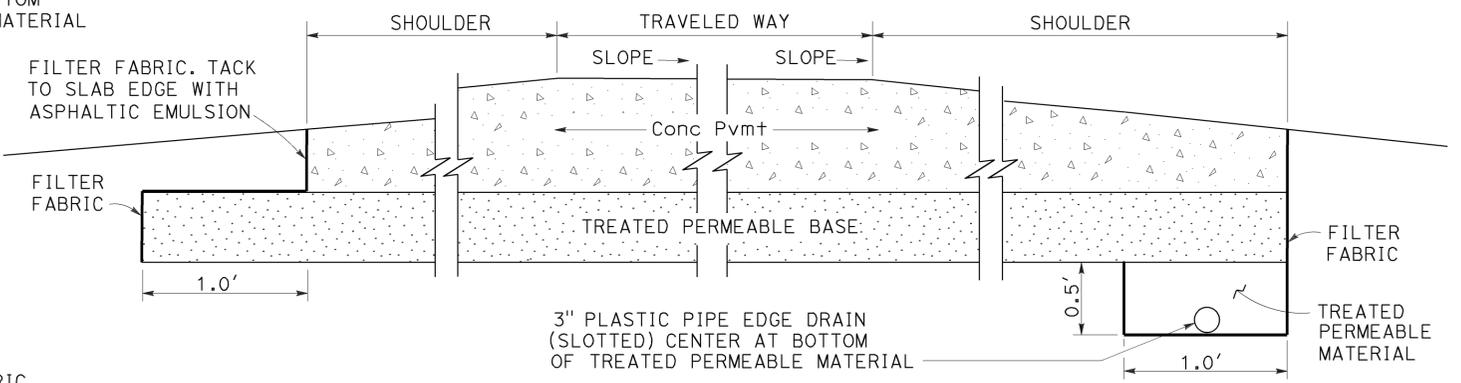

**TYPE 6 PAVEMENT STRUCTURE DRAINAGE SYSTEM**  
(New construction)

**NOTES:**

1. At the Contractor's option, on new construction, the vertical jointline (including the filter fabric) between the treated permeable material and the shoulder base/subgrade material may be rotated about its midpoint to a slope not flatter than 1:1 as shown by the dashed lines.
2. See the project plans and typical cross sections for pavement structure details.
3. The plan layout for pavement structure drainage collector and outlet systems for new concrete pavement and new hot mix asphalt pavement is the same as that shown on Revised Standard Plan RSP D99B.
4. For plastic pipe edge drain diameter larger than 3", the minimum trench width shall be equal to the outside diameter of the plastic pipe plus 4".
5. For plastic pipe edge drain diameters larger than 3", all details for 3" plastic pipe edge drain shall apply.
6. For pavements thicker than 0.75', the minimum trench depth is 1.0'.

STATE OF CALIFORNIA  
DEPARTMENT OF TRANSPORTATION

**PAVEMENT STRUCTURE DRAINAGE SYSTEM DETAILS**  
NO SCALE

RSP D99A DATED OCTOBER 30, 2015 SUPERSEDES STANDARD PLAN D99A DATED MAY 20, 2011 - PAGE 211 OF THE STANDARD PLANS BOOK DATED 2010.


**REVISED STANDARD PLAN RSP D99A**

2010 REVISED STANDARD PLAN RSP D99A


Dist	COUNTY	ROUTE	POST MILES TOTAL PROJECT	SHEET No.	TOTAL SHEETS
11	SD	8,54,67,94, 125, etc.	Var	208	231

William K. Farnbach  
 REGISTERED CIVIL ENGINEER  
 October 30, 2015  
 PLANS APPROVAL DATE  
 THE STATE OF CALIFORNIA OR ITS OFFICERS OR AGENTS SHALL NOT BE RESPONSIBLE FOR THE ACCURACY OR COMPLETENESS OF SCANNED COPIES OF THIS PLAN SHEET.


2010 REVISED STANDARD PLAN RSP D99B

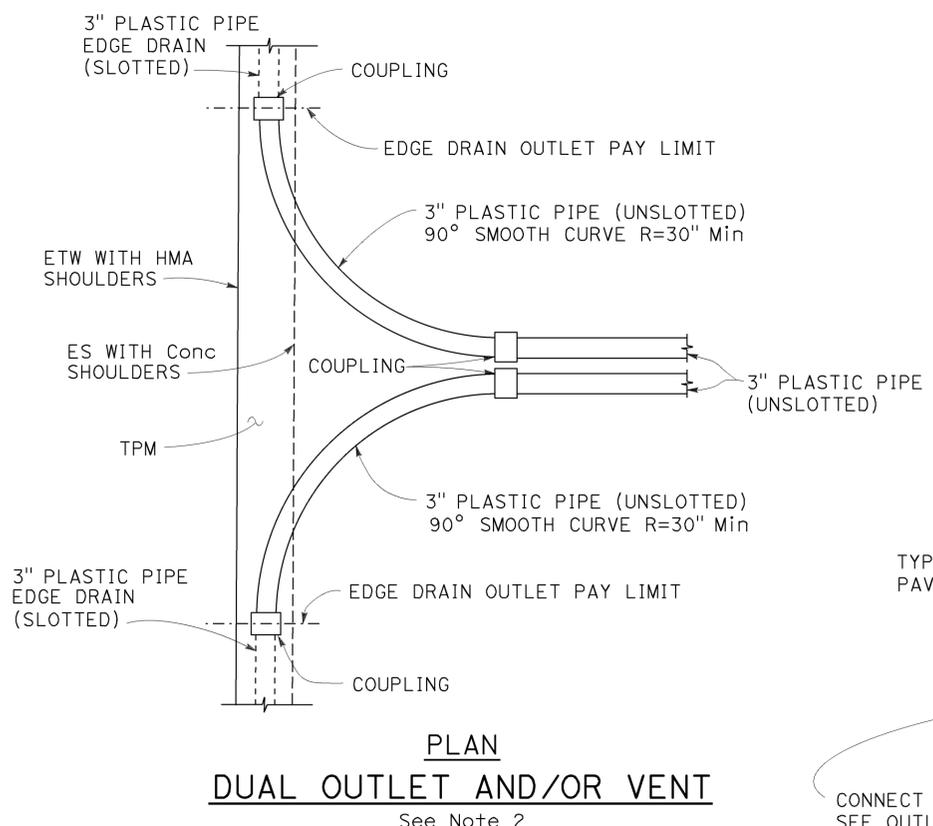


**PLAN**  
**DUAL OUTLET AND/OR VENT**  
See Note 2

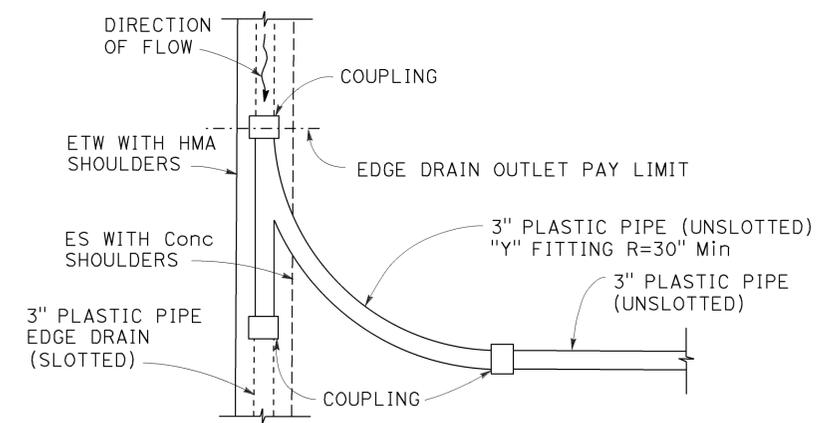


**PLAN**  
**INTERMEDIATE OUTLET**  
See Note 2

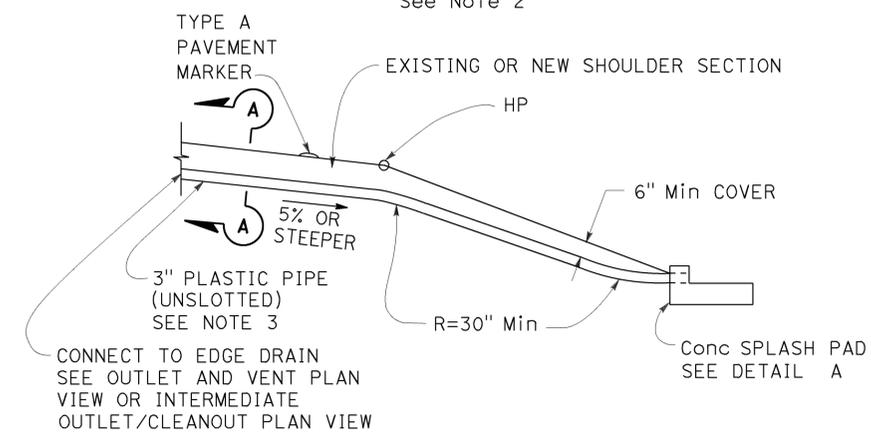


**ELEVATION**  
**TYPE A OUTLET**

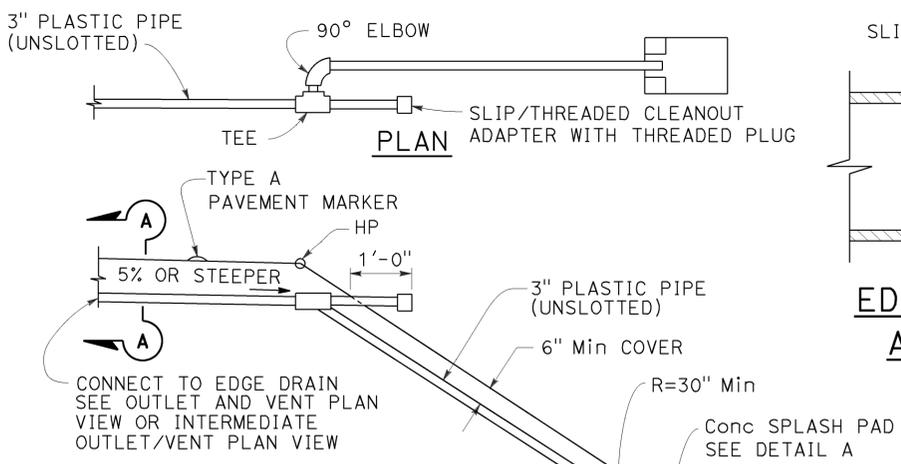


**ELEVATION**  
**TYPE B OUTLET**

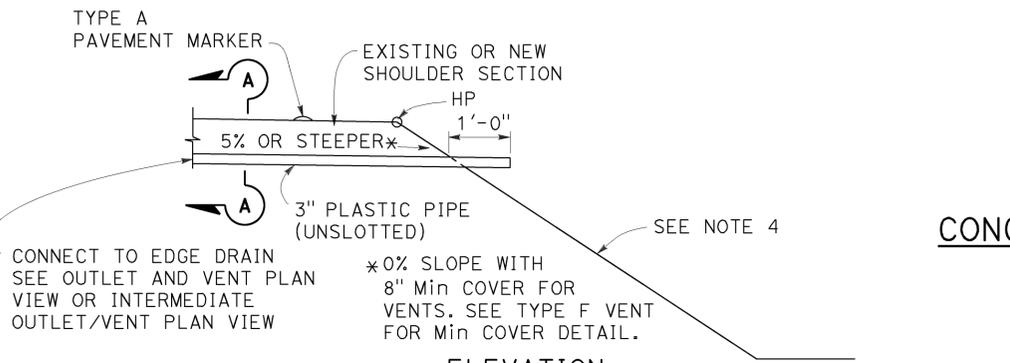


**ELEVATION**  
**TYPE C OUTLET AND/OR VENT**

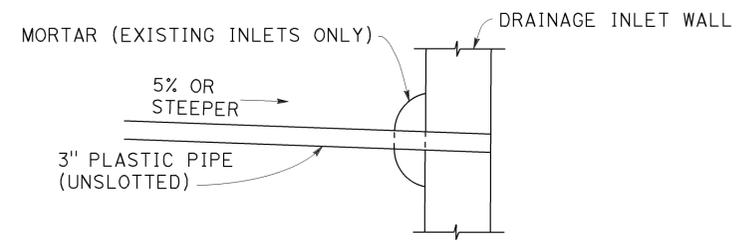


**ELEVATION**  
**TYPE D OUTLET CONNECTION TO DRAINAGE INLET**

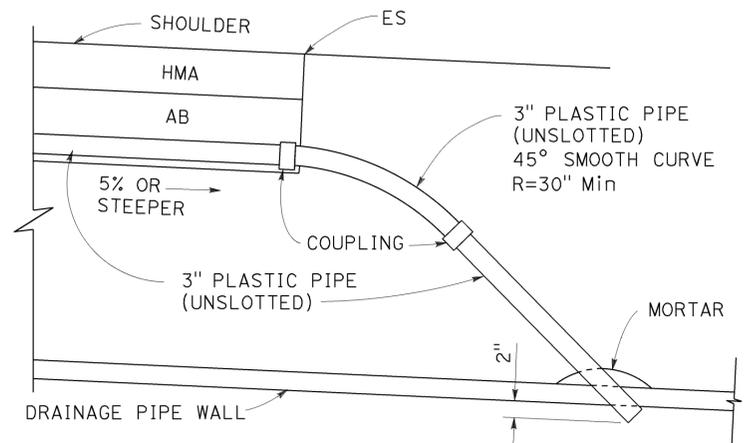


**ELEVATION**  
**TYPE E OUTLET CONNECTION TO DRAINAGE PIPE**

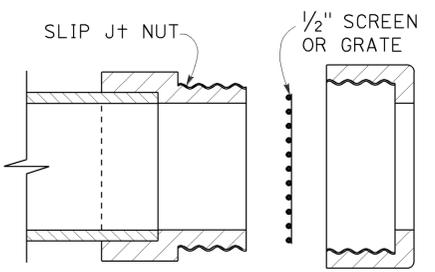


**EDGE DRAIN OUTLET AND VENT COVER**

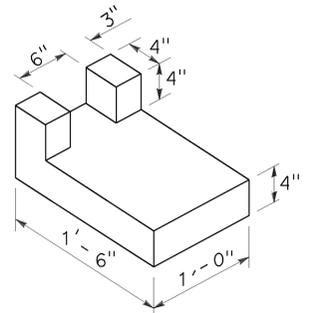

**DETAIL A**  
**CONCRETE SPLASH PAD**

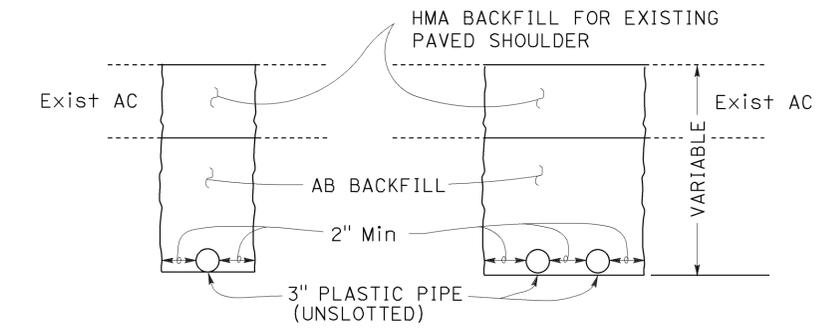

**SECTION A-A**  
**OUTLET EXCAVATION AND BACKFILL IN PAVED SHOULDERS**  
See Note 5

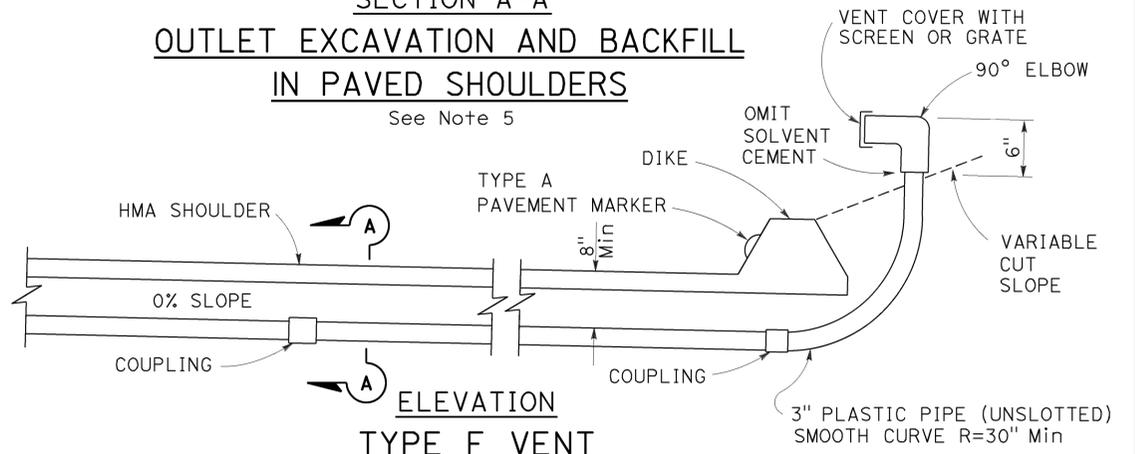

**ELEVATION**  
**TYPE F VENT**

**NOTES:**

1. See project plans for location and type of outlet and/or vent installations.
2. The position of slotted plastic pipe and limits of treated permeable material shown are for the Type 1 pavement structure drainage system shown on Revised Standard Plan RSP D99A.
3. The maximum length of plastic pipe outlet shall be 50'-0" measured from the longitudinal centerline of the collector trench to the pipe outlet. For pipe lengths greater than 50'-0" use Type B outlets.
4. See project plans for slope protection details at Type C pipe outlets.
5. Backfill with aggregate base from outside edge paved shoulder to hinge point and backfill with native material in slope area.
6. See Revised Standard Plan RSP D99C for Type G vent detail used with concrete shoulders.

TO ACCOMPANY PLANS DATED 01-11-16

STATE OF CALIFORNIA  
DEPARTMENT OF TRANSPORTATION  
**EDGE DRAIN OUTLET AND VENT DETAILS**  
NO SCALE




RSP D99B DATED OCTOBER 30, 2015 SUPERSEDES STANDARD PLAN D99B DATED MAY 20, 2011 - PAGE 212 OF THE STANDARD PLANS BOOK DATED 2010.

**REVISED STANDARD PLAN RSP D99B**


Dist	COUNTY	ROUTE	POST MILES TOTAL PROJECT	SHEET No.	TOTAL SHEETS
11	SD	8,54,67,94, 125, etc.	Var	209	231

William K. Farnbach  
 REGISTERED CIVIL ENGINEER  
 October 30, 2015  
 PLANS APPROVAL DATE  
 THE STATE OF CALIFORNIA OR ITS OFFICERS OR AGENTS SHALL NOT BE RESPONSIBLE FOR THE ACCURACY OR COMPLETENESS OF SCANNED COPIES OF THIS PLAN SHEET.




REGISTERED PROFESSIONAL ENGINEER  
 William K. Farnbach  
 No. C49042  
 Exp. 9-30-16  
 CIVIL  
 STATE OF CALIFORNIA

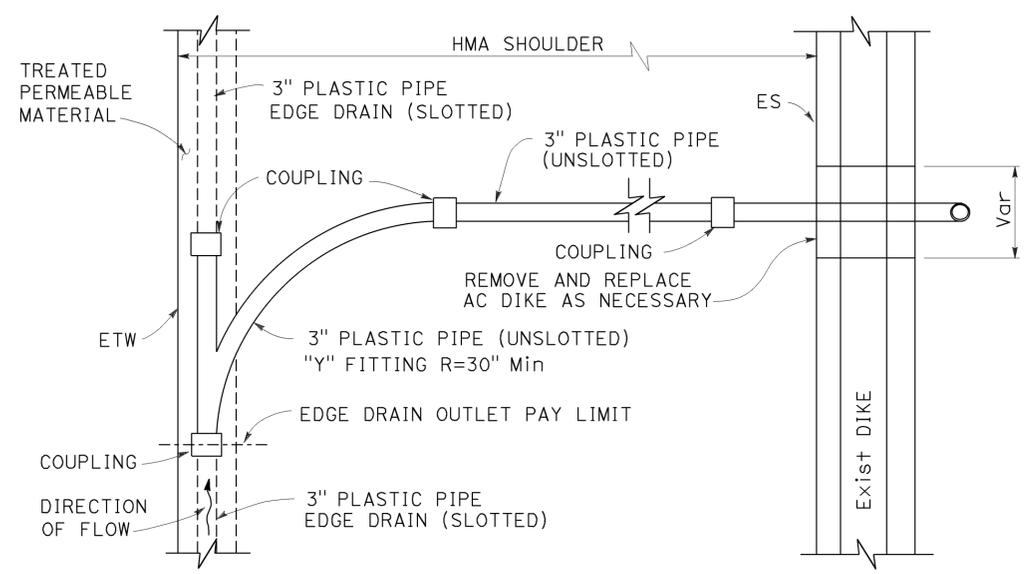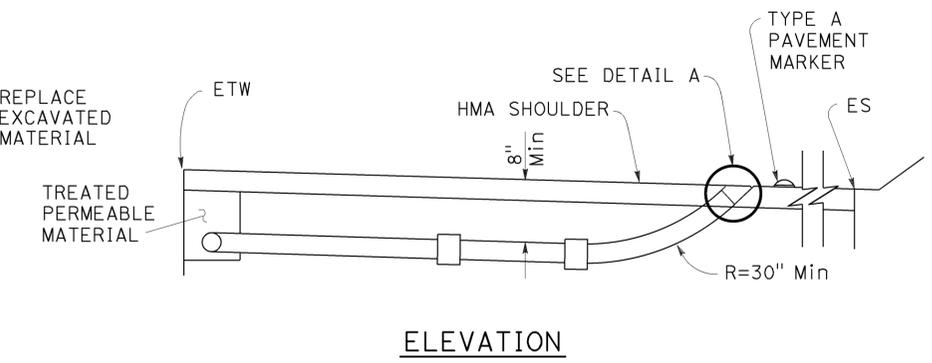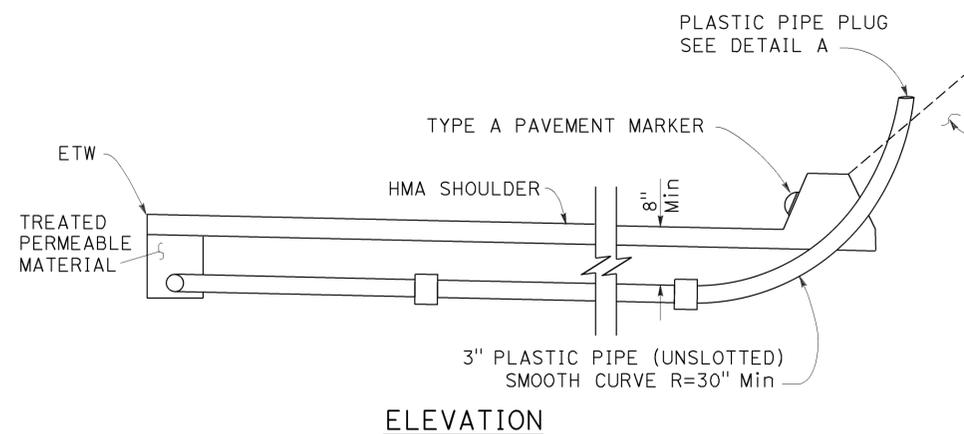


**TYPE 1 CLEANOUT**  
See Note 2

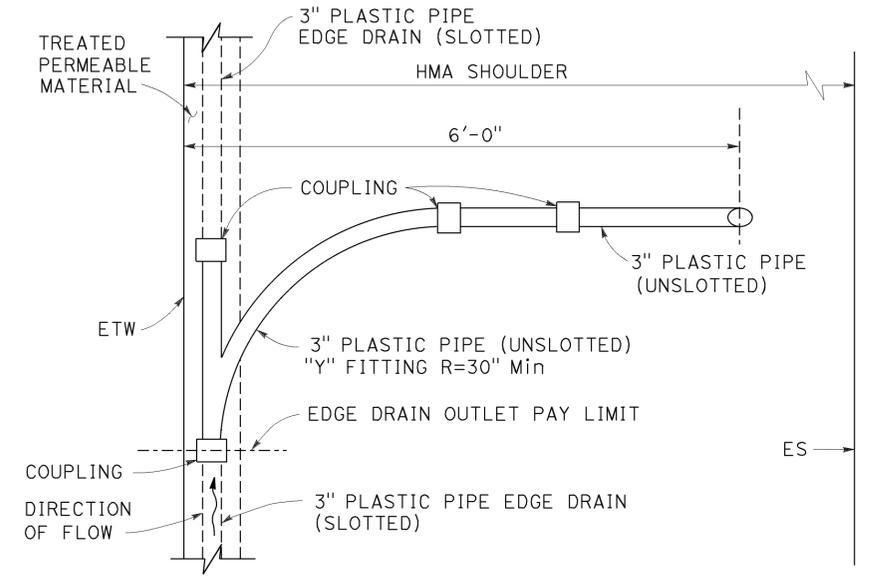

**TYPE 2 CLEANOUT**  
See Note 2

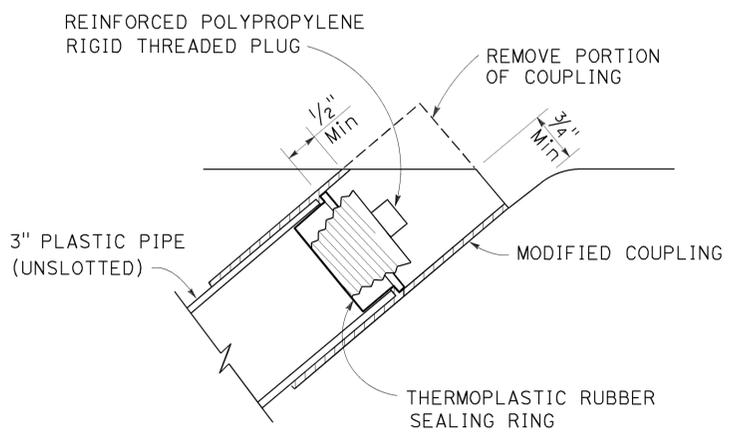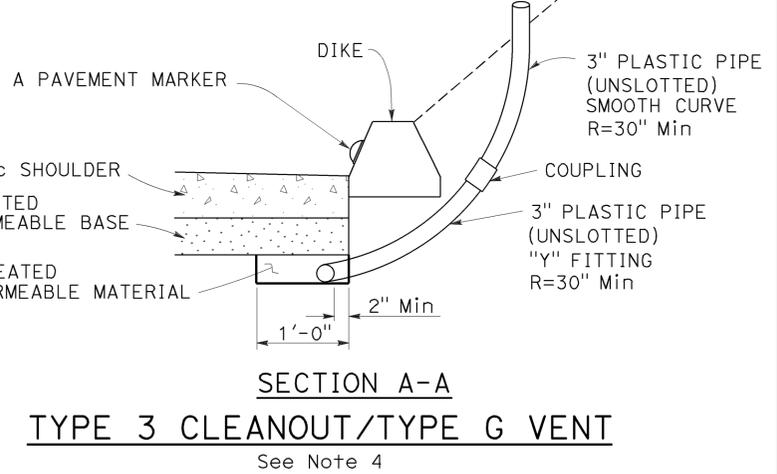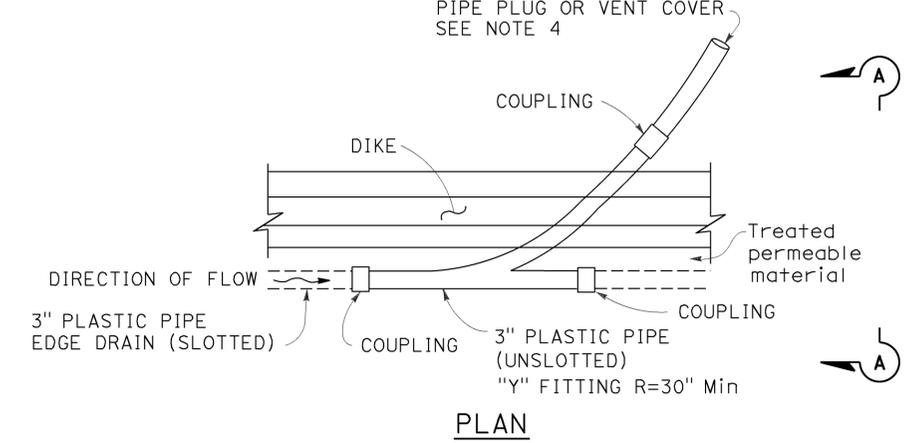

**DETAIL A**  
**PLASTIC PIPE PLUG**  
See Note 3

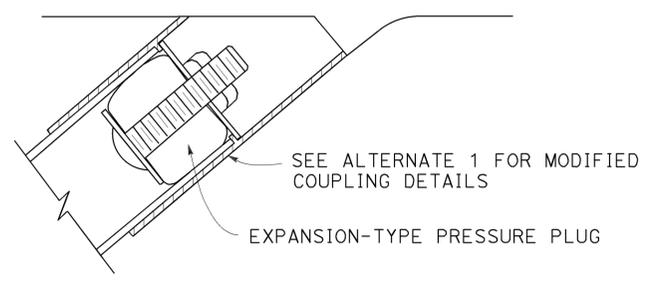

**NOTES:**

1. See project plans for location and type of cleanout or vent installations.
2. The position of slotted plastic pipe and limits of treated permeable material shown are for the Type 1 structural section drainage system shown on Revised Standard Plan RSP D99A.
3. Other types of plugs may be substituted with the Engineer's approval.
4. The Type 3 cleanout and Type G vent is for use with concrete shoulders. The Type 6 structural section drainage system from Revised Standard Plan RSP D99A is shown. Use plastic pipe plug shown in Detail A with Type 3 cleanouts. Use vent cover shown on Revised Standard Plan RSP D99B with Type G vents.

STATE OF CALIFORNIA  
DEPARTMENT OF TRANSPORTATION  
**EDGE DRAIN CLEANOUT AND VENT DETAILS**  
NO SCALE


RSP D99C DATED OCTOBER 30, 2015 SUPERSEDES STANDARD PLAN D99C DATED MAY 20, 2011 - PAGE 213 OF THE STANDARD PLANS BOOK DATED 2010.

**REVISED STANDARD PLAN RSP D99C**

2010 REVISED STANDARD PLAN RSP D99C

Dist	COUNTY	ROUTE	POST MILES TOTAL PROJECT	SHEET No.	TOTAL SHEETS
11	SD	8,54,67,94, 125, etc.	Var	210	231

  
 LICENSED LANDSCAPE ARCHITECT  
 July 19, 2013  
 PLANS APPROVAL DATE  
THE STATE OF CALIFORNIA OR ITS OFFICERS OR AGENTS SHALL NOT BE RESPONSIBLE FOR THE ACCURACY OR COMPLETENESS OF SCANNED COPIES OF THIS PLAN SHEET.

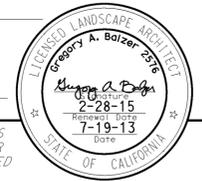

TO ACCOMPANY PLANS DATED 01-11-16

**A**

AB AGGREGATE BASE  
 ABS ACRYLONITRILE-BUTADIENE-STYRENE  
 AC ASPHALT CONCRETE  
 ACC ARMOR-CLAD CONDUCTORS  
 Adj ADJACENT/ADJUSTABLE  
 AIC AUXILIARY IRRIGATION CONTROLLER  
 Alt ALTERNATIVE  
 AMEND AMENDMENT  
 ARV AIR RELEASE VALVE  
 AUTO AUTOMATIC  
 AUX AUXILIARY  
 AVB ATMOSPHERIC VACUUM BREAKER

**B**

B&B BALLED AND BURLAPPED  
 B/B BRASS/BRONZE  
 B/B/PL BRASS/BRONZE/PLASTIC  
 B/PL BRASS/PLASTIC  
 BFM BONDED FIBER MATRIX  
 Bit Ctd BITUMINOUS COATED  
 BP BOOSTER PUMP  
 BPA BACKFLOW PREVENTER ASSEMBLY  
 BPE BACKFLOW PREVENTER ENCLOSURE  
 BV BALL VALVE

**C**

C CONDUIT  
 CAP CORRUGATED ALUMINUM PIPE  
 CARV COMBINATION AIR RELEASE VALVE  
 CB COUPLING BAND  
 CCA CAM COUPLER ASSEMBLY  
 CEC CONTROLLER ENCLOSURE CABINET  
 CHDPE CORRUGATED HIGH DENSITY POLYETHYLENE  
 CL CHAIN LINK  
 CNC CONTROL AND NEUTRAL CONDUCTORS  
 Conc CONCRETE  
 CP COPPER PIPE  
 CS COMPOST SOCK  
 CSP CORRUGATED STEEL PIPE  
 CST CENTER STRIP  
 CV CHECK VALVE

**D**

Dia DIAMETER  
 DIP DUCTILE IRON PIPE  
 DIT DRIP IRRIGATION TUBING  
 DG DECOMPOSED GRANITE  
 DN DIAMETER NOMINAL  
 DVA DRIP VALVE ASSEMBLY

**E**

EC EROSION CONTROL  
 ECTC EROSION CONTROL TECHNOLOGY COUNCIL  
 Elect ELECTRIC/ELECTRICAL  
 Elev ELEVATION  
 ELL ELBOW  
 ENCL ENCLOSURE  
 EP EDGE OF PAVEMENT  
 ES EDGE OF SHOULDER  
 EST END STRIP  
 ESTB ESTABLISHMENT  
 ETW EDGE OF TRAVELED WAY

**F**

F FULL CIRCLE  
 F/P FULL/PART CIRCLE  
 FCV FLOW CONTROL VALVE  
 FERT FERTILIZER  
 FG FINISHED GRADE  
 FH FLEXIBLE HOSE  
 FIPT FEMALE IRON PIPE THREAD  
 FIS FERTILIZER INJECTOR SYSTEM  
 FL FLOW LINE  
 FR FIBER ROLL  
 FS FLOW SENSOR  
 FSC FLOW SENSOR CABLE  
 FV FLUSH VALVE

**G**

Galv GALVANIZED  
 GARV GARDEN VALVE  
 GARVA GARDEN VALVE ASSEMBLY  
 GM GRAVEL MULCH  
 GPH GALLONS PER HOUR  
 GPM GALLONS PER MINUTE  
 GSP GALVANIZED STEEL PIPE  
 GV GATE VALVE

**H**

H HALF CIRCLE  
 HDPE HIGH DENSITY POLYETHYLENE  
 HP HORSEPOWER/HINGE POINT  
 HPL HIGH PRESSURE LINE  
 Hwy HIGHWAY

**I**

IC IRRIGATION CONTROLLER  
 ICC IRRIGATION CONTROLLER(S) IN CONTROLLER ENCLOSURE CABINET  
 ID INSIDE DIAMETER  
 IFS IRRIGATION FILTRATION SYSTEM  
 IPS IRON PIPE SIZE  
 IPT IRON PIPE THREAD  
 Irr IRRIGATION

**L**

L LENGTH

**M**

Max MAXIMUM  
 MBGR METAL BEAM GUARD RAILING  
 MCV MANUAL CONTROL VALVE  
 MIC MASTER IRRIGATION CONTROLLER  
 Min MINIMUM  
 MIPT MALE IRON PIPE THREAD  
 Misc MISCELLANEOUS  
 MtI MATERIAL  
 MVP MAINTENANCE VEHICLE PULLOUT

**N**

NCN NO COMMON NAME  
 NL NOZZLE LINE  
 No. NUMBER  
 NPT NATIONAL PIPE THREAD

**O**

O/C ON CENTER  
 OD OUTSIDE DIAMETER  
 OL OVERLAP

**P**

P PART CIRCLE  
 PB PULL BOX  
 PCC PORTLAND CEMENT CONCRETE  
 PE POLYETHYLENE  
 Pkt+ PACKET  
 PL PLASTIC  
 PLS PURE LIVE SEED  
 PLT PLANT/PLANTING  
 PLT ESTB PLANT ESTABLISHMENT  
 PM POST MILE  
 PR PRESSURE RATED  
 PRLV PRESSURE RELIEF VALVE  
 PRV PRESSURE REGULATING VALVE  
 PVC POLYVINYL CHLORIDE  
 Pvm+ PAVEMENT

**Q**

Q QUARTER CIRCLE  
 QCV QUICK COUPLING VALVE

**NOTE:**  
 For additional abbreviations, see Standard Plans A10A and A10B.

**R**

R RADIUS  
 RCP REINFORCED CONCRETE PIPE  
 RCV REMOTE CONTROL VALVE  
 RCVM REMOTE CONTROL VALVE (MASTER)  
 RCVMF REMOTE CONTROL VALVE (MASTER) W/FLOW SENSOR  
 RCVP REMOTE CONTROL VALVE W/PRESSURE REGULATOR  
 RCW RECYCLED WATER  
 RECP ROLLED EROSION CONTROL PRODUCT  
 REQ REQUIRED  
 RICS REMOTE IRRIGATION CONTROL SYSTEM  
 R/W RIGHT OF WAY

**S**

S SLIP  
 SCH SCHEDULE  
 SF STATE-FURNISHED  
 Shld SHOULDER  
 Sq SQUARE  
 SST SIDE STRIP  
 Sta STATION  
 Std STANDARD  
 SW SIDEWALK/SOUND WALL

**T**

T THIRD CIRCLE/THREAD  
 TLS TRUCK LOADING STANDPIPE  
 TQ THREE QUARTER CIRCLE  
 TRM TURF REINFORCEMENT MAT  
 TT TWO-THIRDS CIRCLE  
 TWSA TREE WELL SPRINKLER ASSEMBLY  
 Typ TYPICAL

**U**

UG UNDERGROUND

**W**

W WIDTH  
 W/ WITH  
 WM WATER METER  
 WS WYE STRAINER  
 WSA WYE STRAINER ASSEMBLY  
 WSP WELDED STEEL PIPE  
 WWM WELDED WIRE MESH

STATE OF CALIFORNIA  
 DEPARTMENT OF TRANSPORTATION  
**LANDSCAPE AND EROSION CONTROL ABBREVIATIONS**  
 NO SCALE

RSP H1 DATED JULY 19, 2013 SUPERSEDES STANDARD PLAN H1 DATED MAY 20, 2011 - PAGE 218 OF THE STANDARD PLANS BOOK DATED 2010.

**REVISED STANDARD PLAN RSP H1**

2010 REVISED STANDARD PLAN RSP H1

Dist	COUNTY	ROUTE	POST MILES TOTAL PROJECT	SHEET No.	TOTAL SHEETS
11	SD	8,54,67,94, 125, etc.	Var	211	231

*Gregory A. Balzer*  
LICENSED LANDSCAPE ARCHITECT

November 15, 2013  
PLANS APPROVAL DATE


THE STATE OF CALIFORNIA OR ITS OFFICERS OR AGENTS SHALL NOT BE RESPONSIBLE FOR THE ACCURACY OR COMPLETENESS OF SCANNED COPIES OF THIS PLAN SHEET.

TO ACCOMPANY PLANS DATED 01-11-16

2010 REVISED STANDARD PLAN RSP H2

EXISTING	NEW	ITEM DESCRIPTION
		WATER METER (WM)
		BACKFLOW PREVENTER ASSEMBLY (BPA)
		BACKFLOW PREVENTER ENCLOSURE (BPE)
		BOOSTER PUMP (BP)
		TRUCK LOADING STANDPIPE (TLS)
		FLOW SENSOR (FS)
		MASTER IRRIGATION CONTROLLER (MIC)
		AUXILIARY IRRIGATION CONTROLLER (AIC)
		IRRIGATION CONTROLLER (IC) IRRIGATION CONTROLLER (IC) (BATTERY) IRRIGATION CONTROLLER (IC) (SOLAR) IRRIGATION CONTROLLER (IC) (TWO WIRE) IRRIGATION CONTROLLER(S) IN CONTROLLER ENCLOSURE CABINET (ICC)
		ARMOR-CLAD CONDUCTORS (ACC)
		CONTROL AND NEUTRAL CONDUCTORS (CNC)
		IRRIGATION CONDUIT
		EXTEND IRRIGATION CONDUIT
		DUCTILE IRON PIPE (SUPPLY LINE) (MAIN) (DIP)
		GALVANIZED STEEL PIPE (SUPPLY LINE) (MAIN) (GSP)
		GALVANIZED STEEL PIPE (SUPPLY LINE) (LATERAL) (GSP)
		PLASTIC PIPE (SUPPLY LINE) (MAIN)
		PLASTIC PIPE (SUPPLY LINE) (LATERAL)
		COPPER PIPE (SUPPLY LINE)
		DRIP IRRIGATION TUBING
		REMOTE CONTROL VALVE (RCV) REMOTE CONTROL VALVE (MASTER) (RCVM) REMOTE CONTROL VALVE (MASTER) W/FLOW METER (RCVMF)
		REMOTE CONTROL VALVE W/PRESSURE REGULATOR (RCVP)
		EXISTING MANUAL CONTROL VALVE (MCV)
		DRIP VALVE ASSEMBLY (DVA)
		WYE STRAINER ASSEMBLY (WSA)

EXISTING	NEW	ITEM DESCRIPTION
		GATE VALVE (GV)
		BALL VALVE (BV)
		QUICK COUPLING VALVE (QCV)
		CAM COUPLER ASSEMBLY (CCA)
		GARDEN VALVE ASSEMBLY (GARVA)
		PRESSURE REGULATING VALVE (PRV)
		PRESSURE RELIEF VALVE (PRLV)
		FLOW CONTROL VALVE (FCV)
		COMBINATION AIR RELEASE VALVE (CARV)
		CHECK VALVE (CV)
		FLUSH VALVE (FV)
		EXISTING NOZZLE LINE W/TURNING UNION
		EXISTING IRRIGATION SYSTEM
		EXISTING IRRIGATION SYSTEM TO BE REMOVED
		CHAIN LINK GATE
		QUICK COUPLING VALVE W/SPRINKLER PROTECTOR
		SPRINKLER W/SPRINKLER PROTECTOR
		CONNECT TO EXISTING SYSTEM
		CAP
		CAP EXISTING
		FIBER ROLL
		COMPOST SOCK

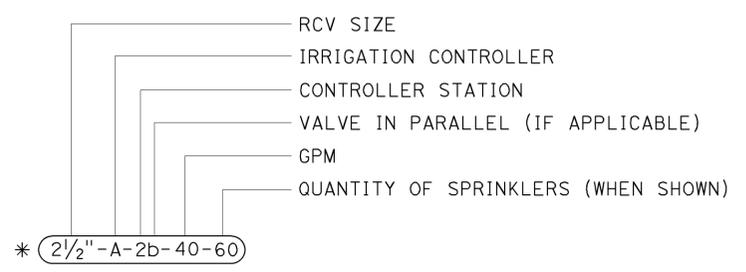

VALVE CODE

\* VALVE CODES FOR EXISTING VALVES ARE SHOWN IN A DASHED ENCLOSURE.

STATE OF CALIFORNIA  
DEPARTMENT OF TRANSPORTATION  
**LANDSCAPE AND EROSION CONTROL SYMBOLS**  
NO SCALE

RSP H2 DATED NOVEMBER 15, 2013 SUPERSEDES RSP H2 DATED JULY 19, 2013 AND STANDARD PLAN H2 DATED MAY 20, 2011 - PAGE 219 OF THE STANDARD PLANS BOOK DATED 2010.


**REVISED STANDARD PLAN RSP H2**

Dist	COUNTY	ROUTE	POST MILES TOTAL PROJECT	SHEET No.	TOTAL SHEETS
11	SD	8,54,67,94, 125, etc.	Var	212	231


Gregory A. Balzer  
 LICENSED LANDSCAPE ARCHITECT  
 July 19, 2013  
 PLANS APPROVAL DATE  
THE STATE OF CALIFORNIA OR ITS OFFICERS OR AGENTS SHALL NOT BE RESPONSIBLE FOR THE ACCURACY OR COMPLETENESS OF SCANNED COPIES OF THIS PLAN SHEET.




TO ACCOMPANY PLANS DATED 01-11-16

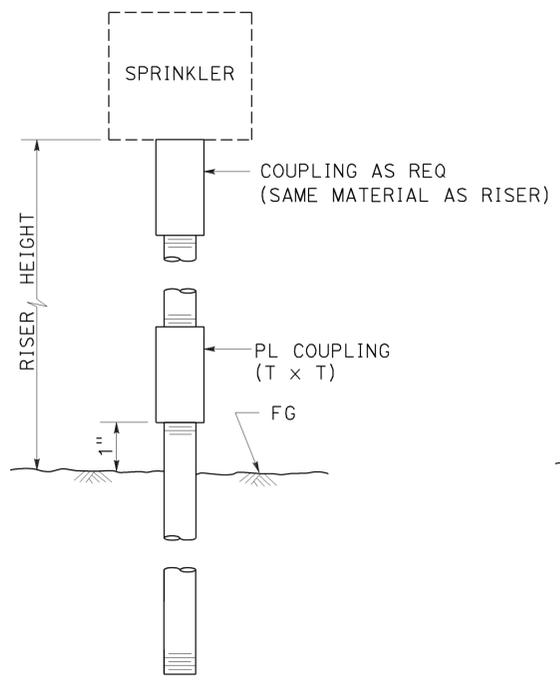


**ELEVATION**  
**RISER SPRINKLER ASSEMBLY TYPE I**

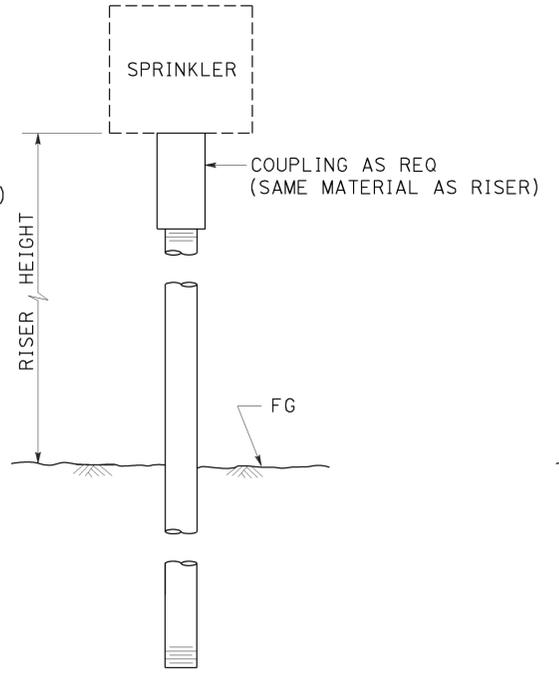

**ELEVATION**  
**RISER SPRINKLER ASSEMBLY TYPE II**

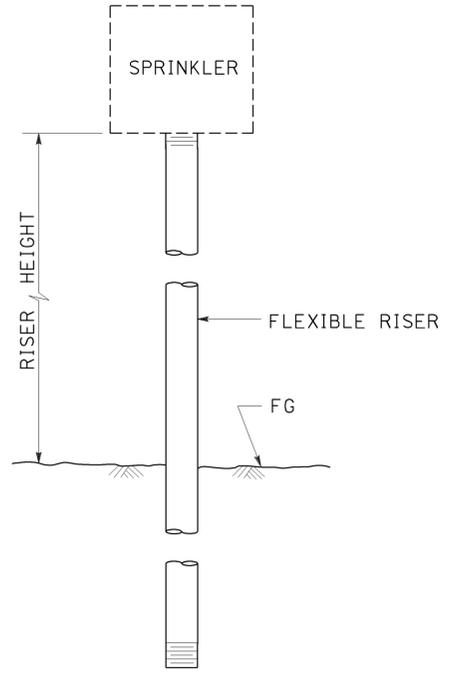


**ELEVATION**  
**RISER SPRINKLER ASSEMBLY TYPE III**

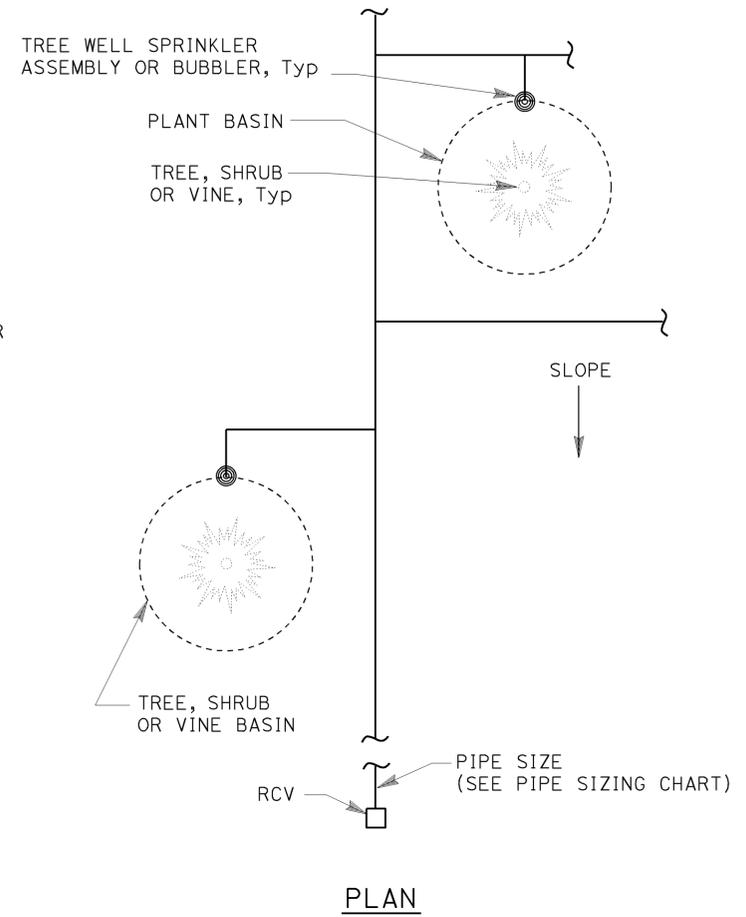


**PLAN**


- NOTES:**
1. Install tree well sprinkler assembly on up-hill side of plant when on slope.
  2. Install bubbler within basin.

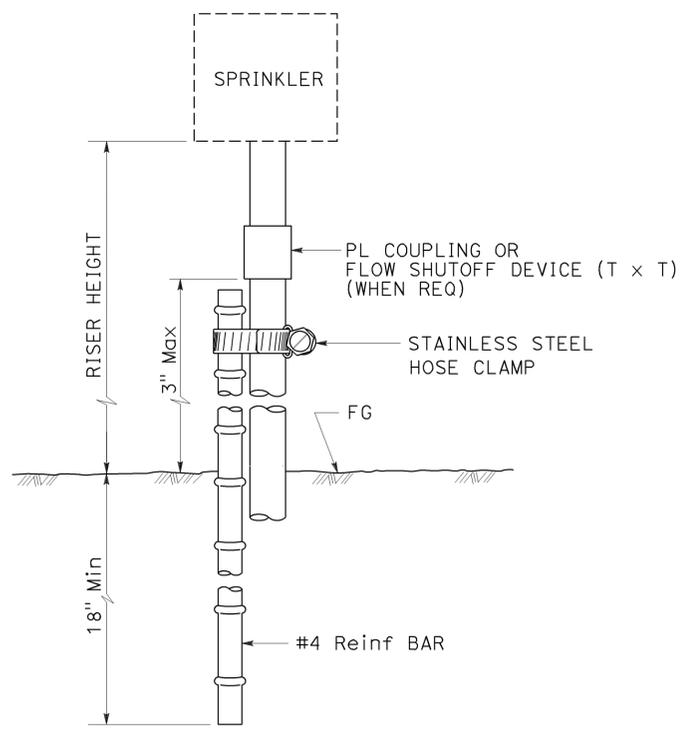

**ELEVATION**  
**RISER SPRINKLER ASSEMBLY TYPE IV**

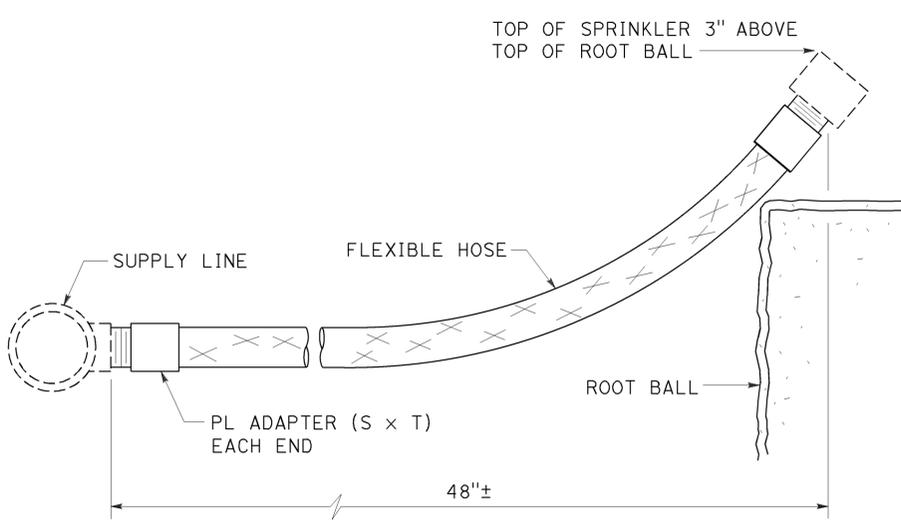

**ELEVATION**  
**RISER SPRINKLER ASSEMBLY TYPE V**

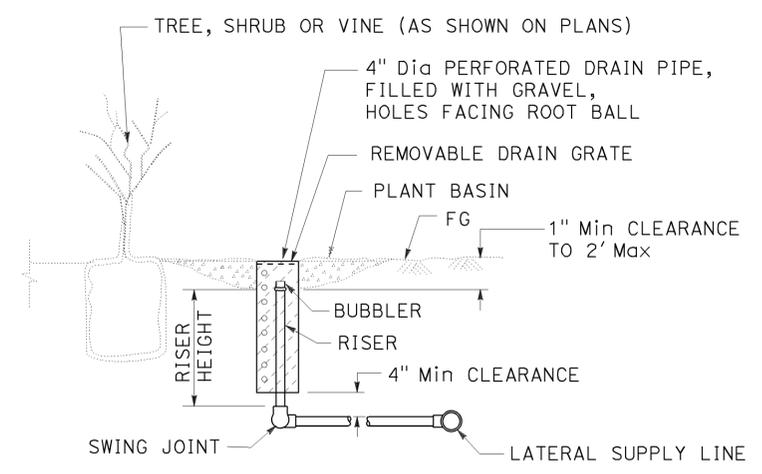

**SECTION**  
**TREE WELL SPRINKLER ASSEMBLY**

STATE OF CALIFORNIA  
DEPARTMENT OF TRANSPORTATION  
**LANDSCAPE DETAILS**  
NO SCALE

RSP H5 DATED JULY 19, 2013 SUPERSEDES STANDARD PLAN H5 DATED MAY 20, 2011 - PAGE 222 OF THE STANDARD PLANS BOOK DATED 2010.


**REVISED STANDARD PLAN RSP H5**

**2010 REVISED STANDARD PLAN RSP H5**

Dist	COUNTY	ROUTE	POST MILES TOTAL PROJECT	SHEET No.	TOTAL SHEETS
11	SD	8,54,67,94, 125, etc.	Var	213	231


*Gregory A. Balzer*  
 LICENSED LANDSCAPE ARCHITECT  
 July 19, 2013  
 PLANS APPROVAL DATE  
THE STATE OF CALIFORNIA OR ITS OFFICERS OR AGENTS SHALL NOT BE RESPONSIBLE FOR THE ACCURACY OR COMPLETENESS OF SCANNED COPIES OF THIS PLAN SHEET.

TO ACCOMPANY PLANS DATED 01-11-16

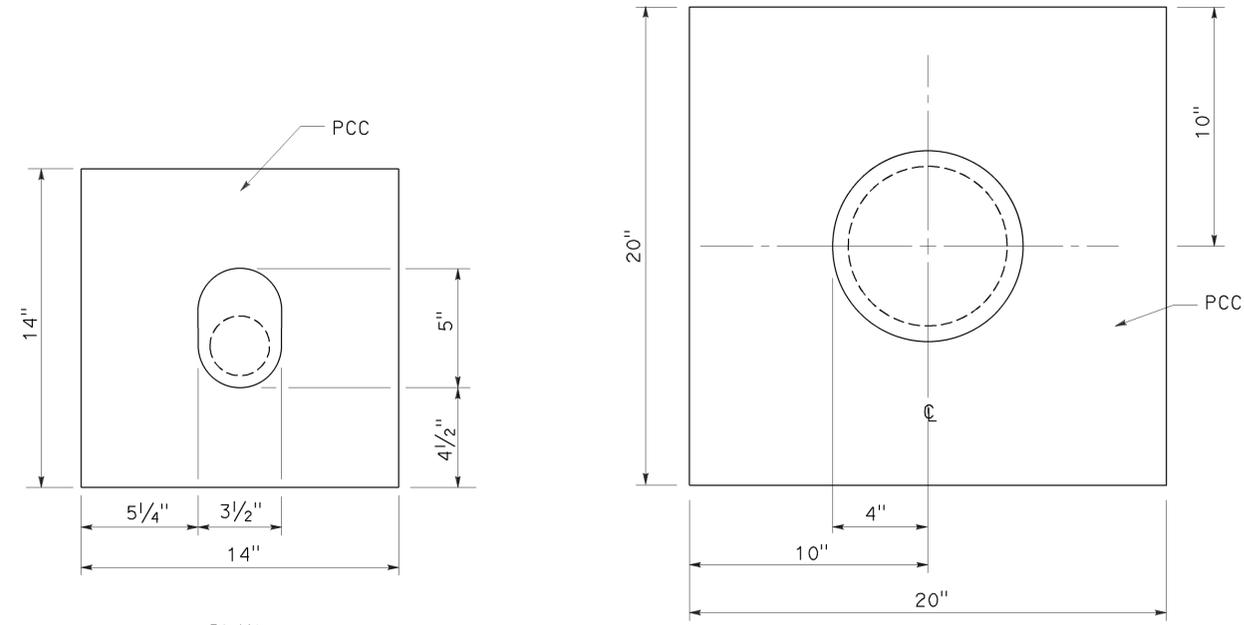


PLAN


PLAN

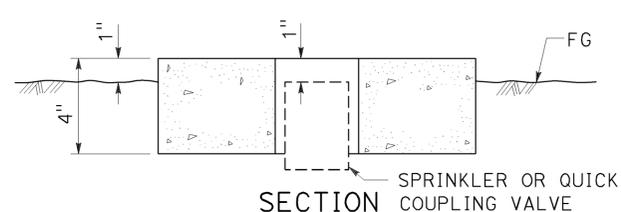


SECTION SPRINKLER PROTECTOR TYPE I

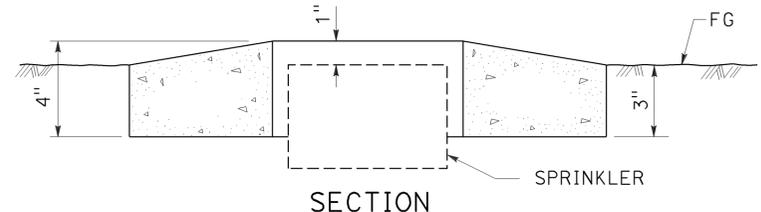


SECTION SPRINKLER PROTECTOR TYPE II

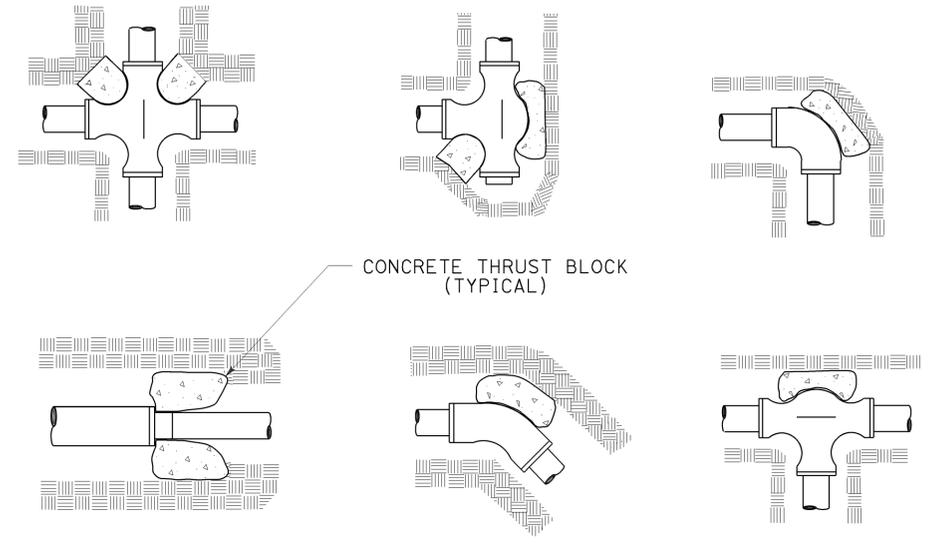


TYPICAL THRUST BLOCKS

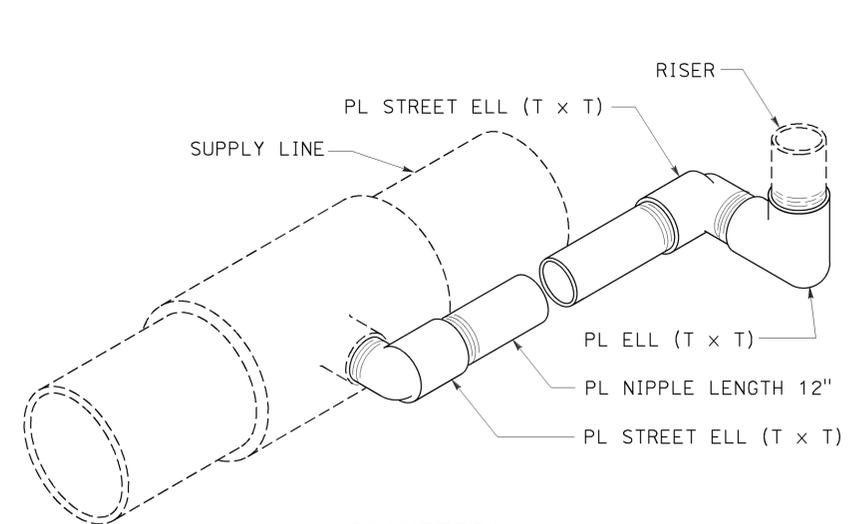

ISOMETRIC POP-UP SPRINKLER ASSEMBLY TYPE I

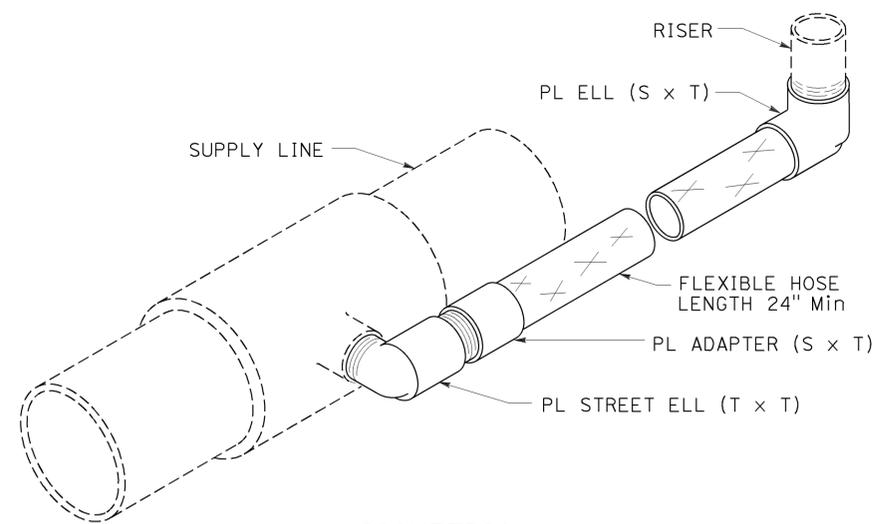

ISOMETRIC POP-UP SPRINKLER ASSEMBLY TYPE II

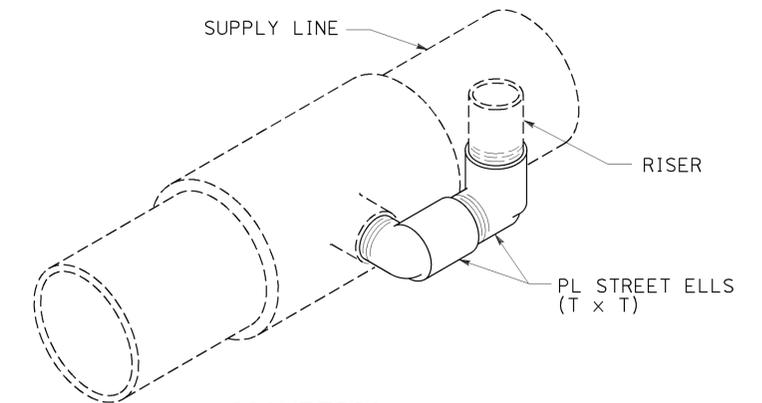

ISOMETRIC POP-UP SPRINKLER ASSEMBLY TYPE III

STATE OF CALIFORNIA  
 DEPARTMENT OF TRANSPORTATION  
**LANDSCAPE DETAILS**

NO SCALE



RSP H6 DATED JULY 19, 2013 SUPERSEDES STANDARD PLAN H6 DATED MAY 20, 2011 - PAGE 223 OF THE STANDARD PLANS BOOK DATED 2010.

**REVISED STANDARD PLAN RSP H6**


2010 REVISED STANDARD PLAN RSP H6

Dist	COUNTY	ROUTE	POST MILES TOTAL PROJECT	SHEET No.	TOTAL SHEETS
11	SD	8,54,67,94, 125, etc.	Var	214	231


*Guyon A. Balzer*  
 LICENSED LANDSCAPE ARCHITECT  
 July 19, 2013  
 PLANS APPROVAL DATE  
THE STATE OF CALIFORNIA OR ITS OFFICERS OR AGENTS SHALL NOT BE RESPONSIBLE FOR THE ACCURACY OR COMPLETENESS OF SCANNED COPIES OF THIS PLAN SHEET.

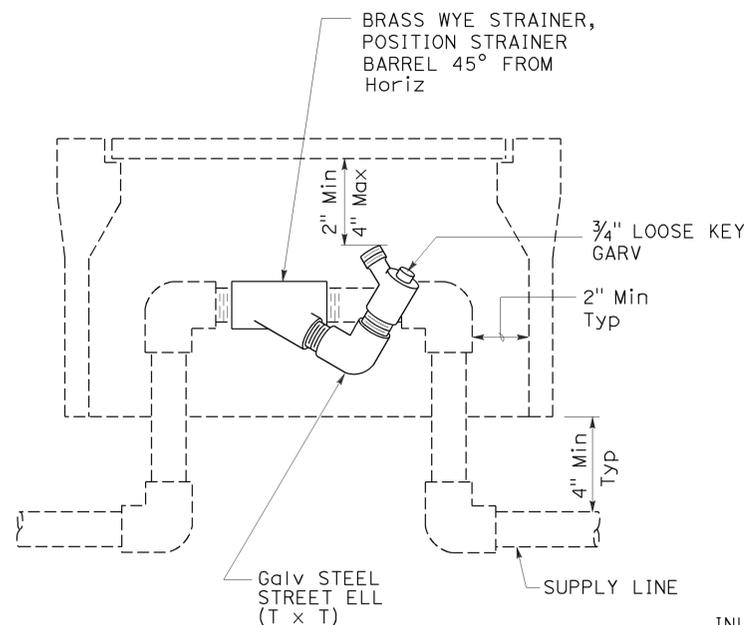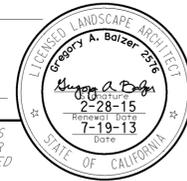


**ELEVATION**  
**WYE STRAINER ASSEMBLY**

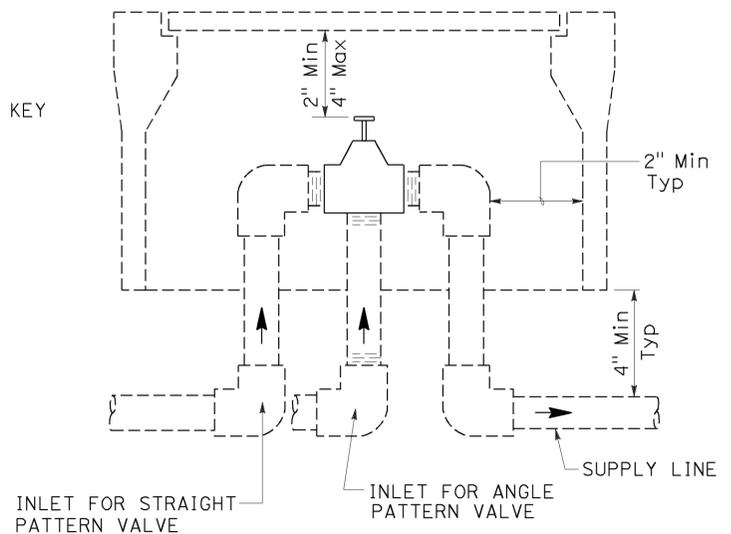


**ELEVATION**  
**VALVE**

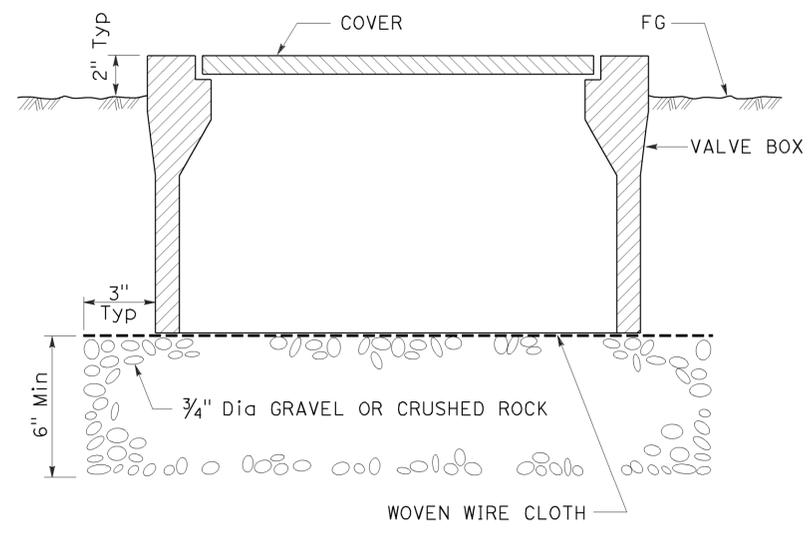

**SECTION**  
**VALVE BOX**

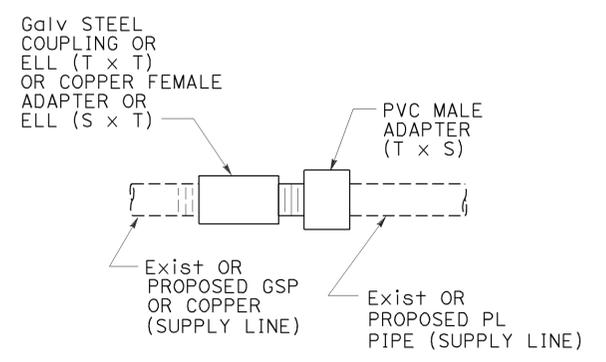


**GALVANIZED OR COPPER PIPE CONNECTION TO PLASTIC PIPE**

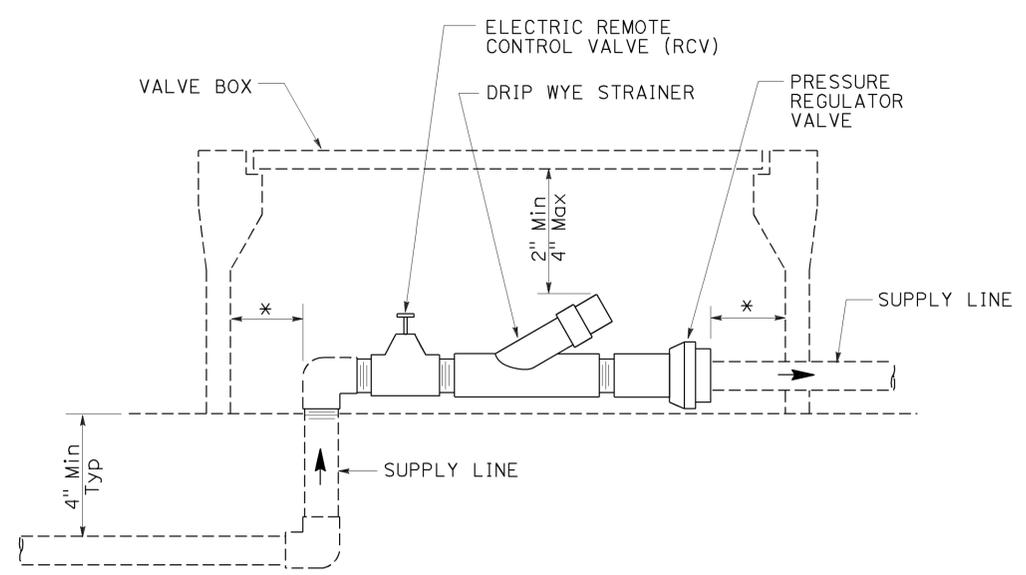


**ELEVATION**  
**DRIP VALVE ASSEMBLY**

IDENTIFICATION LABEL:  
FOR ABBREVIATIONS SEE  
REVISED STANDARD PLANS  
RSP H1 AND RSP H2.  
FOR CONTROLLER AND  
STATION NUMBER  
SEE PROJECT PLANS.


RECYCLED WATER WARNING  
SIGN WHEN REQUIRED

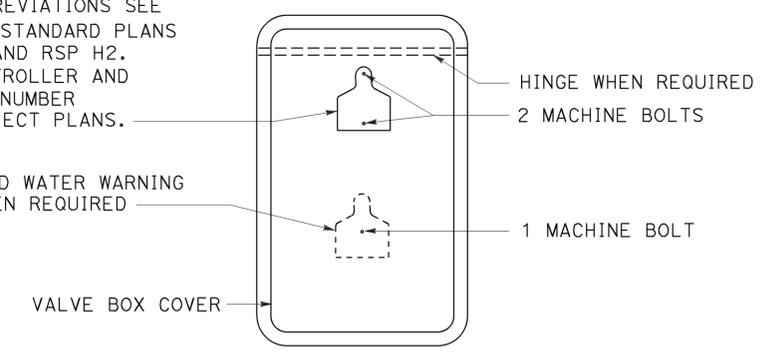


**PLAN**

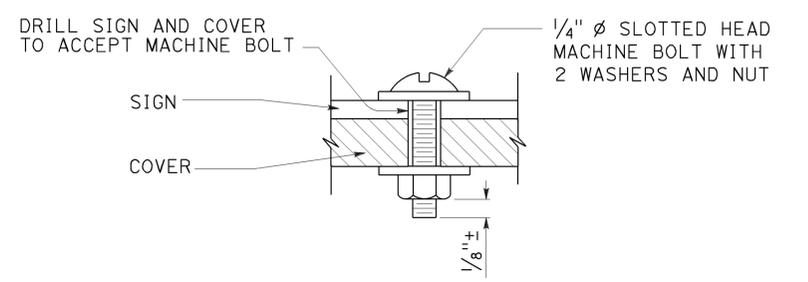

**SECTION**  
**VALVE BOX IDENTIFICATION**

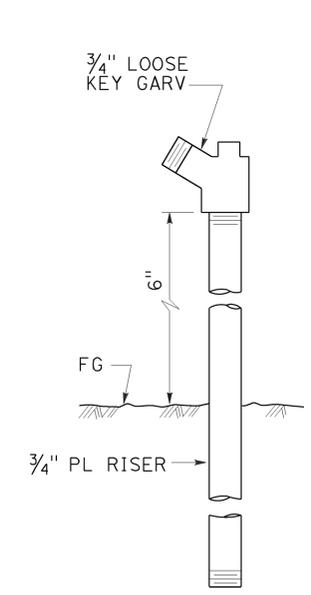

**ELEVATION**  
**GARDEN VALVE ASSEMBLY**

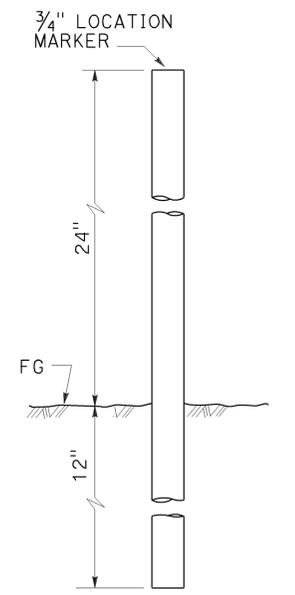

**ELEVATION**  
**LOCATION MARKER**

**LANDSCAPE DETAILS**

STATE OF CALIFORNIA  
DEPARTMENT OF TRANSPORTATION

NO SCALE


RSP H7 DATED JULY 19, 2013 SUPERSEDES STANDARD PLAN H7  
DATED MAY 20, 2011 - PAGE 224 OF THE STANDARD PLANS BOOK DATED 2010.

**REVISED STANDARD PLAN RSP H7**


2010 REVISED STANDARD PLAN RSP H7

Dist	COUNTY	ROUTE	POST MILES TOTAL PROJECT	SHEET No.	TOTAL SHEETS
11	SD	8,54,67,94, 125, etc.	Var	215	231


*Gregory A. Balzer*  
 LICENSED LANDSCAPE ARCHITECT  
 July 19, 2013  
 PLANS APPROVAL DATE  
THE STATE OF CALIFORNIA OR ITS OFFICERS OR AGENTS SHALL NOT BE RESPONSIBLE FOR THE ACCURACY OR COMPLETENESS OF SCANNED COPIES OF THIS PLAN SHEET.

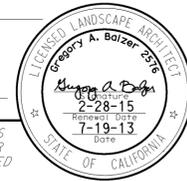


TO ACCOMPANY PLANS DATED 01-11-16

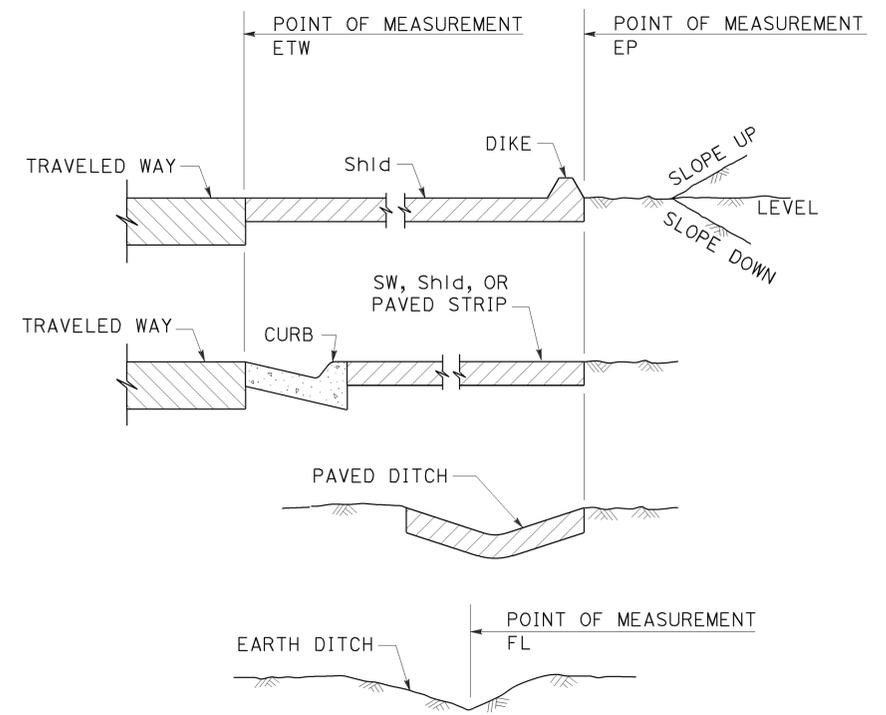


**SECTION  
POINTS OF MEASUREMENT**

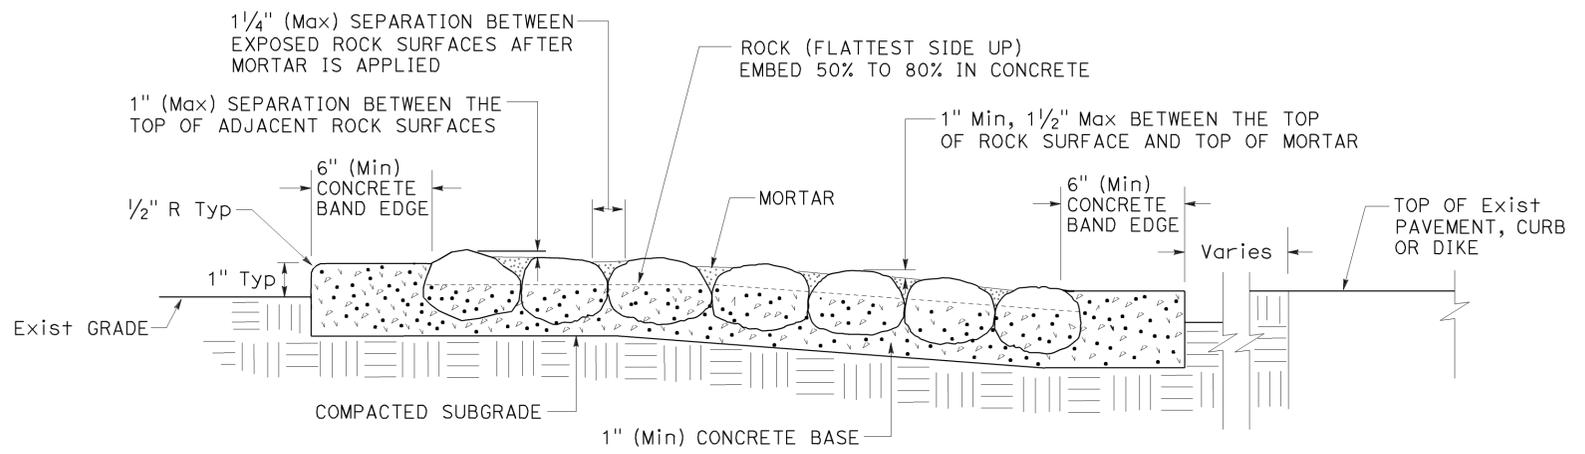

**SECTION  
ROCK BLANKET**

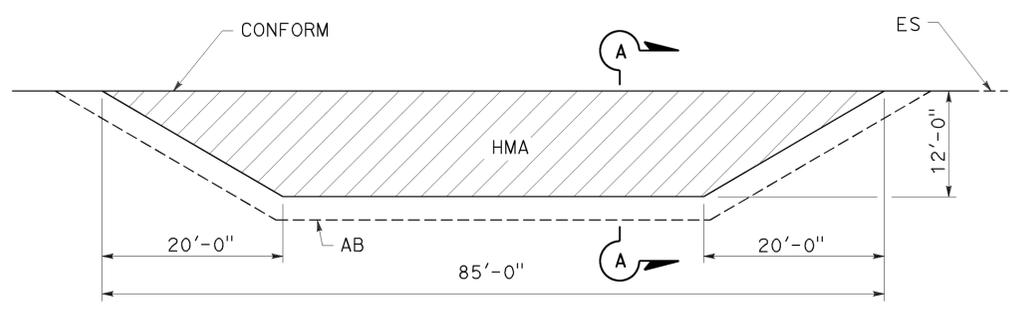

**PLAN**

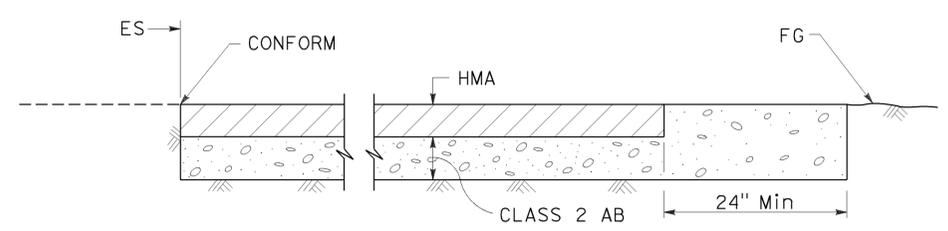

**SECTION A-A  
MAINTENANCE VEHICLE PULLOUT**

STATE OF CALIFORNIA  
 DEPARTMENT OF TRANSPORTATION  
**LANDSCAPE DETAILS**  
 NO SCALE

RSP H9A DATED JULY 19, 2013 SUPPLEMENTS THE STANDARD PLANS BOOK DATED 2010.

**REVISED STANDARD PLAN RSP H9A**

2010 REVISED STANDARD PLAN RSP H9A

TO ACCOMPANY PLANS DATED 01-11-16

TABLE 1

TAPER LENGTH CRITERIA AND CHANNELIZING DEVICE SPACING							
SPEED (S)	MINIMUM TAPER LENGTH * FOR WIDTH OF OFFSET 12 FEET (W)				MAXIMUM CHANNELIZING DEVICE SPACING		
	TANGENT 2L	MERGING L	SHIFTING L/2	SHOULDER L/3	X	Y	Z **
					TAPER	TANGENT	CONFLICT
mph	ft	ft	ft	ft	ft	ft	ft
20	160	80	40	27	20	40	10
25	250	125	63	42	25	50	12
30	360	180	90	60	30	60	15
35	490	245	123	82	35	70	17
40	640	320	160	107	40	80	20
45	1080	540	270	180	45	90	22
50	1200	600	300	200	50	100	25
55	1320	660	330	220	55	110	27
60	1440	720	360	240	60	120	30
65	1560	780	390	260	65	130	32
70	1680	840	420	280	70	140	35

\* - For other offsets, use the following merging taper length formula for L:  
 For speed of 40 mph or less,  $L = WS^2/60$   
 For speed of 45 mph or more,  $L = WS$

Where: L = Taper length in feet  
 W = Width of offset in feet  
 S = Posted speed limit, off-peak 85th-percentile speed prior to work starting, or the anticipated operating speed in mph

\*\* - Use for taper and tangent sections where there are no pavement markings or where there is a conflict between existing pavement markings and channelizers (CA).

TABLE 2

LONGITUDINAL BUFFER SPACE AND FLAGGER STATION SPACING				
SPEED *	Min D **	DOWNGRADE Min D ***		
		-3%	-6%	-9%
		ft	ft	ft
20	115	116	120	126
25	155	158	165	173
30	200	205	215	227
35	250	257	271	287
40	305	315	333	354
45	360	378	400	427
50	425	446	474	507
55	495	520	553	593
60	570	598	638	686
65	645	682	728	785
70	730	771	825	891

\* - Speed is posted speed limit, off-peak 85th-percentile speed prior to work starting, or the anticipated operating speed in mph  
 \*\* - Longitudinal buffer space or flagger station spacing  
 \*\*\* - Use on sustained downgrade steeper than -3 percent and longer than 1 mile.

TABLE 3

ADVANCE WARNING SIGN SPACING			
ROAD TYPE	DISTANCE BETWEEN SIGNS *		
	A	B	C
	ft	ft	ft
URBAN - 25 mph OR LESS	100	100	100
URBAN - MORE THAN 25 mph TO 40 mph	250	250	250
URBAN - MORE THAN 40 mph	350	350	350
RURAL	500	500	500
EXPRESSWAY / FREEWAY	1000	1500	2640

\* - The distances are approximate, are intended for guidance purposes only, and should be applied with engineering judgment. These distances should be adjusted by the Engineer for field conditions, if necessary, by increasing or decreasing the recommended distances.

STATE OF CALIFORNIA  
 DEPARTMENT OF TRANSPORTATION  
**TRAFFIC CONTROL SYSTEM TABLES  
 FOR LANE AND RAMP CLOSURES**  
 NO SCALE

RSP T9 DATED JULY 19, 2013 SUPERSEDES RSP T9 DATED APRIL 19, 2013 THAT SUPPLEMENTS THE STANDARD PLANS BOOK DATED 2010.


2010 REVISED STANDARD PLAN RSP T9

DIST	COUNTY	ROUTE	POST MILES TOTAL PROJECT	SHEET No.	TOTAL SHEETS
11	SD	8,54,67,94, 125, etc.	Var	217	231

REGISTERED CIVIL ENGINEER  
 April 19, 2013  
 PLANS APPROVAL DATE

THE STATE OF CALIFORNIA OR ITS OFFICERS OR AGENTS SHALL NOT BE RESPONSIBLE FOR THE ACCURACY OR COMPLETENESS OF SCANNED COPIES OF THIS PLAN SHEET.

2010 REVISED STANDARD PLAN RSP T10

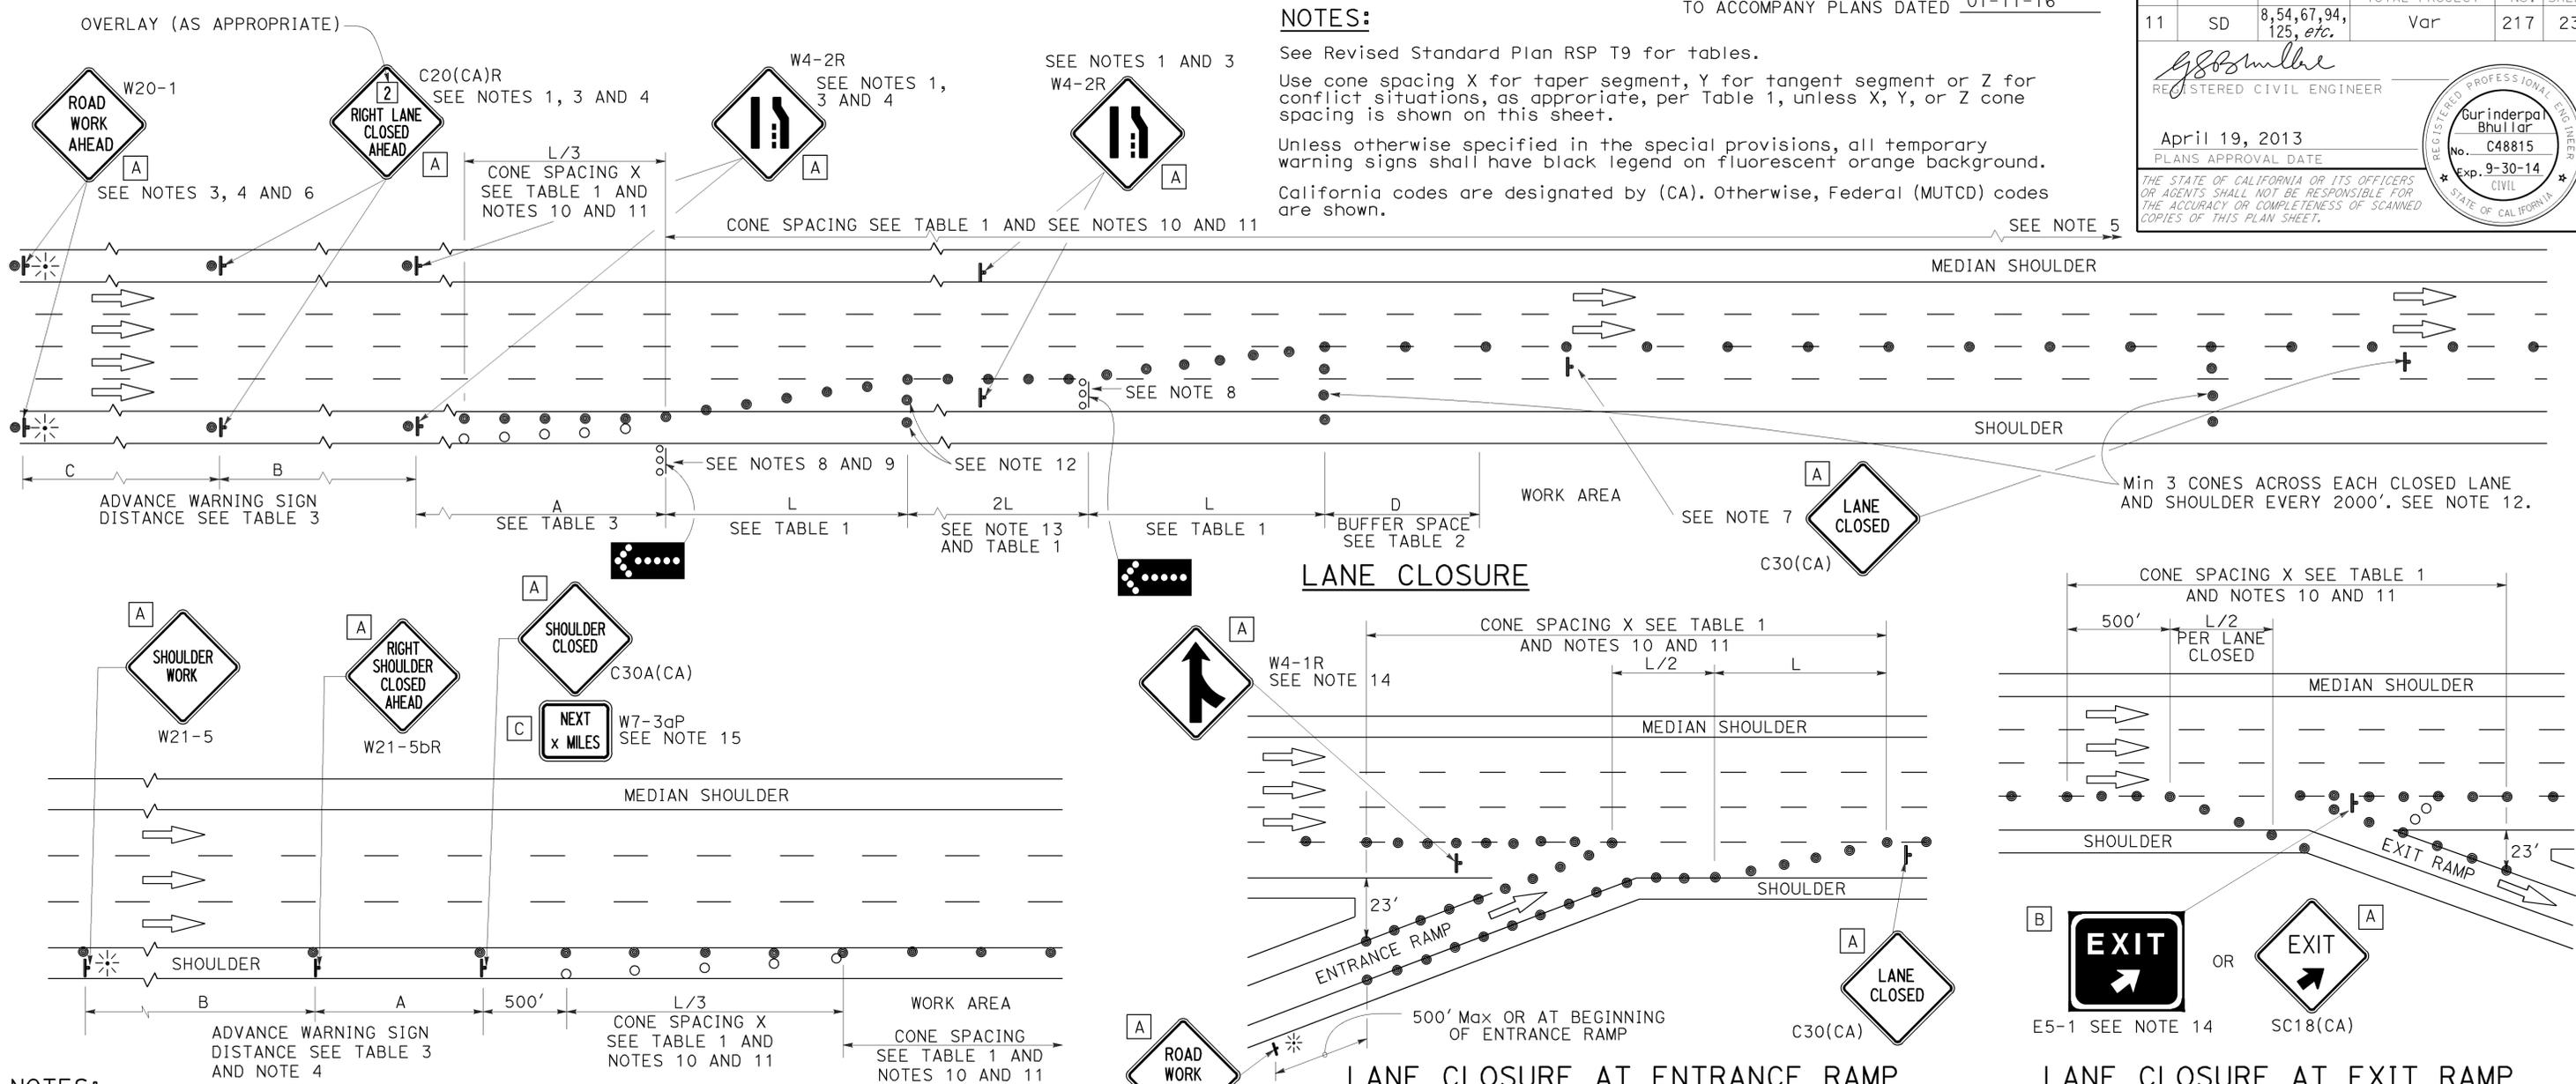

- NOTES:**
- Median lane closures shall conform to the details as shown except that C20(CA)L and W4-2L signs shall be used.
  - At least one person shall be assigned to provide full time maintenance of traffic control devices for lane closures.
  - Duplicate sign installations are not required:
    - On opposite shoulder if at least one-half of the available lanes remain open to traffic.
    - In the median if the width of the median shoulder is less than 8' and the outside lanes are to be closed.
  - Each advance warning sign on each side of the roadway shall be equipped with at least two flags for daytime closure. Each flag shall be at least 16" x 16" in size and shall be orange or fluorescent red-orange in color. Flashing beacons shall be placed at the locations indicated for lane closure during hours of darkness.
  - A G20-2 "END ROAD WORK" sign, with minimum size of 48" x 24" as appropriate, shall be placed at the end of the lane closure unless the end of work area is obvious or ends within a larger project's limits.

- If the W20-1 sign would follow within 2000' of a stationary W20-1 or G20-1 "ROAD WORK NEXT \_\_\_\_\_ MILES", use a C20(CA)L and W4-2L signs shall be used.
- Place a C30(CA) sign every 2000' throughout length of lane closure.
- One flashing arrow sign for each lane closed. The flashing arrow signs shall be Type I.
- A minimum 1500' of sight distance shall be provided where possible for vehicles approaching the first flashing arrow sign. Lane closures shall not begin at top of crest vertical curve or on a horizontal curve.
- All cones used for lane closures during the hours of darkness shall be fitted with retroreflective bands (or sleeves) as specified in the specifications.
- Portable delineators, placed at one-half the spacing indicated for traffic cones may be used instead of cones for daytime closures only.

- Unless otherwise specified in the special provisions, a minimum of 3 cones shall be placed transversely across each closed lane and shoulder at each location where a taper across a traffic lane ends and every 2000' as shown on the "Lane Closure" detail. Two Type II barricades may be used instead of the 3 cones. The transverse alignment of the cones or barricades on the closed shoulder may be shifted from the transverse alignment to provide access to the work.
- Unless otherwise specified in the special provisions, the 2L tangent shown along lane lines shall be used between the L tapers required for each closed traffic lane.
- Unless otherwise specified in the special provisions, the E5-1 or SC18(CA) and W4-1 signs shall be used as shown.
- A W7-3aP "NEXT \_\_\_\_\_ MILES" plaque must be used if the shoulder closure extends beyond the distance that can be perceived by road users.

**LEGEND**

- TRAFFIC CONE
- TRAFFIC CONE (OPTIONAL TAPER)
- † TEMPORARY TRAFFIC CONTROL SIGN
- FLASHING ARROW SIGN (FAS)
- FAS SUPPORT OR TRAILER
- ⚡ PORTABLE FLASHING BEACON

**SIGN PANEL SIZE (Min)**

A	48" x 48"
B	72" x 60"
C	36" x 30"

STATE OF CALIFORNIA  
 DEPARTMENT OF TRANSPORTATION

## TRAFFIC CONTROL SYSTEM FOR LANE CLOSURE ON FREEWAYS AND EXPRESSWAYS

NO SCALE

RSP T10 DATED APRIL 19, 2013 SUPERSEDES STANDARD PLAN T10 DATED MAY 20, 2011 - PAGE 237 OF THE STANDARD PLANS BOOK DATED 2010.

### REVISED STANDARD PLAN RSP T10

DIST	COUNTY	ROUTE	POST MILES TOTAL PROJECT	SHEET NO.	TOTAL SHEETS
11	SD	8,54,67,94, 125, etc.	Var	218	231


REGISTERED CIVIL ENGINEER  
 Gurinderpal Bhullar  
 No. C48815  
 Exp. 9-30-14  
 STATE OF CALIFORNIA

April 19, 2013  
 PLANS APPROVAL DATE

THE STATE OF CALIFORNIA OR ITS OFFICERS OR AGENTS SHALL NOT BE RESPONSIBLE FOR THE ACCURACY OR COMPLETENESS OF SCANNED COPIES OF THIS PLAN SHEET.


**NOTES:** See Revised Standard Plan RSP T9 for tables.  
 Use cone spacing X for taper segment, Y for tangent segment or Z for conflict situations, as appropriate, per Table 1, unless X, Y, or Z cone spacing is shown on this sheet.  
 Unless otherwise specified in the special provisions, all temporary warning signs shall have black legend on fluorescent orange background.  
 California codes are designated by (CA). Otherwise, Federal (MUTCD) codes are shown.

SEE NOTES 3 AND 5

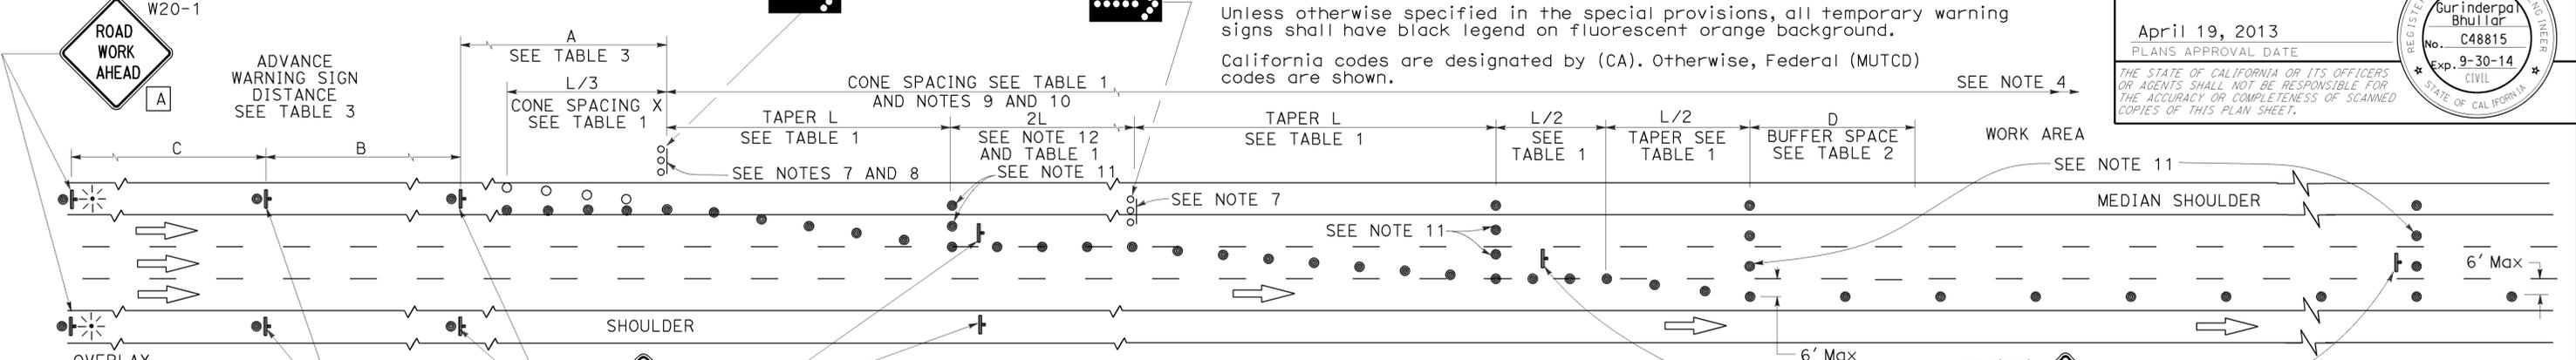

**LANE CLOSURE WITH PARTIAL SHOULDER USE**

SEE NOTES 3 AND 5

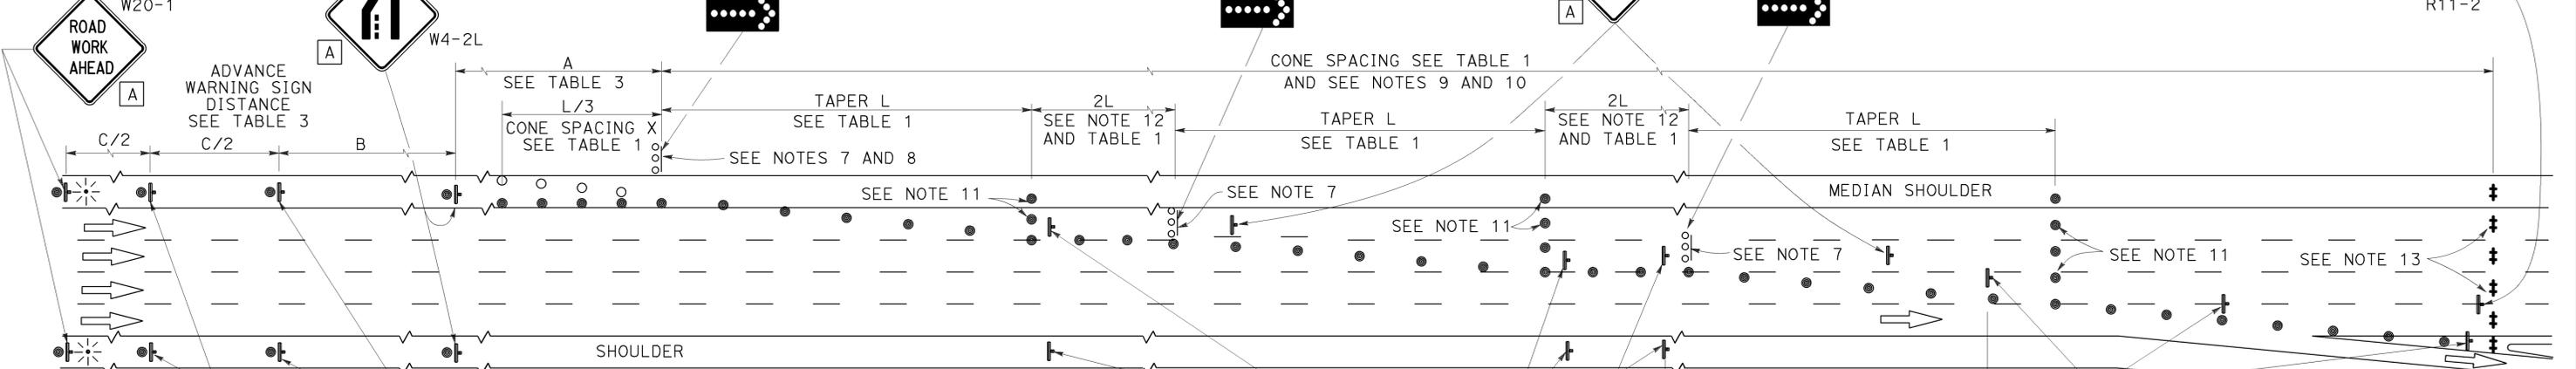

**COMPLETE CLOSURE**

**NOTES:**

- Lane closures on the right side using partial median shoulder as a traffic lane shall conform to the details as shown except that C20(CA)R and W4-2R signs shall be used.
- At least one person shall be assigned to provide full time maintenance of traffic control devices for lane closures.
- Each advance warning sign on each side of the roadway shall be equipped with at least two flags for daytime closure. Each flag shall be at least 16" X 16" in size and shall be orange or fluorescent red-orange in color. Flashing beacons shall be placed at the locations indicated for lane closure during hours of darkness.
- A G20-2 "END ROAD WORK" sign, with minimum size of 48" x 24" as appropriate, shall be placed at the end of the lane closure unless the end of work area is obvious or ends within a larger project's limits.
- If the W20-1 sign would follow within 2000' of a stationary W20-1 or G20-1 "ROAD WORK NEXT \_\_\_ MILES", use a C20(CA) sign for the first advance warning sign.
- Place a C30(CA) sign every 2000' throughout length of lane closure.
- One flashing arrow sign for each lane closed. The flashing arrow signs shall be Type I.
- A minimum 1500' of sight distance shall be provided where possible for vehicles approaching the first flashing arrow sign. Lane closures shall not begin at the top of crest vertical curve or on a horizontal curve.
- All cones used for lane closures during the hours of darkness shall be fitted with retroreflective bands (or sleeves) as specified in the specifications.
- Portable delineators, placed at one-half the spacing indicated for traffic cones, may be used instead of cones for daytime closures only.
- Unless otherwise specified in the special provisions, a minimum of 3 cones shall be placed transversely across each closed lane and shoulder at each location where a taper across a traffic lane ends and every 2000' as shown on the "Lane Closure With Partial Shoulder Use" detail. Two Type II barricades may be used instead of the 3 cones. The transverse alignment of the cones or barricades on the closed shoulder may be shifted from the transverse alignment to provide access to the work.
- Unless otherwise specified in the special provisions, the 2L tangent shown along lane lines shall be used between the L tapers required for each closed traffic lane.
- A minimum of Two Type II or III barricades shall be placed across each closed lane and shoulder at the location shown and every 2000' within the complete closure area. Within the complete closure area, the transverse alignment of the barricades on the closed shoulder may be shifted from the transverse alignment to provide access to the work.
- When specified in the special provisions, a W20-2 "DETOUR AHEAD" sign is to be used in place of the W20-3 "FREEWAY CLOSED AHEAD" sign.

**SIGN PANEL SIZE (Min)**

- A 48" x 48"
- B 48" x 18"
- C 48" x 30"

**LEGEND**

- TRAFFIC CONE
- TRAFFIC CONE (OPTIONAL TAPER)
- † TEMPORARY TRAFFIC CONTROL SIGN
- FLASHING ARROW SIGN (FAS)
- FAS SUPPORT OR TRAILER
- ⊛ PORTABLE FLASHING BEACON

STATE OF CALIFORNIA  
 DEPARTMENT OF TRANSPORTATION  
**TRAFFIC CONTROL SYSTEM  
 FOR LANE CLOSURES ON  
 FREEWAYS AND EXPRESSWAYS**  
 NO SCALE

RSP T10A DATED APRIL 19, 2013 SUPERSEDES STANDARD PLAN T10A DATED MAY 20, 2011 - PAGE 238 OF THE STANDARD PLANS BOOK DATED 2010.

**REVISED STANDARD PLAN RSP T10A**

2010 REVISED STANDARD PLAN RSP T10A

Dist	COUNTY	ROUTE	POST MILES TOTAL PROJECT	SHEET No.	TOTAL SHEETS
11	SD	8,54,67,94, 125, etc.	Var	219	231

REGISTERED CIVIL ENGINEER  
 April 19, 2013  
 PLANS APPROVAL DATE  
 Gurinderpal Bhullar  
 No. C48815  
 Exp. 9-30-14  
 CIVIL  
 STATE OF CALIFORNIA  
THE STATE OF CALIFORNIA OR ITS OFFICERS OR AGENTS SHALL NOT BE RESPONSIBLE FOR THE ACCURACY OR COMPLETENESS OF SCANNED COPIES OF THIS PLAN SHEET.

**LEGEND**

- TRAFFIC CONE
- ⌋ TEMPORARY TRAFFIC CONTROL SIGN
- ⬢ FLASHING ARROW SIGN (FAS)
- ⦿ FAS SUPPORT OR TRAILER
- ⊛ PORTABLE FLASHING BEACON

**SIGN PANEL SIZE (Min)**


- A 48" x 48"
- B 24" x 24"
- C 36" x 18"

**NOTES:**

See Revised Standard Plan RSP T9 for tables.  
 Use cone spacing X for taper segment, Y for tangent segment or Z for conflict situations, as appropriate, per Table 1, unless X, Y, or Z cone spacing is shown on this sheet.  
 Unless otherwise specified in the special provisions, all temporary warning signs shall have black legend on fluorescent orange background.  
 California codes are designated by (CA). Otherwise, Federal (MUTCD) codes are shown.

TO ACCOMPANY PLANS DATED 01-11-16

**TYPICAL HALF ROAD CLOSURE**

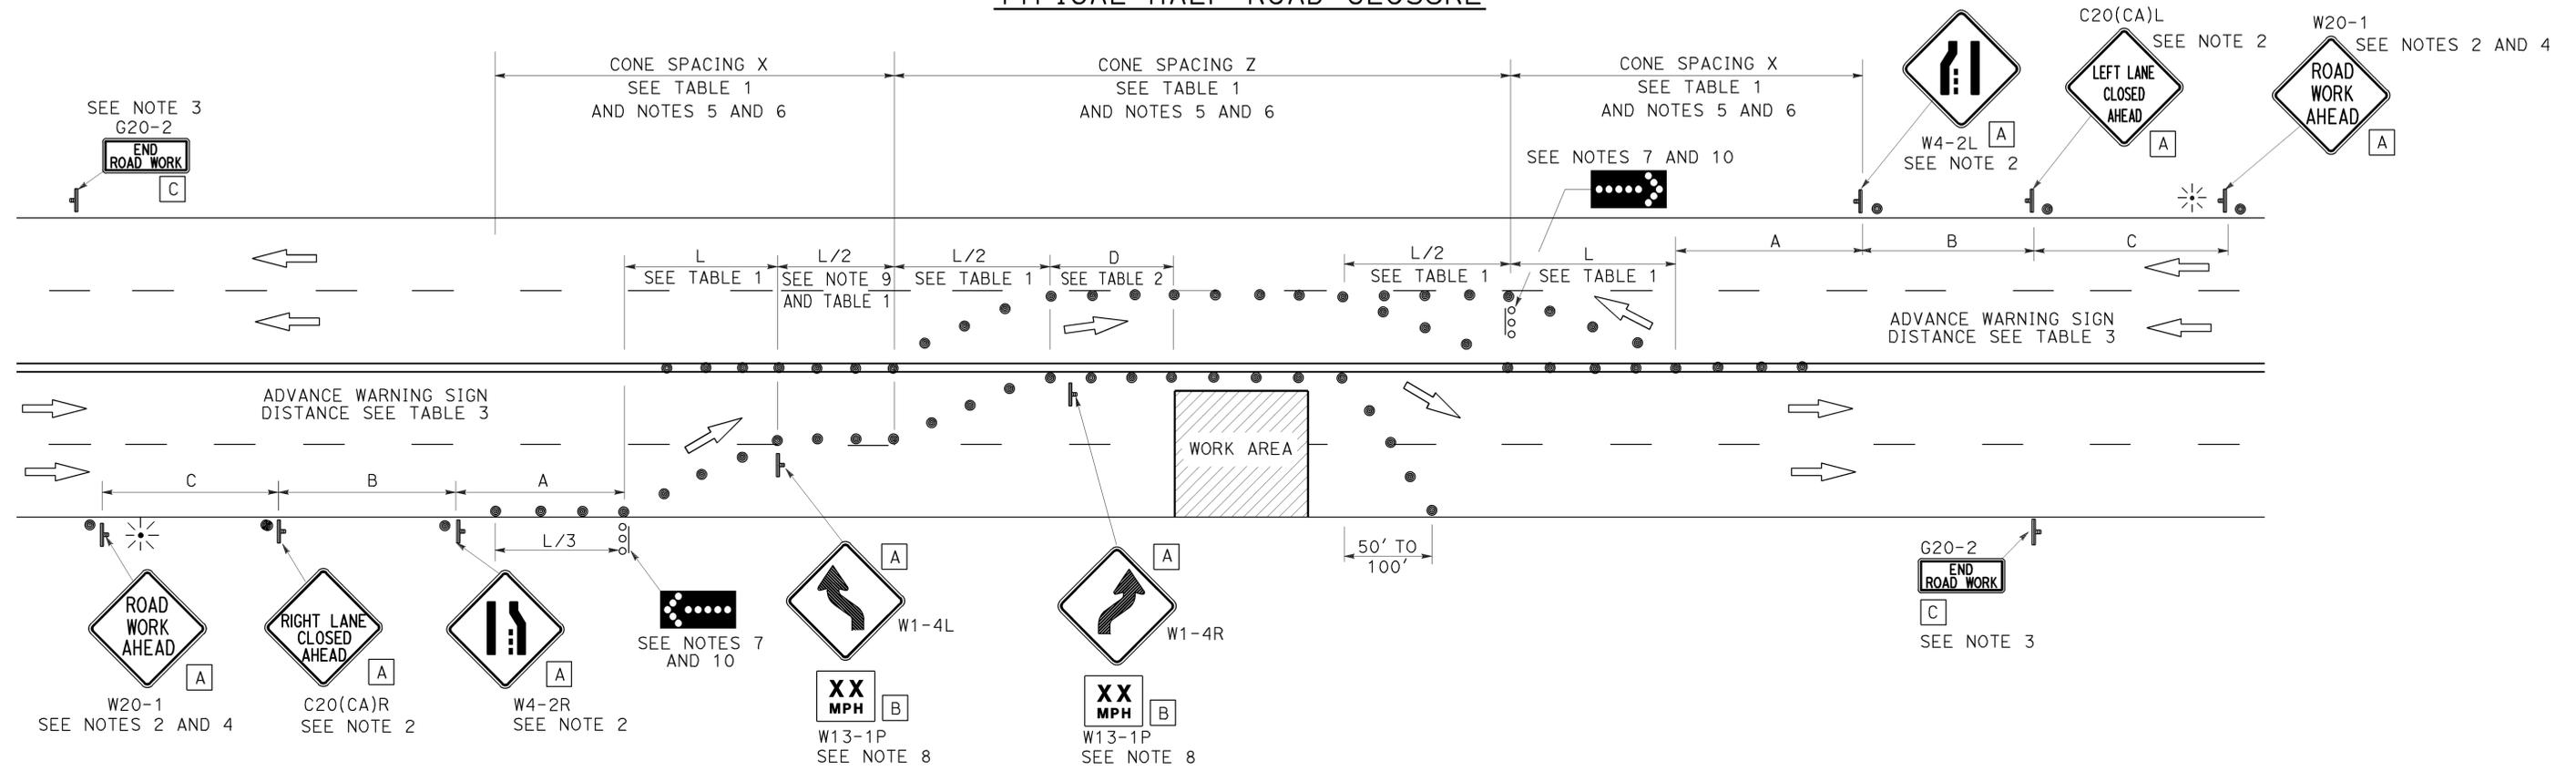

**NOTES:**

1. At least one person shall be assigned to provide full time maintenance of traffic control devices for lane closure unless, otherwise directed by the Engineer.
2. Each advance warning sign in each direction of travel shall be equipped with at least two flags for daytime closure. Each flag shall be at least 16" x 16" in size and shall be orange or fluorescent red-orange in color. Flashing beacons shall be placed at the locations indicated for lane closure during hours of darkness.
3. A G20-2 "END ROAD WORK" sign, as appropriate, shall be placed at the end of the lane closure unless the end of work area is obvious, or ends within a larger project's limits.
4. If the W20-1 sign would follow within 2000' of a stationary W20-1 or G20-1 "ROAD WORK NEXT \_\_\_\_\_ MILES", use a C20(CA) sign for the first advance warning sign.
5. All cones used for lane closures during the hours of darkness shall be fitted with retroreflective bands (or sleeves) as specified in the specifications.
6. Portable delineators, placed at one-half the spacing indicated for traffic cones, may be used instead of cones for daytime closures only.
7. Flashing arrow signs shall be either Type I or Type II.
8. Advisory speed will be determined by the Engineer. The W13-1P Plaque will not be required when advisory speed is more than the posted or maximum speed limit.
9. Unless otherwise specified in the special provisions, the tangent (L/2) shall be used.
10. A minimum 1500' of sight distance shall be provided where possible for vehicles approaching the first flashing arrow sign. Lane closures shall not begin at the top of crest vertical curve or on a horizontal curve.

STATE OF CALIFORNIA  
 DEPARTMENT OF TRANSPORTATION  
**TRAFFIC CONTROL SYSTEM  
 FOR HALF ROAD CLOSURE ON  
 MULTILANE CONVENTIONAL  
 HIGHWAYS AND EXPRESSWAYS**

NO SCALE

RSP T12 DATED APRIL 19, 2013 SUPERSEDES STANDARD PLAN T12  
 DATED MAY 20, 2011 - PAGE 240 OF THE STANDARD PLANS BOOK DATED 2010.

**REVISED STANDARD PLAN RSP T12**

2010 REVISED STANDARD PLAN RSP T12

# TYPICAL RAMP CLOSURES

## SIGN PANEL SIZE (Min)

- A 48" x 48"
- B 48" x 30"
- C 36" x 36"
- D 48" x 36"

## LEGEND

- TRAFFIC CONE
- † TEMPORARY TRAFFIC CONTROL SIGN
- ‡ BARRICADES
- ⚡ PORTABLE FLASHING BEACON

Dist	COUNTY	ROUTE	POST MILES TOTAL PROJECT	SHEET No.	TOTAL SHEETS
11	SD	8,54,67,94, 125, etc.	Var	220	231


*Gurinderpal Bhullar*  
 REGISTERED CIVIL ENGINEER  
 April 19, 2013  
 PLANS APPROVAL DATE  
THE STATE OF CALIFORNIA OR ITS OFFICERS OR AGENTS SHALL NOT BE RESPONSIBLE FOR THE ACCURACY OR COMPLETENESS OF SCANNED COPIES OF THIS PLAN SHEET.

REGISTERED PROFESSIONAL ENGINEER  
**Gurinderpal Bhullar**  
 No. C48815  
 Exp. 9-30-14  
 CIVIL  
 STATE OF CALIFORNIA


TO ACCOMPANY PLANS DATED 01-11-16

## NOTES:


- Barricades shall be Type I, II, or III for closures lasting one week or less and Type III for closures lasting longer than one week.
- In addition to placing the C19(CA) "RAMP CLOSED AHEAD" and C30(CA) "RAMP CLOSED" signs, black on orange overlay plates with the word "CLOSED" may be mounted, as directed by the Engineer, on all guide signs that refer to the closed ramp. The letter size on the overlay shall be the same as the guide sign.
- Each advance C19(CA) "RAMP CLOSED AHEAD" sign shall be equipped with at least two flags for daytime closure. Each flag shall be at least 16" x 16" in size and shall be orange or fluorescent red-orange in color. A flashing beacon shall be placed on top of the first C19(CA) sign during hours of darkness.
- All cones used for ramp closures during the hours of darkness shall be fitted with retroreflective bands (or sleeves) as specified in the specifications.
- Portable delineators, placed at one-half the spacing indicated for traffic cones, may be used instead of cones for daytime ramp closures only.
- At least one person shall be assigned to provide full time maintenance of traffic control devices, unless otherwise directed by the Engineer.
- The existing "EXIT" signs shall be covered during ramp closures.
- A minimum of 3 cones shall be placed transversely across each closed lane and shoulder.

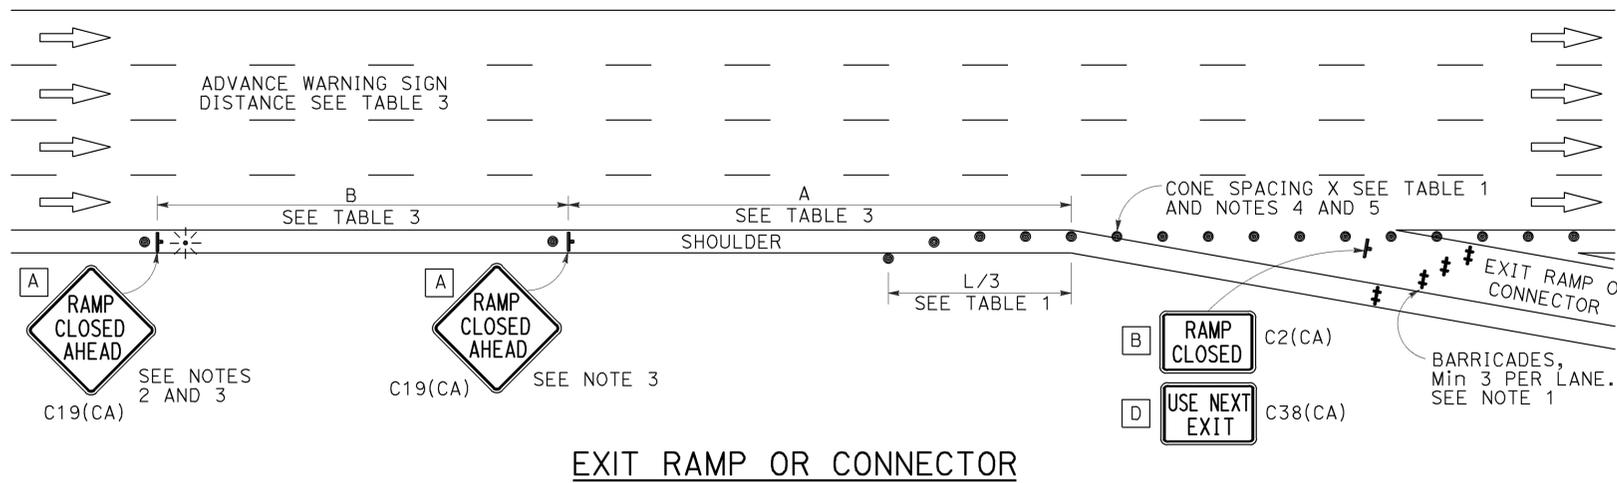


EXIT RAMP OR CONNECTOR

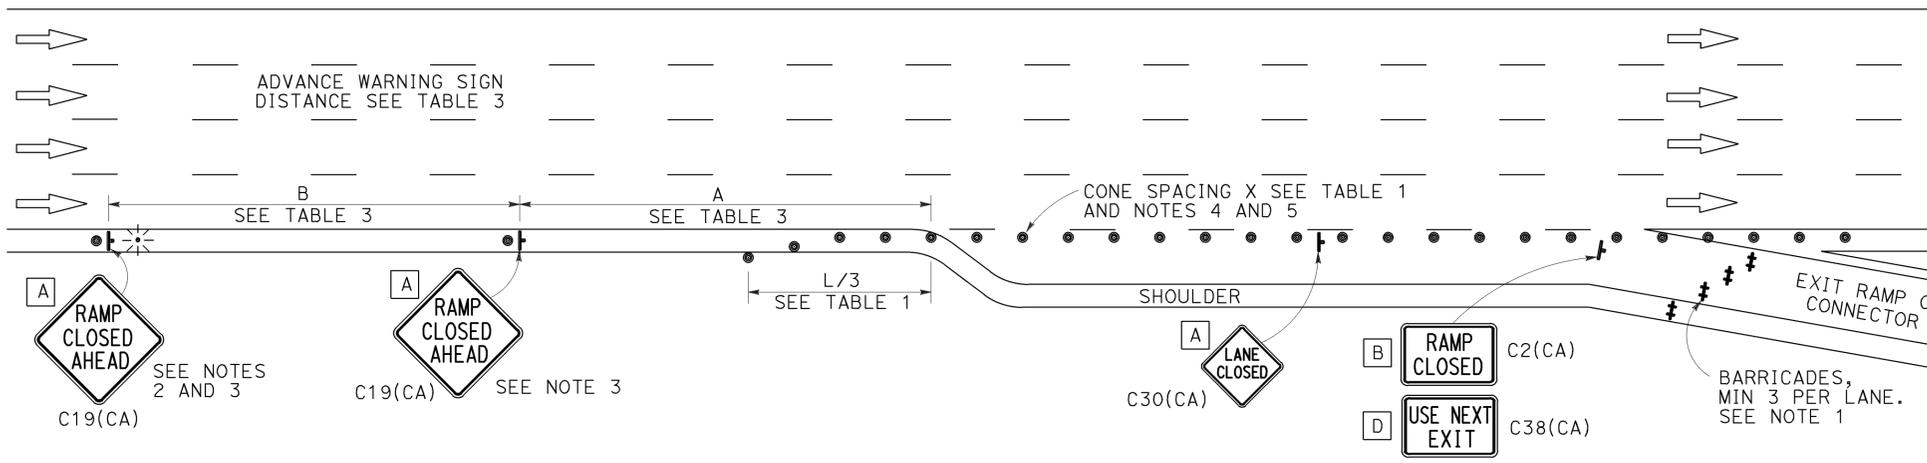

EXIT RAMP OR CONNECTOR WITH ADDITIONAL LANE

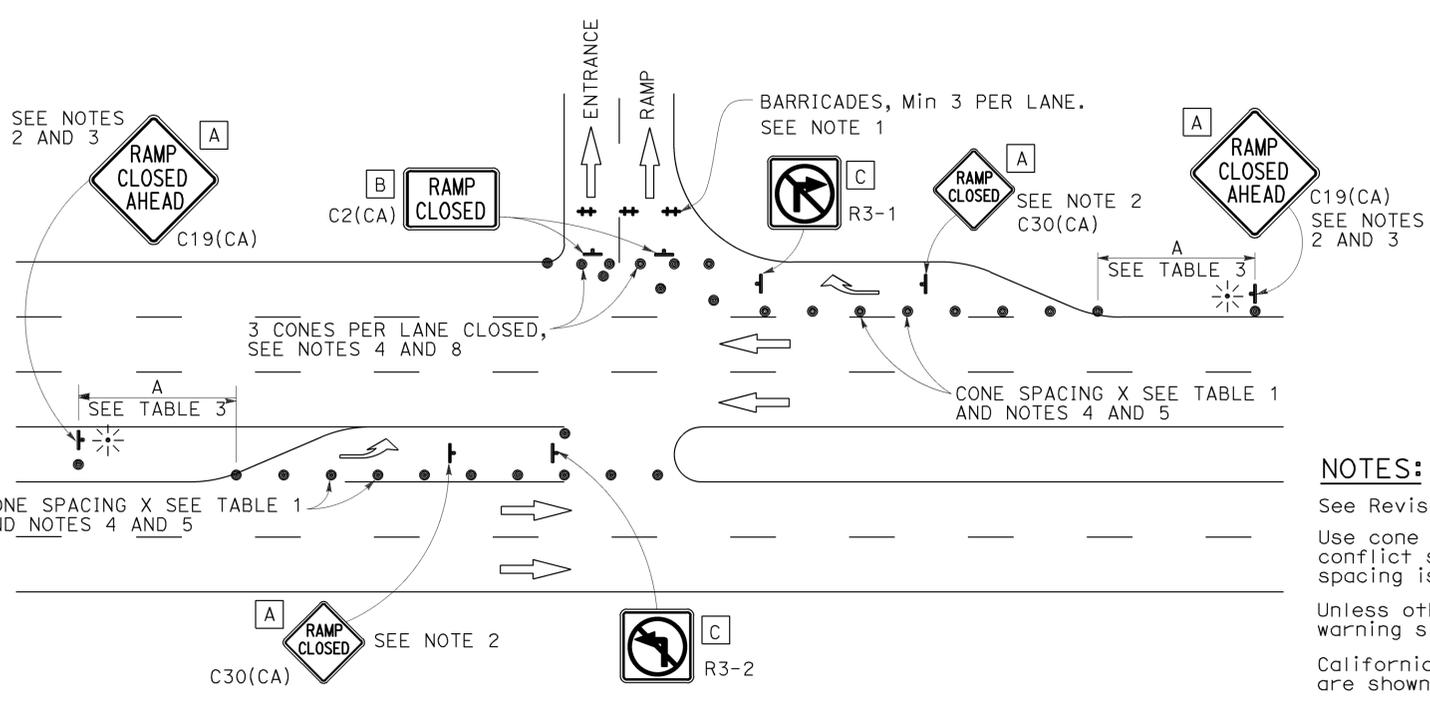

ENTRANCE RAMP WITH TURNING POCKETS

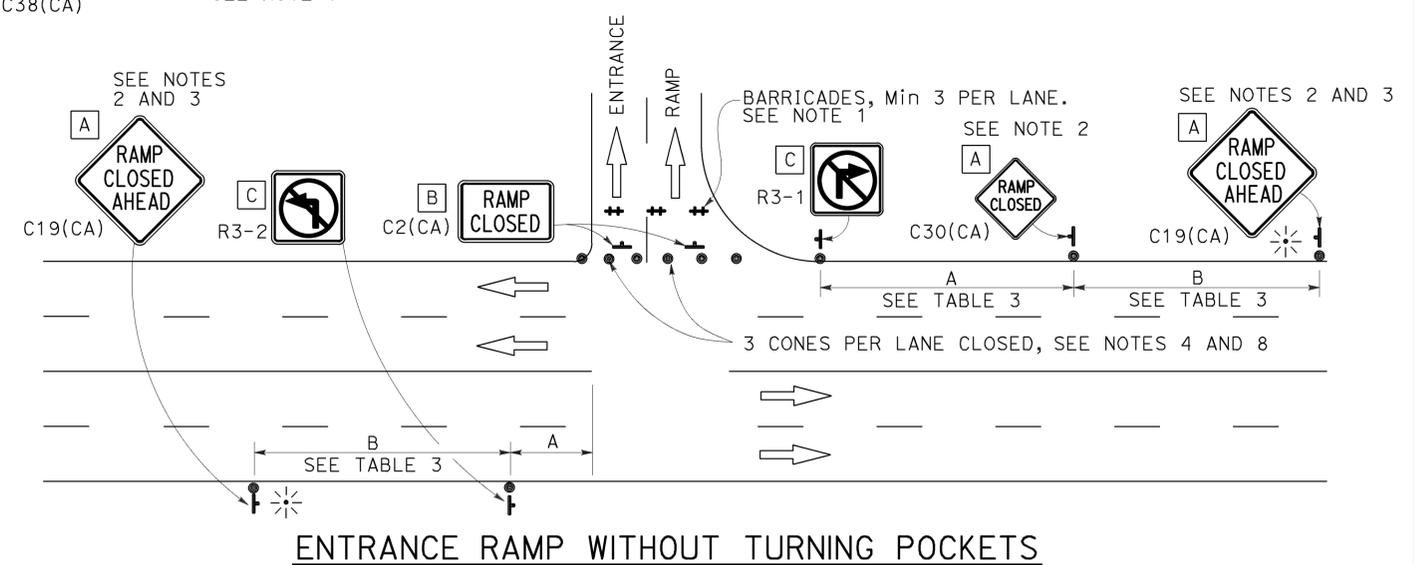

ENTRANCE RAMP WITHOUT TURNING POCKETS

## NOTES:


- See Revised Standard Plan RSP T9 for tables.
- Use cone spacing X for taper segment, Y for tangent segment or Z for conflict situations, as appropriate, per Table 1, unless X, Y, or Z cone spacing is shown on this sheet.
- Unless otherwise specified in the special provisions, all temporary warning signs shall have black legend on fluorescent orange background.
- California codes are designated by (CA). Otherwise, Federal (MUTCD) codes are shown.

STATE OF CALIFORNIA  
 DEPARTMENT OF TRANSPORTATION  
**TRAFFIC CONTROL SYSTEM  
 FOR RAMP CLOSURE**  
 NO SCALE


RSP T14 DATED APRIL 19, 2013 SUPERSEDES STANDARD PLAN T14 DATED MAY 20, 2011 - PAGE 242 OF THE STANDARD PLANS BOOK DATED 2010.

**REVISED STANDARD PLAN RSP T14**

2010 REVISED STANDARD PLAN RSP T14

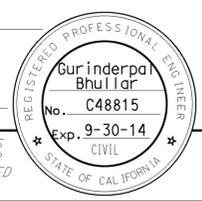

TO ACCOMPANY PLANS DATED 01-11-16

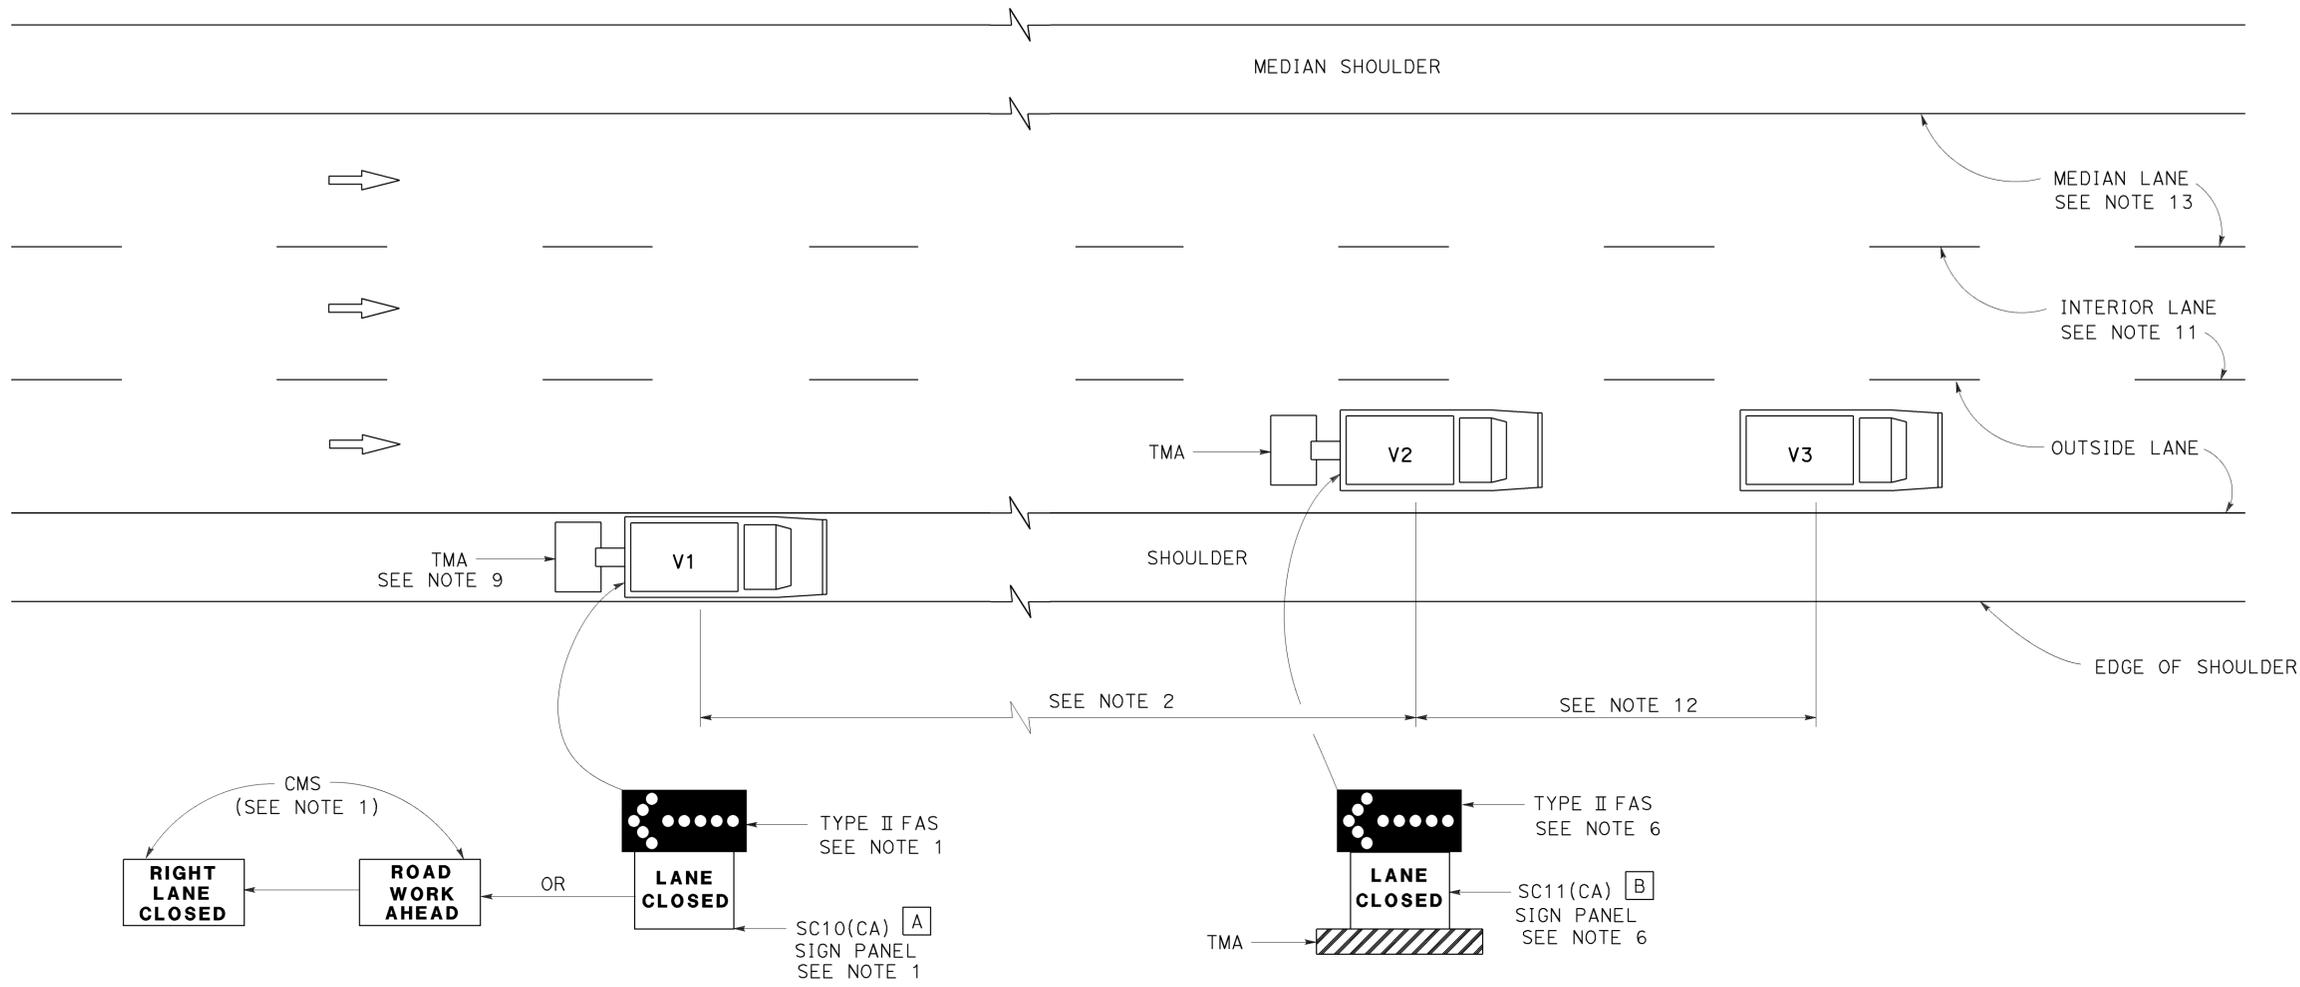

**SIGN PANEL SIZE (Min)**

- A 66" x 36"
- B 54" x 42"

**LEGEND**

- V1 SIGN VEHICLE
- V2 SHADOW VEHICLE
- V3 WORK/APPLICATION VEHICLE
- FLASHING ARROW SIGN (FAS)
- CMS CHANGEABLE MESSAGE SIGN
- TMA TRUCK-MOUNTED ATTENUATOR

**MOVING LANE CLOSURE ON MEDIAN LANE OR OUTSIDE LANE OF MULTILANE HIGHWAYS**

**NOTES:**

1. Either a changeable message sign or a SC10(CA) sign panel and a Type II flashing arrow sign shall be mounted on the rear of sign vehicle V1. The changeable message sign shall be sequenced to show the "ROAD WORK AHEAD" message first, followed by the "RIGHT LANE CLOSED" message. For median lane closure, the flashing arrow symbol shall be reversed with the arrowhead on the right and the changeable message sign shall show "LEFT LANE CLOSED".
2. If traffic queues develop, sign vehicle V1 should be positioned upstream from the end of queue. Sign vehicle V1 shall be positioned where highly visible when shoulders are not available.
3. A minimum sight distance of 1500' should be provided in advance of sign vehicle V1.
4. Sign vehicle V1 should remain at the beginning of horizontal or vertical curves until the other vehicles (V2 and V3) are far enough beyond the curve to resume the minimum sight distance of 1500'.
5. Vehicle-mounted sign panels shall have Type III or above retroreflective sheeting, black on white, or black on fluorescent orange, with 6" minimum series D letters per Caltrans sign specifications.
6. Shadow vehicle V2 shall be equipped with a truck-mounted attenuator. The sign panel shown and a Type II flashing arrow sign shall be mounted on the rear of shadow vehicle V2. For median lane closure the flashing arrow sign symbol shall be displayed with the arrowhead on the right.
7. All vehicles used for lane closures shall be equipped with two-way radios, and the vehicle operators shall maintain communication during the work or application operation.
8. All vehicles shall be equipped with flashing or rotating amber lights.
9. If sign vehicle V1 encroaches into the traffic lane due to insufficient shoulder width, sign vehicle V1 shall be equipped with a truck-mounted attenuator. Sign vehicle V1 shall stay as close to the edge of shoulder as practicable.
10. Where workers would be on foot in the work area, a stationary type lane closure (Revised Standard Plan T10, T11, etc., as applicable) shall be used instead of this plan.
11. For moving lane closure on interior lane of multilane highways, use Revised Standard Plan T16.
12. The spacing between work vehicle(s) and the shadow vehicles, and between each shadow vehicle should be minimized to deter road users from driving in between.
13. When the work/application vehicle V3 occupies the median lane, sign vehicle V1 should drive in the median shoulder and indicate left lane closed ahead.

STATE OF CALIFORNIA  
DEPARTMENT OF TRANSPORTATION

**TRAFFIC CONTROL SYSTEM FOR MOVING LANE CLOSURE ON MULTILANE HIGHWAYS**

NO SCALE

RSP T15 DATED APRIL 19, 2013 SUPERSEDES STANDARD PLAN T15 DATED MAY 20, 2011 - PAGE 243 OF THE STANDARD PLANS BOOK DATED 2010.

**REVISED STANDARD PLAN RSP T15**


2010 REVISED STANDARD PLAN RSP T15

Dist	COUNTY	ROUTE	POST MILES TOTAL PROJECT	SHEET No.	TOTAL SHEETS
11	SD	8,54,67,94, 125, etc.	Var	222	231

Registered Civil Engineer  
 April 19, 2013  
 PLANS APPROVAL DATE  
 THE STATE OF CALIFORNIA OR ITS OFFICERS OR AGENTS SHALL NOT BE RESPONSIBLE FOR THE ACCURACY OR COMPLETENESS OF SCANNED COPIES OF THIS PLAN SHEET.



TO ACCOMPANY PLANS DATED 01-11-16

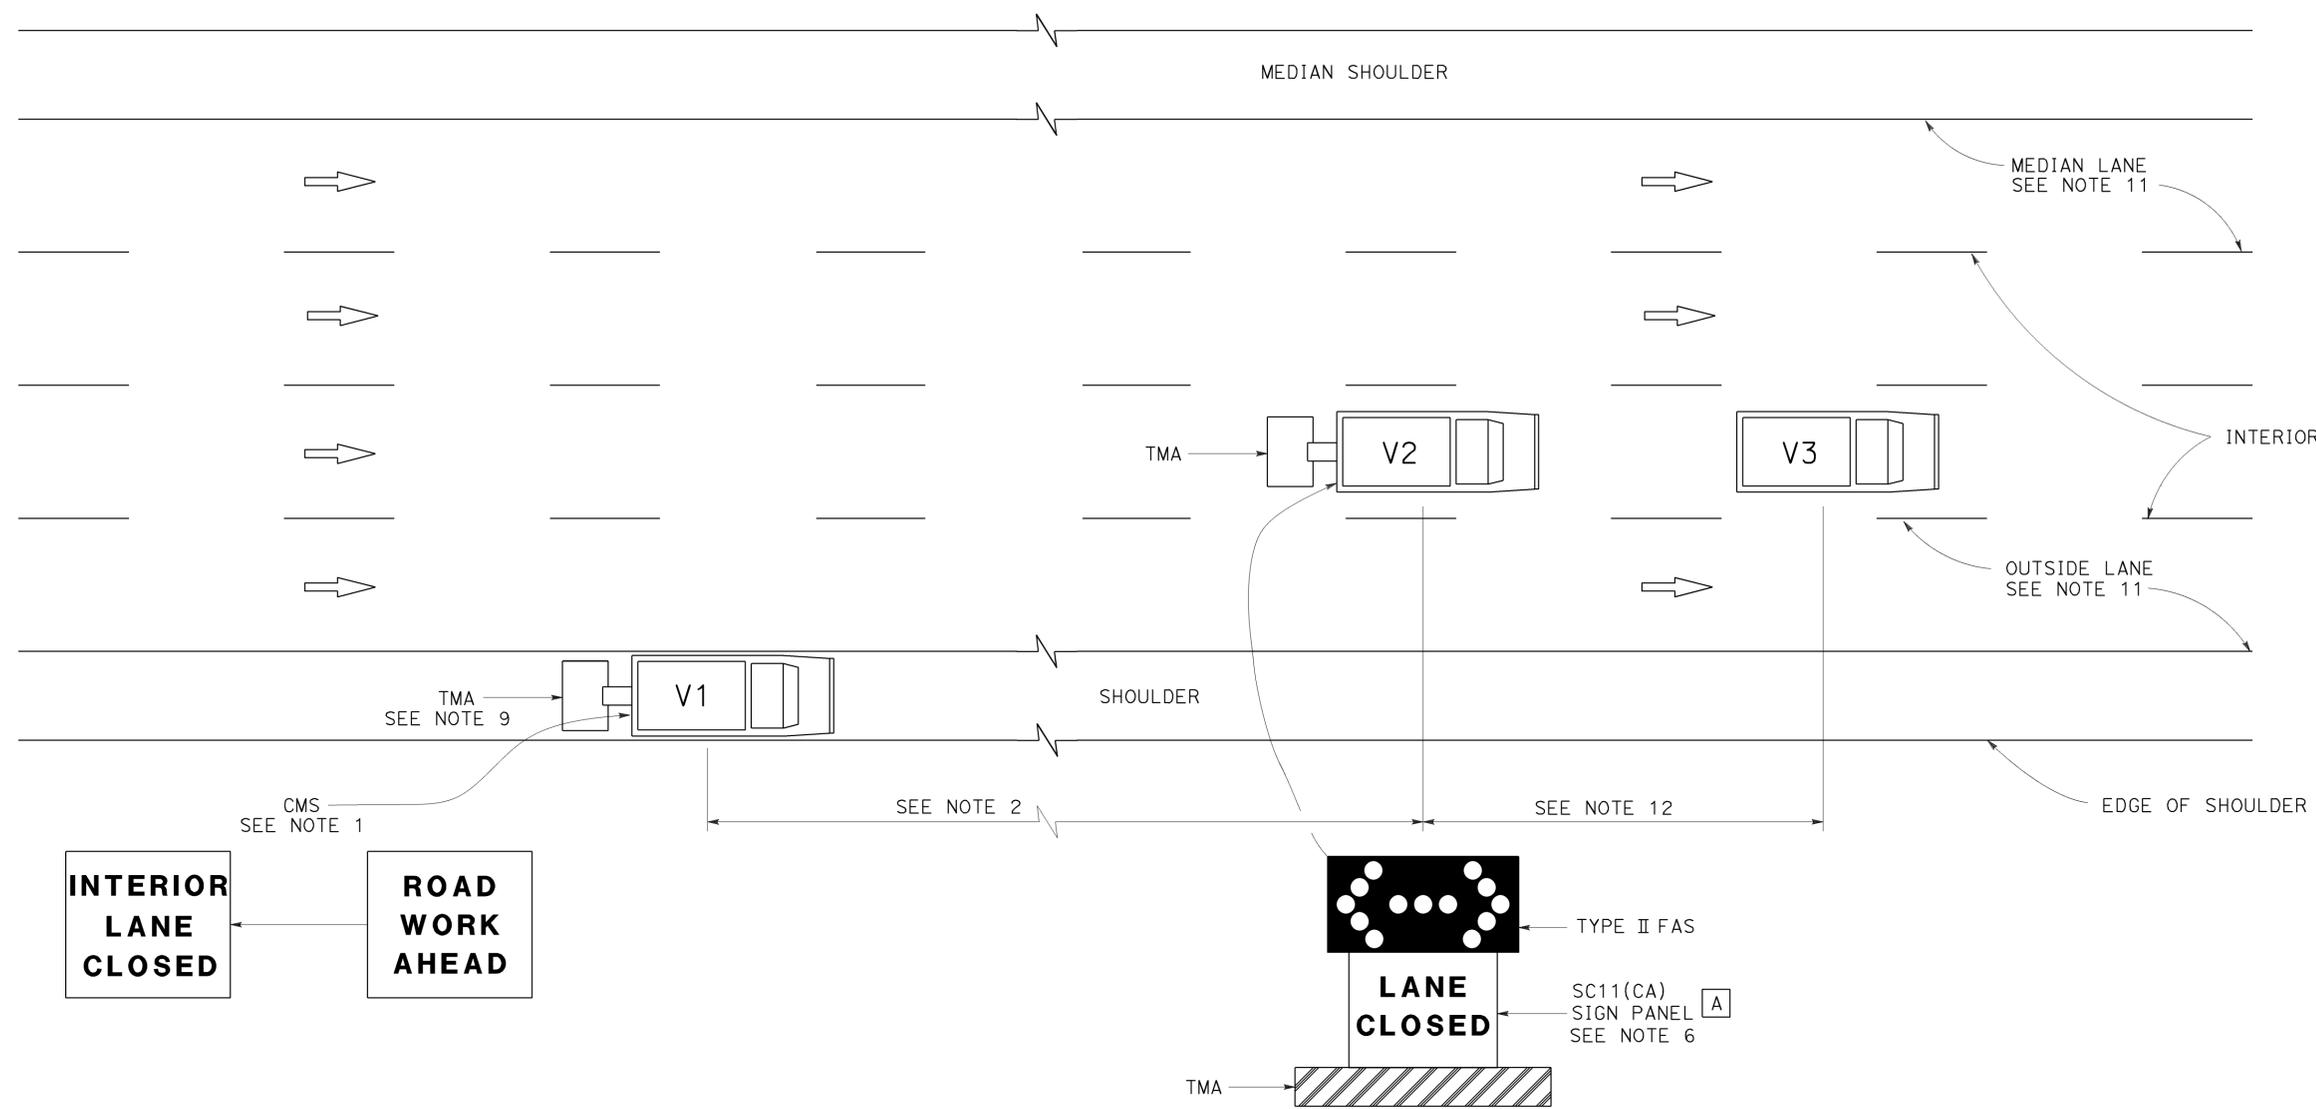

SIGN PANEL SIZE (Min)

A 54" x 42"

LEGEND

- V1 SIGN VEHICLE
- V2 SHADOW VEHICLE
- V3 WORK/APPLICATION VEHICLE
- FLASHING ARROW SIGN (FAS) IN FLASHING DOUBLE ARROW MODE
- CMS CHANGEABLE MESSAGE SIGN
- TMA TRUCK-MOUNTED ATTENUATOR

MOVING LANE CLOSURE ON INTERIOR LANE OF MULTILANE HIGHWAYS

NOTES:

1. A changeable message sign shall be mounted on the rear of sign vehicle V1. The changeable message sign shall be sequenced to show the "ROAD WORK AHEAD" message first, followed by the "INTERIOR LANE CLOSED" message. The message "CENTER LANE CLOSED" may be used in place of the "INTERIOR LANE CLOSED" message.
2. If traffic queues develop, sign vehicle V1 should be positioned upstream from the end of queue. Sign vehicle V1 shall be positioned where highly visible when shoulders are not available.
3. A minimum sight distance of 1500' should be provided in advance of sign vehicle V1.
4. Sign vehicle V1 should remain at the beginning of horizontal or vertical curves until the other vehicles (V2 and V3) are far enough beyond the curve to resume the minimum sight distance of 1500'.
5. Vehicle-mounted sign panels shall have Type III or above retroreflective sheeting, black on white, or black on fluorescent orange, with 6" minimum series D letters per Caltrans sign specifications.
6. Shadow vehicle V2 shall be equipped with a truck-mounted attenuator. The sign panel shown and a Type II flashing arrow sign shall be mounted on the rear of shadow vehicle V2.
7. All vehicles used for lane closures shall be equipped with two-way radios, and the vehicle operators shall maintain communication during the work or application operation.
8. All vehicles shall be equipped with flashing or rotating amber lights.
9. If sign vehicle V1 encroaches into the traffic lane due to insufficient shoulder width, sign vehicle V1 shall be equipped with a truck-mounted attenuator. Sign vehicle V1 shall stay as close to the edge of shoulder as practicable.
10. Where workers would be on foot in the work area, a stationary type lane closure (Revised Standard Plan T10, T11 etc., as applicable) shall be used instead of this plan.
11. For moving lane closure on median lane or outside lane of multilane highways, use Revised Standard Plan T15.
12. The spacing between work vehicle(s) and the shadow vehicles, and between each shadow vehicle should be minimized to deter road users from driving in between.

STATE OF CALIFORNIA  
 DEPARTMENT OF TRANSPORTATION  
**TRAFFIC CONTROL SYSTEM  
 FOR MOVING LANE CLOSURE  
 ON MULTILANE HIGHWAYS**

NO SCALE

RSP T16 DATED APRIL 19, 2013 SUPERSEDES STANDARD PLAN T16 DATED MAY 20, 2011 - PAGE 244 OF THE STANDARD PLANS BOOK DATED 2010.

**REVISED STANDARD PLAN RSP T16**

2010 REVISED STANDARD PLAN RSP T16

**LEGEND:**

<b>AB</b>	ABANDON. IF APPLIED TO CONDUIT, REMOVE CONDUCTORS
<b>BC</b>	INSTALL PULL BOX IN EXISTING CONDUIT RUN
<b>BP</b>	PEDESTRIAN BARRICADE, TYPE AS INDICATED ON PLAN
<b>CB</b>	INSTALL CONDUIT INTO EXISTING PULL BOX
<b>CC</b>	CONNECT NEW AND EXISTING CONDUIT. REMOVE EXISTING CONDUCTORS AND INSTALL CONDUCTORS AS INDICATED
<b>CF</b>	CONDUIT TO REMAIN FOR FUTURE USE. REMOVE CONDUCTORS. INSTALL PULL TAPE
<b>DH</b>	DETECTOR HANDHOLE
<b>FA</b>	FOUNDATION TO BE ABANDONED
<b>IS</b>	INSTALL SIGN ON SIGNAL MAST ARM
<b>NS</b>	NO SLIP BASE ON STANDARD
<b>PEC</b>	PHOTOELECTRIC CONTROL
<b>PEU</b>	PHOTOELECTRIC UNIT
<b>RC</b>	EQUIPMENT OR MATERIAL TO BE REMOVED AND BECOME THE PROPERTY OF THE CONTRACTOR
<b>RE</b>	REMOVE ELECTROLIER, FUSES AND BALLAST. TAPE ENDS OF CONDUCTORS
<b>RL</b>	RELOCATE EQUIPMENT
<b>RR</b>	REMOVE AND REUSE EQUIPMENT
<b>RS</b>	REMOVE AND SALVAGE EQUIPMENT
<b>SC</b>	SPLICE NEW TO EXISTING CONDUCTORS
<b>SD</b>	SERVICE DISCONNECT
<b>TSP</b>	TELEPHONE SERVICE POINT

**ABBREVIATIONS**

AC+	UNDERGROUNDED CONDUCTOR	MAT	MAST ARM MOUNTING TOP ATTACHMENT
APS	ACCESSIBLE PEDESTRIAN SIGNAL	MAS	MAST ARM MOUNTING SIDE ATTACHMENT
Batt	BATTERY	MBPS	MANUAL BYPASS SWITCH
BBS	BATTERY BACKUP SYSTEM	M/M	MULTIPLE TO MULTIPLE TRANSFORMER
BC	BOLT CIRCLE	Mtg	MOUNTING
BIK	BLACK	MV	MERCURY VAPOR LIGHTING FIXTURE
BP	BYPASS	MVDS	MICROWAVE VEHICLE DETECTION SYSTEM
BPB	BICYCLE PUSH BUTTON	N	NEUTRAL (GROUNDED CONDUCTOR)
C	CONDUIT	NB	NEUTRAL BUS
CB	CIRCUIT BREAKER	NC	NORMALLY CLOSE
CCTV	CLOSED CIRCUIT TELEVISION	NO	NORMALLY OPEN
Ckt	CIRCUIT	P	CIRCUIT BREAKER'S POLE
CMS	CHANGEABLE MESSAGE SIGN	PB	PULL BOX
Ctid	CALTRANS IDENTIFICATION	PBA	PUSH BUTTON ASSEMBLY
Comm	COMMUNICATION	PEC	PHOTOELECTRIC CONTROL
Cn+I	CONTROL	Ped	PEDESTRIAN
DF	DEPARTMENT-FURNISHED	PEU	PHOTOELECTRIC UNIT
DLC	LOOP DETECTOR LEAD-IN CABLE	PT	CONDUIT WITH PULL TAPE
EMS	EXTINGUISHABLE MESSAGE SIGN	PTR	POWER TRANSFER RELAY
EVUC	EMERGENCY VEHICLE UNIT CABLE	RE	RELOCATED EQUIPMENT
EVUD	EMERGENCY VEHICLE UNIT DETECTOR	RM	RAMP METERING
FB	FLASHING BEACON	RWIS	ROADSIDE WEATHER INFORMATION SYSTEM
FBCA	FLASHING BEACON CONTROL ASSEMBLY	SB	SLIP BASE
FBS	FLASHING BEACON WITH SLIP BASE	SIC	SIGNAL INTERCONNECT CABLE
FO	FIBER OPTIC	Sig	SIGNAL
G	EQUIPMENT GROUNDING CONDUCTOR	SMA	SIGNAL MAST ARM
GB	GROUND BUS	SNS	STREET NAME SIGN
GFCI	GROUND FAULT CIRCUIT INTERRUPTER	SP	SERVICE POINT
Grn	GREEN	TB	TERMINAL BOARD
HAR	HIGHWAY ADVISORY RADIO	TDC	TELEPHONE DEMARCATION CABINET
Hex	HEXAGONAL	Temp	TEMPERATURE
HPS	HIGH PRESSURE SODIUM	TMS	TRAFFIC MONITORING STATION
IISNS	INTERNALLY ILLUMINATED STREET NAME SIGN	TOS	TRAFFIC OPERATIONS SYSTEM
ISL	INDUCTION SIGN LIGHTING	UPS	UNINTERRUPTABLE POWER SUPPLY
LED	LIGHT EMITTING DIODE	UPSC	UNINTERRUPTABLE POWER SUPPLY CONTROLLER
LMA	LUMINAIRE MAST ARM	Veh	VEHICLE
LPS	LOW PRESSURE SODIUM	VIVDS	VIDEO IMAGE VEHICLE DETECTION SYSTEM
Ltg	LIGHTING	Wh+	WHITE
Lum	LUMINAIRE	WIM	WEIGH-IN-MOTION
M	METERED	Xfmr	TRANSFORMER

Dist	COUNTY	ROUTE	POST MILES TOTAL PROJECT	SHEET No.	TOTAL SHEETS
11	SD	8,54,67,94, 125, etc.	Var	223	231

*Theresa Gabriel*  
 REGISTERED ELECTRICAL ENGINEER  
 October 30, 2015  
 PLANS APPROVAL DATE

Theresa  
 Aziz Gabriel  
 No. E15129  
 Exp. 6-30-16  
 ELECTRICAL  
 STATE OF CALIFORNIA

THE STATE OF CALIFORNIA OR ITS OFFICERS OR AGENTS SHALL NOT BE RESPONSIBLE FOR THE ACCURACY OR COMPLETENESS OF SCANNED COPIES OF THIS PLAN SHEET.

TO ACCOMPANY PLANS DATED 01-11-16

**SOFFIT AND WALL-MOUNTED LUMINAIRES**

- PENDANT SOFFIT LUMINAIRE, 70 W HPS UNLESS OTHERWISE SPECIFIED
- FLUSH-MOUNTED SOFFIT LUMINAIRE, 70 W HPS UNLESS OTHERWISE SPECIFIED
- WALL-MOUNTED LUMINAIRE, 70 W HPS UNLESS OTHERWISE SPECIFIED
- EXISTING SOFFIT OR WALL-MOUNTED LUMINAIRE TO REMAIN UNMODIFIED
- EXISTING SOFFIT OR WALL-MOUNTED LUMINAIRE TO BE MODIFIED AS SPECIFIED

**NOTE:**  
 Arrow indicates "street side" of luminaire.

COMMONLY USED SYMBOLS FOR UNITED STATES CUSTOMARY UNITS OF MEASUREMENT:

SYMBOL	DEFINITIONS
Ω	OHMS
min	MINUTE
s	SECOND
bps	BITS PER SECOND
Bps	BYTES PER SECOND
A	AMPERE
V	VOLT
V(dc)	VOLT (DIRECT CURRENT)
V(ac)	VOLT (ALTERNATING CURRENT)
FC	FOOT - CANDLE
W	WATTS
VA	VOLT-AMPERE
M	MEGA
k	KILO
m	MILLI
μ	MICRO
P	PICO
Hz	HERTZ

**MISCELLANEOUS ELECTROLIERS**

NEW	EXISTING	
		LUMINAIRE ON WOOD POLE
		NON-STANDARD ELECTROLIER (SEE PROJECT LEGEND)
		CITY ELECTROLIER
		ELECTROLIER FOUNDATION (FUTURE INSTALLATION)

- NOTES:**
- LED luminaires shall be 235 W when installed on Type 21, 21D, 30, 31 and 32 Standards, unless otherwise specified. LED luminaires shall be 165 W when installed on other type standards or poles, unless otherwise specified.
  - Luminaires shall be the cutoff type, ANSI Type III medium cutoff lighting distribution, unless otherwise specified.

**STANDARD ELECTROLIER**

NEW	EXISTING	STANDARD TYPE
		15
		15D
		15 STRUCTURE
		15D STRUCTURE
		21
		21D
		21 STRUCTURE
		21D STRUCTURE
		30
		31
		32

STATE OF CALIFORNIA  
 DEPARTMENT OF TRANSPORTATION

**ELECTRICAL SYSTEMS (LEGEND AND ABBREVIATIONS)**

NO SCALE


RSP ES-1A DATED OCTOBER 30, 2015 SUPERSEDES RSP ES-1A DATED JULY 19, 2013 AND STANDARD PLAN ES-1A DATED MAY 20, 2011 - PAGE 425 OF THE STANDARD PLANS BOOK DATED 2010.

**REVISED STANDARD PLAN RSP ES-1A**

2010 REVISED STANDARD PLAN RSP ES-1A

Dist	COUNTY	ROUTE	POST MILES TOTAL PROJECT	SHEET No.	TOTAL SHEETS
11	SD	8,54,67,94, 125, etc.	Var	224	231

Theresa Gabriel  
 REGISTERED ELECTRICAL ENGINEER  
 October 30, 2015  
 PLANS APPROVAL DATE  
THE STATE OF CALIFORNIA OR ITS OFFICERS OR AGENTS SHALL NOT BE RESPONSIBLE FOR THE ACCURACY OR COMPLETENESS OF SCANNED COPIES OF THIS PLAN SHEET.

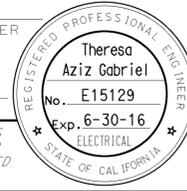

TO ACCOMPANY PLANS DATED 01-11-16

**CONDUIT**

NEW	EXISTING	
---	---	LIGHTING CONDUIT, UNLESS OTHERWISE INDICATED OR NOTED
---	---	TRAFFIC SIGNAL CONDUIT
---C---	---c---	COMMUNICATION CONDUIT
---T---	---t---	TELEPHONE CONDUIT
---F---	---f---	FIRE ALARM CONDUIT
---FO---	---fo---	FIBER OPTIC CONDUIT
---	---	CONDUIT TERMINATION
		CONDUIT RISER ATTACHED TO THE STRUCTURE OR SERVICE POLE

 
**SIGNAL EQUIPMENT**

NEW	EXISTING	
		PEDESTRIAN SIGNAL HEAD
		PUSH BUTTON ASSEMBLY POST
		PEDESTRIAN BARRICADE
		VEHICLE SIGNAL HEAD (WITH BACKPLATE AND 3-SECTIONS: RED, YELLOW AND GREEN)
		VEHICLE SIGNAL HEAD WITH ANGLE VISOR
		MODIFICATIONS OF BASIC SYMBOL: "L" INDICATES ALL NON-ARROW SECTIONS LOUVERED "LG" INDICATES LOUVERED GREEN SECTION ONLY "PV" INDICATES ALL 12" SECTIONS PROGRAMMED VISIBILITY "8" INDICATES ALL 8" SECTIONS (ONLY WHEN SPECIFIED)
		VEHICLE SIGNAL HEAD CONSISTING OF RED, YELLOW AND GREEN LEFT ARROW SECTIONS
		VEHICLE SIGNAL HEAD CONSISTING OF RED AND YELLOW SECTIONS WITH AN UP GREEN ARROW SECTION
		VEHICLE SIGNAL HEAD (5 SECTION) CONSISTING OF RED, YELLOW AND GREEN SECTIONS WITH YELLOW AND GREEN RIGHT ARROW SECTIONS
		TYPE 15TS STANDARD WITH VEHICLE SIGNAL HEAD AND LUMINAIRE
		TYPE 21TS STANDARD WITH VEHICLE SIGNAL HEAD AND LUMINAIRE
		STANDARD WITH LUMINAIRE AND SIGNAL MAST ARMS AND ATTACHED VEHICLE SIGNAL HEADS
		TYPE 1 STANDARD WITH ATTACHED VEHICLE SIGNAL HEADS
		STANDARD WITH A SIGNAL MAST ARM, ATTACHED VEHICLE SIGNAL HEADS AND INTERNALLY ILLUMINATED STREET NAME SIGN
		CONTROLLER ASSEMBLY. DOOR INDICATES FRONT OF CABINET

**SERVICE EQUIPMENT**

NEW	EXISTING	
---OH---	---oh---	OVERHEAD LINES
		WOOD POLE, "U" INDICATES UTILITY OWNED
		POLE GUY WITH ANCHOR
		UTILITY TRANSFORMER - GROUND MOUNTED
		SERVICE EQUIPMENT ENCLOSURE TYPE. DOOR INDICATES FRONT OF ENCLOSURE
		TELEPHONE DEMARCATION CABINET

**POLE-MOUNTED SERVICE DESIGNATION**



**FLASHING BEACON**

NEW	EXISTING	
		FLASHING BEACON (ONE VEHICLE SIGNAL HEAD WITH BACKPLATE AND VISOR) "R" INDICATES RED INDICATION, "Y" INDICATES YELLOW INDICATION
		FLASHING BEACON WITH TYPE 15-FBS STANDARD AND A SIGN.
		FLASHING BEACON WITH TYPES 9, 9A OR 9B SIGN UNLESS OTHERWISE SPECIFIED OR INDICATED

**SIGNAL EQUIPMENT Cont**

NEW	EXISTING	
		GUARD POST
		TYPE 1 STANDARD WITH RAMP METERING SIGN
		OPTICAL DETECTOR FOR THE EMERGENCY VEHICLE DETECTION

**NOTES:**

- All signal sections shall be 12" unless shown otherwise.
- Signal heads shall be provided with backplates unless shown otherwise.

**ILLUMINATED OVERHEAD SIGN**

NEW	EXISTING	
		SINGLE POST, SINGLE ILLUMINATED SIGN, BALANCED BUTTERFLY
		SINGLE POST, DOUBLE ILLUMINATED SIGN, BALANCED BUTTERFLY
		SINGLE POST, SINGLE ILLUMINATED SIGN, FULL CANTILEVER
		DOUBLE POST, SINGLE ILLUMINATED SIGN
		SINGLE ILLUMINATED SIGN MOUNTED ON STRUCTURE
		DOUBLE POST, SINGLE ILLUMINATED SIGN WITH ELECTROLIER

STATE OF CALIFORNIA  
DEPARTMENT OF TRANSPORTATION


**ELECTRICAL SYSTEMS  
(LEGEND AND ABBREVIATIONS)**

NO SCALE

RSP ES-1B DATED OCTOBER 30, 2015 SUPERSEDES RSP ES-1B DATED JULY 19, 2013 AND STANDARD PLAN ES-1B DATED MAY 20, 2011 - PAGE 426 OF THE STANDARD PLANS BOOK DATED 2010.

**REVISED STANDARD PLAN RSP ES-1B**


2010 REVISED STANDARD PLAN RSP ES-1B

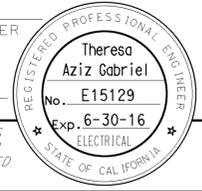


TO ACCOMPANY PLANS DATED 01-11-16

### EQUIPMENT IDENTIFICATION


#### ILLUMINATED SIGN IDENTIFICATION NUMBER:

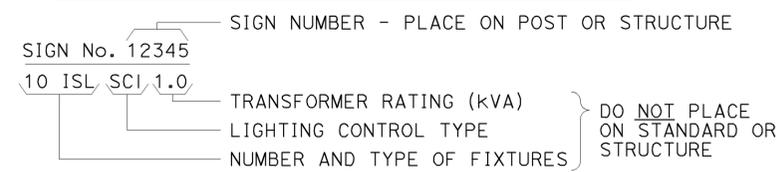


#### ELECTROLIER OR EQUIPMENT IDENTIFICATION NUMBER:

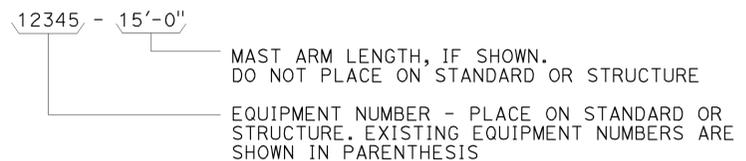


#### CONDUIT AND CONDUCTOR IDENTIFICATION:

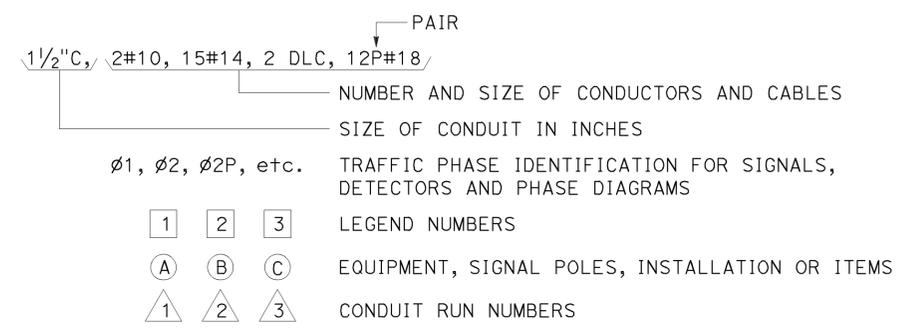


#### SIGNAL AND LIGHTING STANDARD (TYPICAL DESIGNATION):

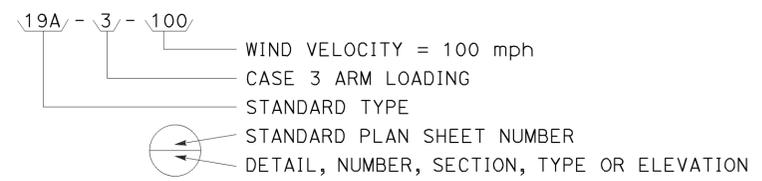


### MISCELLANEOUS EQUIPMENT

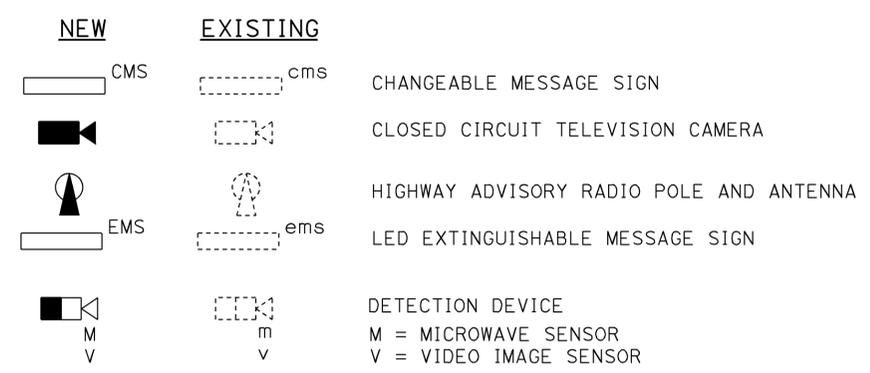



### WIRING DIAGRAM LEGEND

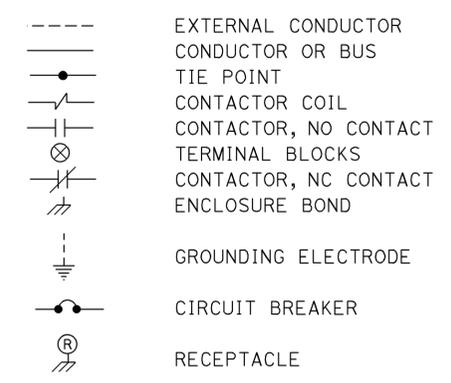

### PULL BOXES

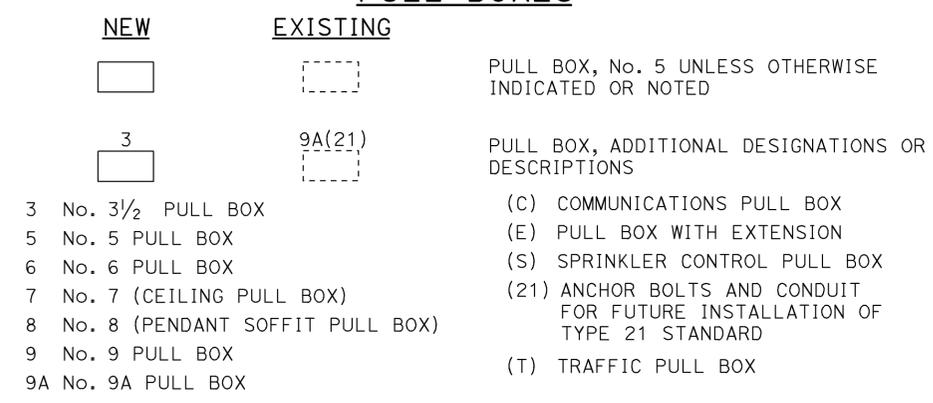

### VEHICLE DETECTORS

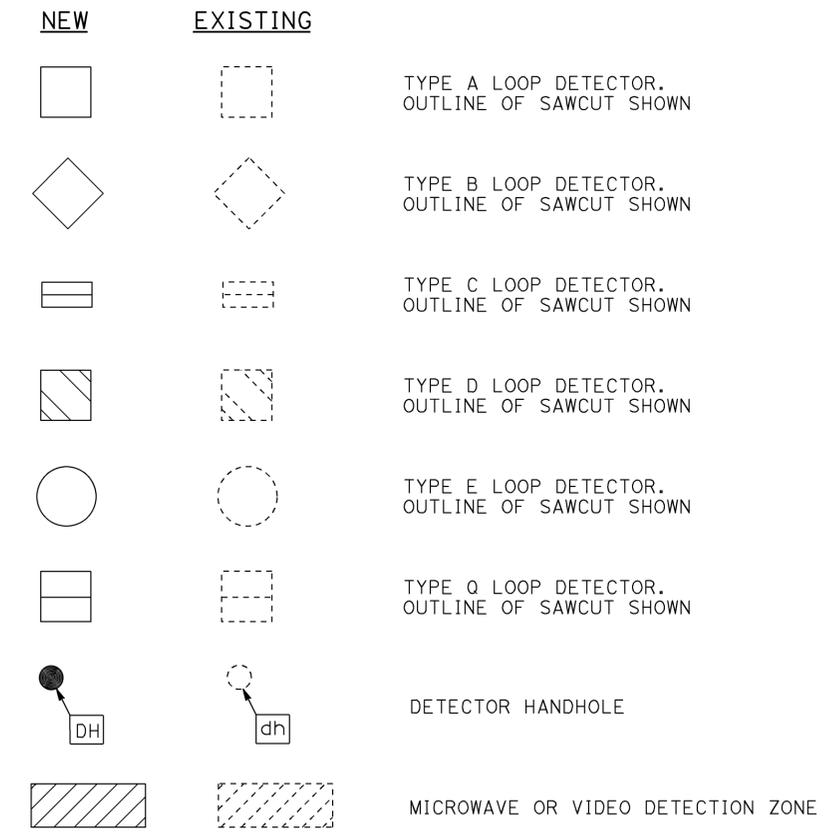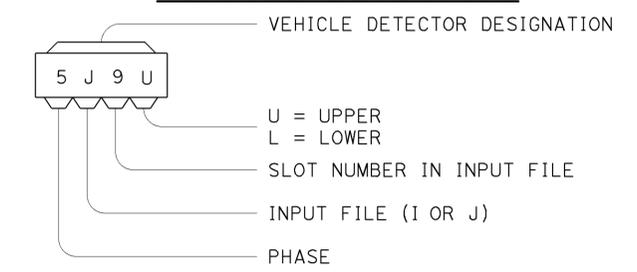

STATE OF CALIFORNIA  
DEPARTMENT OF TRANSPORTATION

## ELECTRICAL SYSTEMS (LEGEND AND ABBREVIATIONS)

NO SCALE

RSP ES-1C DATED OCTOBER 30, 2015 SUPERSEDES RSP ES-1C DATED JULY 19, 2013 AND STANDARD PLAN ES-1C DATED MAY 20, 2011 - PAGE 427 OF THE STANDARD PLANS BOOK DATED 2010.

2010 REVISED STANDARD PLAN RSP ES-1C

Dist	COUNTY	ROUTE	POST MILES TOTAL PROJECT	SHEET No.	TOTAL SHEETS
11	SD	8,54,67,94, 125, etc.	Var	226	231


Theresa Gabriel  
REGISTERED ELECTRICAL ENGINEER

October 30, 2015  
PLANS APPROVAL DATE

Theresa Aziz Gabriel  
REGISTERED PROFESSIONAL ENGINEER  
No. E15129  
Exp. 6-30-16  
ELECTRICAL  
STATE OF CALIFORNIA


THE STATE OF CALIFORNIA OR ITS OFFICERS OR AGENTS SHALL NOT BE RESPONSIBLE FOR THE ACCURACY OR COMPLETENESS OF SCANNED COPIES OF THIS PLAN SHEET.

TO ACCOMPANY PLANS DATED 01-11-16

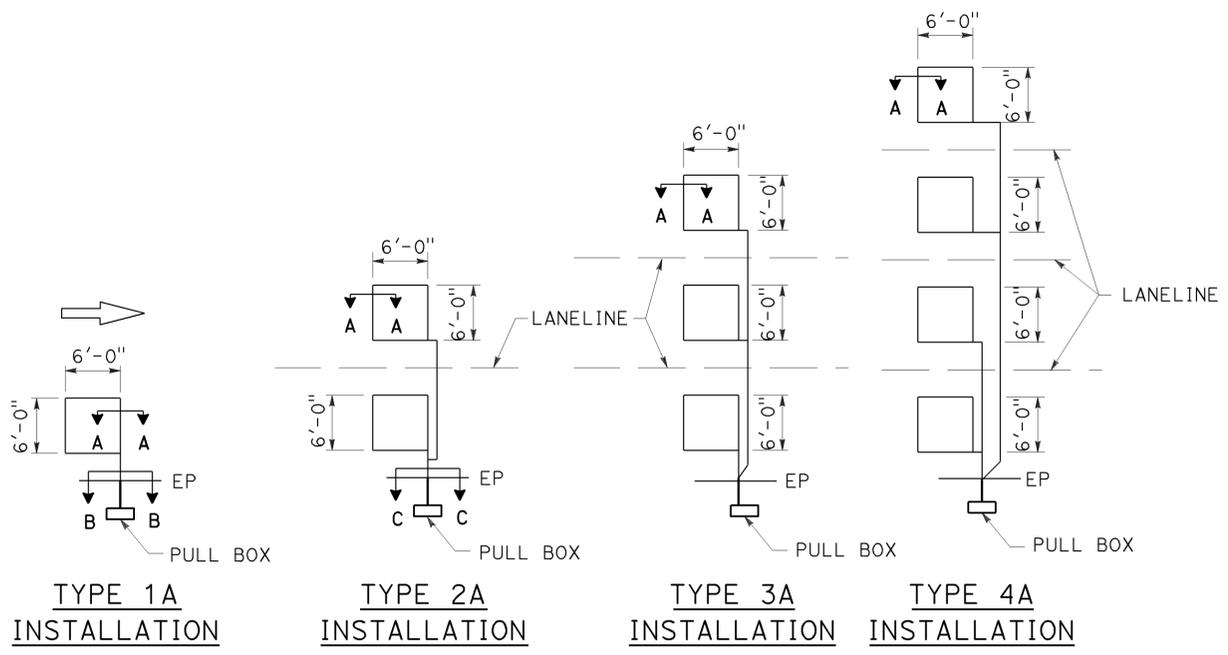


**SAWCUT DETAILS**

- Type A loop detector configurations illustrated
- 1A thru 4A = 1 Type A loop configuration in each lane.
  - 1B thru 4B = 1 Type B loop configuration in each lane.
  - 1C = 1 Type C loop configuration entering lanes as required.
  - 1D thru 4D = 1 Type D loop configuration in each lane.
  - 1E thru 4E = 1 Type E loop configuration in each lane.
  - 1Q thru 4Q = 1 Type Q loop configuration in each lane.
- Use Type A, B, C, D, E or Q loop detector configurations only when specified or shown on plans.

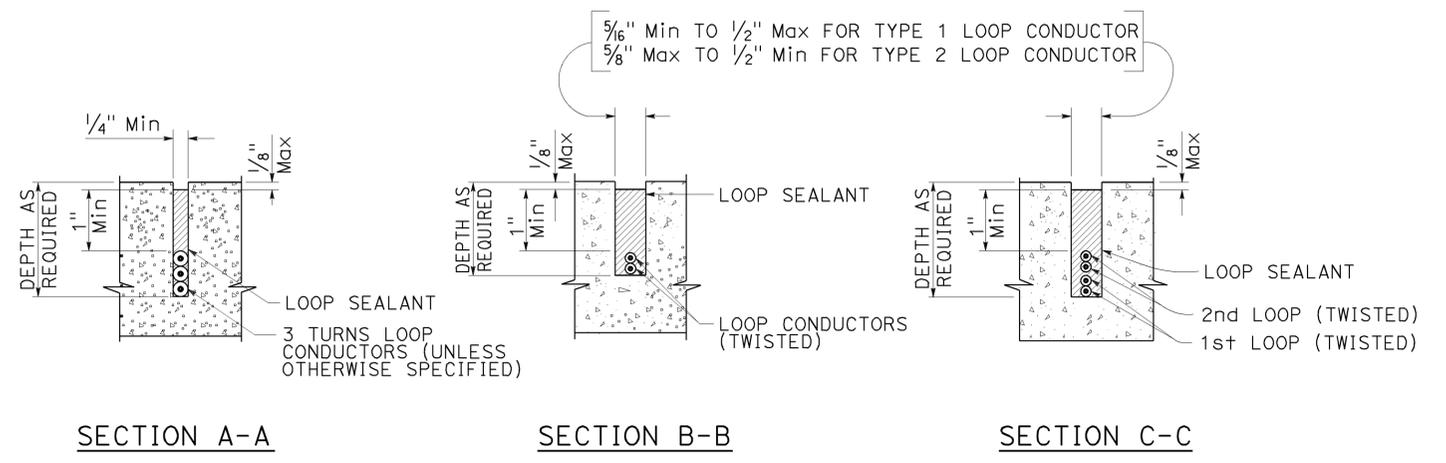


**SLOT DETAILS - TYPE 1 AND TYPE 2 LOOP CONDUCTOR**

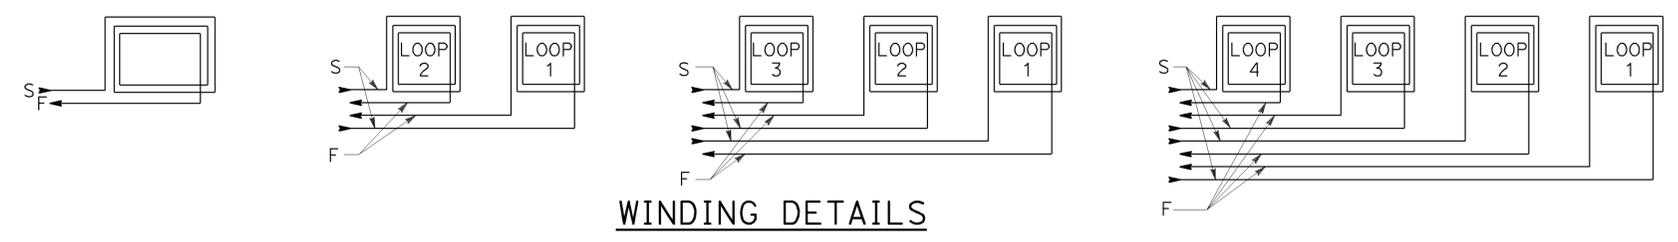

**WINDING DETAILS**

**ABBREVIATIONS:**  
S - START  
F - FINISH

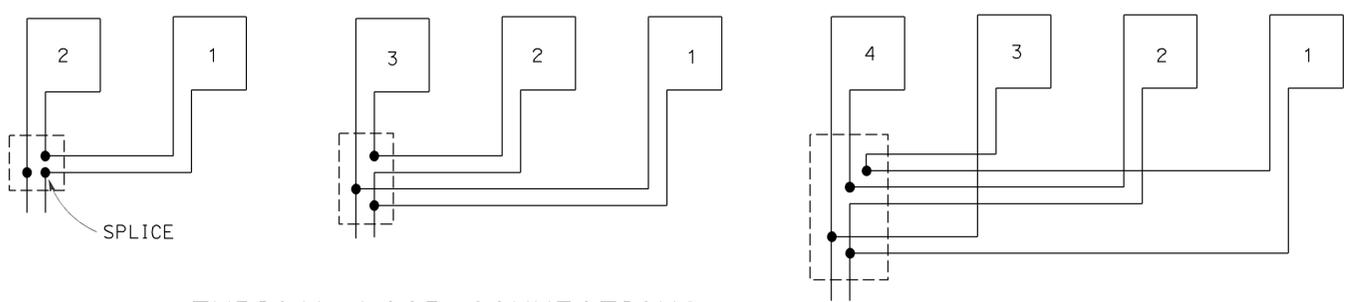

**TYPICAL LOOP CONNECTIONS**

Dashed lines represent the pull box

STATE OF CALIFORNIA  
DEPARTMENT OF TRANSPORTATION  
**ELECTRICAL SYSTEMS  
(LOOP DETECTORS)**  
NO SCALE

RSP ES-5A DATED OCTOBER 30, 2015 SUPERSEDES STANDARD PLAN ES-5A DATED MAY 20, 2011 - PAGE 448 OF THE STANDARD PLANS BOOK DATED 2010.

**REVISED STANDARD PLAN RSP ES-5A**

2010 REVISED STANDARD PLAN RSP ES-5A

Dist	COUNTY	ROUTE	POST MILES TOTAL PROJECT	SHEET No.	TOTAL SHEETS
11	SD	8,54,67,94, 125, etc.	Var	227	231


Theresa Gabriel  
REGISTERED ELECTRICAL ENGINEER

October 30, 2015  
PLANS APPROVAL DATE


Theresa Aziz Gabriel  
REGISTERED PROFESSIONAL ENGINEER  
No. E15129  
Exp. 6-30-16  
ELECTRICAL  
STATE OF CALIFORNIA

THE STATE OF CALIFORNIA OR ITS OFFICERS OR AGENTS SHALL NOT BE RESPONSIBLE FOR THE ACCURACY OR COMPLETENESS OF SCANNED COPIES OF THIS PLAN SHEET.


TO ACCOMPANY PLANS DATED 01-11-16

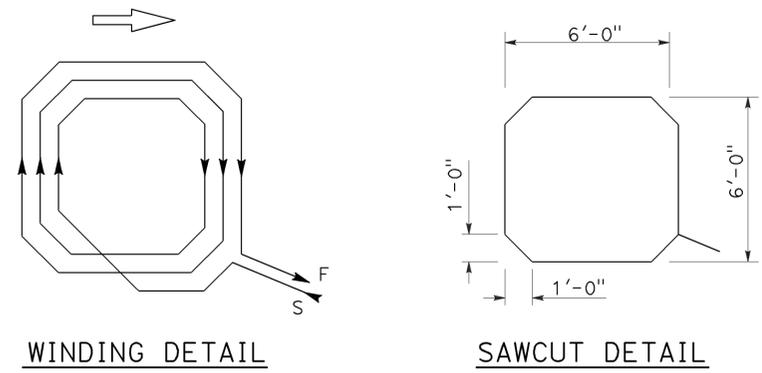


WINDING DETAIL  
SAWCUT DETAIL  
TYPE A LOOP DETECTOR CONFIGURATION

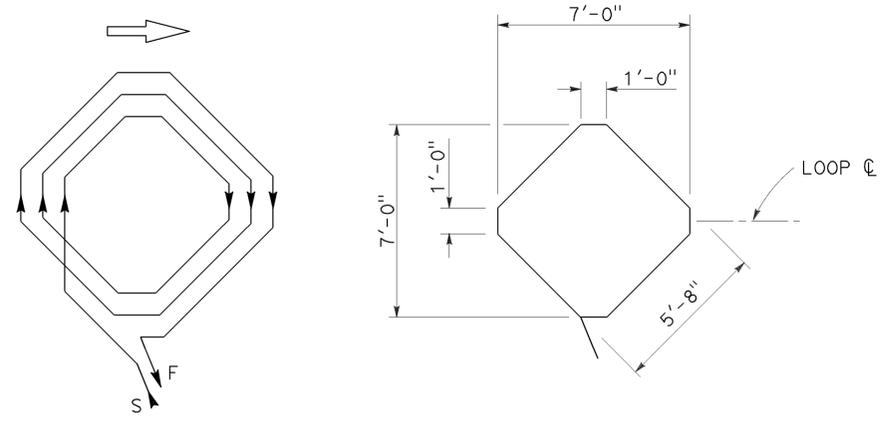


WINDING DETAIL  
SAWCUT DETAIL  
TYPE B LOOP DETECTOR CONFIGURATION

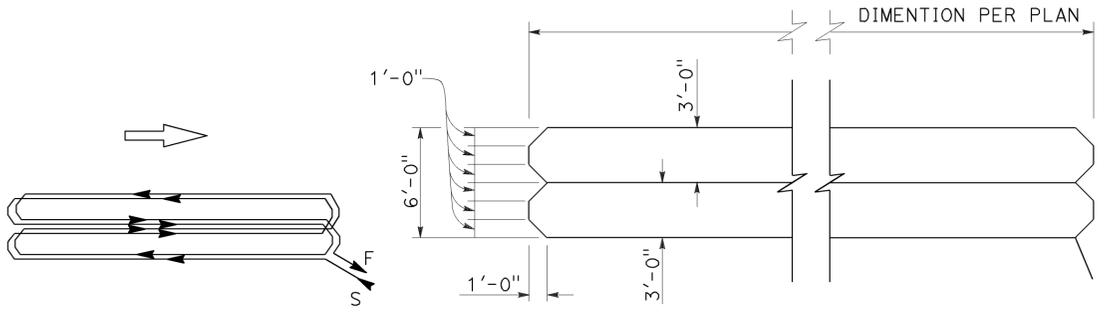


WINDING DETAIL  
SAWCUT DETAIL  
TYPE C LOOP DETECTOR CONFIGURATION

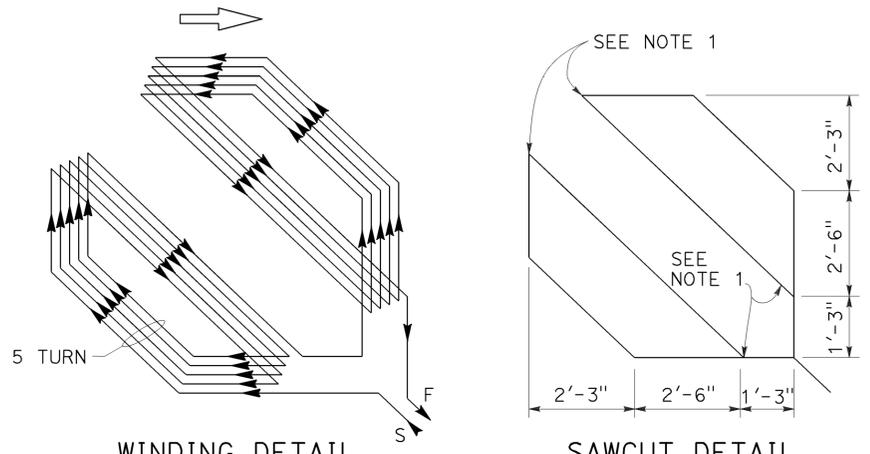


WINDING DETAIL  
SAWCUT DETAIL  
TYPE D LOOP DETECTOR CONFIGURATION

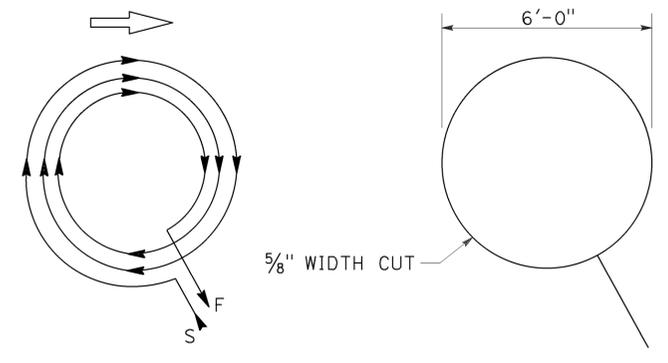

WINDING DETAIL  
SAWCUT DETAIL  
TYPE E LOOP DETECTOR CONFIGURATION

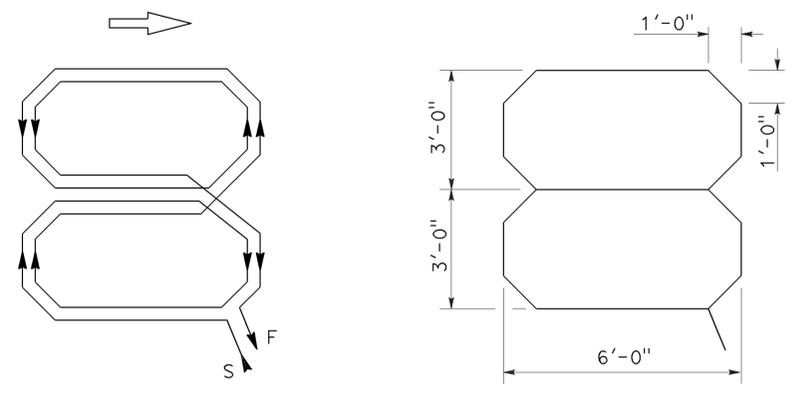

WINDING DETAIL  
SAWCUT DETAIL  
TYPE Q LOOP DETECTOR CONFIGURATION

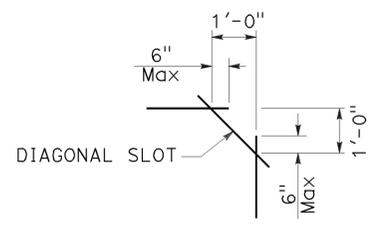

PLAN VIEW OF DIAGONAL SLOT AT CORNERS

- NOTES:**
1. Round corners of acute angle sawcuts to prevent damage to conductors.
  2. Typical distance separating loops from edge to edge is 10' for Type A, B, D and E installation in single lane.
  3. Use Type D loops for limit line detector installations in left turn and bicycle lanes.

STATE OF CALIFORNIA  
DEPARTMENT OF TRANSPORTATION  
**ELECTRICAL SYSTEMS (DETECTORS)**  
NO SCALE

RSP ES-5B DATED OCTOBER 30, 2015 SUPERSEDES RSP ES-5B DATED JULY 19, 2013 AND STANDARD PLAN ES-5B DATED MAY 20, 2011 - PAGE 449 OF THE STANDARD PLANS BOOK DATED 2010.

**REVISED STANDARD PLAN RSP ES-5B**

2010 REVISED STANDARD PLAN RSP ES-5B

Dist	COUNTY	ROUTE	POST MILES TOTAL PROJECT	SHEET No.	TOTAL SHEETS
11	SD	8,54,67,94, 125, etc.	Var	228	231


Theresa Gabriel  
REGISTERED ELECTRICAL ENGINEER

October 30, 2015  
PLANS APPROVAL DATE


Theresa Aziz Gabriel  
No. E15129  
Exp. 6-30-16  
ELECTRICAL  
STATE OF CALIFORNIA

THE STATE OF CALIFORNIA OR ITS OFFICERS OR AGENTS SHALL NOT BE RESPONSIBLE FOR THE ACCURACY OR COMPLETENESS OF SCANNED COPIES OF THIS PLAN SHEET.

TO ACCOMPANY PLANS DATED 01-11-16

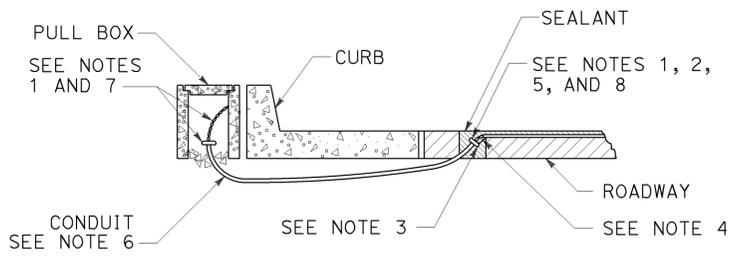


**TYPE A  
CURB TERMINATION DETAIL**

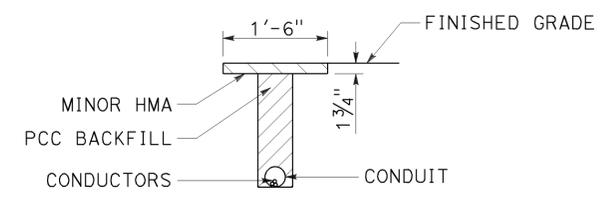


**"T" TRENCH  
DETAIL T**


5/16" x 1 1/2" SCREW (BRASS, STAINLESS STEEL OR OTHER NON-CORRODING MATERIAL)

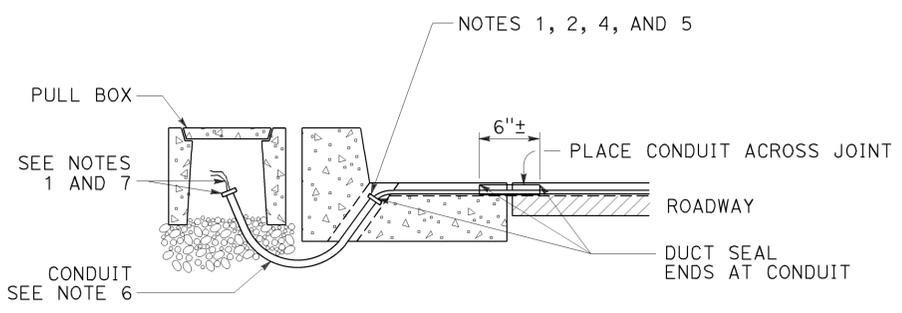

**CROSS SECTION**

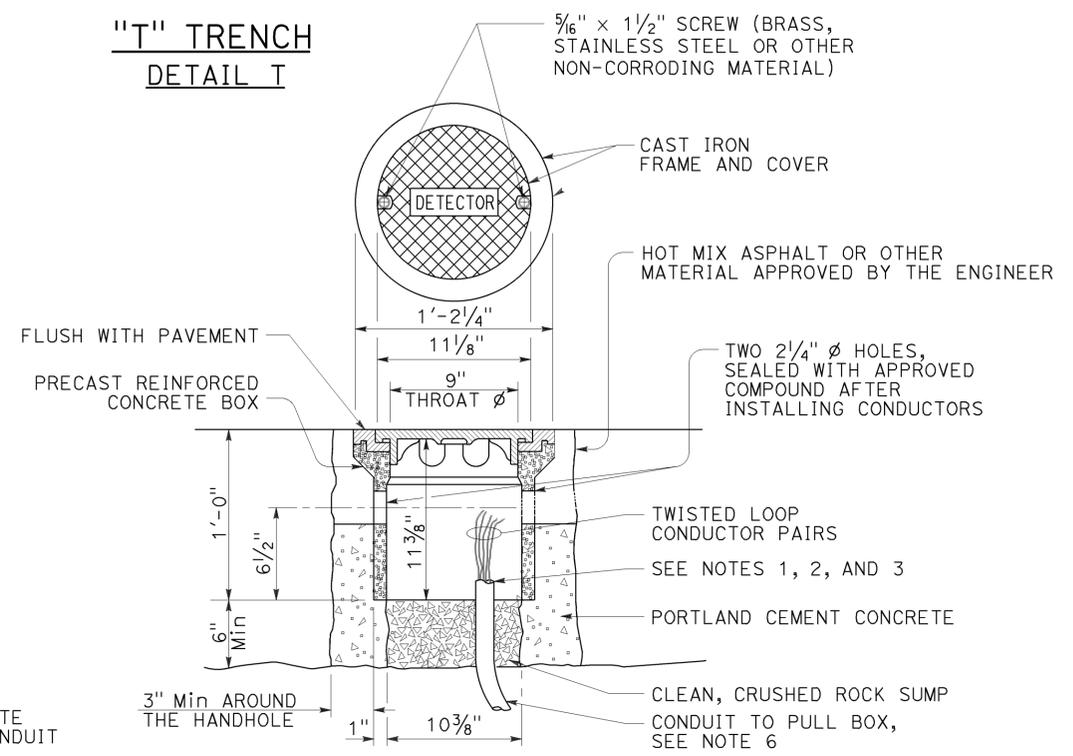


**DETECTOR HANDHOLE DETAIL**

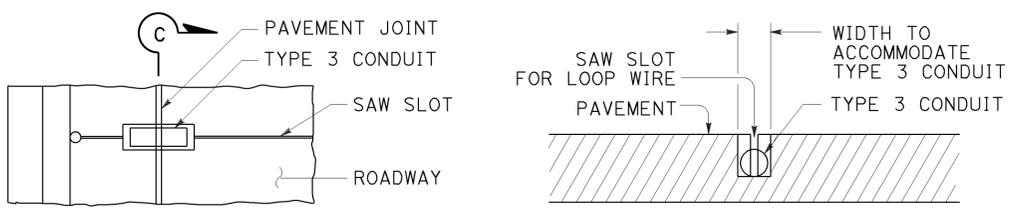


**PLAN VIEW**

**SECTION C-C**


**TYPE B  
CURB TERMINATION DETAIL**

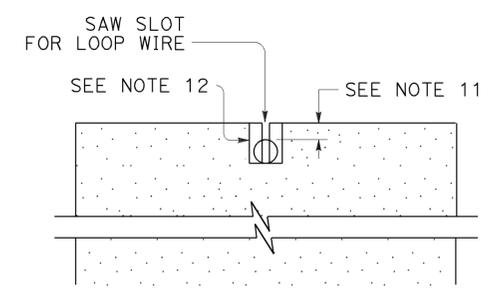

**SECTION A-A**

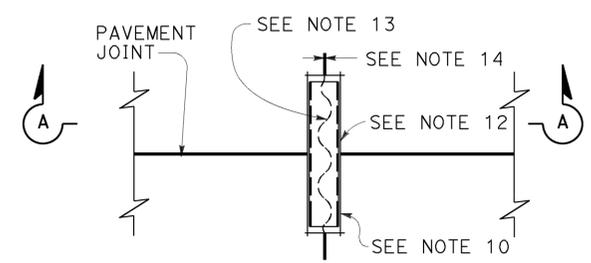

**PLAN VIEW  
TYPICAL LOOP LEAD-IN DETAIL  
AT PAVEMENT JOINT**

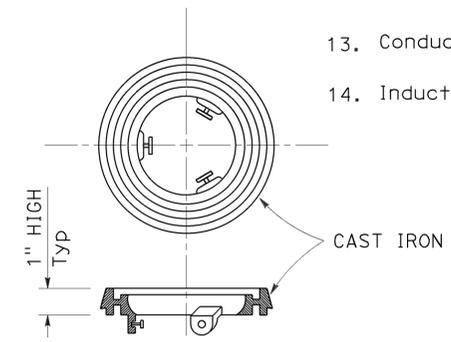

**LOCKING GRADE RING**

STATE OF CALIFORNIA  
DEPARTMENT OF TRANSPORTATION

**ELECTRICAL SYSTEMS  
(CURB AND SHOULDER TERMINATION,  
TRENCH, AND HANDHOLE DETAILS)**

NO SCALE

RSP ES-5D DATED OCTOBER 30, 2015 SUPERSEDES RSP ES-5D DATED JULY 19, 2013 AND STANDARD PLAN ES-5D DATED MAY 20, 2011 - PAGE 451 OF THE STANDARD PLANS BOOK DATED 2010.

**REVISED STANDARD PLAN RSP ES-5D**


2010 REVISED STANDARD PLAN RSP ES-5D

**NOTES:**


- Bushing shall be used at end of conduit.
- Tape detector conductors or cables 3" each side of bushings.
- Install duct seal compound to each end of termination conduit before installing sealant.
- Round all sharp edges where detector conductors or cables have to pass.
- End of conduit shall be 3/8" below roadway surface.
- Conduit size      Loop conductors  
1"C minimum      1 to 2 pairs  
1 1/2"C minimum      3 to 4 pairs  
2"C minimum      5 or more pairs
- Splice detector conductors or cables to detector lead-in-cable.
- Location of detector handhole when shown on plans.
- When the shoulder and traveled way are paved with the same material and there is no joint between them, the conduit shall extend only 2'-0" into the shoulder pavement.
- 3/4"C, Type 3 conduit 6" long minimum, plug both ends with duct compound to keep out sealant.
- 1/2" Minimum between top of conduit and pavement surface.
- Sawcut shall not exceed 1" in width and 1/8" longer than conduit to be installed.
- Conductors with 1/2" minimum slack inside conduit.
- Inductive loop detector saw slot.

DIST	COUNTY	ROUTE	POST MILES TOTAL PROJECT	SHEET NO.	TOTAL SHEETS
11	SD	8,54,67,94, 125, etc.	Var	229	231


Theresa Gabriel  
 REGISTERED ELECTRICAL ENGINEER  
 October 30, 2015  
 PLANS APPROVAL DATE  
 THE STATE OF CALIFORNIA OR ITS OFFICERS OR AGENTS SHALL NOT BE RESPONSIBLE FOR THE ACCURACY OR COMPLETENESS OF SCANNED COPIES OF THIS PLAN SHEET.

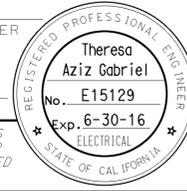


TO ACCOMPANY PLANS DATED 01-11-16

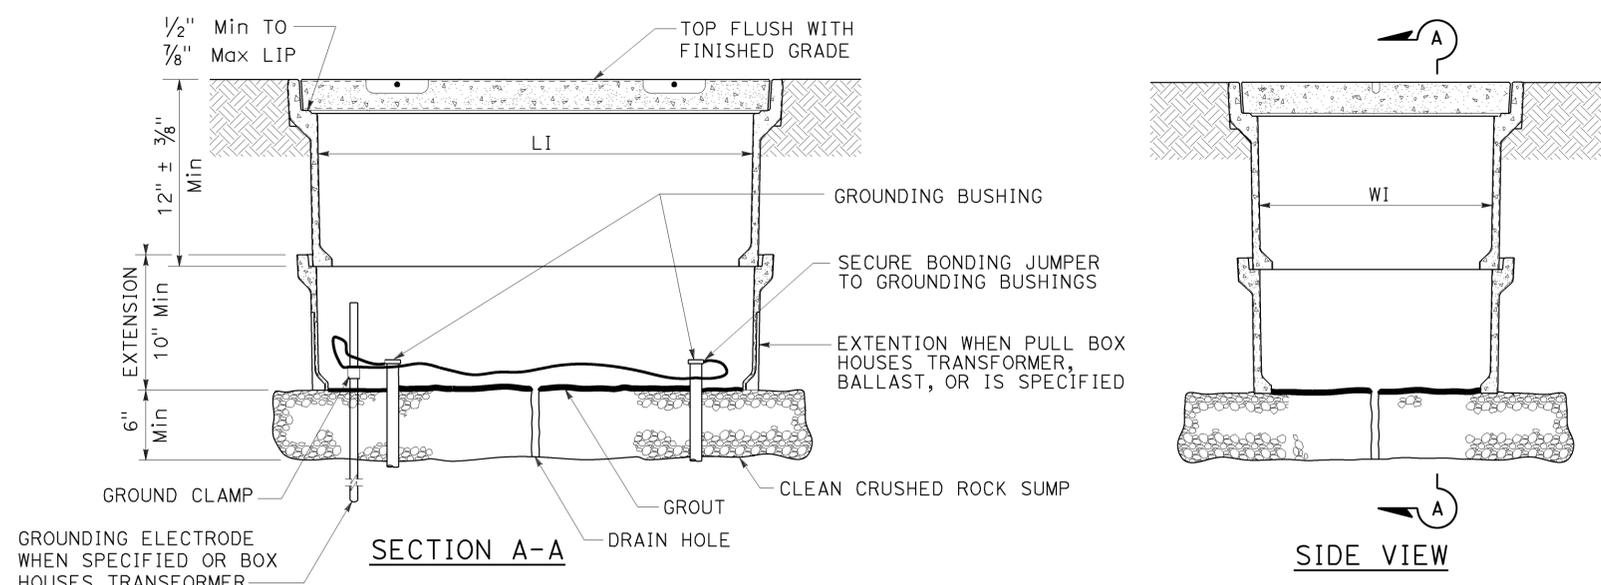


**INSTALLATION DETAILS**  
**DETAIL A**

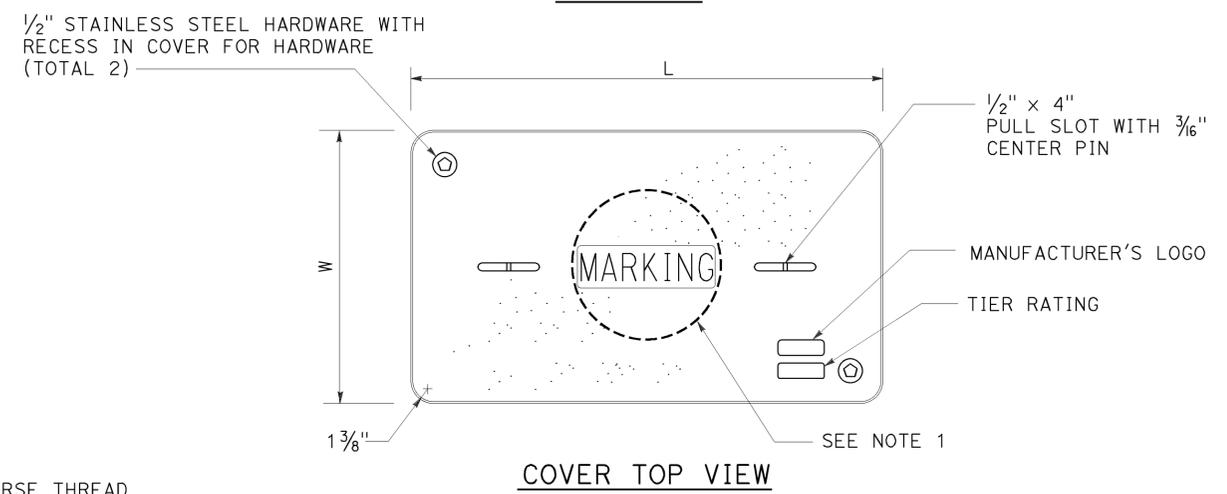

**COVER TOP VIEW**

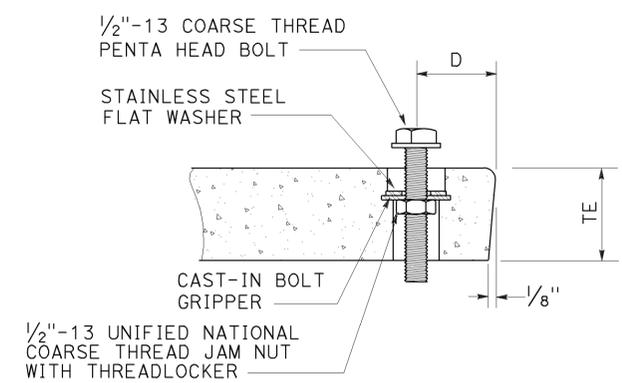

**TYPICAL COVER CAPTIVE BOLT**  
**OR SIMILAR**

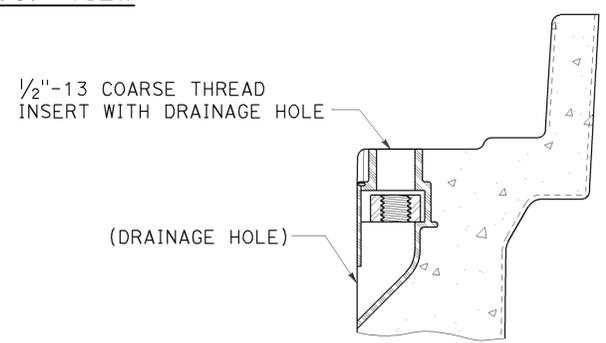

**TYPICAL THREADED INSERT**  
**OR SIMILAR**

**NOTES:**

- Pull box covers shall be marked as follows: "SERVICE" Service circuits between service point and service disconnect; "SPRINKLER-CONTROL" sprinkler control circuits, 50 V or less; "CALTRANS" on all pull boxes, except pull boxes marked "SPRINKLER-CONTROL"; and "TELEPHONE" Telephone service;
  - No. 3 1/2 pull box.
    - "SIGNAL" - Traffic signal circuits with or without lighting or sign lighting circuits.
    - "LIGHTING" - Lighting or sign lighting circuits where voltage is under 600 V.
  - No. 5, 6, 9 or 9A pull box.
    - "TRAFFIC SIGNAL" - Traffic signal circuits with or without lighting or sign lighting circuits.
    - "LIGHTING" - Lighting or sign lighting circuits where voltage is under 600 V.
    - "LIGHTING-HIGH VOLTAGE" - Lighting or sign lighting circuits where voltage is above 600 V.
    - "IRRIGATION" - Circuits to irrigation controller 120 V or more.
    - "RAMP METER" - Ramp meter circuits.
    - "COUNT STATION" - Count or speed monitor circuits.
    - "COMMUNICATIONS" - Communication circuits.
    - "TOS COMMUNICATIONS" - TOS communication line.
    - "TOS POWER" - TOS power.
    - "TDC POWER" - Telephone demarcation cabinet power.
    - "CCTV" - Closed circuit television circuits.
    - "TMS" - Traffic monitoring station circuits.
    - "CMS" - Changeable message sign circuits.
    - "HAR" - Highway advisory radio circuits.
    - "BOOSTER PUMP" - Booster pump circuit.
- The nominal dimensions of the opening in which the cover sets shall be the same as the cover dimensions except the length and width dimensions shall be 1/8" greater.
- Covers and boxes shall be interchangeable with California standard male and female gages. When interchanged with a standard male or female gage, the top surfaces shall be flush within 1/8". Top outside radius of covers and pull boxes shall have a 1/8" radius.
- Pull box extension may be another pull box as long as the bottom edge of the pull box can fit into the cover opening.
- Dimensions for the cover for non-traffic pull box are nominal values.

DIMENSION TABLE										
PULL BOX	PULL BOX				COVER					
	MINIMUM DEPTH BOX	MINIMUM DEPTH EXTENSION	MINIMUM WEIGHT	LI Min	WI Min	TE	D	L	W	MINIMUM WEIGHT
No. 3 1/2	12"	N/A	40 lb	1' - 3"	9"	1 3/4"	1 3/4"	1'-3 1/4" - 1'-3 3/8"	10" - 10 1/8"	30 lb
No. 5	12"	10"	55 lb	1' - 8"	11"	2"	1 3/4"	1'-11 1/4"	1'-1 3/4"	60 lb
No. 6	12"	10"	70 lb	2' - 4 1/4"	1' - 3 1/4"	2"	2"	2'-6 1/2"	1'-5 1/2"	85 lb

STATE OF CALIFORNIA  
DEPARTMENT OF TRANSPORTATION  
**ELECTRICAL SYSTEMS**  
**(NON-TRAFFIC PULL BOX)**  
NO SCALE


RSP ES-8A DATED OCTOBER 30, 2015 SUPERSEDES RSP ES-8A DATED JULY 19, 2013 AND RSP ES-8A DATED JANUARY 20, 2012 THAT SUPPLEMENTS THE STANDARD PLANS BOOK DATED 2010.

**REVISED STANDARD PLAN RSP ES-8A**





2010 REVISED STANDARD PLAN RSP ES-8A

DIST	COUNTY	ROUTE	POST MILES TOTAL PROJECT	SHEET No.	TOTAL SHEETS
11	SD	8,54,67,94, 125, etc.	Var	230	231

Theresa Gabriel  
 REGISTERED ELECTRICAL ENGINEER  
 October 30, 2015  
 PLANS APPROVAL DATE  
THE STATE OF CALIFORNIA OR ITS OFFICERS OR AGENTS SHALL NOT BE RESPONSIBLE FOR THE ACCURACY OR COMPLETENESS OF SCANNED COPIES OF THIS PLAN SHEET.

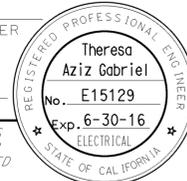


TO ACCOMPANY PLANS DATED 01-11-16

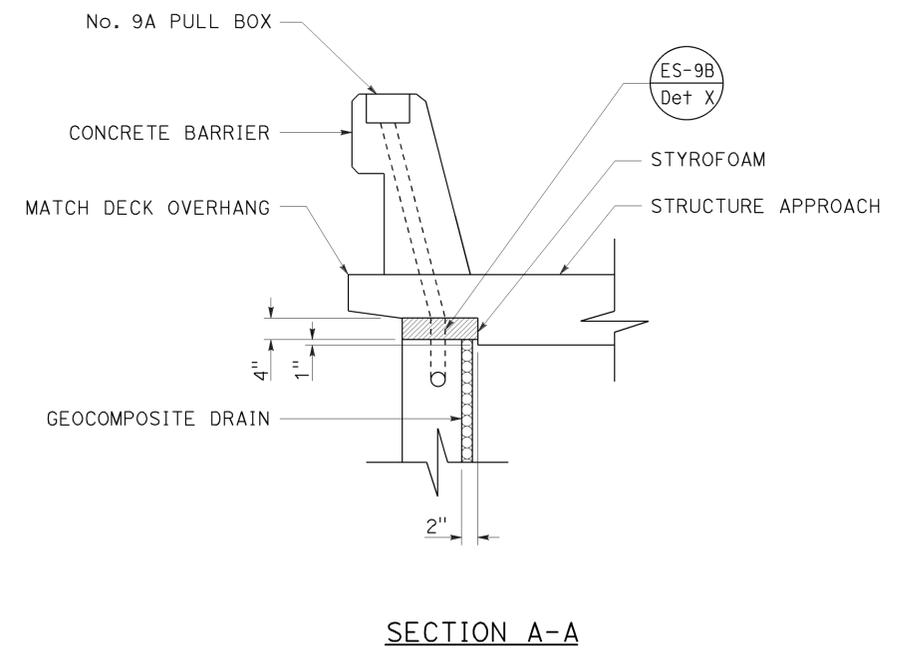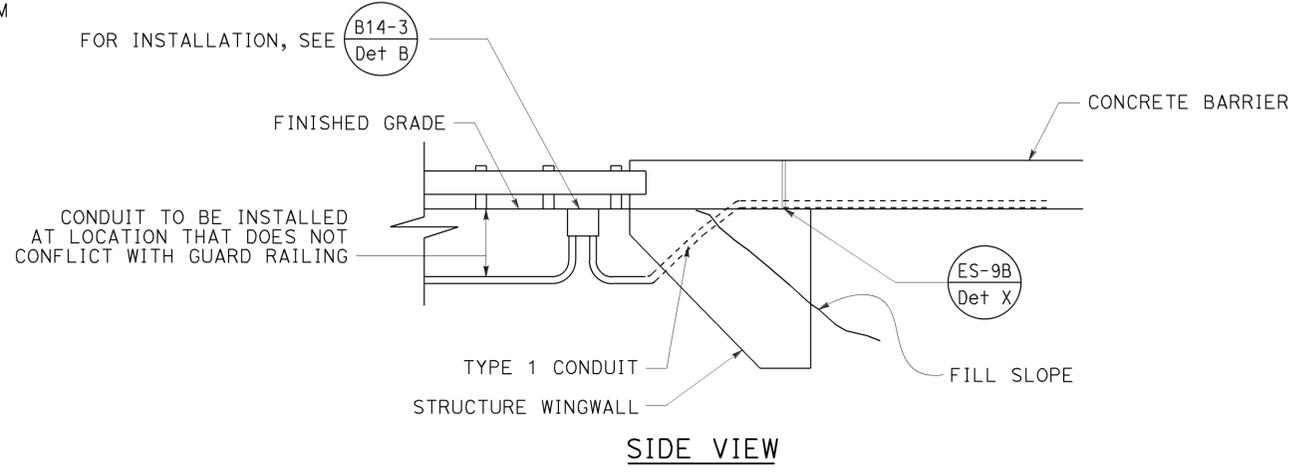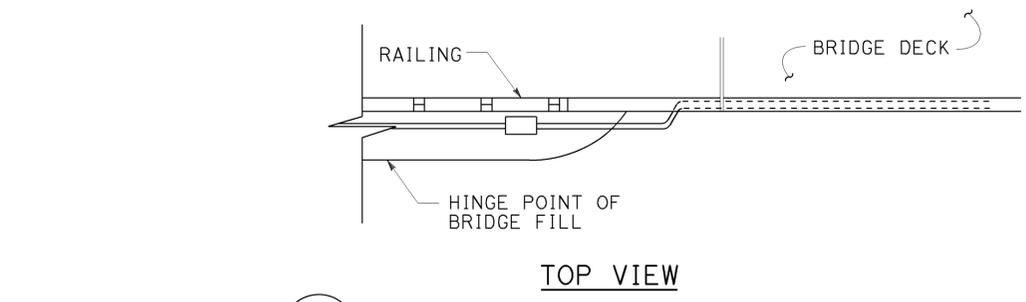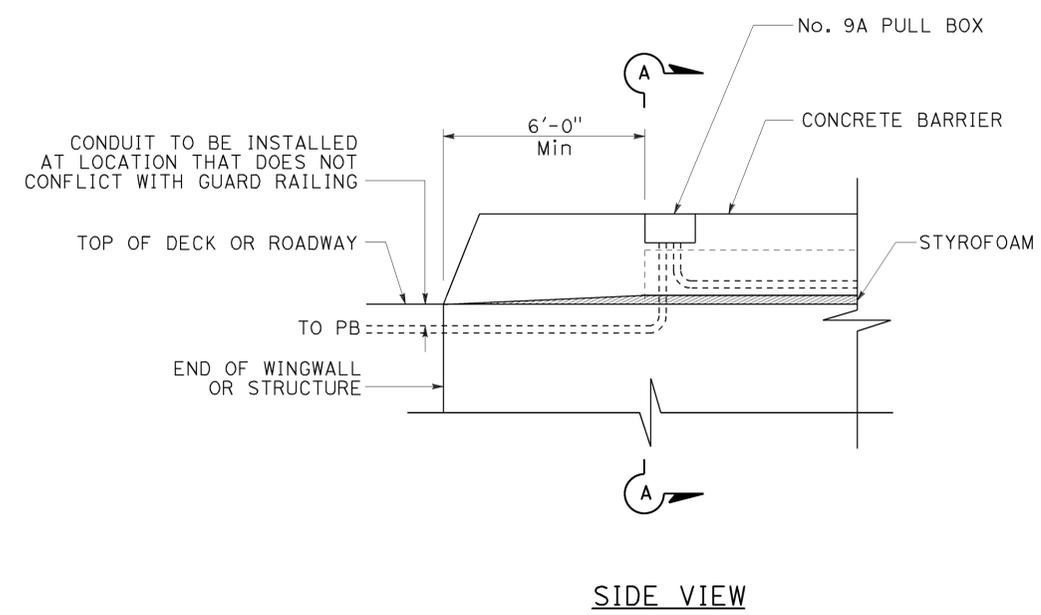

**CONDUIT TERMINATION  
DETAIL A**

**CONDUIT TERMINATION  
DETAIL I**

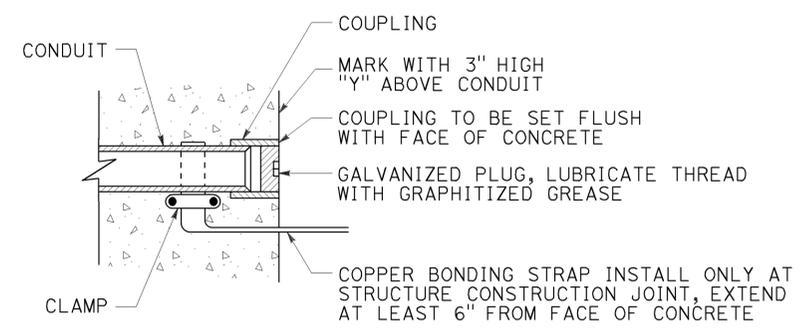

**CONDUIT TERMINATION  
DETAIL C**

**ELECTRICAL SYSTEMS  
(STRUCTURE PULL BOX  
INSTALLATIONS)**

STATE OF CALIFORNIA  
DEPARTMENT OF TRANSPORTATION

NO SCALE

RSP ES-9A DATED OCTOBER 30, 2015 SUPERSEDES STANDARD PLAN ES-9A DATED MAY 20, 2011 - PAGE 481 OF THE STANDARD PLANS BOOK DATED 2010.

**REVISED STANDARD PLAN RSP ES-9A**

2010 REVISED STANDARD PLAN RSP ES-9A


Dist	COUNTY	ROUTE	POST MILES TOTAL PROJECT	SHEET No.	TOTAL SHEETS
11	SD	8,54,67,94, 125, etc.	Var	231	231

Theresa Gabriel  
 REGISTERED ELECTRICAL ENGINEER  
 October 30, 2015  
 PLANS APPROVAL DATE

Theresa Aziz Gabriel  
 No. E15129  
 Exp. 6-30-16  
 ELECTRICAL  
 STATE OF CALIFORNIA


THE STATE OF CALIFORNIA OR ITS OFFICERS OR AGENTS SHALL NOT BE RESPONSIBLE FOR THE ACCURACY OR COMPLETENESS OF SCANNED COPIES OF THIS PLAN SHEET.

TO ACCOMPANY PLANS DATED 01-11-16

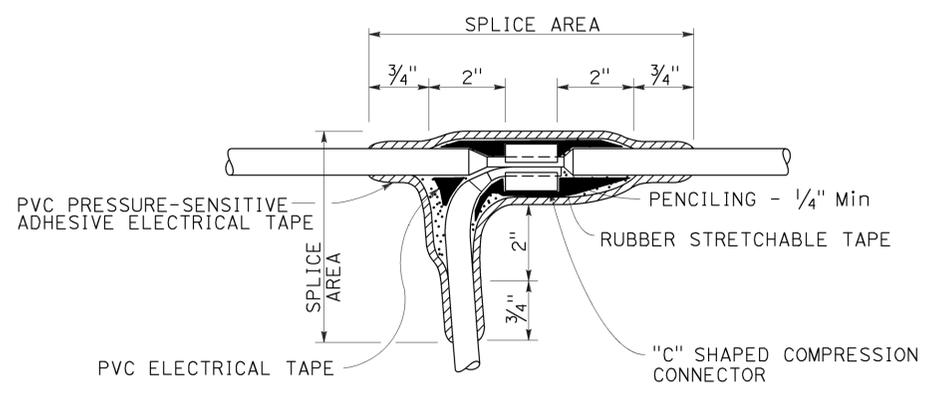

**TYPE C SPLICE**

See Note 3

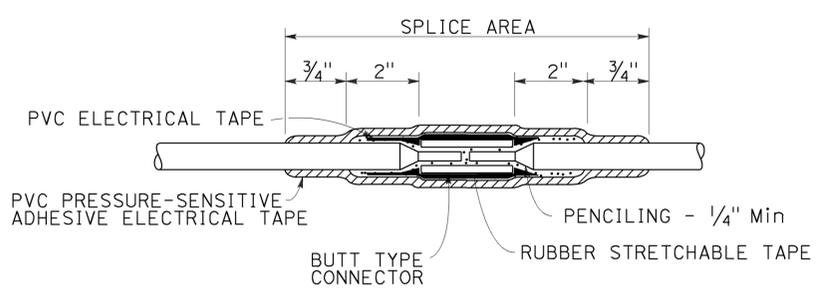


**TYPE S SPLICE**

See Note 4


**NOTES:**

1. Dimensions are minimum.
2. Rubber tapes shall be rolled after application.
3. Between 1 free-end and 1 through conductor.
4. Between 2 free-end conductors.
5. Between 3 free-end conductors.

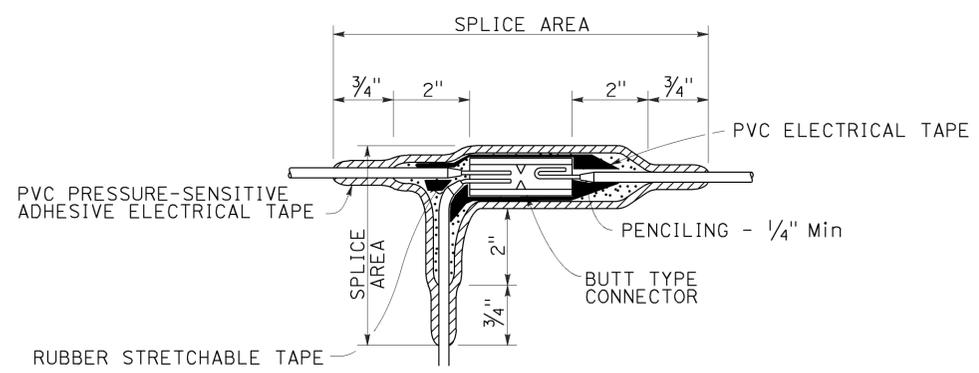

**TYPE ST SPLICE**

See Note 5

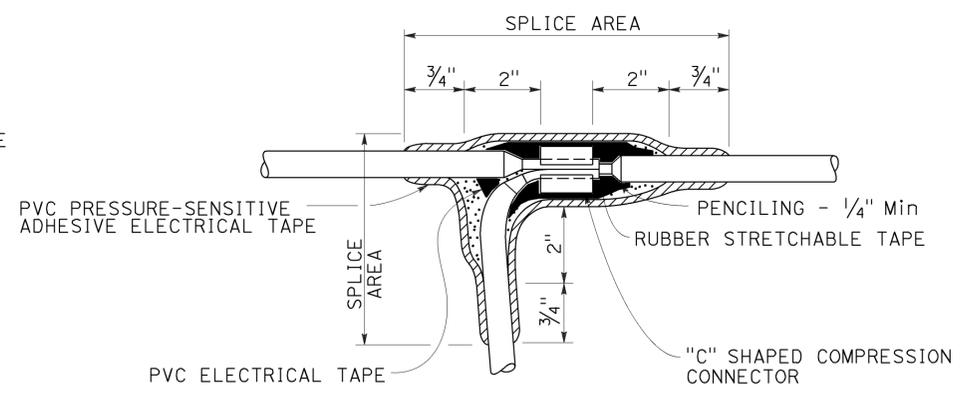

**TYPE T SPLICE**

See Note 5

STATE OF CALIFORNIA  
DEPARTMENT OF TRANSPORTATION

**ELECTRICAL SYSTEMS  
(SPLICING DETAILS)**

NO SCALE

RSP ES-13A DATED OCTOBER 30, 2015 SUPERSEDES STANDARD PLAN ES-13A DATED MAY 20, 2011 - PAGE 491 OF THE STANDARD PLANS BOOK DATED 2010.

**REVISED STANDARD PLAN RSP ES-13A**

2010 REVISED STANDARD PLAN RSP ES-13A