 



Dist	COUNTY	ROUTE	POST MILES TOTAL PROJECT	SHEET No.	TOTAL SHEETS
02	Sha	5	R14.9/R16.2	75	165
ART			02-11-10		
REGISTERED ELECTRICAL ENGINEER					
5-10-10			PLANS APPROVAL DATE		
<small>THE STATE OF CALIFORNIA OR ITS OFFICERS OR AGENTS SHALL NOT BE RESPONSIBLE FOR THE ACCURACY OR COMPLETENESS OF ELECTRONIC COPIES OF THIS PLAN SHEET.</small>					

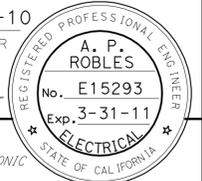


NOTES:
 1. FOR COMPLETE RIGHT OF WAY AND ACCURATE ACCESS DATA, SEE RIGHT OF WAY RECORD MAPS AT DISTRICT OFFICE.
 2. SEE SHEET E-5 FOR ELECTRICAL DETAILS.

LEGEND
 (PB) OBJECT MARKER (TYPE PB) AND PB PAVING

ABBREVIATIONS
 TC TELEPHONE CABLE
 Cab CABINET
 I/C INTERCHANGE
 ITS INTELLIGENT TRANSPORTATION SYSTEMS
 COR CITY OF REDDING
 REU REDDING ELECTRIC UTILITY
 JB JUNCTION BOX

STATE OF CALIFORNIA - DEPARTMENT OF TRANSPORTATION
Caltrans ELECTRICAL DESIGN
 FUNCTIONAL SUPERVISOR: ROB STINGER
 CALCULATED/DESIGNED BY: [blank]
 CHECKED BY: [blank]
 ARTURO ROBLES
 JAMES M. HANNIGAN
 REVISED BY: [blank]
 DATE REVISED: [blank]

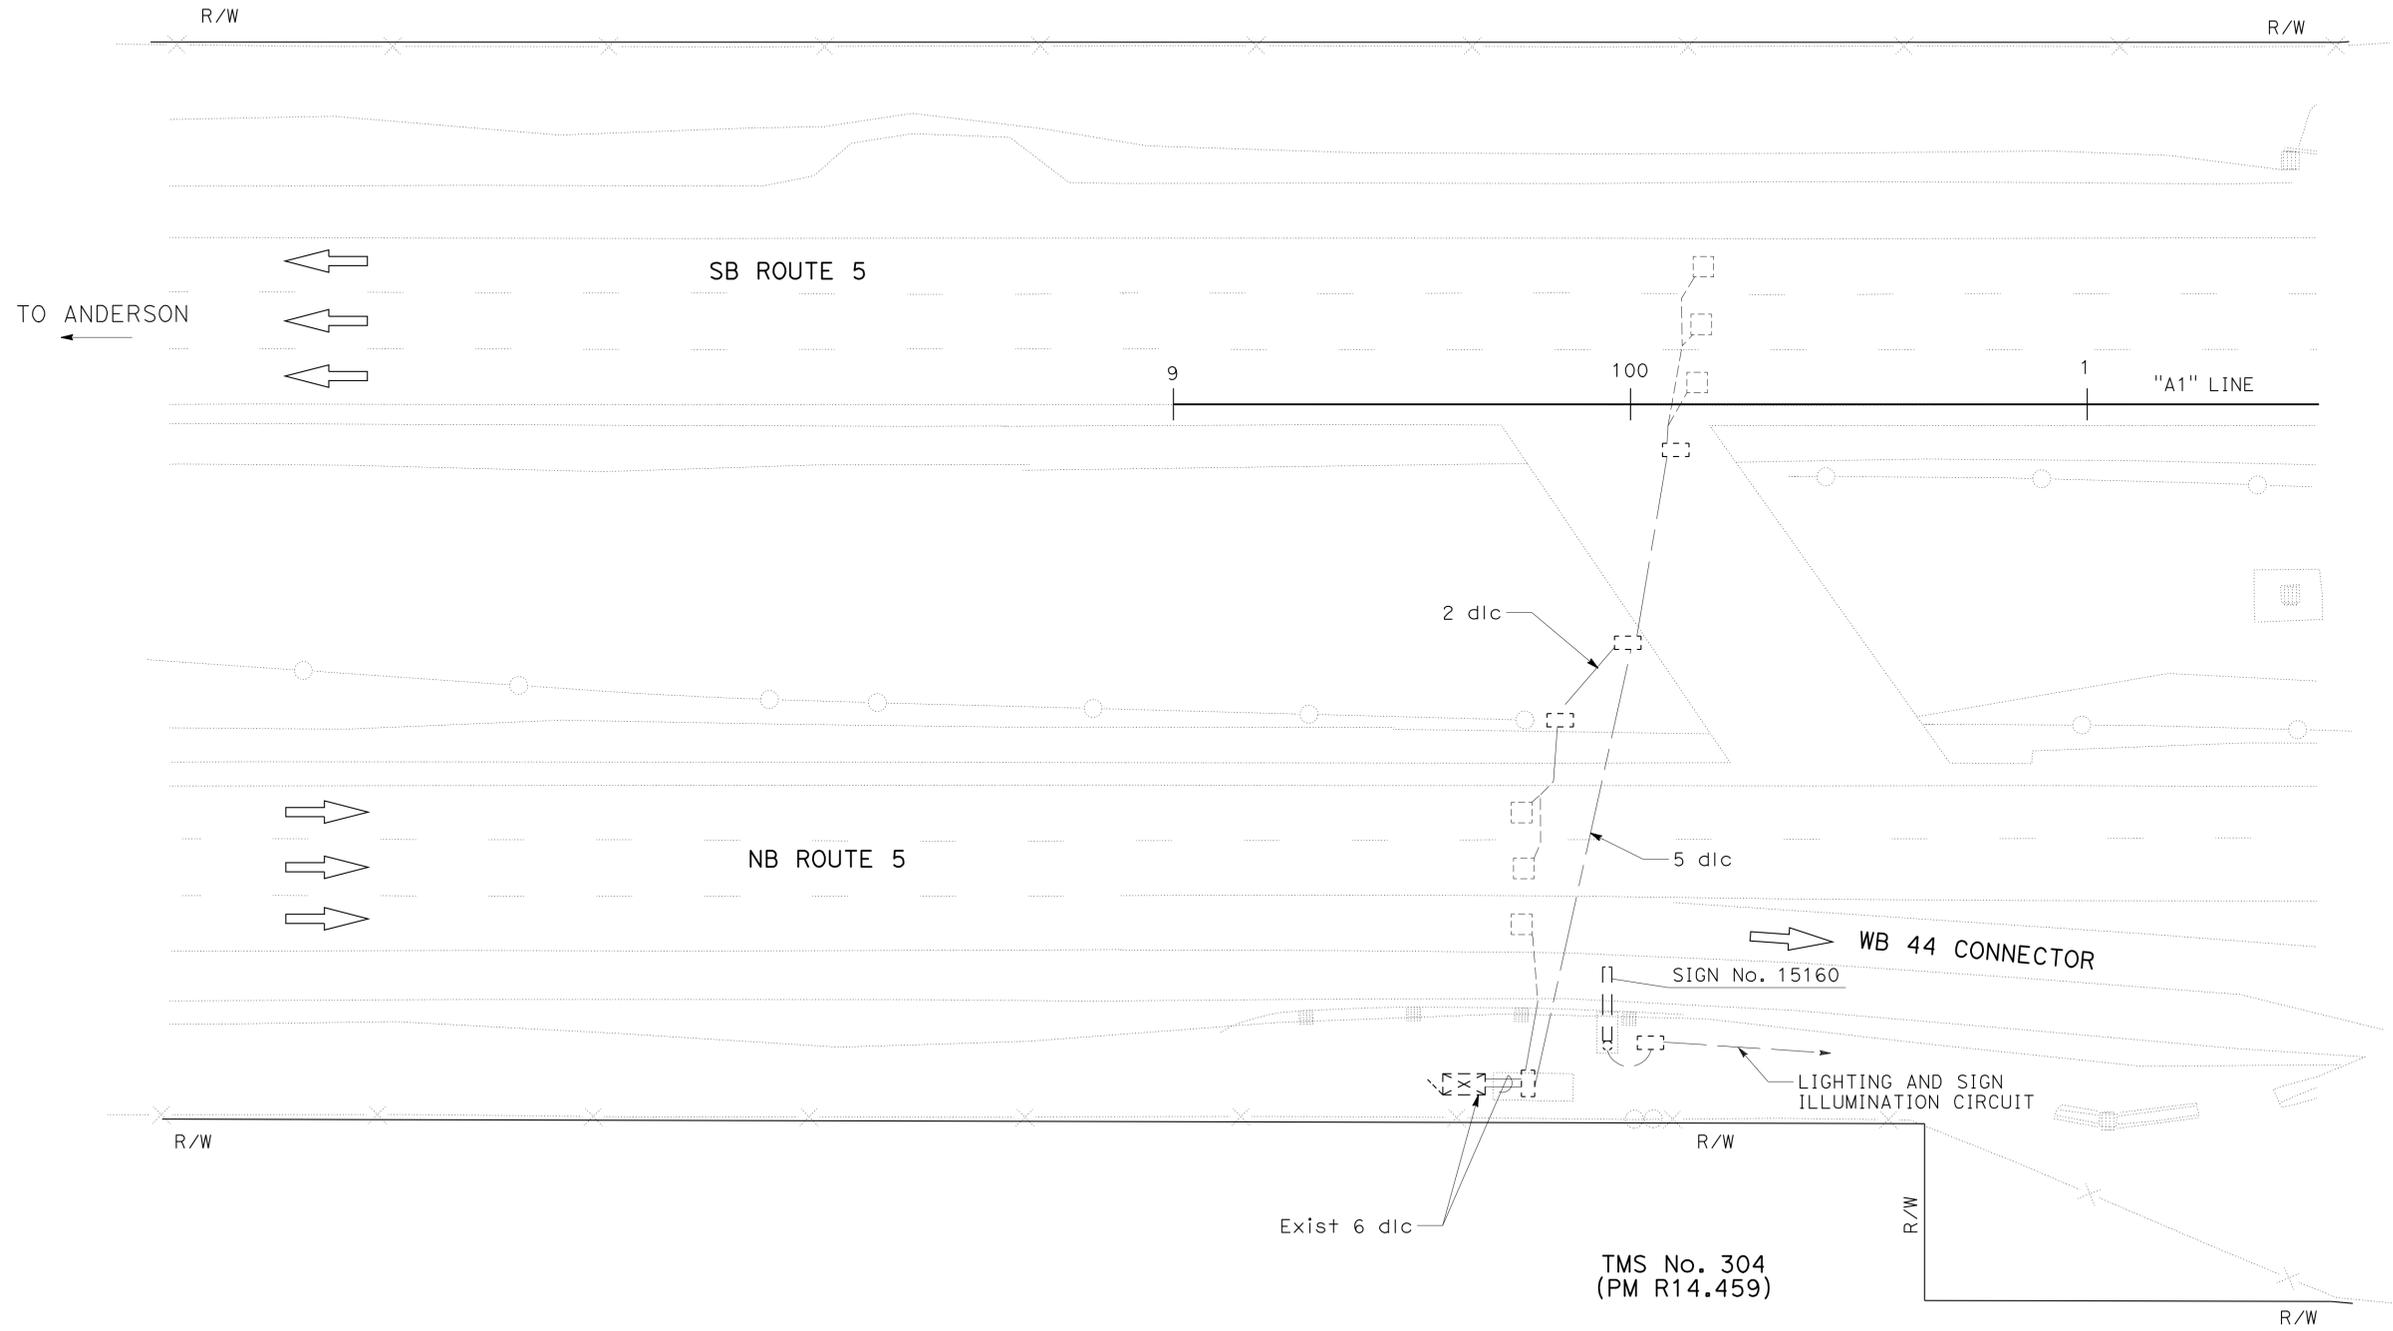

REVISED PER ADDENDUM No. 1 DATED SEPTEMBER 23, 2010

TRAFFIC MONITORING STATION

SCALE: 1" = 20'

E-1

THIS PLAN IS ACCURATE FOR ELECTRICAL WORK ONLY.

