

INDEX OF PLANS

SHEET No.	DESCRIPTION
1	TITLE AND LOCATION MAP
2-4	CONSTRUCTION DETAILS
5-6	SIGN PLAN, DETAILS
7	SUMMARY OF QUANTITIES
8-10	ELECTRICAL PLANS
11-22	REVISED STANDARD PLANS

THE STANDARD PLANS LIST APPLICABLE TO THIS CONTRACT IS INCLUDED IN THE NOTICE TO BIDDERS AND SPECIAL PROVISIONS BOOK.


STATE OF CALIFORNIA
DEPARTMENT OF TRANSPORTATION

NH-P070(101)

PROJECT PLANS FOR CONSTRUCTION ON
STATE HIGHWAY

IN YUBA COUNTY
AT OLIVEHURST
FROM 0.2 MILE SOUTH OF MCGOWAN PARKWAY OVERCROSSING
TO 0.3 MILE NORTH OF MCGOWAN PARKWAY OVERCROSSING

TO BE SUPPLEMENTED BY STANDARD PLANS DATED MAY 2006

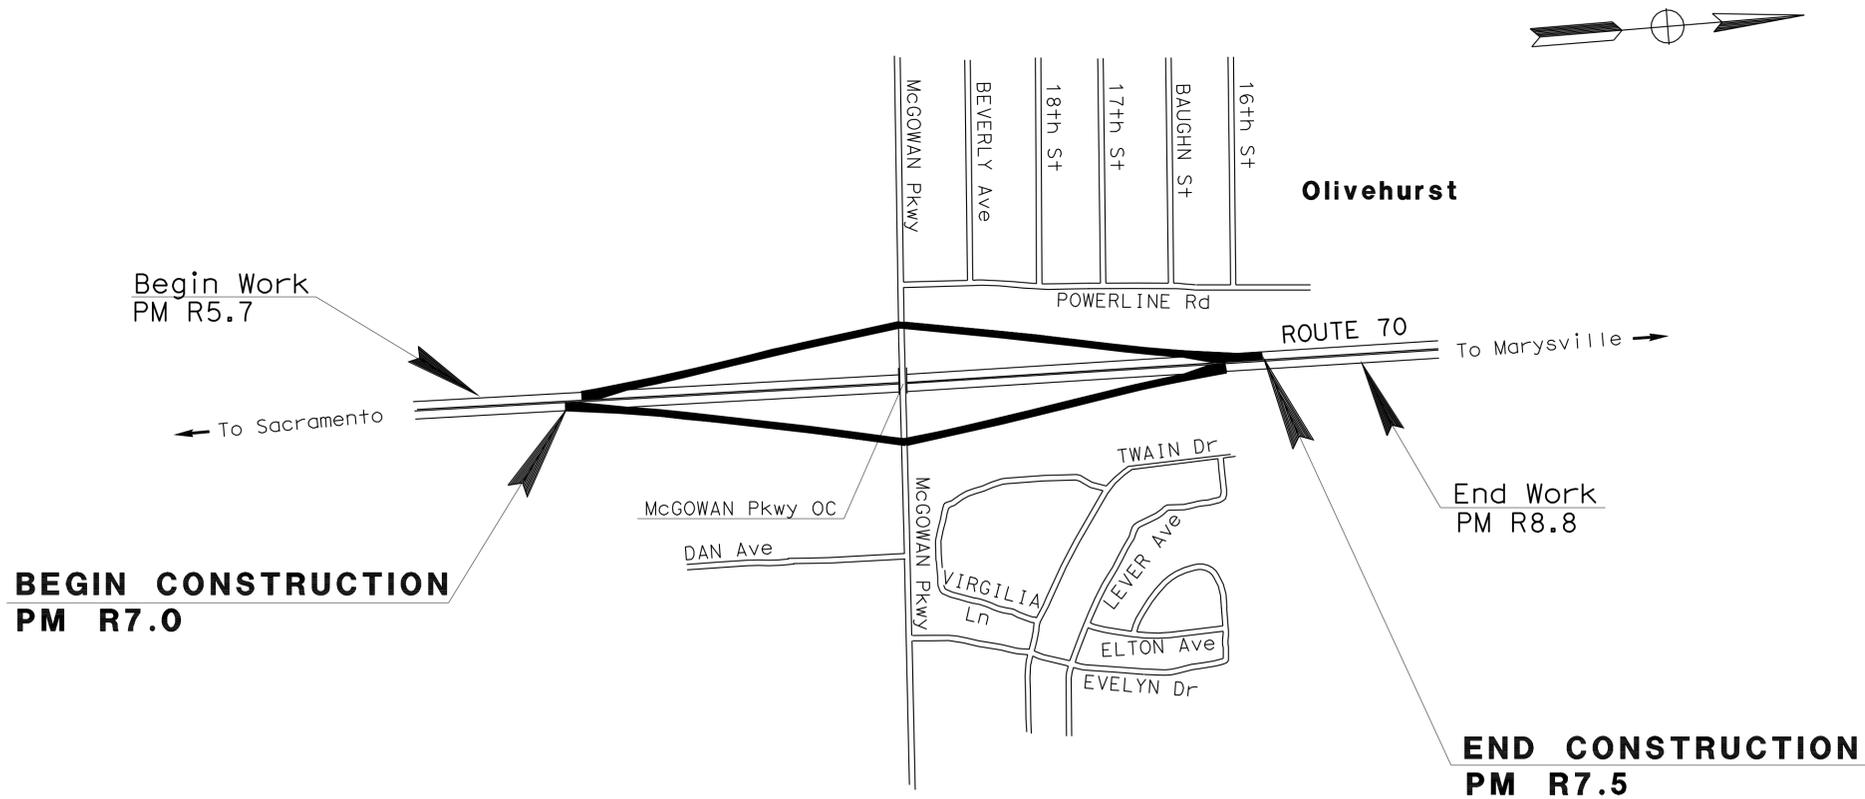

NO SCALE

PROJECT MANAGER
NAJED DAKAK


DESIGN ENGINEER
ROBERT PETERSON

THE CONTRACTOR SHALL POSSESS THE CLASS (OR CLASSES) OF LICENSE AS SPECIFIED IN THE "NOTICE TO BIDDERS."

Dennis G. Corcoran 2-9-11
PROJECT ENGINEER DATE
REGISTERED CIVIL ENGINEER

April 4, 2011
PLANS APPROVAL DATE

THE STATE OF CALIFORNIA OR ITS OFFICERS OR AGENTS SHALL NOT BE RESPONSIBLE FOR THE ACCURACY OR COMPLETENESS OF SCANNED COPIES OF THIS PLAN SHEET.

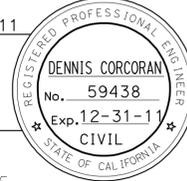


CONTRACT No.	03-3E8904
PROJECT ID	0300001123

Dist	COUNTY	ROUTE	POST MILES TOTAL PROJECT	SHEET No.	TOTAL SHEETS
03	Yub	70	R7.0/R7.5	2	22


<i>Dennis G. Corcoran</i>	2-9-11
REGISTERED CIVIL ENGINEER	DATE
4-4-11	
PLANS APPROVAL DATE	

REGISTERED PROFESSIONAL ENGINEER	DENNIS CORCORAN
No. 59438	Exp. 12-31-11
CIVIL	STATE OF CALIFORNIA


THE STATE OF CALIFORNIA OR ITS OFFICERS OR AGENTS SHALL NOT BE RESPONSIBLE FOR THE ACCURACY OR COMPLETENESS OF SCANNED COPIES OF THIS PLAN SHEET.

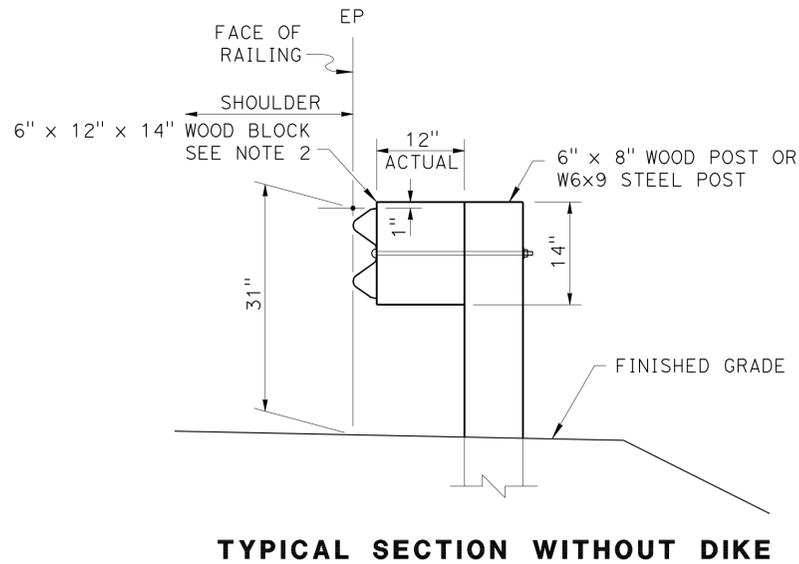

TYPICAL SECTION WITHOUT DIKE

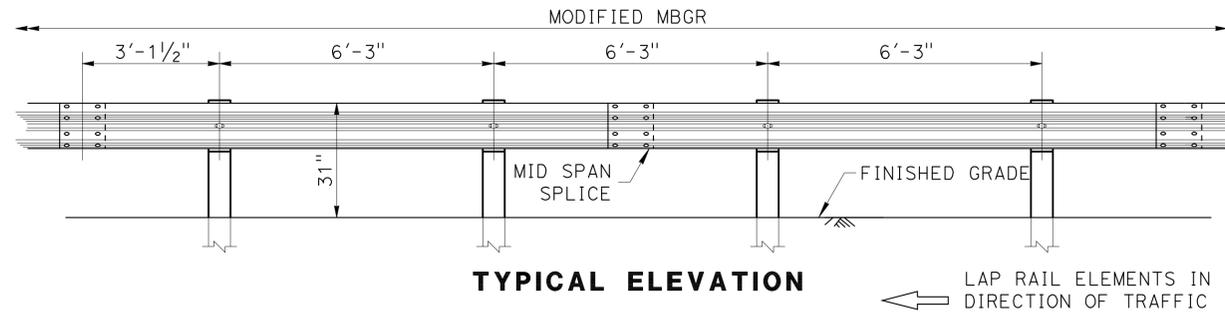


TYPICAL ELEVATION

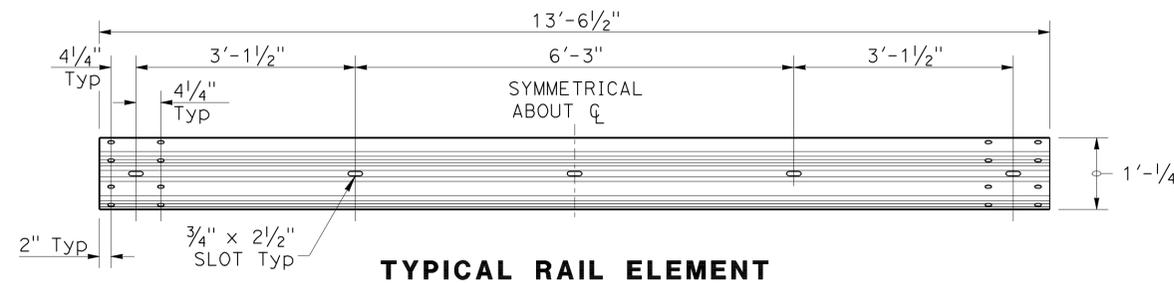


TYPICAL RAIL ELEMENT

NOTES:


- EXISTING UTILITY FACILITIES HAVE NOT BEEN POSITIVELY IDENTIFIED.
- USE A SINGLE OR COMBINATION OF BLOCKS TO ACHIEVE THE ACTUAL 12" OFFSET. WOOD OR PLASTIC BLOCKS SHALL BE TOE-NAILED TO POST (AND BLOCKS, IF BLOCK COMBINATIONS ARE UTILIZED) WITH A 16D GALVANIZED NAIL TO PREVENT BLOCK ROTATION.
- ON STEEL POSTS, ATTACH BLOCKOUTS USING BOLT HOLES ON APPROACHING TRAFFIC SIDE OF POST WEB.
- USE A 5/8" x 22" BUTTON HEAD BOLT WITH A 7/32" OVAL GRIP (Typ) FOR WOOD POSTS, AND A 5/8" x 14" BUTTON HEAD BOLT WITH A 7/32" OVAL GRIP RECESSED HEX NUT WITH CUT WASHER (Typ) FOR STEEL POSTS.

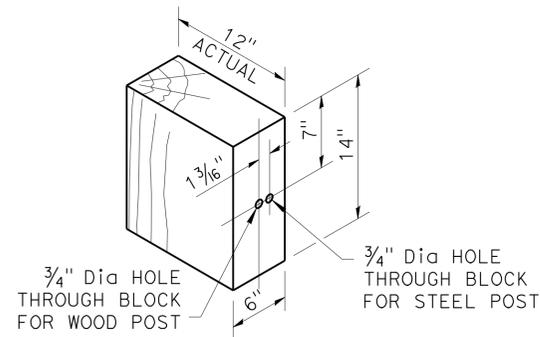


WOOD BLOCK

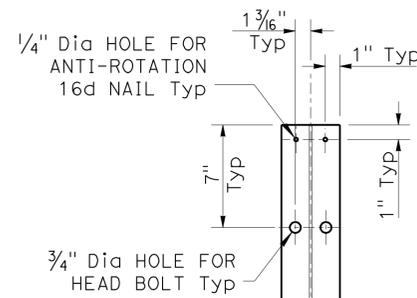

STEEL POST
(SEE NOTE 3)

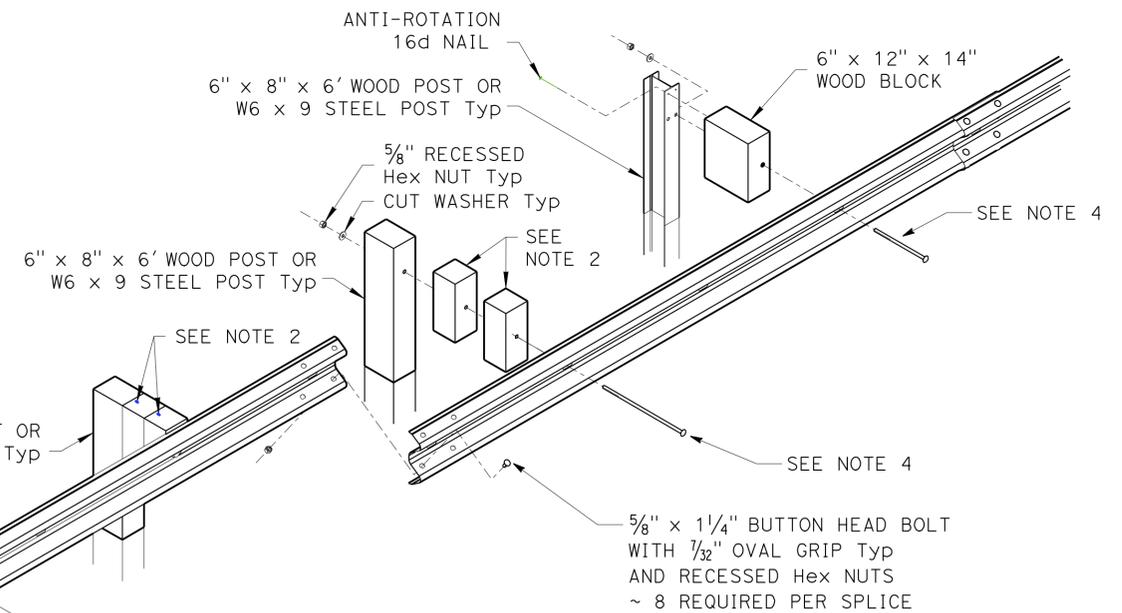

ISOMETRIC VIEW

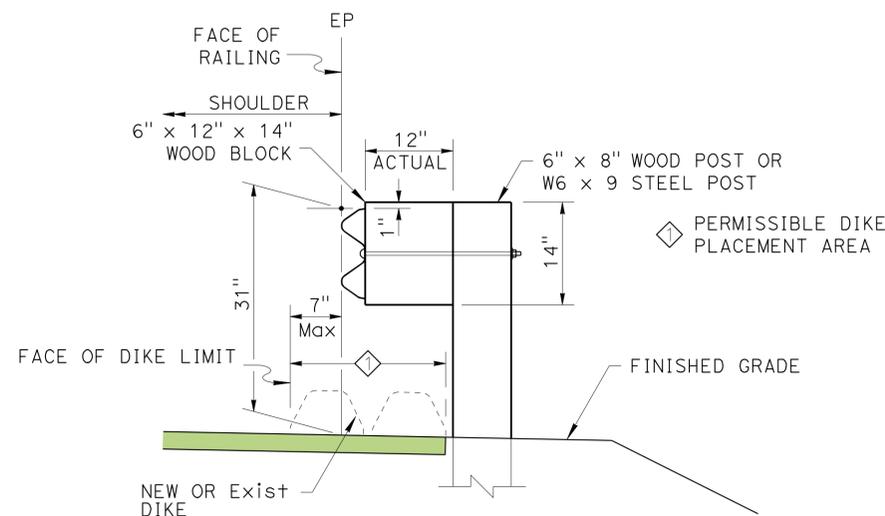

TYPICAL SECTION WITH DIKE

MODIFIED METAL BEAM GUARD RAILING

CONSTRUCTION DETAILS

NO SCALE

C-1

STATE OF CALIFORNIA - DEPARTMENT OF TRANSPORTATION
Caltrans
FUNCTIONAL SUPERVISOR: ROBERT PETERSON
CALCULATED/DESIGNED BY: DENNIS CORCORAN
CHECKED BY: ROBERT PETERSON
REVISOR: DENNIS CORCORAN
DATE: ROBERT PETERSON
REVISED BY: DENNIS CORCORAN
DATE: ROBERT PETERSON

Dist	COUNTY	ROUTE	POST MILES TOTAL PROJECT	SHEET No.	TOTAL SHEETS
03	Yub	70	R7.0/R7.5	3	22


<i>Dennis G. Corcoran</i>		2-9-11
REGISTERED CIVIL ENGINEER		DATE
4-4-11		
PLANS APPROVAL DATE		

REGISTERED PROFESSIONAL ENGINEER	
DENNIS CORCORAN	
No. 59438	
Exp. 12-31-11	
CIVIL	


THE STATE OF CALIFORNIA OR ITS OFFICERS OR AGENTS SHALL NOT BE RESPONSIBLE FOR THE ACCURACY OR COMPLETENESS OF SCANNED COPIES OF THIS PLAN SHEET.

NOTES:


- EXISTING UTILITY FACILITIES HAVE NOT BEEN POSITIVELY IDENTIFIED.
- FOR ADDITIONAL DETAILS, SEE STANDARD PLANS, A77L2 AND A77L3.

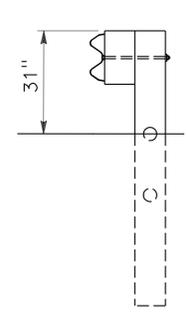


SECTION B-B

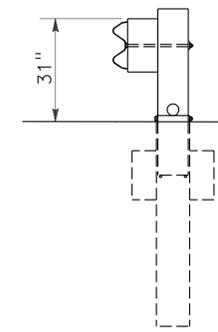

SECTION A-A

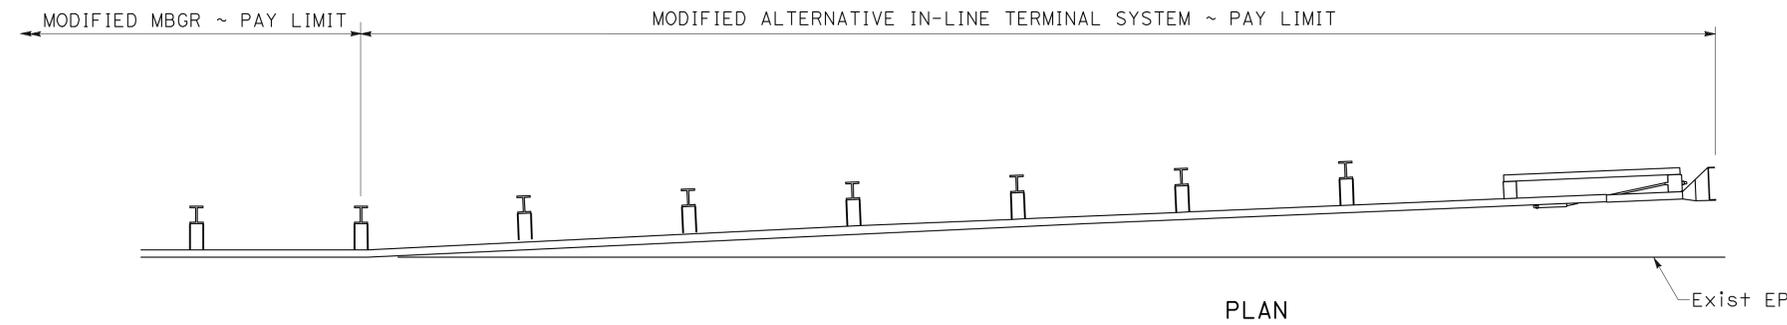

PLAN

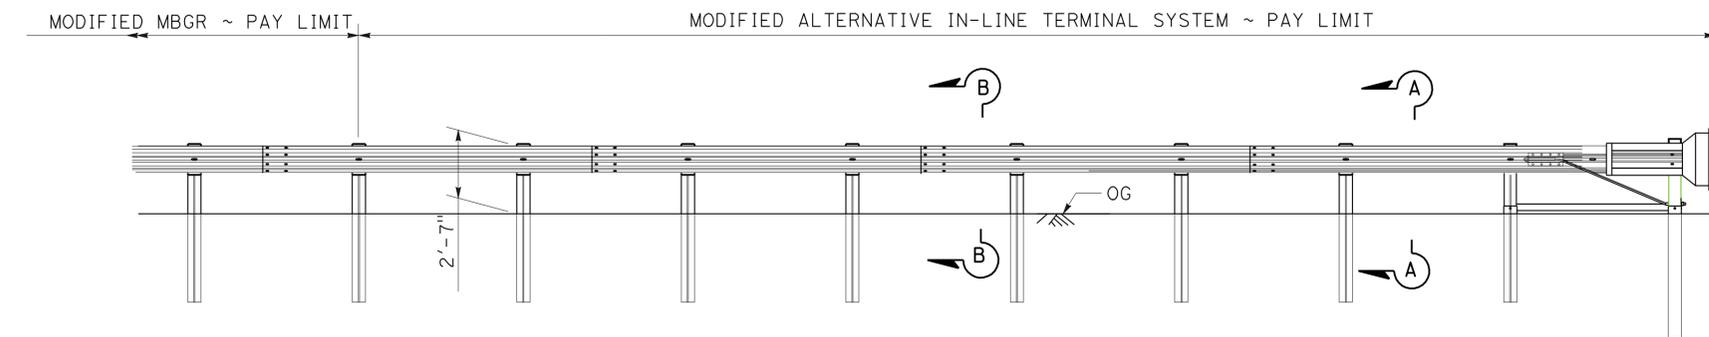

ELEVATION

MODIFIED ALTERNATIVE IN-LINE TERMINAL SYSTEM

CONSTRUCTION DETAILS

NO SCALE

C-2

STATE OF CALIFORNIA - DEPARTMENT OF TRANSPORTATION	REVISOR	DATE
Caltrans	DENNIS CORCORAN	
	ROBERT PETERSON	
	ROBERT PETERSON	
	ROBERT PETERSON	



Dist	COUNTY	ROUTE	POST MILES TOTAL PROJECT	SHEET No.	TOTAL SHEETS
03	Yub	70	R7.0/R7.5	4	22

<i>Dennis L. Corcoran</i>	2-9-11
REGISTERED CIVIL ENGINEER	DATE
4-4-11	
PLANS APPROVAL DATE	


REGISTERED PROFESSIONAL ENGINEER
DENNIS CORCORAN
No. 59438
Exp. 12-31-11
CIVIL
STATE OF CALIFORNIA

THE STATE OF CALIFORNIA OR ITS OFFICERS OR AGENTS SHALL NOT BE RESPONSIBLE FOR THE ACCURACY OR COMPLETENESS OF SCANNED COPIES OF THIS PLAN SHEET.

NOTES:

- EXISTING UTILITY FACILITIES HAVE NOT BEEN POSITIVELY IDENTIFIED.
- FOR ADDITIONAL DETAILS, SEE STANDARD PLAN, A77H1.

STATE OF CALIFORNIA - DEPARTMENT OF TRANSPORTATION	FUNCTIONAL SUPERVISOR	CALCULATED/DESIGNED BY	DENNIS CORCORAN	REVISOR	
Caltrans	ROBERT PETERSON	CHECKED BY	ROBERT PETERSON	DATE	
TRAFFIC					

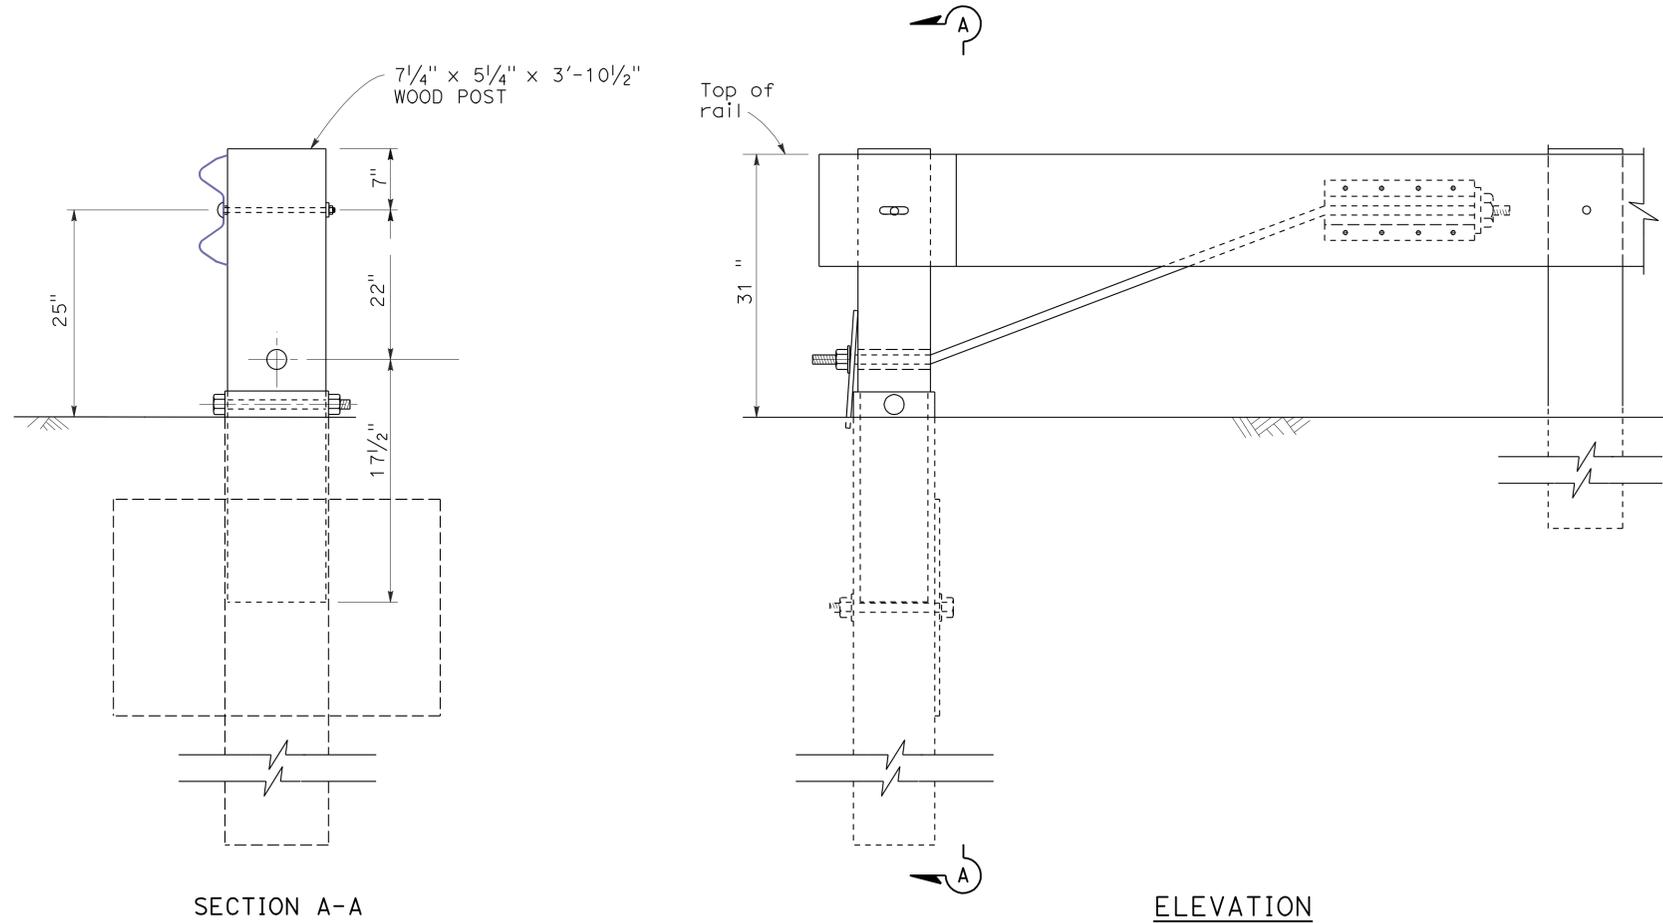


MODIFIED END ANCHOR ASSEMBLY (TYPE SFT)

CONSTRUCTION DETAILS

NO SCALE

 C-3



LEGEND:

- (No.) ROADSIDE SIGN NUMBER
- (No.) OVERHEAD SIGN NUMBER
- <CA> CALIFORNIA SIGN CODE
- INSTALL SIGN (SSBM)
- REMOVE ROADSIDE SIGN


NOTES:

1. ALL EXISTING SIGNS NOT SHOWN FOR REMOVAL SHALL REMAIN IN PLACE.
2. ALL SIGN CODES SHOWN ARE FEDERAL SIGN CODES UNLESS OTHERWISE DESIGNATED AS CALIFORNIA SIGN CODES.
3. THIS PLAN ACCURATE FOR SIGNING WORK ONLY.

Dist	COUNTY	ROUTE	POST MILES TOTAL PROJECT	SHEET No.	TOTAL SHEETS
03	Yub	70	R7.0/R7.5	5	22

REGISTERED CIVIL ENGINEER
 2-10-11 DATE
 4-4-11 PLANS APPROVAL DATE
 THE STATE OF CALIFORNIA OR ITS OFFICERS OR AGENTS SHALL NOT BE RESPONSIBLE FOR THE ACCURACY OR COMPLETENESS OF SCANNED COPIES OF THIS PLAN SHEET.

REGISTERED PROFESSIONAL ENGINEER
 Jeffrey S. Jewett
 No. 49233
 Exp. 9-30-12
 CIVIL
 STATE OF CALIFORNIA

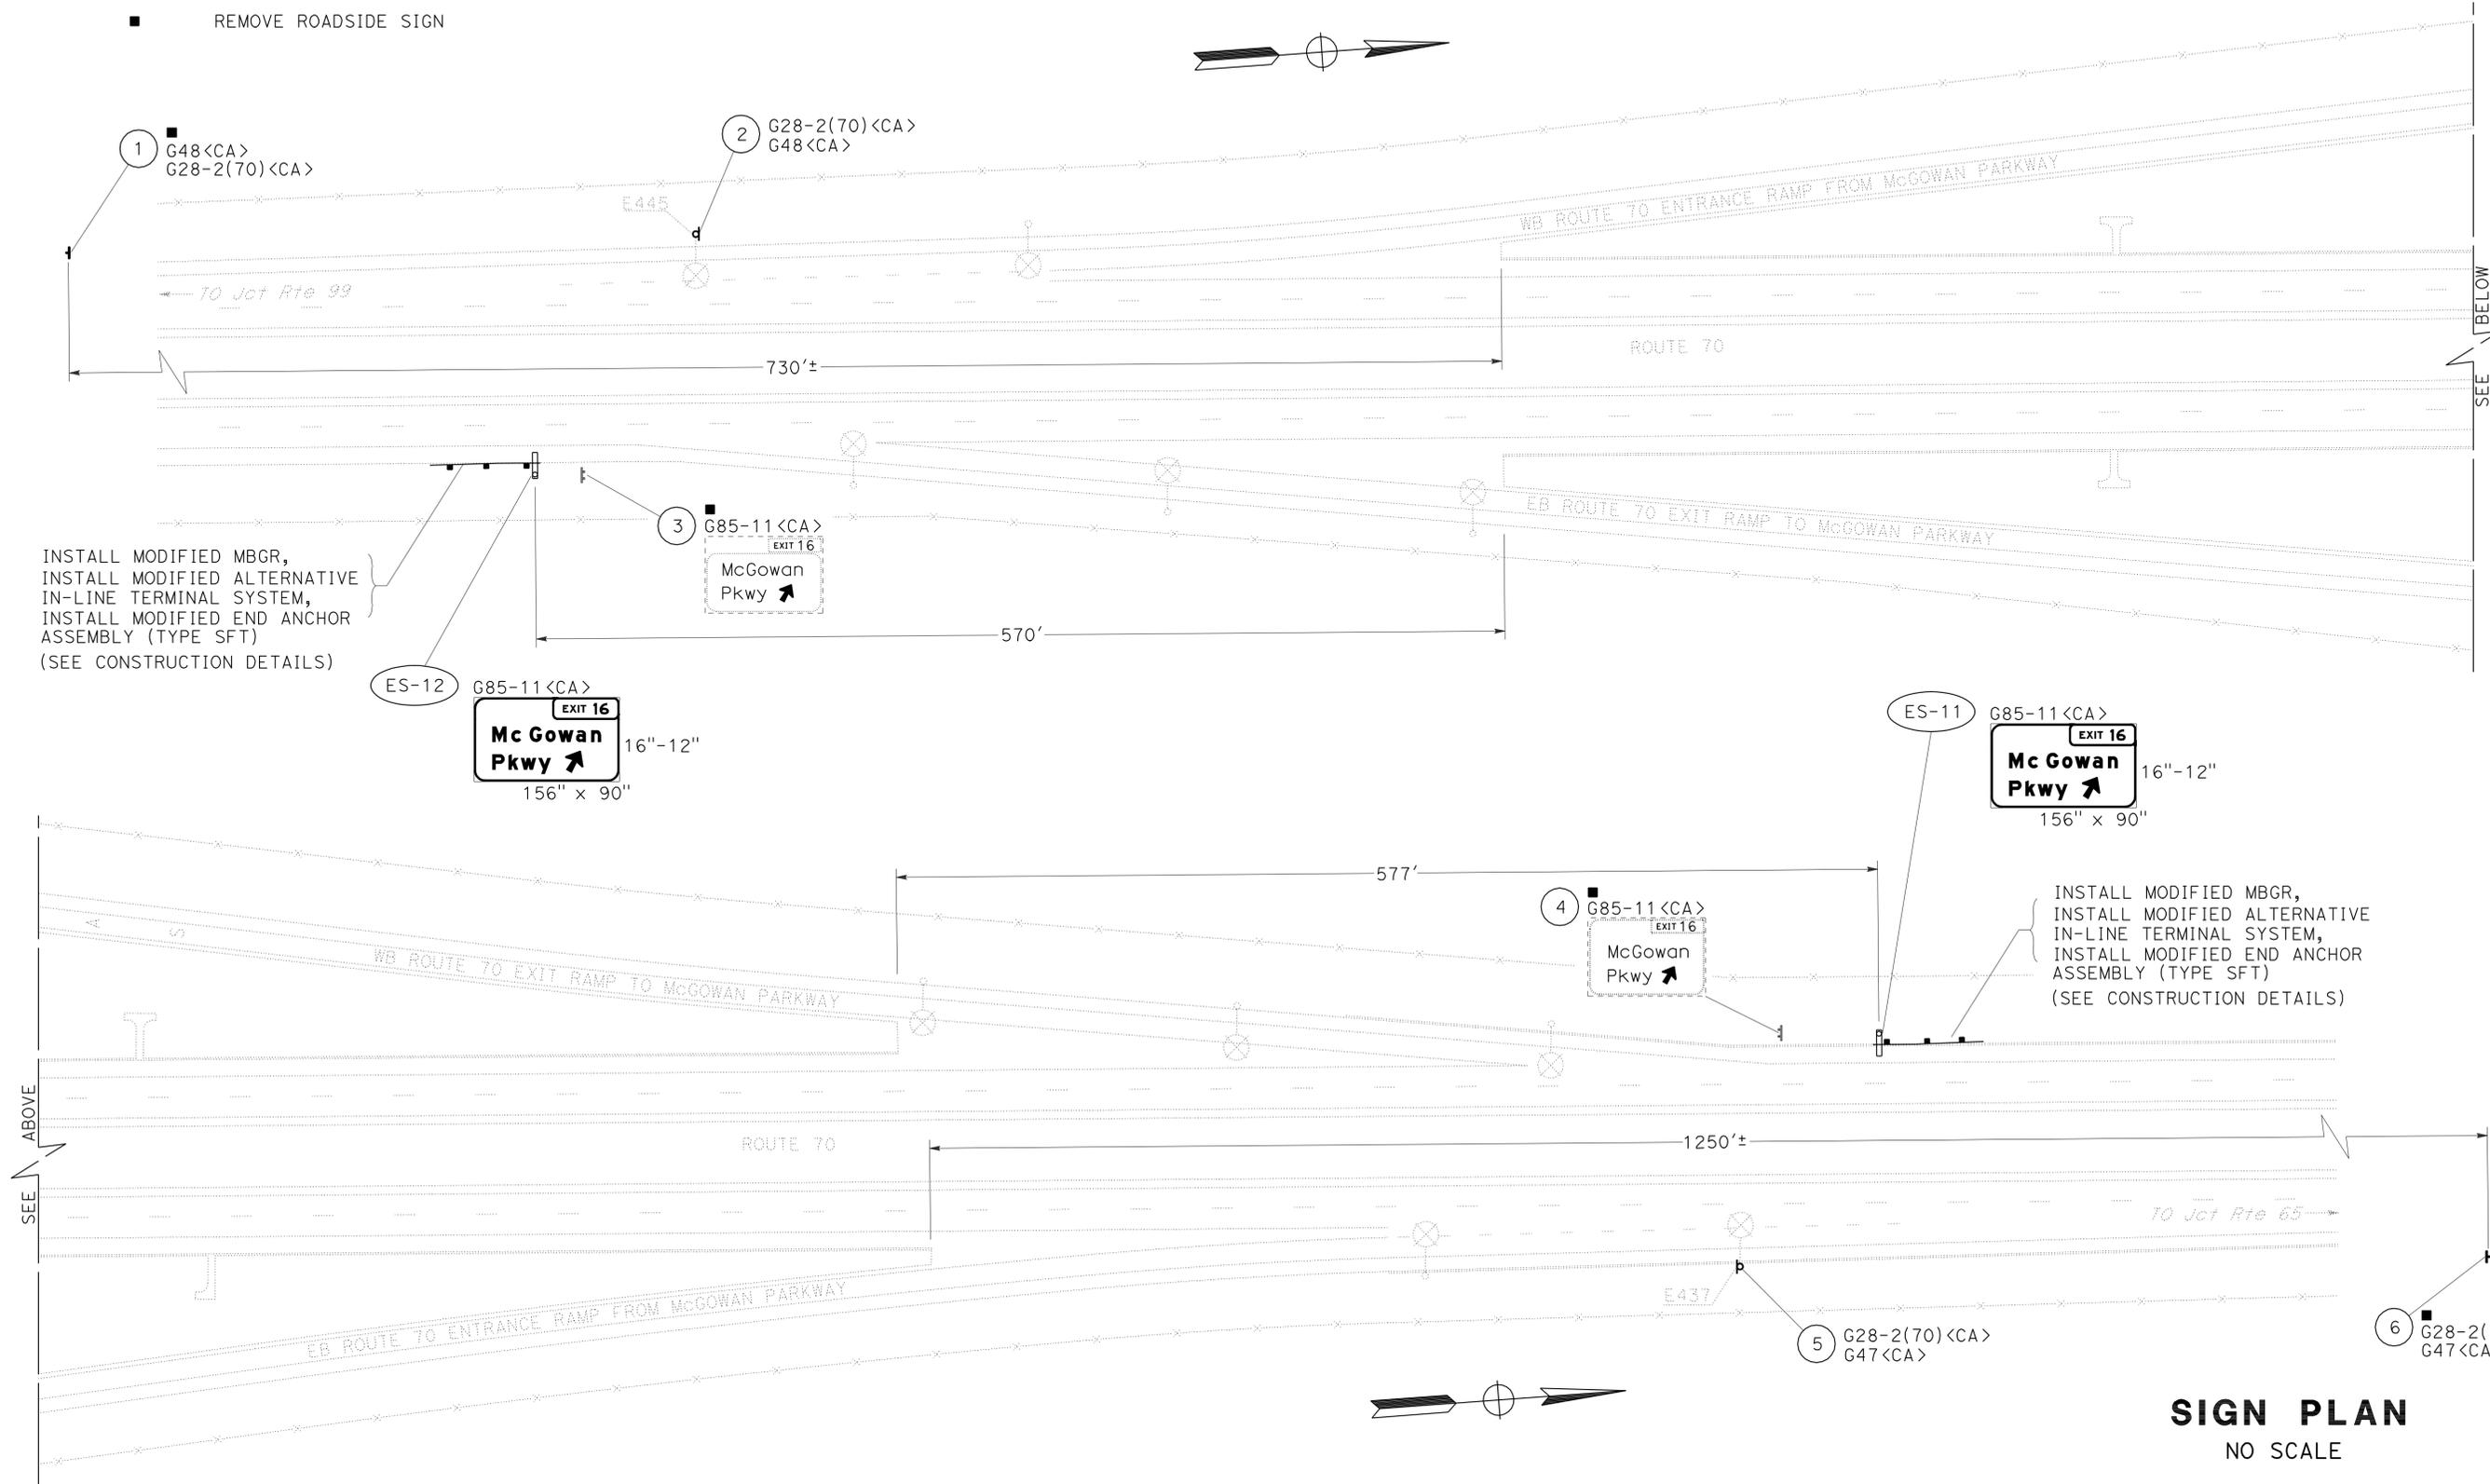


SIGN PLAN
NO SCALE

Dist	COUNTY	ROUTE	POST MILES TOTAL PROJECT	SHEET No.	TOTAL SHEETS
03	Yub	70	R7.0/R7.5	6	22

REGISTERED CIVIL ENGINEER *Jeffrey S. Jewett* DATE 2-10-11
 4-4-11
 PLANS APPROVAL DATE

REGISTERED PROFESSIONAL ENGINEER
 Jeffrey S. Jewett
 No. 49233
 Exp. 9-30-12
 CIVIL
 STATE OF CALIFORNIA



THE STATE OF CALIFORNIA OR ITS OFFICERS OR AGENTS SHALL NOT BE RESPONSIBLE FOR THE ACCURACY OR COMPLETENESS OF SCANNED COPIES OF THIS PLAN SHEET.

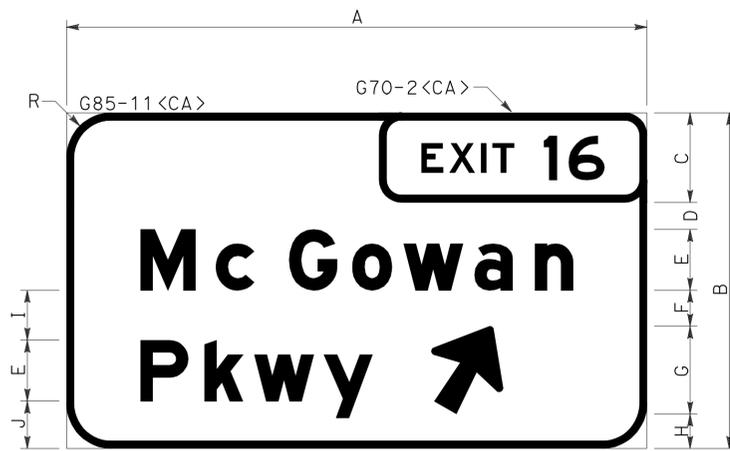

A	B	C	D	E	F	G	H	I	J	R
156"	90"	24"	7.3"	16"E Mod	10"	23.4"	9.3"	13.7"	13"	12"

2" BORDER
 ARROW 16" CAP-1L - 25" - 60°

OVERHEAD SIGN NUMBERS ES-11 AND ES-12

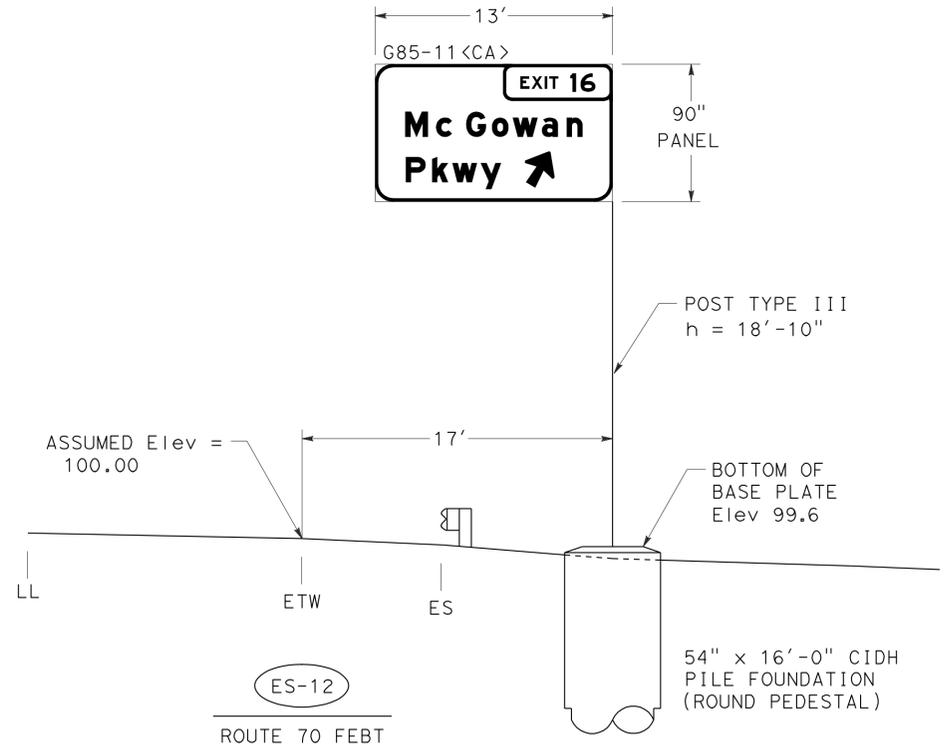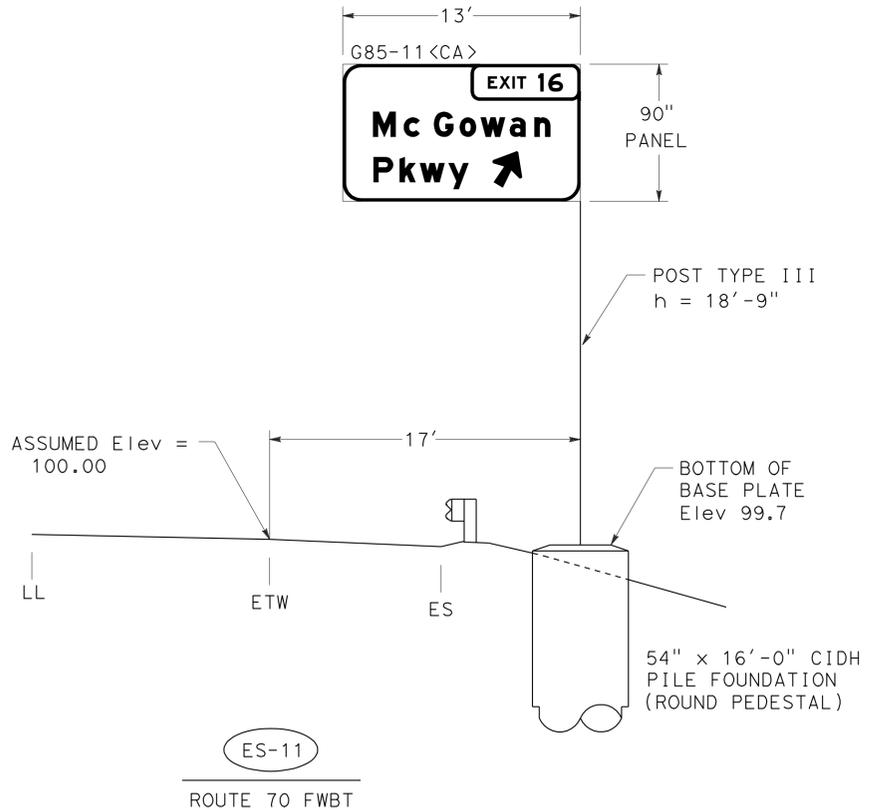

NOTES:

1. LL = LANELINE
2. h = DISTANCE FROM BOTTOM OF FRAME TO BOTTOM OF BASE PLATE.
3. OVERHEAD SIGN PANELS SHALL BE LAMINATED PANELS TYPE A.
4. ALL SIGN CODES ARE FEDERAL SIGN CODES UNLESS OTHERWISE DESIGNATED AS CALIFORNIA <CA> SIGN CODES.

SIGN DETAILS
 NO SCALE

SD-1

STATE OF CALIFORNIA - DEPARTMENT OF TRANSPORTATION

Caltrans

FUNCTIONAL SUPERVISOR: LAURIE LAMMERT

JACK KEMMERLY

REVISOR: JACK KEMMERLY

DATE: 7/2/2010

REVISIONS:

NO.	DESCRIPTION	DATE

Dist	COUNTY	ROUTE	POST MILES TOTAL PROJECT	SHEET No.	TOTAL SHEETS
03	Yub	70	R7.0/R7.5	8	22

Jaskaran Boparai
 REGISTERED ELECTRICAL ENGINEER DATE 2/9/11
 4-4-11
 PLANS APPROVAL DATE
 THE STATE OF CALIFORNIA OR ITS OFFICERS OR AGENTS SHALL NOT BE RESPONSIBLE FOR THE ACCURACY OR COMPLETENESS OF SCANNED COPIES OF THIS PLAN SHEET.



 
REGISTERED PROFESSIONAL ENGINEER
 JASKARAN SINGH BOPARAI
 No. E15056
 Exp. 12/31/11
 ELECTRICAL
 STATE OF CALIFORNIA

NOTE:

FOR ACCURATE RIGHT OF WAY DATA, CONTACT RIGHT OF WAY ENGINEERING AT THE DISTRICT OFFICE.


ABBREVIATIONS:

CTID CALTRANS IDENTIFICATION

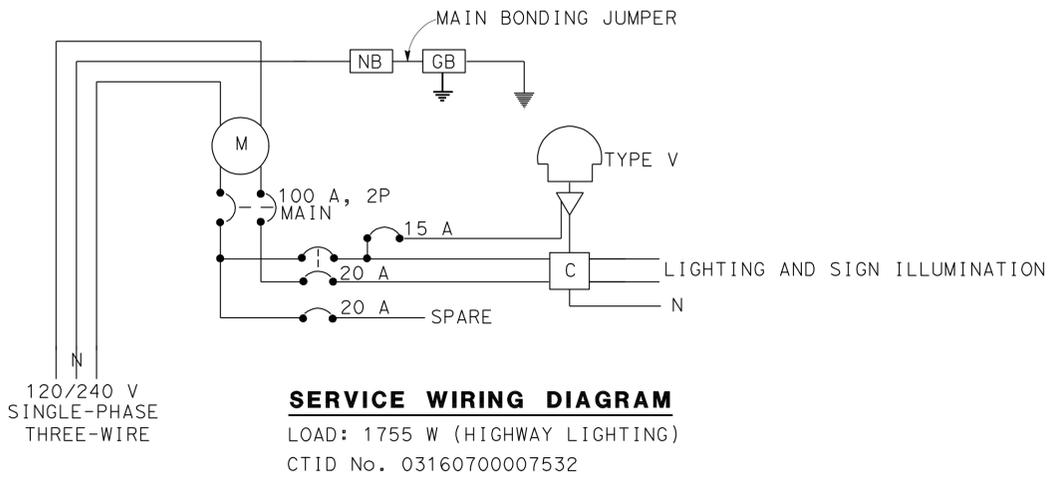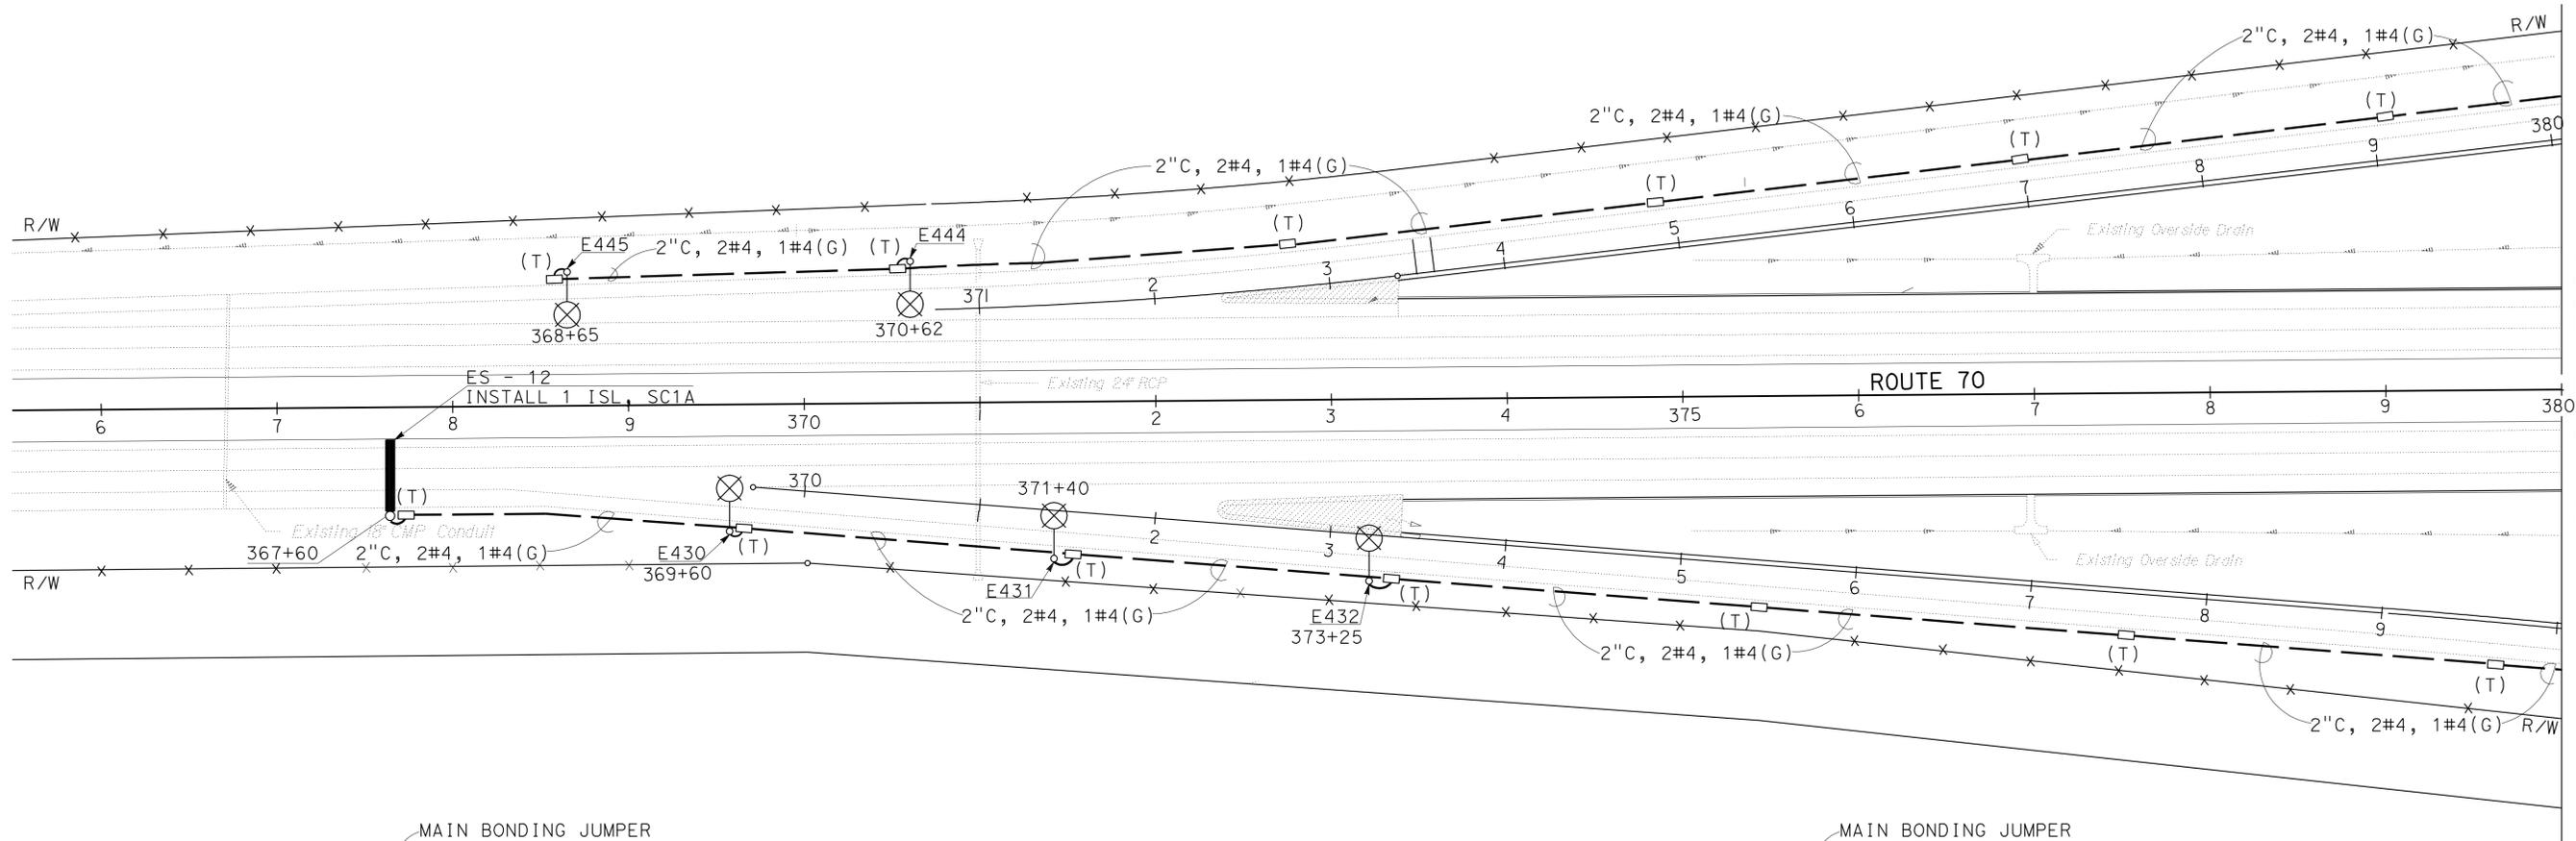

WIRING DIAGRAM LEGEND:

- (M) METER SOCKET AND SUPPORT
- (C) CONTACTOR
- (SN) SOLID NEUTRAL BUS
- ▽ AUTO TEST SWITCH
- ☉ PHOTOELECTRIC UNIT

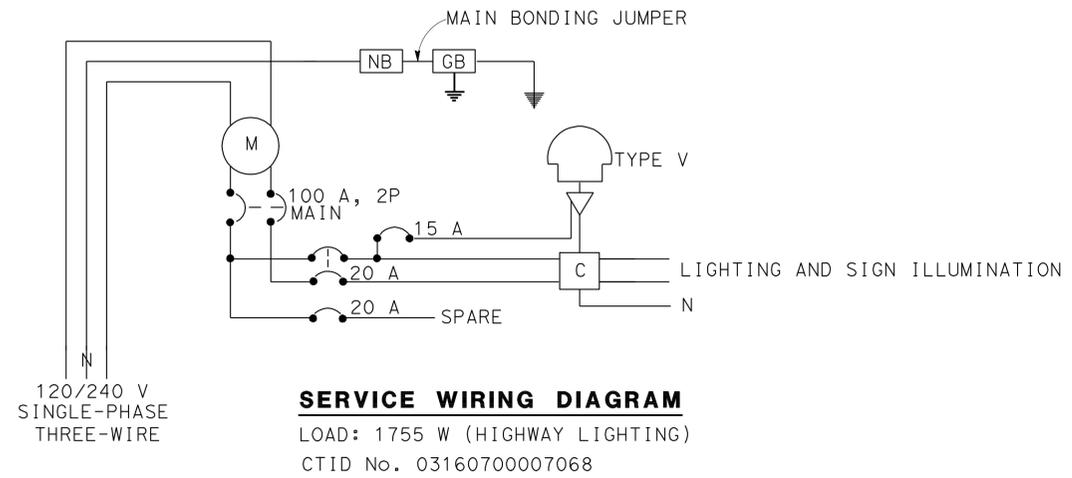

LIGHTING AND SIGN ILLUMINATION

SCALE: 1" = 50'

E-1

THIS PLAN IS ACCURATE FOR ELECTRICAL WORK ONLY.



LAST REVISION DATE PLOTTED => 11-APR-2011
 01-11-11 TIME PLOTTED => 10:21

STATE OF CALIFORNIA - DEPARTMENT OF TRANSPORTATION
 OFFICE OF ELECTRICAL DESIGN
 FUNCTIONAL SUPERVISOR STEVEN S LEE
 CALCULATED/DESIGNED BY CHECKED BY
 OANH D. NGUYEN JASKARAN BOPARAI
 REVISED BY DATE
 REVISIONS

MATCH LINE, SEE SHEET E-2

Dist	COUNTY	ROUTE	POST MILES TOTAL PROJECT	SHEET No.	TOTAL SHEETS
03	Yub	70	R7.0/R7.5	9	22


Jaskaran Bopara
 REGISTERED ELECTRICAL ENGINEER 2/9/11 DATE
 No. E15056
 Exp. 12/31/11
 ELECTRICAL
 STATE OF CALIFORNIA

4-4-11
 PLANS APPROVAL DATE
 THE STATE OF CALIFORNIA OR ITS OFFICERS OR AGENTS SHALL NOT BE RESPONSIBLE FOR THE ACCURACY OR COMPLETENESS OF SCANNED COPIES OF THIS PLAN SHEET.


PROJECT NOTES (THIS SHEET ONLY)

- INSTALL TYPE III-AF SERVICE EQUIPMENT ENCLOSURE CTID No. 03160700007532. FOR SERVICE WIRING DIAGRAM SEE SHEET E-1.
- INSTALL TYPE III-AF SERVICE EQUIPMENT ENCLOSURE CTID No. 03160700007068. FOR SERVICE WIRING DIAGRAM SEE SHEET E-1.
- INSTALL ULTILITY PULL BOX.

NOTE:
 FOR ACCURATE RIGHT OF WAY DATA, CONTACT RIGHT OF WAY ENGINEERING AT THE DISTRICT OFFICE.

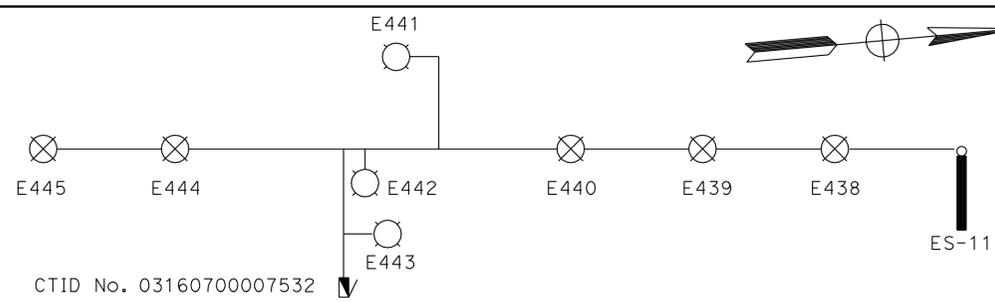

LIGHTING DIAGRAM

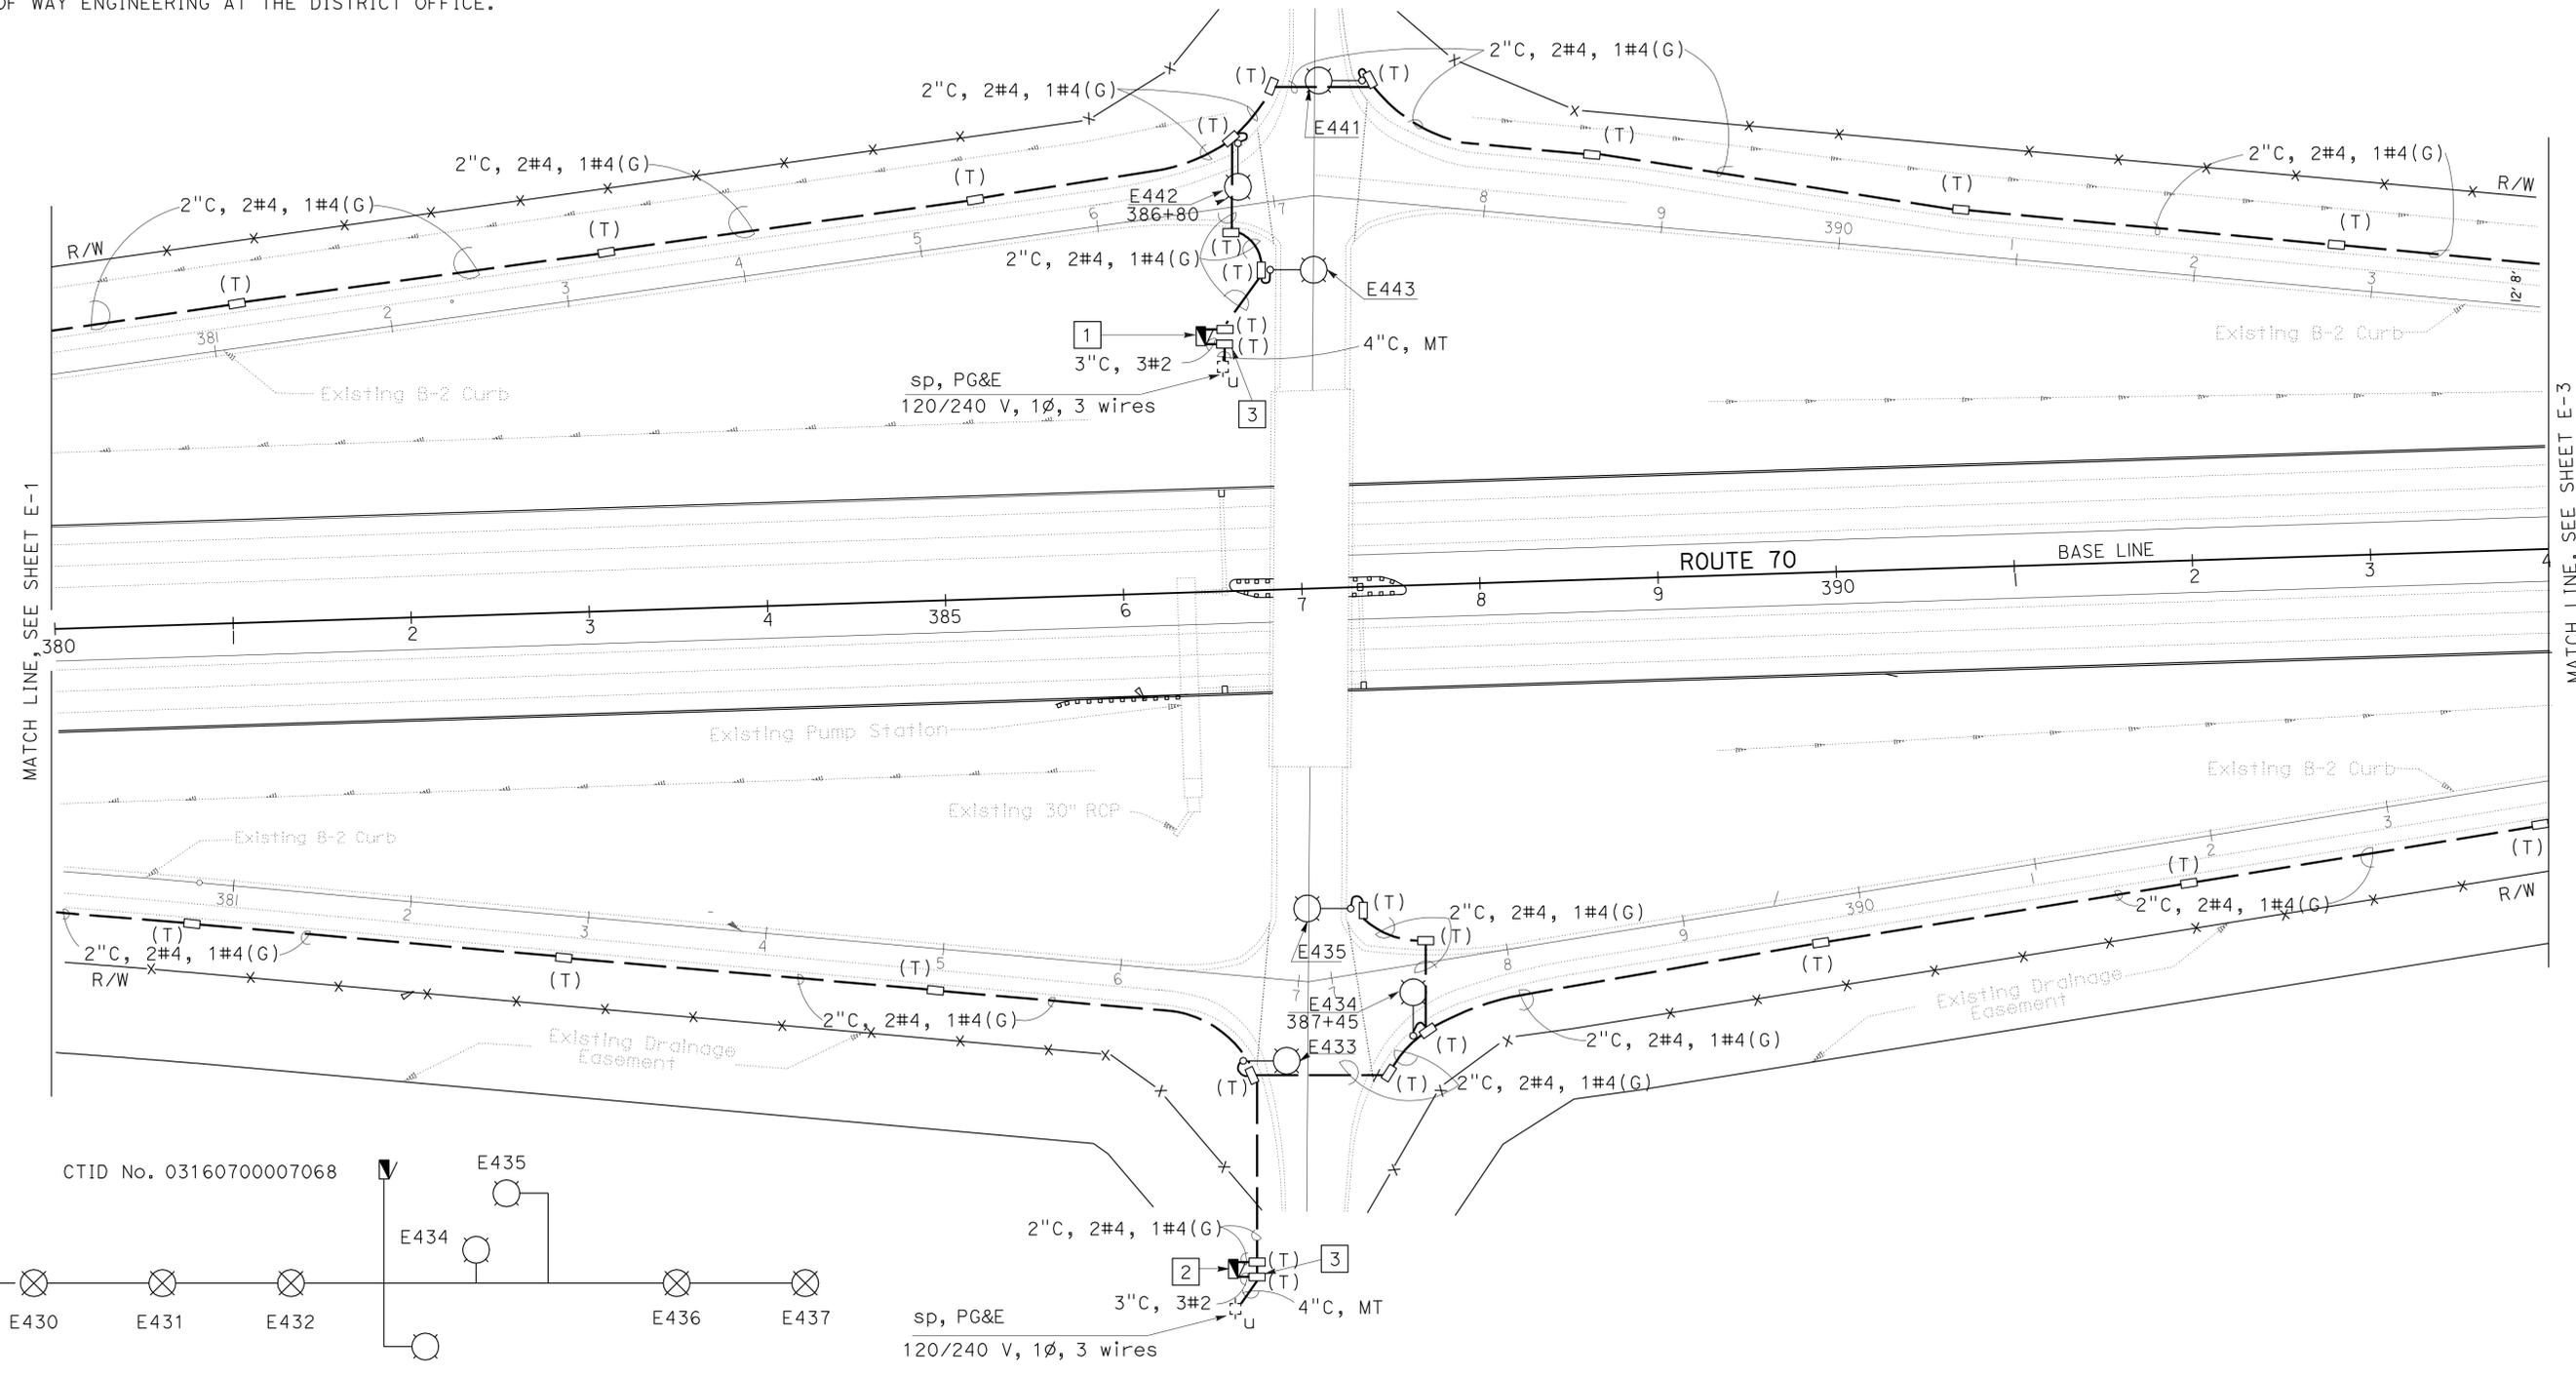

LIGHTING DIAGRAM

LIGHTING AND SIGN ILLUMINATION

THIS PLAN IS ACCURATE FOR ELECTRICAL WORK ONLY.

SCALE: 1" = 50'

E-2

STATE OF CALIFORNIA - DEPARTMENT OF TRANSPORTATION
 OFFICE OF ELECTRICAL DESIGN
 Steven S. Lee
 Functional Supervisor
 Oanh D. Nguyen
 Jaskaran Bopara
 Calculated/Designed by
 Checked by
 Revised by
 Date Revised

DATE PLOTTED => 11-APR-2011
 TIME PLOTTED => 10:22
 LAST REVISION
 1-11-11

Dist	COUNTY	ROUTE	POST MILES TOTAL PROJECT	SHEET No.	TOTAL SHEETS
03	Yub	70	7.0/R7.5	10	22


<i>Jaskaran Boparai</i>		2/9/11
REGISTERED ELECTRICAL ENGINEER	DATE	
4-4-11		
PLANS APPROVAL DATE		
<small>THE STATE OF CALIFORNIA OR ITS OFFICERS OR AGENTS SHALL NOT BE RESPONSIBLE FOR THE ACCURACY OR COMPLETENESS OF SCANNED COPIES OF THIS PLAN SHEET.</small>		

REGISTERED PROFESSIONAL ENGINEER
JASKARAN SINGH BOPARAI
 No. E15056
 Exp. 12/31/11
 ELECTRICAL
STATE OF CALIFORNIA

NOTE:

FOR ACCURATE RIGHT OF WAY DATA, CONTACT RIGHT OF WAY ENGINEERING AT THE DISTRICT OFFICE.

STATE OF CALIFORNIA - DEPARTMENT OF TRANSPORTATION	FUNCTIONAL SUPERVISOR	CALCULATED/DESIGNED BY	REVISOR
Caltrans OFFICE OF ELECTRICAL DESIGN	STEVEN S LEE	STEVEN S LEE	JOHN D. NGUYEN
		CHECKED BY	DATE
		JASKARAN BOPARAI	DATE

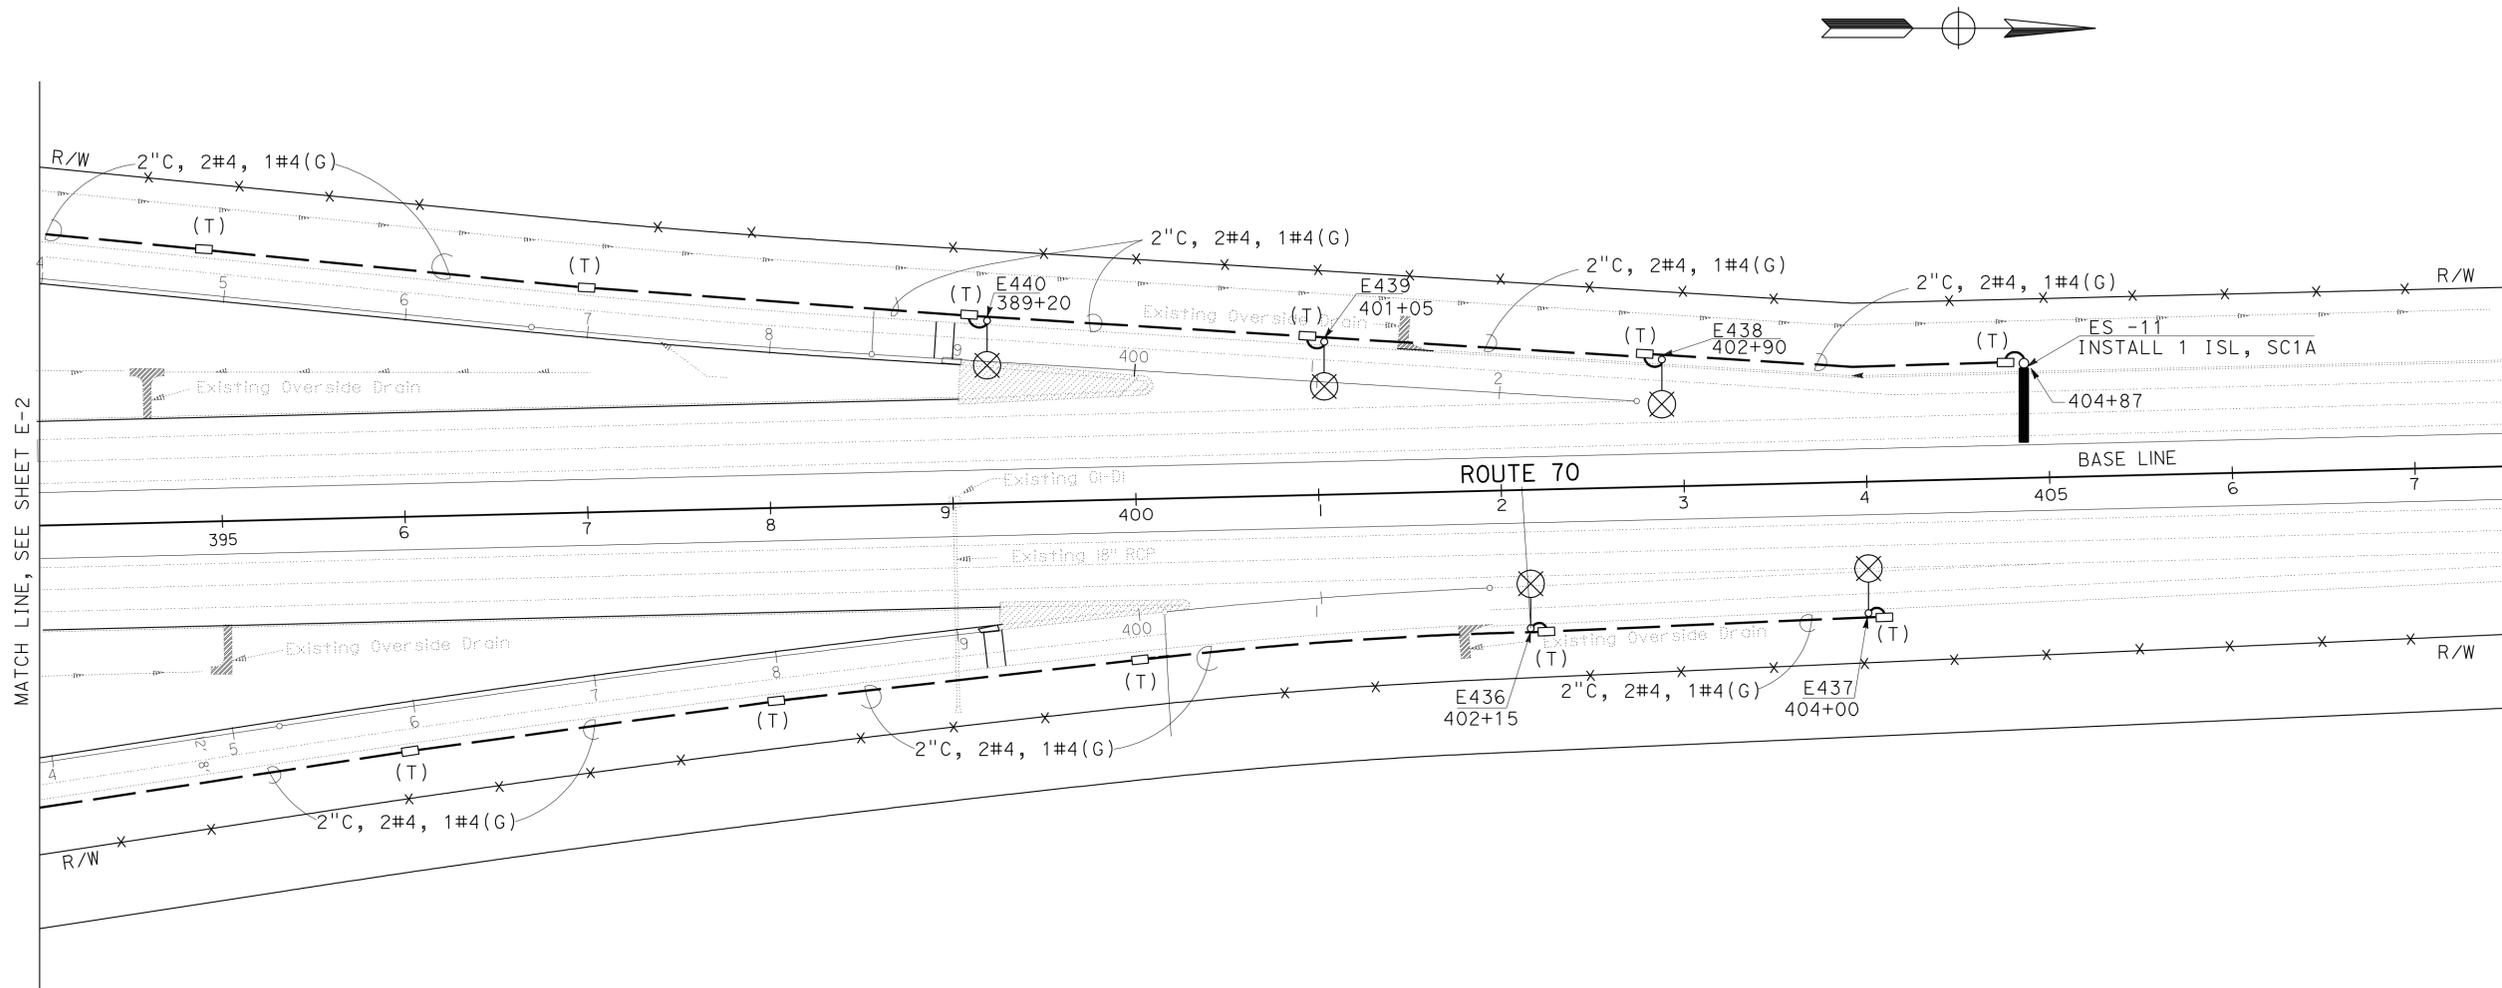


LIGHTING AND SIGN ILLUMINATION

SCALE: 1" = 50'

E-3

 THIS PLAN IS ACCURATE FOR ELECTRICAL WORK ONLY.



DIST	COUNTY	ROUTE	POST MILES TOTAL PROJECT	SHEET NO.	TOTAL SHEETS
03	Yub	70	R7.0/R7.5	11	22

Randell D. Hiatt
REGISTERED CIVIL ENGINEER


June 6, 2008
PLANS APPROVAL DATE

The State of California or its officers or agents shall not be responsible for the accuracy or completeness of electronic copies of this plan sheet.


To accompany plans dated 4-4-11

NOTES:

1. When necessary to place dike in front of face of guard railing, only Type C dike may be used. For dike details, see Standard Plan A87B.
2. For standard railing post embedment, see Standard Plans A77C3.
3. Guard railing delineation to be used where shown on the Project Plans.
4. When dike or curb is placed under guard railing, the maximum height of the dike or curb shall be 4". Mountable dike should not be used. For dike and curb details, see Revised Standard Plans RSP A87A and Standard Plan A87B.
5. For details of typical distance between the face of rail and hinge point, see Standard Plan A77C3.

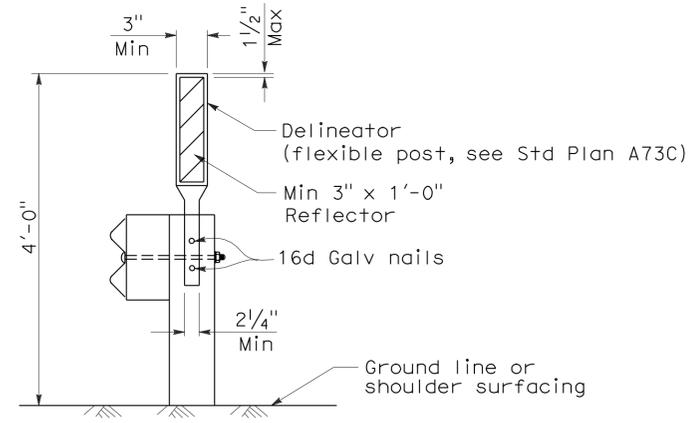

GUARD RAILING DELINEATION
See Note 3

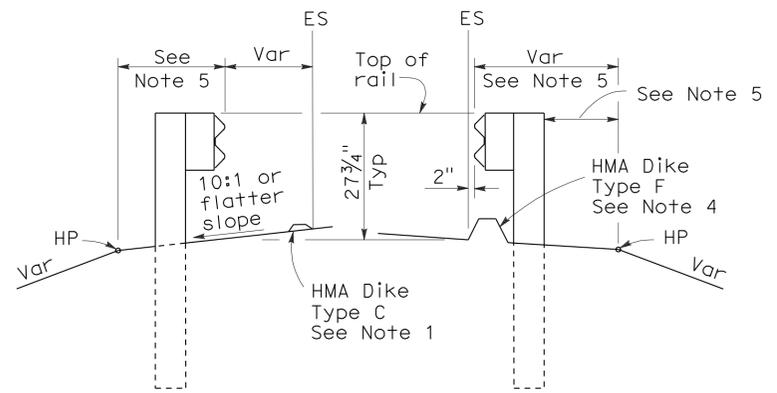

DIKE POSITIONING
See Note 1

STATE OF CALIFORNIA
DEPARTMENT OF TRANSPORTATION

**METAL BEAM GUARD RAILING
TYPICAL RAILING DELINEATION
AND DIKE POSITIONING DETAILS**

NO SCALE

RSP A77C4 DATED JUNE 6, 2008 SUPERSEDES STANDARD PLAN A77C4
DATED MAY 1, 2006 - PAGE 47 OF THE STANDARD PLANS BOOK DATED MAY 2006.

REVISED STANDARD PLAN RSP A77C4

2006 REVISED STANDARD PLAN RSP A77C4


DIST	COUNTY	ROUTE	POST MILES TOTAL PROJECT	SHEET NO.	TOTAL SHEETS
03	Yub	70	R7.0/R7.5	12	22

Randell D. Hiatt
REGISTERED CIVIL ENGINEER

June 6, 2008
PLANS APPROVAL DATE


The State of California or its officers or agents shall not be responsible for the accuracy or completeness of electronic copies of this plan sheet.

STATE OF CALIFORNIA
REGISTERED PROFESSIONAL ENGINEER
No. C50200
Exp. 6-30-09
CIVIL

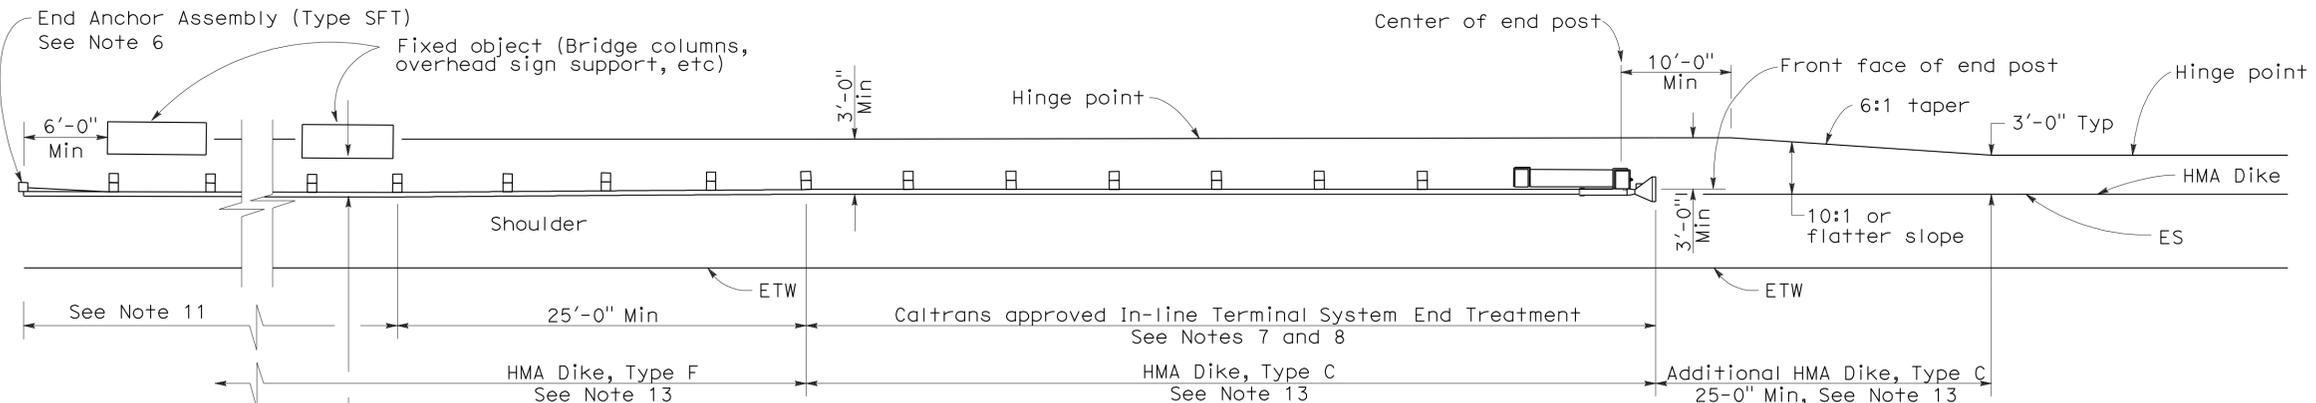


TYPE 16A LAYOUT

(GUARD RAILING INSTALLATION AT ROADSIDE FIXED OBJECT OR OBJECTS WITH AN IN-LINE END TREATMENT AT TRAFFIC APPROACH END OF RAILING)
See Notes 12 and 13

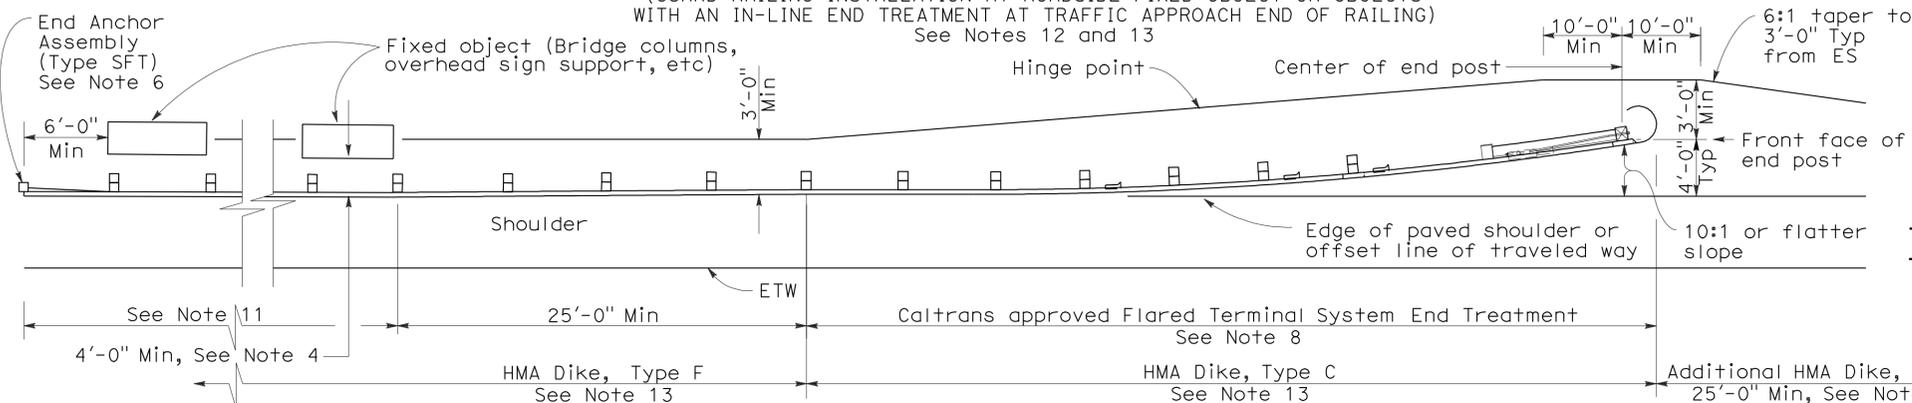


TYPE 16B LAYOUT

(GUARD RAILING INSTALLATION AT ROADSIDE FIXED OBJECT OR OBJECTS WITH A FLARED END TREATMENT AT TRAFFIC APPROACH END OF RAILING)
See Notes 12 and 13

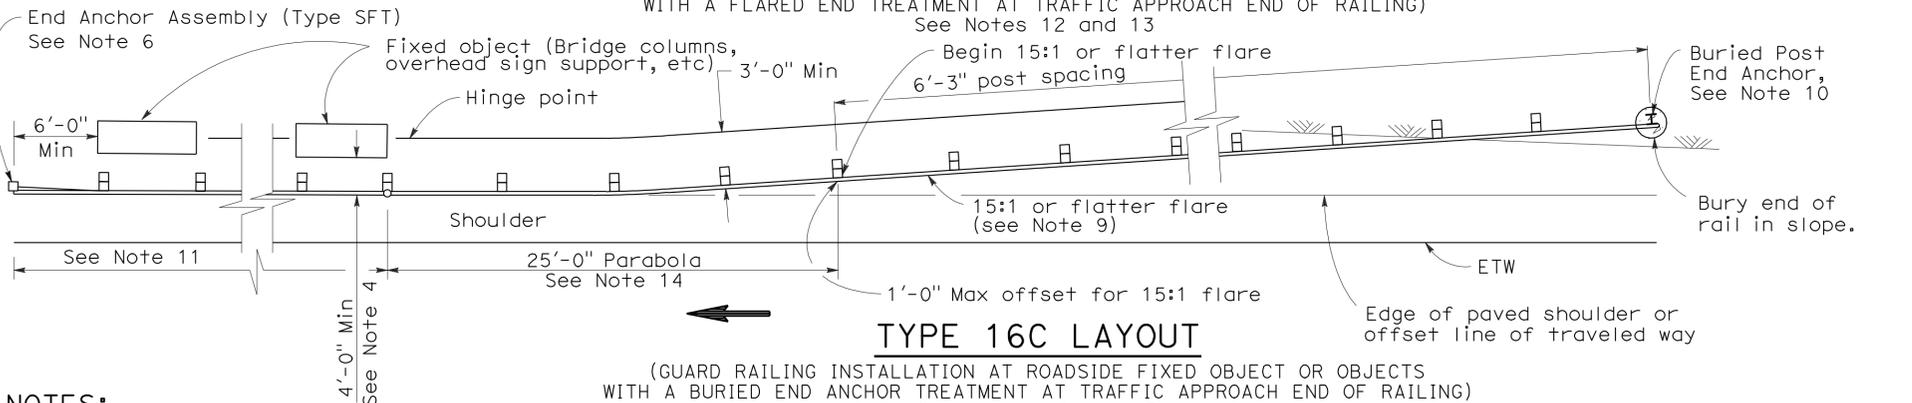


TYPE 16C LAYOUT

(GUARD RAILING INSTALLATION AT ROADSIDE FIXED OBJECT OR OBJECTS WITH A BURIED END ANCHOR TREATMENT AT TRAFFIC APPROACH END OF RAILING)
See Notes 12 and 13

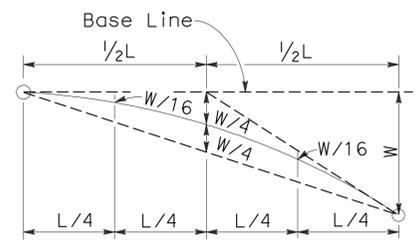

TYPICAL PARABOLIC LAYOUT

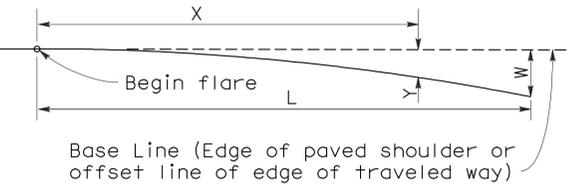


Base Line (Edge of paved shoulder or offset line of edge of traveled way)
Y = Offset from base line
W = Maximum offset
X = Distance along base line
L = Length of flare

PARABOLIC FLARE OFFSETS

NOTES:

- Line post, blocks and hardware to be used are shown on Revised Standard Plans A77A1, A77A2, A77B1, A77C1 and A77C2.
- Guard railing post spacing to be 6'-3" center to center, except as otherwise noted.
- Except as noted, line posts are 6" x 8" x 6'-0" wood with 6" x 8" x 1'-2" wood blocks. W6 x 9 steel posts, 6'-0" in length, with 6" x 8" x 1'-2" notched wood blocks or notched recycled plastic blocks may be used for 6" x 8" x 6'-0" wood line posts with 6" x 8" x 1'-2" wood blocks where applicable and when specified.
- A 4'-0" minimum clearance is required between the face of the railing and the face of a fixed object located directly behind standard guard railing sections with post spacing of 6'-3". Construct guard railing as shown in the detail "Strengthened Railing Sections for Fixed Objects" on this plan, where the clearance between the face of the railing and the face of a fixed object is less than 4'-0", but not less than 2'-3". Where the clearance is less than 2'-3", a concrete wall or barrier should be constructed to shield the fixed object(s).
- Direction of adjacent traffic indicated by \rightarrow .
- For End Anchor Assembly (Type SFT) details, see Standard Plan A77H1.
- In-line Terminal System End Treatments are used where site conditions will not accommodate a flared end treatment.
- The type of terminal system to be used will be shown on the Project Plans.
- The 15:1 or flatter flare used with Type 16C Layout is based on the edge of the paved shoulder or offset line of edge of the traveled way. The length of guard railing within the 15:1 or flatter flare is based on site conditions and should be a length equal to multiples of 12'-6".
- For details of the Buried Post End Anchor used with Type 16C Layout, see Standard Plan A77I2.
- As site conditions dictate, construct additional guard railing to shield fixed object(s). Additional guard railing length equal to multiples of 12'-6". Post spacing at 6'-3" except as specified in Note 4.
- Layout Types 16A, 16B or 16C are typically used where guard railing is recommended to shield roadside fixed object(s) and a crashworthy end treatment is required for only one direction of traffic.
- Where placement of dike is required with guard railing, see Revised Standard Plan RSP A77C4 for dike positioning details.
- For typical flare offsets for 25'-0" length parabola with maximum offset of 1'-0", see Revised Standard Plan RSP A77E1.
- W6 x 15 steel post, 8'-0" in length, with 8" x 8" x 1'-2" notched wood block or notched recycled plastic blocks may be used in place of the 10" x 10" x 8'-0" wood post with 8" x 8" x 1'-2" wood block shown in the "Strengthened Railing Sections Detail".

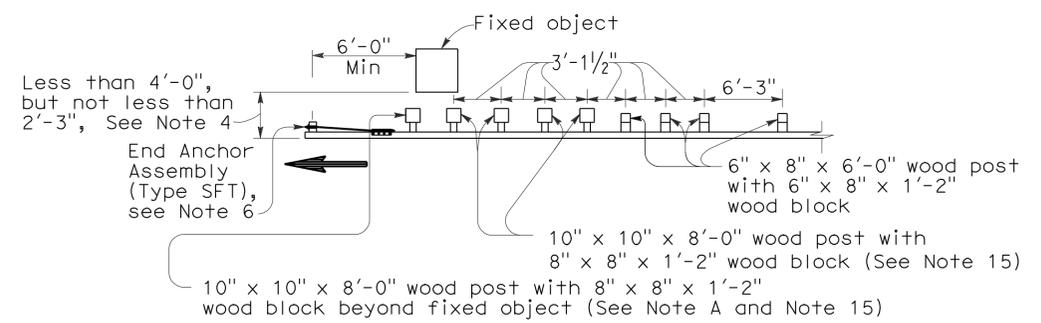

NOTE A: For a series of fixed objects (bridge columns, overhead sign supports, etc.) additional 10" x 10" x 8'-0" wood post with 8" x 8" x 1'-2" wood blocks at 3'-1/2" center to center spacing are to be used between fixed objects.

STRENGTHENED RAILING SECTIONS FOR FIXED OBJECT

Use strengthened railing sections with Types 16A, 16B or 16C Layouts where minimum clearance between the face of the guard railing and fixed object(s) is less than 4'-0", but not less than 2'-3". See Note 4

STATE OF CALIFORNIA
DEPARTMENT OF TRANSPORTATION
METAL BEAM GUARD RAILING TYPICAL LAYOUTS FOR ROADSIDE FIXED OBJECTS

NO SCALE
RSP A77G3 DATED JUNE 6, 2008 SUPERSEDES STANDARD PLAN A77G3
DATED MAY 1, 2006 - PAGE 61 OF THE STANDARD PLANS BOOK DATED MAY 2006.

REVISED STANDARD PLAN RSP A77G3

2006 REVISED STANDARD PLAN RSP A77G3

DIST	COUNTY	ROUTE	POST MILES TOTAL PROJECT	SHEET NO.	TOTAL SHEETS
03	Yub	70	R7.0/R7.5	13	22


Randell D. Hiatt
REGISTERED CIVIL ENGINEER

June 6, 2008
PLANS APPROVAL DATE

Randell D. Hiatt
No. C50200
Exp. 6-30-09
CIVIL
STATE OF CALIFORNIA


The State of California or its officers or agents shall not be responsible for the accuracy or completeness of electronic copies of this plan sheet.

To accompany plans dated 4-4-11

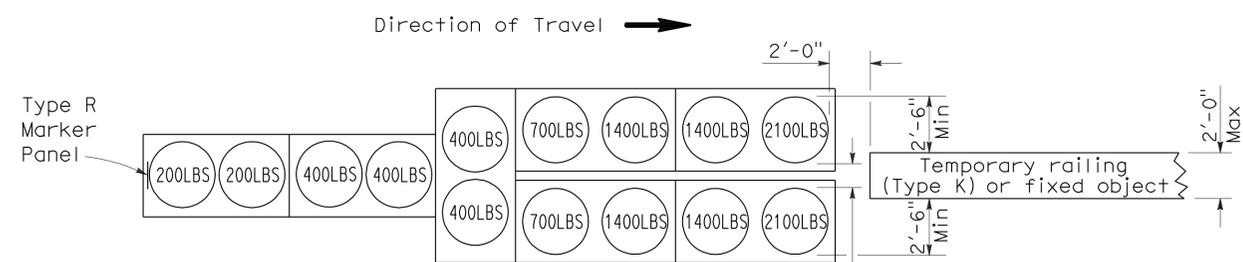


ARRAY 'TU14'

Approach speed 45 mph or more

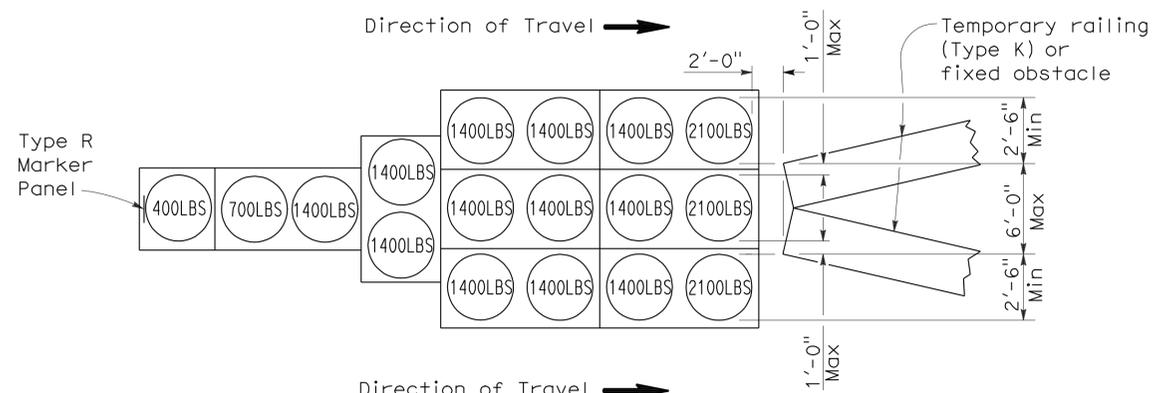


ARRAY 'TU17'

Approach speed less than 45 mph

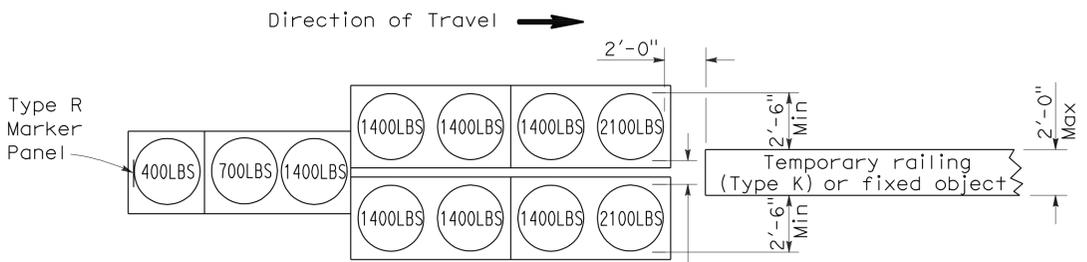


ARRAY 'TU11'

Approach speed less than 45 mph

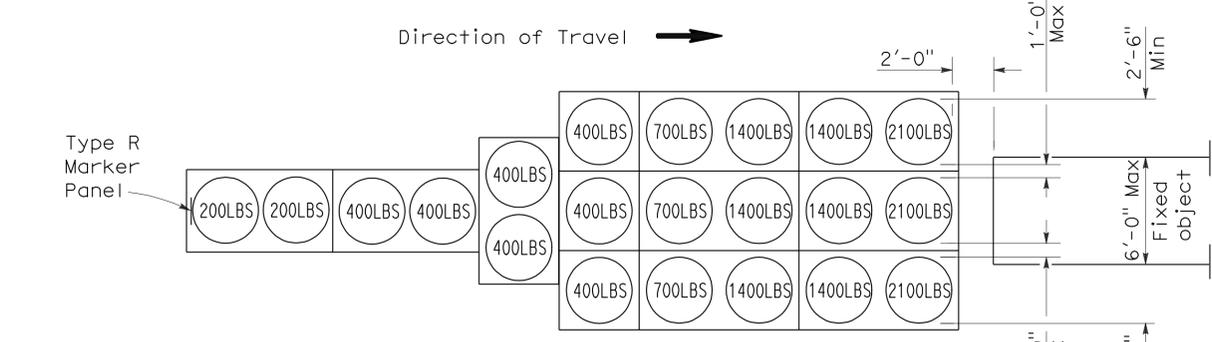


ARRAY 'TU21'

Approach speed 45 mph or more

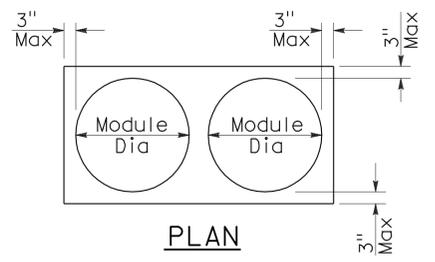

PLAN

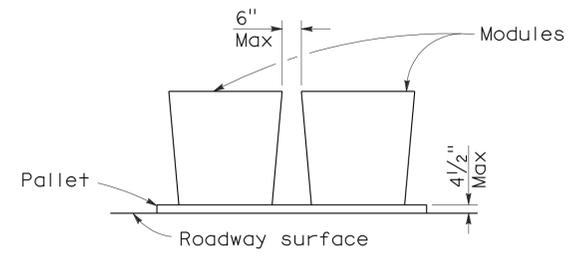

ELEVATION

CRASH CUSHION PALLET DETAIL

See Note 7

NOTES:

1. (XXX) Indicates sand filled module location and weight of sand in pounds for each module. Module spacing is based on the greater diameter of the module.
2. All sand weights are nominal.
3. Temporary crash cushion arrays shall not encroach on the traveled way.
4. Place the top of Type R marker panel 1" below the module lid.
5. Refer to Standard Plan A73B for marker details.
6. Approach speeds indicated conform to NCHRP 350 Report criteria.
7. Use of pallets is optional.

STATE OF CALIFORNIA
DEPARTMENT OF TRANSPORTATION

**TEMPORARY CRASH CUSHION,
SAND FILLED
(UNIDIRECTIONAL)**

NO SCALE

RSP T1A DATED JUNE 6, 2008 SUPERSEDES STANDARD PLAN T1A
DATED MAY 1, 2006 - PAGE 211 OF THE STANDARD PLANS BOOK DATED MAY 2006.

REVISED STANDARD PLAN RSP T1A

2006 REVISED STANDARD PLAN RSP T1A


DIST	COUNTY	ROUTE	POST MILES TOTAL PROJECT	SHEET NO.	TOTAL SHEETS
03	Yub	70	R7.0/R7.5	14	22

Randell D. Hiatt
REGISTERED CIVIL ENGINEER

June 6, 2008
PLANS APPROVAL DATE


The State of California or its officers or agents shall not be responsible for the accuracy or completeness of electronic copies of this plan sheet.

To accompany plans dated 4-4-11

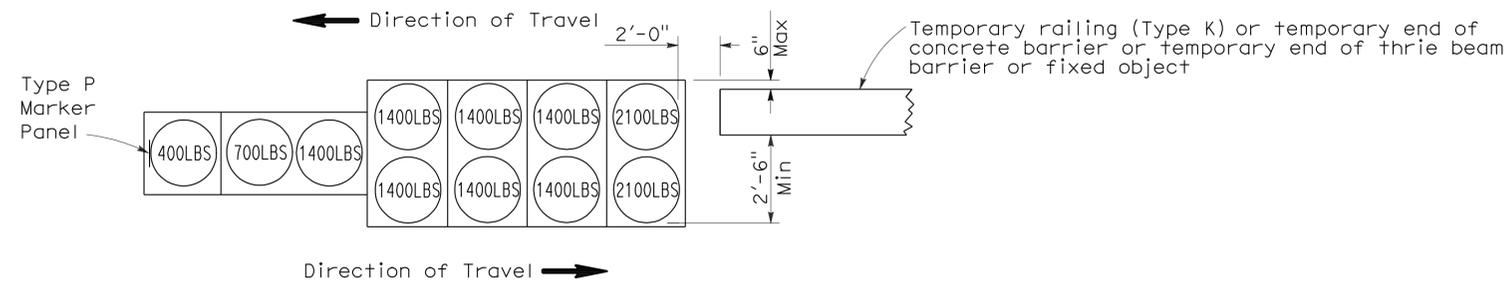



ARRAY 'TB11'

Approach speed less than 45 mph

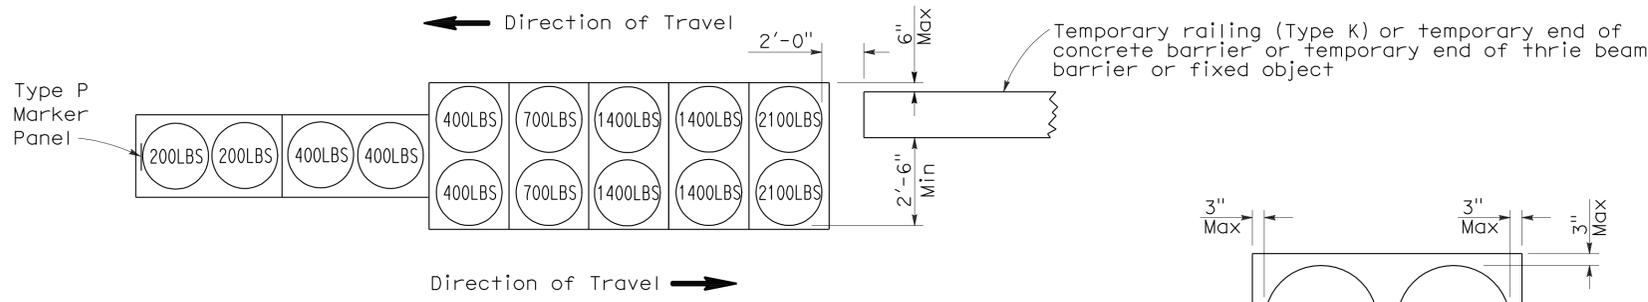

ARRAY 'TB14'

Approach speed 45 mph or more

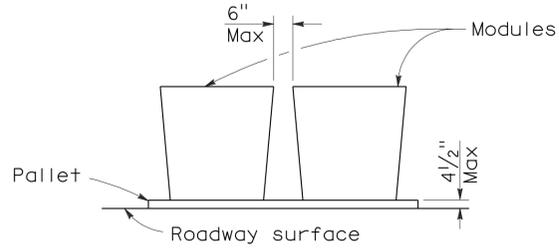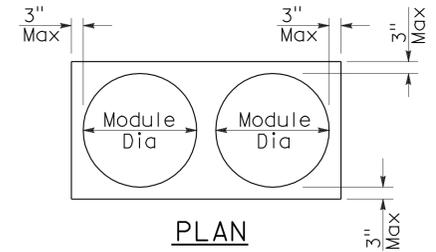

CRASH CUSHION PALLET DETAIL
See Note 7

NOTES:

1. (XXX) Indicates sand filled module location and weight of sand in pounds for each module. Module spacing is based on the greater diameter of the module.
2. All sand weights are nominal.
3. Temporary crash cushion arrays shall not encroach on the traveled way.
4. Place the Type P marker panel so that the bottom of the panel rests upon the pallet.
5. Refer to Standard Plan A73B for marker details.
6. Approach speeds indicated conform to NCHRP 350 Report criteria.
7. Use of pallets is optional.

STATE OF CALIFORNIA
DEPARTMENT OF TRANSPORTATION
**TEMPORARY CRASH CUSHION,
SAND FILLED
(BIDIRECTIONAL)**

NO SCALE
RSP T1B DATED JUNE 6, 2008 SUPERSEDES STANDARD PLAN T1B
DATED MAY 1, 2006 - PAGE 212 OF THE STANDARD PLANS BOOK DATED MAY 2006.

REVISED STANDARD PLAN RSP T1B

2006 REVISED STANDARD PLAN RSP T1B

DIST	COUNTY	ROUTE	POST MILES TOTAL PROJECT	SHEET NO.	TOTAL SHEETS
03	Yub	70	R7.0/R7.5	15	22


Randell D. Hiatt
REGISTERED CIVIL ENGINEER

June 6, 2008
PLANS APPROVAL DATE


Randell D. Hiatt
REGISTERED PROFESSIONAL ENGINEER
No. C50200
Exp. 6-30-09
CIVIL
STATE OF CALIFORNIA

The State of California or its officers or agents shall not be responsible for the accuracy or completeness of electronic copies of this plan sheet.


To accompany plans dated 4-4-11

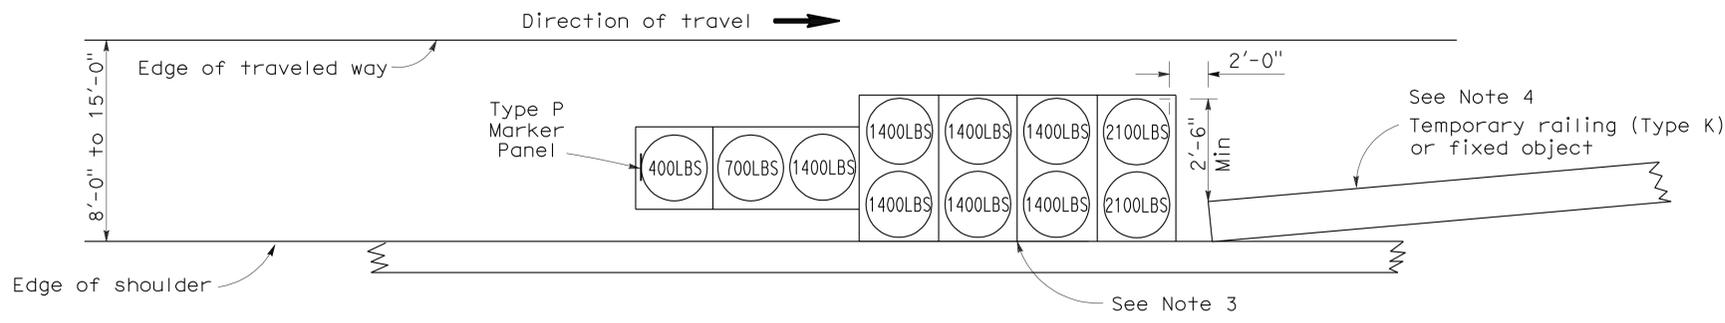

ARRAY 'TS11'
Approach speed less than 45 mph
See Note 9

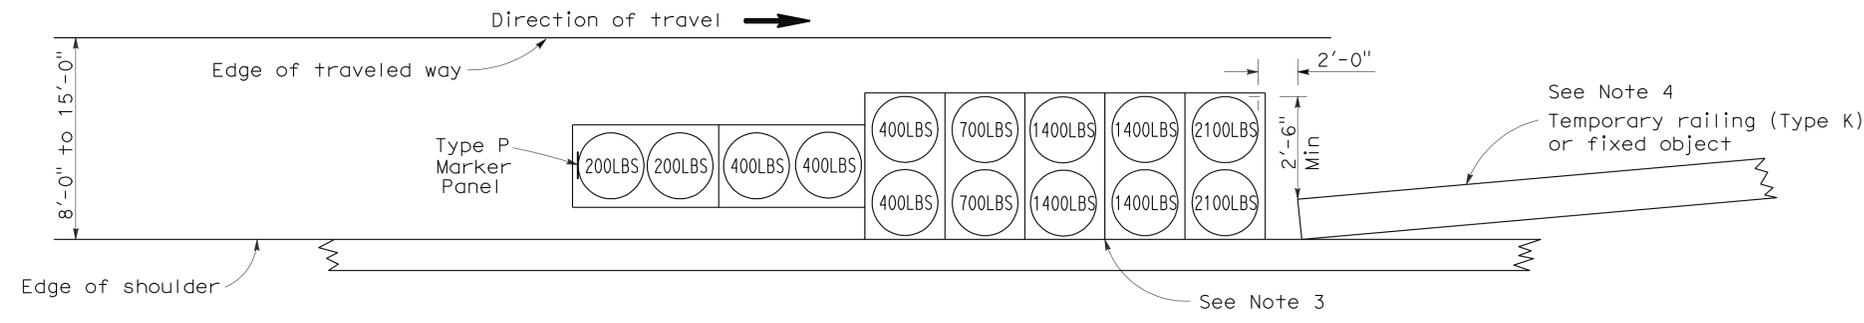

ARRAY 'TS14'
Approach speed 45 mph or more
See Note 9

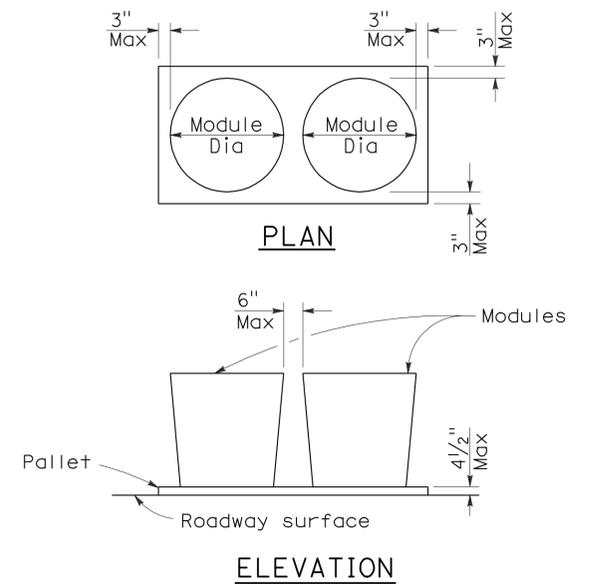

CRASH CUSHION PALLET DETAIL
See Note 11

NOTES:

1. (XXX) Indicates sand filled module location and weight of sand in pounds for each module. Module spacing is based on the greater diameter of the module.
2. All sand weights are nominal.
3. The temporary crash cushion arrays shown on this plan shall be used only in locations where there will be traffic on one side of the temporary crash cushion array.
4. If the fixed object or approach end of the temporary railing is less than 15'-0" from the edge of traveled way, a temporary crash cushion is required in a construction or work zone.
5. Temporary crash cushion arrays shall not encroach on the traveled way.
6. Arrays for median shoulders shall conform to details shown on this plan for outside shoulders.
7. Place the Type P marker panel so that the bottom of the panel rests upon the pallet and faces traffic.
8. Refer to Standard Plan A73B for marker details.
9. For shoulder widths less than 8'-0", appropriate approved crash cushion protection, other than sand filled modules, shall be provided at fixed objects and at approach ends of temporary railing. The specific type of crash cushion shall be as shown on the project plans or as specified in the Special Provisions, or if not shown on the project plans or specified in the Special Provisions, shall be as approved by the Engineer.
10. Approach speeds indicated conform to NCHRP 350 Report criteria.
11. Use of pallets is optional.

 

STATE OF CALIFORNIA
DEPARTMENT OF TRANSPORTATION
**TEMPORARY CRASH CUSHION,
SAND FILLED
(SHOULDER INSTALLATIONS)**

NO SCALE
RSP T2 DATED JUNE 6, 2008 SUPERSEDES STANDARD PLAN T2
DATED MAY 1, 2006 - PAGE 213 OF THE STANDARD PLANS BOOK DATED MAY 2006.

REVISED STANDARD PLAN RSP T2

2006 REVISED STANDARD PLAN RSP T2

ELECTROLIERS

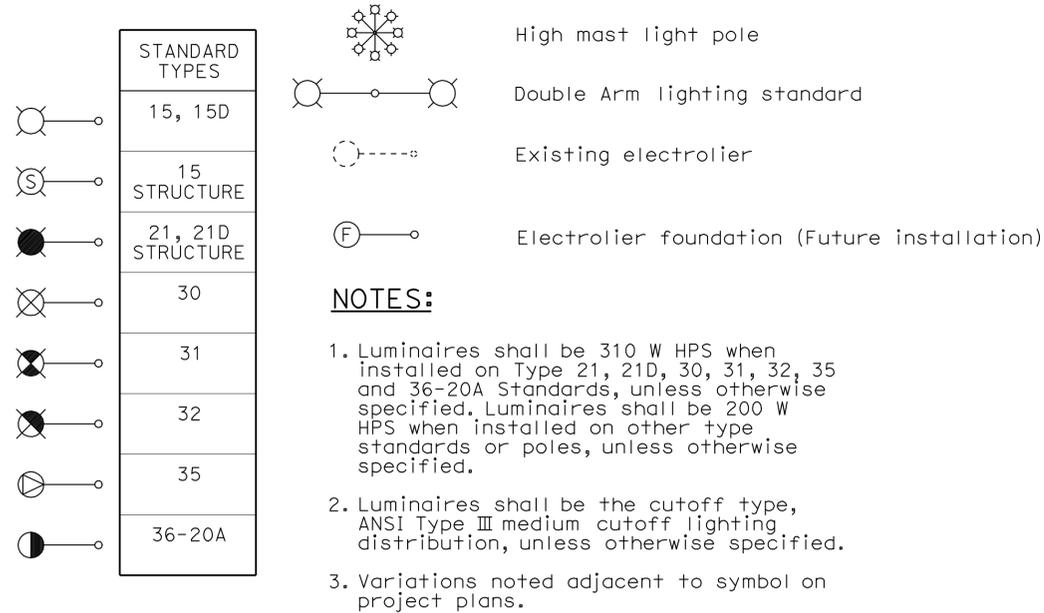

STANDARD NOTES:

- AB** Abandon. If applied to conduit, remove conductors.
- BC** Install pull box in existing conduit run.
- BP** Pedestrian barricade, type as indicated on plan.
- CB** Install conduit into existing pull box.
- CC** Connect new and existing conduit. Remove existing conductors and install conductors as indicated.
- CF** Conduit to remain for future use. Remove conductors. Install pull wire or rope.
- DH** Detector handhole.
- FA** Foundation to be abandoned.
- IS** Install sign on signal mast arm.
- NS** No slip base on standard.
- PEC** Photoelectric control.
- PEU** Photoelectric unit.
- RC** Equipment or material to be removed and become the property of the Contractor.
- RE** Remove electrolier, fuses and ballast. Tape ends of conductors.
- RL** Relocate equipment.
- RR** Remove and reuse equipment.
- RS** Remove and salvage equipment.
- SC** Splice new to existing conductors.
- SD** Service disconnect.
- SF** Standard to remain for future use. Remove luminaire, pole conductors, fuses and ballast.
- TSP** Telephone service point.

ABBREVIATIONS AND EQUIPMENT DESIGNATIONS

PROPOSED EXISTING

BBS	bbs	Battery backup system
BC	bc	Bolt circle
C	C	Conduit
CCTV	cctv	Closed circuit television
CKT	ckt	Circuit
CMS	cms	Changeable message sign
DLC	dlc	Loop detector lead-in cable
EMS	ems	Extinguishable message sign
EVC	evc	Emergency vehicle cable
EVD	evd	Emergency vehicle detector
FB	fb	Flashing beacon
FBCA	fbca	Flashing beacon control assembly
FBS	fbs	Flashing beacon with slip base
FO	fo	Fiber optic
G	G	Ground (Equipment Grounding Conductor)
GFCI	GFCI	Ground fault circuit interrupt
HAR	har	Highway advisory radio
HEX	hex	Hexagonal
HPS	hps	High pressure sodium
IISNS	iisns	Internally illuminated street name sign
ISL	isl	Induction sign lighting
LED	led	Light emitting diode
LMA	lma	Luminaire mast arm
LPS	lps	Low pressure sodium
LTG	ltg	Lighting
LUM	lum	Luminaire
MAT	mat	Mast arm mounting vehicle signal faces, top attachment
MAS	mas	Mast arm mounting vehicle signal faces, side attachment
MAS-4A	mas-4A	Mast arm mounting vehicle signal faces, top attachment
MAS-4B	mas-4B	Mast arm mounting vehicle signal faces, side attachment - 4 signal section
MAS-4C	mas-4C	Mast arm mounting vehicle signal faces, side attachment - 4 signal section
MAS-5A	mas-5A	Mast arm mounting vehicle signal faces, top attachment
MAS-5B	mas-5B	Mast arm mounting vehicle signal faces, side attachment - 5 signal section
MC	mc	Mercury contactor
M/M	m/m	Multiple to multiple transformer
MT	mt	Conduit with pull wire or rope only
MTG	mtg	Mounting
	mv	Mercury vapor lighting fixture
N	N	Neutral (Grounded Conductor)
NC	NC	Normally closed
NO	NO	Normally open
PB	pb	Pull box
PEC	pec	Photoelectric control (Type I, II, III, IV or V as shown)
PED	ped	Pedestrian
PEU	peu	Photoelectric unit
PPB	ppb	Pedestrian push button
RL	rl	Relocated equipment
RM	rm	Ramp metering
SB	sb	Slip base
SIC	sic	Signal interconnect cable
SIG	sig	Signal
SMA	sma	Signal mast arm
SNS	sns	Street name sign
SP	sp	Service point
TDC	tdc	Telephone demarcation cabinet
TMS	tms	Traffic monitoring station
TOS	tos	Traffic Operations System
VEH	veh	Vehicle
XFMR	xfmr	Transformer
COMM	comm	Communication
RWIS	rwis	Roadway weather information system

DIST	COUNTY	ROUTE	POST MILES TOTAL PROJECT	SHEET NO.	TOTAL SHEETS
03	Yub	70	R7.0/R7.5	16	22

Jeffery G. McRae
REGISTERED ELECTRICAL ENGINEER


October 5, 2007
PLANS APPROVAL DATE

REGISTERED PROFESSIONAL ENGINEER
Jeffery G. McRae
No. E14512
Exp. 6-30-08
ELECTRICAL
STATE OF CALIFORNIA

The State of California or its officers or agents shall not be responsible for the accuracy or completeness of electronic copies of this plan sheet.

To accompany plans dated 4-4-11

SOFFIT AND WALL MOUNTED LUMINAIRES

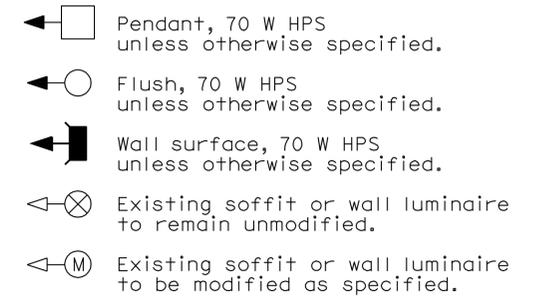

NOTE:

Arrow indicates "street side" of luminaire.

STATE OF CALIFORNIA
DEPARTMENT OF TRANSPORTATION

ELECTRICAL SYSTEMS (SYMBOLS AND ABBREVIATIONS)

NO SCALE

RSP ES-1A DATED OCTOBER 5, 2007 SUPERSEDES STANDARD PLAN ES-1A DATED MAY 1, 2006 - PAGE 400 OF THE STANDARD PLANS BOOK DATED MAY 2006.

REVISED STANDARD PLAN RSP ES-1A

2006 REVISED STANDARD PLAN RSP ES-1A

DIST	COUNTY	ROUTE	POST MILES TOTAL PROJECT	SHEET NO.	TOTAL SHEETS
03	Yub	70	R7.0/R7.5	17	22

Jeffery G. McRae
 REGISTERED ELECTRICAL ENGINEER
 No. E14512
 Exp. 6-30-08
 ELECTRICAL
 STATE OF CALIFORNIA

October 5, 2007
 PLANS APPROVAL DATE

The State of California or its officers or agents shall not be responsible for the accuracy or completeness of electronic copies of this plan sheet.

To accompany plans dated 4-4-11

CONDUIT

PROPOSED	EXISTING	
		Lighting Conduit, unless otherwise indicated or noted
		Traffic signal conduit
		Communication conduit
		Telephone conduit
		Fire alarm conduit
		Fiber optic conduit
		Conduit termination
		Conduit riser in/on structure or service pole


SIGNAL EQUIPMENT

PROPOSED	EXISTING	
		Pedestrian signal face
		Pedestrian push button post
		Pedestrian barricade
		Vehicle signal face (with backplate, 3-Section: red, yellow and green)
		Vehicle signal face with angle visors
		Modifications of basic symbols: "L" indicates all non-arrow sections louvered "LG" indicates louvered green section only "PV" indicates 12" programmed visibility sections "8" indicates all 8" sections (only when specified)
		Type 15TS and Vehicle signal face
		Vehicle signal face with red, yellow and green left arrow sections
		Vehicle signal face with red and yellow sections and up green arrow
		Vehicle signal face (5 Section) with red, yellow and green sections and yellow and green right arrows
		Type 1 Standard and attached vehicle signal faces
		Standard with signal mast arm only and attached vehicle signal faces and internally illuminated street name sign
		Type 33 Standard, Left-turn vehicle signal face and sign
		Standard with luminaire and signal mast arms and attached vehicle signal faces
		Cantilever flashing beacon Type 9 Frame, with a sign unless otherwise specified or indicated
		Type 15-FBS Standard with two vehicle signal face sections with lens, backplate and visor with a sign
		Flashing beacon. One vehicle signal face section with lens, backplate and visor. "R" indicates red indication, "Y" indicates yellow indication
		Controller assembly. Door indicates front of cabinet

SERVICE EQUIPMENT

PROPOSED	EXISTING	
		Overhead lines
		Wood pole "U" indicates utility owned
		Pole guy with anchor
		Utility transformer - ground mounted
		Service equipment enclosure type
		Service equipment enclosure door indicates front of enclosure
		Telephone demarcation cabinet

POLE-MOUNTED SERVICE DESIGNATION

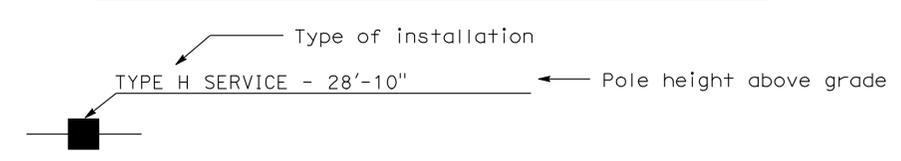

ILLUMINATED OVERHEAD SIGN

PROPOSED	EXISTING	
		Overhead sign - Single post
		Overhead sign - Two post
		Overhead sign - Mounted on structure
		Overhead sign with electrolier

SIGNAL EQUIPMENT Cont

PROPOSED	EXISTING	
		Guard post
		Type 1 Standard with "Meter On" sign
		Emergency Vehicle detector

NOTES:

- All signal sections shall be 12" unless shown otherwise.
- Signal heads shall be provided with backplates unless shown otherwise.
- Signal indication shall be LED.

STATE OF CALIFORNIA
 DEPARTMENT OF TRANSPORTATION
**ELECTRICAL SYSTEMS
 (SYMBOLS AND ABBREVIATIONS)**
 NO SCALE


RSP ES-1B DATED OCTOBER 5, 2007 SUPERCEDES STANDARD PLAN ES-1B
 DATED MAY 1, 2006 - PAGE 401 OF THE STANDARD PLANS BOOK DATED MAY 2006.

REVISED STANDARD PLAN RSP ES-1B


2006 REVISED STANDARD PLAN RSP ES-1B

EQUIPMENT IDENTIFICATION


ILLUMINATED SIGN IDENTIFICATION NUMBER:

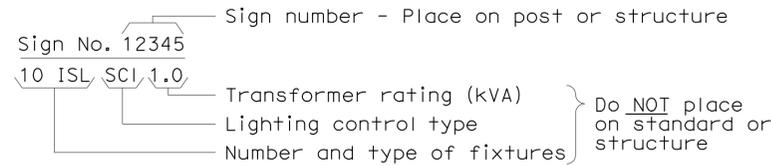


ELECTROLIER OR EQUIPMENT IDENTIFICATION NUMBER:

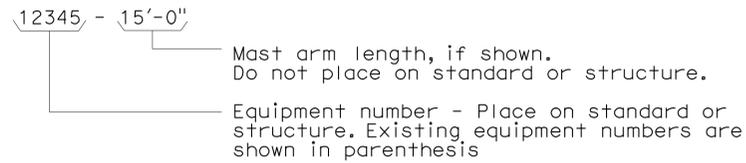


CONDUIT AND CONDUCTOR IDENTIFICATION:

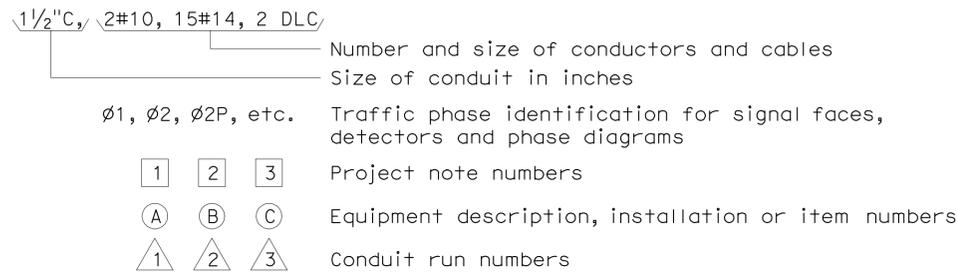


SIGNAL AND LIGHTING STANDARD (TYPICAL DESIGNATION):

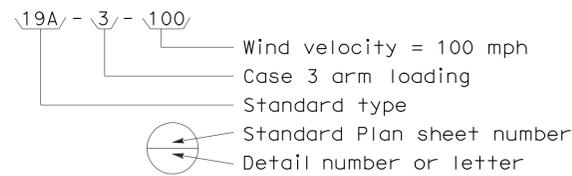


MISCELLANEOUS EQUIPMENT

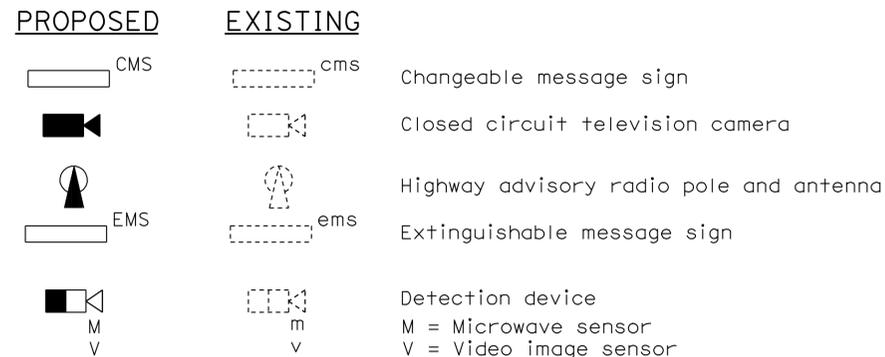


WIRING DIAGRAM LEGEND

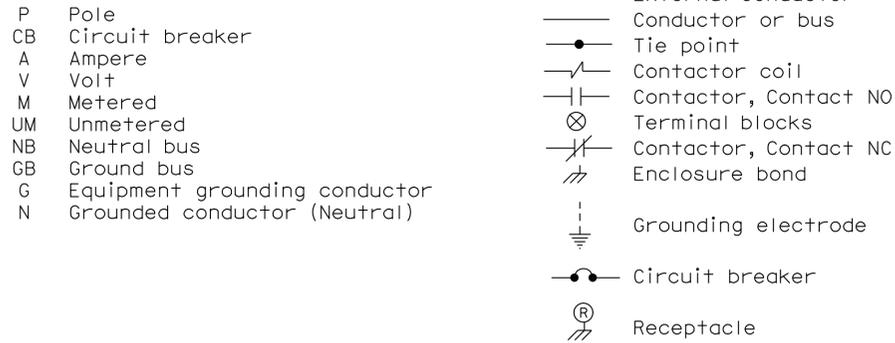

PULL BOXES

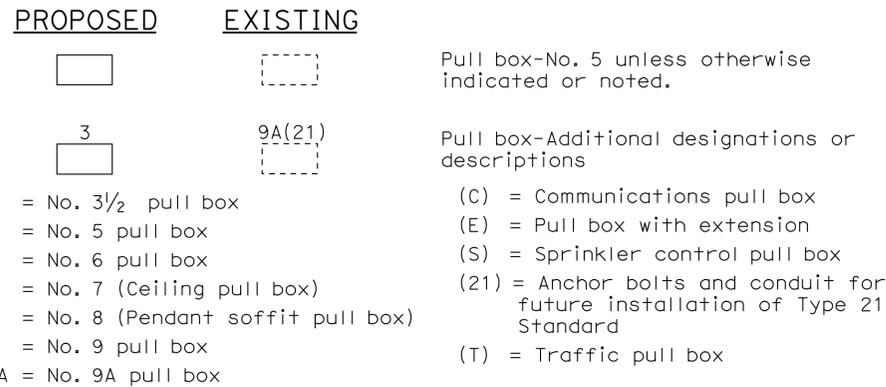

VEHICLE DETECTORS

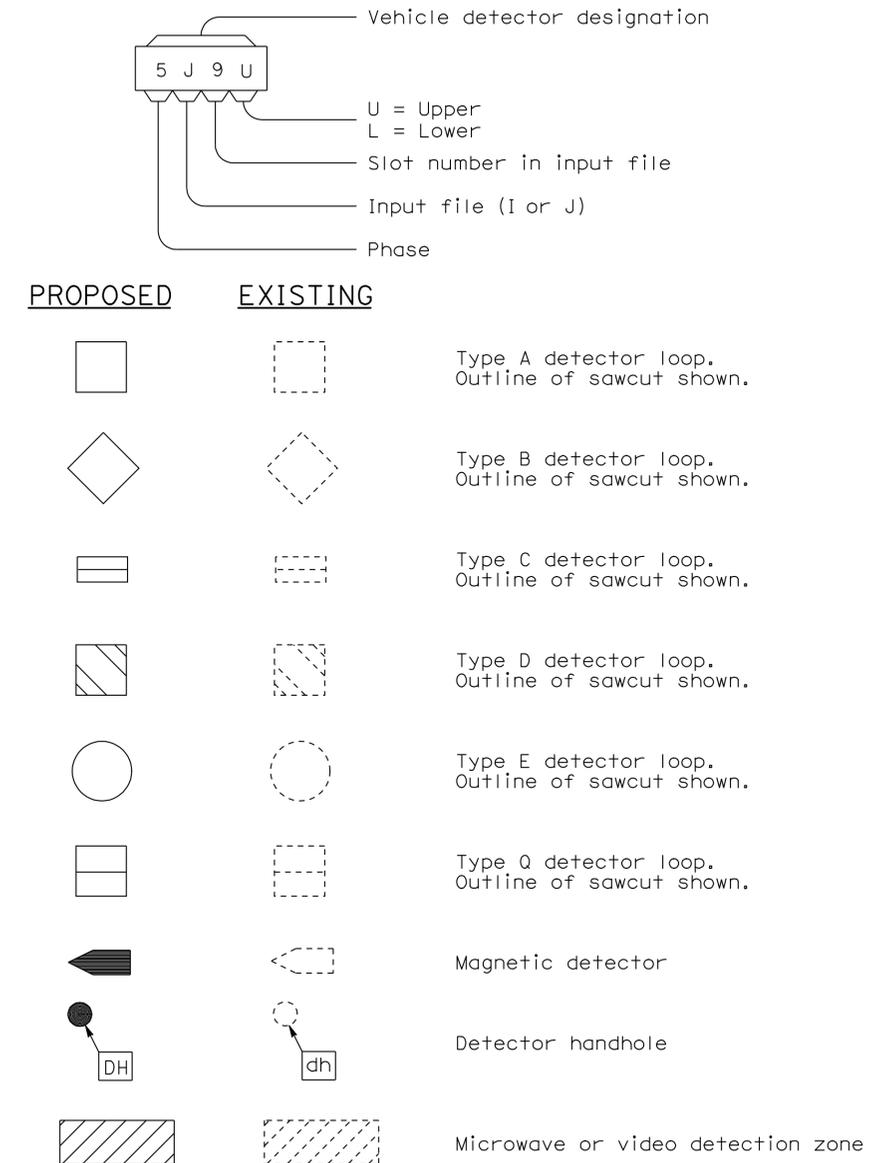

STATE OF CALIFORNIA
 DEPARTMENT OF TRANSPORTATION
**ELECTRICAL SYSTEMS
 (SYMBOLS AND ABBREVIATIONS)**

NO SCALE

RSP ES-1C DATED OCTOBER 5, 2007 SUPERCEDES STANDARD PLAN ES-1C
 DATED MAY 1, 2006 - PAGE 402 OF THE STANDARD PLANS BOOK DATED MAY 2006.

REVISED STANDARD PLAN RSP ES-1C

2006 REVISED STANDARD PLAN RSP ES-1C

DIST	COUNTY	ROUTE	POST MILES TOTAL PROJECT	SHEET NO.	TOTAL SHEETS
03	Yub	70	R7.0/R7.5	19	22

Jeffery G. McRae
 REGISTERED ELECTRICAL ENGINEER

October 5, 2007
 PLANS APPROVAL DATE

The State of California or its officers or agents shall not be responsible for the accuracy or completeness of electronic copies of this plan sheet.

REGISTERED PROFESSIONAL ENGINEER
 Jeffery G. McRae
 No. E14512
 Exp. 6-30-08
 ELECTRICAL
 STATE OF CALIFORNIA

NOTES-TYPE III SERVICE EQUIPMENT ENCLOSURES:

1. Service equipment enclosure and metering equipment shall meet the requirements of the service utility. The meter area shall have a sealable, lockable, weathertight cover that can be removed without the use of tools.
2. Service equipment enclosures shall be factory wired and conform to NEMA standards.
3. Dimensions of service equipment enclosures shall meet the requirements of the service utility.
4. The dead front panels on Type III service equipment enclosures shall have a continuous stainless steel or aluminum piano hinge. The panel in front of the breakers shall be secured with a latch or captive screws. No live parts shall be mounted on the dead front panel.
5. The exterior door shall have provisions for padlocking. The padlock hole shall be a minimum diameter of $\frac{1}{16}$ ".
6. Enclosures housing transformers of more than one kVA shall have effective screened ventilation louver of not less than 50 square inches. Screen shall be stainless steel No. 304, with a No. 10 size mesh. Framed screen shall be secured with at least four bolts.
7. Fasteners on the exterior of the enclosure shall be vandal-resistant and shall not be removable from the exterior. Exterior screws, nuts, bolts and washers shall be stainless steel.
8. Landing lugs for incoming service conductors shall be compatible with either copper or aluminum conductors sized to suit the conductors shown on the plan. Landing lugs shall be copper or tin-plated aluminum. Neutral bus shall be rated for 125 A and be suitable for copper or aluminum conductors unless otherwise specified. The terminal shall include but not be limited to:
 - a) Incoming terminals (landing lugs)
 - b) Neutral lugs
 - c) Solid neutral terminal strip
9. At least 6 standard single pole circuit breaker spaces, $\frac{3}{4}$ " nominal, shall be provided for branch circuits. Circuit breaker interiors shall be copper. Interiors of enclosure shall accept plug-in or cable-in/cable-out circuit breakers.
10. Control wiring shall be 600 V, 14 stranded machine tool wire. Where subject to flexing, 19 strand wire shall be used.
11. Main bus shall be rated for 125 A and shall be tin-plated copper.
12. A plastic laminated wiring diagram shall be provided with brass mounting eyelets and attached to the inside of the enclosure and the wiring diagram shall be affixed to the interior with a UL or ETL approved method.

13. An engraved phenolic nameplate on the dead front panel indicating the function of each circuit or device shall be installed with stainless steel rivets or stainless steel screws:
 - a) Adjacent to the breaker or device with character size a minimum of $\frac{1}{8}$ ".
 - b) At the top of the exterior door panel indicating State system number, voltage level and number of phases with character size a minimum of $\frac{3}{16}$ ".
14. The plan shows the approximate location of devices within the enclosure. Components may be rearranged, however, the "working" clearances within the service equipment enclosure shall be maintained.
15. In unpaved areas a raised portland cement concrete pad 2'-0" x 4" x width of foundation shall be constructed in front of new service equipment enclosure installation. Pad shall be set to elevation of foundation.
16. Foundation shall extend 2" minimum beyond edge of service equipment enclosure.
17. Internal bus, where shown, is typical only. Alternative design of proposed service equipment enclosure shall be submitted to the Engineer for approval.
18. Plug-in circuit breakers may be mounted in the vertical or horizontal position. Cable-in/cable-out circuit breakers shall be mounted in the vertical position.
19. Type III-AF and Type III-BF service equipment enclosures shall have the meter viewing windows located on the front side of the service equipment enclosures.
20. Type III-AR and Type III-BR service equipment enclosures shall be similarly constructed as Type III-AF and Type III-BF respectively, except the meter viewing windows shall be located on the back side of the service equipment enclosures.
21. Minimum clearance shall be required for front and back of service equipment enclosure per National Electrical Code, Article 110.26, "Spaces About Electric Equipment (600 Volts, Nominal, or Less)."

To accompany plans dated 4-4-11

STATE OF CALIFORNIA
 DEPARTMENT OF TRANSPORTATION


**ELECTRICAL SYSTEMS
 (SERVICE EQUIPMENT NOTES
 TYPE III SERIES)**

NO SCALE

RSP ES-2C DATED OCTOBER 5, 2007 SUPERCEDES STANDARD PLAN ES-2C
 DATED MAY 1, 2006 - PAGE 405 OF THE STANDARD PLANS BOOK DATED MAY 2006.

REVISED STANDARD PLAN RSP ES-2C


2006 REVISED STANDARD PLAN RSP ES-2C

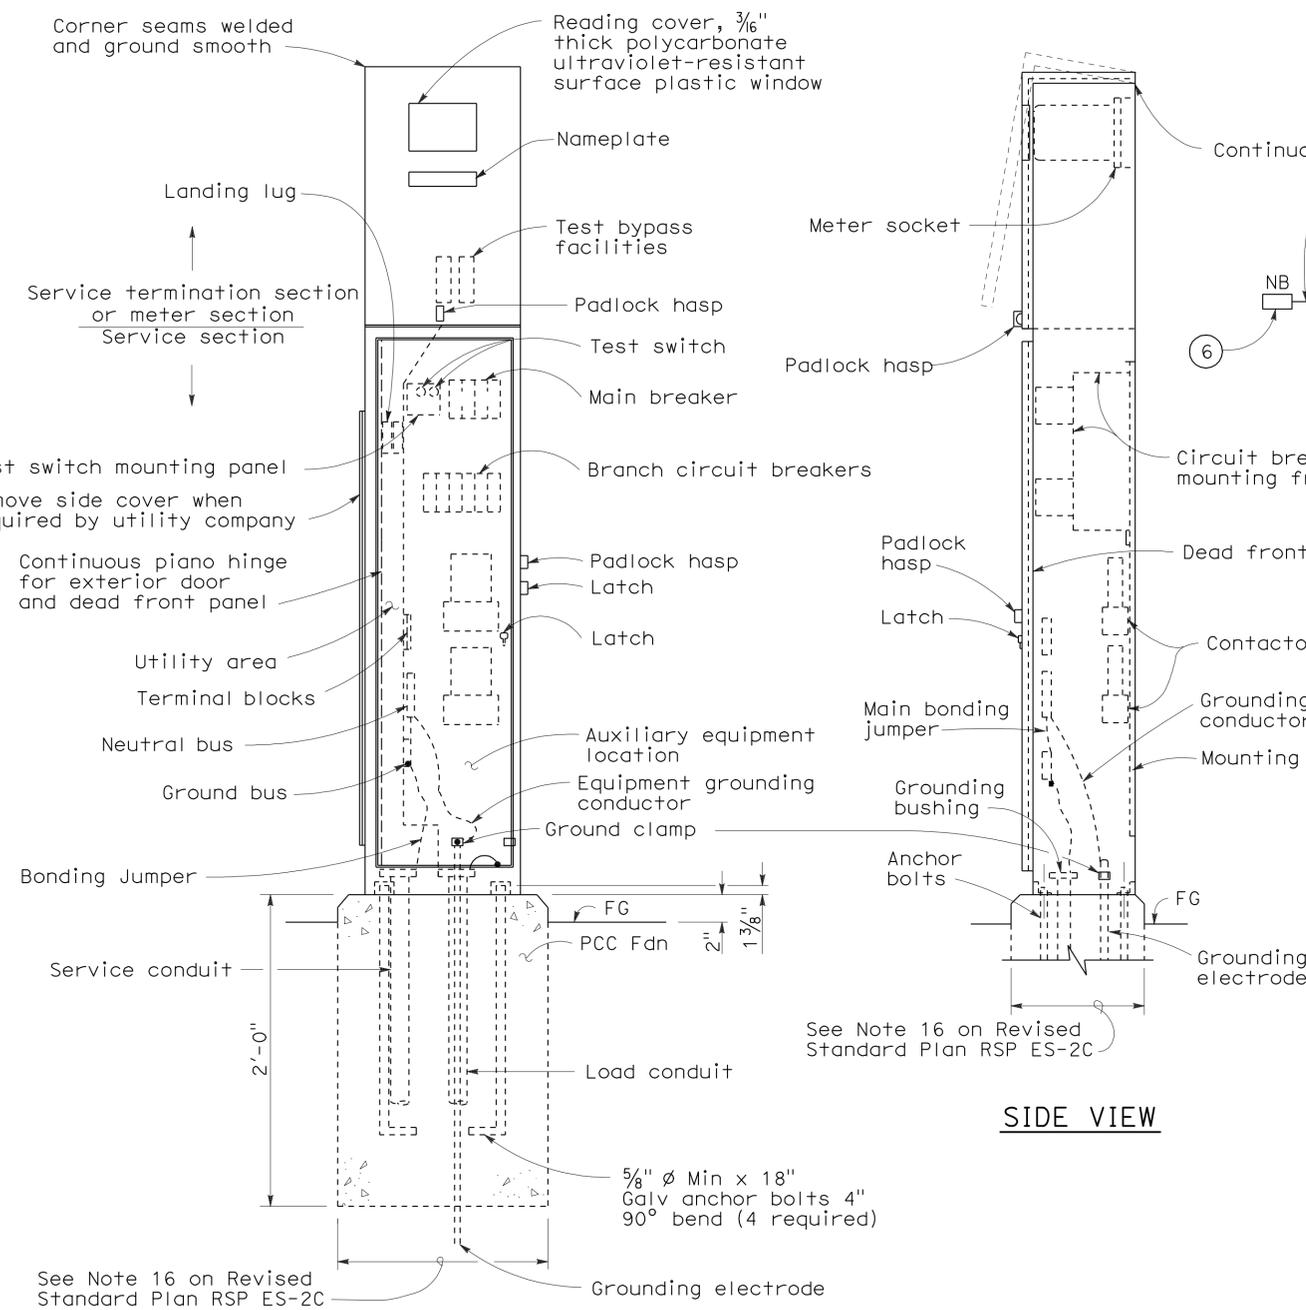



TYPE III-AF SERVICE EQUIPMENT ENCLOSURE (TYPICAL)

FRONT VIEW

SIDE VIEW

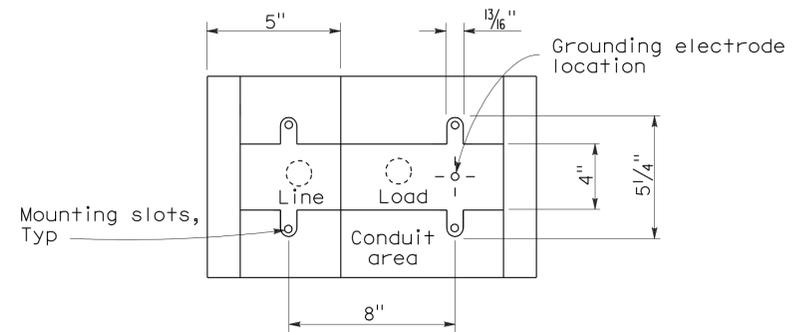

BASE FOR TYPE III-A SERVICE EQUIPMENT ENCLOSURE

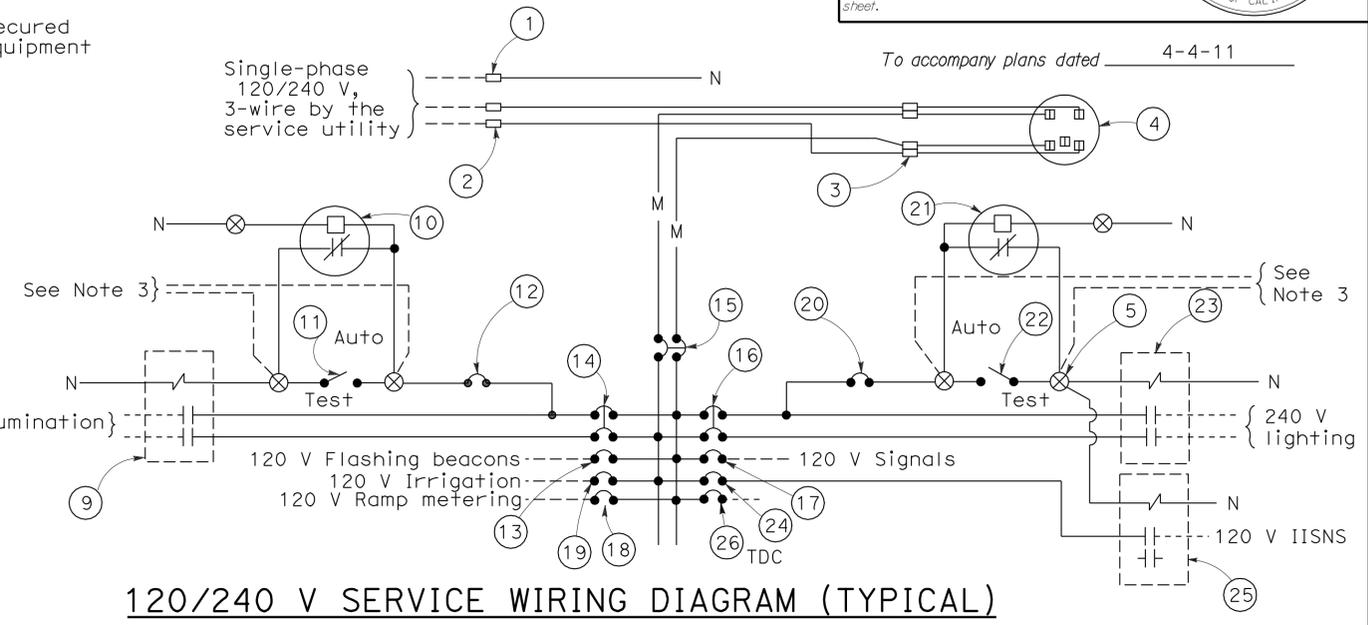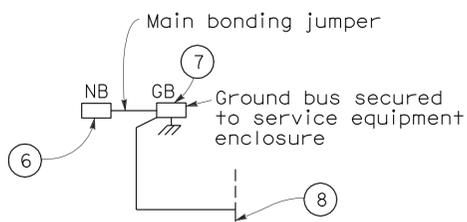

120/240 V SERVICE WIRING DIAGRAM (TYPICAL)

TYPE III-A SERVICE (120/240 V) EQUIPMENT LEGEND					
ITEM No.	COMPONENT	NAME PLATE DESCRIPTION	ITEM No.	COMPONENT	NAME PLATE DESCRIPTION
1	Neutral lug		14	30 A, 240 V, 2P, CB	Sign Illumination
2	Landing lug (Note 6)		15	100 A, 240 V, 2P, CB	Main Breaker
3	Test bypass facility		16	30 A, 240 V, 2P, CB	Lighting
4	Meter socket and support		17	50 A, 120 V, 1P, CB	Signals
5	Terminal blocks		18	30 A, 120 V, 1P, CB	Ramp Metering
6	Neutral bus		19	20 A, 120 V, 1P, CB	Irrigation
7	Ground bus		20	15 A, 120 V, 1P, CB	Lighting Control
8	Grounding electrode		21	Photoelectric unit (Note 7)	
9	30 A, 2PNO Contactor	Sign Illumination	22	15 A, 1P, Test switch	Lighting Test Switch
10	Photoelectric unit (Note 7)		23	60 A, 2PNO Contactor	Lighting
11	15 A, 1P, Test switch	Sign Illumination Test Switch	24	15 A, 120 V, 1P, CB	IISNS
12	15 A, 120 V, 1P, CB	Sign Illumination Control	25	30 A, 2PNO Contactor	IISNS
13	15 A, 120 V, 1P, CB	Flashing Beacon	26	20 A, 120 V, 1P, CB	Telephone Demarcation Cabinet

NOTES: (FOR SERVICE EQUIPMENT ENCLOSURE)

- Voltage ratings of service equipment shall conform to the service voltages indicated on the plans.
- Unless otherwise indicated on the plans, service equipment items shall be provided for each service equipment enclosure as shown.
- Connect to remote test switch mounted on lighting standards, sign post or structure when required.
- Items No. 1 and 6 shall be isolated from the service equipment enclosure.
- Meter sockets shall be 5 clip type.
- The landing lug shall be suitable for multiple conductors.
- Type I photoelectric control shall be used unless otherwise indicated on the plans.


STATE OF CALIFORNIA
 DEPARTMENT OF TRANSPORTATION
**ELECTRICAL SYSTEMS
 (SERVICE EQUIPMENT AND
 TYPICAL WIRING DIAGRAM,
 TYPE III - A SERIES)**

NO SCALE


RSP ES-2D DATED OCTOBER 5, 2007 SUPERCEDES STANDARD PLAN ES-2D DATED MAY 1, 2006 - PAGE 406 OF THE STANDARD PLANS BOOK DATED MAY 2006.

2006 REVISED STANDARD PLAN RSP ES-2D


To accompany plans dated 4-4-11

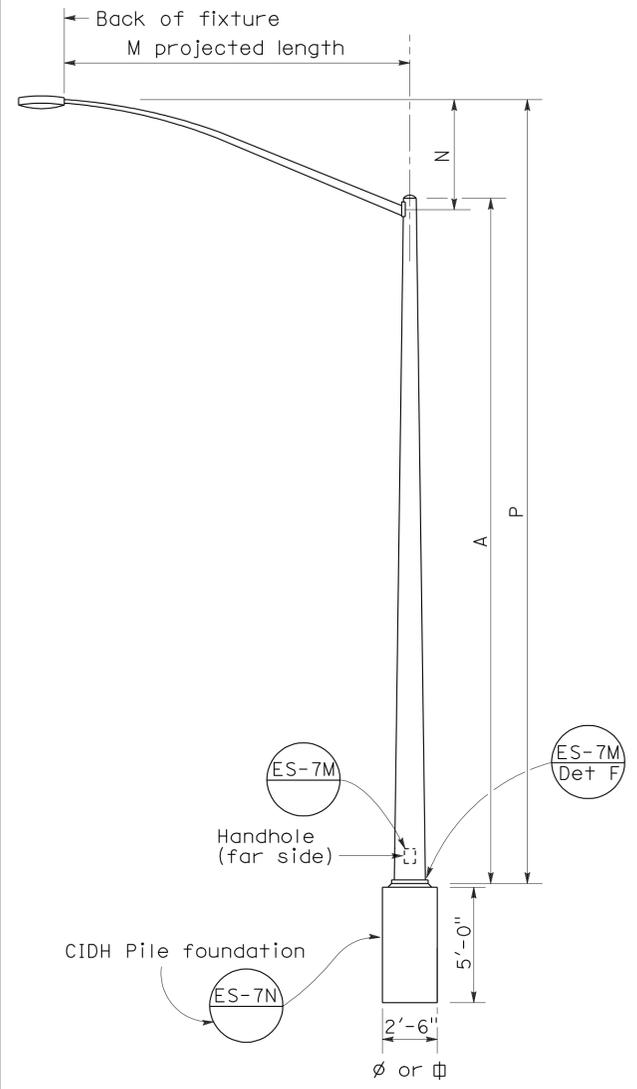


ELEVATION
TYPE 15 AND TYPE 21

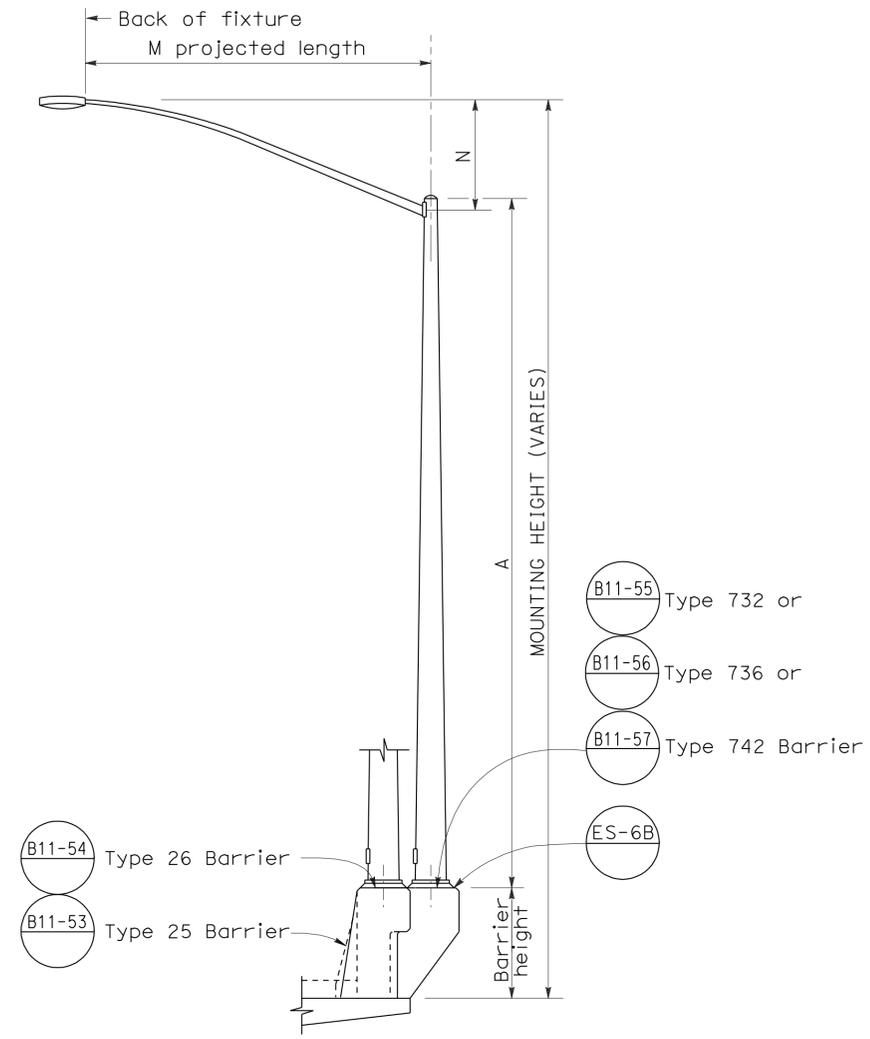

ELEVATION
TYPE 15 AND TYPE 21 BARRIER RAIL MOUNTED

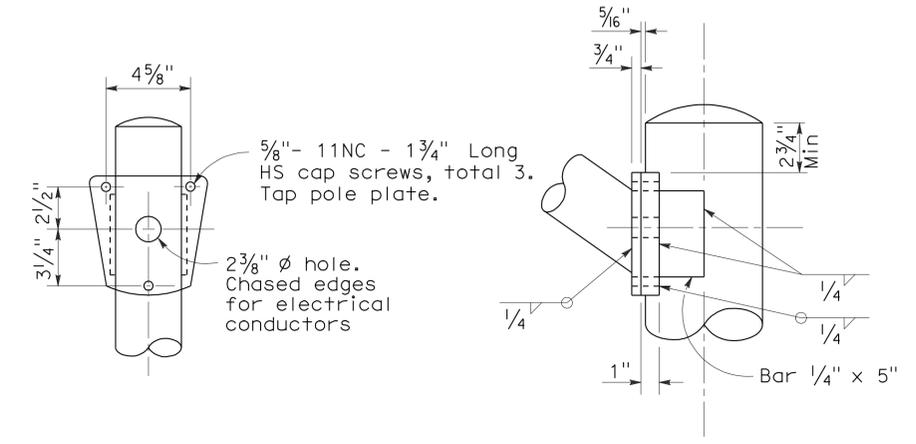

DETAIL R
LUMINAIRE ARM CONNECTION

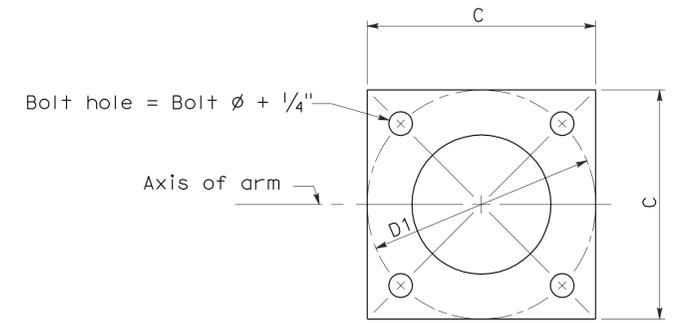

BASE PLATE

POLE TYPE	POLE DATA				BASE PLATE DATA				LUMINAIRE ARM
	A Height	Min OD		Wall Thickness	C	D1 Bolt Circle	Thick-ness	Anchor Bolts Size	
15	30'	8"	3 7/8"	0.1196"	1'-0"	1'-0"	1"	1" ø x 3'-0" x 4"*	6' - 15' 12'
21	35'	8 5/8"	3 7/8"	0.1196"	1'-0"	1'-0"	1"	1 1/4" ø x 3'-0" x 4"*	6' - 15' 12'

* For barrier rail bolts, see Standard Plan ES-6B.

M Projected Length	N Rise	Min OD At Pole	Nominal Thickness	LUMINAIRE ARM DATA	
				Type 15	Type 21
6'-0"	2'-0"±	3 1/4"	0.1196"	31'-6"±	36'-6"±
8'-0"	2'-6"±	3 1/2"	0.1196"	32'-0"±	37'-0"±
10'-0"	3'-3"±	3 3/8"	0.1196"	32'-9"±	37'-9"±
12'-0"	4'-3"±	3 3/8"	0.1196"	33'-9"±	38'-9"±
15'-0"	4'-9"±	4 1/4"	0.1196"	34'-3"±	39'-3"±

NOTES:

- Indicates arm length to be used unless otherwise noted on the plans.
- For Type 15-SB, use Type 15 standard with Type 30 slip base plate details, see Standard Plan ES-6F.
- For additional notes, see Standard Plan ES-7M and ES-7N.

STATE OF CALIFORNIA
DEPARTMENT OF TRANSPORTATION
ELECTRICAL SYSTEMS
(LIGHTING STANDARD
TYPES 15 AND 21)

NO SCALE

RSP ES-6A DATED OCTOBER 5, 2007 SUPERCEDES STANDARD PLAN ES-6A DATED MAY 1, 2006 - PAGE 427 OF THE STANDARD PLANS BOOK DATED MAY 2006.


REVISED STANDARD PLAN RSP ES-6A

2006 REVISED STANDARD PLAN RSP ES-6A


LUMINAIRE ARM DATA

PROJECTED LENGTH	THICKNESS	MINIMUM OD @ POLE	MOUNTING HEIGHT
* 6'-0"	0.1196"	3/4"	36'-9"±
8'-0"		3/2"	37'-3"±
10'-0"		3 3/4"	38'-0"±
12'-0"		3 3/4"	39'-0"±
15'-0"		4 1/4"	39'-6"±
** 20'-0"	0.1793"	5"	37'-0"±


* Type 30 - arm length 6'-0" - 15'-0" maximum
 ** Type 31 - arm lengths 20'-0"

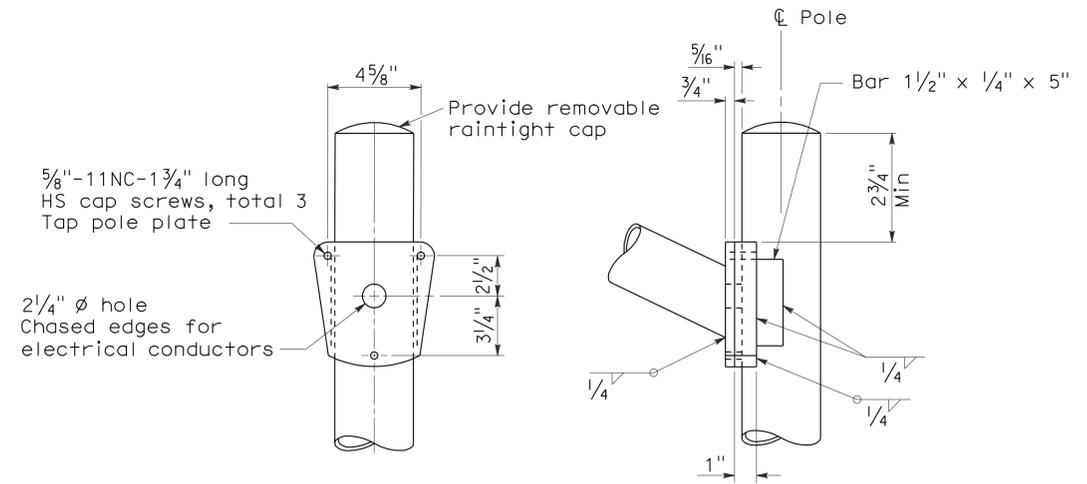


DETAIL A - TYPE 30

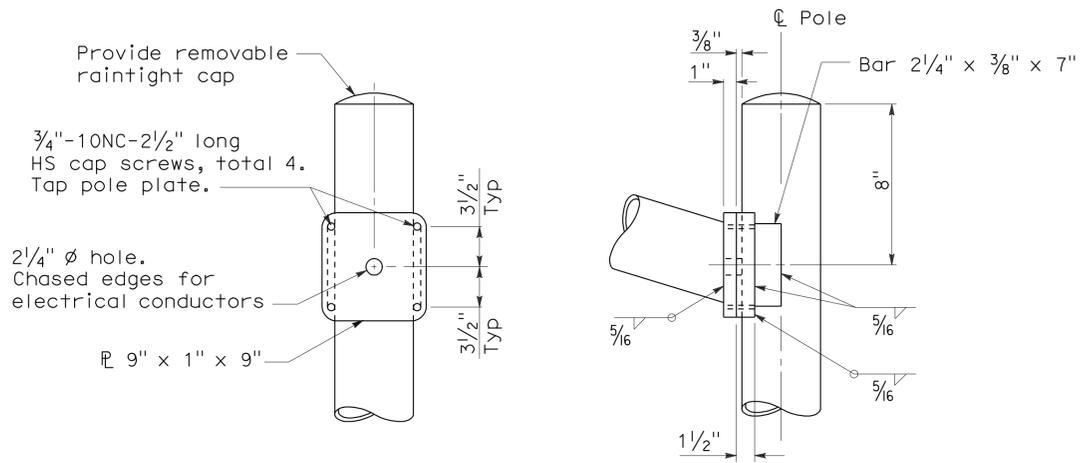


DETAIL A - TYPE 31

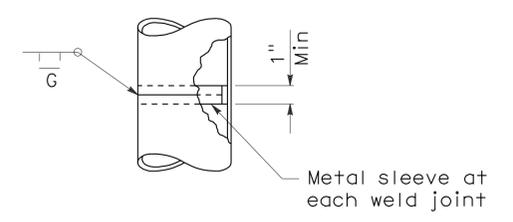

POLE SPLICE

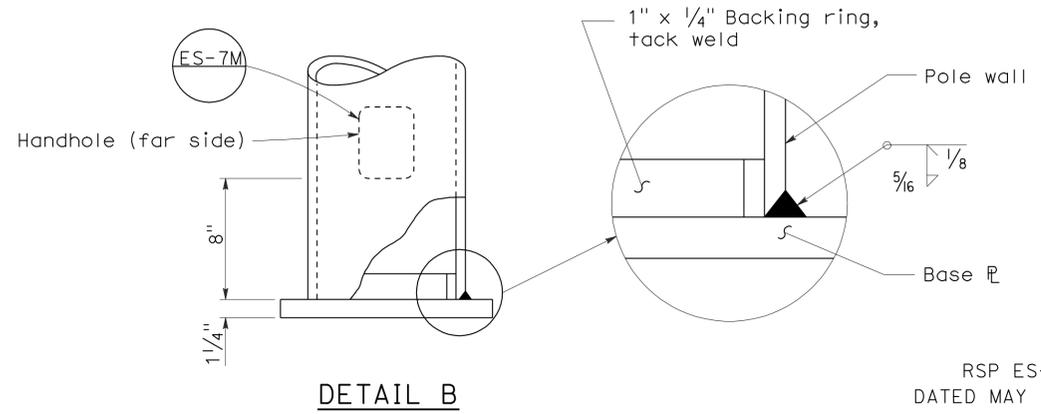

DETAIL B

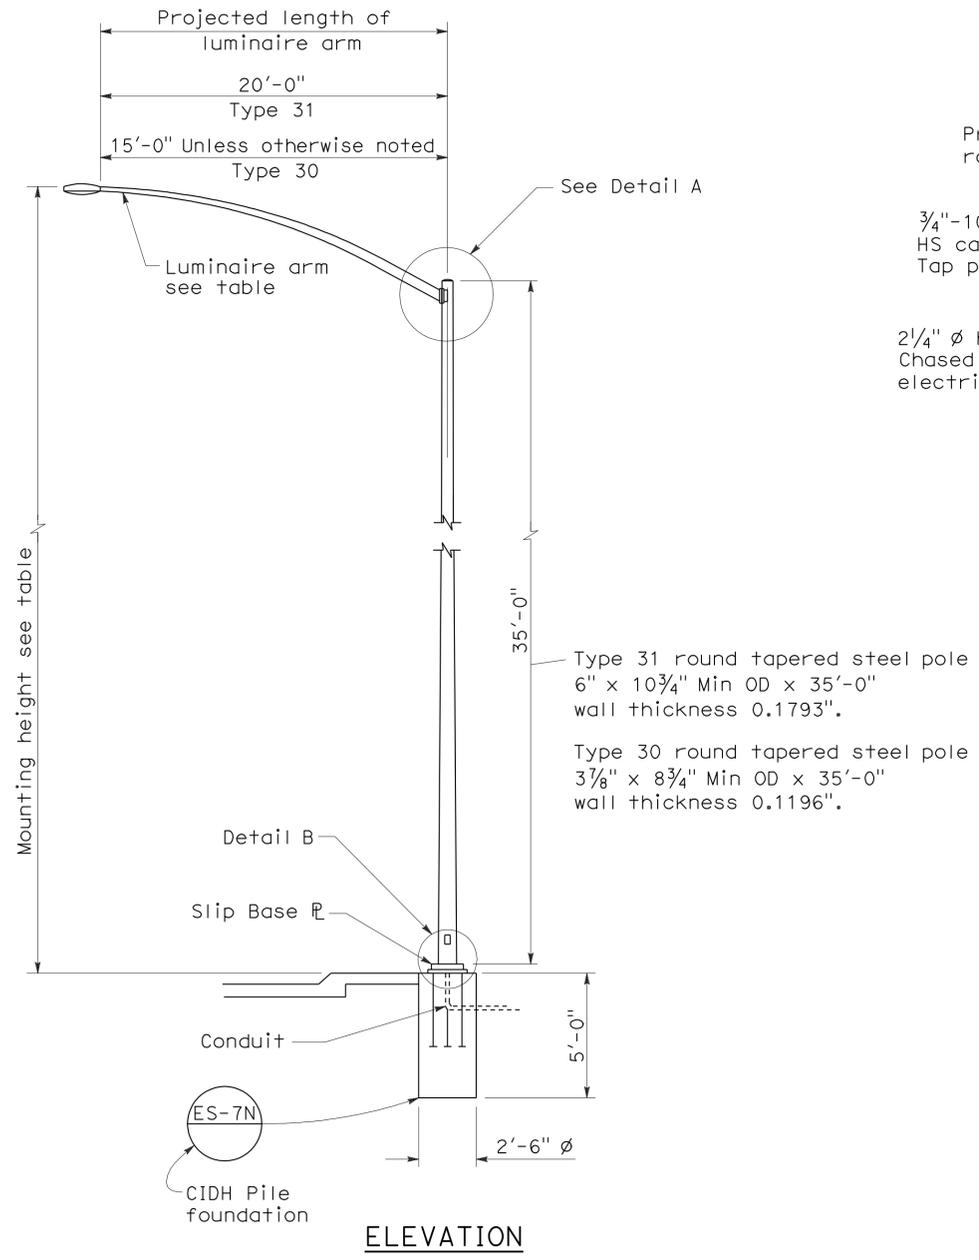

ELEVATION

NOTES:

- Sheet steel shall have a minimum yield of 48,000 psi.
- For slip base details see Standard Plan ES-6F.
- For Type 30 fixed base use Type 15 base plate, and foundation shown on Revised Standard Plan RSP ES-6A. Use 1 1/4 inch Dia x 3'-6 inch x 4 inch anchor bolts.
- For Type 31 fixed base use Type 32 base plate, anchor bolts and foundation on Standard Plan ES-6G.
- Handhole shall be located on downstream side of traffic unless noted otherwise on plans.
- For additional general notes refer to Standard Plan ES-7M.

STATE OF CALIFORNIA
 DEPARTMENT OF TRANSPORTATION
**ELECTRICAL SYSTEMS
 (LIGHTING STANDARD
 TYPES 30 AND 31)**
 NO SCALE

RSP ES-6E DATED JANUARY 18, 2008 SUPERCEDES STANDARD PLAN ES-6E
 DATED MAY 1, 2006 - PAGE 430 OF THE STANDARD PLANS BOOK DATED MAY 2006.