

INDEX OF PLANS

SHEET No.	DESCRIPTION
1	TITLE AND LOCATION MAP
2	EROSION CONTROL LEGEND
3-12	ELECTRICAL PLANS
13-24	REVISED STANDARD PLANS

THE STANDARD PLANS LIST APPLICABLE TO THIS CONTRACT IS INCLUDED IN THE NOTICE TO BIDDERS AND SPECIAL PROVISIONS BOOK.

STATE OF CALIFORNIA
DEPARTMENT OF TRANSPORTATION
PROJECT PLANS FOR CONSTRUCTION ON
STATE HIGHWAY
IN BUTTE COUNTY IN CHICO
AT THE COHASSET ROAD OFFRAMP
AND AT THE EATON ROAD INTERCHANGE


TO BE SUPPLEMENTED BY STANDARD PLANS DATED 2010

Dist	COUNTY	ROUTE	POST MILES TOTAL PROJECT	SHEET No.	TOTAL SHEETS
03	But	99	R34.2,R36.3	1	24





LOCATION MAP

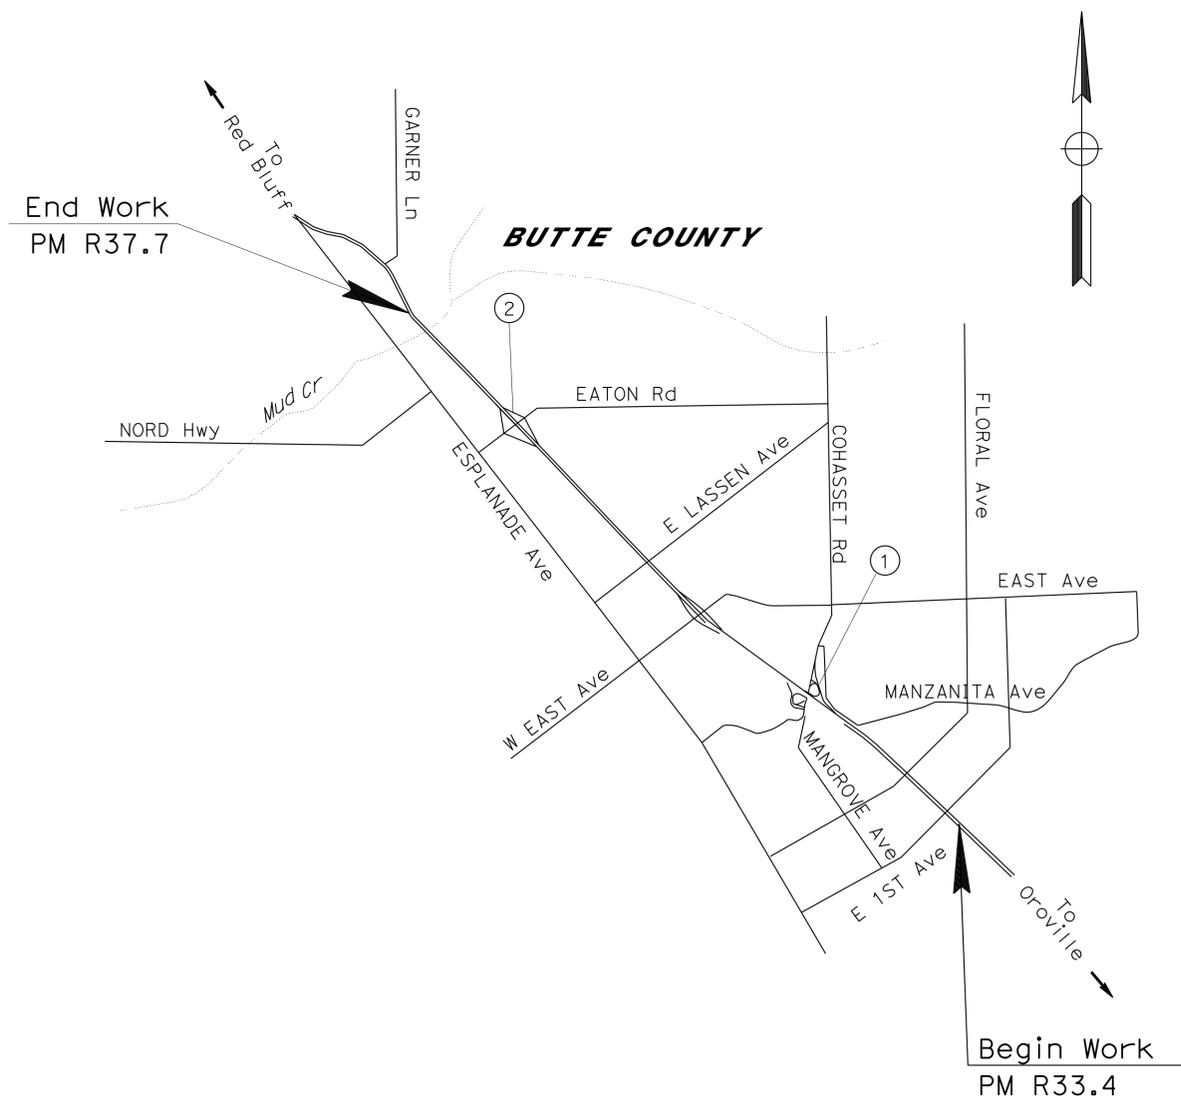

LOCATIONS OF CONSTRUCTION

Loc No. ①	COUNTY	ROUTE	PM	DESCRIPTION	DIRECTION
1	But	99	R34.2	NB OFF-RAMP TO COHASSET Rd	NB
2	But	99	R36.3	EATON Rd INTERCHANGE	NB

PROJECT MANAGER
NAJ DAKAK
 DESIGN MANAGER
MIKE HAGEN

Dennis G. Corcoran 2-2-15
 PROJECT ENGINEER DATE
 REGISTERED CIVIL ENGINEER



February 2, 2015
 PLANS APPROVAL DATE

THE STATE OF CALIFORNIA OR ITS OFFICERS OR AGENTS SHALL NOT BE RESPONSIBLE FOR THE ACCURACY OR COMPLETENESS OF SCANNED COPIES OF THIS PLAN SHEET.

THE CONTRACTOR SHALL POSSESS THE CLASS (OR CLASSES) OF LICENSE AS SPECIFIED IN THE "NOTICE TO BIDDERS."


NO SCALE

Dist	COUNTY	ROUTE	POST MILES TOTAL PROJECT	SHEET No.	TOTAL SHEETS
03	Bu+	99	R34.2,R36.3	2	24


 LICENSED LANDSCAPE ARCHITECT
 2-2-15
 PLANS APPROVAL DATE



THE STATE OF CALIFORNIA OR ITS OFFICERS OR AGENTS SHALL NOT BE RESPONSIBLE FOR THE ACCURACY OR COMPLETENESS OF SCANNED COPIES OF THIS PLAN SHEET.

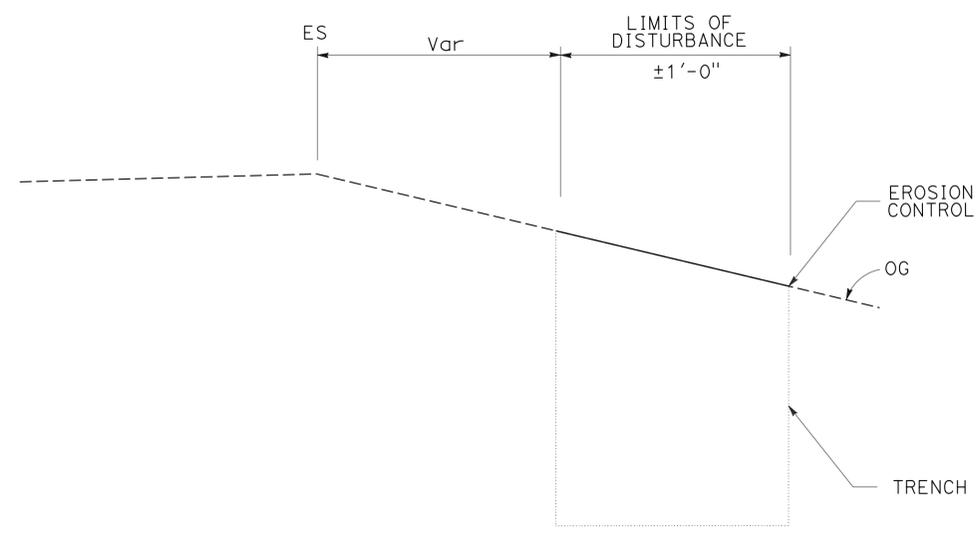

SECTION
EROSION CONTROL (Typ)

EROSION CONTROL

ITEM	MATERIAL		DEPTH
	DESCRIPTION	TYPE	
COMPOST	COMPOST	COARSE	2"

EROSION CONTROL QUANTITIES

EROSION CONTROL LOCATION	COMPOST
	SQFT
COHASSET ROAD INTERCHANGE	128
EATON ROAD INTERCHANGE	8,472
TOTAL	8,600

EROSION CONTROL LEGEND
ECD-1

STATE OF CALIFORNIA - DEPARTMENT OF TRANSPORTATION
Caltrans LANDSCAPE ARCHITECTURE
 SENIOR LANDSCAPE ARCHITECT
 T. CHRIS JOHNSON
 CALCULATED/DESIGNED BY
 CHECKED BY
 DAN BREWER
 JAMES WILLIAMSON
 REVISED BY
 DATE REVISED

Dist	COUNTY	ROUTE	POST MILES TOTAL PROJECT	SHEET No.	TOTAL SHEETS
03	But	99	R34.2,R36.3	3	24

<i>Normanye</i>	2-2-15
REGISTERED ELECTRICAL ENGINEER	DATE
2-2-15	
PLANS APPROVAL DATE	

REGISTERED PROFESSIONAL ENGINEER	
NORMAN S. YE	
No. 16913	
Exp. 6-30-15	
ELECTRICAL	
STATE OF CALIFORNIA	


THE STATE OF CALIFORNIA OR ITS OFFICERS OR AGENTS SHALL NOT BE RESPONSIBLE FOR THE ACCURACY OR COMPLETENESS OF SCANNED COPIES OF THIS PLAN SHEET.

NOTE:

FOR ACCURATE RIGHT OF WAY DATA, CONTACT RIGHT OF WAY ENGINEERING AT THE DISTRICT OFFICE.

NOTES: THIS SHEET ONLY

IRRIGATION LINES ARE IN CLOSE PROXIMITY TO THE TRENCHING AND LUMINIARE WORK LOCATION.

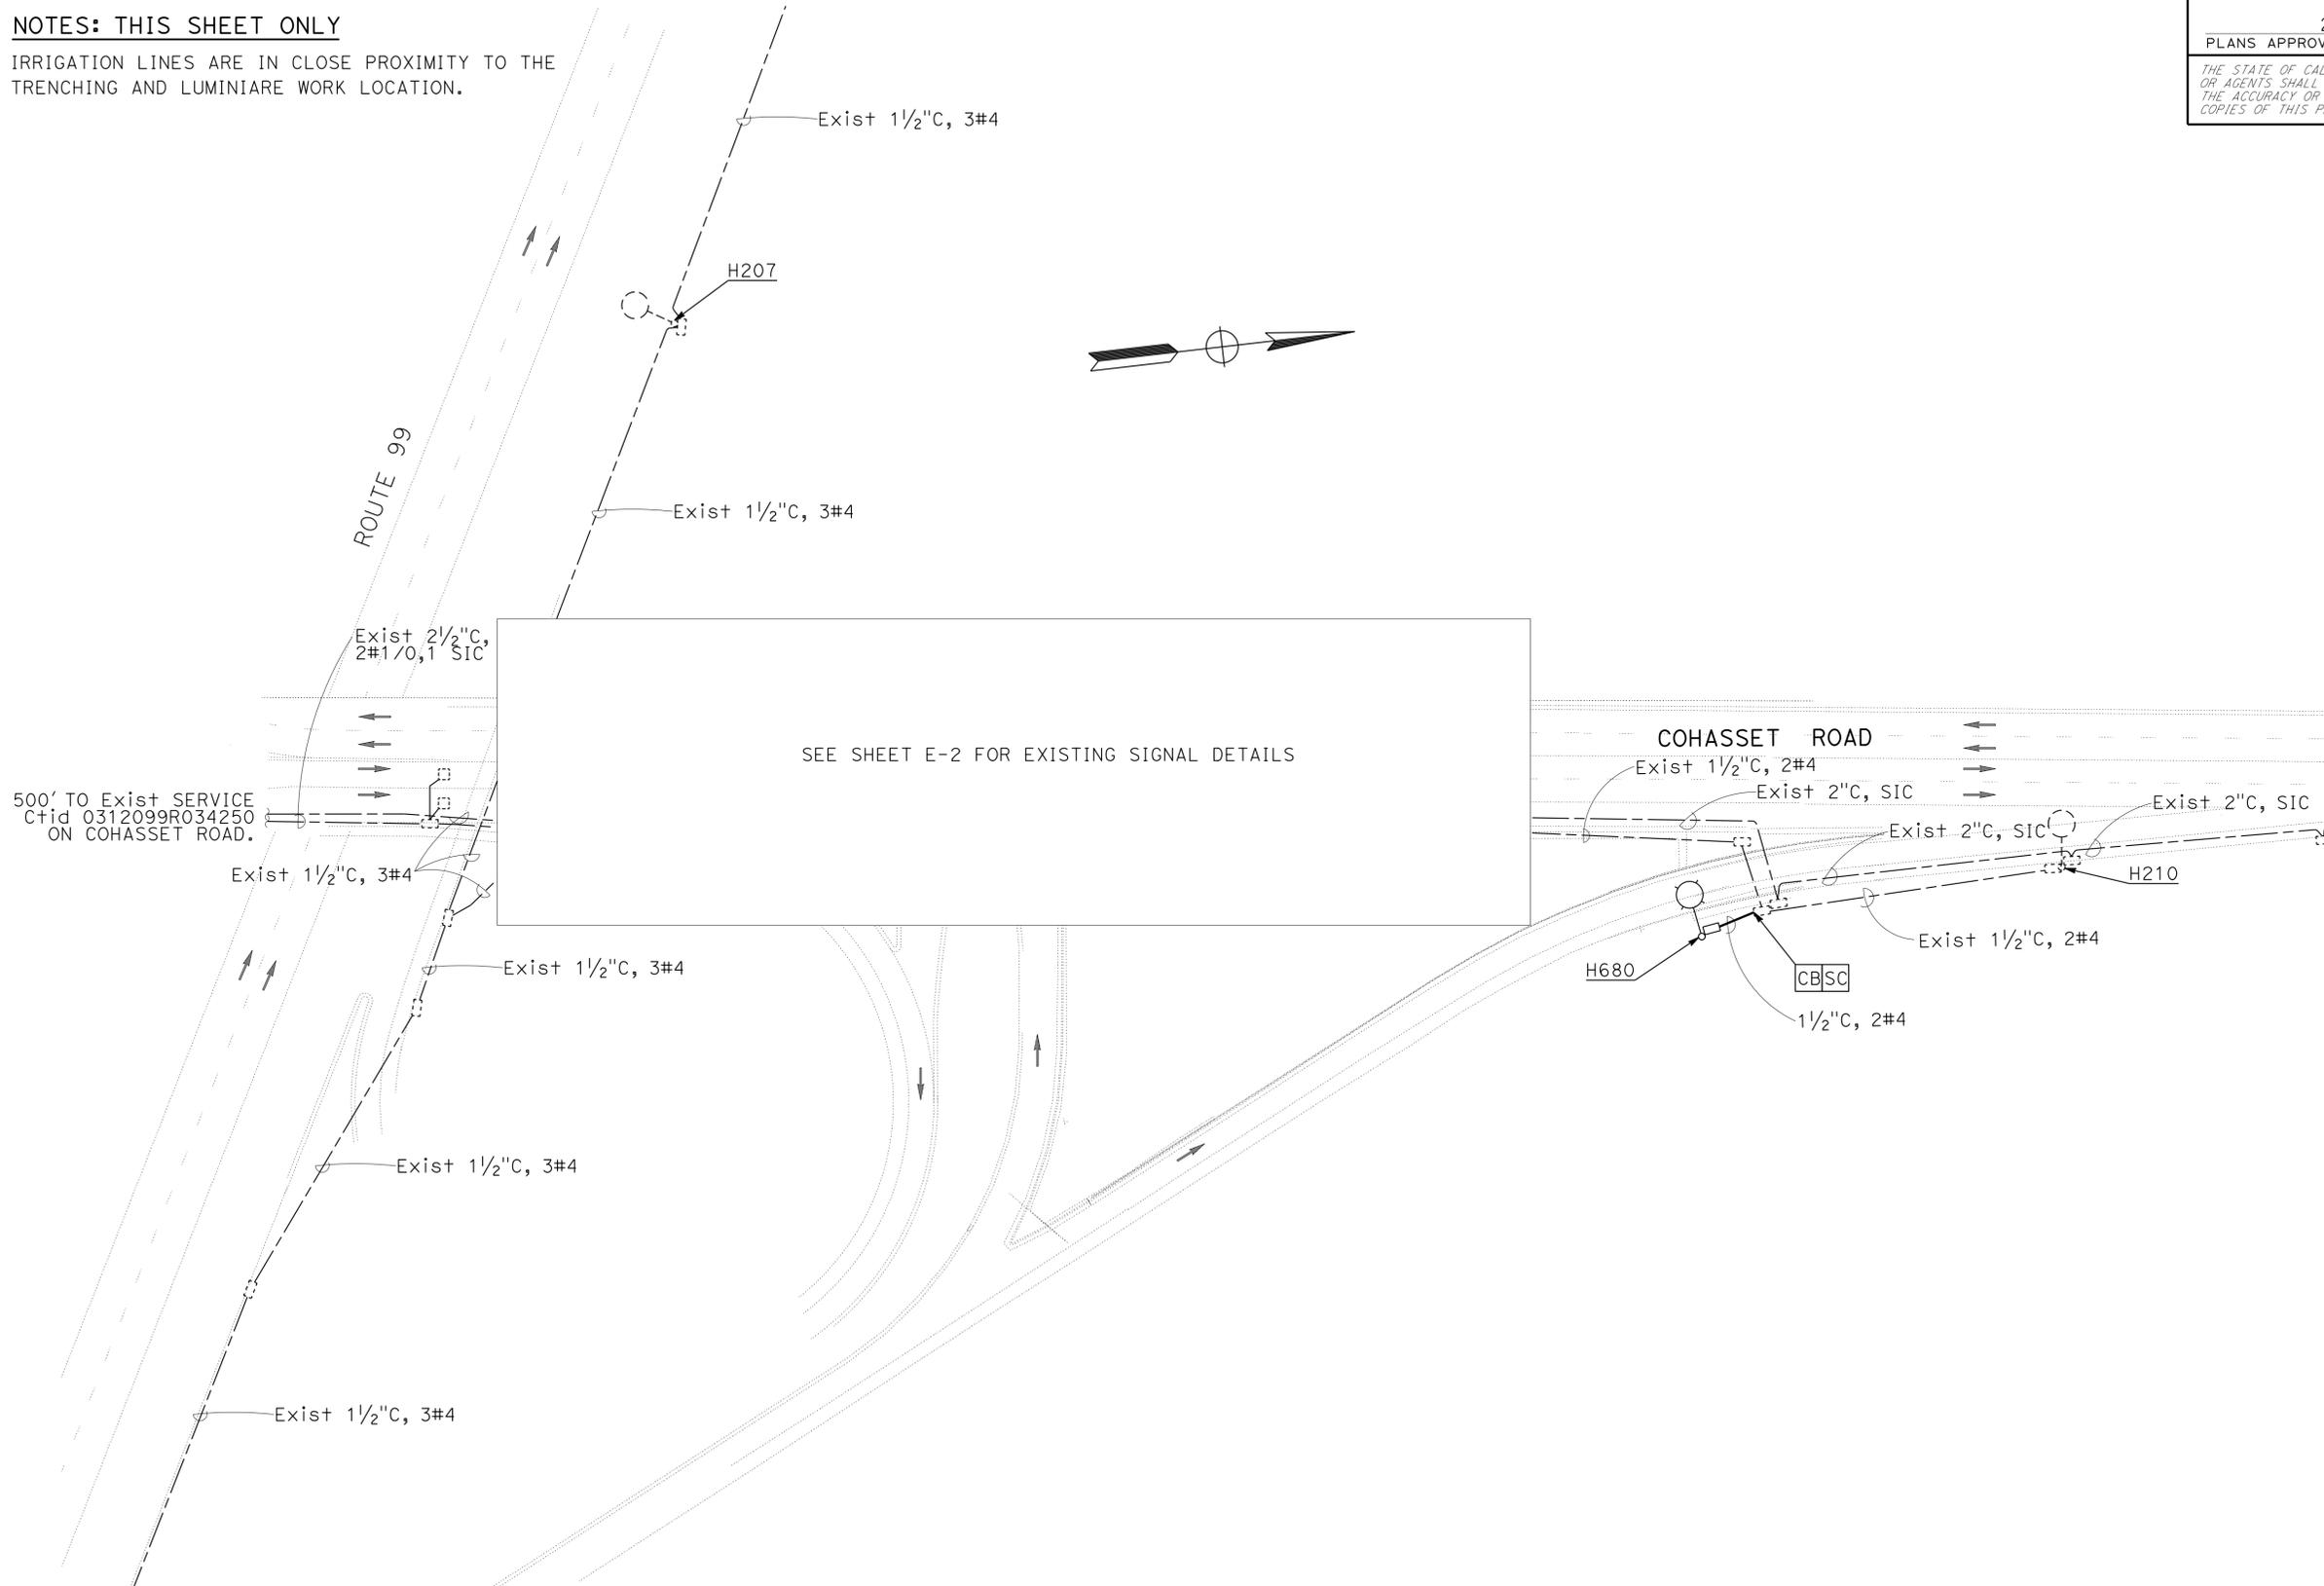

MODIFY LIGHTING
SCALE 1" = 50'

APPROVED FOR ELECTRICAL WORK ONLY

E-1

STATE OF CALIFORNIA - DEPARTMENT OF TRANSPORTATION	FUNCTIONAL SUPERVISOR	DESIGNED BY	REVISOR
Caltrans	NELSON LEE	NATHAN DEKENS	NATHAN DEKENS
ELECTRICAL DESIGN		NORMAN S. YE	NORMAN S. YE
		CHECKED BY	DATE REVISION



STATE OF CALIFORNIA - DEPARTMENT OF TRANSPORTATION
Caltrans ELECTRICAL DESIGN
 FUNCTIONAL SUPERVISOR: NELSON LEE
 CALCULATED/DESIGNED BY: CHECKED BY:
 NATHAN DEKENS NORMAN S. YE
 REVISED BY: DATE REVISED:

Dist	COUNTY	ROUTE	POST MILES TOTAL PROJECT	SHEET No.	TOTAL SHEETS
03	Bu+	99	R34.2,R36.3	4	24

2-2-15
 REGISTERED ELECTRICAL ENGINEER DATE
 2-2-15
 PLANS APPROVAL DATE
 THE STATE OF CALIFORNIA OR ITS OFFICERS OR AGENTS SHALL NOT BE RESPONSIBLE FOR THE ACCURACY OR COMPLETENESS OF SCANNED COPIES OF THIS PLAN SHEET.

Norman S. Ye
 REGISTERED PROFESSIONAL ENGINEER
 No. 16913
 Exp. 6-30-15
 ELECTRICAL
 STATE OF CALIFORNIA

NOTE:
 FOR ACCURATE RIGHT OF WAY DATA, CONTACT RIGHT OF WAY ENGINEERING AT THE DISTRICT OFFICE.

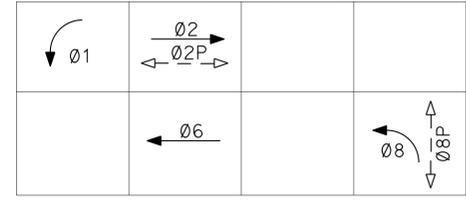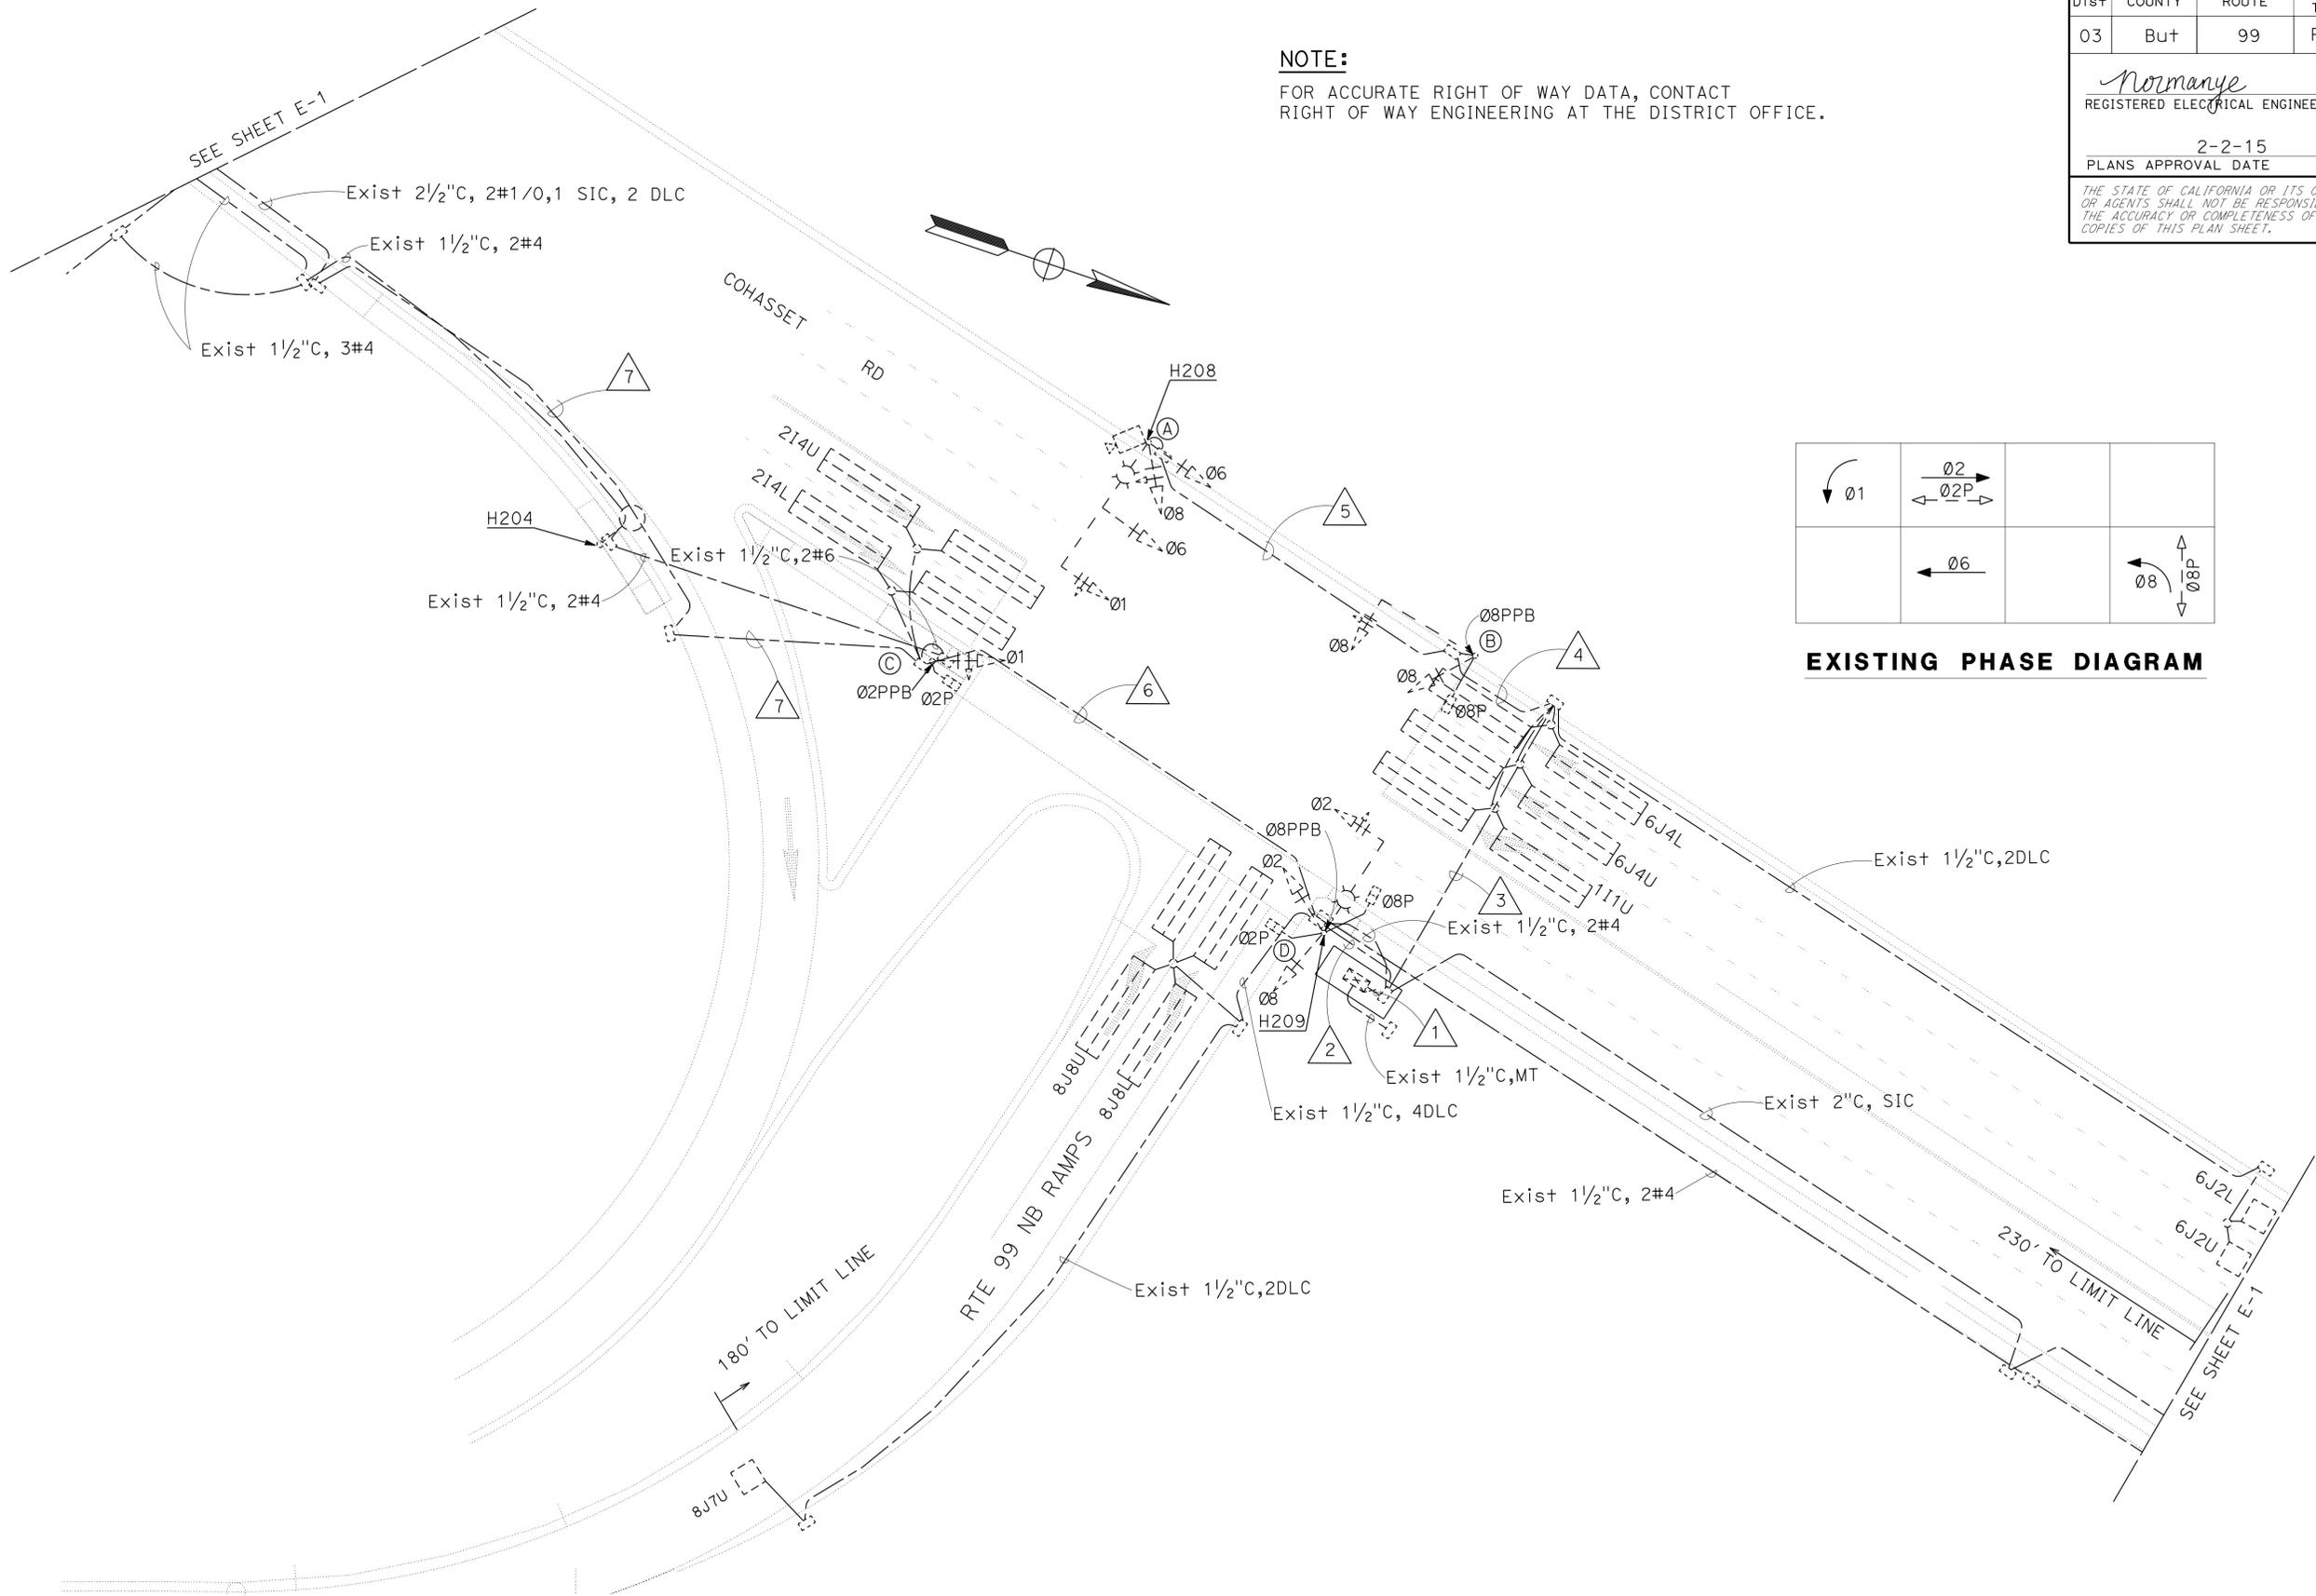


EXISTING PHASE DIAGRAM

MODIFY LIGHTING
 SCALE 1"= 20'

APPROVED FOR ELECTRICAL WORK ONLY

EXISTING POLE AND EQUIPMENT SCHEDULE

NO.	STANDARD			VEH SIG		PED SIGNAL	PPB		HPS LUMINAIRE	SPECIAL REQUIREMENTS
	Type	Sig M.A.	Lum M.A.	Ø	MTG	MTG	Ø	ARROW		
A	24A-4-100	35'	15'	1	MAT				310 W	
				6	MAS					
				6	SV-2-TB					
				8						
B	18-3-100	25'		8	SV-1-T	SP-1-T	8	←		
				8	MAT					
C	1 - B			8	TV-1-T	SP-1-T	2	←		
D	19A-3-100	35'	15'	2	MAT	SP-2-T	2	→	310 W	
				2	SV-1-T					
				8	SV-1-T					
				8	SV-1-T					

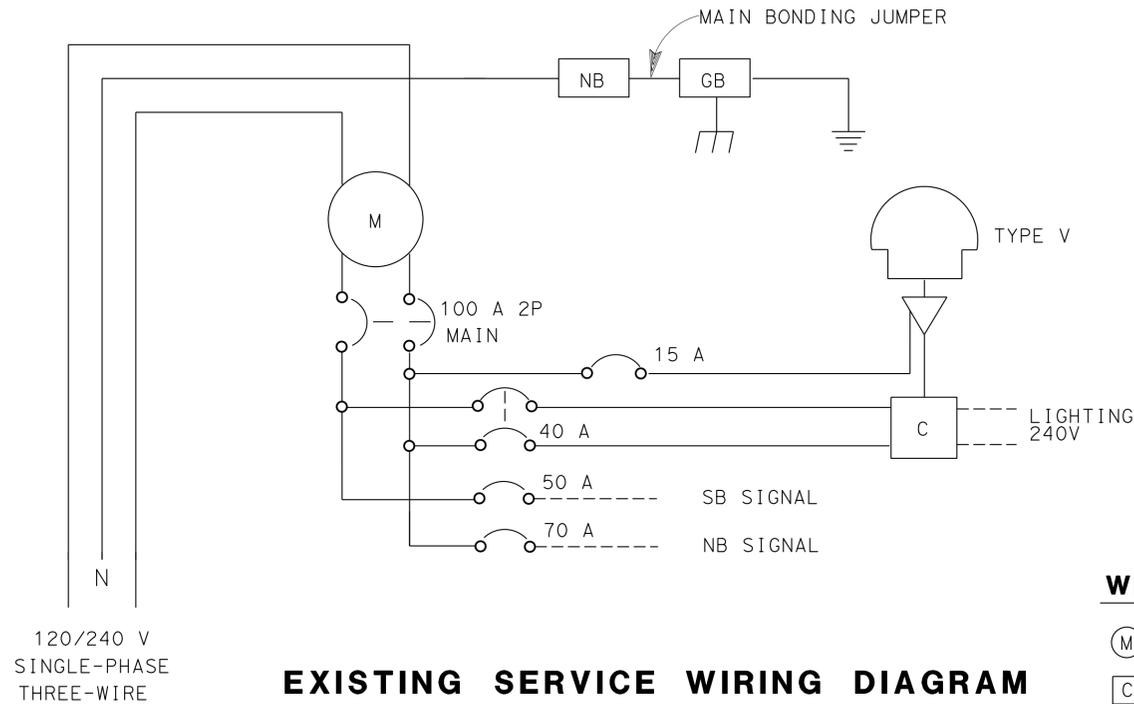

EXISTING SERVICE WIRING DIAGRAM

Ctid NO. 0312099R034250
 LOAD: 11-200 W (HPS LIGHTING)
 4-310 W (HPS LIGHTING)
 1976 W (NB SIGNAL)
 2000 W (SB SIGNAL)
 NEW LOAD: 1-165 W (LED LIGHTING)

WIRING DIAGRAM LEGEND:


- (M) METER SOCKET AND SUPPORT
- (C) CONTACTOR
- (NB) SOLID NEUTRAL BUS
- ▽ AUTO TEST SWITCH
- ☉ PHOTOELECTRIC UNIT

EXISTING CONDUCTOR AND CONDUIT SCHEDULE

AWG OR CABLE	CONDUCTOR RUN	1	2	3	4	5	6	7
#14	Ø 1	6	3	3	3	3	3	
	Ø 2	6	3					
	Ø 6	3		3	3	3		
	Ø 8	6	3	3	3	3		
	Ø 2 PED		2					2
	Ø 2 PPB		1					1
	Ø 8 PED	2	2	2				
	Ø 8 PPB	1	1	1				
	PPB NEUTRAL	3	1	1				1
	SPARES	6	3	3	3	3	3	
TOTAL	33	19	16	12	12	10		
#8	SIGNAL NEUTRAL	2	1	1	1	1	1	
	TOTAL	2	1	1	1	1	1	
DLC	Ø 1 DLC	4		1				
	Ø 2 DLC	1	4				4	2
	Ø 6 DLC	4		4				
	Ø 8 DLC	3	3					
	TOTAL	12	7	5			4	2
SIC	SIG. INTERCONNECT	2	1				1	1
#4	EXIST. FRWY LIGHTING							
	SIGNAL LIGHTING		2	2	2	2	2	
#1/0	NB SIGNAL SERVICE	2	2				2	2
SIZE PER SSP	CAMERA CABLE	1		1	1	1		
	CAMERA POWER CABLE	1		1	1	1		
	CAMERA COMM. CABLE	1		1	1	1		
SIZE		2-3"	2-3"	3"	2"	2"	3"	3"

MODIFY LIGHTING

Dist	COUNTY	ROUTE	POST MILES TOTAL PROJECT	SHEET No.	TOTAL SHEETS
03	Bu+	99	R34.2,R36.3	6	24
<i>Norman S. Ye</i> REGISTERED ELECTRICAL ENGINEER			2-2-15	DATE	
2-2-15 PLANS APPROVAL DATE					
<small>THE STATE OF CALIFORNIA OR ITS OFFICERS OR AGENTS SHALL NOT BE RESPONSIBLE FOR THE ACCURACY OR COMPLETENESS OF SCANNED COPIES OF THIS PLAN SHEET.</small>					

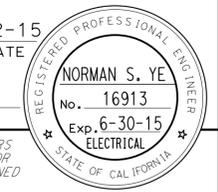


NOTE:
 FOR ACCURATE RIGHT OF WAY DATA, CONTACT
 RIGHT OF WAY ENGINEERING AT THE DISTRICT OFFICE.

NOTES: THIS SHEET ONLY

1. SEE DETAIL SHEET E-9 FOR ALL NEW 5(T) PB.

STATE OF CALIFORNIA - DEPARTMENT OF TRANSPORTATION	FUNCTIONAL SUPERVISOR	CALCULATED/DESIGNED BY	REVISOR
Caltrans ELECTRICAL DESIGN	NELSON LEE	CHECKED BY	DATE REVISED
		NATHAN DEKENS	
		NORMAN S. YE	

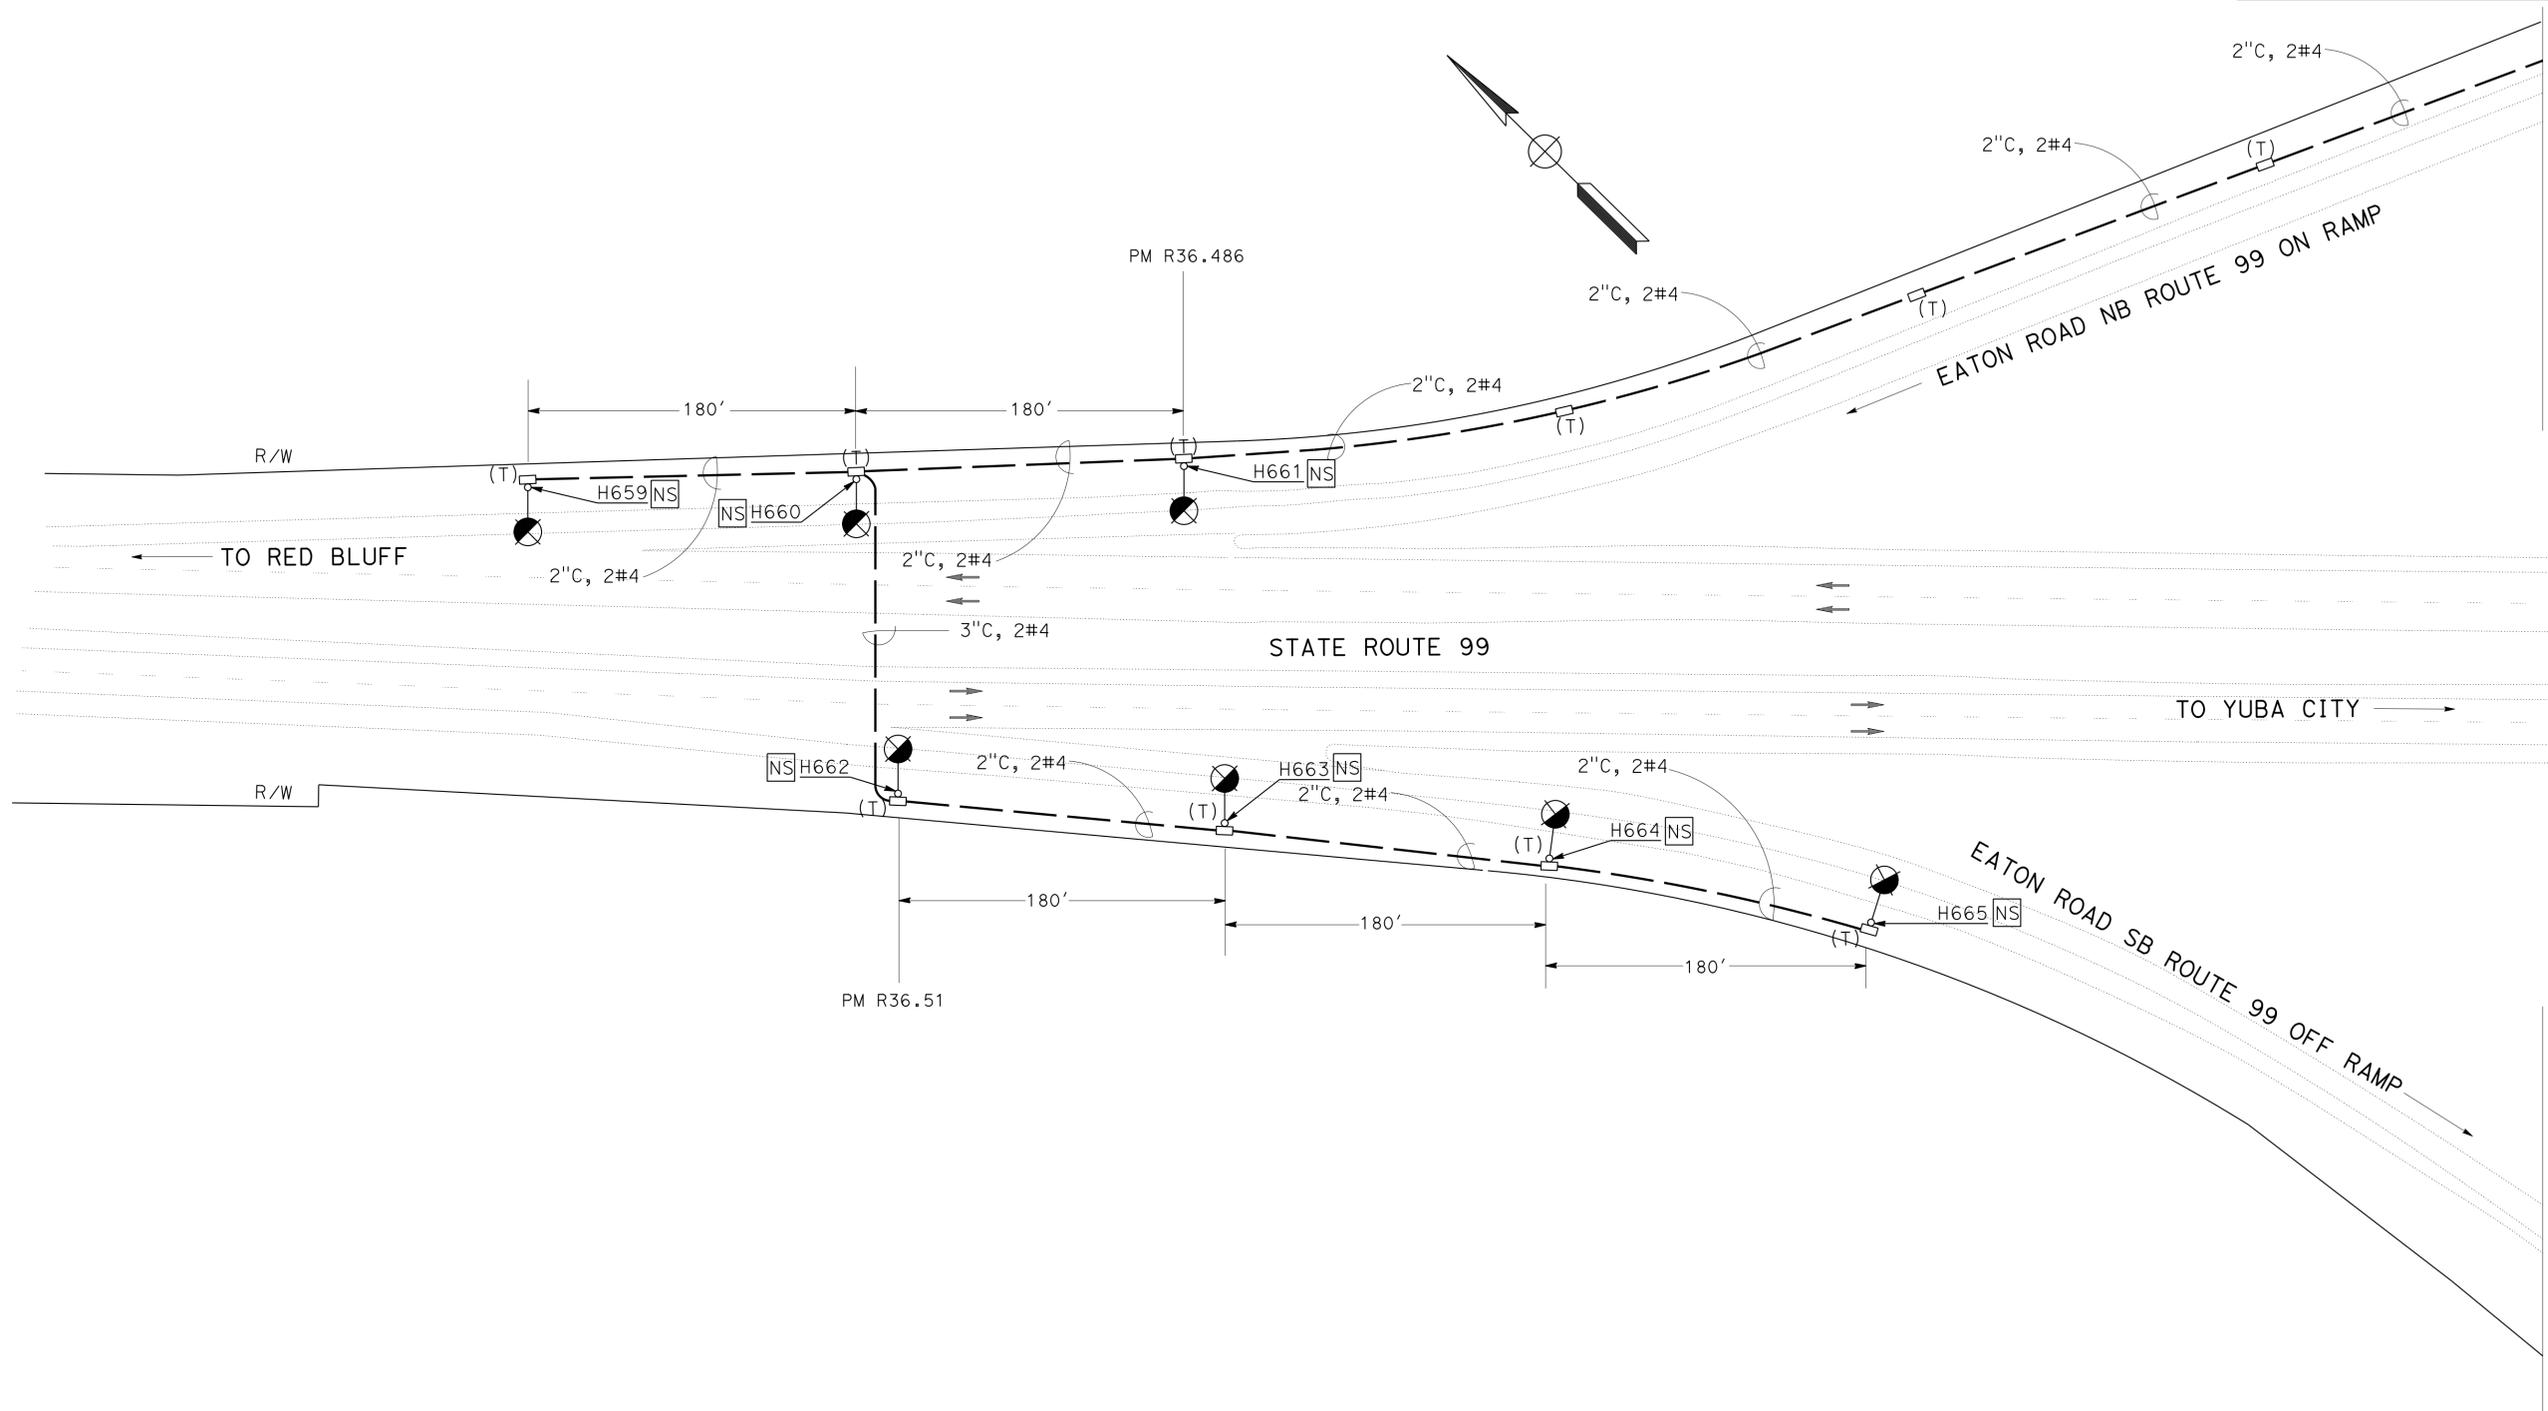

SEE SHEET E-7
(A - A)

SEE SHEET E-6
(B - B)

HIGHWAY LIGHTING
 SCALE 1" = 50'

APPROVED FOR ELECTRICAL WORK ONLY

Dist	COUNTY	ROUTE	POST MILES TOTAL PROJECT	SHEET No.	TOTAL SHEETS
03	Bu+	99	R34.2,R36.3	7	24

<i>Normanye</i>	2-2-15
REGISTERED ELECTRICAL ENGINEER	DATE
2-2-15	
PLANS APPROVAL DATE	

REGISTERED PROFESSIONAL ENGINEER
NORMAN S. YE
No. 16913
Exp. 6-30-15
ELECTRICAL
STATE OF CALIFORNIA


THE STATE OF CALIFORNIA OR ITS OFFICERS OR AGENTS SHALL NOT BE RESPONSIBLE FOR THE ACCURACY OR COMPLETENESS OF SCANNED COPIES OF THIS PLAN SHEET.

NOTE:

FOR ACCURATE RIGHT OF WAY DATA, CONTACT RIGHT OF WAY ENGINEERING AT THE DISTRICT OFFICE.

NOTES: THIS SHEET ONLY

1. SEE DETAIL SHEET E-9 FOR ALL NEW 5(T) PB.

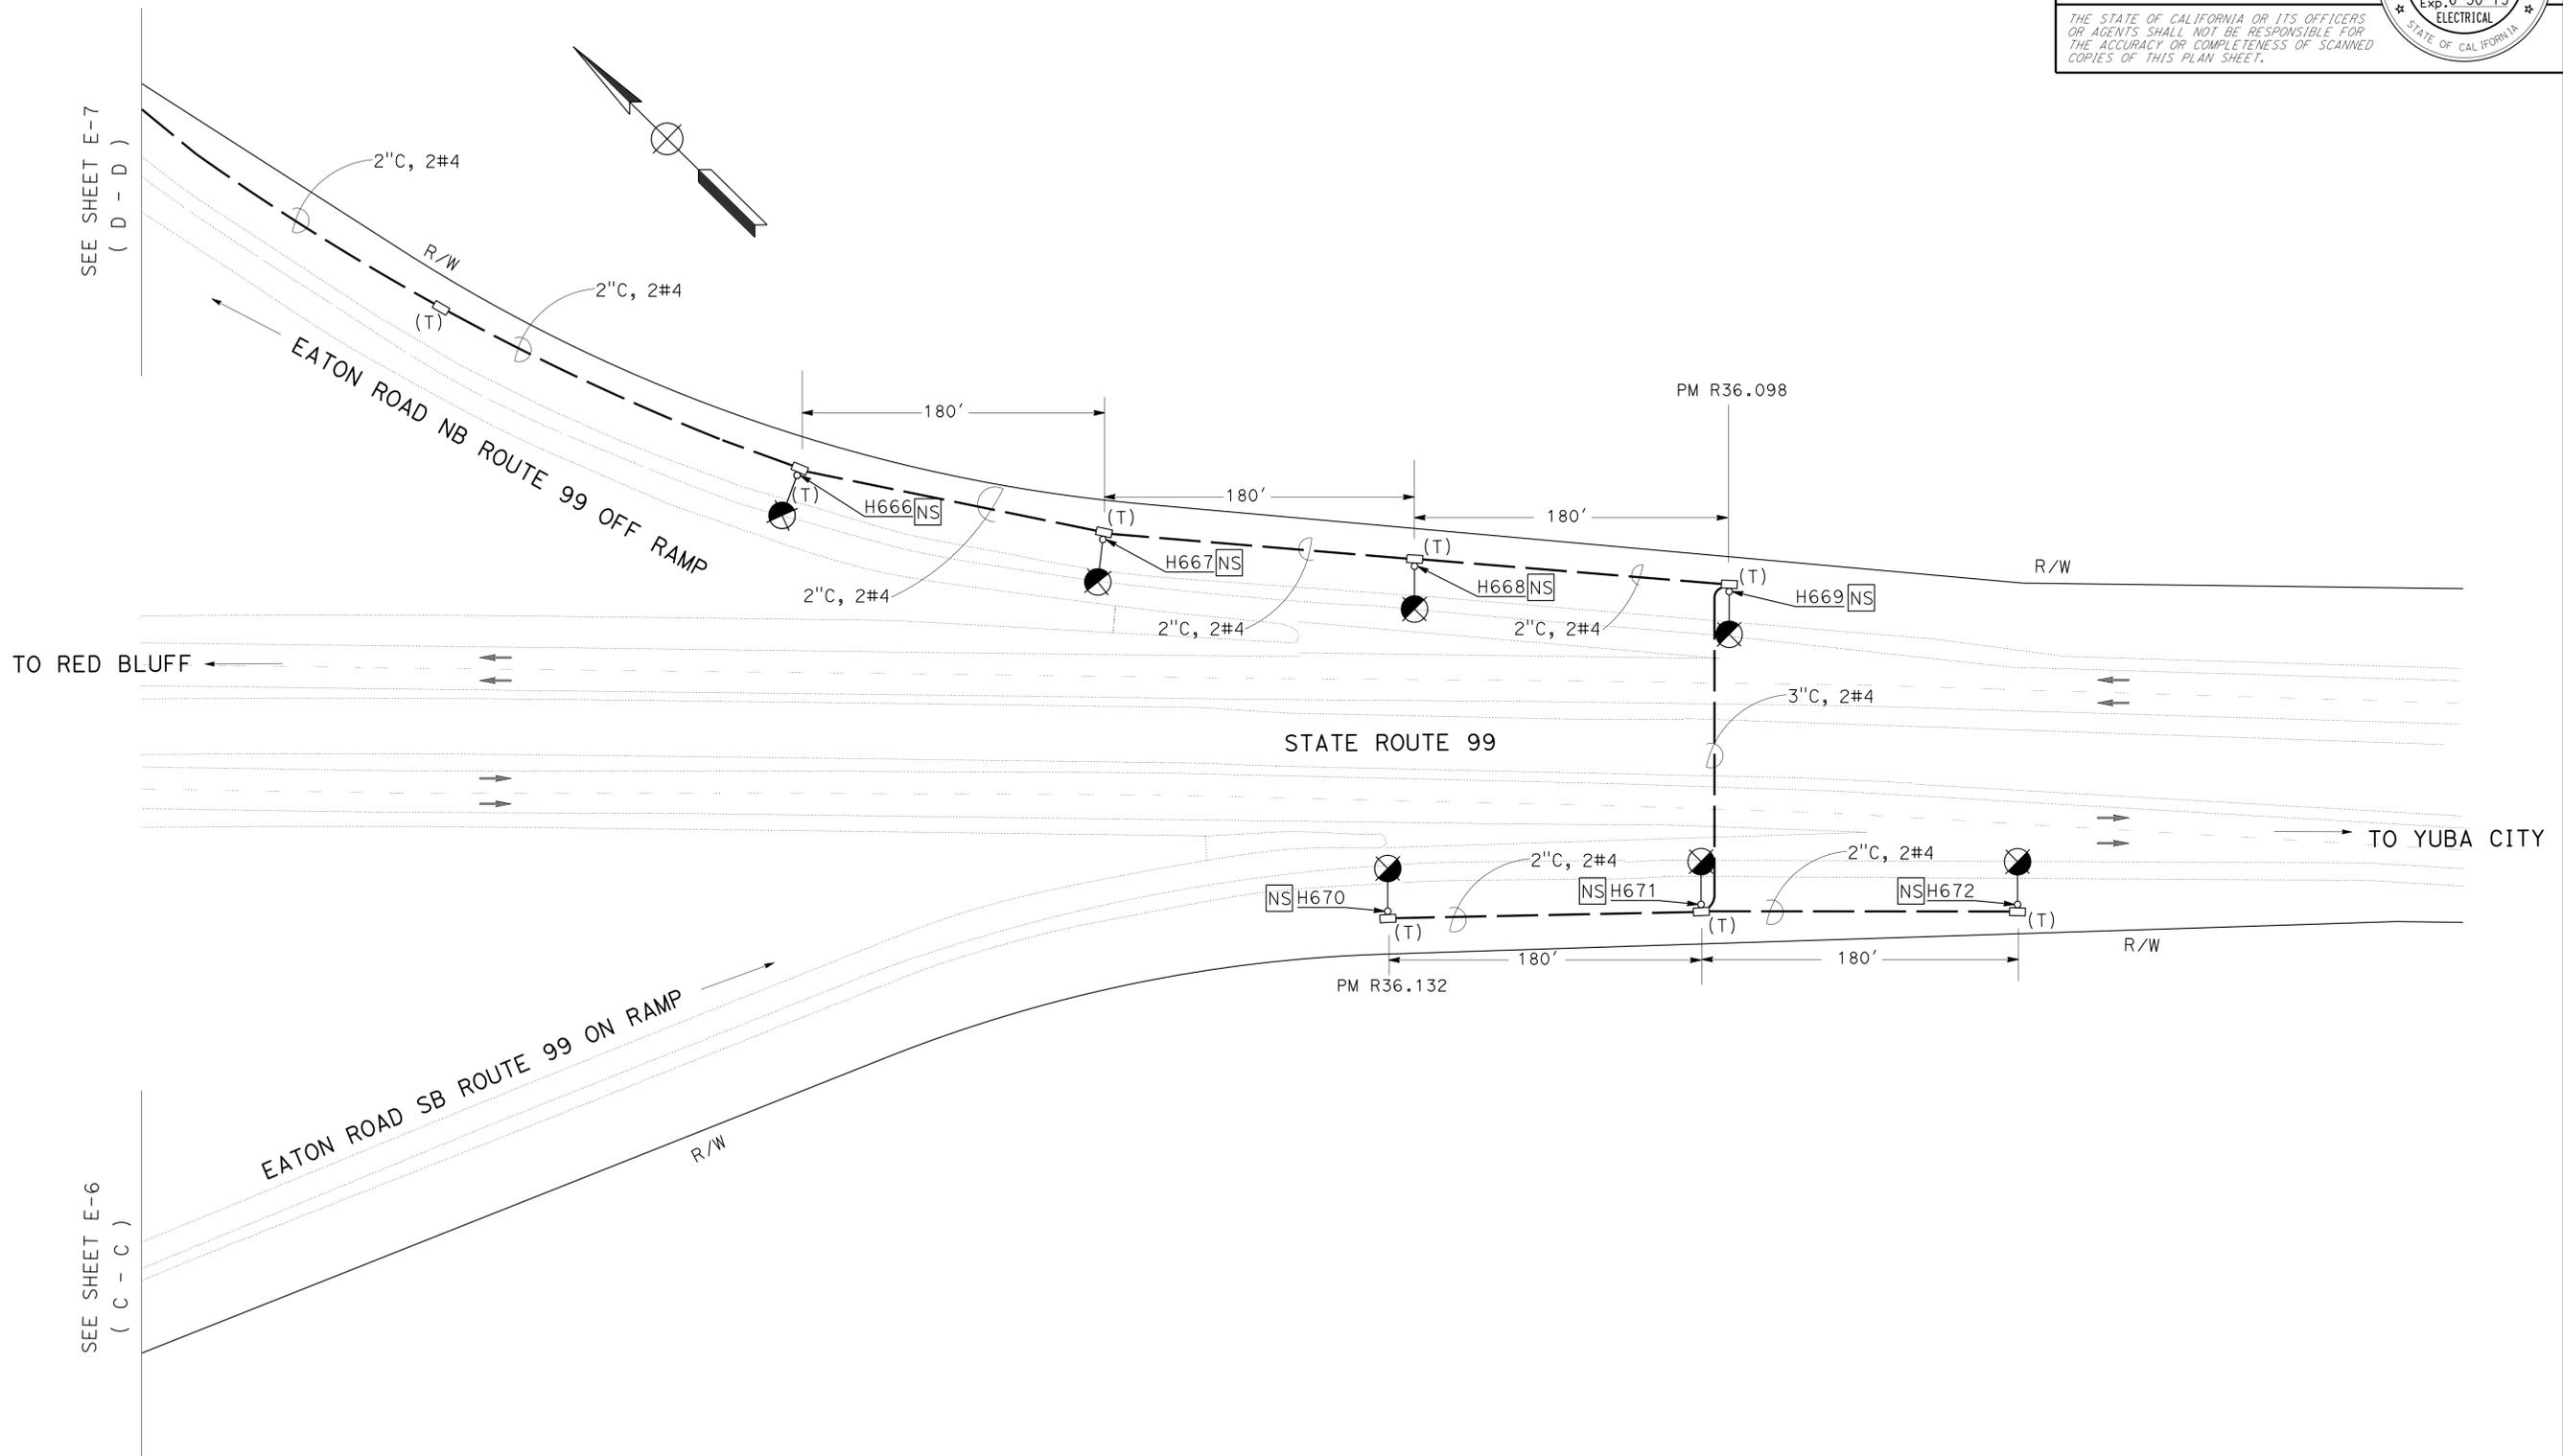

STATE OF CALIFORNIA - DEPARTMENT OF TRANSPORTATION	FUNCTIONAL SUPERVISOR	DESIGNED BY	REVISOR
Caltrans ELECTRICAL DESIGN	NELSON LEE	NATHAN DEKENS	NATHAN DEKENS
		CHECKED BY	DATE REVISOR
		NORMAN S. YE	

APPROVED FOR ELECTRICAL WORK ONLY

HIGHWAY LIGHTING
SCALE 1" = 50'

E-5

STATE OF CALIFORNIA - DEPARTMENT OF TRANSPORTATION	FUNCTIONAL SUPERVISOR	DESIGNED BY	REVISOR
Caltrans	NELSON LEE	CHECKED BY	NATHAN DEKENS
ELECTRICAL DESIGN			NORMAN S. YE

Dist	COUNTY	ROUTE	POST MILES TOTAL PROJECT	SHEET No.	TOTAL SHEETS
03	Bu+	99	R34.2,R36.3	9	24

2-2-15
 REGISTERED ELECTRICAL ENGINEER DATE
 2-2-15
 PLANS APPROVAL DATE

THE STATE OF CALIFORNIA OR ITS OFFICERS OR AGENTS SHALL NOT BE RESPONSIBLE FOR THE ACCURACY OR COMPLETENESS OF SCANNED COPIES OF THIS PLAN SHEET.

REGISTERED PROFESSIONAL ENGINEER
 NORMAN S. YE
 No. 16913
 Exp. 6-30-15
 ELECTRICAL
 STATE OF CALIFORNIA


NOTE:
 FOR ACCURATE RIGHT OF WAY DATA, CONTACT RIGHT OF WAY ENGINEERING AT THE DISTRICT OFFICE.

NOTES: THIS SHEET ONLY

- SEE DETAIL SHEET E-9 FOR ALL NEW 5(T) AND 6(T) PB.

LEGEND:

- TO PG&E UTILITY CONNECTION. CONDUIT AND FILL PER UTILITY.
- 25' POLE SHALL CONFORM TO PG&E SERVICE (SEE ES-2A) AND CLEARANCE OF THE OVERHEAD LINE FROM ANY OBSTACLES.

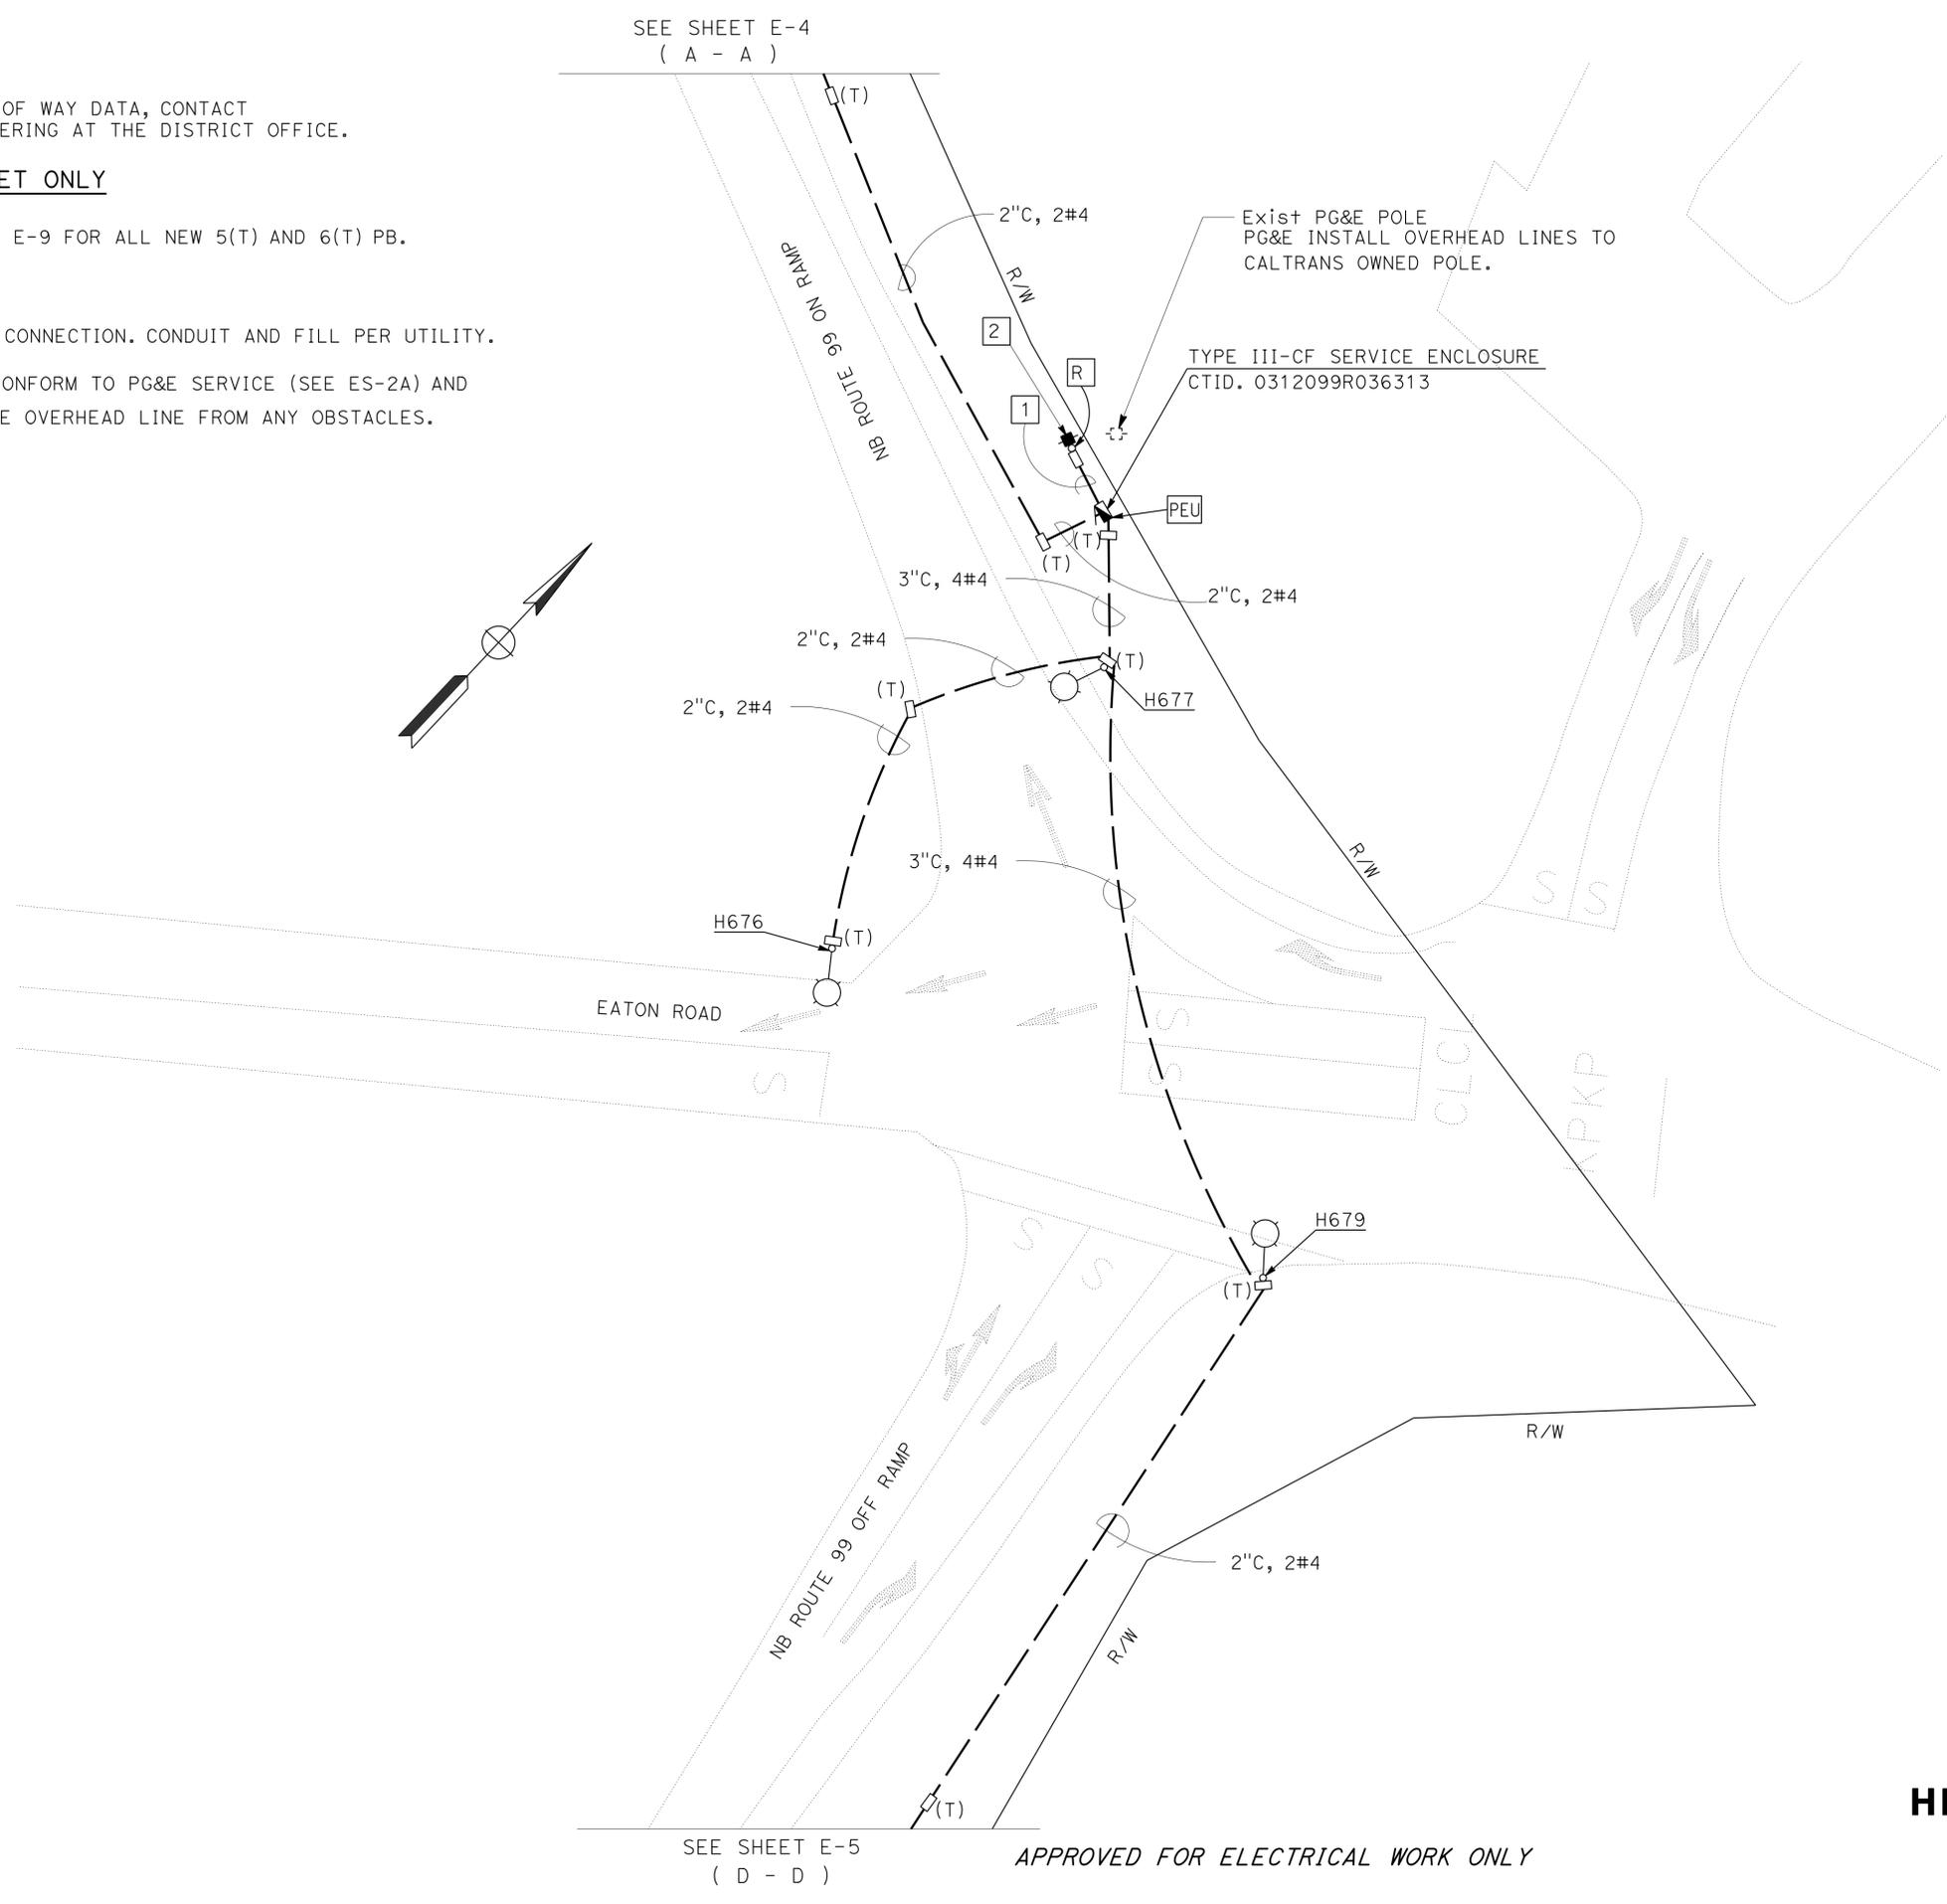

SEE SHEET E-4
(A - A)

SEE SHEET E-5
(D - D)


APPROVED FOR ELECTRICAL WORK ONLY

HIGHWAY LIGHTING

SCALE 1"= 20'

E-7

Dist	COUNTY	ROUTE	POST MILES TOTAL PROJECT	SHEET No.	TOTAL SHEETS
03	Bu+	99	R34.2,R36.3	10	24
<i>Normanye</i> REGISTERED ELECTRICAL ENGINEER			2-2-15 DATE		
PLANS APPROVAL DATE			2-2-15		
<small>THE STATE OF CALIFORNIA OR ITS OFFICERS OR AGENTS SHALL NOT BE RESPONSIBLE FOR THE ACCURACY OR COMPLETENESS OF SCANNED COPIES OF THIS PLAN SHEET.</small>					

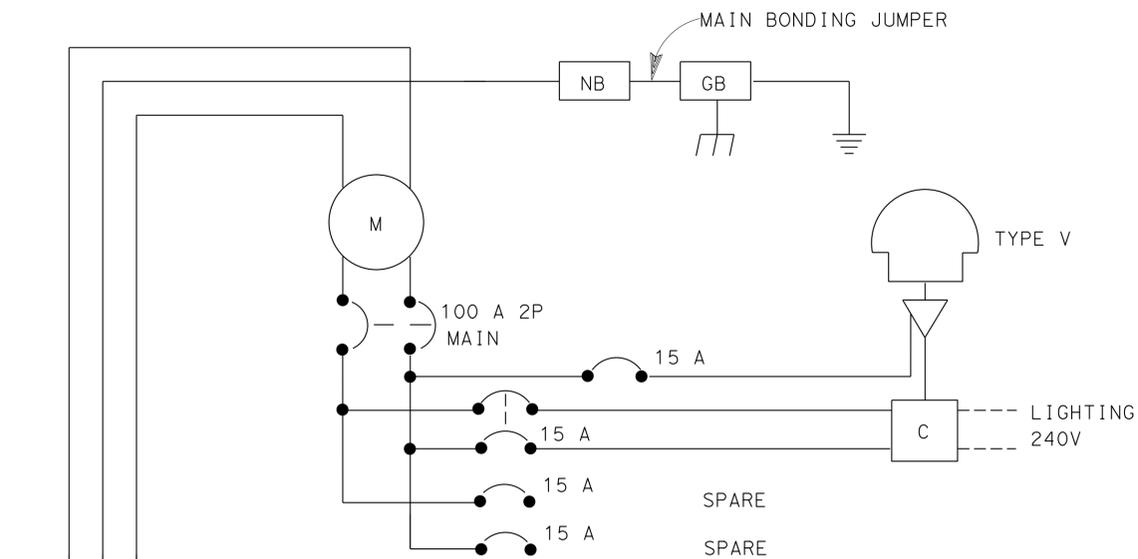


SERVICE WIRING DIAGRAM

CTID NO. 0312099R036349
LOAD: 3-165 W (LED LIGHTING)

WIRING DIAGRAM LEGEND:

- METER SOCKET AND SUPPORT
- CONTACTOR
- SOLID NEUTRAL BUS
- AUTO TEST SWITCH
- PHOTOELECTRIC UNIT

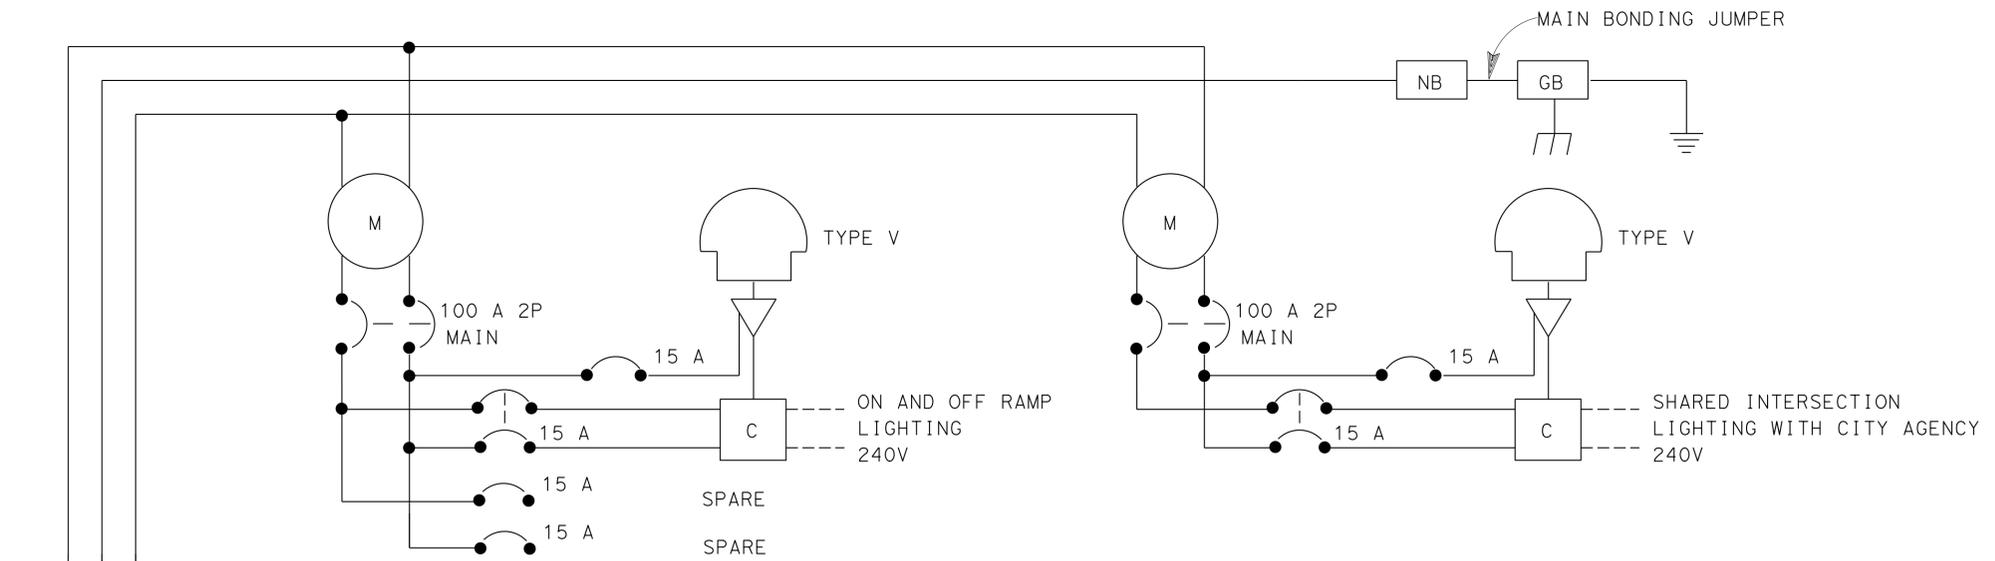

SERVICE WIRING DIAGRAM

CTID NO. 0312099R036313
LOAD: 3-165 W (LED LIGHTING)
7-235 W (LED LIGHTING)

STATE OF CALIFORNIA - DEPARTMENT OF TRANSPORTATION
Caltrans ELECTRICAL DESIGN
 FUNCTIONAL SUPERVISOR: NELSON LEE
 REVISIONS: NATHAN DEKENS, NORMAN S. YE, REVISOR; DATE, REVISION
 CALCULATED/DESIGNED BY, CHECKED BY

APPROVED FOR ELECTRICAL WORK ONLY

HIGHWAY LIGHTING

E-8



Dist	COUNTY	ROUTE	POST MILES TOTAL PROJECT	SHEET No.	TOTAL SHEETS
03	Bu+	99	R34.2,R36.3	12	24

Normanye 2-2-15
 REGISTERED ELECTRICAL ENGINEER DATE

2-2-15
 PLANS APPROVAL DATE

THE STATE OF CALIFORNIA OR ITS OFFICERS
 OR AGENTS SHALL NOT BE RESPONSIBLE FOR
 THE ACCURACY OR COMPLETENESS OF SCANNED
 COPIES OF THIS PLAN SHEET.

MODIFY LIGHTING (COHASSET ROAD)

SHEET No.	No. 5 PB	#4 AWG	1 1/2" TYPE 3 CONDUIT	TYPE 15 LUMINAIRE
	EA	FT	FT	EA
E-1	1	50	25	1

HIGHWAY LIGHTING (EATON ROAD)

SHEET No.	No. 5 (T) PB	No. 5 PB	No. 6E PB	No. 6E (T) PB	2" TYPE 3 CONDUIT	#4 AWG	TYPE 32 LUMINAIRE	TYPE 15 LUMINAIRE	TYPE III SERVICE PEDESTAL	25' WOODEN POLE WITH RISER
	EA		EA	EA	FT	FT	EA	EA	EA	EA
E-4	12				2000	4000	7			
E-5	11				2000	4000	7			
E-6	4		1	1	825	1650		3	1	
E-7	8	1			750	1500		4	1	1

NOTE: ITEMS SHOWN IN TABLES ARE NOT SEPERATE PAY ITEMS.

ELECTRICAL QUANTITIES

E-10

APPROVED FOR ELECTRICAL WORK ONLY

STATE OF CALIFORNIA - DEPARTMENT OF TRANSPORTATION
Caltrans
 ELECTRICAL DESIGN
 FUNCTIONAL SUPERVISOR
 NELSON LEE
 CALCULATED/DESIGNED BY
 CHECKED BY
 NATHAN DEKENS
 NORMAN S. YE
 REVISED BY
 DATE REVISED



Dist	COUNTY	ROUTE	POST MILES TOTAL PROJECT	SHEET No.	TOTAL SHEETS
03	But	99	R34.2,R36.3	13	24

Grace M. Tsushima
REGISTERED CIVIL ENGINEER

July 19, 2013
PLANS APPROVAL DATE

THE STATE OF CALIFORNIA OR ITS OFFICERS
OR AGENTS SHALL NOT BE RESPONSIBLE FOR
THE ACCURACY OR COMPLETENESS OF SCANNED
COPIES OF THIS PLAN SHEET.

TO ACCOMPANY PLANS DATED 2-2-15

UNIT OF MEASUREMENT SYMBOLS:

Some of the symbols used in the project plan quantity tables and in the Bid Item List are:

TABLE A

SYMBOL USED	DEFINITIONS
ACRE	ACRE
CF	CUBIC FOOT
CY	CUBIC YARD
EA	EACH
GAL	GALLON
LB	POUND
LF	LINEAR FOOT
SQFT	SQUARE FOOT
SQYD	SQUARE YARD
STA	100 FEET
TAB	TABLET
TON	2,000 POUNDS

Some of the symbols used in the plans other than in the project plan quantity tables are:

TABLE B

SYMBOL USED	DEFINITIONS
ksi	KIPS PER SQUARE INCH
ksf	KIPS PER SQUARE FOOT
psi	POUNDS PER SQUARE INCH
psf	POUNDS PER SQUARE FOOT
lb/ft ³ , pcf	POUNDS PER CUBIC FOOT
tsf	TONS PER SQUARE FOOT
mph, MPH *	MILES PER HOUR
∅	NOMINAL DIAMETER
oz	OUNCE
lb	POUND
kíp	1,000 POUNDS
cal	CALORIE
ft	FOOT OR FEET
gal	GALLON

* For use on a sign panel only

STATE OF CALIFORNIA
DEPARTMENT OF TRANSPORTATION

**ABBREVIATIONS
(SHEET 2 OF 2)**

NO SCALE

RSP A10B DATED JULY 19, 2013 SUPERSEDES STANDARD PLAN A10B
DATED MAY 20, 2011 - PAGE 2 OF THE STANDARD PLANS BOOK DATED 2010.

REVISED STANDARD PLAN RSP A10B

	M
Maint	MAINTENANCE
Max	MAXIMUM
MB	METAL BEAM
MBB	METAL BEAM BARRIER
MBGR	METAL BEAM GUARD RAILING
Med	MEDIAN
MGS	MIDWEST GUARDRAIL SYSTEM
MH	MANHOLE
Min	MINIMUM
Misc	MISCELLANEOUS
Misc I & S	MISCELLANEOUS IRON AND STEEL
Mkr	MARKER
Mod	MODIFIED, MODIFY
Mon	MONUMENT
MP	METAL PLATE
MPGR	METAL PLATE GUARD RAILING
MR	MOVEMENT RATING
MSE	MECHANICALLY STABILIZED EMBANKMENT
Mt	MOUNTAIN, MOUNT
MtI	MATERIAL
MVP	MAINTENANCE VEHICLE PULLOUT
	N
N	NORTH
NB	NORTHBOUND
No.	NUMBER (MUST HAVE PERIOD)
Nos.	NUMBERS (MUST HAVE PERIOD)
NPS	NOMINAL PIPE SIZE
NS	NEAR SIDE
NSP	NEW STANDARD PLAN
NTS	NOT TO SCALE
	O
Obir	OBLITERATE
OC	OVERCROSSING
OD	OUTSIDE DIAMETER
OF	OUTSIDE FACE
OG	ORIGINAL GROUND
OGAC	OPEN GRADED ASPHALT CONCRETE
OGFC	OPEN GRADED FRICTION COURSE
OH	OVERHEAD
OHWM	ORDINARY HIGH WATER MARK
O-O	OUT TO OUT
Opp	OPPOSITE
OSD	OVERSIDE DRAIN
	P
p	PAGE
PAP	PERFORATED ALUMINUM PIPE
PB	PULL BOX
PC	POINT OF CURVATURE, PRECAST
PCC	POINT OF COMPOUND CURVE, PORTLAND CEMENT CONCRETE
PCMS	PORTABLE CHANGEABLE MESSAGE SIGN
PCP	PERFORATED CONCRETE PIPE, PRESTRESSED CONCRETE PIPE
PCVC	POINT OF COMPOUND VERTICAL CURVE
PEC	PERMIT TO ENTER AND CONSTRUCT
Ped	PEDESTRIAN
Ped OC	PEDESTRIAN OVERCROSSING
Ped UC	PEDESTRIAN UNDERCROSSING
Perm MtI	PERMEABLE MATERIAL

	P continued
PG	PROFILE GRADE
PI	POINT OF INTERSECTION
PJP	PARTIAL JOINT PENETRATION
Pkwy	PARKWAY
PL, PL	PLATE
P/L	PROPERTY LINE
PM	POST MILE, TIME FROM NOON TO MIDNIGHT
PN	PAVING NOTCH
POC	POINT OF HORIZONTAL CURVE
POT	POINT OF TANGENT
POVC	POINT OF VERTICAL CURVE
PP	PIPE PILE, PLASTIC PIPE, POWER POLE
PPL	PREFORMED PERMEABLE LINER
PPP	PERFORATED PLASTIC PIPE
PRC	POINT OF REVERSE CURVE
PRF	PAVEMENT REINFORCING FABRIC
PRVC	POINT OF REVERSE VERTICAL CURVE
PS&E	PLANS, SPECIFICATIONS AND ESTIMATES
PS, P/S	PRESTRESSED
PSP	PERFORATED STEEL PIPE
PT	POINT OF TANGENCY
PVC	POLYVINYL CHLORIDE
Pvmt	PAVEMENT
	Q
Qty	QUANTITY
	R
R	RADIUS
R & D	REMOVE AND DISPOSE
R & S	REMOVE AND SALVAGE
R/C	RATE OF CHANGE
RCA	REINFORCED CONCRETE ARCH
RCB	REINFORCED CONCRETE BOX
RCP	REINFORCED CONCRETE PIPE
RCPA	REINFORCED CONCRETE PIPE ARCH
Rd	ROAD
Reinf	REINFORCED, REINFORCEMENT, REINFORCING
Rel	RELOCATE
Repl	REPLACEMENT
Ret	RETAINING
Rev	REVISED, REVISION
Rdwy	ROADWAY
RHMA	RUBBERIZED HOT MIX ASPHALT
Riv	RIVER
RM	ROAD-MIXED
RP	RADIUS POINT, REFERENCE POINT
RR	RAILROAD
RSP	ROCK SLOPE PROTECTION, REVISED STANDARD PLAN
Rt	RIGHT
Rte	ROUTE
RW	REDWOOD, RETAINING WALL
R/W	RIGHT OF WAY
Rwy	RAILWAY

	S
S	SOUTH, SUPPLEMENT
SAE	STRUCTURE APPROACH EMBANKMENT
Salv	SALVAGE
SAPP	STRUCTURAL ALUMINUM PLATE PIPE
SB	SOUTHBOUND
SC	SAND CUSHION
SCSP	SLOTTED CORRUGATED STEEL PIPE
SD	STORM DRAIN
Sec	SECOND, SECTION
Sep	SEPARATION
SG	SUBGRADE
Shld	SHOULDER
Sht	SHEET
Sim	SIMILAR
ℒ	STATION LINE
SM	SELECTED MATERIAL
Spec	SPECIAL, SPECIFICATIONS
SPP	SLOTTED PLASTIC PIPE
SS	SLOPE STAKE
SSBM	STRAP AND SADDLE BRACKET METHOD
SSD	STRUCTURAL SECTION DRAIN
SSPA	STRUCTURAL STEEL PLATE ARCH
SSPP	STRUCTURAL STEEL PLATE PIPE
SSPPA	STRUCTURAL STEEL PLATE PIPE ARCH
SSRP	STEEL SPIRAL RIB PIPE
St	STREET
Sta	STATION
STBB	SINGLE THRIE BEAM BARRIER
Std	STANDARD
Str	STRUCTURE
Surf	SURFACING
SW	SIDEWALK, SOUND WALL
Swr	SEWER
Sym	SYMMETRICAL
S4S	SURFACE 4 SIDES
	T
T	SEMI-TANGENT
Tan	TANGENT
TBB	THRIE BEAM BARRIER
Tbr	TIMBER
TC	TOP OF CURB
TCB	TRAFFIC CONTROL BOX
TCE	TEMPORARY CONSTRUCTION EASEMENT
TeI	TELEPHONE
Temp	TEMPORARY
TG	TOP OF GRADE
Tot	TOTAL
TP	TELEPHONE POLE
TPB	TREATED PERMEABLE BASE
TPM	TREATED PERMEABLE MATERIAL
Trans	TRANSITION

	T continued
TS	TRANSVERSE, TRAFFIC SIGNAL, TUBULAR STEEL
Typ	TYPICAL
	U
UC	UNDERCROSSING
UD	UNDERDRAIN
UG	UNDERGROUND
UON	UNLESS OTHERWISE NOTED
UP	UNDERPASS
	V
V	VALVE, DESIGN SPEED
Var	VARIABLE, VARIES
VC	VERTICAL CURVE
VCP	VITRIFIED CLAY PIPE
Vert	VERTICAL
Via	VIADUCT
Vol	VOLUME
	W
W	WEST, WIDTH
WB	WESTBOUND
WH	WEEP HOLE
WM	WIRE MESH
WS	WATER SURFACE
WSP	WELDED STEEL PIPE
Wt	WEIGHT
WV	WATER VALVE
WW	WINGWALL
WWLOL	WINGWALL LAYOUT LINE
	X
X Sec	CROSS SECTION
Xing	CROSSING
	Y
Yr	YEAR
Yrs	YEARS

TO ACCOMPANY PLANS DATED 2-2-15

TABLE 1

TAPER LENGTH CRITERIA AND CHANNELIZING DEVICE SPACING							
SPEED (S)	MINIMUM TAPER LENGTH * FOR WIDTH OF OFFSET 12 FEET (W)				MAXIMUM CHANNELIZING DEVICE SPACING		
	TANGENT 2L	MERGING L	SHIFTING L/2	SHOULDER L/3	X	Y	Z **
					TAPER	TANGENT	CONFLICT
mph	ft	ft	ft	ft	ft	ft	ft
20	160	80	40	27	20	40	10
25	250	125	63	42	25	50	12
30	360	180	90	60	30	60	15
35	490	245	123	82	35	70	17
40	640	320	160	107	40	80	20
45	1080	540	270	180	45	90	22
50	1200	600	300	200	50	100	25
55	1320	660	330	220	55	110	27
60	1440	720	360	240	60	120	30
65	1560	780	390	260	65	130	32
70	1680	840	420	280	70	140	35

* - For other offsets, use the following merging taper length formula for L:
 For speed of 40 mph or less, $L = WS^2/60$
 For speed of 45 mph or more, $L = WS$

Where: L = Taper length in feet
 W = Width of offset in feet
 S = Posted speed limit, off-peak 85th-percentile speed prior to work starting, or the anticipated operating speed in mph

** - Use for taper and tangent sections where there are no pavement markings or where there is a conflict between existing pavement markings and channelizers (CA).

TABLE 2

LONGITUDINAL BUFFER SPACE AND FLAGGER STATION SPACING				
SPEED *	Min D **	DOWNGRADE Min D ***		
		-3%	-6%	-9%
		ft	ft	ft
20	115	116	120	126
25	155	158	165	173
30	200	205	215	227
35	250	257	271	287
40	305	315	333	354
45	360	378	400	427
50	425	446	474	507
55	495	520	553	593
60	570	598	638	686
65	645	682	728	785
70	730	771	825	891

* - Speed is posted speed limit, off-peak 85th-percentile speed prior to work starting, or the anticipated operating speed in mph
 ** - Longitudinal buffer space or flagger station spacing
 *** - Use on sustained downgrade steeper than -3 percent and longer than 1 mile.

TABLE 3

ADVANCE WARNING SIGN SPACING			
ROAD TYPE	DISTANCE BETWEEN SIGNS *		
	A	B	C
	ft	ft	ft
URBAN - 25 mph OR LESS	100	100	100
URBAN - MORE THAN 25 mph TO 40 mph	250	250	250
URBAN - MORE THAN 40 mph	350	350	350
RURAL	500	500	500
EXPRESSWAY / FREEWAY	1000	1500	2640

* - The distances are approximate, are intended for guidance purposes only, and should be applied with engineering judgment. These distances should be adjusted by the Engineer for field conditions, if necessary, by increasing or decreasing the recommended distances.

STATE OF CALIFORNIA
 DEPARTMENT OF TRANSPORTATION
**TRAFFIC CONTROL SYSTEM TABLES
 FOR LANE AND RAMP CLOSURES**

NO SCALE

RSP T9 DATED JULY 19, 2013 SUPERSEDES RSP T9 DATED APRIL 19, 2013 THAT SUPPLEMENTS THE STANDARD PLANS BOOK DATED 2010.

REVISED STANDARD PLAN RSP T9


2010 REVISED STANDARD PLAN RSP T9

Dist	COUNTY	ROUTE	POST MILES TOTAL PROJECT	SHEET No.	TOTAL SHEETS
03	But	99	R34.2,R36.3	15	24

REGISTERED CIVIL ENGINEER
 April 19, 2013
 PLANS APPROVAL DATE

Gurinderpal Bhullar
 No. C48815
 Exp. 9-30-14
 CIVIL ENGINEER
 STATE OF CALIFORNIA

THE STATE OF CALIFORNIA OR ITS OFFICERS OR AGENTS SHALL NOT BE RESPONSIBLE FOR THE ACCURACY OR COMPLETENESS OF SCANNED COPIES OF THIS PLAN SHEET.

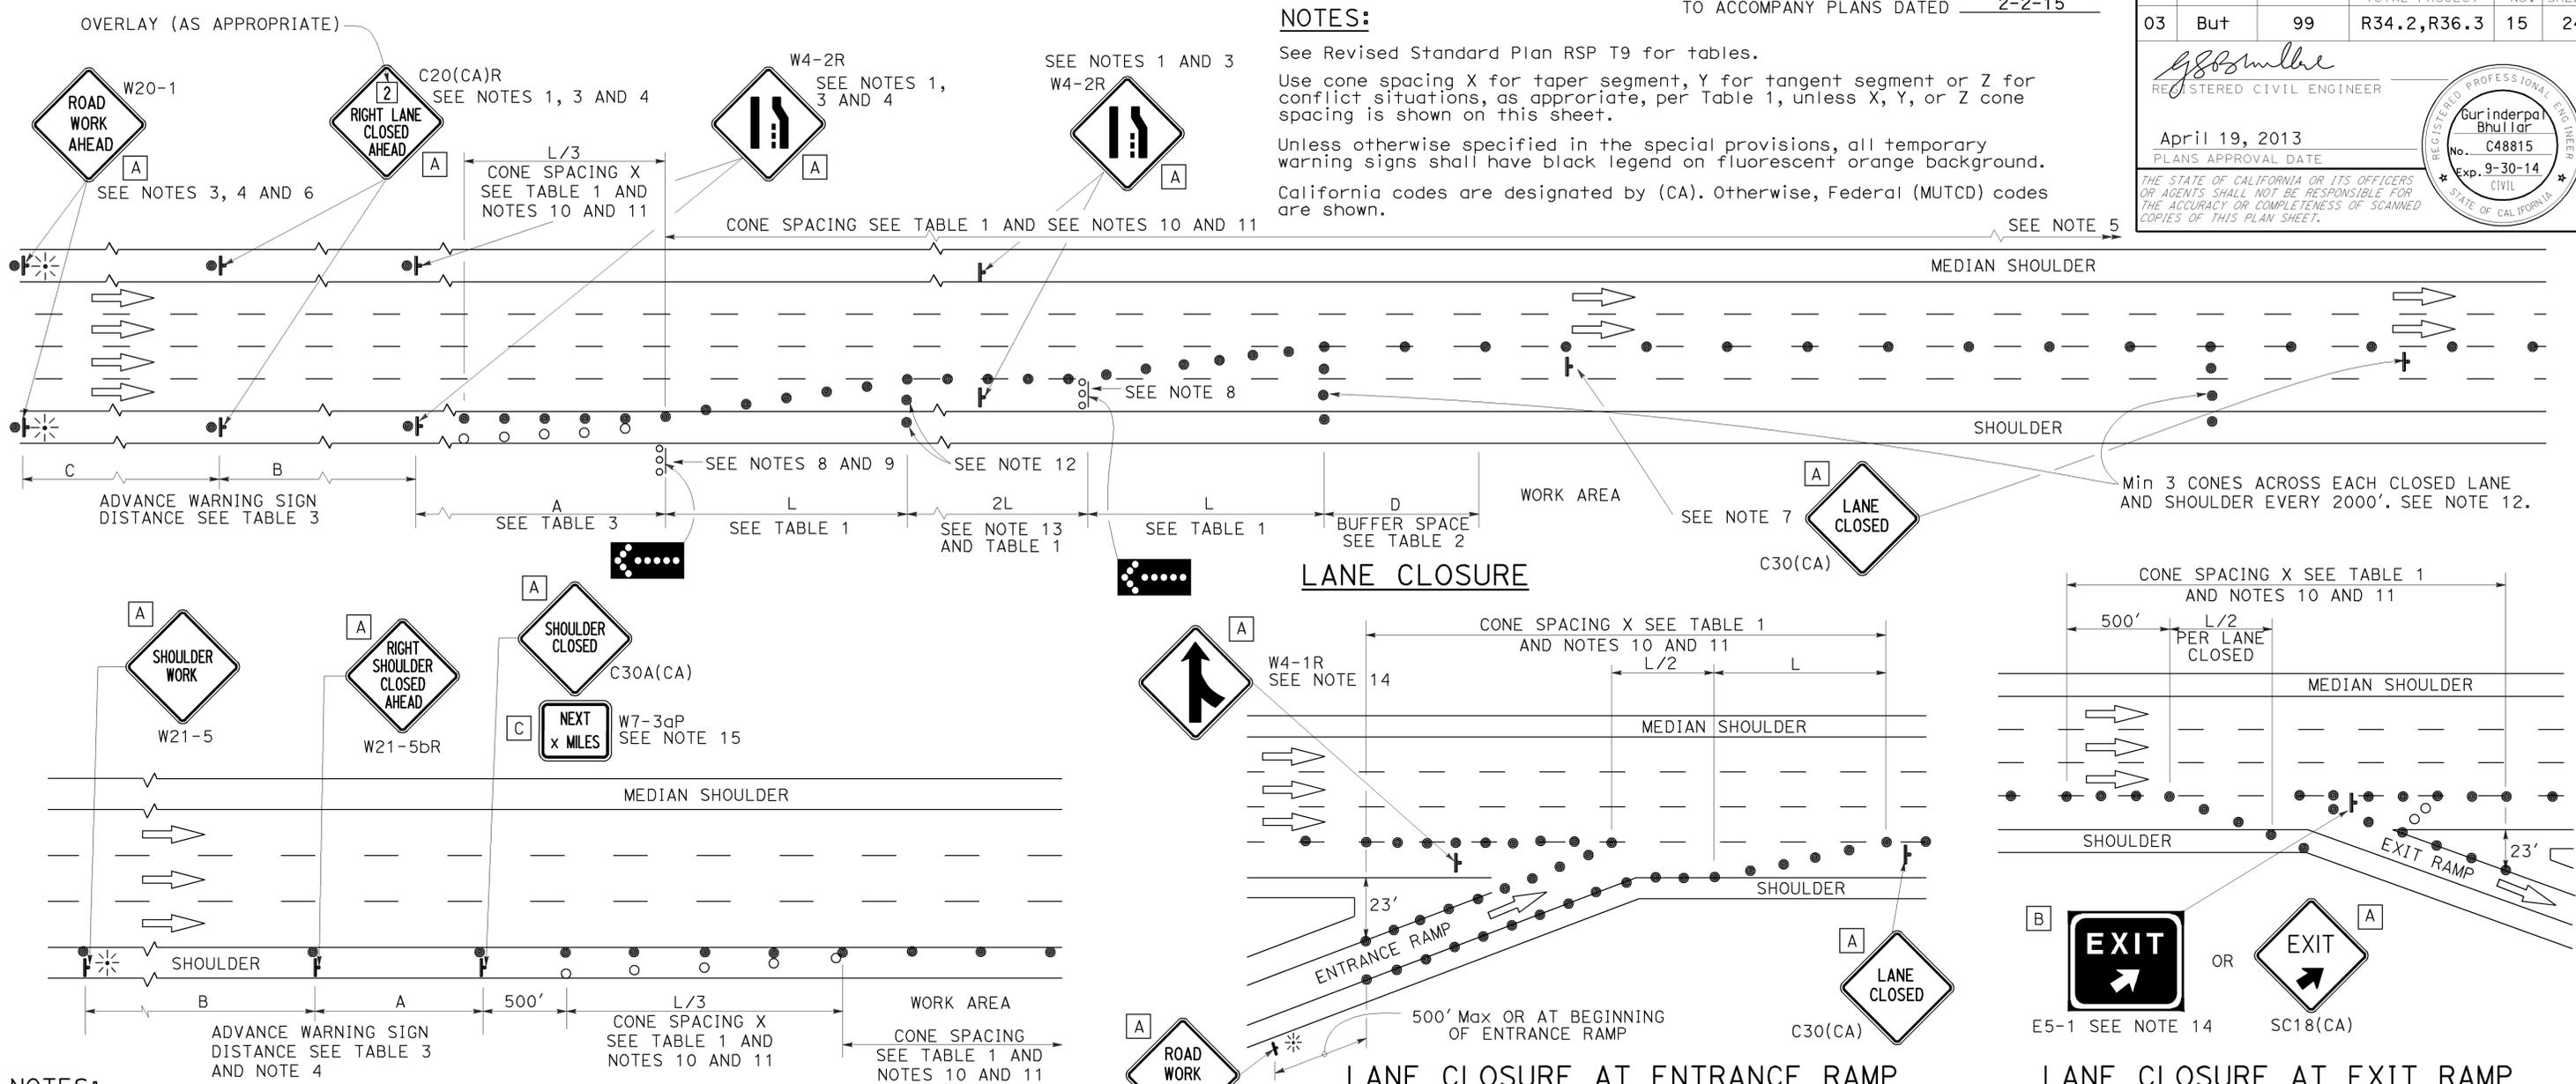

- NOTES:**
1. Median lane closures shall conform to the details as shown except that C20(CA)L and W4-2L signs shall be used.
 2. At least one person shall be assigned to provide full time maintenance of traffic control devices for lane closures.
 3. Duplicate sign installations are not required:
 - a) On opposite shoulder if at least one-half of the available lanes remain open to traffic.
 - b) In the median if the width of the median shoulder is less than 8' and the outside lanes are to be closed.
 4. Each advance warning sign on each side of the roadway shall be equipped with at least two flags for daytime closure. Each flag shall be at least 16" x 16" in size and shall be orange or fluorescent red-orange in color. Flashing beacons shall be placed at the locations indicated for lane closure during hours of darkness.
 5. A G20-2 "END ROAD WORK" sign, with minimum size of 48" x 24" as appropriate, shall be placed at the end of the lane closure unless the end of work area is obvious or ends within a larger project's limits.

- SHOULDER CLOSURE**
6. If the W20-1 sign would follow within 2000' of a stationary W20-1 or G20-1 "ROAD WORK NEXT _____ MILES", use a C20(CA)L and W4-2L signs shall be used.
 7. Place a C30(CA) sign every 2000' throughout length of lane closure.
 8. One flashing arrow sign for each lane closed. The flashing arrow signs shall be Type I.
 9. A minimum 1500' of sight distance shall be provided where possible for vehicles approaching the first flashing arrow sign. Lane closures shall not begin at top of crest vertical curve or on a horizontal curve.
 10. All cones used for lane closures during the hours of darkness shall be fitted with retroreflective bands (or sleeves) as specified in the specifications.
 11. Portable delineators, placed at one-half the spacing indicated for traffic cones may be used instead of cones for daytime closures only.

- LANE CLOSURE AT ENTRANCE RAMP**
- LANE CLOSURE AT EXIT RAMP**
12. Unless otherwise specified in the special provisions, a minimum of 3 cones shall be placed transversely across each closed lane and shoulder at each location where a taper across a traffic lane ends and every 2000' as shown on the "Lane Closure" detail. Two Type II barricades may be used instead of the 3 cones. The transverse alignment of the cones or barricades on the closed shoulder may be shifted from the transverse alignment to provide access to the work.
 13. Unless otherwise specified in the special provisions, the 2L tangent shown along lane lines shall be used between the L tapers required for each closed traffic lane.
 14. Unless otherwise specified in the special provisions, the E5-1 or SC18(CA) and W4-1 signs shall be used as shown.
 15. A W7-3aP "NEXT _____ MILES" plaque must be used if the shoulder closure extends beyond the distance that can be perceived by road users.

LEGEND

- TRAFFIC CONE
- TRAFFIC CONE (OPTIONAL TAPER)
- † TEMPORARY TRAFFIC CONTROL SIGN
- ⬢ FLASHING ARROW SIGN (FAS)
- ⬢ FAS SUPPORT OR TRAILER
- ⚡ PORTABLE FLASHING BEACON

SIGN PANEL SIZE (Min)

A	48" x 48"
B	72" x 60"
C	36" x 30"

STATE OF CALIFORNIA
 DEPARTMENT OF TRANSPORTATION

**TRAFFIC CONTROL SYSTEM
 FOR LANE CLOSURE ON
 FREEWAYS AND EXPRESSWAYS**

NO SCALE

RSP T10 DATED APRIL 19, 2013 SUPERSEDES STANDARD PLAN T10 DATED MAY 20, 2011 - PAGE 237 OF THE STANDARD PLANS BOOK DATED 2010.

REVISED STANDARD PLAN RSP T10

2010 REVISED STANDARD PLAN RSP T10

NOTES:

See Revised Standard Plan RSP T9 for tables.


Use cone spacing X for taper segment, Y for tangent segment or Z for conflict situations, as appropriate, per Table 1, unless X, Y, or Z cone spacing is shown on this sheet.

Unless otherwise specified in the special provisions, all temporary warning signs shall have black legend on fluorescent orange background.

California codes are designated by (CA). Otherwise, Federal (MUTCD) codes are shown.


TYPICAL LANE CLOSURE WITH REVERSIBLE CONTROL

TO ACCOMPANY PLANS DATED 2-2-15

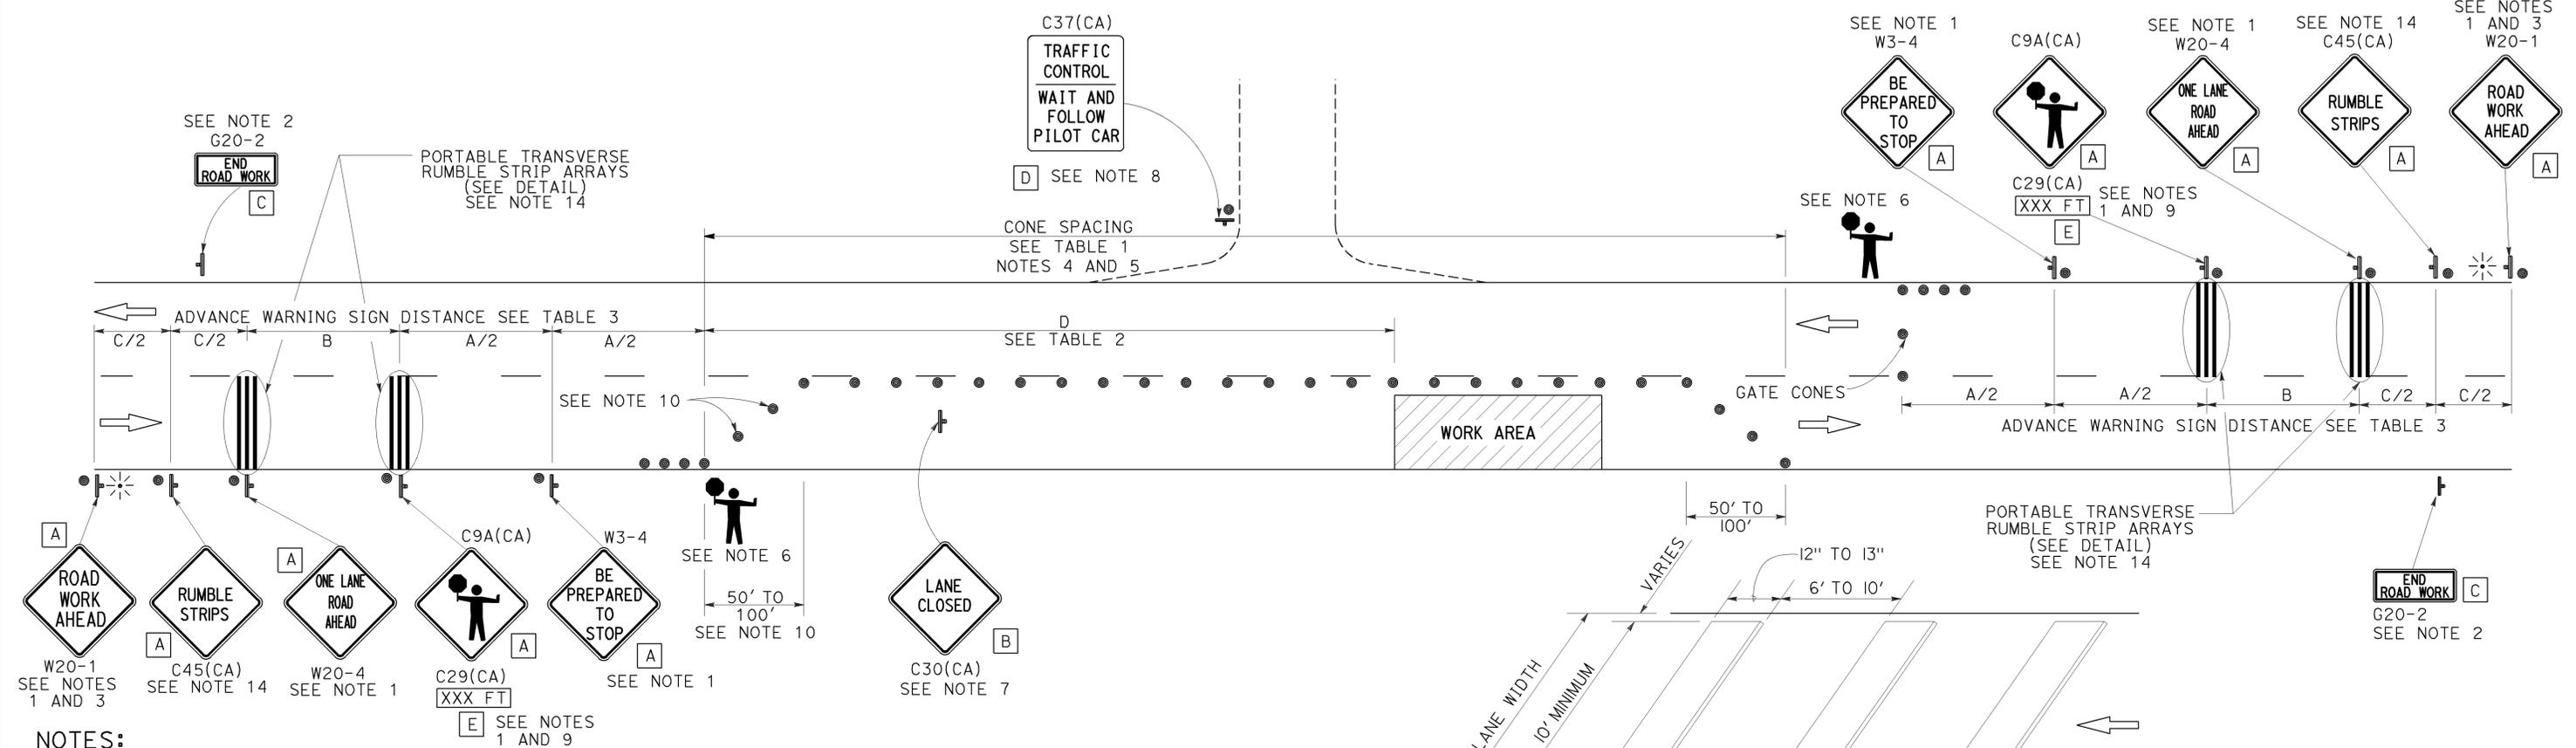

- NOTES:**
- Each advance warning sign in each direction of travel shall be equipped with at least two flags for daytime closure. Each flag shall be at least 16" x 16" in size and shall be orange or fluorescent red-orange in color. Flashing beacons shall be placed at the locations indicated for lane closure during hours of darkness.
 - A G20-2 "END ROAD WORK" sign, as appropriate, shall be placed at the end of the lane control unless the end of work area is obvious, or ends within a larger project's limits.
 - If the W20-1 sign would follow within 2000' of a stationary W20-1 or G20-1 "ROAD WORK NEXT _____ MILES", use a W20-4 sign for the first advance warning sign.
 - All cones used for lane closures during the hours of darkness shall be fitted with retroreflective bands (or sleeves) as specified in the specifications.
 - Portable delineators, placed at one-half the spacing indicated for traffic cones, may be used instead of cones for daytime closures only.
 - Additional advance flaggers may be required. Flagger should stand in a conspicuous place, be visible to approaching traffic as well as approaching vehicles after the first vehicle has stopped. During the hours of darkness, the flagging-station and flagger shall be illuminated and clearly visible to approaching traffic. The illumination footprint of the lighting on the ground shall be at least 20' in diameter. Place a minimum of four cones at 50' intervals in advance of flagger station as shown.

- Place C30(CA) "LANE CLOSED" sign at 500' to 1000' intervals throughout extended work areas. They are optional if the work area is visible from the flagger station.
- When a pilot car is used, place a C37(CA) "TRAFFIC CONTROL-WAIT AND FOLLOW PILOT CAR" sign with black legend on white background at all intersections, driveways and alleys without a flagger within traffic control area. Signs shall be clean and visible at all times. Where traffic can not be effectively self-regulated, at least one flagger shall be used at each intersection within traffic control area.
- An optional C29(CA) sign may be placed below the C9A(CA) sign.
- Either traffic cones or barricades shall be placed on the taper. Barricades shall be Type I, II, or III.
- The color of the portable transverse rumble strips shall be black or orange. Use 2 arrays, each array shall consist of 3 rumble strips.
- Portable transverse rumble strips shall not be placed on sharp horizontal or vertical curves nor shall they be placed through pedestrian crossings.
- If the portable transverse rumble strips become out of alignment (skewed) by more than 6 inches, measured from one end to the other, they shall be readjusted to bring the placement back to the original location.
- Portable transverse rumble strips are not required if any one of the following conditions is satisfied:
 - Work duration occupies a location for four hours or less
 - Posted speed limit is below 45 MPH
 - Work is of emergency nature
 - Work zone is in snow or icy weather conditions

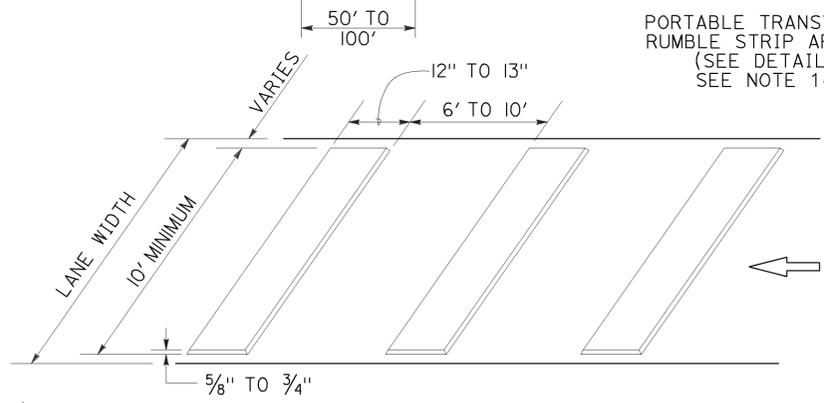

SIGN PANEL SIZE (Min)

- A 48" x 48"
- B 30" x 30"
- C 36" x 18"
- D 36" x 42"
- E 20" x 7"

LEGEND

- TRAFFIC CONE
- ⊥ TEMPORARY TRAFFIC CONTROL SIGN
- ⚡ PORTABLE FLASHING BEACON
- 🚧 FLAGGER

STATE OF CALIFORNIA
DEPARTMENT OF TRANSPORTATION

**TRAFFIC CONTROL SYSTEM
FOR LANE CLOSURE ON
TWO LANE CONVENTIONAL
HIGHWAYS**

NO SCALE

RSP T13 DATED OCTOBER 17, 2014 SUPERSEDES RSP T13 DATED JULY 18, 2014
AND RSP T13 DATED APRIL 19, 2013 AND STANDARD PLAN T13 DATED
MAY 20, 2011 - PAGE 241 OF THE STANDARD PLANS BOOK DATED 2010.

2010 REVISED STANDARD PLAN RSP T13

TYPICAL RAMP CLOSURES

SIGN PANEL SIZE (Min)

- A 48" x 48"
- B 48" x 30"
- C 36" x 36"
- D 48" x 36"

LEGEND

- TRAFFIC CONE
- † TEMPORARY TRAFFIC CONTROL SIGN
- ‡ BARRICADES
- ⚡ PORTABLE FLASHING BEACON


Dist	COUNTY	ROUTE	POST MILES TOTAL PROJECT	SHEET No.	TOTAL SHEETS
03	But	99	R34.2,R36.3	17	24

Gurinderpal Bhullar
 REGISTERED CIVIL ENGINEER
 April 19, 2013
 PLANS APPROVAL DATE
THE STATE OF CALIFORNIA OR ITS OFFICERS OR AGENTS SHALL NOT BE RESPONSIBLE FOR THE ACCURACY OR COMPLETENESS OF SCANNED COPIES OF THIS PLAN SHEET.


TO ACCOMPANY PLANS DATED 2-2-15

NOTES:


- Barricades shall be Type I, II, or III for closures lasting one week or less and Type III for closures lasting longer than one week.
- In addition to placing the C19(CA) "RAMP CLOSED AHEAD" and C30(CA) "RAMP CLOSED" signs, black on orange overlay plates with the word "CLOSED" may be mounted, as directed by the Engineer, on all guide signs that refer to the closed ramp. The letter size on the overlay shall be the same as the guide sign.
- Each advance C19(CA) "RAMP CLOSED AHEAD" sign shall be equipped with at least two flags for daytime closure. Each flag shall be at least 16" x 16" in size and shall be orange or fluorescent red-orange in color. A flashing beacon shall be placed on top of the first C19(CA) sign during hours of darkness.
- All cones used for ramp closures during the hours of darkness shall be fitted with retroreflective bands (or sleeves) as specified in the specifications.
- Portable delineators, placed at one-half the spacing indicated for traffic cones, may be used instead of cones for daytime ramp closures only.
- At least one person shall be assigned to provide full time maintenance of traffic control devices, unless otherwise directed by the Engineer.
- The existing "EXIT" signs shall be covered during ramp closures.
- A minimum of 3 cones shall be placed transversely across each closed lane and shoulder.

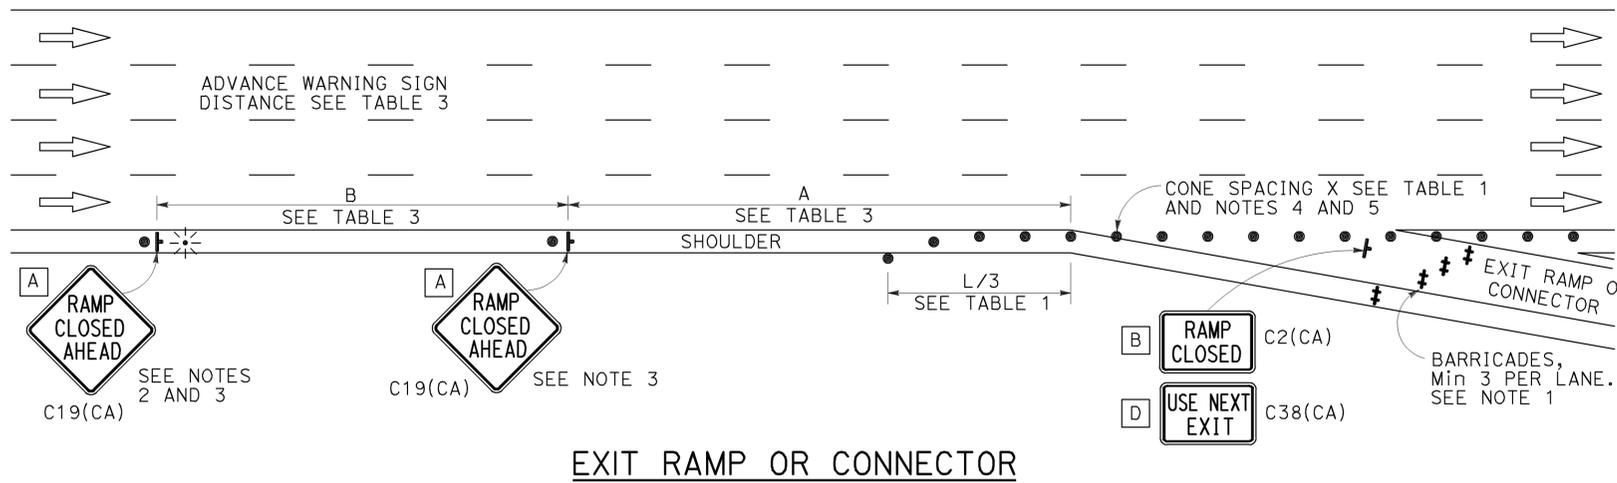


EXIT RAMP OR CONNECTOR

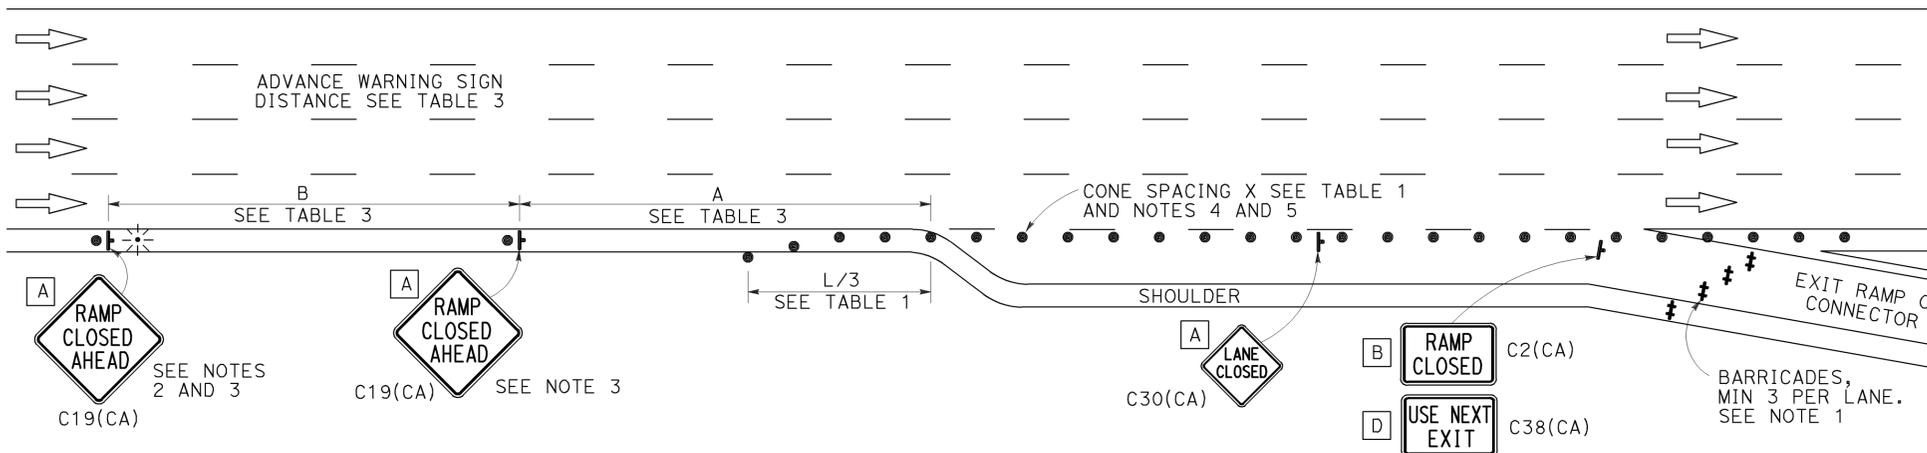

EXIT RAMP OR CONNECTOR WITH ADDITIONAL LANE

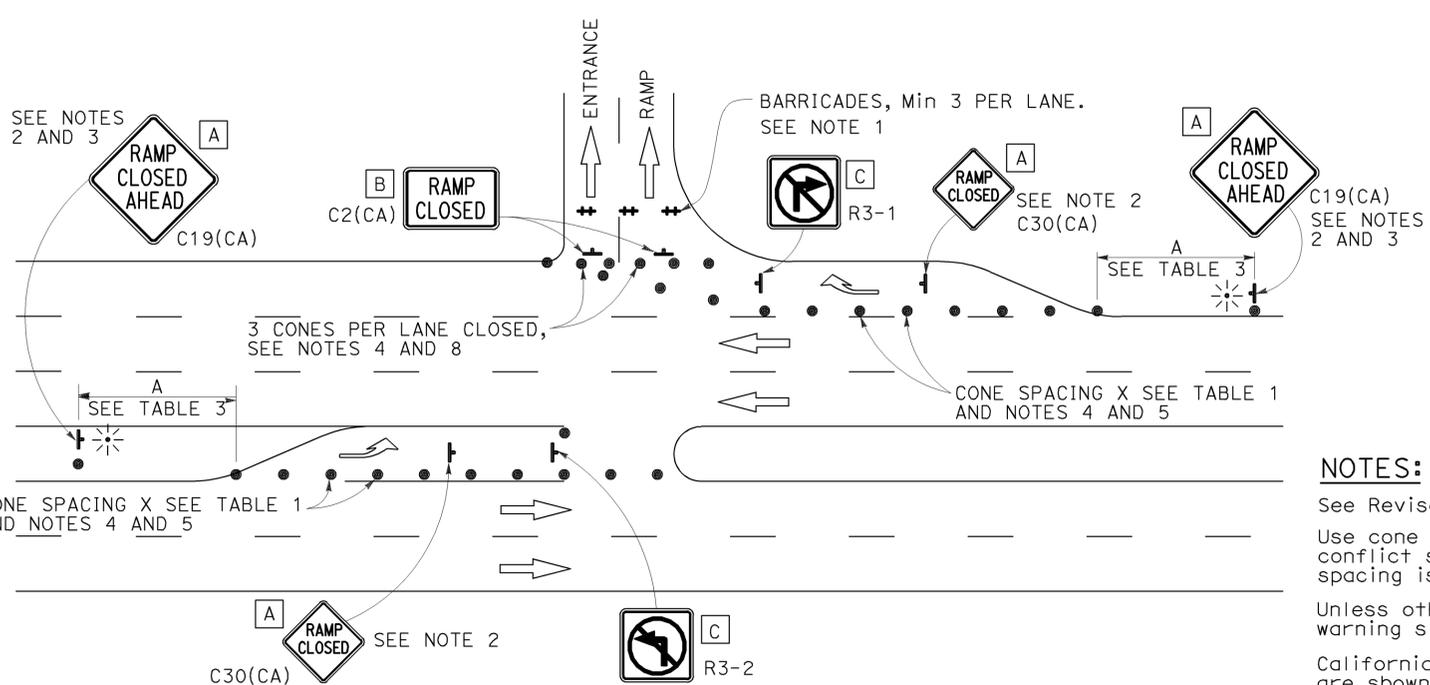

ENTRANCE RAMP WITH TURNING POCKETS

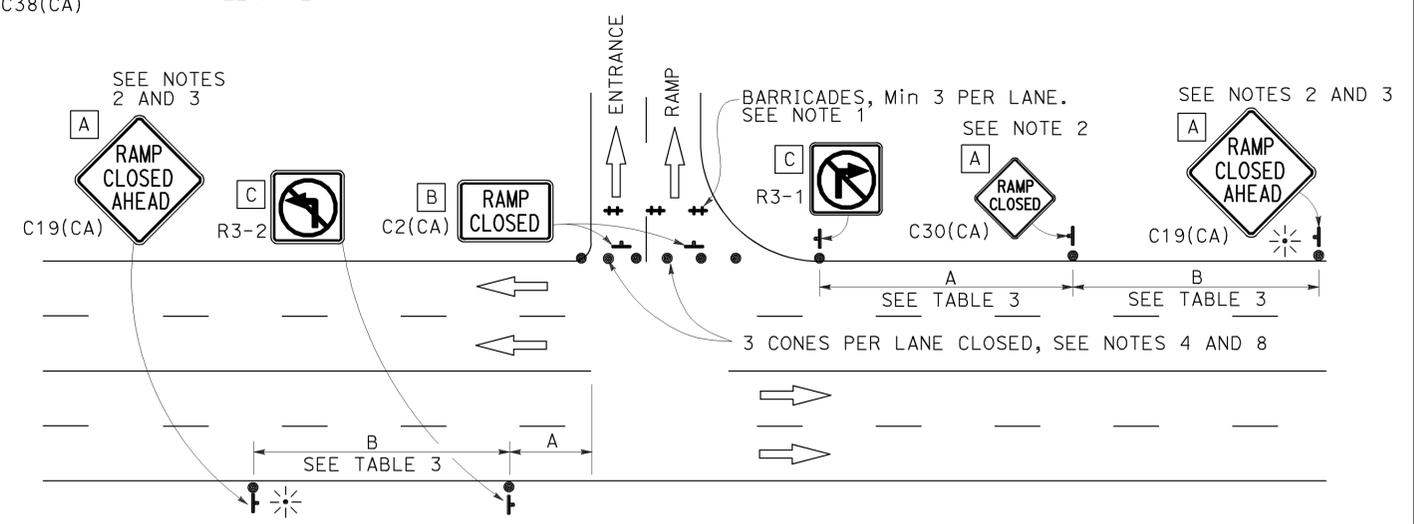

ENTRANCE RAMP WITHOUT TURNING POCKETS

NOTES:

- See Revised Standard Plan RSP T9 for tables.
- Use cone spacing X for taper segment, Y for tangent segment or Z for conflict situations, as appropriate, per Table 1, unless X, Y, or Z cone spacing is shown on this sheet.
- Unless otherwise specified in the special provisions, all temporary warning signs shall have black legend on fluorescent orange background.
- California codes are designated by (CA). Otherwise, Federal (MUTCD) codes are shown.

STATE OF CALIFORNIA
 DEPARTMENT OF TRANSPORTATION
**TRAFFIC CONTROL SYSTEM
 FOR RAMP CLOSURE**
 NO SCALE

RSP T14 DATED APRIL 19, 2013 SUPERSEDES STANDARD PLAN T14
 DATED MAY 20, 2011 - PAGE 242 OF THE STANDARD PLANS BOOK DATED 2010.

REVISED STANDARD PLAN RSP T14

2010 REVISED STANDARD PLAN RSP T14

LEGEND:

AB	ABANDON. IF APPLIED TO CONDUIT, REMOVE CONDUCTORS
BC	INSTALL PULL BOX IN EXISTING CONDUIT RUN
BP	PEDESTRIAN BARRICADE, TYPE AS INDICATED ON PLAN
CB	INSTALL CONDUIT INTO EXISTING PULL BOX
CC	CONNECT NEW AND EXISTING CONDUIT. REMOVE EXISTING CONDUCTORS AND INSTALL CONDUCTORS AS INDICATED
CF	CONDUIT TO REMAIN FOR FUTURE USE. REMOVE CONDUCTORS. INSTALL PULL TAPE
DH	DETECTOR HANDHOLE
FA	FOUNDATION TO BE ABANDONED
IS	INSTALL SIGN ON SIGNAL MAST ARM
NS	NO SLIP BASE ON STANDARD
PEC	PHOTOELECTRIC CONTROL
PEU	PHOTOELECTRIC UNIT
RC	EQUIPMENT OR MATERIAL TO BE REMOVED AND BECOME THE PROPERTY OF THE CONTRACTOR
RE	REMOVE ELECTROLIER, FUSES AND BALLAST. TAPE ENDS OF CONDUCTORS
RL	RELOCATE EQUIPMENT
RR	REMOVE AND REUSE EQUIPMENT
RS	REMOVE AND SALVAGE EQUIPMENT
SC	SPLICE NEW TO EXISTING CONDUCTORS
SD	SERVICE DISCONNECT
TSP	TELEPHONE SERVICE POINT

ABBREVIATIONS

APS	ACCESSIBLE PEDESTRIAN SIGNAL	M/M	MULTIPLE TO MULTIPLE TRANSFORMER
BBS	BATTERY BACKUP SYSTEM	Mtg	MOUNTING
BC	BOLT CIRCLE	MV	MERCURY VAPOR LIGHTING FIXTURE
BPB	BICYCLE PUSH BUTTON	MVDS	MICROWAVE VEHICLE DETECTION SYSTEM
C	CONDUIT	N	NEUTRAL (GROUNDED CONDUCTOR)
CB	CIRCUIT BREAKER	NB	NEUTRAL BUS
CCTV	CLOSED CIRCUIT TELEVISION	NC	NORMALLY CLOSE
Ck+	CIRCUIT	NO	NORMALLY OPEN
CMS	CHANGEABLE MESSAGE SIGN	P	CIRCUIT BREAKER'S POLE
Ctid	CALTRANS IDENTIFICATION	PB	PULL BOX
Comm	COMMUNICATION	PBA	PUSH BUTTON ASSEMBLY
DLC	LOOP DETECTOR LEAD-IN CABLE	PEC	PHOTOELECTRIC CONTROL
EMS	EXTINGUISHABLE MESSAGE SIGN	Ped	PEDESTRIAN
EVUC	EMERGENCY VEHICLE UNIT CABLE	PEU	PHOTOELECTRIC UNIT
EVUD	EMERGENCY VEHICLE UNIT DETECTOR	PT	CONDUIT WITH PULL TAPE
FB	FLASHING BEACON	RE	RELOCATED EQUIPMENT
FBCA	FLASHING BEACON CONTROL ASSEMBLY	RM	RAMP METERING
FBS	FLASHING BEACON WITH SLIP BASE	RWIS	ROADSIDE WEATHER INFORMATION SYSTEM
FO	FIBER OPTIC	SB	SLIP BASE
G	EQUIPMENT GROUNDING CONDUCTOR	SIC	SIGNAL INTERCONNECT CABLE
GB	GROUND BUS	Sig	SIGNAL
GFCI	GROUND FAULT CIRCUIT INTERRUPTER	SMA	SIGNAL MAST ARM
HAR	HIGHWAY ADVISORY RADIO	SNS	STREET NAME SIGN
Hex	HEXAGONAL	SP	SERVICE POINT
HPS	HIGH PRESSURE SODIUM	TDC	TELEPHONE DEMARCATION CABINET
IISNS	INTERNALLY ILLUMINATED STREET NAME SIGN	TMS	TRAFFIC MONITORING STATION
ISL	INDUCTION SIGN LIGHTING	TOS	TRAFFIC OPERATIONS SYSTEM
LED	LIGHT EMITTING DIODE	Veh	VEHICLE
LMA	LUMINAIRE MAST ARM	VIVDS	VIDEO IMAGE VEHICLE DETECTION SYSTEM
LPS	LOW PRESSURE SODIUM	WIM	WEIGH-IN-MOTION
Ltg	LIGHTING	Xfmr	TRANSFORMER
Lum	LUMINAIRE		
M	METERED		
MAT	MAST ARM MOUNTING TOP ATTACHMENT		
MAS	MAST ARM MOUNTING SIDE ATTACHMENT		

Dist	COUNTY	ROUTE	POST MILES TOTAL PROJECT	SHEET No.	TOTAL SHEETS
03	But	99	R34.2,R36.3	18	24

Theresa Gabriel
REGISTERED ELECTRICAL ENGINEER

July 19, 2013
PLANS APPROVAL DATE

Theresa
Aziz Gabriel
No. E15129
Exp. 6-30-14
ELECTRICAL
STATE OF CALIFORNIA

THE STATE OF CALIFORNIA OR ITS OFFICERS OR AGENTS SHALL NOT BE RESPONSIBLE FOR THE ACCURACY OR COMPLETENESS OF SCANNED COPIES OF THIS PLAN SHEET.

TO ACCOMPANY PLANS DATED 2-2-15

SOFFIT AND WALL MOUNTED LUMINAIRES

- PENDANT, 70 W HPS UNLESS OTHERWISE SPECIFIED
- FLUSH, 70 W HPS UNLESS OTHERWISE SPECIFIED
- WALL SURFACE, 70 W HPS UNLESS OTHERWISE SPECIFIED
- EXISTING SOFFIT OR WALL LUMINAIRE TO REMAIN UNMODIFIED
- EXISTING SOFFIT OR WALL LUMINAIRE TO BE MODIFIED AS SPECIFIED

NOTE:
Arrow indicates "street side" of luminaire.

COMMONLY USED SYMBOLS FOR UNITED STATES CUSTOMARY UNITS OF MEASUREMENT:

SYMBOL USED	DEFINITIONS
Ω	OHMS
min	MINUTE
s	SECOND
bps	BITS PER SECOND
Bps	BYTES PER SECOND
A	AMPERE
V	VOLT
V(dc)	VOLT (DIRECT CURRENT)
V(ac)	VOLT (ALTERNATING CURRENT)
FC	FOOT - CANDLE
W	WATTS
VA	VOLT-AMPERE
M	MEGA
k	KILO
m	MILLI
μ	MICRO
P	PICO
HZ	HERTZ

MISCELLANEOUS ELECTROLIERS

NEW	EXISTING	
		LUMINAIRE ON WOOD POLE
		NON-STANDARD ELECTROLIER (SEE PROJECT NOTES OR PROJECT PLANS)
		CITY ELECTROLIER
		ELECTROLIER FOUNDATION (FUTURE INSTALLATION)

NOTES:

- HPS luminaires shall be 310 W HPS when installed on Type 21, 21D, 30, 31 and 32 Standards, unless otherwise specified. HPS luminaires shall be 200 W when installed on other type standards or poles, unless otherwise specified.
- LED luminaires shall be 235 W when installed on Type 21, 21D, 30, 31 and 32 Standards, unless otherwise specified. LED luminaires shall be 165 W when installed on other type standards or poles, unless otherwise specified.
- Luminaires shall be the cutoff type, ANSI Type III medium cutoff lighting distribution, unless otherwise specified.

STANDARD ELECTROLIER

NEW	EXISTING	STANDARD TYPE
		15
		15D
		15 STRUCTURE
		15D STRUCTURE
		21
		21D
		21 STRUCTURE
		21D STRUCTURE
		30
		31
		32

STATE OF CALIFORNIA
DEPARTMENT OF TRANSPORTATION

ELECTRICAL SYSTEMS (LEGEND AND ABBREVIATIONS)

NO SCALE

RSP ES-1A DATED JULY 19, 2013 SUPERSEDES STANDARD PLAN ES-1A DATED MAY 20, 2011 - PAGE 425 OF THE STANDARD PLANS BOOK DATED 2010.

REVISED STANDARD PLAN RSP ES-1A

2010 REVISED STANDARD PLAN RSP ES-1A

Dist	COUNTY	ROUTE	POST MILES TOTAL PROJECT	SHEET No.	TOTAL SHEETS
03	But	99	R34.2,R36.3	19	24

Theresa Gabriel
 REGISTERED ELECTRICAL ENGINEER
 July 19, 2013
 PLANS APPROVAL DATE
THE STATE OF CALIFORNIA OR ITS OFFICERS OR AGENTS SHALL NOT BE RESPONSIBLE FOR THE ACCURACY OR COMPLETENESS OF SCANNED COPIES OF THIS PLAN SHEET.

TO ACCOMPANY PLANS DATED 2-2-15

CONDUIT

SIGNAL EQUIPMENT

NEW	EXISTING	
---	---	LIGHTING CONDUIT, UNLESS OTHERWISE INDICATED OR NOTED
---	---	TRAFFIC SIGNAL CONDUIT
---C---	---c---	COMMUNICATION CONDUIT
---T---	---t---	TELEPHONE CONDUIT
---F---	---f---	FIRE ALARM CONDUIT
---FO---	---fo---	FIBER OPTIC CONDUIT
---	---	CONDUIT TERMINATION
		CONDUIT RISER ATTACHED TO THE STRUCTURE OR SERVICE POLE

NEW	EXISTING	
		PEDESTRIAN SIGNAL HEAD "C" INDICATES COUNTDOWN PEDESTRIAN HEAD
		PUSH BUTTON ASSEMBLY POST
		PEDESTRIAN BARRICADE
		VEHICLE SIGNAL HEAD (WITH BACKPLATE AND 3-SECTIONS: RED, YELLOW AND GREEN)
		VEHICLE SIGNAL HEAD WITH ANGLE VISOR
		MODIFICATIONS OF BASIC SYMBOL: "L" INDICATES ALL NON-ARROW SECTIONS LOUVERED "LG" INDICATES LOUVERED GREEN SECTION ONLY "PV" INDICATES ALL 12" SECTIONS PROGRAMMED VISIBILITY "8" INDICATES ALL 8" SECTIONS (ONLY WHEN SPECIFIED)

SIGNAL EQUIPMENT Cont

NEW	EXISTING	
		GUARD POST
		TYPE 1 STANDARD WITH RAMP METERING SIGN
		OPTICAL DETECTOR FOR THE EMERGENCY VEHICLE DETECTION SYSTEM

SERVICE EQUIPMENT

NEW	EXISTING	
---OH---	---oh---	OVERHEAD LINES
		WOOD POLE, "U" INDICATES UTILITY OWNED
		POLE GUY WITH ANCHOR
		UTILITY TRANSFORMER - GROUND MOUNTED
		SERVICE EQUIPMENT ENCLOSURE TYPE. DOOR INDICATES FRONT OF ENCLOSURE
		TELEPHONE DEMARCATION CABINET

NEW	EXISTING	
		VEHICLE SIGNAL HEAD CONSISTING OF RED, YELLOW AND GREEN LEFT ARROW SECTIONS
		VEHICLE SIGNAL HEAD CONSISTING OF RED AND YELLOW SECTIONS WITH AN UP GREEN ARROW SECTION
		VEHICLE SIGNAL HEAD (5 SECTION) CONSISTING OF RED, YELLOW AND GREEN SECTIONS WITH YELLOW AND GREEN RIGHT ARROW SECTIONS
		TYPE 15TS STANDARD WITH VEHICLE SIGNAL HEAD AND LUMINAIRE
		TYPE 21TS STANDARD WITH VEHICLE SIGNAL HEAD AND LUMINAIRE
		STANDARD WITH LUMINAIRE AND SIGNAL MAST ARMS AND ATTACHED VEHICLE SIGNAL HEADS
		TYPE 1 STANDARD WITH ATTACHED VEHICLE SIGNAL HEADS
		STANDARD WITH A SIGNAL MAST ARM, ATTACHED VEHICLE SIGNAL HEADS AND INTERNALLY ILLUMINATED STREET NAME SIGN
		CONTROLLER ASSEMBLY. DOOR INDICATES FRONT OF CABINET

NOTES:

- All signal sections shall be 12" unless shown otherwise.
- Signal heads shall be provided with backplates unless shown otherwise.

POLE-MOUNTED SERVICE DESIGNATION

	TYPE H SERVICE, 28'-10"	TYPE OF INSTALLATION AND POLE HEIGHT ABOVE GRADE
--	-------------------------	--

FLASHING BEACON

NEW	EXISTING	
		FLASHING BEACON (ONE VEHICLE SIGNAL HEAD WITH BACKPLATE AND VISOR) "R" INDICATES RED INDICATION, "Y" INDICATES YELLOW INDICATION
		FLASHING BEACON WITH TYPE 15-FBS STANDARD AND A SIGN.
		FLASHING BEACON WITH TYPES 9, 9A OR 9B SIGN UNLESS OTHERWISE SPECIFIED OR INDICATED

ILLUMINATED OVERHEAD SIGN

NEW	EXISTING	
		SINGLE POST, SINGLE ILLUMINATED SIGN, BALANCED BUTTERFLY
		SINGLE POST, DOUBLE ILLUMINATED SIGN, BALANCED BUTTERFLY
		SINGLE POST, SINGLE ILLUMINATED SIGN, FULL CANTILEVER
		DOUBLE POST, SINGLE ILLUMINATED SIGN
		SINGLE ILLUMINATED SIGN MOUNTED ON STRUCTURE
		DOUBLE POST, SINGLE ILLUMINATED SIGN WITH ELECTROLIER


STATE OF CALIFORNIA
DEPARTMENT OF TRANSPORTATION
**ELECTRICAL SYSTEMS
(LEGEND AND ABBREVIATIONS)**

NO SCALE
RSP ES-1B DATED JULY 19, 2013 SUPERSEDES STANDARD PLAN ES-1B DATED MAY 20, 2011 - PAGE 426 OF THE STANDARD PLANS BOOK DATED 2010.


2010 REVISED STANDARD PLAN RSP ES-1B

EQUIPMENT IDENTIFICATION


ILLUMINATED SIGN IDENTIFICATION NUMBER:

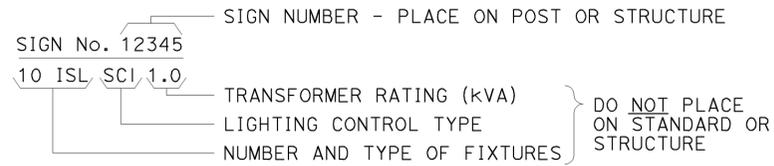


ELECTROLIER OR EQUIPMENT IDENTIFICATION NUMBER:

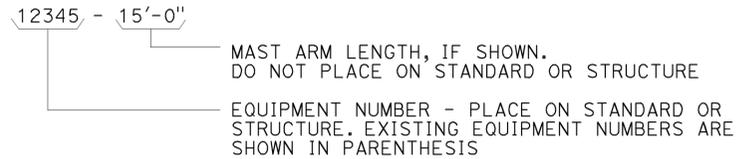


CONDUIT AND CONDUCTOR IDENTIFICATION:

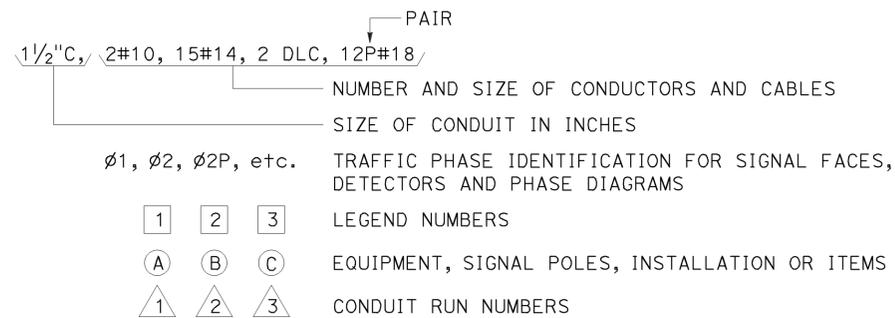


SIGNAL AND LIGHTING STANDARD (TYPICAL DESIGNATION):

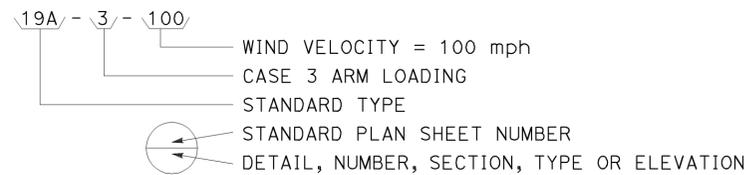


MISCELLANEOUS EQUIPMENT

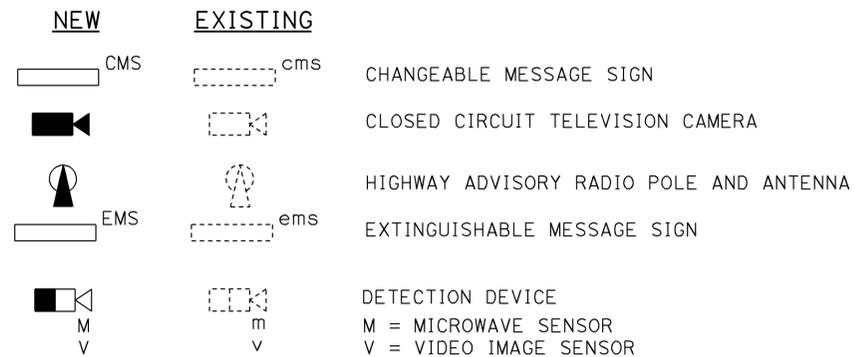



WIRING DIAGRAM LEGEND

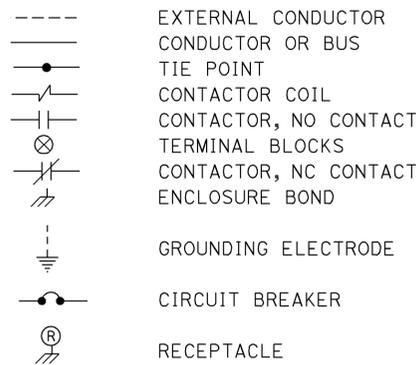

PULL BOXES

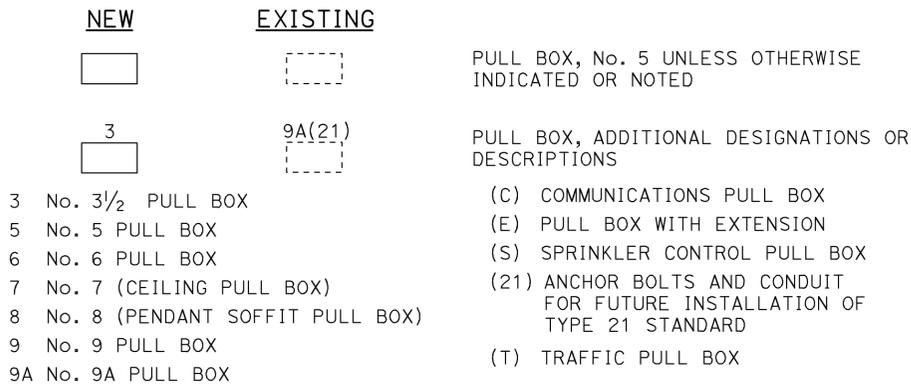

VEHICLE DETECTORS

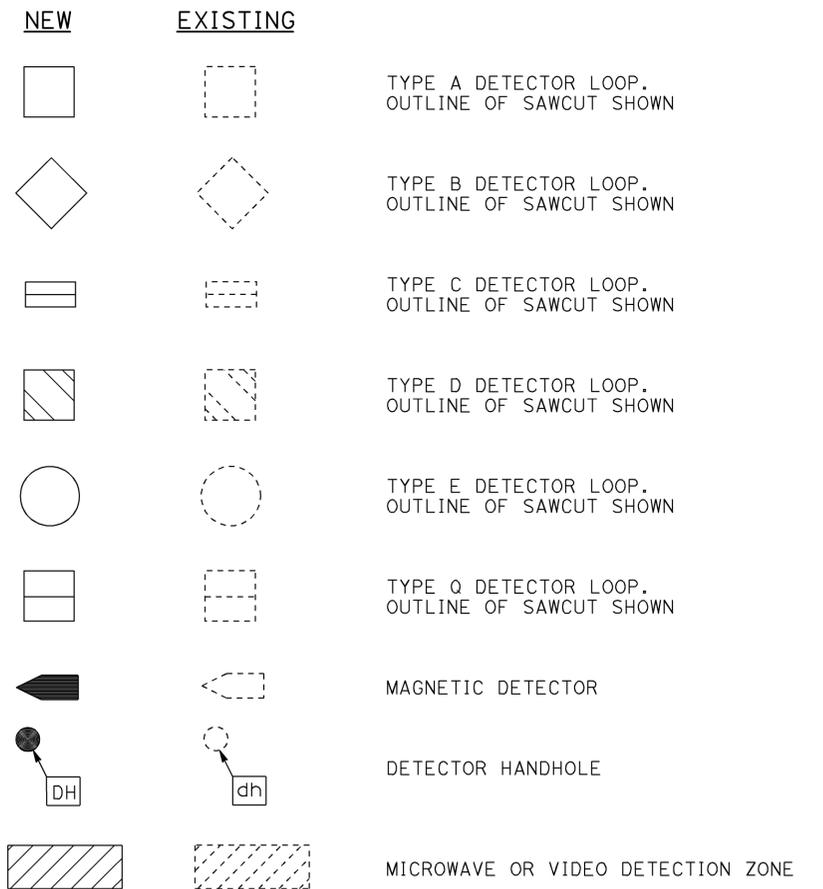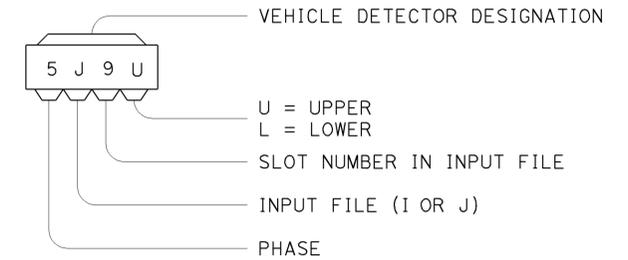

STATE OF CALIFORNIA
DEPARTMENT OF TRANSPORTATION

ELECTRICAL SYSTEMS (LEGEND AND ABBREVIATIONS)

NO SCALE

RSP ES-1C DATED JULY 19, 2013 SUPERSEDES STANDARD PLAN ES-1C DATED MAY 20, 2011 - PAGE 427 OF THE STANDARD PLANS BOOK DATED 2010.

REVISED STANDARD PLAN RSP ES-1C

2010 REVISED STANDARD PLAN RSP ES-1C

DIST	COUNTY	ROUTE	POST MILES TOTAL PROJECT	SHEET NO.	TOTAL SHEETS
03	But	99	R34.2,R36.3	21	24


Theresa Gabriel
REGISTERED ELECTRICAL ENGINEER

July 19, 2013
PLANS APPROVAL DATE


Theresa Aziz Gabriel
No. E15129
Exp. 6-30-14
ELECTRICAL
STATE OF CALIFORNIA

THE STATE OF CALIFORNIA OR ITS OFFICERS OR AGENTS SHALL NOT BE RESPONSIBLE FOR THE ACCURACY OR COMPLETENESS OF SCANNED COPIES OF THIS PLAN SHEET.


TO ACCOMPANY PLANS DATED 2-2-15

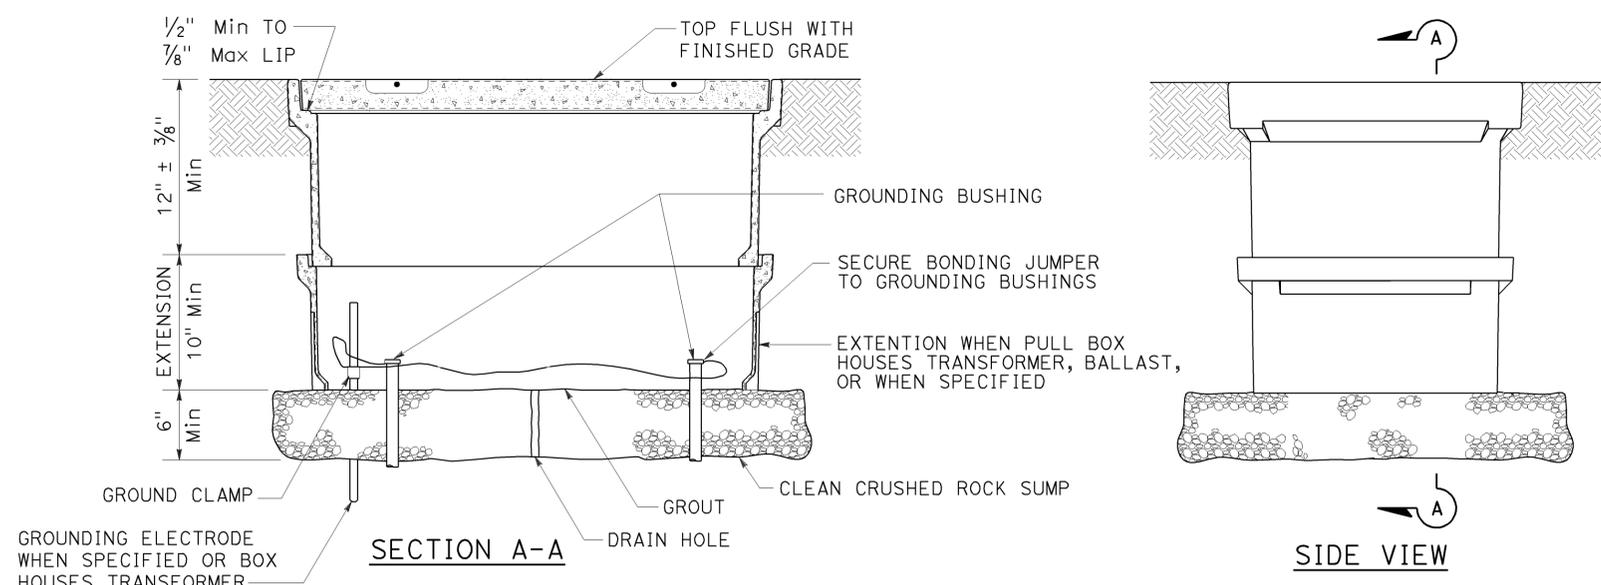


INSTALLATION DETAILS
DETAIL A

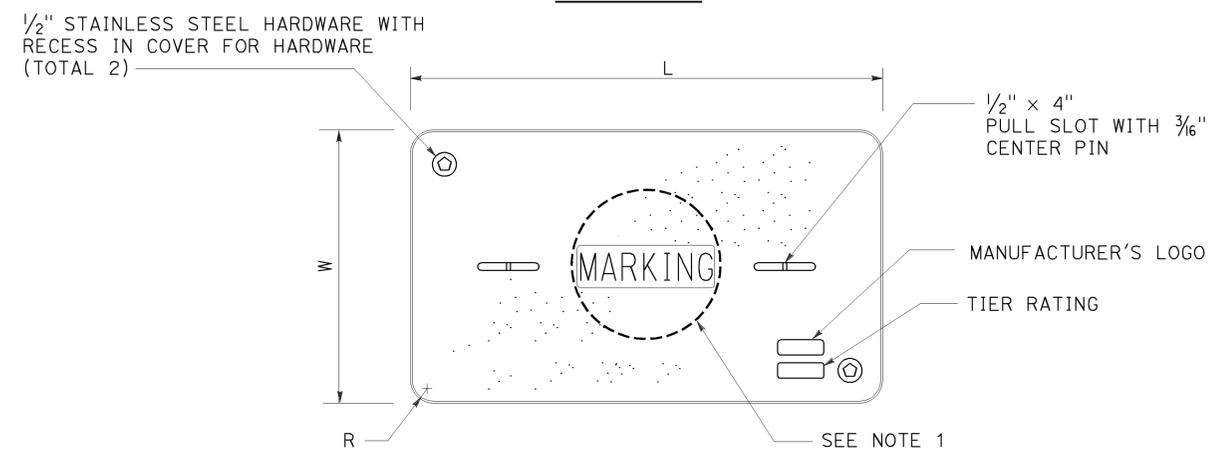

COVER TOP VIEW

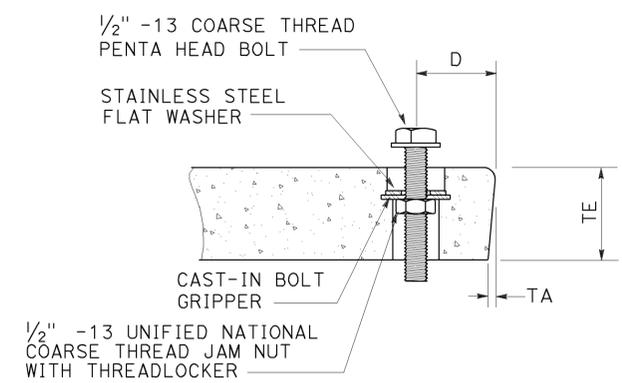

TYPICAL COVER CAPTIVE BOLT
OR SIMILAR

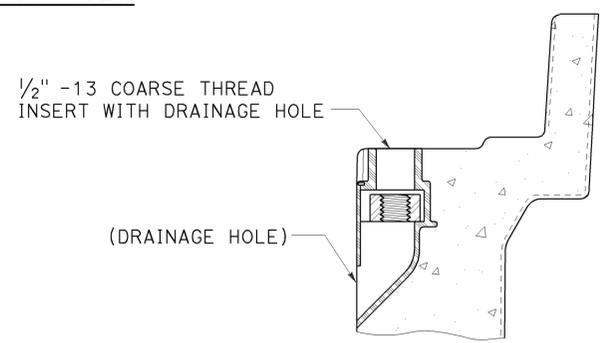

TYPICAL THREADED INSERT
OR SIMILAR

NOTES:

- Pull box covers shall be marked as follows: "SERVICE" Service circuits between service point and service disconnect; "SPRINKLER-CONTROL" sprinkler control circuits, 50 V or less; "CALTRANS" on all pull boxes, except pull boxes marked "SPRINKLER-CONTROL"; and "TELEPHONE" Telephone service;
 - No. 3 1/2 pull box.
 - "SIGNAL" - Traffic signal circuits with or without lighting or sign lighting circuits.
 - "LIGHTING" - Lighting or sign lighting circuits where voltage is under 600 V.
 - No. 5, 6, 9 or 9A pull box.
 - "TRAFFIC SIGNAL" - Traffic signal circuits with or without lighting or sign lighting circuits.
 - "LIGHTING" - Lighting or sign lighting circuits where voltage is under 600 V.
 - "LIGHTING-HIGH VOLTAGE" - Lighting or sign lighting circuits where voltage is above 600 V.
 - "IRRIGATION" - Circuits to irrigation controller 120 V or more.
 - "RAMP METER" - Ramp meter circuits.
 - "COUNT STATION" - Count or speed monitor circuits.
 - "COMMUNICATIONS" - Communication circuits.
 - "TOS COMMUNICATIONS" - TOS communication line.
 - "TOS POWER" - TOS power.
 - "TDC POWER" - Telephone demarcation cabinet power.
 - "CCTV" - Closed circuit television circuits.
 - "TMS" - Traffic monitoring station circuits.
 - "CMS" - Changeable message sign circuits.
 - "HAR" - Highway advisory radio circuits.
 - "BOOSTER PUMP" - Booster pump circuit.
- The nominal dimensions of the opening in which the cover sets shall be the same as the cover dimensions except the length and width dimensions shall be 1/8" greater.
- Covers and boxes shall be interchangeable with California standard male and female gages. When interchanged with a standard male or female gage, the top surfaces shall be flush within 1/8". Top outside radius of covers and pull boxes shall have a 1/8" radius.
- Pull box extension may be another pull box as long as the bottom edge of the pull box can fit into the cover opening.
- All dimensions for the cover for non-traffic pull box are nominal values.

DIMENSION TABLE										
PULL BOX	PULL BOX			COVER						
	MINIMUM DEPTH BOX	MINIMUM DEPTH EXTENSION	MAXIMUM WEIGHT	L	W	R	TE	TA	D	MAXIMUM WEIGHT
No. 3 1/2	12"	N/A	40 lb	1' - 3 3/8"	10 1/8"	1 3/8"	2"	1/8"	1 3/4"	30 lb
No. 5	12"	10"	55 lb	1' - 11 1/4"	1' - 1 3/4"	1 3/8"	2"	1/8"	1 3/4"	60 lb
No. 6	12"	10"	70 lb	2' - 6 1/2"	1' - 5 1/2"	1 3/8"	2"	1/8"	2"	85 lb

STATE OF CALIFORNIA
DEPARTMENT OF TRANSPORTATION
ELECTRICAL SYSTEMS
(NON-TRAFFIC PULL BOX)
NO SCALE

RSP ES-8A DATED JULY 19, 2013 SUPERSEDES RSP ES-8A DATED JANUARY 20, 2012 THAT SUPPLEMENTS THE STANDARD PLANS BOOK DATED 2010.

REVISED STANDARD PLAN RSP ES-8A

2010 REVISED STANDARD PLAN RSP ES-8A


DIST	COUNTY	ROUTE	POST MILES TOTAL PROJECT	SHEET NO.	TOTAL SHEETS
03	But	99	R34.2,R36.3	22	24

Theresa Gabriel
 REGISTERED ELECTRICAL ENGINEER
 July 19, 2013
 PLANS APPROVAL DATE

THE STATE OF CALIFORNIA OR ITS OFFICERS OR AGENTS SHALL NOT BE RESPONSIBLE FOR THE ACCURACY OR COMPLETENESS OF SCANNED COPIES OF THIS PLAN SHEET.



TO ACCOMPANY PLANS DATED 2-2-15

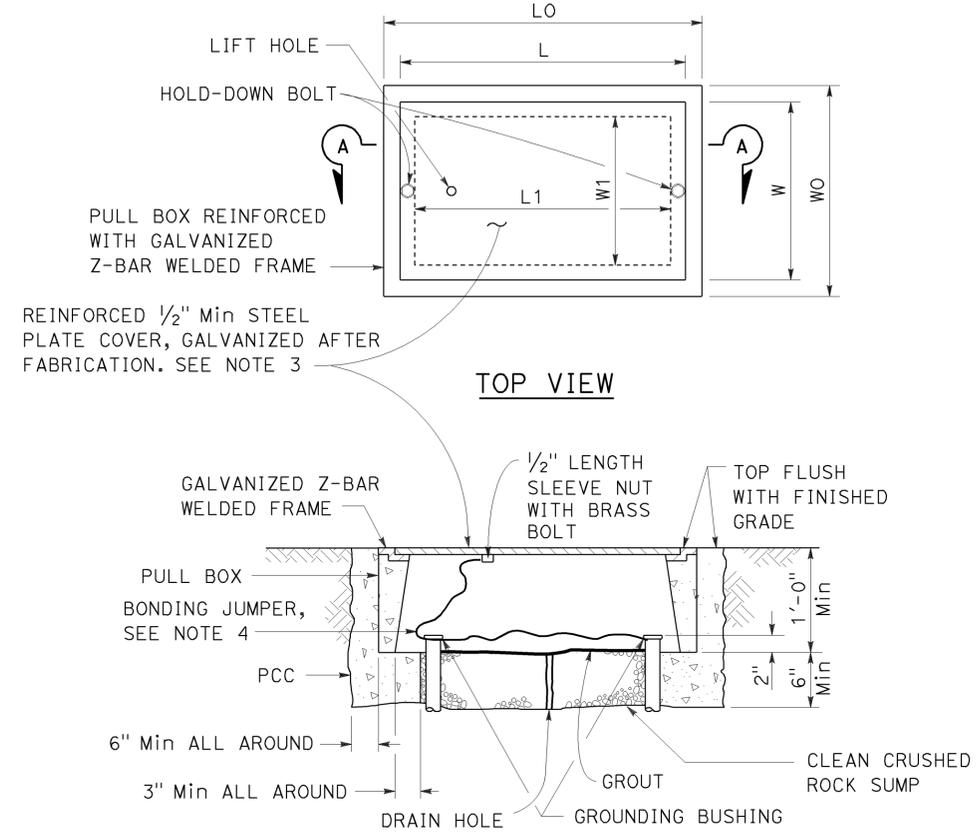

SECTION A-A
No. 3 1/2(T), No. 5(T) AND
No. 6(T) TRAFFIC PULL BOX

NOTES:

- Traffic pull box shall be provided with steel cover and special concrete footing. Steel cover shall have embossed non-skid pattern.
- Steel reinforcing shall be as regularly used in the standard products of the respective manufacturer.
- Pull box covers shall be marked as follows: "SERVICE" Service circuits between service point and service disconnect; "SPRINKLER-CONTROL" Sprinkler control circuits, 50 V or less; "CALTRANS" On all pull boxes, except pull boxes marked "SPRINKLER-CONTROL"; and "TELEPHONE" Telephone service.
 - No. 3 1/2(T) pull box.
 - "SIGNAL" - Traffic signal circuits with or without lighting or sign lighting circuits.
 - "LIGHTING" - Lighting or sign lighting circuits where voltage is under 600 V.
 - No. 5(T) or 6(T) pull box.
 - "TRAFFIC SIGNAL" - Traffic signal circuits with or without lighting or sign lighting circuits.
 - "LIGHTING" - Lighting or sign lighting circuits where voltage is under 600 V.
 - "LIGHTING-HIGH VOLTAGE" - Lighting or sign lighting circuits where voltage is above 600 V.
 - "IRRIGATION" - Circuits to irrigation controller 120 V or more.
 - "RAMP METER" - Ramp meter circuits.
 - "COUNT STATION" - Count or speed monitor circuits.
 - "COMMUNICATION" - Communication circuits.
 - "TOS COMMUNICATIONS" - TOS communications line.
 - "TOS POWER" - TOS power.
 - "TDC POWER" - Telephone demarcation cabinet power.
 - "CCTV" - Closed circuit television circuits.
 - "TMS" - Traffic monitoring station circuits.
 - "CMS" - Changeable message sign circuits.
 - "HAR" - Highway advisory radio circuits.
 - "BOOSTER PUMP" - Booster pump circuit.
- Bonding jumper for metal covers shall be 3' long, minimum.
- The nominal dimensions of the opening in which the cover sets shall be the same as the cover dimensions except the length and width dimensions shall be 1/8" greater.
- Covers and boxes shall be interchangeable with California standard male and female gages. When interchanged with a standard male or female gage, the top surfaces shall be flush within 1/8".

PULL BOX	PULL BOX						COVER				
	MINIMUM * THICKNESS	MINIMUM DEPTH BOX AND EXTENSION	W0	L0	L1	W1	L **	W **	R	EDGE THICKNESS	EDGE TAPER
No. 3 1/2(T)	1 1/2"	1'-0"	1'-5"± 1"	1'-8 3/8"±	1'-2 1/2"±	10 5/8"± 1"	1'-8"±	1'-1 3/4"±	0"	1/2"	NONE
No. 5(T)	1 3/4"	1'-0"	1'-11 1/2"± 1"	2'-5 1/2"±	1'-7"±	1'-1"± 1"	2'-3"±	1'-4"±	0"	1/2"	NONE
No. 6(T)	2"	1'-0"	2'-6"± 1"	2'-11 1/2"±	1'-11 1/2"±	1'-5"± 1"	2'-9"±	1'-8"±	0"	1/2"	NONE

* EXCLUDING CONDUIT WEB ** TOP DIMENSION

STATE OF CALIFORNIA
 DEPARTMENT OF TRANSPORTATION
ELECTRICAL SYSTEMS
(TRAFFIC PULL BOX)
 NO SCALE

RSP ES-8B DATED JULY 19, 2013 SUPERSEDES RSP ES-8B DATED JANUARY 20, 2012 THAT SUPPLEMENTS THE STANDARD PLANS BOOK DATED 2010.

REVISED STANDARD PLAN RSP ES-8B

2010 REVISED STANDARD PLAN RSP ES-8B

Dist	COUNTY	ROUTE	POST MILES TOTAL PROJECT	SHEET No.	TOTAL SHEETS
03	But	99	R34.2,R36.3	23	24


Theresa Gabriel
 REGISTERED ELECTRICAL ENGINEER
 No. E15129
 Exp. 6-30-14
 ELECTRICAL
 STATE OF CALIFORNIA

July 19, 2013
 PLANS APPROVAL DATE

THE STATE OF CALIFORNIA OR ITS OFFICERS OR AGENTS SHALL NOT BE RESPONSIBLE FOR THE ACCURACY OR COMPLETENESS OF SCANNED COPIES OF THIS PLAN SHEET.


TO ACCOMPANY PLANS DATED 2-2-15

ISOFOOTCANDLE CURVE - MINIMUM

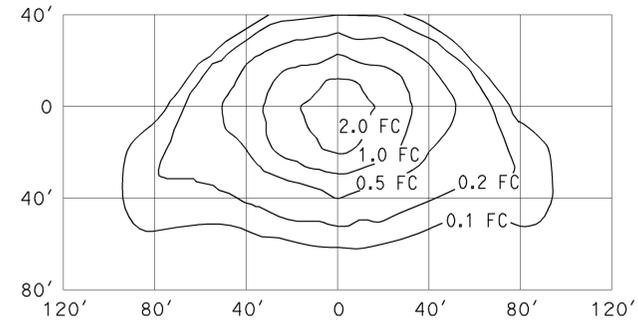


TYPE III MEDIUM CUTOFF
 Cutoff Luminaire
 34' Mounting Height
 Lamp operated at 22,000 lm
 200-W high pressure sodium lamp
 ANSI Designation S66

ISOFOOTCANDLE CURVE - MINIMUM

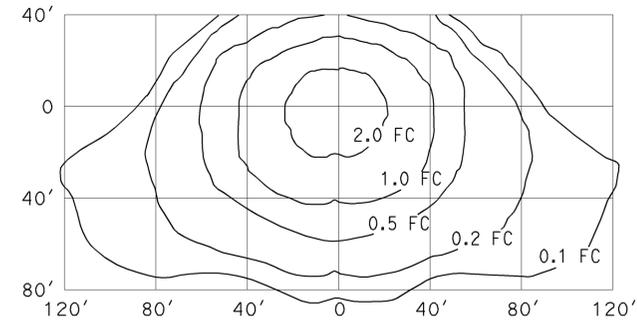


TYPE III MEDIUM CUTOFF
 Cutoff Luminaire
 40' Mounting Height
 Lamp operated at 37,000 lm
 310-W high pressure sodium lamp
 ANSI Designation S67

ISOFOOTCANDLE CURVE - MINIMUM

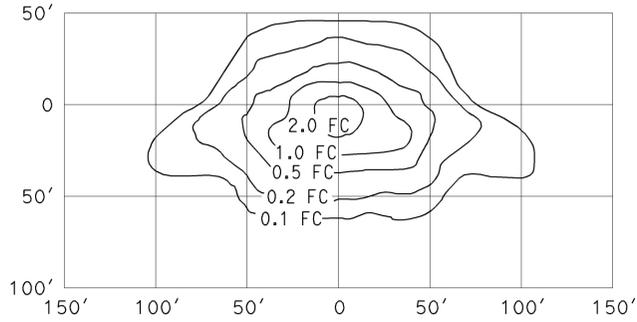


TYPE III MEDIUM CUTOFF
 Cutoff Luminaire
 30' Mounting Height
 Lamp operated at 16,000 lm
 150-W high pressure sodium lamp
 ANSI Designation S55

ISOFOOTCANDLE CURVE - MINIMUM

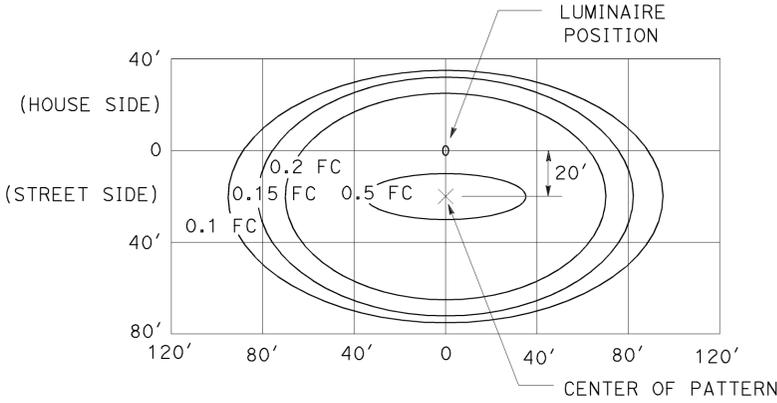


LED LUMINAIRE ROADWAY 1
 165-W at 34' Mounting Height

ISOFOOTCANDLE CURVE - MINIMUM

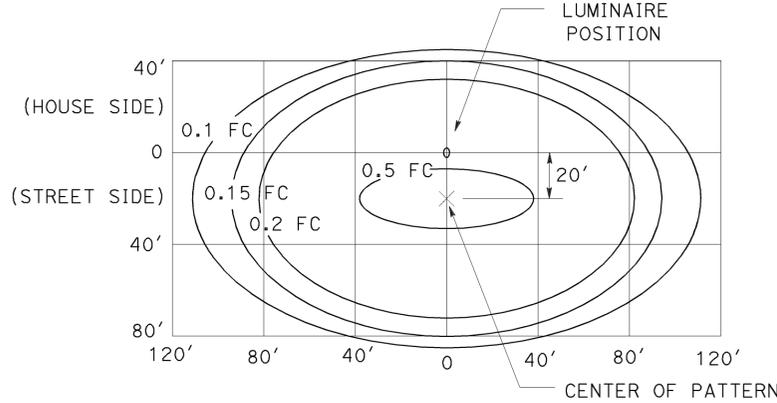


LED LUMINAIRE ROADWAY 2
 235-W at 40' Mounting Height

ISOFOOTCANDLE CURVE - MINIMUM

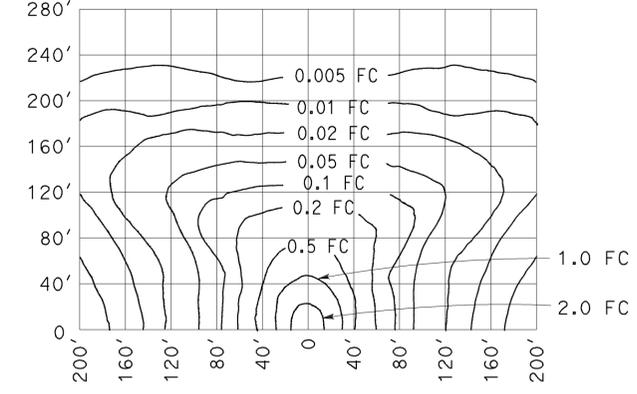


LOW PRESSURE SODIUM LUMINAIRE
 40' Mounting Height
 Lamp operated at 33,000 lm
 180-W low pressure sodium lamp

ISOFOOTCANDLE CURVE - MINIMUM

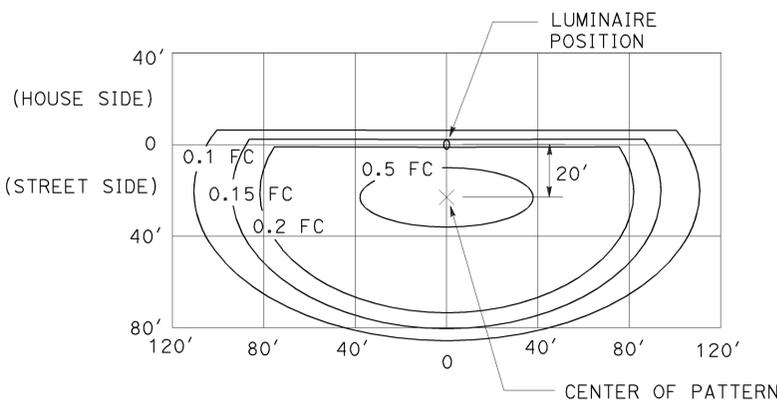

LED LUMINAIRE ROADWAY 3
 235-W at 40' Mounting Height
 with back side control

ISOFOOTCANDLE CURVE - MINIMUM


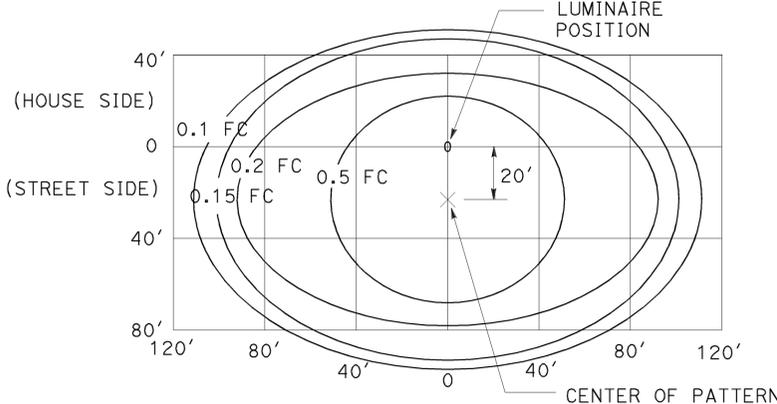


LED LUMINAIRE ROADWAY 4
 300-W at 40' Mounting Height


STATE OF CALIFORNIA
 DEPARTMENT OF TRANSPORTATION
**ELECTRICAL SYSTEMS
 (ISOFOOTCANDLE DIAGRAMS)**

NO SCALE
 RSP ES-10A DATED JULY 19, 2013 SUPERSEDES RSP ES-10A DATED JULY 20, 2012
 THAT SUPPLEMENTS THE STANDARD PLANS BOOK DATED 2010.


2010 REVISED STANDARD PLAN RSP ES-10A

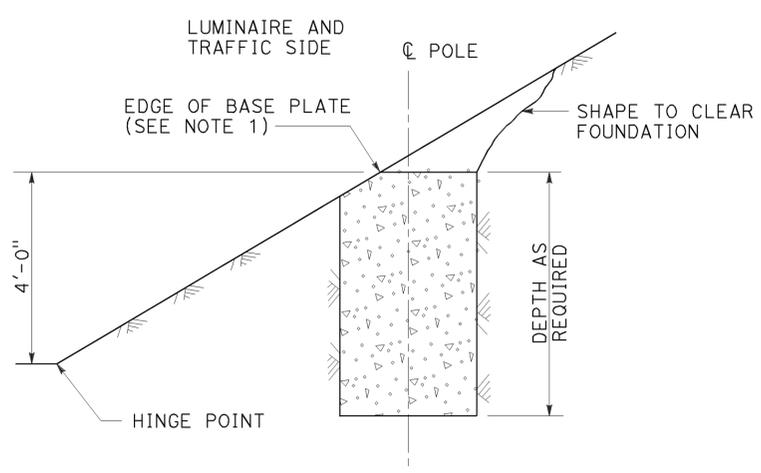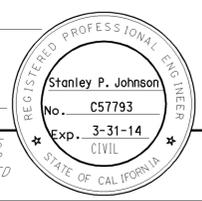

CUT SLOPES
STEEPER THAN 4:1,
LESS THAN 2:1
DETAIL A-1
 See Note 2 and 3

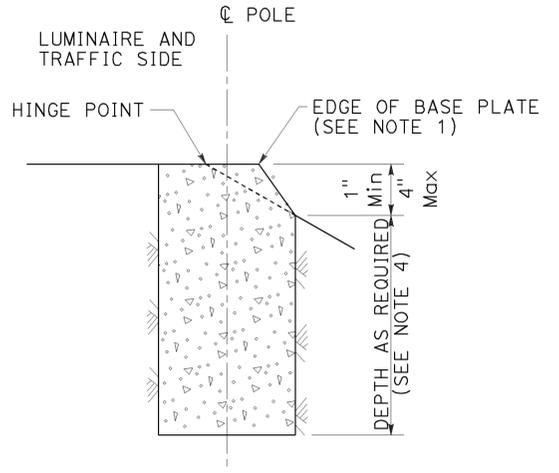

FILL SLOPES
STEEPER THAN 4:1,
LESS THAN 2:1
DETAIL A-2
 See Note 2 and 3

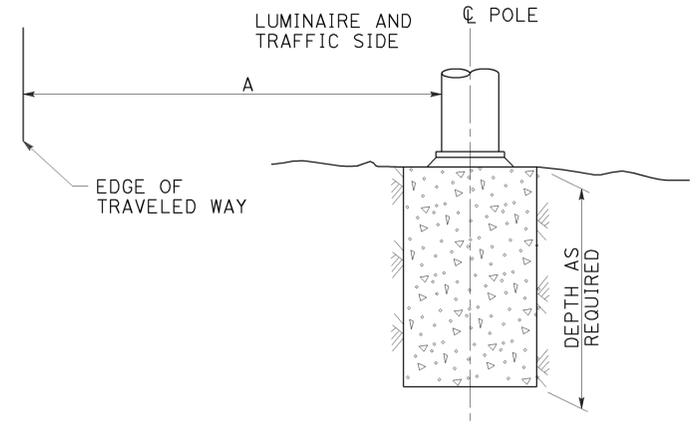

FLAT SECTIONS, CUT OR FILL SLOPES
4:1 OR FLATTER
DETAIL A-3
 See Note 2


TO ACCOMPANY PLANS DATED 2-2-15

STANDARD TYPE	SETBACK (DIMENSION A)
32	30'-0" (Min)
31	20'-0" (Min)
15, 15D, 15-SB, 21, 21D, 30	ARM LENGTH (Min)


FOUNDATIONS ADJACENT TO ALL ROADWAYS EXCEPT
IN SIDEWALK, MEDIAN AND ISLAND AREAS
DETAIL A

NOTES:

- Where a portion of the foundation is above grade, the top edges shall have a 1" chamfer.
- Slopes shall be horizontal to vertical ratio (Horizontal : Vertical).
- Horizontal setbacks on cut and fill slopes steeper than 4:1 shall not exceed the distance shown for flat sections.
- CIDH embedment depth shall be increased beyond standard depths by the diameter of the CIDH.

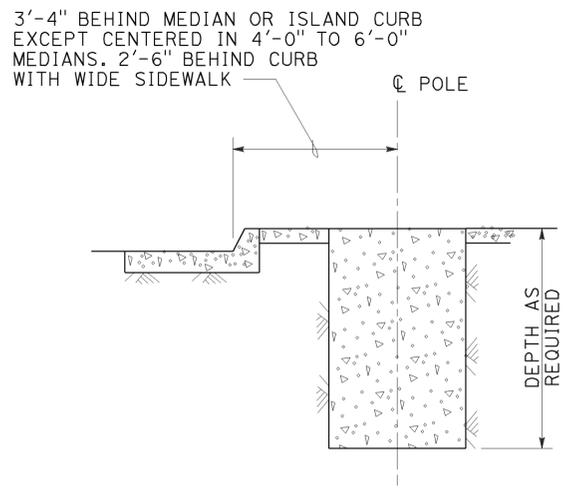

MEDIAN, ISLAND
OR WIDE SIDEWALK
DETAIL B-1
 7' Wide and wider

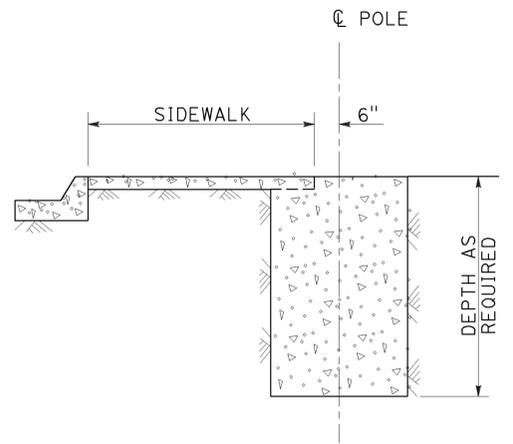

NARROW SIDEWALK
DETAIL B-2
 Less than 7' wide

FOUNDATIONS IN SIDEWALK, MEDIAN AND ISLAND AREAS
DETAIL B

STATE OF CALIFORNIA
 DEPARTMENT OF TRANSPORTATION
ELECTRICAL SYSTEMS
(FOUNDATION INSTALLATIONS)
 NO SCALE

RSP ES-11 DATED JULY 19, 2013 SUPERSEDES STANDARD PLAN ES-11
 DATED MAY 20, 2011 - PAGE 488 OF THE STANDARD PLANS BOOK DATED 2010.