

NOTES:

- Line post, blocks and hardware to be used are shown on Revised Standard Plans RSP A77L1, RSP A77L2, RSP A77M1, RSP A77N1 and RSP A77N2.
- MGS post spacing to be 6'-3" center to center, except as otherwise noted.
- Except as noted, line posts are 6" x 8" x 6'-0" wood with 6" x 12" x 1'-2" wood blocks. W6 x 8.5 or W6 x 9 steel posts, 6'-0" in length, with 6" x 12" x 1'-2" notched wood blocks or notched recycled plastic blocks may be used for 6" x 8" x 6'-0" wood line posts with 6" x 12" x 1'-2" wood blocks where applicable and when specified.
- A 4'-0" minimum clearance is required between the face of the railing and the face of a fixed object located directly behind MGS section with post spacing of 6'-3". Construct MGS as shown in the detail "Strengthened Midwest Guardrail System Sections for Fixed Object" on this plan, where the clearance between the face of the railing and the face of a fixed object is less than 4'-0", but not less than 3'-0". Where the clearance is less than 3'-0", a concrete wall or barrier should be constructed to shield the fixed object(s).

- For End Anchor Assembly (Type SFT) details, see Standard Plan RSP A77S1.
- Type of crash cushion to be used will be shown on the Project Plans.
- Type 15A layout is typically used on multilane freeways or expressways to shield fixed objects in the area between separated one-way roadbeds.
- For typical flare offsets for 25'-0" length parabola with maximum offset of 1'-0", see Revised Standard Plan RSP A77P1.
- The 15:1 or flatter flare is measured off of the edge of the traveled way.
- W6 x 15 steel post, 8'-0" in length, with 8" x 12" x 1'-2" notched wood block or notched recycled plastic blocks may be used in place of the 10" x 10" x 8'-0" wood post with 8" x 12" x 1'-2" wood block shown in the detail "Strengthened Midwest Guardrail System Sections for Fixed Object".

Dist	COUNTY	ROUTE	POST MILES TOTAL PROJECT	SHEET No.	TOTAL SHEETS
07	LA	5	13.8/19.2	201	262


Randell D. Hiatt
REGISTERED CIVIL ENGINEER

July 19, 2013
PLANS APPROVAL DATE

THE STATE OF CALIFORNIA OR ITS OFFICERS OR AGENTS SHALL NOT BE RESPONSIBLE FOR THE ACCURACY OR COMPLETENESS OF SCANNED COPIES OF THIS PLAN SHEET.


REGISTERED PROFESSIONAL ENGINEER
Randell D. Hiatt
No. C50200
Exp. 6-30-15
CIVIL
STATE OF CALIFORNIA

TO ACCOMPANY PLANS DATED 2-1-16

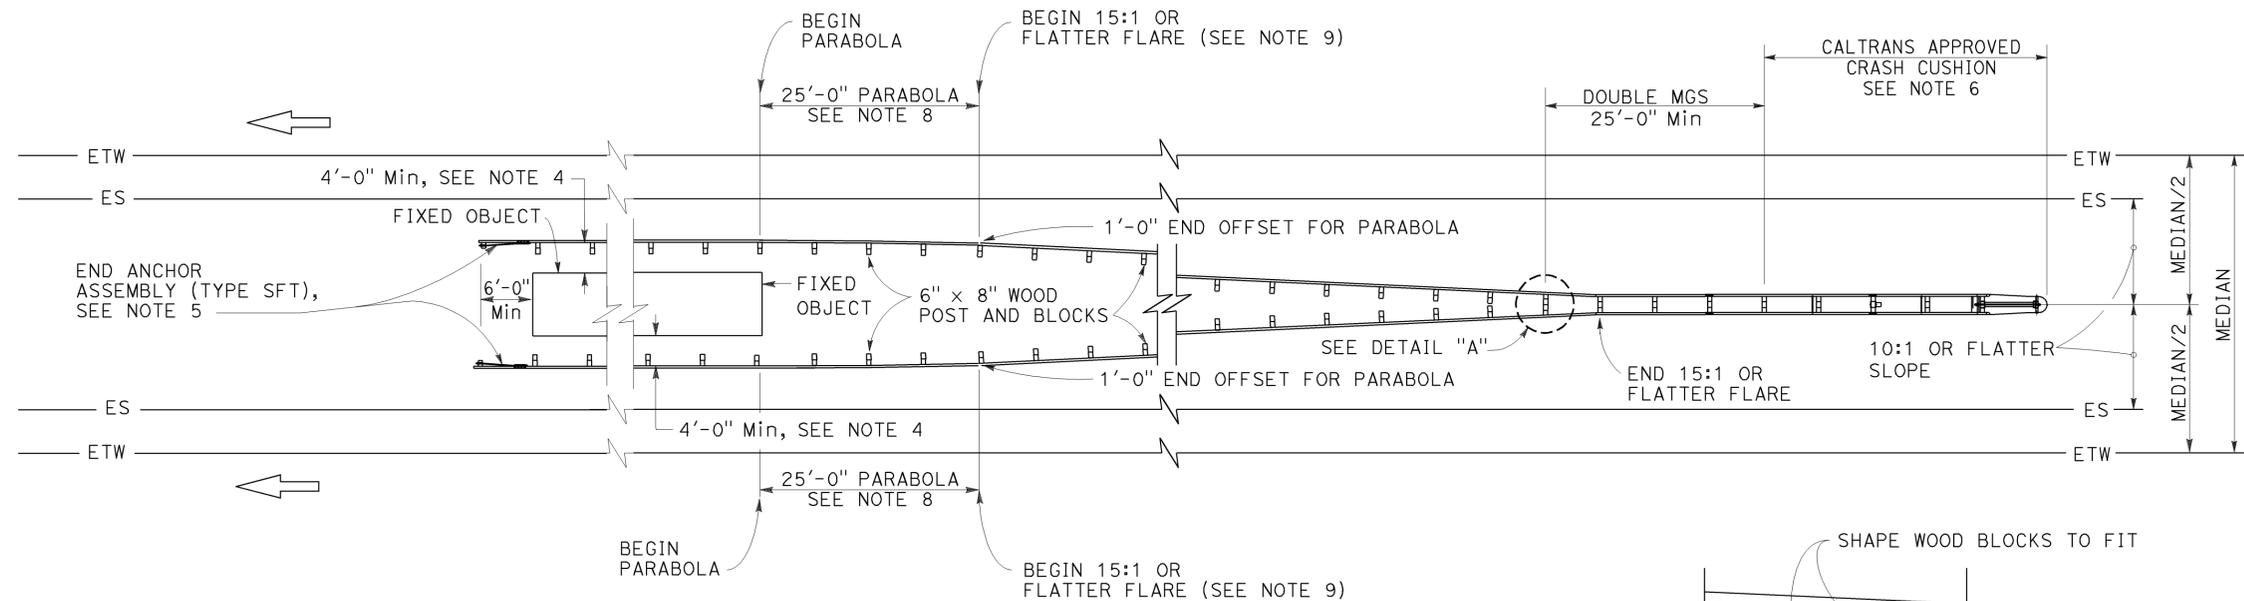

TYPE 15A LAYOUT


See Note 7

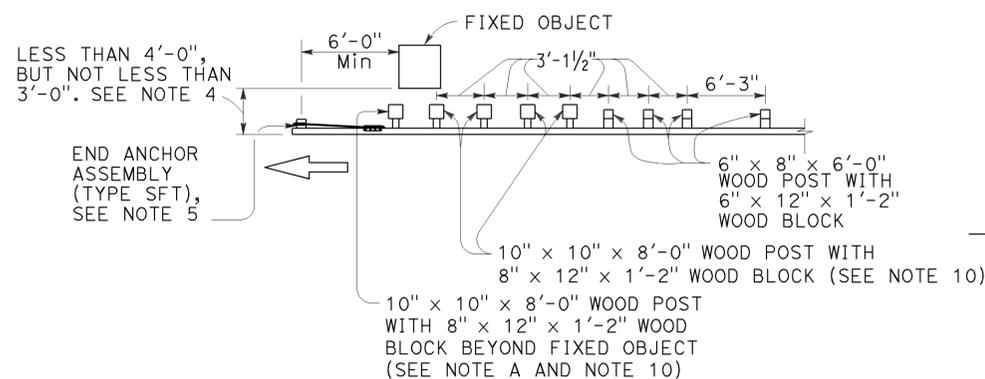

NOTE A: For a series of fixed objects (bridge columns, overhead sign supports, etc.) additional 10" x 10" x 8'-0" wood post with 8" x 12" x 1'-2" wood blocks at 3'-1/2" center to center spacing are to be used between fixed objects.

STRENGTHENED MIDWEST GUARDRAIL SYSTEM SECTIONS FOR FIXED OBJECT


Use strengthened MGS sections with Type 15A layout where minimum clearance between the face of the MGS and the fixed object(s) is less than 4'-0", but not less than 3'-0". See Note 4.

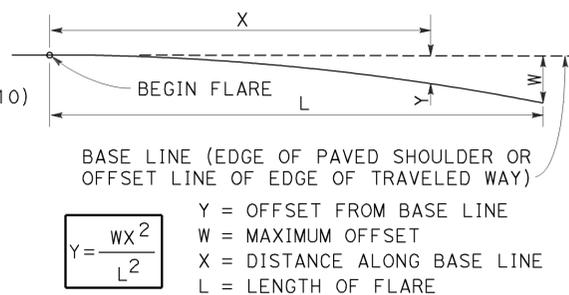


PARABOLIC FLARE OFFSETS

$$Y = \frac{WX^2}{L^2}$$

Y = OFFSET FROM BASE LINE
W = MAXIMUM OFFSET
X = DISTANCE ALONG BASE LINE
L = LENGTH OF FLARE

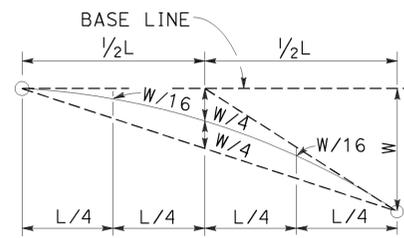

TYPICAL PARABOLIC LAYOUT

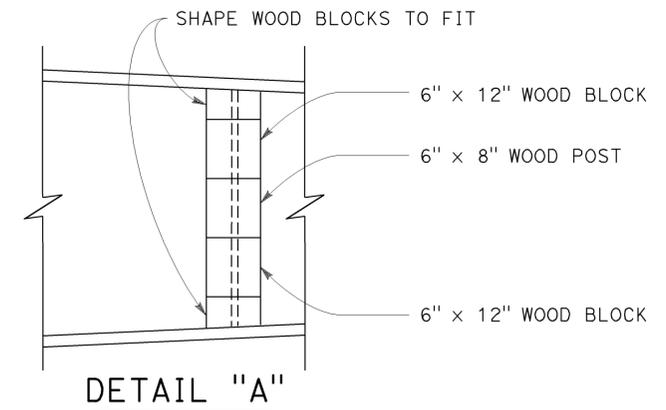

STATE OF CALIFORNIA
DEPARTMENT OF TRANSPORTATION
**MIDWEST GUARDRAIL SYSTEM
TYPICAL LAYOUTS FOR
FIXED OBJECTS
BETWEEN SEPARATE ROADBEDS
(ONE-WAY TRAFFIC)**

NO SCALE

RSP A77R2 DATED JULY 19, 2013 SUPPLEMENTS THE STANDARD PLANS BOOK DATED 2010.

REVISED STANDARD PLAN RSP A77R2

2010 REVISED STANDARD PLAN RSP A77R2


Dist	COUNTY	ROUTE	POST MILES TOTAL PROJECT	SHEET No.	TOTAL SHEETS
07	LA	5	13.8/19.2	202	262

Randell D. Hiatt
REGISTERED CIVIL ENGINEER


July 19, 2013
PLANS APPROVAL DATE

THE STATE OF CALIFORNIA OR ITS OFFICERS OR AGENTS SHALL NOT BE RESPONSIBLE FOR THE ACCURACY OR COMPLETENESS OF SCANNED COPIES OF THIS PLAN SHEET.


NO. C50200
Exp. 6-30-15
CIVIL
STATE OF CALIFORNIA

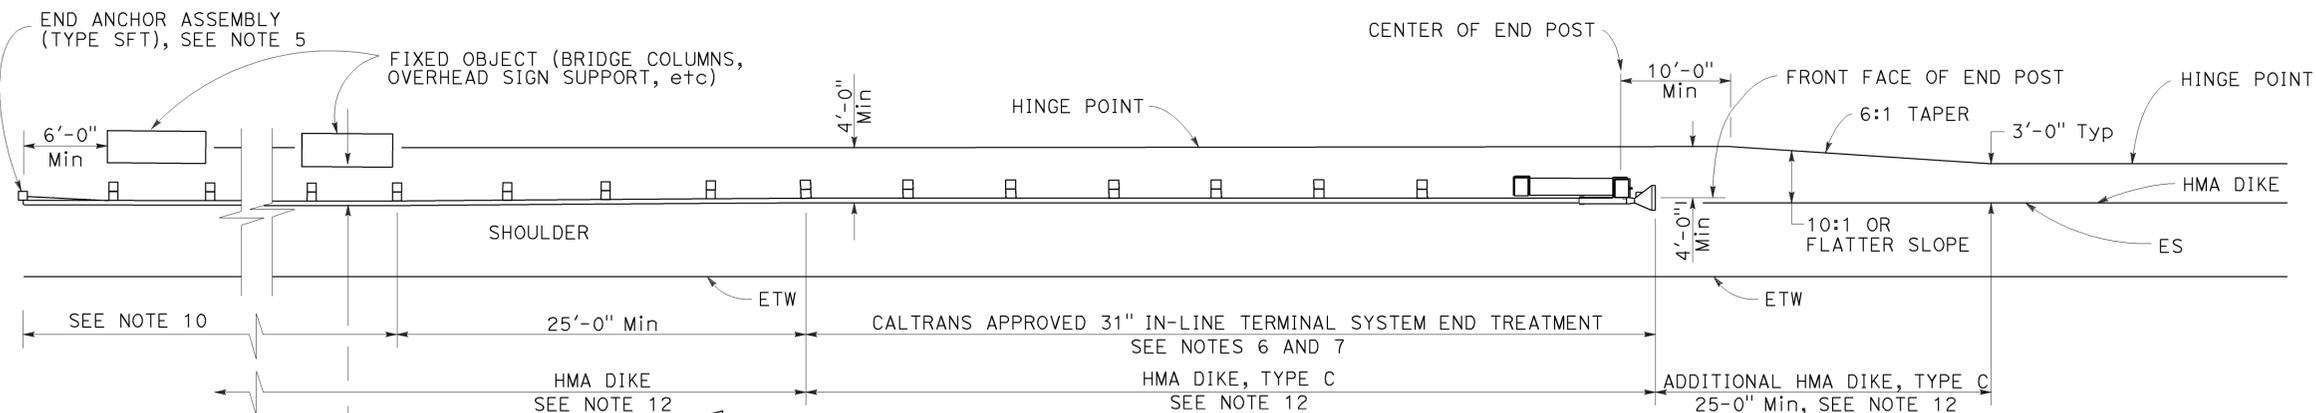


TYPE 16A LAYOUT

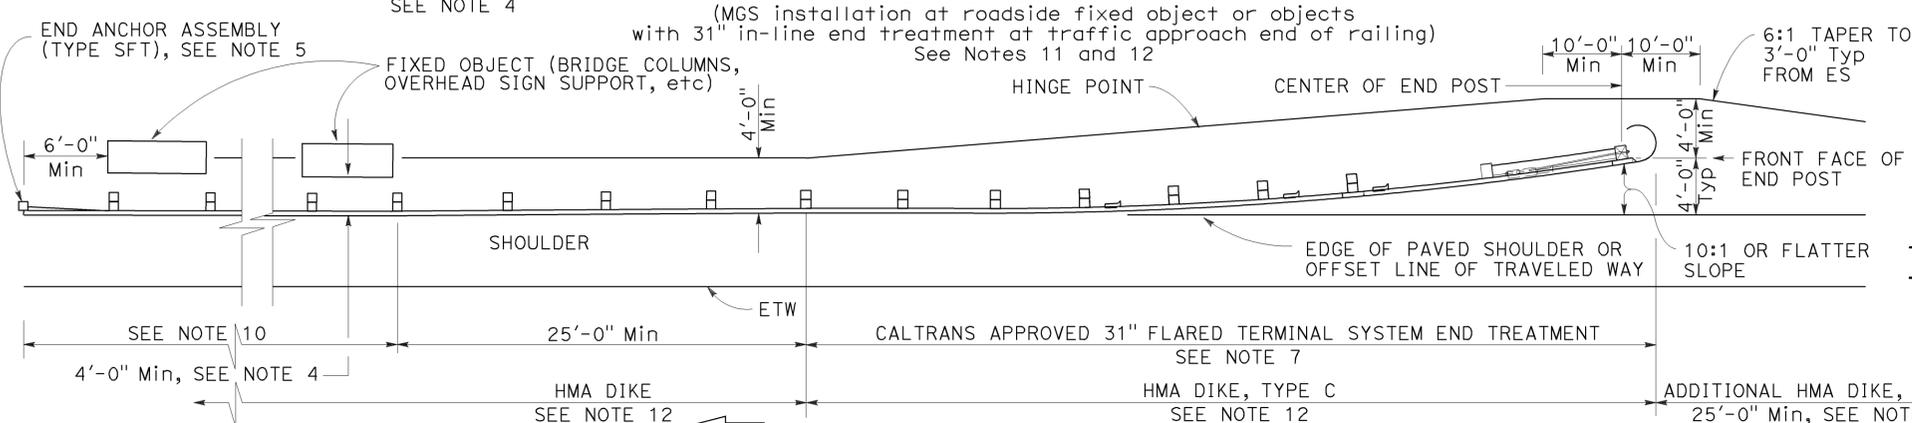


TYPE 16B LAYOUT

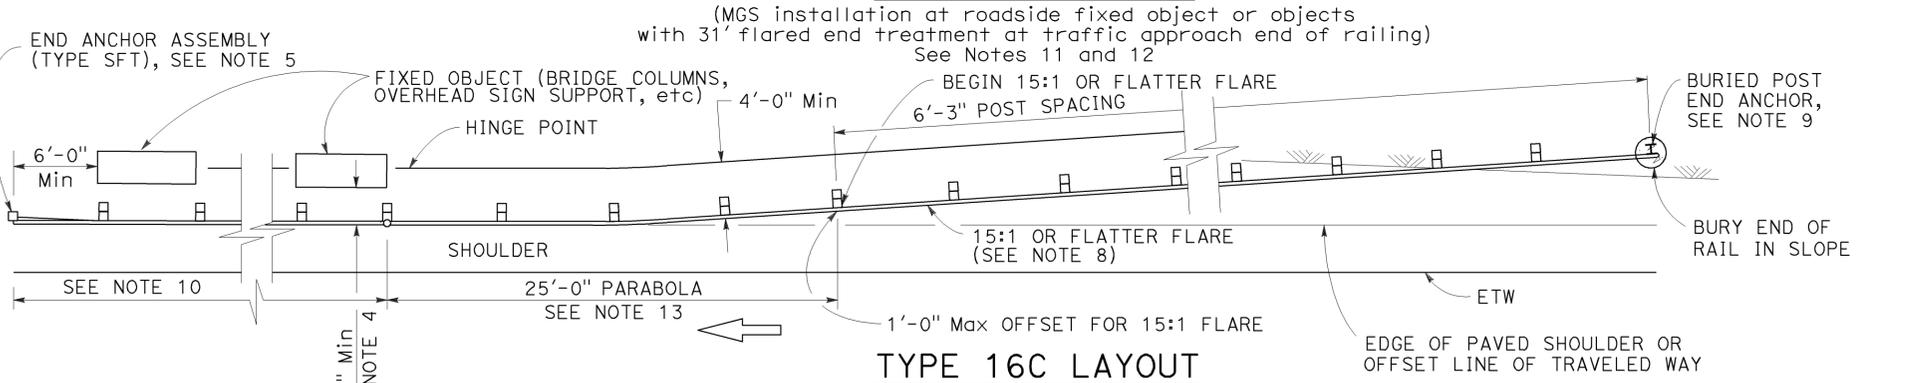


TYPE 16C LAYOUT

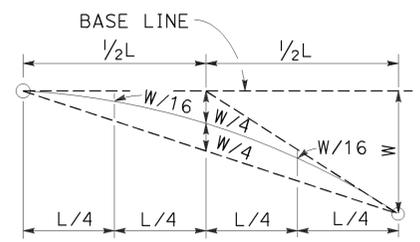

TYPICAL PARABOLIC LAYOUT

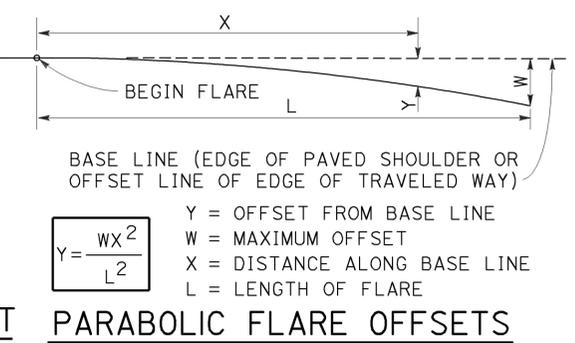

PARABOLIC FLARE OFFSETS

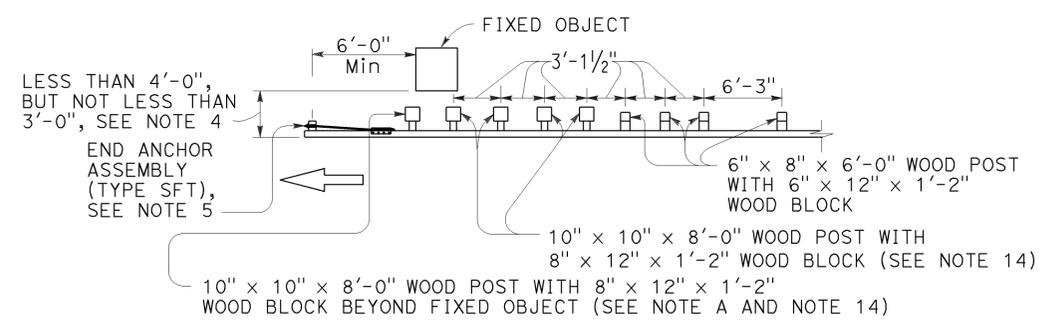

NOTE A: For a series of fixed objects (bridge columns, overhead sign supports, etc.) additional 10" x 10" x 8'-0" wood post with 8" x 12" x 1'-2" wood blocks at 3'-1/2" center to center spacing are to be used between fixed objects.

STRENGTHENED MIDWEST GUARDRAIL SYSTEM SECTIONS FOR FIXED OBJECT

Use strengthened MGS sections with Types 16A, 16B or 16C layouts where minimum clearance between the face of the railing and fixed object(s) is less than 4'-0", but not less than 3'-0". See Note 4

STATE OF CALIFORNIA
DEPARTMENT OF TRANSPORTATION
MIDWEST GUARDRAIL SYSTEM TYPICAL LAYOUTS FOR ROADSIDE FIXED OBJECTS

NO SCALE

RSP A77R3 DATED JULY 19, 2013 SUPPLEMENTS THE STANDARD PLANS BOOK DATED 2010.

REVISED STANDARD PLAN RSP A77R3

NOTES:

- Line post, blocks and hardware to be used are shown on Revised Standard Plans RSP A77L1, RSP A77L2, RSP A77M1, RSP A77N1 and RSP A77N2.
- MGS post spacing to be 6'-3" center to center, except as otherwise noted.
- Except as noted, line posts are 6" x 8" x 6'-0" wood with 6" x 12" x 1'-2" wood blocks. W6 x 8.5 or W6 x 9 steel posts, 6'-0" in length, with 6" x 12" x 1'-2" notched wood blocks or notched recycled plastic blocks may be used for 6" x 8" x 6'-0" wood line posts with 6" x 12" x 1'-2" wood blocks where applicable and when specified.
- A 4'-0" minimum clearance is required between the face of the railing and the face of a fixed object located directly behind MGS sections with post spacing of 6'-3". Construct MGS as shown in the detail "Strengthened Midwest Guardrail System Sections for Fixed Object" on this plan, where the clearance between the face of the railing and the face of a fixed object is less than 4'-0", but not less than 3'-0". Where the clearance is less than 3'-0", a concrete wall or barrier should be constructed to shield the fixed object(s).
- For End Anchor Assembly (Type SFT) details, see Revised Standard Plan RSP A77S1.
- 31" in-line terminal system end treatments are used where site conditions will not accommodate a 31" flared end treatment.
- The type of 31" terminal system to be used will be shown on the Project Plans.
- The 15:1 or flatter flare used with Type 16C Layout is based on the edge of the paved shoulder or offset line of edge of the traveled way. The length of MGS within the 15:1 or flatter flare is based on site conditions and should be a length equal to multiples of 12'-6".
- For details of the Buried Post End Anchor used with Type 16C Layout, see Revised Standard Plan RSP A77T2.
- As site conditions dictate, construct additional MGS to shield fixed object(s). Additional MGS length equal to multiples of 12'-6". Post spacing at 6'-3" except as specified in Note 4.
- Layout Types 16A, 16B or 16C are typically used where MGS is recommended to shield roadside fixed object(s) and a crashworthy 31" end treatment is required for only one direction of traffic.
- Where placement of dike is required with MGS, see Revised Standard Plan RSP A77N4 for dike positioning details.
- For typical flare offsets for 25'-0" length parabola with maximum offset of 1'-0", see Revised Standard Plan RSP A77P1.
- W6 x 15 steel post, 8'-0" in length, with 8" x 12" x 1'-2" notched wood block or notched recycled plastic blocks may be used in place of the 10" x 10" x 8'-0" wood post with 8" x 12" x 1'-2" wood block shown in the detail "Strengthened Midwest Guardrail System Sections for Fixed Object".

2010 REVISED STANDARD PLAN RSP A77R3


Dist	COUNTY	ROUTE	POST MILES TOTAL PROJECT	SHEET No.	TOTAL SHEETS
07	LA	5	13.8/19.2	203	262

Randell D. Hiatt
REGISTERED CIVIL ENGINEER

July 19, 2013
PLANS APPROVAL DATE

THE STATE OF CALIFORNIA OR ITS OFFICERS OR AGENTS SHALL NOT BE RESPONSIBLE FOR THE ACCURACY OR COMPLETENESS OF SCANNED COPIES OF THIS PLAN SHEET.


REGISTERED PROFESSIONAL ENGINEER
Randell D. Hiatt
No. C50200
Exp. 6-30-15
CIVIL
STATE OF CALIFORNIA

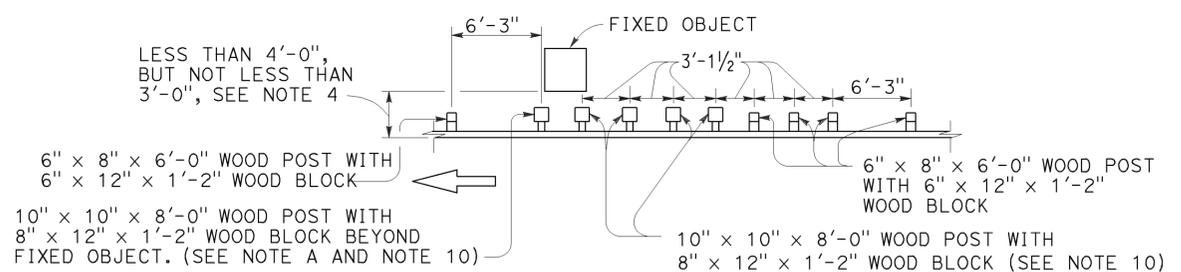

NOTE A: For a series of fixed objects (bridge columns, overhead sign supports, etc.) additional 10" x 10" x 8'-0" wood post with 8" x 12" x 1'-2" wood blocks at 3'-1/2" center to center spacing are to be used between fixed object(s).


STRENGTHENED MIDWEST GUARDRAIL SYSTEM SECTIONS FOR FIXED OBJECT

Use strengthened MGS sections with layout Types 16D or 16E where minimum clearance between the face of the MGS and fixed object(s) is less than 4'-0", but not less than 3'-0". See Note 4.

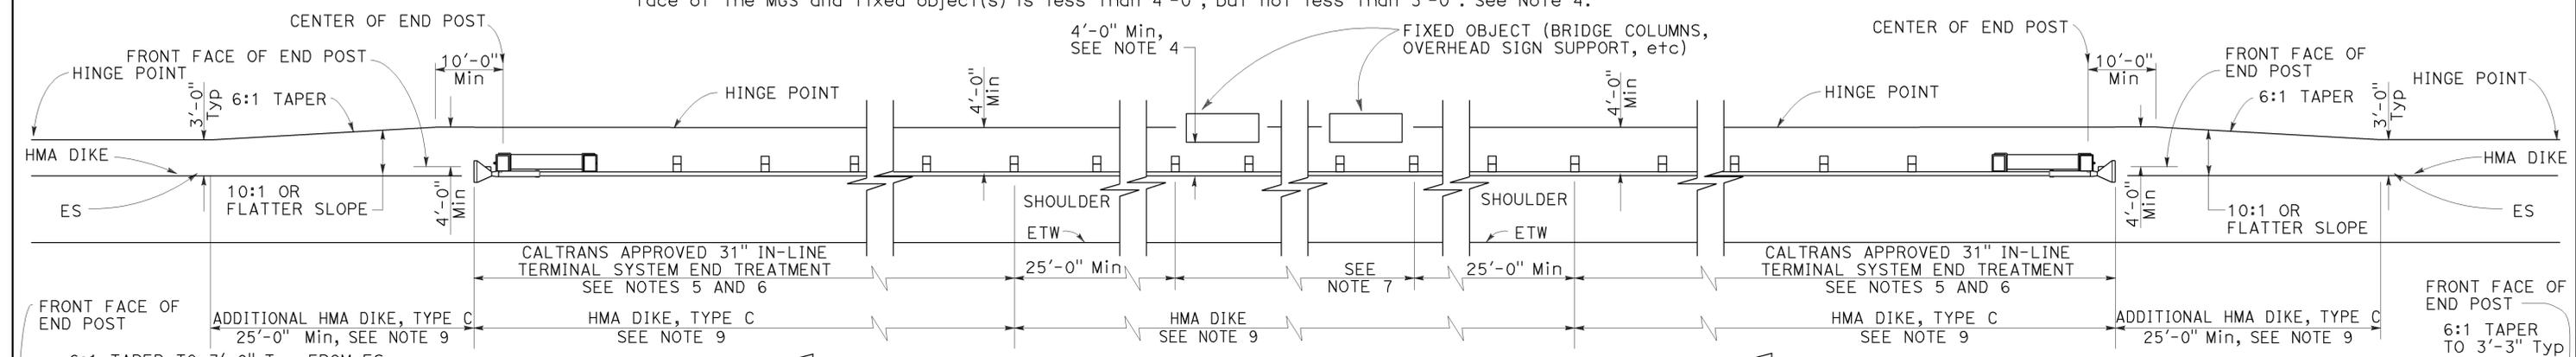

TYPE 16D LAYOUT

(Guard railing installation at roadside fixed object or objects with 31" in-line end treatment at each end of railing) See Note 8

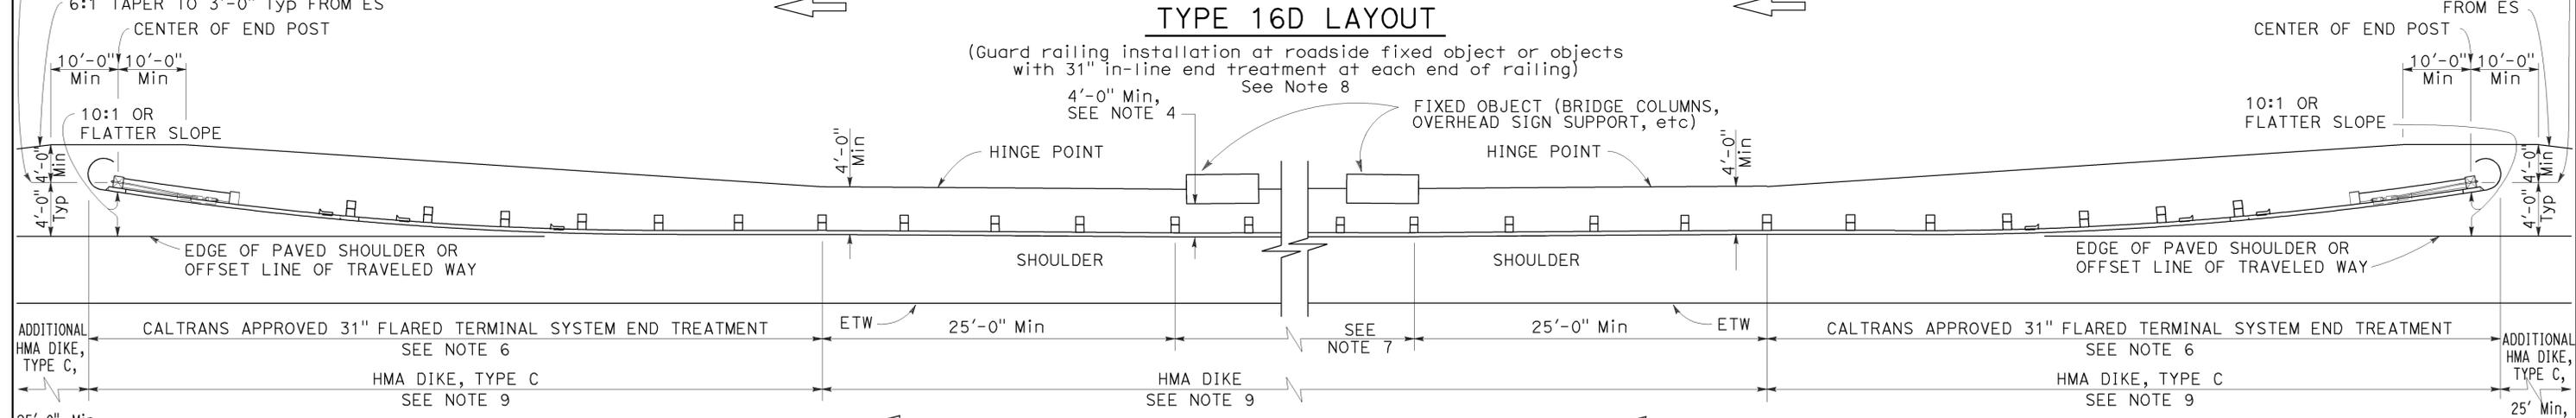

TYPE 16E LAYOUT

(MGS installation at roadside fixed object or objects with 31" flared end treatment at each end of railing) See Note 8

- NOTES:**
- Line post, blocks and hardware to be used are shown on Revised Standard Plans RSP A77L1, RSP A77L2, RSP A77M1, RSP A77N1 and RSP A77N2.
 - MGS post spacing to be 6'-3" center to center, except as otherwise noted.
 - Except as noted, line posts are 6" x 8" x 6'-0" wood with 6" x 12" x 1'-2" wood blocks. W6 x 8.5 or W6 x 9 steel posts, 6'-0" in length, with 6" x 12" x 1'-2" notched wood blocks or notched recycled plastic blocks may be used for 6" x 8" x 6'-0" wood line posts with 6" x 12" x 1'-2" wood blocks where applicable and when specified.
 - A 4'-0" minimum clearance is required between the face of the railing and the face of a fixed object located directly behind MGS sections with post spacing at 6'-3". Construct MGS as shown in the detail "Strengthened Midwest Guardrail System Sections for Fixed Object". on this plan, where the clearance between the face of the railing and the face of a fixed object is less than 4'-0", but not less than 3'-0". Where the clearance is less than 3'-0", a concrete wall or barrier should be constructed to shield the fixed object(s).
 - 31" in-line terminal system end treatments are used where site conditions will not accommodate a 31" flared end treatment.
 - The type of 31" terminal system to be used will be shown on the Project Plans.
 - As site conditions dictate, construct additional MGS to shield fixed object(s). Additional MGS length equal to multiples of 12'-6". Post spacing at 6'-3", except as specified in Note 4.
 - Layout Types 16D through 16L, shown on the A77R Series of Standard Plans, are typically used where MGS is recommended to shield roadside fixed object(s) and a crashworthy 31" end treatment is required for both directions of traffic.
 - Where placement of dike is required with MGS, see Revised Standard Plan RSP A77N4 for dike positioning details.
 - W6 x 15 steel post, 8'-0" in length, with 8" x 12" x 1'-2" notched wood block or notched recycled plastic block may be used in place of the 10" x 10" x 8'-0" wood post with 8" x 12" x 1'-2" wood block shown in the detail "Strengthened Midwest Guardrail System Sections for Fixed Object".

STATE OF CALIFORNIA
DEPARTMENT OF TRANSPORTATION
**MIDWEST GUARDRAIL SYSTEM
TYPICAL LAYOUTS FOR
ROADSIDE FIXED OBJECTS**
NO SCALE

RSP A77R4 DATED JULY 19, 2013 SUPPLEMENTS THE STANDARD PLANS BOOK DATED 2010.

REVISED STANDARD PLAN RSP A77R4

2010 REVISED STANDARD PLAN RSP A77R4




Dist	COUNTY	ROUTE	POST MILES TOTAL PROJECT	SHEET No.	TOTAL SHEETS
07	LA	5	13.8/19.2	204	262

Randell D. Hiatt
REGISTERED CIVIL ENGINEER

July 19, 2013
PLANS APPROVAL DATE

THE STATE OF CALIFORNIA OR ITS OFFICERS OR AGENTS SHALL NOT BE RESPONSIBLE FOR THE ACCURACY OR COMPLETENESS OF SCANNED COPIES OF THIS PLAN SHEET.


REGISTERED PROFESSIONAL ENGINEER
Randell D. Hiatt
No. C50200
Exp. 6-30-15
CIVIL
STATE OF CALIFORNIA

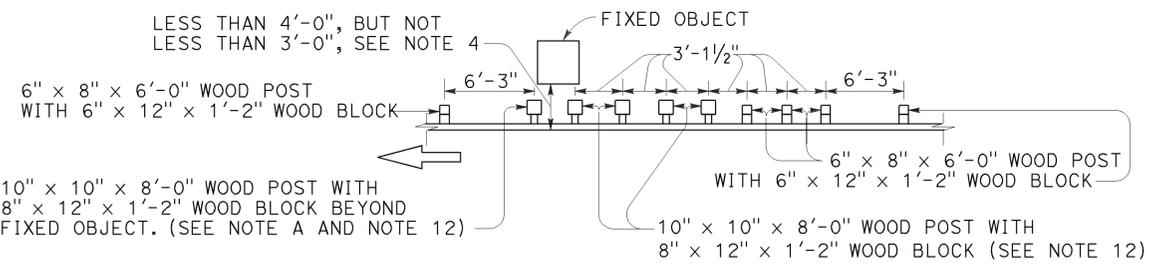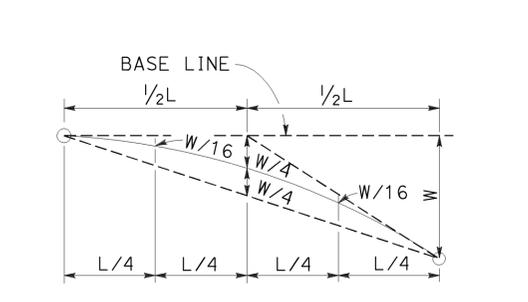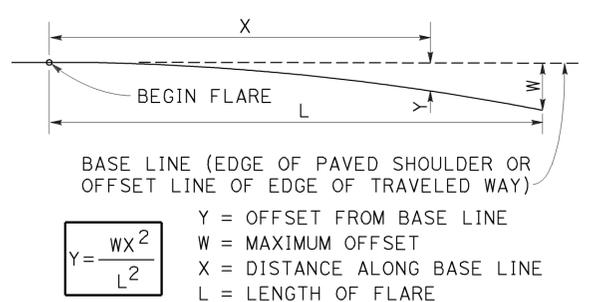

NOTE A: For a series of fixed objects (bridge columns, overhead sign supports, etc) additional 10" x 10" x 8'-0" wood post with 8" x 12" x 1'-2" wood blocks at 3'-1/2" center to center spacing are to be used between fixed object(s).


STRENGTHENED MIDWEST GUARDRAIL SYSTEM SECTIONS FOR FIXED OBJECT

Use strengthened MGS sections with layout Types 16F or 16G where minimum clearance between the face of the MGS and fixed object(s) is less than 4'-0", but not less than 3'-0". See Note 4.

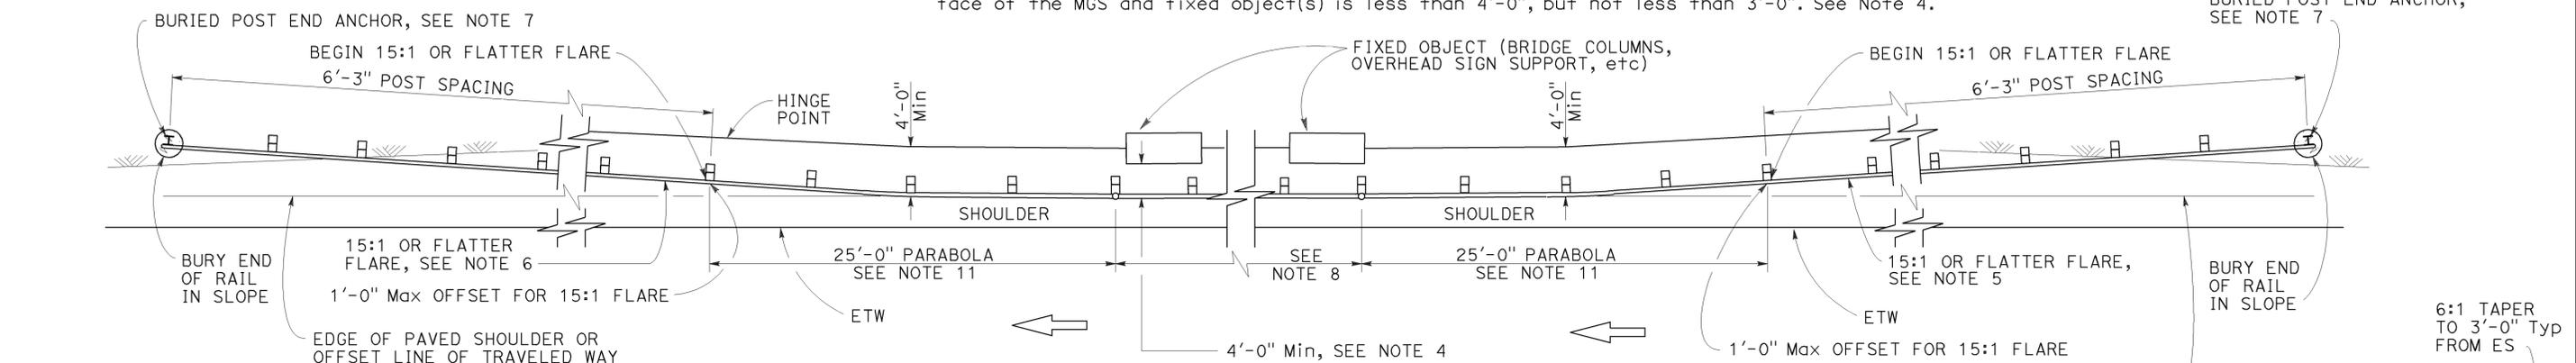

TYPE 16F LAYOUT

(MGS installation at roadside fixed object or objects with a buried end anchor treatment at each end of railing) See Notes 9 and 10

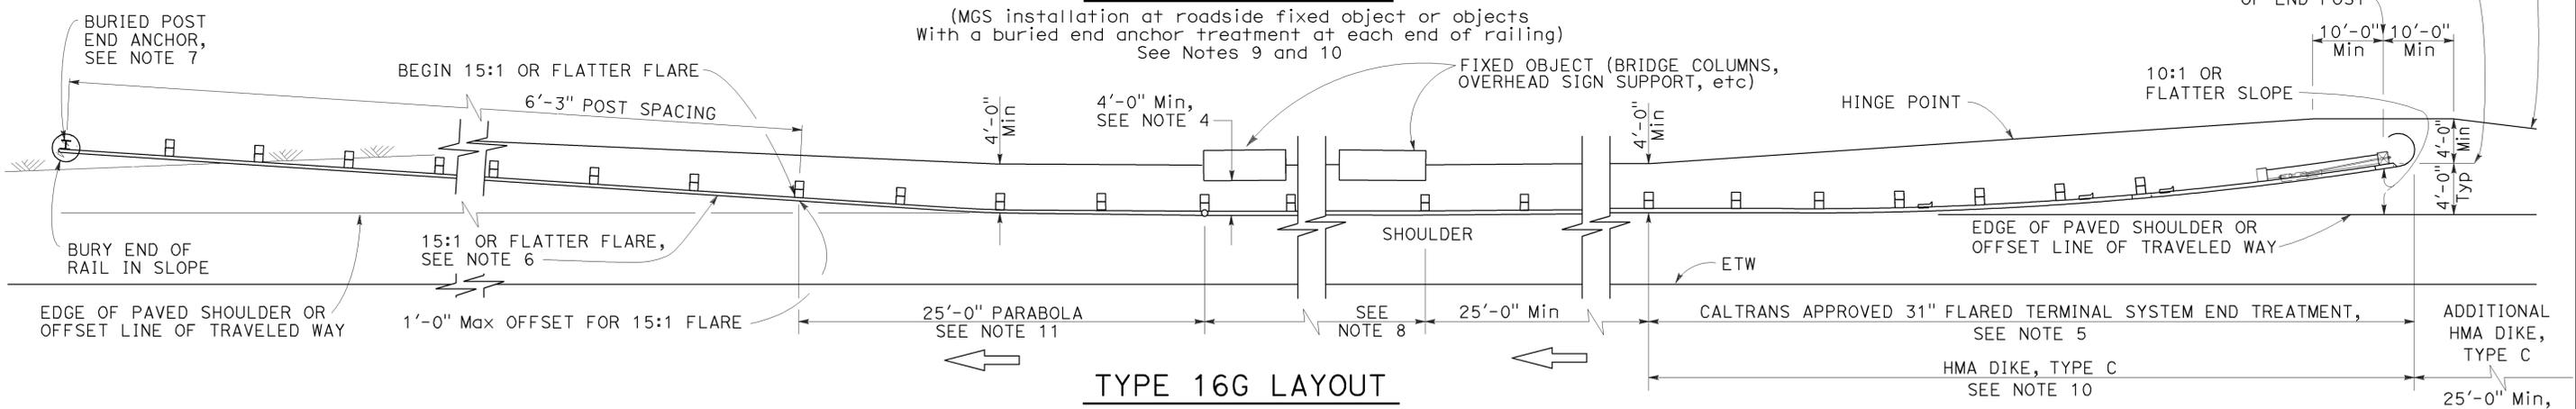

TYPE 16G LAYOUT

(MGS installation at roadside fixed object or objects with 31" flared end treatment and a buried end anchor treatment at the ends of railing) See Notes 9 and 10

NOTES:

- Line post, blocks and hardware to be used are shown on Revised Standard Plans RSP A77L1, RSP A77L2, RSP A77M1, RSP A77N1 and RSP A77N2.
- MGS post spacing to be 6'-3" center to center, except as otherwise noted.
- Except as noted, line posts are 6" x 8" x 6'-0" wood with 6" x 12" x 1'-2" wood blocks. W6 x 8.5 or W6 x 9 steel posts, 6'-0" in length, with 8" x 12" x 1'-2" notched wood blocks or notched recycled plastic blocks may be used for 6" x 8" x 6'-0" wood posts with 6" x 12" x 1'-2" wood blocks where applicable and when specified.
- A 4'-0" minimum clearance is required between the face of the railing and the face of a fixed object located directly behind MGS sections with post spacing at 6'-3". Construct MGS as shown in the detail "Strengthened Midwest Guardrail System Sections for Fixed Objects" on this plan, where the clearance between the face of the railing and the face of a fixed object is less than 4'-0", but not less than 3'-0". Where the clearance is less than 3'-0", a concrete wall or barrier should be constructed to shield the fixed object(s).
- The type of 31" terminal system to be used will be shown on the Project Plans.
- The 15:1 or flatter flare for the buried post anchor is based on the edge of the paved shoulder or offset line of edge of the traveled way. The length of MGS within the 15:1 or flatter flare is based on site conditions and should be a length equal to multiples of 12'-6".
- For details of the Buried Post End Anchor, see Revised Standard Plan RSP A77T2.
- As site conditions dictate, construct additional MGS to shield fixed object(s). Additional MGS length equal to multiples of 12'-6". Post spacing at 6'-3", except as specified in Note 4.
- Layout Types 16D through 16L, shown on the A77R Series of Standard Plans, are typically used on highways where MGS is recommended to shield roadside fixed object(s) and a crashworthy 31" end treatment is required for both directions of traffic.
- Where placement of dike is required with MGS, see Revised Standard Plan RSP A77N4 for dike positioning details.
- For typical flare offsets for 25'-0" length parabola with maximum offset of 1'-0", see Revised Standard Plan RSP A77P1.
- W6 x 15 steel post, 8'-0" in length, with 8" x 12" x 1'-2" notched wood block or notched recycled plastic blocks may be used in place of the 10" x 10" x 8'-0" wood post with 8" x 12" x 1'-2" wood block shown in the detail "Strengthened Midwest Guardrail System Sections for Fixed Object".

STATE OF CALIFORNIA
DEPARTMENT OF TRANSPORTATION
**MIDWEST GUARDRAIL SYSTEM
TYPICAL LAYOUTS FOR
ROADSIDE FIXED OBJECTS**
NO SCALE

RSP A77R5 DATED JULY 19, 2013 SUPPLEMENTS THE STANDARD PLANS BOOK DATED 2010.

REVISED STANDARD PLAN RSP A77R5

2010 REVISED STANDARD PLAN RSP A77R5


Dist	COUNTY	ROUTE	POST MILES TOTAL PROJECT	SHEET No.	TOTAL SHEETS
07	LA	5	13.8/19.2	205	262

Randell D. Hiatt
REGISTERED CIVIL ENGINEER

July 19, 2013
PLANS APPROVAL DATE

THE STATE OF CALIFORNIA OR ITS OFFICERS OR AGENTS SHALL NOT BE RESPONSIBLE FOR THE ACCURACY OR COMPLETENESS OF SCANNED COPIES OF THIS PLAN SHEET.

REGISTERED PROFESSIONAL ENGINEER
No. C50200
Exp. 6-30-15
CIVIL
STATE OF CALIFORNIA

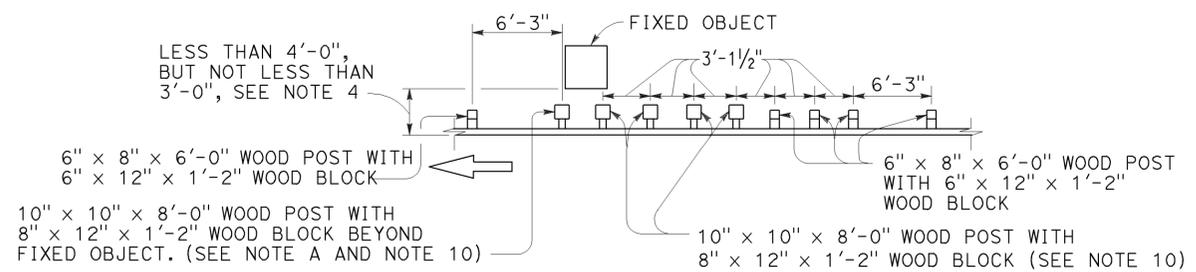


NOTE A: For a series of fixed objects (bridge columns, overhead sign supports, etc.) additional 10" x 10" x 8'-0" wood post with 8" x 12" x 1'-2" wood blocks at 3'-1/2" center to center spacing are to be used between fixed object(s).

TO ACCOMPANY PLANS DATED 2-1-16

STRENGTHENED MIDWEST GUARDRAIL SYSTEM SECTIONS FOR FIXED OBJECT

Use strengthened MGS sections with layout Type 16H where minimum clearance between the face of the MGS and fixed object(s) is less than 4'-0", but not less than 3'-0". See Note 4.

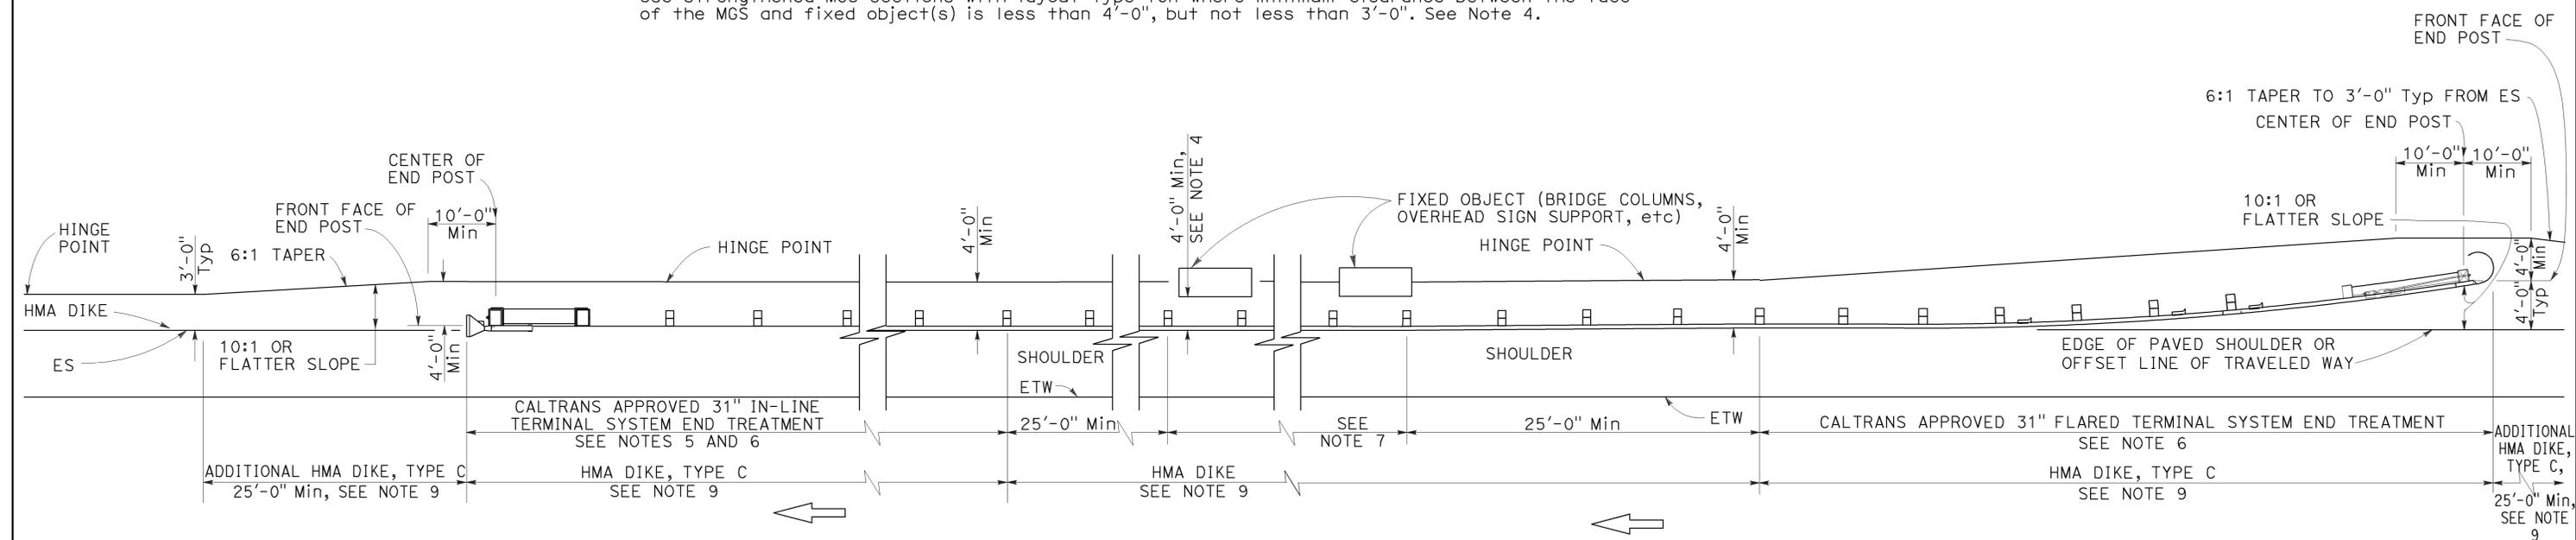

TYPE 16H LAYOUT

(MGS installation at roadside fixed object or objects with 31" flared end treatment and 31" in-line end treatment at the ends of railing) See Note 8

NOTES:

- Line post, blocks and hardware to be used are shown on Revised Standard Plans RSP A77L1, RSP A77L2, RSP A77M1, RSP A77N1 and RSP A77N2.
- MGS post spacing to be 6'-3" center to center, except as otherwise noted.
- Except as noted, line posts are 6" x 8" x 6'-0" wood with 6" x 12" x 1'-2" wood blocks. W6 x 8.5 or W6 x 9 steel posts, 6'-0" in length, with 6" x 12" x 1'-2" notched wood blocks or notched recycled plastic blocks may be used for 6" x 8" x 6'-0" wood posts with 6" x 12" x 1'-2" wood blocks where applicable and when specified.
- A 4'-0" minimum clearance is required between the face of the railing and the face of a fixed object located directly behind MGS sections with post spacing at 6'-3". Construct MGS as shown in the detail "Strengthened Midwest Guardrail System Sections for Fixed Objects" on this plan, where the clearance between the face of the railing and the face of a fixed object is less than 4'-0", but not less than 3'-0". Where the clearance is less than 3'-0", a concrete wall or barrier should be constructed to shield the fixed object(s).
- 31" in-line terminal system end treatments are used where site conditions will not accommodate a 31" flared end treatment.
- The type of 31" terminal system to be used will be shown on the Project Plans.
- As site conditions dictate, construct additional MGS to shield fixed object(s). Additional MGS length equal to multiples of 12'-6". Post spacing at 6'-3", except as specified in Note 4.
- Layout Types 16D through 16L, shown on the A77R Series of Standard Plans, typically used where MGS is recommended to shield roadside fixed object(s) and a crashworthy 31" end treatment is required for both directions of traffic.
- Where placement of dike is required with MGS, see Revised Standard Plan RSP A77N4 for dike positioning details.
- W6 x 15 steel post, 8'-0" in length, with 8" x 12" x 1'-2" notched wood block or notched recycled plastic blocks may be used in place of the 10" x 10" x 8'-0" wood post with 8" x 12" x 1'-2" wood block shown in the detail "Strengthened Midwest Guardrail System Sections for Fixed Object".

STATE OF CALIFORNIA
DEPARTMENT OF TRANSPORTATION
**MIDWEST GUARDRAIL SYSTEM
TYPICAL LAYOUTS FOR
ROADSIDE FIXED OBJECTS**

NO SCALE

RSP A77R6 DATED JULY 19, 2013 SUPPLEMENTS THE STANDARD PLANS BOOK DATED 2010.

REVISED STANDARD PLAN RSP A77R6

2010 REVISED STANDARD PLAN RSP A77R6


Dist	COUNTY	ROUTE	POST MILES TOTAL PROJECT	SHEET No.	TOTAL SHEETS
07	LA	5	13.8/19.2	206	262

Randell D. Hiatt
REGISTERED CIVIL ENGINEER

July 19, 2013
PLANS APPROVAL DATE


THE STATE OF CALIFORNIA OR ITS OFFICERS OR AGENTS SHALL NOT BE RESPONSIBLE FOR THE ACCURACY OR COMPLETENESS OF SCANNED COPIES OF THIS PLAN SHEET.

REGISTERED PROFESSIONAL ENGINEER
No. C50200
Exp. 6-30-15
CIVIL
STATE OF CALIFORNIA

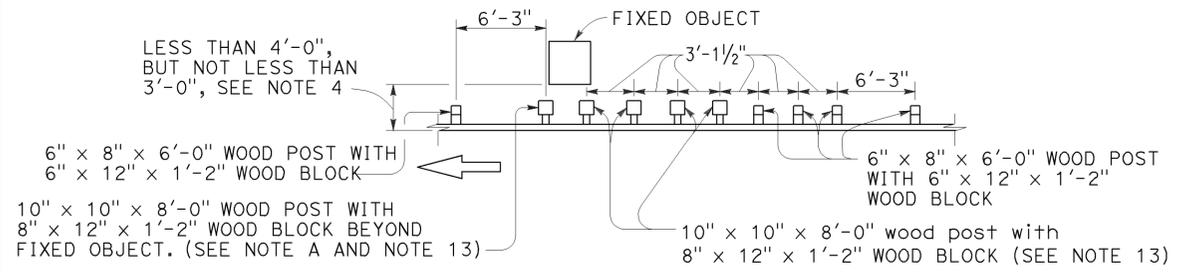

NOTE A: For a series of fixed objects (bridge columns, overhead sign supports, etc.) additional 10" x 10" x 8'-0" wood post with 8" x 12" x 1'-2" wood blocks at 3'-1/2" center to center spacing are to be used between fixed object(s).


STRENGTHENED MIDWEST GUARDRAIL SYSTEM SECTIONS FOR FIXED OBJECT

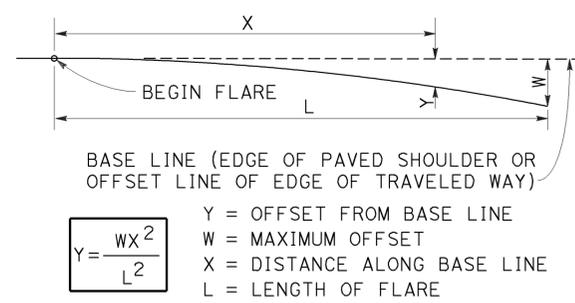

$$Y = \frac{WX^2}{L^2}$$


Y = OFFSET FROM BASE LINE
W = MAXIMUM OFFSET
X = DISTANCE ALONG BASE LINE
L = LENGTH OF FLARE

PARABOLIC FLARE OFFSETS

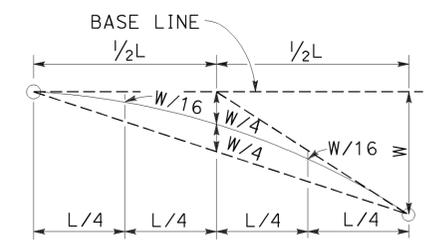


TYPICAL PARABOLIC LAYOUT

Use strengthened MGS sections with layout Types 16I or 16J Layouts where minimum clearance between the face of the MGS and fixed object(s) is less than 4'-0", but not less than 3'-0". See Note 4.

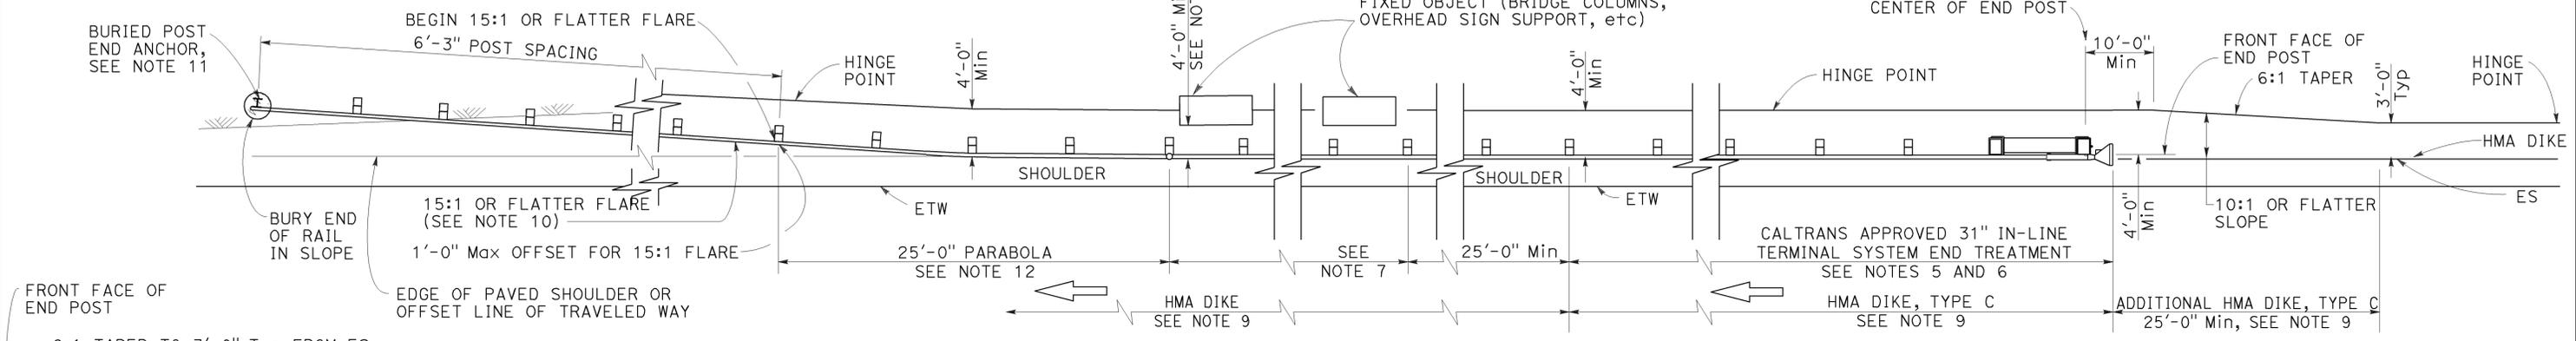

TYPE 16I LAYOUT

(MGS installation at roadside fixed object or objects with 31" in-line end treatment and a buried end anchor treatment at the ends of railing) See Note 8

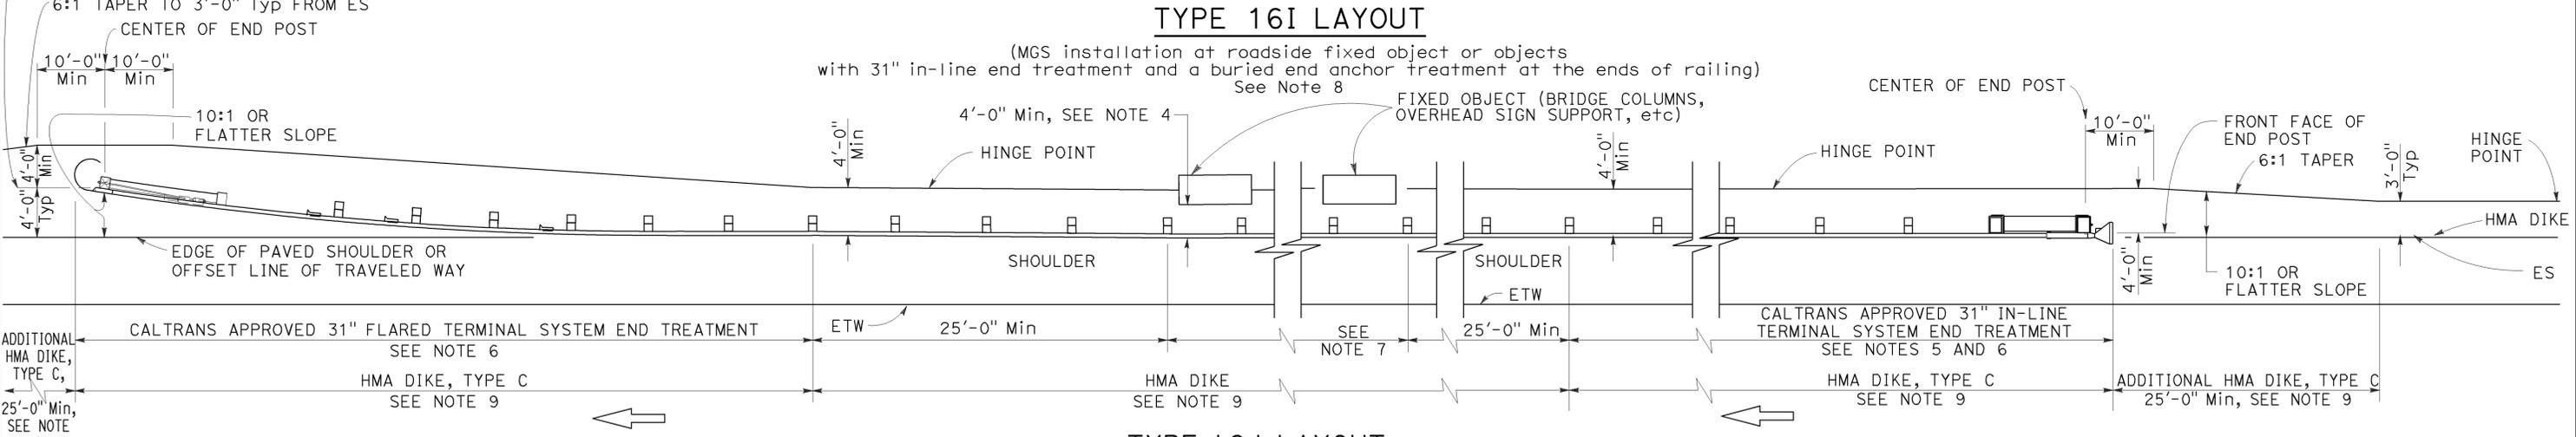

TYPE 16J LAYOUT

(MGS installation at roadside fixed object or objects With a 31" in-line end treatment and a 31" flared end treatment at the ends of railing) See Note 8

NOTES:

- Line post, blocks and hardware to be used are shown on Revised Standard Plans RSP A77L1, RSP A77L2, RSP A77M1, RSP A77N1 and RSP A77N2.
- MGS post spacing to be 6'-3" center to center, except as otherwise noted.
- Except as noted, line posts are 6" x 8" x 6'-0" wood with 6" x 12" x 1'-2" wood blocks, W6 x 8.5 or W6 x 9 steel posts, 6'-0" in length, with 6" x 12" x 1'-2" notched wood blocks or notched recycled plastic blocks may be used for 6" x 8" x 6'-0" wood posts with 6" x 12" x 1'-2" wood blocks where applicable and when specified.
- A 4'-0" minimum clearance is required between the face of the railing and the face of a fixed object located directly behind MGS sections with post spacing at 6'-3". Construct MGS as shown in the detail "Strengthened Midwest Guardrail System Sections for Fixed Objects" on this plan, where the clearance between the face of the railing and the face of a fixed object is less than 4'-0", but not less than 3'-0". Where the clearance is less than 3'-0", a concrete wall or barrier should be constructed to shield the fixed object(s).

- 31" in-line terminal system end treatments are used where site conditions will not accommodate a 31" flared end treatment.
- The type of 31" terminal system to be used will be shown on the Project Plans.
- As site conditions dictate, construct additional MGS to shield fixed object(s). Additional MGS length equal to multiples of 12'-6". Post spacing at 6'-3", except as specified in Note 4.
- Layout Types 16D through 16L, shown on the A77R Series of Standard Plans, are typically used where MGS is recommended to shield roadside fixed object(s) and a crashworthy 31" end treatment is required for both directions of traffic.
- Where placement of dike is required with guard railing, see Revised Standard Plan RSP A77N4 for dike positioning details.
- The 15:1 or flatter flare for the buried post anchor is based on the edge of the paved shoulder or offset line of edge of the traveled way. The length of MGS within the 15:1 or flatter flare is based on site conditions and should be a length equal to multiples of 12'-6".

- For details of Buried Post End Anchor, see Revised Standard Plan RSP A77T2.
- For typical flare offsets for 25'-0" length parabola with maximum offset of 1'-0", see Revised Standard Plan RSP A77P1.
- W6 x 15 steel post, 8'-0" in length, with 8" x 12" x 1'-2" notched wood block or notched recycled plastic blocks may be used in place of the 10" x 10" x 8'-0" wood post with 8" x 12" x 1'-2" wood block shown in the detail "Strengthened Midwest Guardrail System Sections for Fixed Object".

MIDWEST GUARDRAIL SYSTEM TYPICAL LAYOUTS FOR ROADSIDE FIXED OBJECTS

NO SCALE

RSP A77R7 DATED JULY 19, 2013 SUPPLEMENTS THE STANDARD PLANS BOOK DATED 2010.

REVISED STANDARD PLAN RSP A77R7

2010 REVISED STANDARD PLAN RSP A77R7


Dist	COUNTY	ROUTE	POST MILES TOTAL PROJECT	SHEET No.	TOTAL SHEETS
07	LA	5	13.8/19.2	207	262

Randell D. Hiatt
REGISTERED CIVIL ENGINEER

July 19, 2013
PLANS APPROVAL DATE


THE STATE OF CALIFORNIA OR ITS OFFICERS OR AGENTS SHALL NOT BE RESPONSIBLE FOR THE ACCURACY OR COMPLETENESS OF SCANNED COPIES OF THIS PLAN SHEET.

REGISTERED PROFESSIONAL ENGINEER
No. C50200
Exp. 6-30-15
CIVIL
STATE OF CALIFORNIA

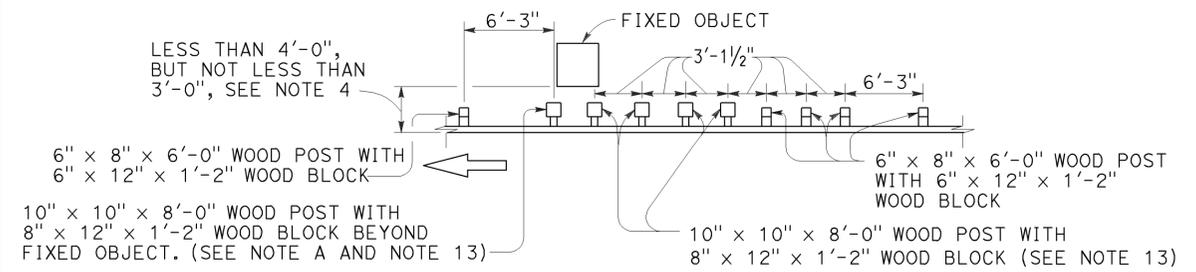


NOTE A: For a series of fixed objects (bridge columns, overhead sign supports, etc.) additional 10" x 10" x 8'-0" wood post with 8" x 12" x 1'-2" wood blocks at 3'-1/2" center to center spacing are to be used between fixed object(s).

STRENGTHENED MIDWEST GUARDRAIL SYSTEM SECTIONS FOR FIXED OBJECT

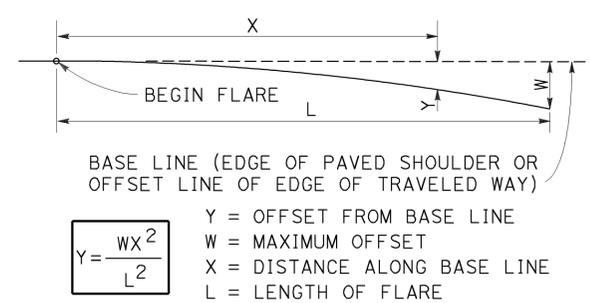


PARABOLIC FLARE OFFSETS

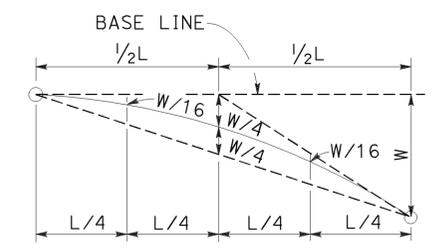


TYPICAL PARABOLIC LAYOUT

Use strengthened MGS sections with layout Types 16K or 16L layouts where minimum clearance between the face of the MGS and fixed object(s) is less than 4'-0", but not less than 3'-0". See Note 4.

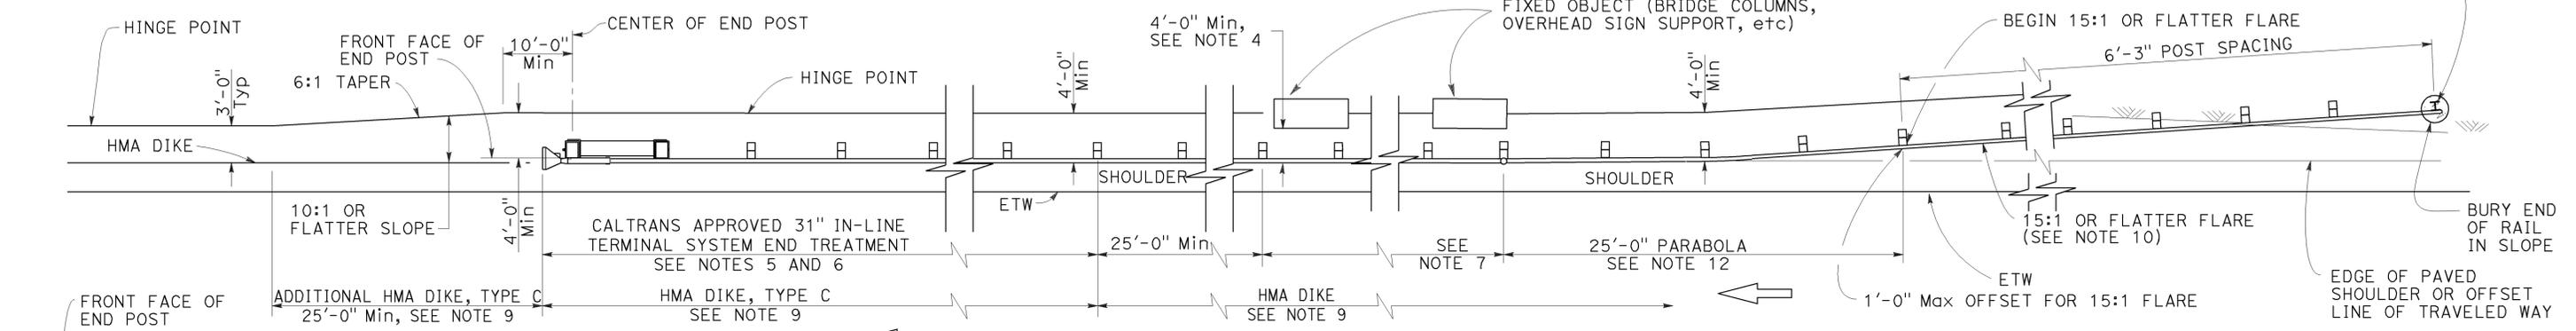

TYPE 16K LAYOUT

(MGS installation at roadside fixed object or objects with a buried end anchor treatment and a 31" in-line end treatment at the ends of railing) See Note 8

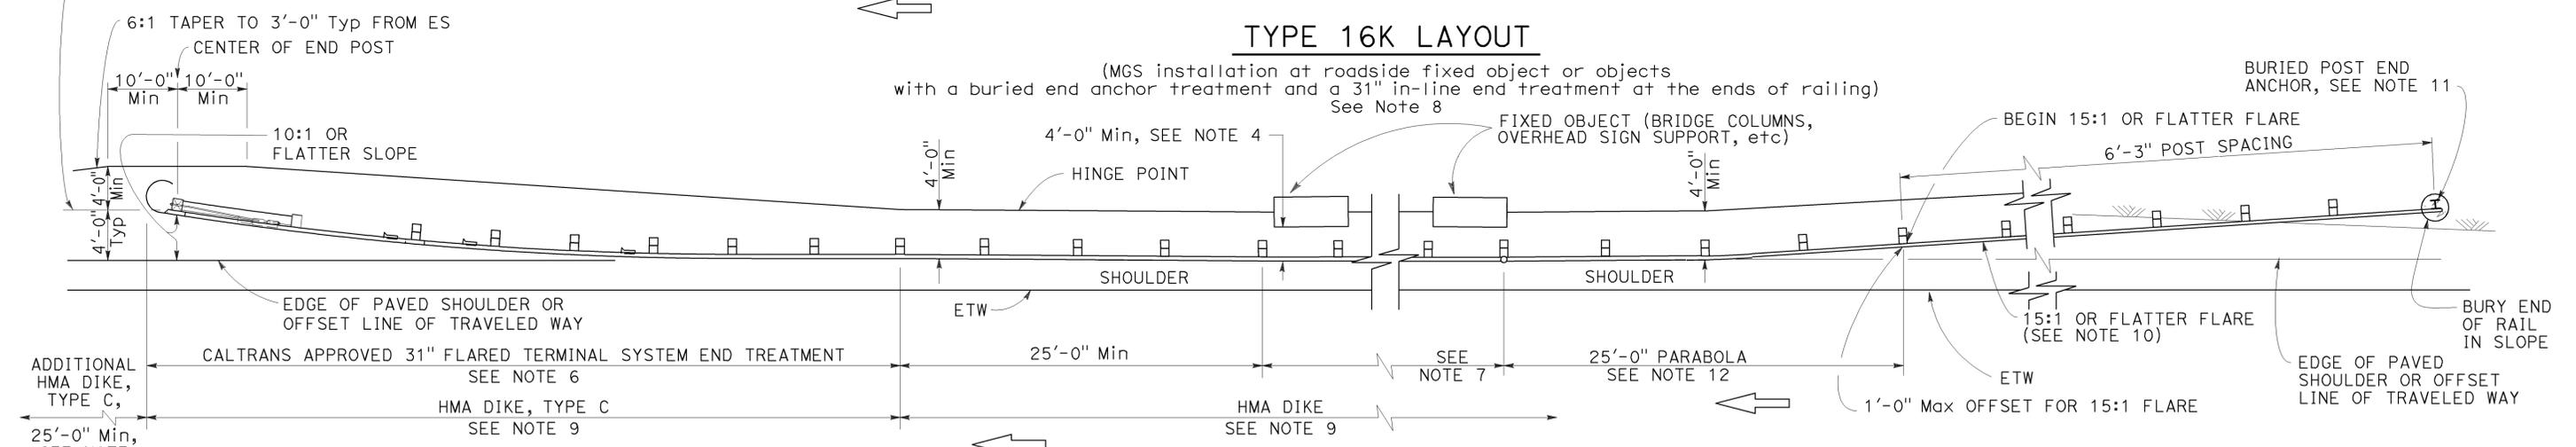

TYPE 16L LAYOUT

(MGS installation at roadside fixed object or objects with a buried end anchor treatment and a 31" flared end treatment at the ends of railing) See Note 8

NOTES:

- Line post, blocks and hardware to be used are shown on Revised Standard Plans RSP A77L1, RSP A77L2, RSP A77M1, RSP A77N1 and RSP A77N2.
- MGS post spacing to be 6'-3" center to center, except as otherwise noted.
- Except as noted, line posts are 6" x 8" x 6'-0" wood with 6" x 12" x 1'-2" wood blocks. W6 x 8.5 or W6 x 9 steel posts, 6'-0" in length, with 6" x 12" x 1'-2" notched wood blocks or notched recycled plastic blocks may be used for 6" x 8" x 6'-0" wood posts with 6" x 12" x 1'-2" wood blocks where applicable and when specified.
- A 4'-0" minimum clearance is required between the face of the railing and the face of a fixed object located directly behind MGS sections with post spacing at 6'-3". Construct MGS as shown in the detail "Strengthened Midwest Guardrail System Sections for Fixed Objects" on this plan, where the clearance between the face of the railing and the face of a fixed object is less than 4'-0", but not less than 3'-0". Where the clearance is less than 3'-0", a concrete wall or barrier should be constructed to shield the fixed object(s).

- 31" in-line terminal system end treatments are used where site conditions will not accommodate a 31" flared end treatment.
- The type of 31" terminal system to be used will be shown on the Project Plans.
- As site conditions dictate, construct additional MGS to shield fixed object(s). Additional MGS length equal to multiples of 12'-6". Post spacing at 6'-3", except as specified in Note 4.
- Layout Types 16D through 16L, shown on the A77R Series of Standard Plans are typically used where MGS is recommended to shield roadside fixed object(s) and a crashworthy 31" end treatment is required for both directions of traffic.
- Where placement of dike is required with MGS, see Revised Standard Plan RSP A77N4 for dike positioning details.
- The 15:1 or flatter flare for the buried post anchor is based on the edge of the paved shoulder or offset line of edge of the traveled way. The length of MGS within the 15:1 or flatter flare is based on site conditions and should be a length equal to multiples of 12'-6".

- For details of Buried Post End Anchor, see Revised Standard Plan RSP A77T2.
- For typical flare offsets for 25'-0" length parabola with maximum offset of 1'-0", see Revised Standard Plan RSP A77P1.
- W6 x 15 steel post, 8'-0" in length, with 8" x 12" x 1'-2" notched wood block or notched recycled plastic blocks may be used in place of the 10" x 10" x 8'-0" wood post with 8" x 12" x 1'-2" wood block shown in the detail "Strengthened Midwest Guardrail System Sections for Fixed Object".

STATE OF CALIFORNIA
DEPARTMENT OF TRANSPORTATION

MIDWEST GUARDRAIL SYSTEM TYPICAL LAYOUTS FOR ROADSIDE FIXED OBJECTS

NO SCALE

RSP A77R8 DATED JULY 19, 2013 SUPPLEMENTS THE STANDARD PLANS BOOK DATED 2010.

REVISED STANDARD PLAN RSP A77R8

2010 REVISED STANDARD PLAN RSP A77R8



Dist	COUNTY	ROUTE	POST MILES TOTAL PROJECT	SHEET No.	TOTAL SHEETS
07	LA	5	13.8/19.2	208	262

Randell D. Hiatt
REGISTERED CIVIL ENGINEER


November 15, 2013
PLANS APPROVAL DATE

THE STATE OF CALIFORNIA OR ITS OFFICERS OR AGENTS SHALL NOT BE RESPONSIBLE FOR THE ACCURACY OR COMPLETENESS OF SCANNED COPIES OF THIS PLAN SHEET.


TO ACCOMPANY PLANS DATED 2-1-16

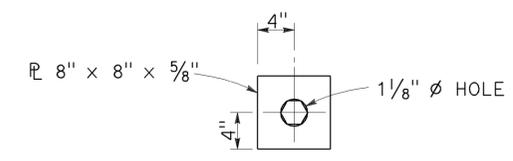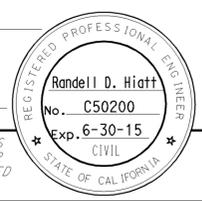


DETAIL "A"
CABLE CONNECTION
END PLATE

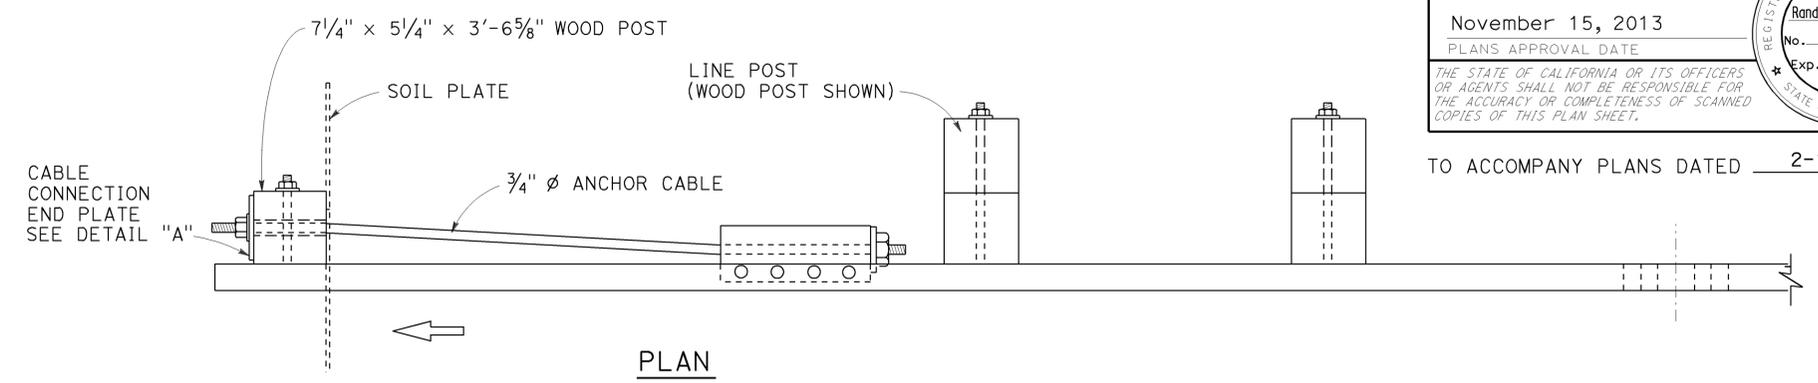

PLAN

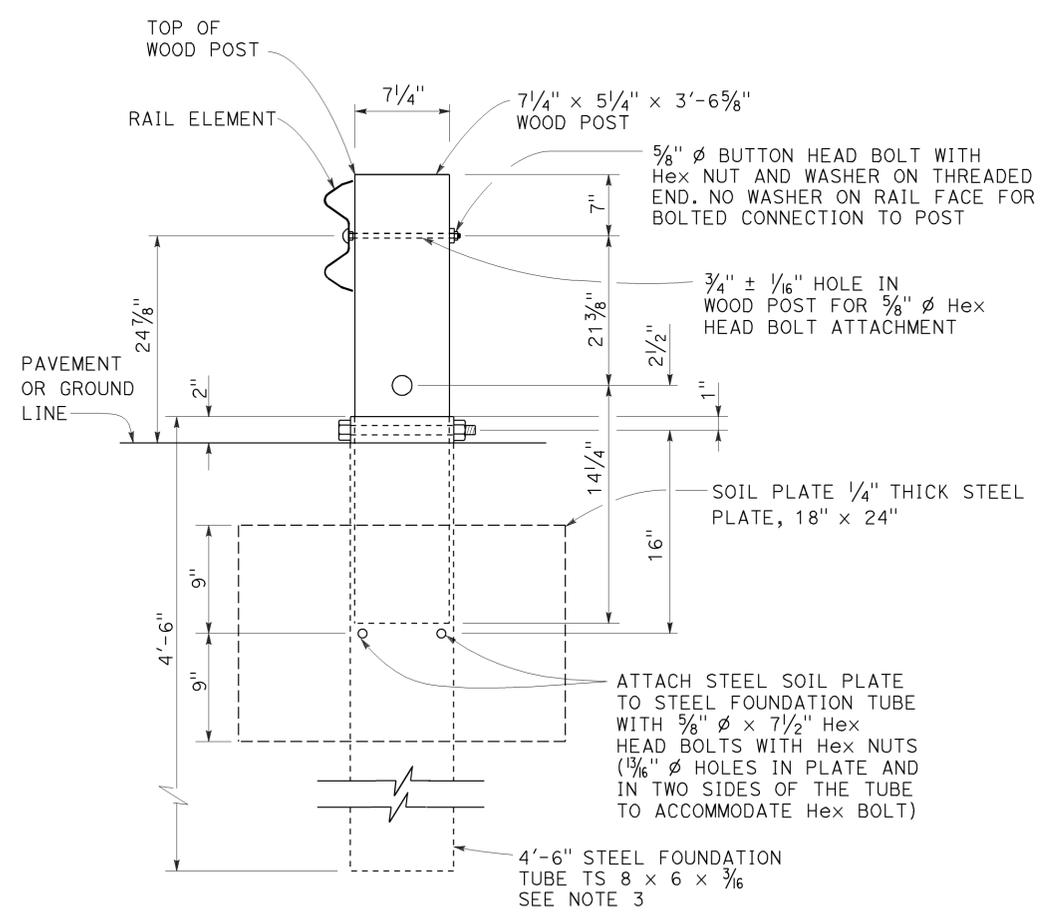

SECTION A-A

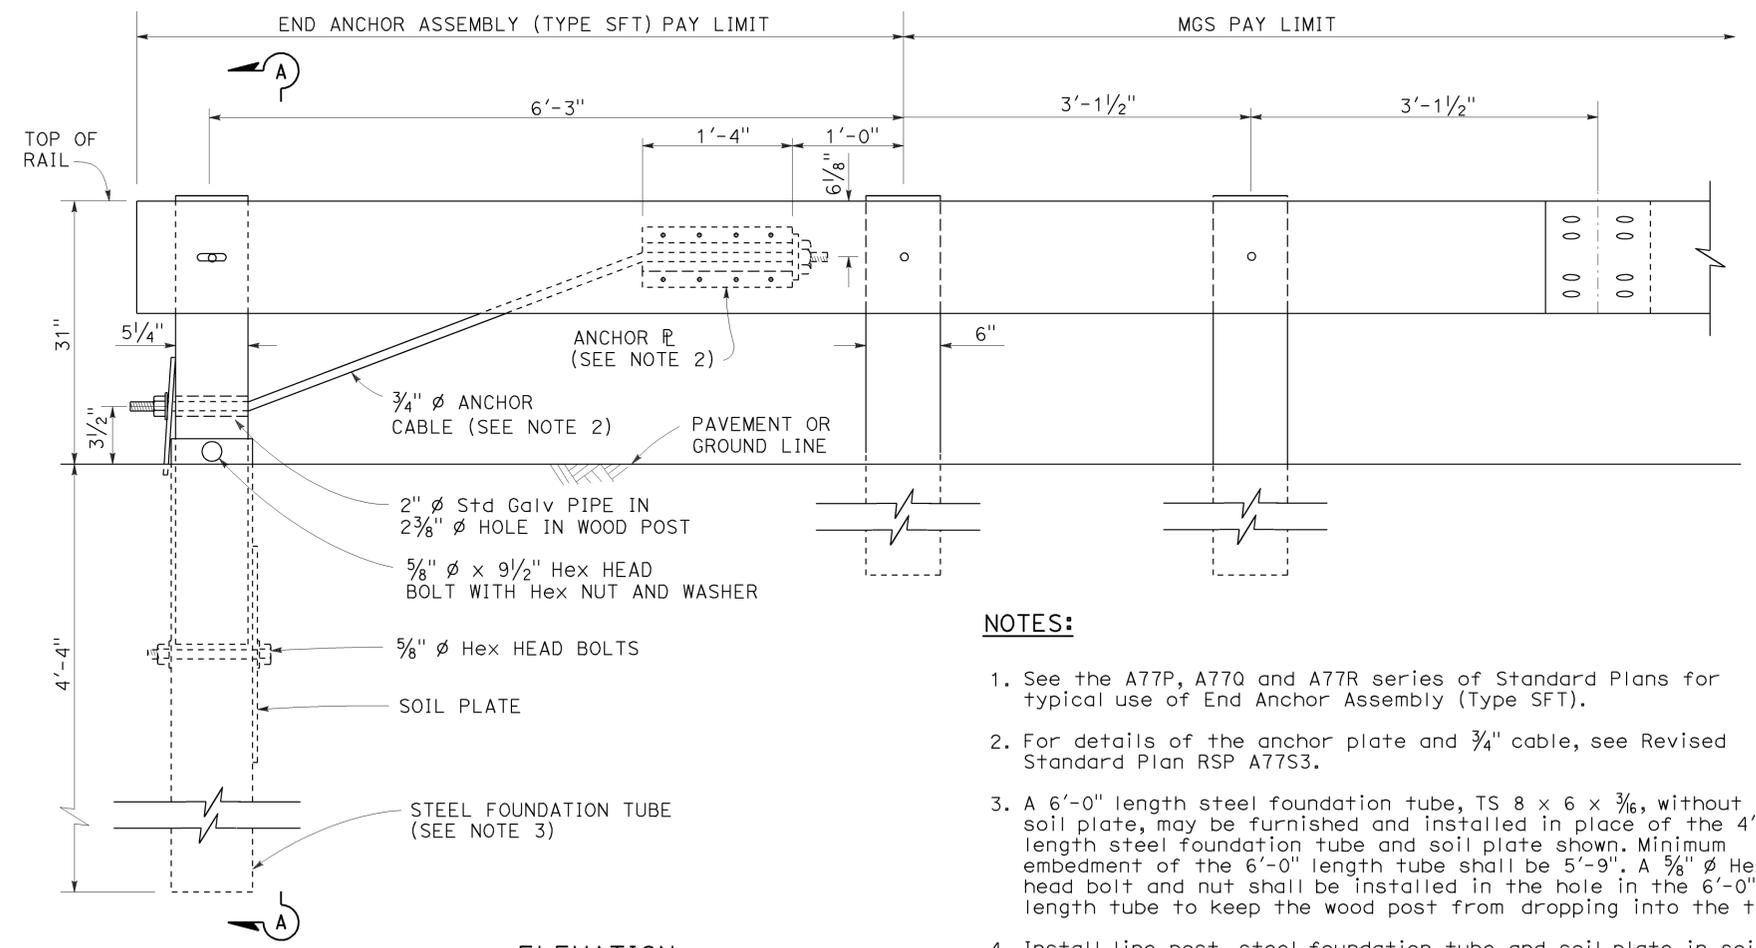

ELEVATION

END ANCHOR
ASSEMBLY (TYPE SFT)
See Note 1

NOTES:

1. See the A77P, A77Q and A77R series of Standard Plans for typical use of End Anchor Assembly (Type SFT).
2. For details of the anchor plate and 3/4" cable, see Revised Standard Plan RSP A77S3.
3. A 6'-0" length steel foundation tube, TS 8 x 6 x 3/16, without a soil plate, may be furnished and installed in place of the 4'-6" length steel foundation tube and soil plate shown. Minimum embedment of the 6'-0" length tube shall be 5'-9". A 5/8" diameter hex head bolt and nut shall be installed in the hole in the 6'-0" length tube to keep the wood post from dropping into the tube.
4. Install line post, steel foundation tube and soil plate in soil.

STATE OF CALIFORNIA
DEPARTMENT OF TRANSPORTATION
MIDWEST GUARDRAIL SYSTEM
END ANCHOR ASSEMBLY
(TYPE SFT)

NO SCALE

RSP A77S1 DATED NOVEMBER 15, 2013 SUPERSEDES RSP A77S1 DATED JULY 19, 2013 THAT SUPPLEMENTS THE STANDARD PLANS BOOK DATED 2010.

REVISED STANDARD PLAN RSP A77S1

2010 REVISED STANDARD PLAN RSP A77S1

Dist	COUNTY	ROUTE	POST MILES TOTAL PROJECT	SHEET No.	TOTAL SHEETS
07	LA	5	13.8/19.2	209	262

Randell D. Hiatt
REGISTERED CIVIL ENGINEER


November 15, 2013
PLANS APPROVAL DATE

THE STATE OF CALIFORNIA OR ITS OFFICERS OR AGENTS SHALL NOT BE RESPONSIBLE FOR THE ACCURACY OR COMPLETENESS OF SCANNED COPIES OF THIS PLAN SHEET.


REGISTERED PROFESSIONAL ENGINEER
Randell D. Hiatt
No. C50200
Exp. 6-30-15
CIVIL
STATE OF CALIFORNIA

TO ACCOMPANY PLANS DATED 2-1-16

NOTE:
See Revised Standard Plans RSP A77S1, RSP A77S2 and RSP A77T1 for typical use of anchor cable and anchor plate.

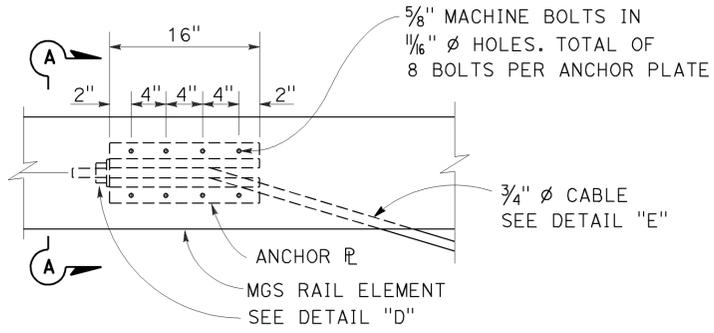


ANCHOR PLATE DETAIL
(MGS shown, TBB similar)

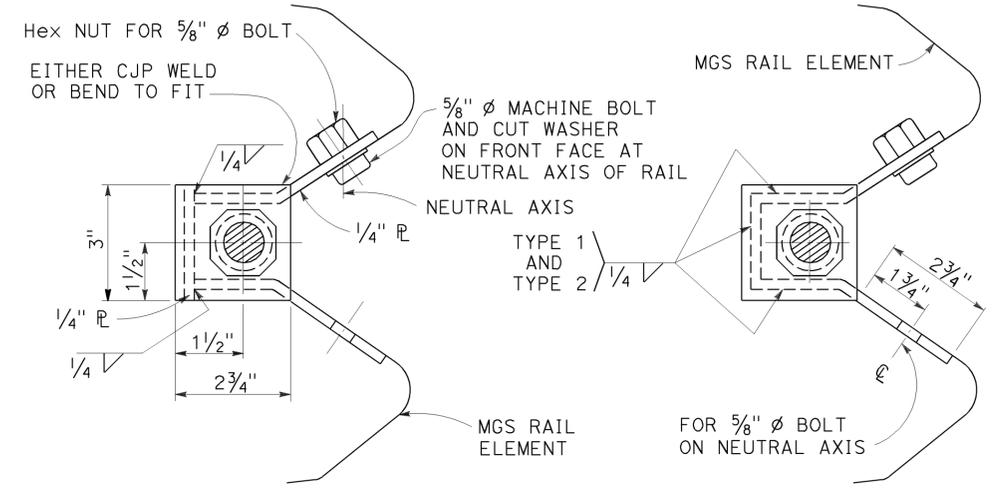


SECTION A-A (ALTERNATIVE TYPE 1)

SECTION A-A (ALTERNATIVE TYPE 2)

NOTE:
Dimensioning applies to both types.

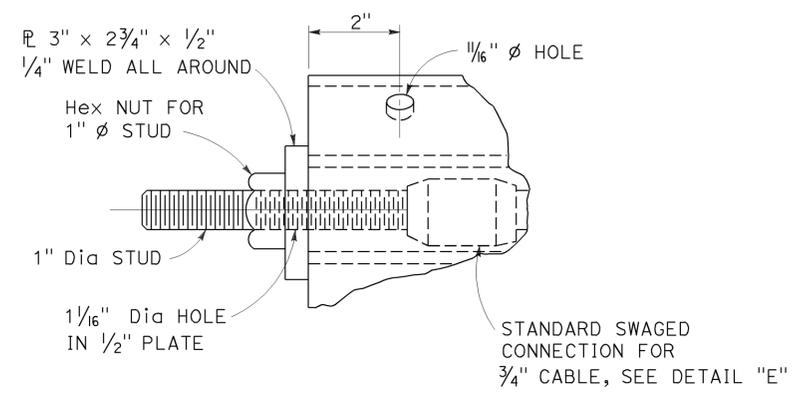

DETAIL "D"

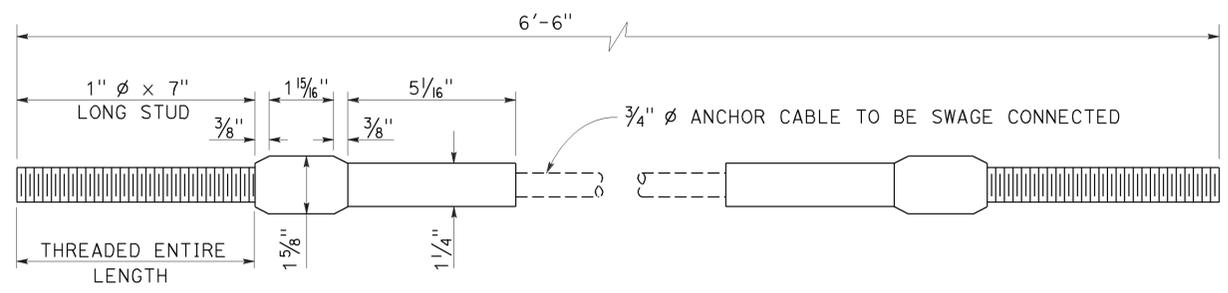

ANCHOR CABLE WITH SWAGED FITTING AND STUD
DETAIL "E"

STATE OF CALIFORNIA
DEPARTMENT OF TRANSPORTATION

**METAL RAILING
ANCHOR CABLE AND
ANCHOR PLATE DETAILS**

NO SCALE

RSP A77S3 DATED NOVEMBER 15, 2013 SUPERSEDES RSP A77S3 DATED JULY 19, 2013 THAT SUPPLEMENTS THE STANDARD PLANS BOOK DATED 2010.


2010 REVISED STANDARD PLAN RSP A77S3

Dist	COUNTY	ROUTE	POST MILES TOTAL PROJECT	SHEET No.	TOTAL SHEETS
07	LA	5	13.8/19.2	210	262


Randell D. Hiatt
REGISTERED CIVIL ENGINEER

November 15, 2013
PLANS APPROVAL DATE

THE STATE OF CALIFORNIA OR ITS OFFICERS OR AGENTS SHALL NOT BE RESPONSIBLE FOR THE ACCURACY OR COMPLETENESS OF SCANNED COPIES OF THIS PLAN SHEET.

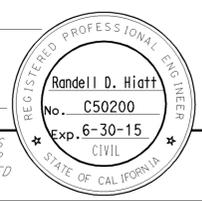


TO ACCOMPANY PLANS DATED 2-1-16

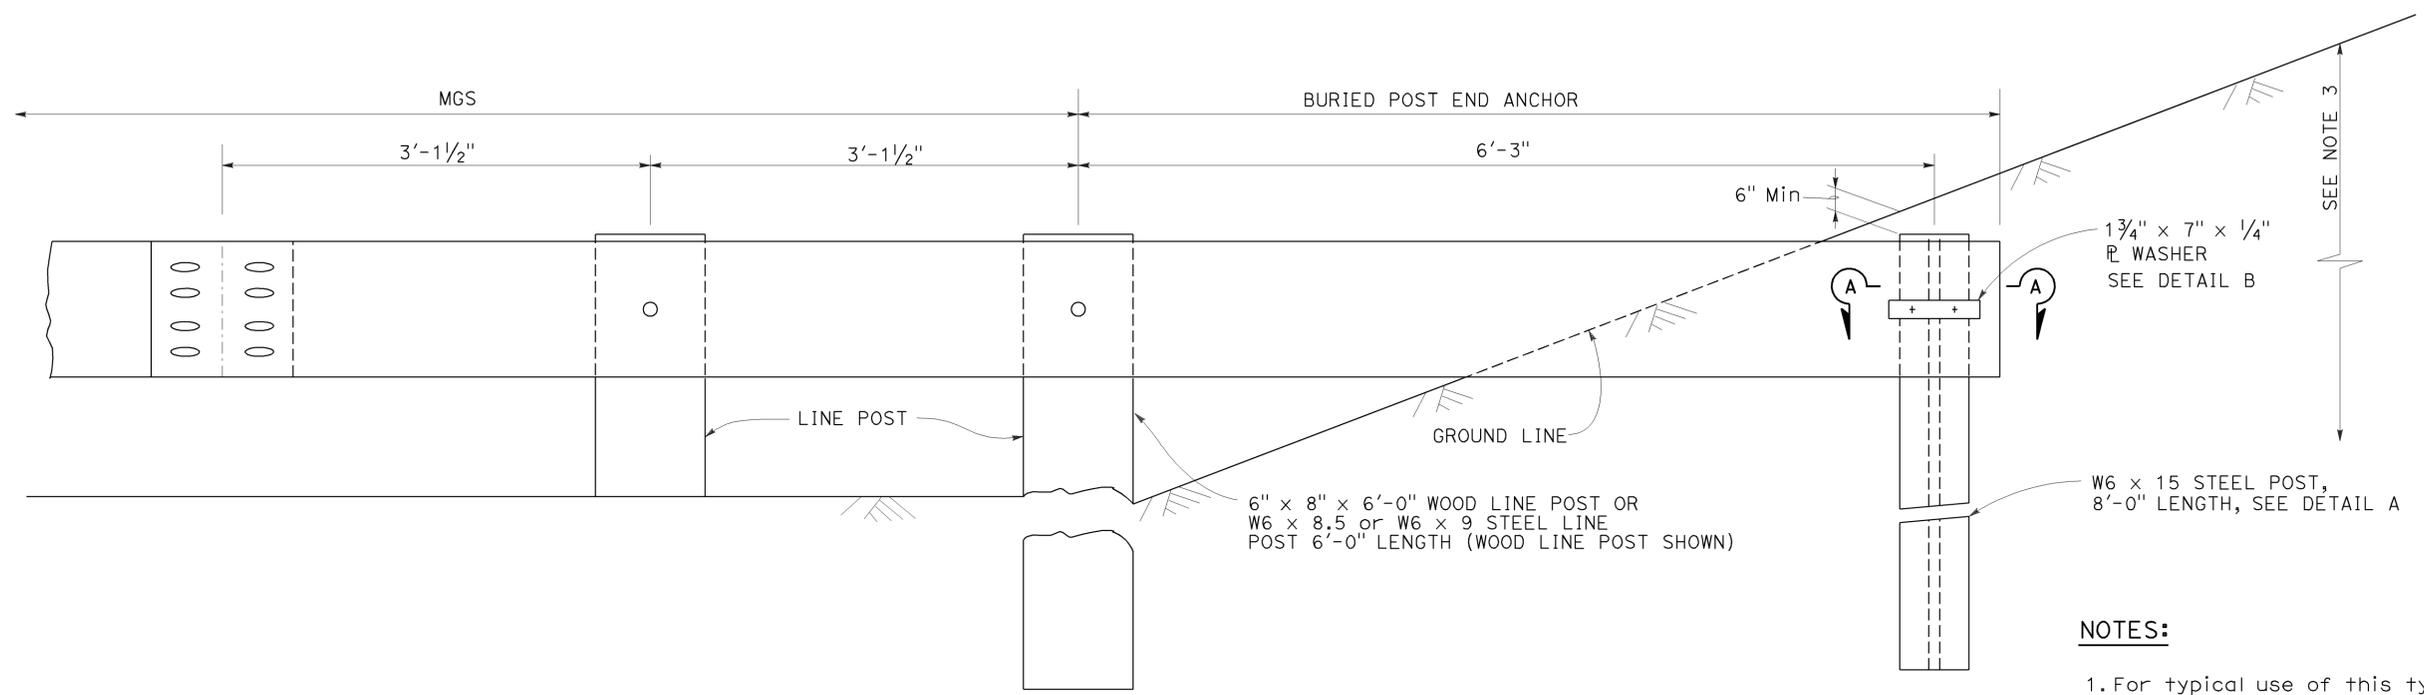


BURIED POST END ANCHOR
See Note 3

NOTES:


1. For typical use of this type of end anchor with MGS see the A77P, A77Q and A77R Series of the Standard Plans.
2. Holes excavation in the slope to construct the buried post end anchor shall be backfilled with selected earth, placed in layers approximately 1'-0" thick. Each layer shall be moistened and thoroughly compacted.
3. The buried post end anchor shall only be constructed at those locations where the slope perpendicular to the roadway is non-traversable.

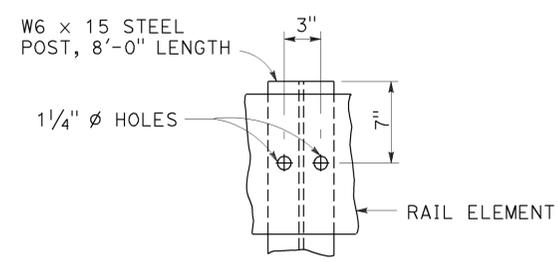

DETAIL A

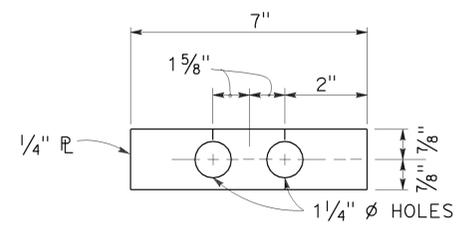

DETAIL B

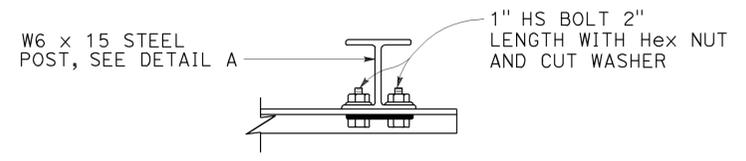

SECTION A-A

STATE OF CALIFORNIA
DEPARTMENT OF TRANSPORTATION
**MIDWEST GUARDRAIL SYSTEM
BURIED POST END ANCHOR**
NO SCALE

RSP A77T2 DATED NOVEMBER 15, 2013 SUPERSEDES RSP A77T2
DATED JULY 19, 2013 THAT SUPPLEMENTS THE STANDARD PLANS BOOK DATED 2010.

REVISED STANDARD PLAN RSP A77T2

2010 REVISED STANDARD PLAN RSP A77T2

Dist	COUNTY	ROUTE	POST MILES TOTAL PROJECT	SHEET No.	TOTAL SHEETS
07	LA	5	13.8/19.2	211	262



Randell D. Hiatt
REGISTERED CIVIL ENGINEER

July 19, 2013
PLANS APPROVAL DATE

THE STATE OF CALIFORNIA OR ITS OFFICERS OR AGENTS SHALL NOT BE RESPONSIBLE FOR THE ACCURACY OR COMPLETENESS OF SCANNED COPIES OF THIS PLAN SHEET.

REGISTERED PROFESSIONAL ENGINEER
Randell D. Hiatt
No. C50200
Exp. 6-30-15
CIVIL
STATE OF CALIFORNIA


TO ACCOMPANY PLANS DATED 2-1-16

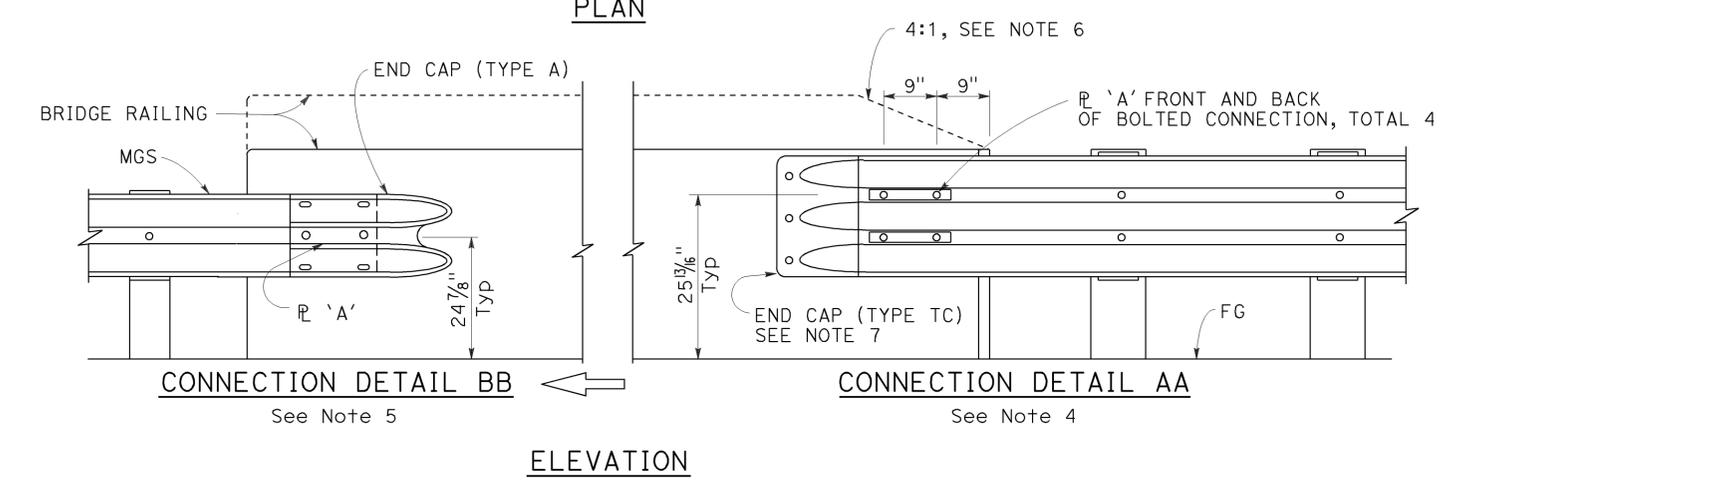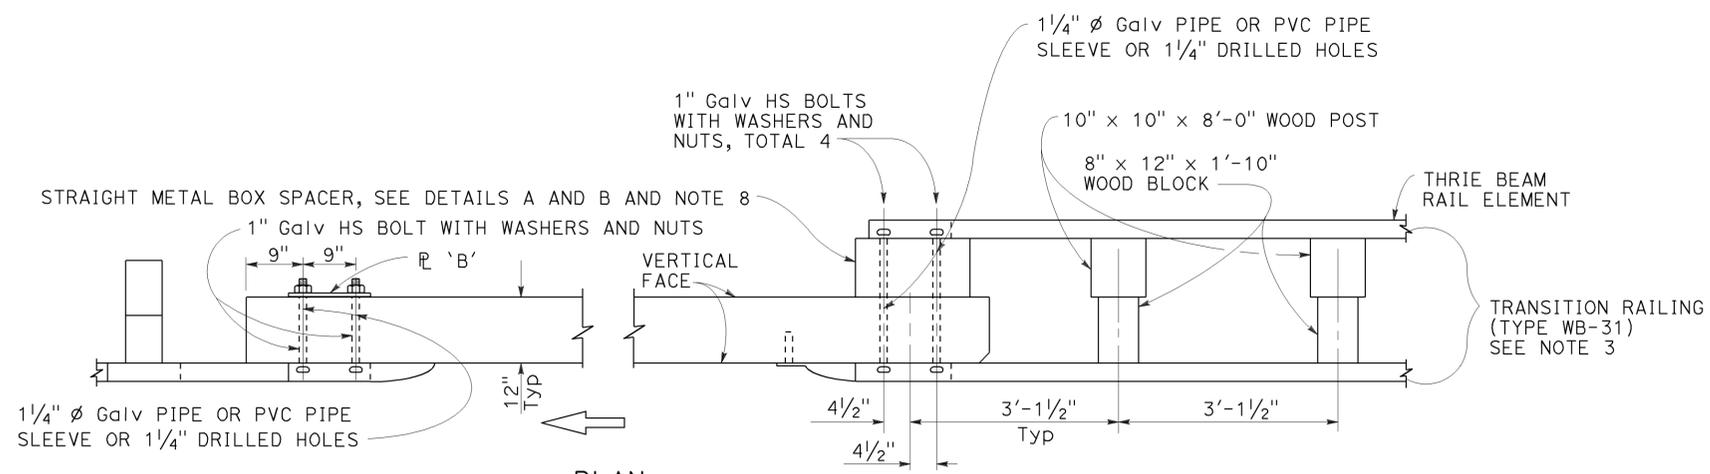

MIDWEST GUARDRAIL SYSTEM CONNECTION TO BRIDGE RAILING WITHOUT SIDEWALK

NOTES:

1. See Revised Standard Plan RSP A77U2 for additional connection details to bridges without sidewalks.
2. Additional details of posts, blocks and hardware are shown on Revised Standard Plans RSP A77M1, RSP A77N1 and RSP A77N2.
3. For additional details of Transition Railing (Type WB-31), see Revised Standard Plan RSP A77U4. Transition Railing (Type WB-31) transitions the 12 gauge MGS railing section to a heavier gage nested thrie beam railing section which is connected to the concrete bridge railing.
4. For typical use of Connection Detail AA, see Layout Types 12A and 12B on Revised Standard Plan RSP A77Q1, Layout Types 12C and 12D on Revised Standard Plan RSP A77Q2, and Layout Type 12E on Revised Standard Plan RSP A77Q3.
5. For typical use of Connection Detail BB, see Layout Type 12D (structure departure railing connection) on Revised Standard Plan RSP A77Q2 and Layout Type 12DD on Revised Standard Plan RSP A77Q5.
6. Where the height of the bridge railing exceeds the height of the thrie beam railing by more than 1" at Connection Detail AA, taper the top of the end of the bridge railing at 4:1 to match the top elevation of the thrie beam rail.
7. For details of End Cap (Type TC), see Revised Standard Plan RSP A77U4.
8. See Revised Standard Plan RSP A77U4 for additional details regarding depth dimension for straight metal box spacer.

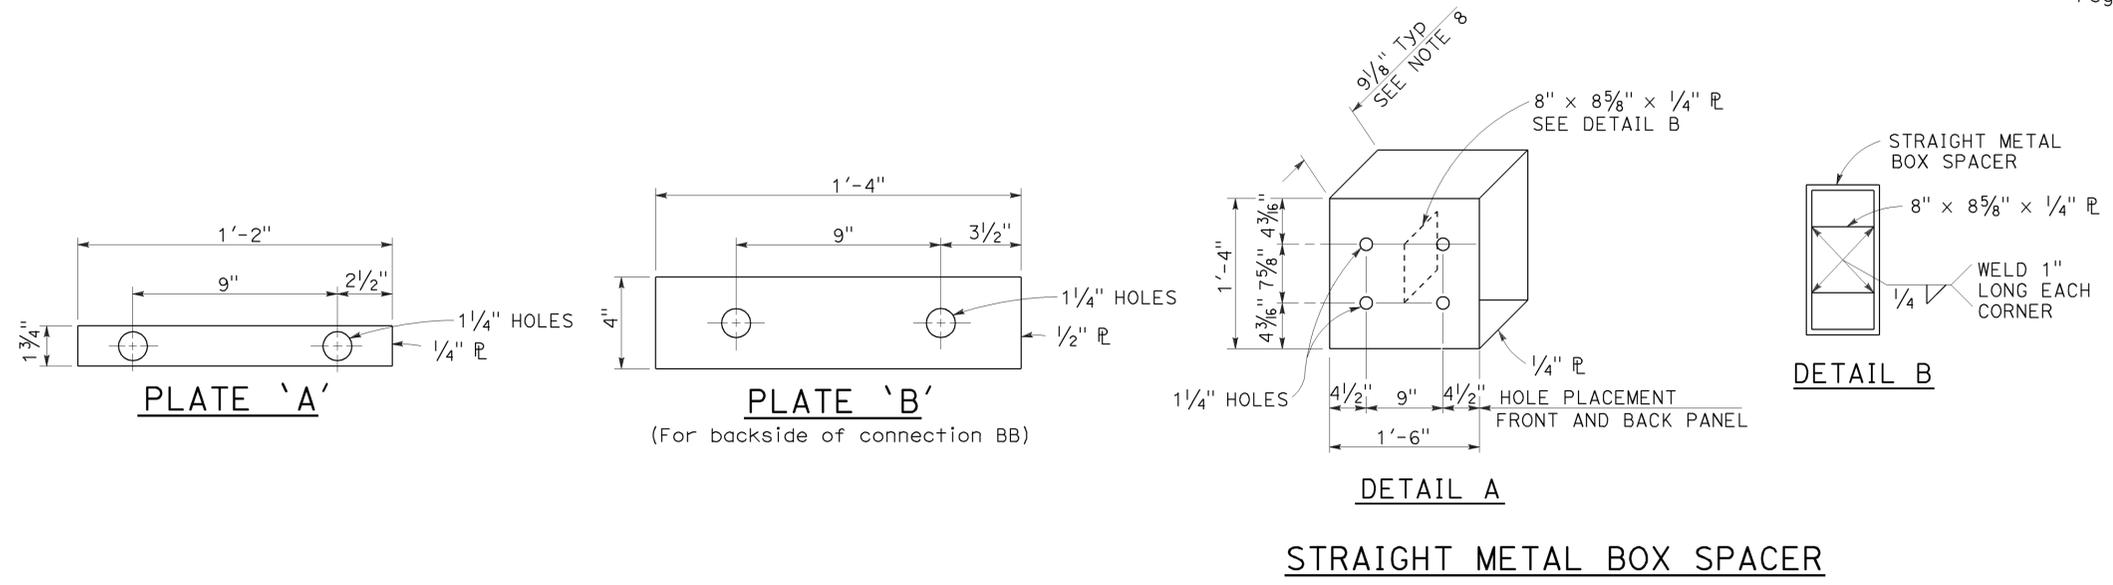

STATE OF CALIFORNIA
DEPARTMENT OF TRANSPORTATION
MIDWEST GUARDRAIL SYSTEM CONNECTIONS TO BRIDGE RAILINGS WITHOUT SIDEWALKS
DETAILS No. 1
NO SCALE

RSP A77U1 DATED JULY 19, 2013 SUPPLEMENTS THE STANDARD PLANS BOOK DATED 2010.

REVISED STANDARD PLAN RSP A77U1

2010 REVISED STANDARD PLAN RSP A77U1

Dist	COUNTY	ROUTE	POST MILES TOTAL PROJECT	SHEET No.	TOTAL SHEETS
07	LA	5	13.8/19.2	212	262



Randell D. Hiatt
REGISTERED CIVIL ENGINEER

July 19, 2013
PLANS APPROVAL DATE

THE STATE OF CALIFORNIA OR ITS OFFICERS OR AGENTS SHALL NOT BE RESPONSIBLE FOR THE ACCURACY OR COMPLETENESS OF SCANNED COPIES OF THIS PLAN SHEET.

REGISTERED PROFESSIONAL ENGINEER
No. C50200
Exp. 6-30-15
CIVIL
STATE OF CALIFORNIA




TO ACCOMPANY PLANS DATED 2-1-16

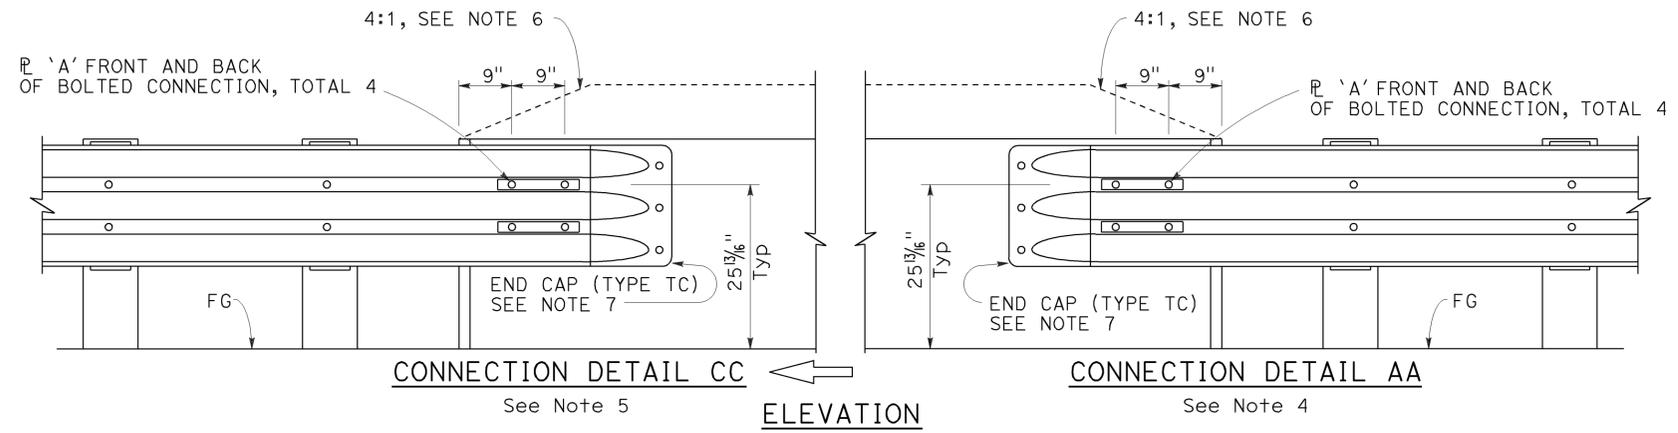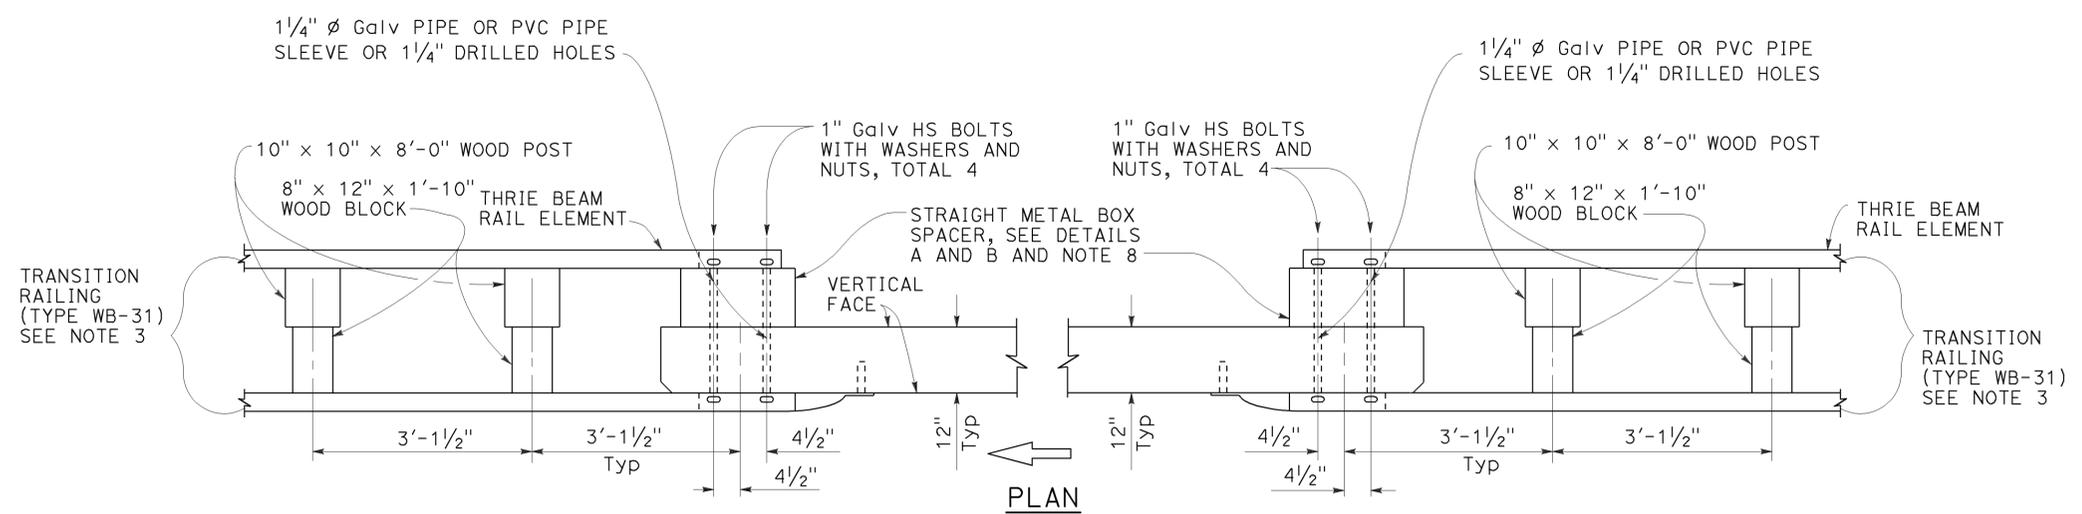

MIDWEST GUARDRAIL SYSTEM CONNECTION TO BRIDGE RAILING WITHOUT SIDEWALK

NOTES:

1. See Revised Standard Plan RSP A77U1 for additional connection details to bridges without sidewalks.
2. Additional details of posts, blocks and hardware are shown on Revised Standard Plans RSP A77M1, RSP A77N1 and RSP A77N2.
3. For additional details of Transition Railing (Type WB-31), see Revised Standard Plan RSP A77U4. Transition Railing (Type WB-31) transitions the 12 gauge MGS railing section to a heavier gage nested thrie beam railing section which is connected to the concrete bridge railing.
4. For typical use of Connection Detail AA, see Layout Types 12A and 12B on Revised Standard Plan RSP A77Q1, Layout Types 12C and 12D on Revised Standard Plan RSP A77Q2, and Layout Type 12E on Revised Standard Plan RSP A77Q3.
5. For typical use of Connection Detail CC, see Layout Types 12AA and 12BB on Revised Standard Plan RSP A77Q4 and Layout Type 12CC on Revised Standard Plan RSP A77Q5.
6. Where the height of the bridge railing exceeds the height of the thrie beam railing by more than 1" at Connection Detail AA and connection Detail CC, taper the top of the end of the bridge railing at 4:1 to match the top elevation of the thrie beam railing.
7. For details of End Cap (Type TC), see Revised Standard Plan RSP A77U4.
8. See Revised Standard Plan RSP A77U4 for additional details regarding depth dimension for straight metal box spacer.

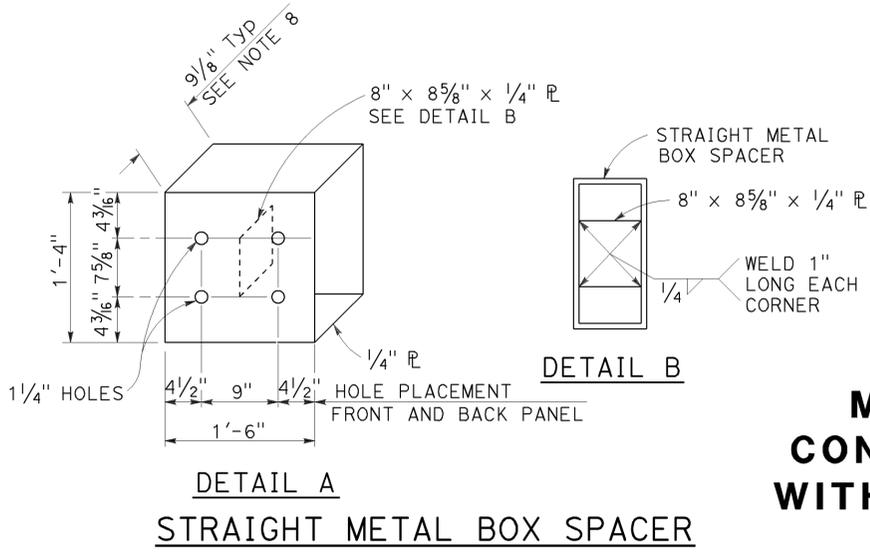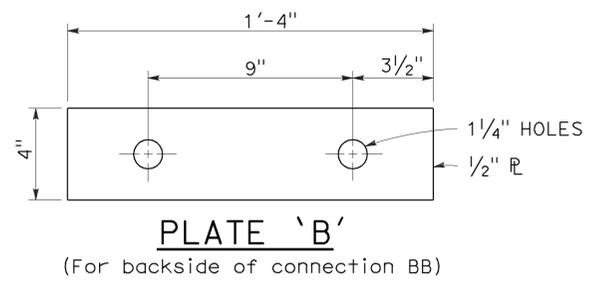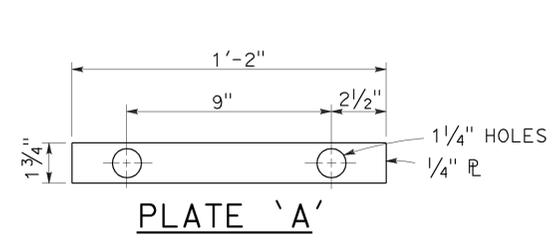

STATE OF CALIFORNIA
DEPARTMENT OF TRANSPORTATION

**MIDWEST GUARDRAIL SYSTEM
CONNECTIONS TO BRIDGE RAILINGS
WITHOUT SIDEWALKS DETAILS No. 2**


NO SCALE

2010 REVISED STANDARD PLAN RSP A77U2

Dist	COUNTY	ROUTE	POST MILES TOTAL PROJECT	SHEET No.	TOTAL SHEETS
07	LA	5	13.8/19.2	213	262

RANDALL D. HIATT
 REGISTERED CIVIL ENGINEER
 July 19, 2013
 PLANS APPROVAL DATE
 THE STATE OF CALIFORNIA OR ITS OFFICERS OR AGENTS SHALL NOT BE RESPONSIBLE FOR THE ACCURACY OR COMPLETENESS OF SCANNED COPIES OF THIS PLAN SHEET.




TO ACCOMPANY PLANS DATED 2-1-16

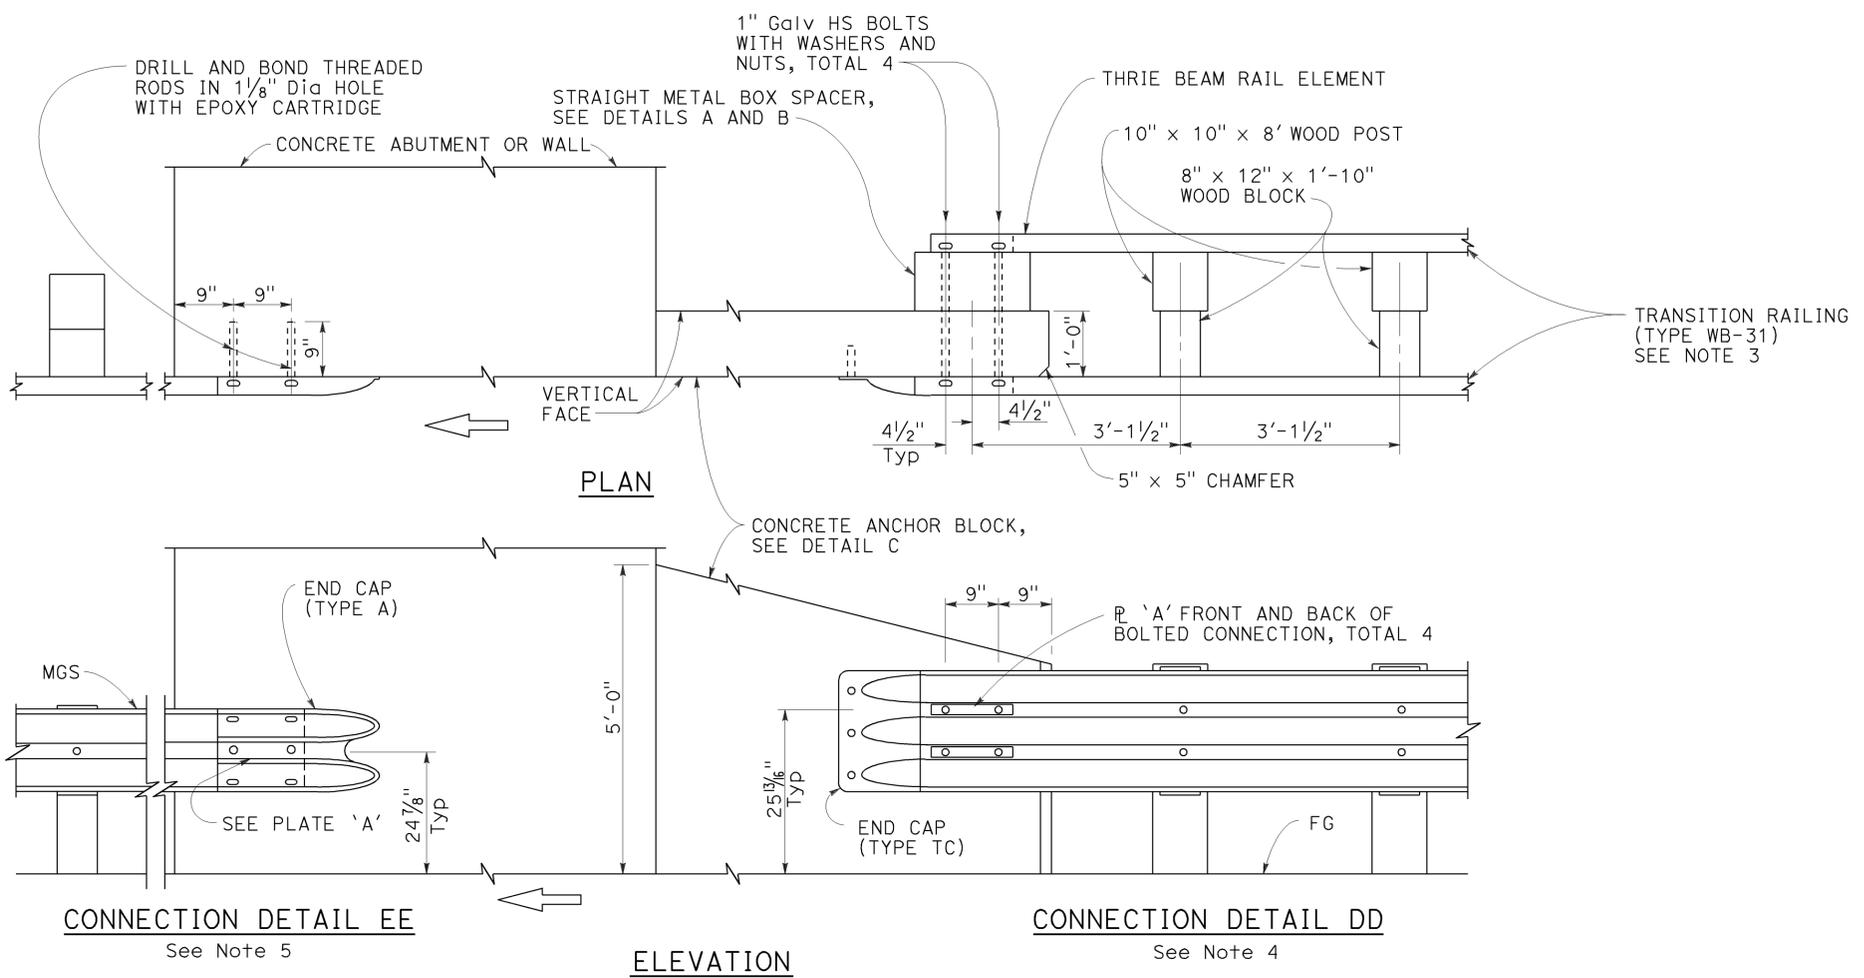

NOTES:

1. These connection details apply to abutments and walls.
2. Additional details of posts, blocks and hardware are shown on Revised Standard Plans RSP A77M1, RSP A77N1 and RSP A77N2.
3. For additional details of Transition Railing (Type WB-31), see Revised Standard Plan RSP A77U4. Transition Railing (Type WB-31) transitions the 12 gauge MGS railing section to a heavier gage nested thrie beam railing section which is connected to the concrete anchor block.
4. For typical use of Connection Details DD, see Layout Types 12A and 12B on Revised Standard Plan RSP A77Q1 and Layout Types 12C and 12D on Revised Standard Plan RSP A77Q2.
5. For typical use of Connection Detail EE, see Layout Type 12D on Revised Standard Plan RSP A77Q2 and Layout Type 12DD on Revised Standard Plan RSP A77Q5.

MIDWEST GUARDRAIL SYSTEM CONNECTION TO ABUTMENT OR WALL

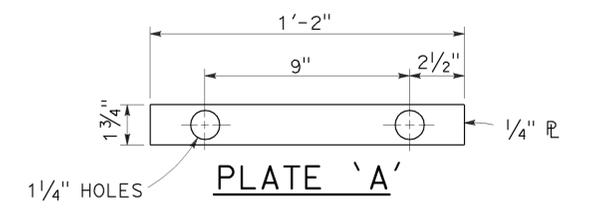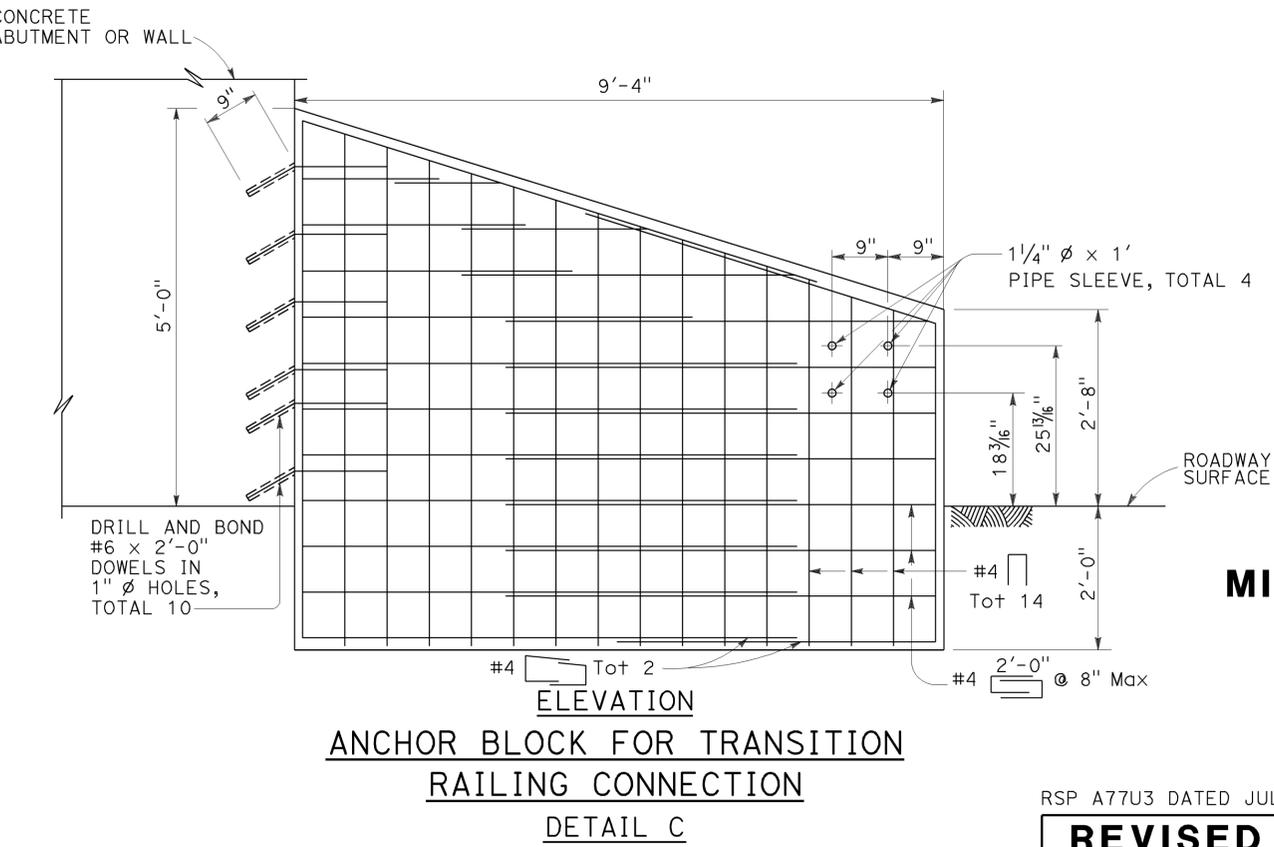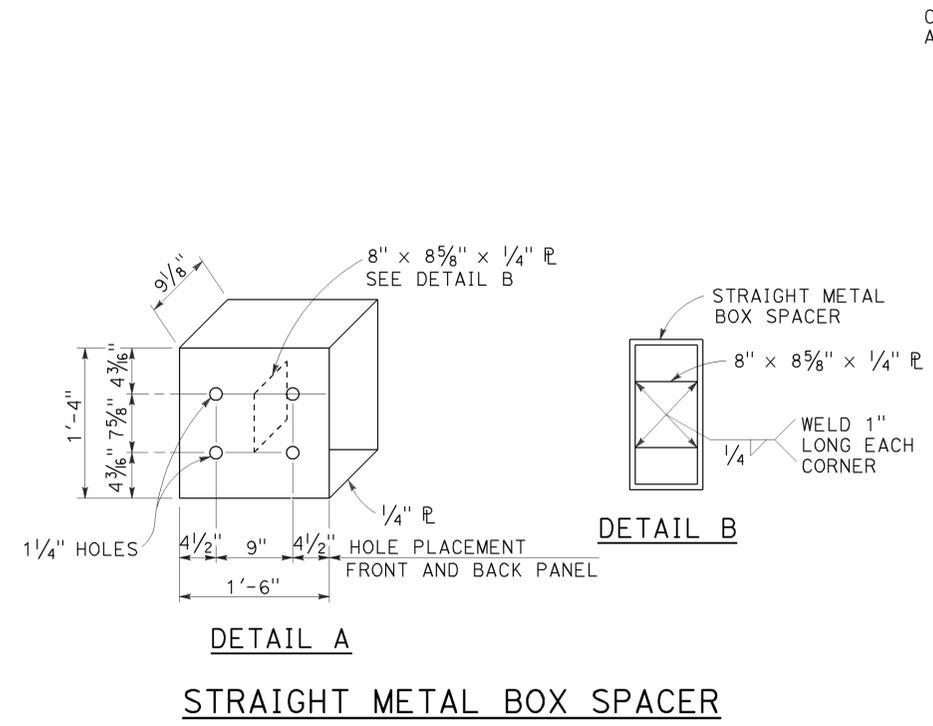

MIDWEST GUARDRAIL SYSTEM CONNECTIONS TO ABUTMENTS AND WALLS

NO SCALE

RSP A77U3 DATED JULY 19, 2013 SUPPLEMENTS THE STANDARD PLANS BOOK DATED 2010.

REVISED STANDARD PLAN RSP A77U3

2010 REVISED STANDARD PLAN RSP A77U3






Dist	COUNTY	ROUTE	POST MILES TOTAL PROJECT	SHEET No.	TOTAL SHEETS
07	LA	5	13.8/19.2	214	262

Randell D. Hiatt
REGISTERED CIVIL ENGINEER

January 23, 2015
PLANS APPROVAL DATE

THE STATE OF CALIFORNIA OR ITS OFFICERS OR AGENTS SHALL NOT BE RESPONSIBLE FOR THE ACCURACY OR COMPLETENESS OF SCANNED COPIES OF THIS PLAN SHEET.



REGISTERED PROFESSIONAL ENGINEER
No. C50200
Exp. 6-30-15
CIVIL
STATE OF CALIFORNIA

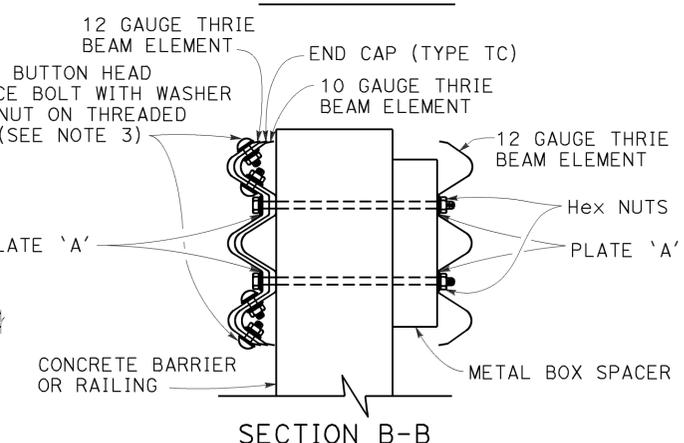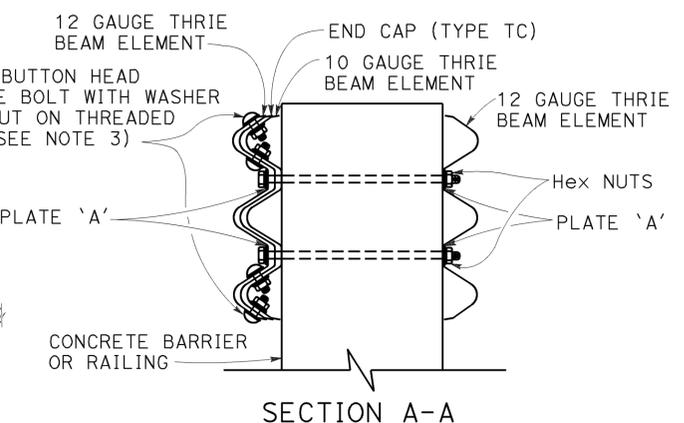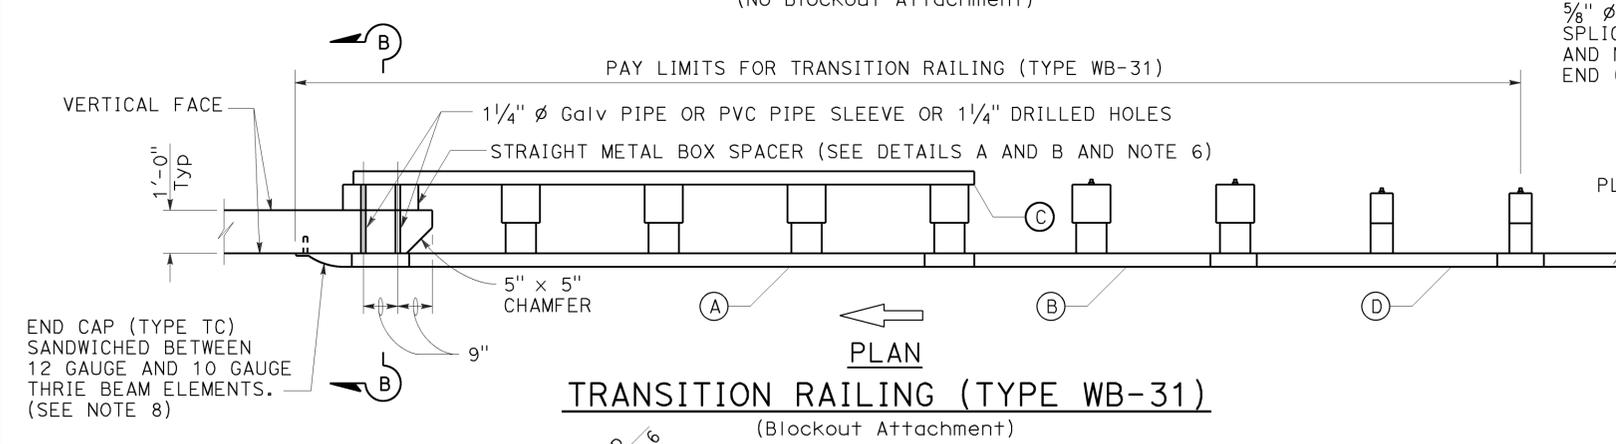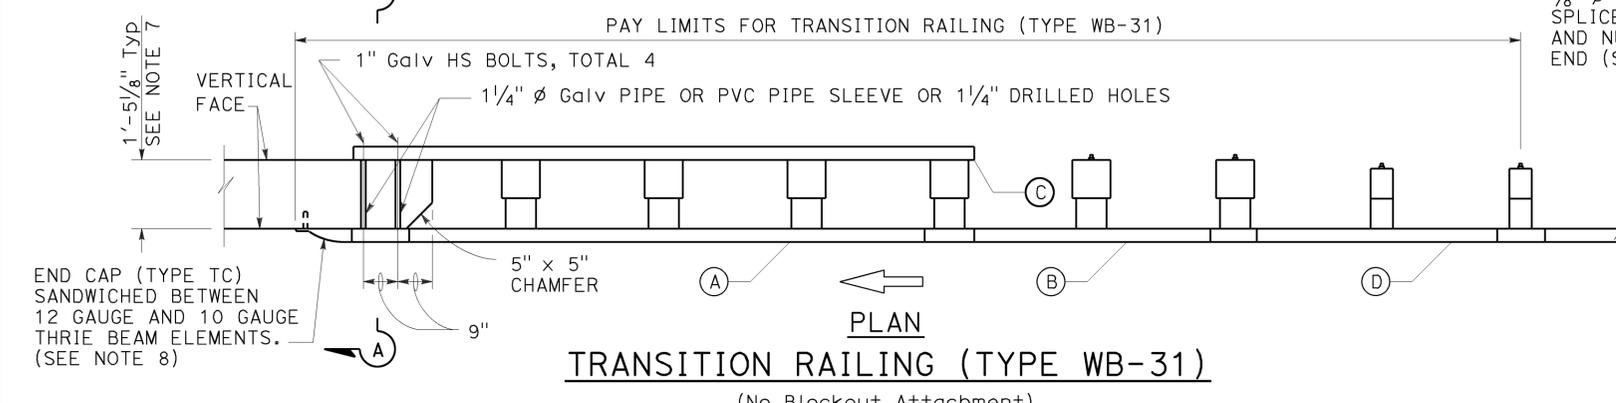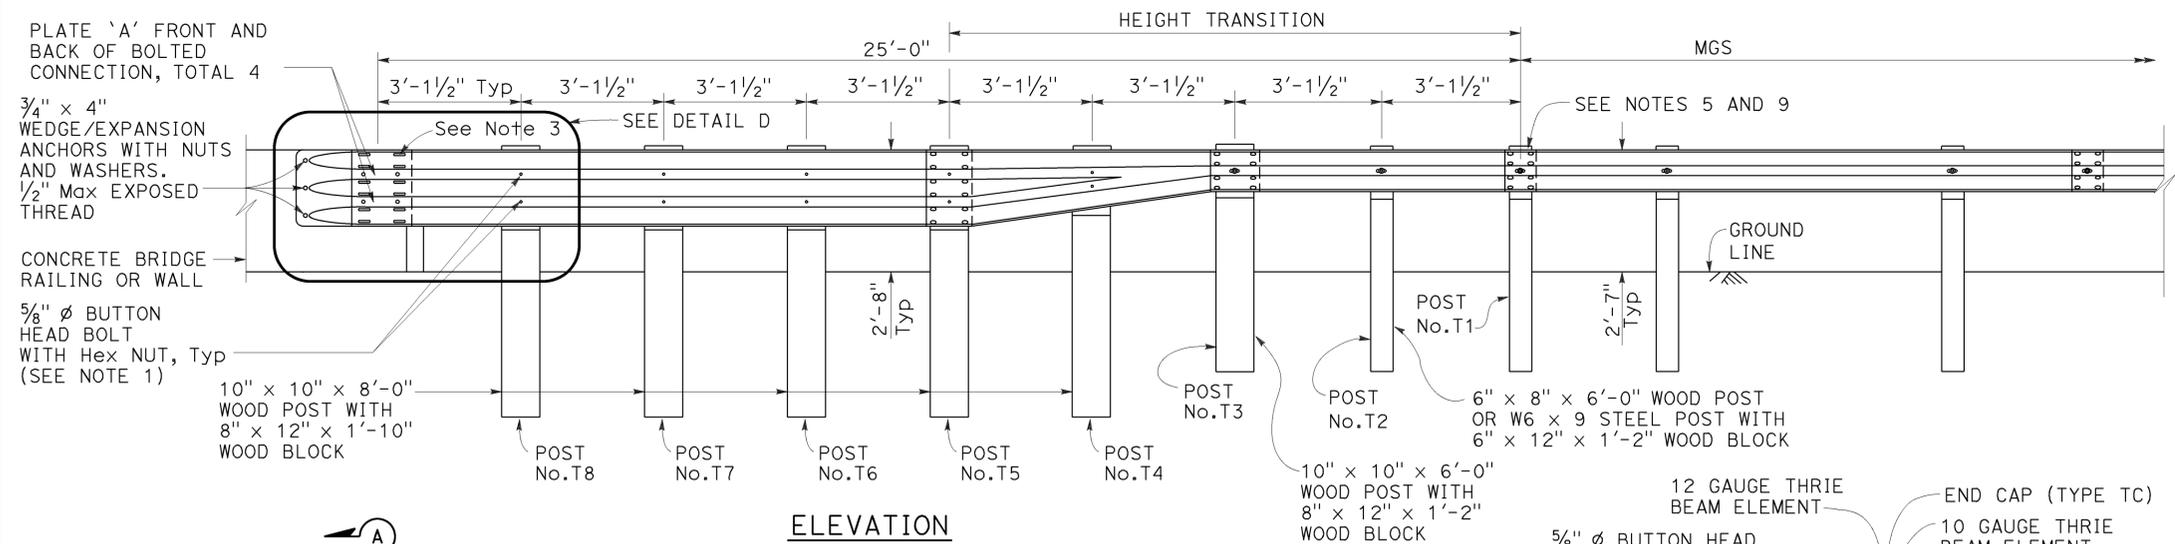

NOTES: TO ACCOMPANY PLANS DATED 2-1-16

- Use 5/8" Ø Button head bolts and hex nuts for connections to posts. No washer on rail face for bolted connections to post.
- The nested rail elements, end cap, and 'W' beam to thrie beam element may be spliced together prior to bolting the elements to the wood post and concrete barrier or railing.
- Exterior splice bolt holes for rail element splices at Post No. T5 and the connection to the concrete barrier or railing shall be the standard 29/32" x 1/8" slot size. Interior splice bolt holes at these locations may be increased up to 1/4" Ø. Only the top 4 and the bottom 4 splice bolts with washers and nuts are required for rail splices at Post No. T5 and the connection to the concrete barrier or railing.
- The top elevation of Posts No. T2 through No. T7 shall not project more than 1" above the top elevation of the rail element.
- Typically, the railing connected to Transition Railing (Type WB-31) will be either standard railing section of MGS with height transition ratio of 150:1 or a Caltrans approved 31" end treatment attached to Post No. T1.
- The depth of the metal box spacer varies from the 9/8" to 1/2" and is dependent on the width of the concrete railing or wall. The combined dimension for the depth of the metal box spacer plus the width of railing or wall is typically 21 1/8". Where the space between the backside of the concrete railing or wall and the rear thrie beam element is less than 1 1/2", metal plates similar to Plate 'A' are to be used as spacers.
- Where the width of the concrete railing or wall is greater than 17 1/8", wood blocks are to be used to fill the space created between the backside of Posts No. T5 through No. T8 and the rear thrie beam element. These wood blocks shall be 8" in width and 1'-2" in length. The dimension between the front thrie beam element and the rear thrie beam element is to match the width of the concrete railing or wall.
- End cap may be installed over 12 gauge and 10 gauge thrie beam elements where transition railing is installed on the departure end of bridge railing.
- Conform standard railing section height to 31" at Post No. T1 using height transition ratio of 150:1.

- LEGEND:**
- (A) NESTED THRIE BEAM ELEMENTS (ONE 12 GAUGE ELEMENT NESTED OVER ONE 10 GAUGE ELEMENT).
 - (B) ONE ASYMMETRICAL 10 GAUGE "W" BEAM TO THRIE BEAM ELEMENT.
 - (C) ONE 12 GAUGE THRIE BEAM ELEMENT.
 - (D) ONE 10 GAUGE "W" BEAM RAIL ELEMENT (7'-3 1/2" LENGTH)
- 10 GAUGE = 0.138" THICK
12 GAUGE = 0.108" THICK

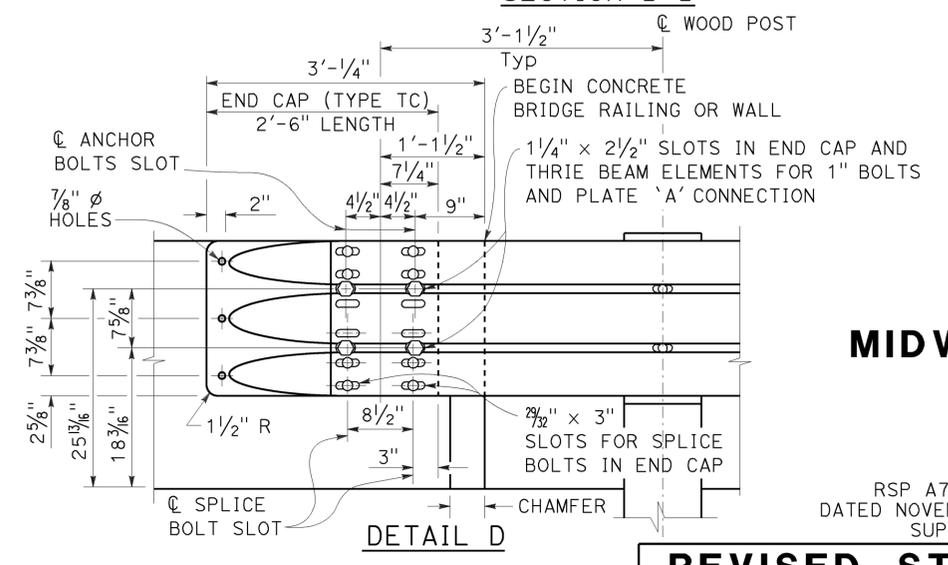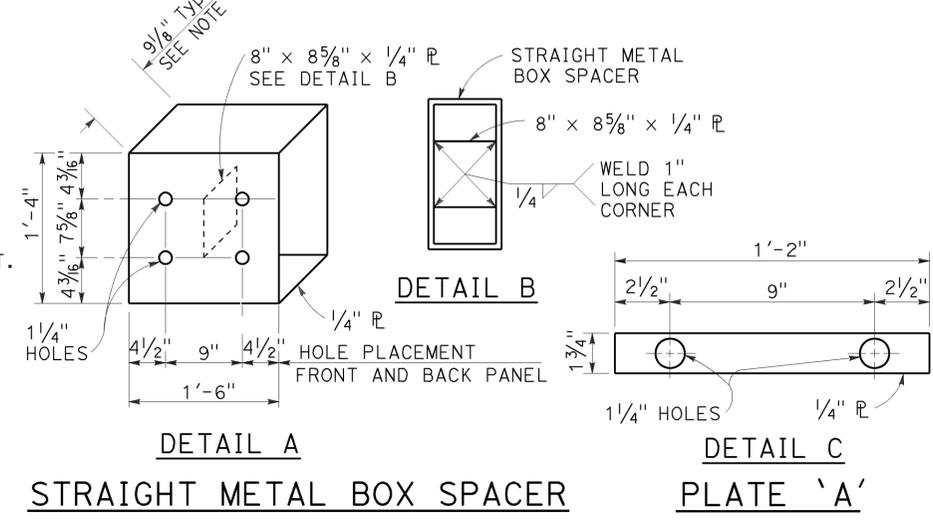

STATE OF CALIFORNIA
DEPARTMENT OF TRANSPORTATION

**MIDWEST GUARDRAIL SYSTEM
TRANSITION RAILING
(TYPE WB-31)**

NO SCALE

RSP A77U4 DATED JANUARY 23, 2015 SUPERSEDES RSP A77U4 DATED NOVEMBER 15, 2013 AND RSP A77U4 DATED JULY 19, 2013 THAT SUPPLEMENTS THE STANDARD PLANS BOOK DATED 2010.

REVISED STANDARD PLAN RSP A77U4

2010 REVISED STANDARD PLAN RSP A77U4

Dist	COUNTY	ROUTE	POST MILES TOTAL PROJECT	SHEET No.	TOTAL SHEETS
07	LA	5	13.8/19.2	216	262

Randell D. Hiatt
REGISTERED CIVIL ENGINEER

July 19, 2013
PLANS APPROVAL DATE









THE STATE OF CALIFORNIA OR ITS OFFICERS OR AGENTS SHALL NOT BE RESPONSIBLE FOR THE ACCURACY OR COMPLETENESS OF SCANNED COPIES OF THIS PLAN SHEET.

REGISTERED PROFESSIONAL ENGINEER
Randell D. Hiatt
No. C50200
Exp. 6-30-15
CIVIL
STATE OF CALIFORNIA

TO ACCOMPANY PLANS DATED 2-1-16

NOTES:

1. All holes in steel post to be $\frac{13}{16}$ " Dia maximum. Holes in wood posts and wood blocks to be $\frac{3}{4}$ " Dia $\pm \frac{1}{16}$ ".
2. Dimensions shown for wood post are nominal.
3. For use with W6 x 8.5 or W6 x 9 steel post.
4. For use with W6 x 15 steel post.
5. Notched face of block faces steel post.

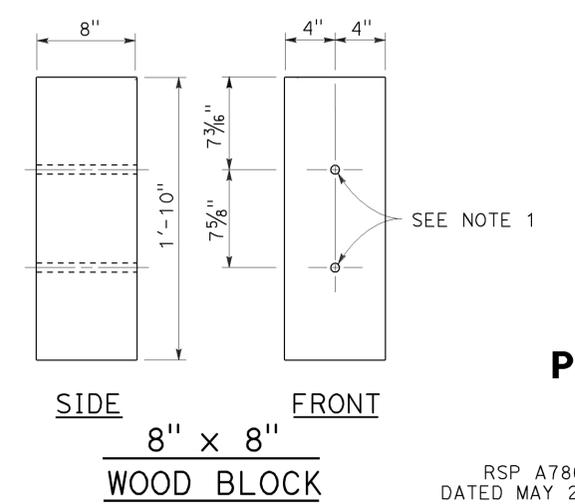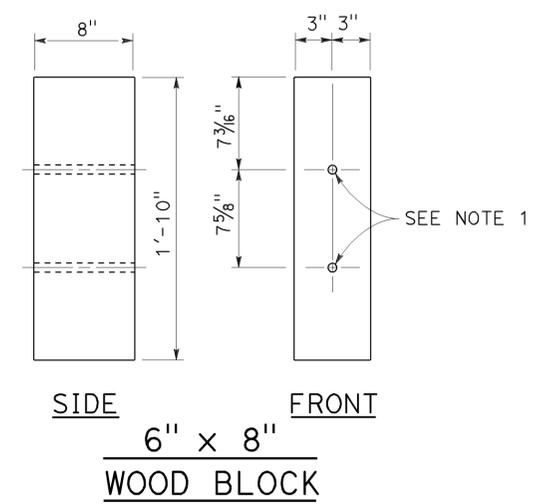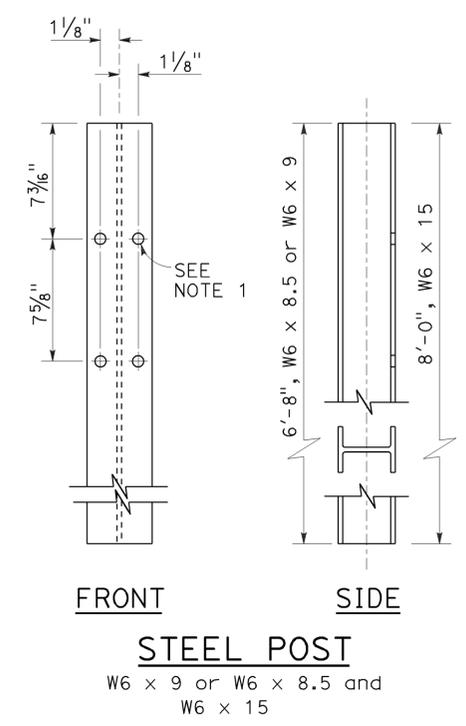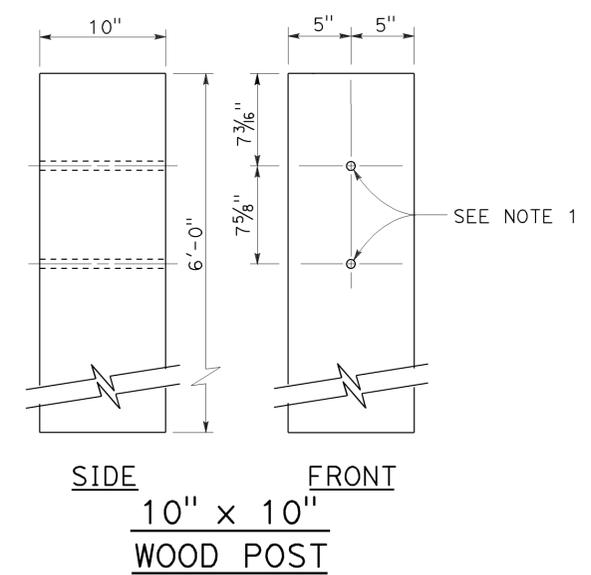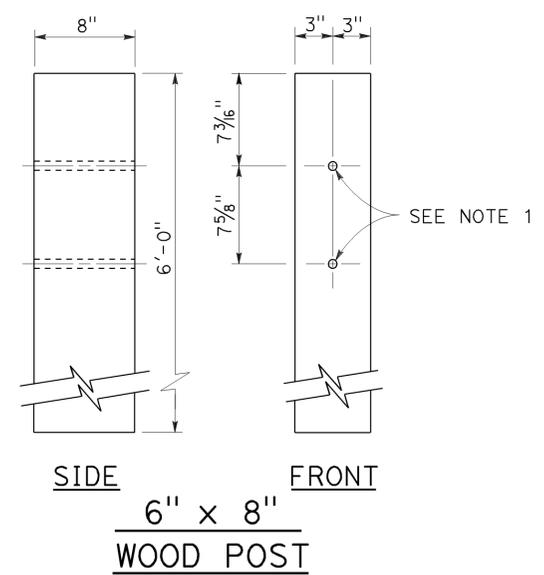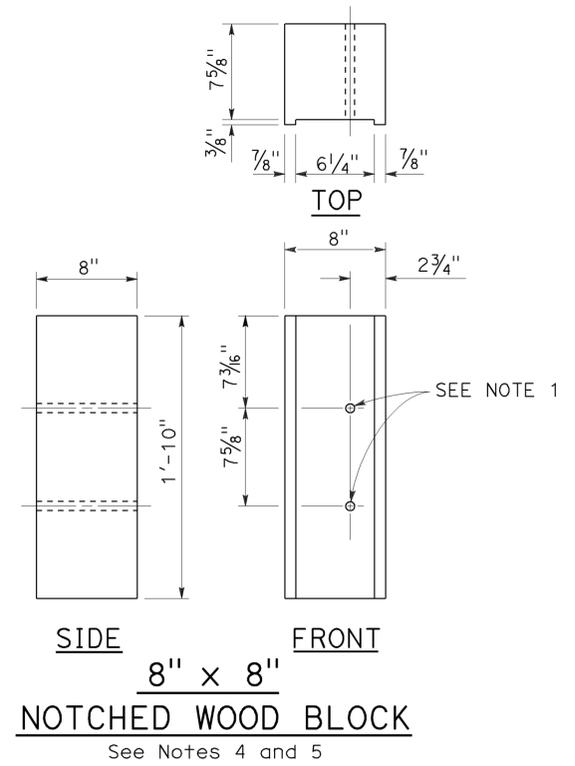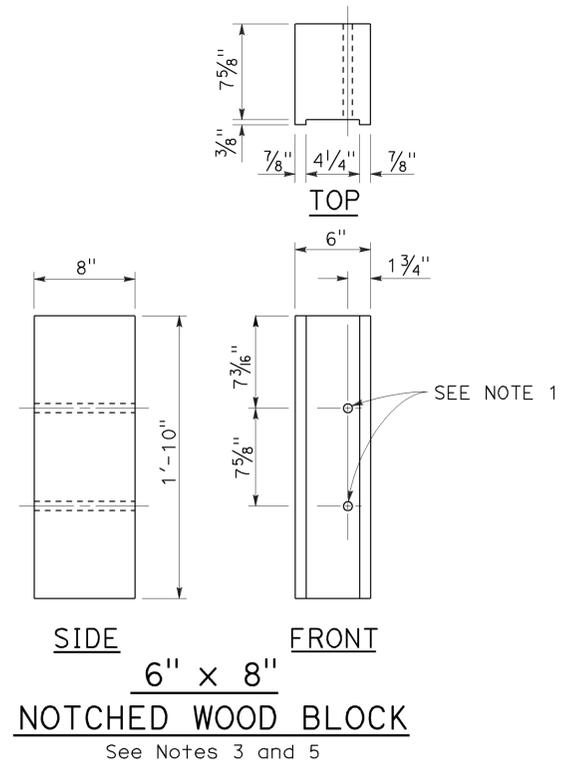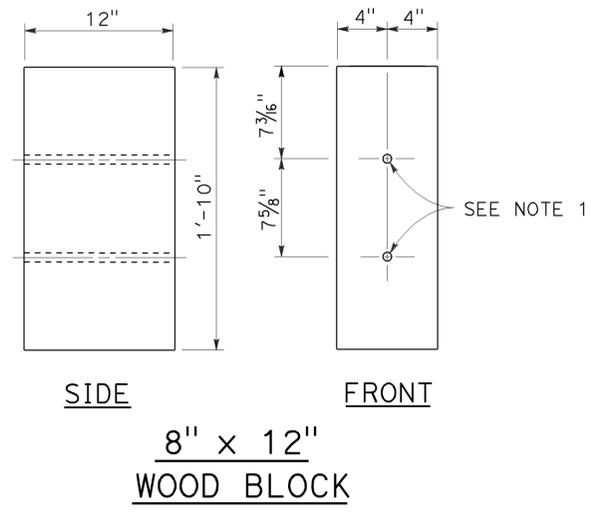

STATE OF CALIFORNIA
DEPARTMENT OF TRANSPORTATION

**THRIE BEAM BARRIER
POST AND BLOCK DETAILS**

NO SCALE

RSP A78C2 DATED JULY 19, 2013 SUPERSEDES STANDARD PLAN A78C2
DATED MAY 20, 2011 - PAGE 92 OF THE STANDARD PLANS BOOK DATED 2010.

2010 REVISED STANDARD PLAN RSP A78C2

Dist	COUNTY	ROUTE	POST MILES TOTAL PROJECT	SHEET No.	TOTAL SHEETS
07	LA	5	13.8/19.2	217	262


Randell D. Hiatt
REGISTERED CIVIL ENGINEER

July 19, 2013
PLANS APPROVAL DATE

THE STATE OF CALIFORNIA OR ITS OFFICERS OR AGENTS SHALL NOT BE RESPONSIBLE FOR THE ACCURACY OR COMPLETENESS OF SCANNED COPIES OF THIS PLAN SHEET.

REGISTERED PROFESSIONAL ENGINEER
No. C50200
Exp. 6-30-15
CIVIL
STATE OF CALIFORNIA


TO ACCOMPANY PLANS DATED 2-1-16

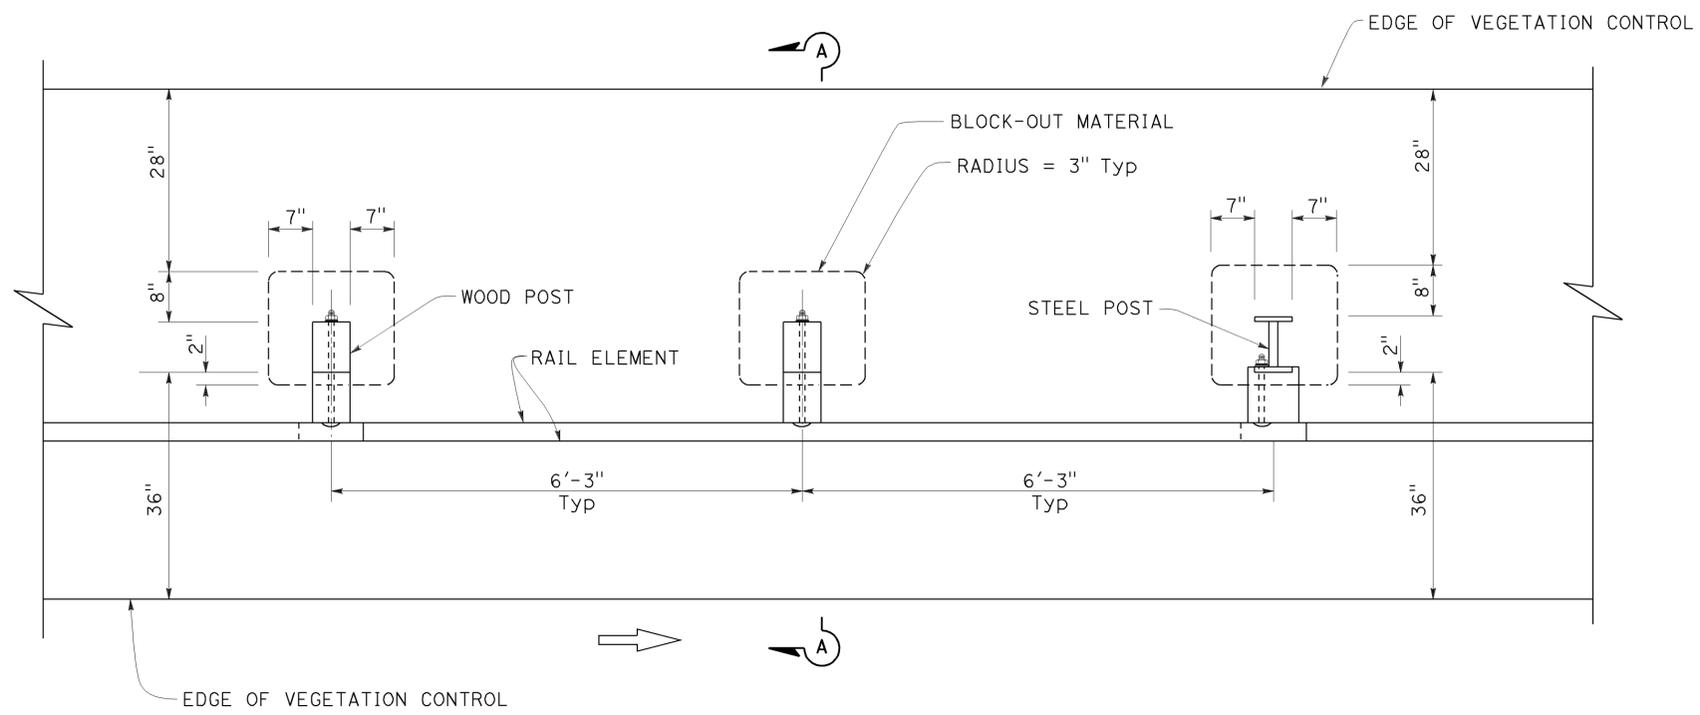

PLAN

NOTES:

1. Where the distance between back of post and hinge point is less than 42", construct vegetation control to 6" from hinge point while maintaining the 8" block-out at back of post. If the 8" block-out at back of post can not be maintained, construct vegetation control flush with the back edge of post.
2. Where dike is constructed under barrier, construct vegetation control to back edge of dike. Where paved shoulder is constructed within 36" in front of the post, construct vegetation control to the edge of paved shoulder.
3. For wood and steel post sizes, see Revised Standard Plan RSP A77N2.
4. For details not shown, see Standard Plan A78B and Revised Standard Plan RSP A78A.

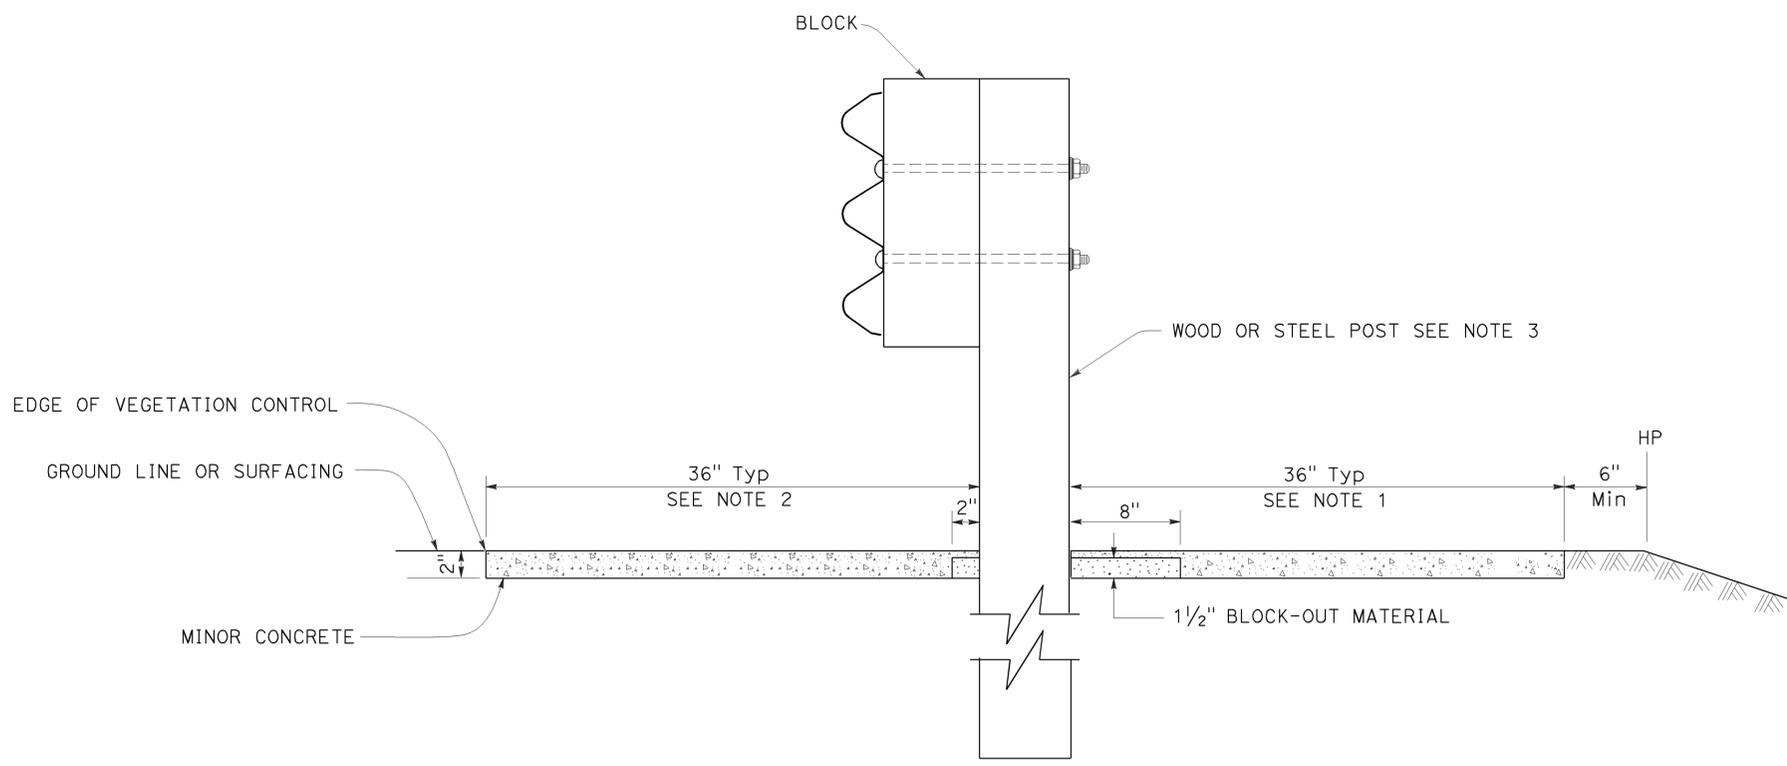

SECTION A-A

STATE OF CALIFORNIA
DEPARTMENT OF TRANSPORTATION

**SINGLE THRIE BEAM BARRIER
TYPICAL VEGETATION CONTROL
STANDARD BARRIER RAILING SECTION**

NO SCALE

RSP A78C3 DATED JULY 19, 2013 SUPERSEDES STANDARD PLAN A78C3
DATED MAY 20, 2011 - PAGE 93 OF THE STANDARD PLANS BOOK DATED 2010.

REVISED STANDARD PLAN RSP A78C3

2010 REVISED STANDARD PLAN RSP A78C3

Dist	COUNTY	ROUTE	POST MILES TOTAL PROJECT	SHEET No.	TOTAL SHEETS
07	LA	5	13.8/19.2	218	262


Randell D. Hiatt
REGISTERED CIVIL ENGINEER

October 19, 2012
PLANS APPROVAL DATE


Randell D. Hiatt
No. C50200
Exp. 6-30-13
CIVIL
STATE OF CALIFORNIA

THE STATE OF CALIFORNIA OR ITS OFFICERS OR AGENTS SHALL NOT BE RESPONSIBLE FOR THE ACCURACY OR COMPLETENESS OF SCANNED COPIES OF THIS PLAN SHEET.

TO ACCOMPANY PLANS DATED 2-1-16

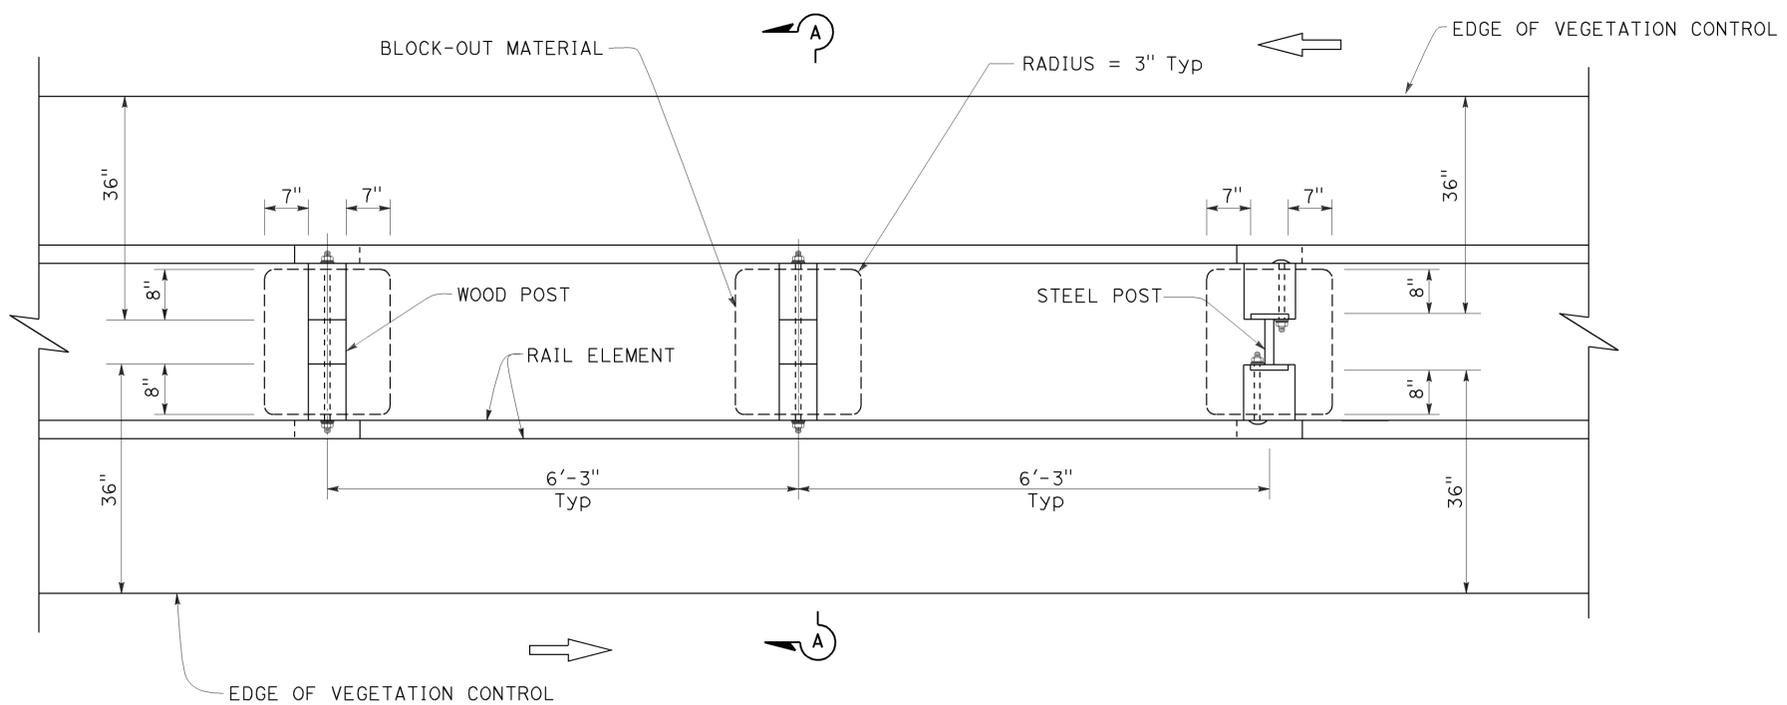

PLAN

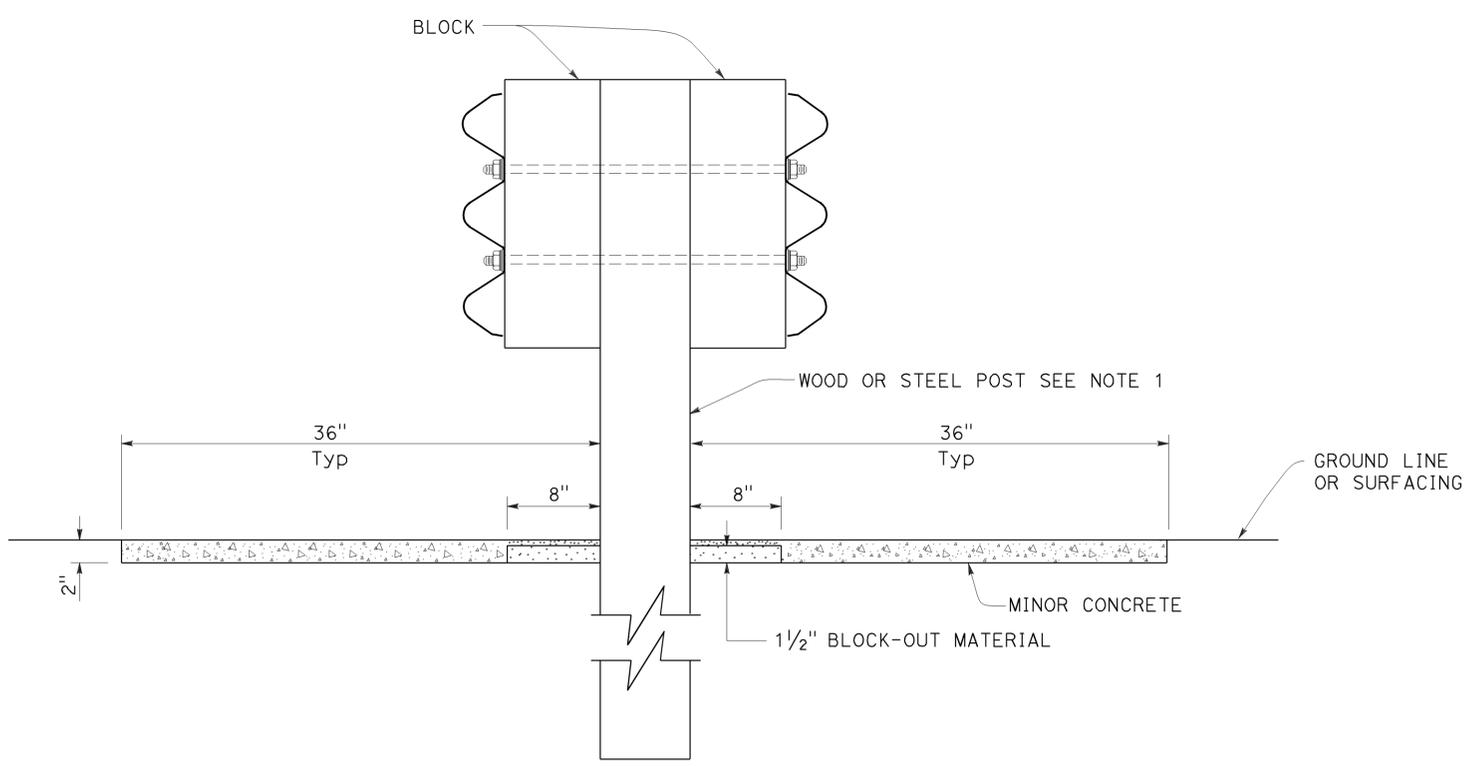

SECTION A-A

NOTES:

1. For wood and steel post sizes, see Standard Plan A78C2.
2. For details not shown, see Standard Plans A78A and A78B.

STATE OF CALIFORNIA
DEPARTMENT OF TRANSPORTATION

**DOUBLE THRIE BEAM BARRIER
TYPICAL VEGETATION CONTROL
STANDARD BARRIER RAILING SECTION**

NO SCALE

RSP A78C4 DATED OCTOBER 19, 2012 SUPERSEDES STANDARD PLAN A78C4
DATED MAY 20, 2011 - PAGE 94 OF THE STANDARD PLANS BOOK DATED 2010.

REVISED STANDARD PLAN RSP A78C4

2010 REVISED STANDARD PLAN RSP A78C4

Dist	COUNTY	ROUTE	POST MILES TOTAL PROJECT	SHEET No.	TOTAL SHEETS
07	LA	5	13.8/19.2	220	262


Randell D. Hiatt
REGISTERED CIVIL ENGINEER

October 19, 2012
PLANS APPROVAL DATE

THE STATE OF CALIFORNIA OR ITS OFFICERS OR AGENTS SHALL NOT BE RESPONSIBLE FOR THE ACCURACY OR COMPLETENESS OF SCANNED COPIES OF THIS PLAN SHEET.

REGISTERED PROFESSIONAL ENGINEER
Randell D. Hiatt
No. C50200
Exp. 6-30-13
CIVIL
STATE OF CALIFORNIA


TO ACCOMPANY PLANS DATED 2-1-16

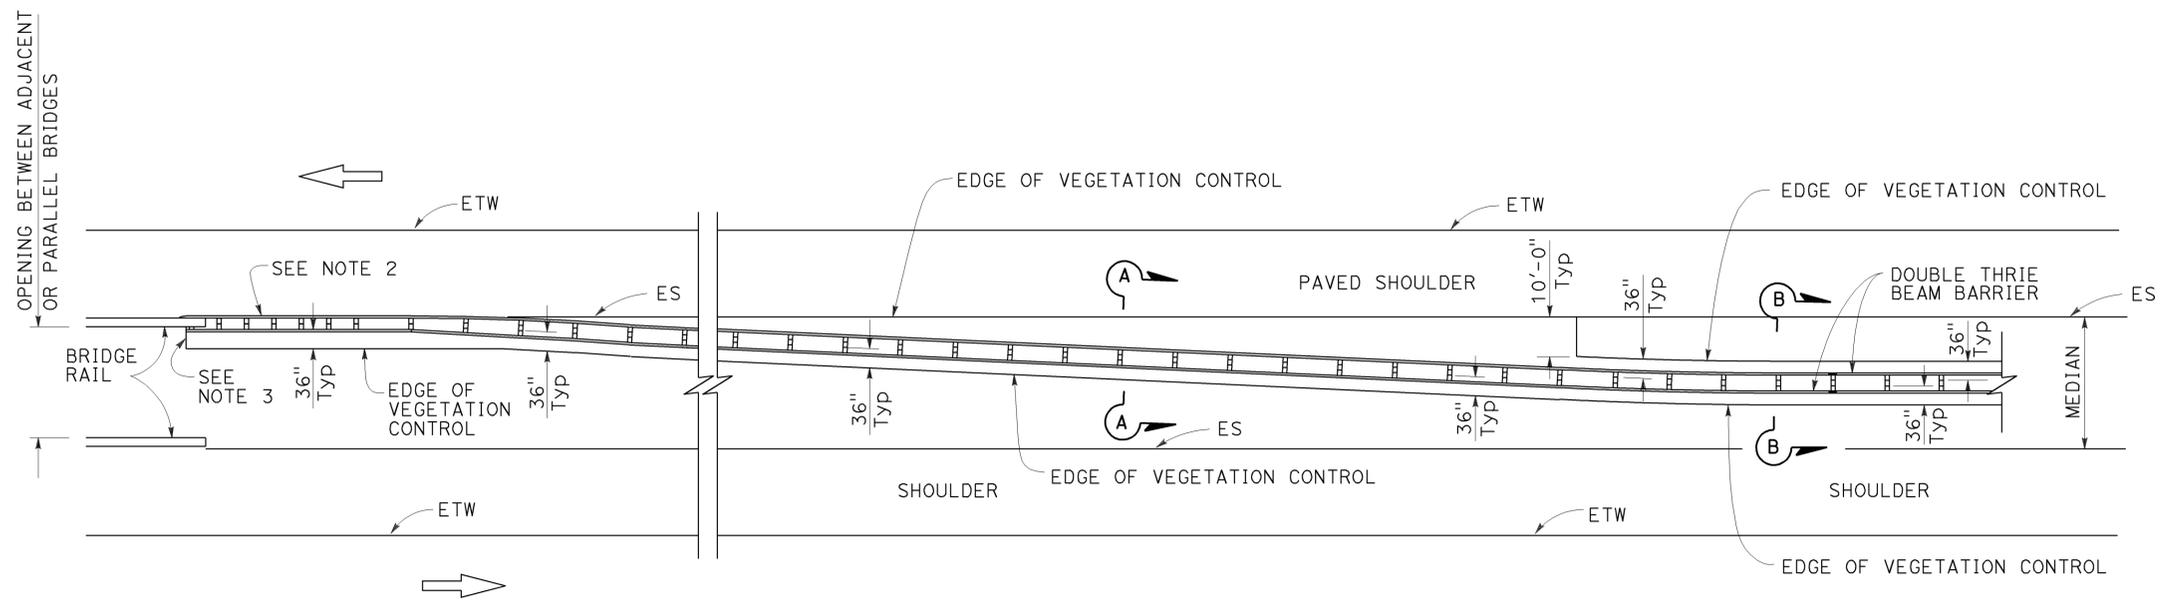


PLAN

NOTES:

1. See Revised Standard Plan RSP A78C4 for additional vegetation control details.
2. Where dike is constructed under barrier, construct vegetation control to back edge of dike. Where paved shoulder is constructed within 36" in front of the post, construct vegetation control to the edge of paved shoulder.
3. End vegetation control at end of backside rail element attached to bridge railing.

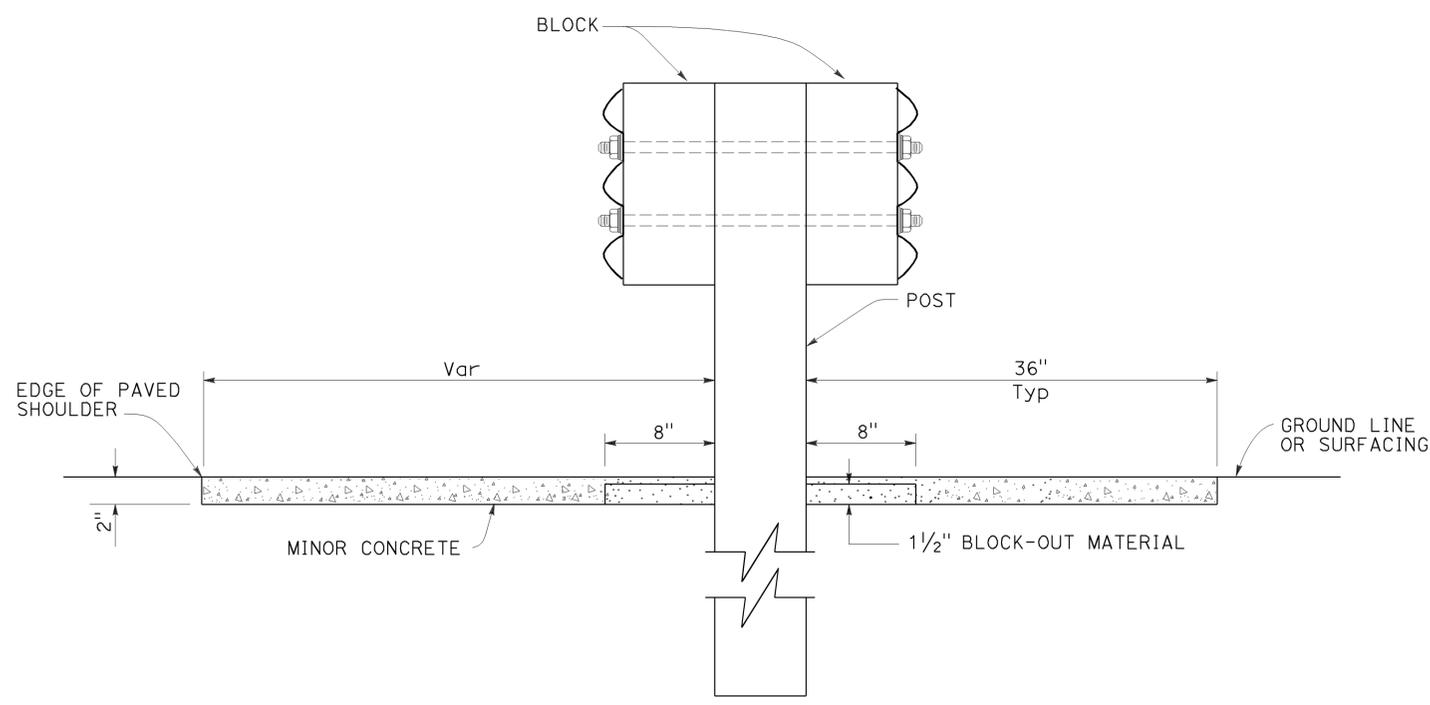

SECTION A-A

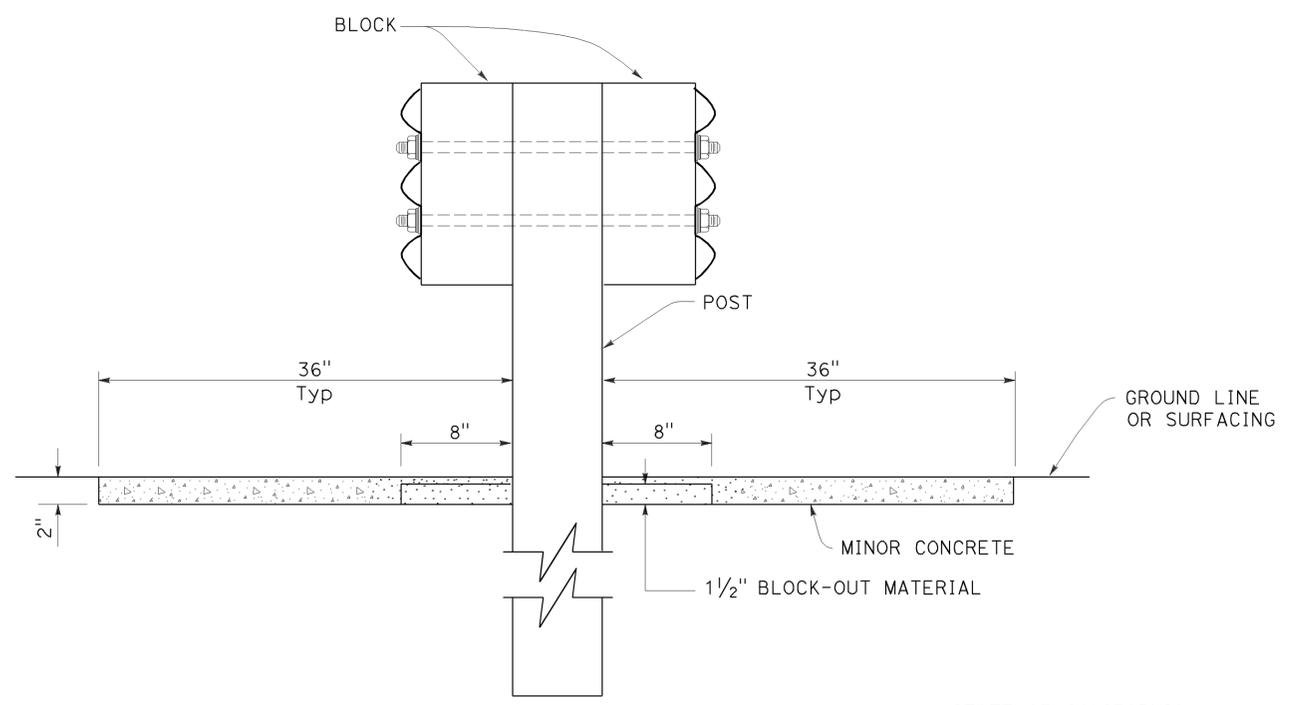

SECTION B-B

STATE OF CALIFORNIA
DEPARTMENT OF TRANSPORTATION

**THRIE BEAM BARRIER
TYPICAL VEGETATION CONTROL
AT STRUCTURE APPROACH**


NO SCALE

RSP A78C6 DATED OCTOBER 19, 2012 SUPERSEDES STANDARD PLAN A78C6
DATED MAY 20, 2011 - PAGE 96 OF THE STANDARD PLANS BOOK DATED 2010.

REVISED STANDARD PLAN RSP A78C6

2010 REVISED STANDARD PLAN RSP A78C6


TO ACCOMPANY PLANS DATED 2-1-16

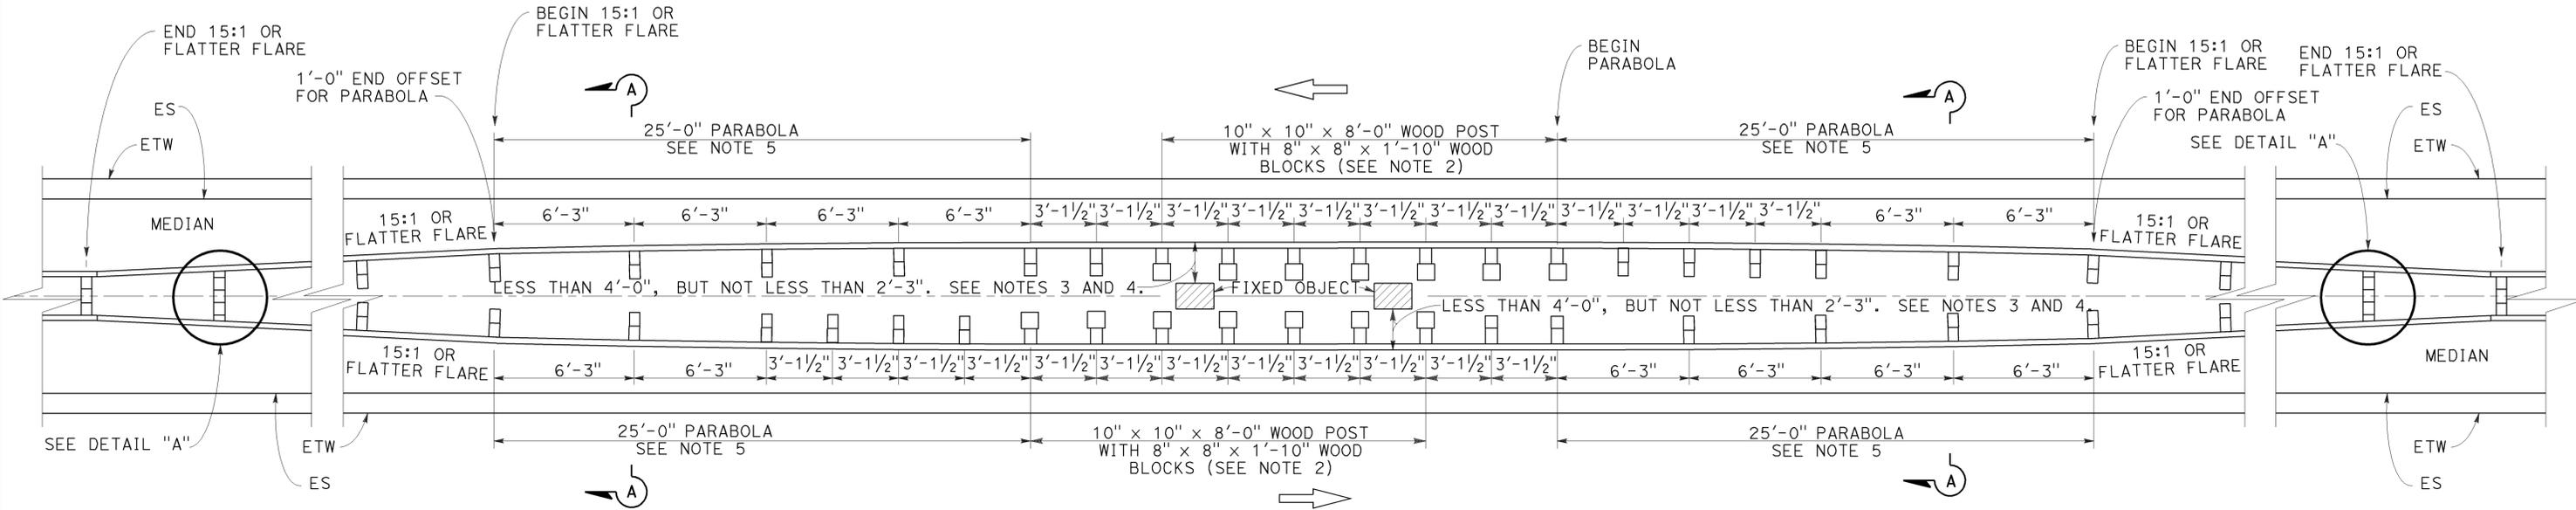


PLAN

THRIE BEAM BARRIER AT FIXED OBJECTS


(Wood post and block shown)
See Notes 1, 2 and 3.

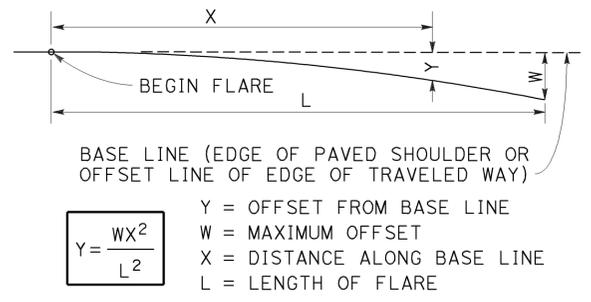

PARABOLIC FLARE OFFSETS

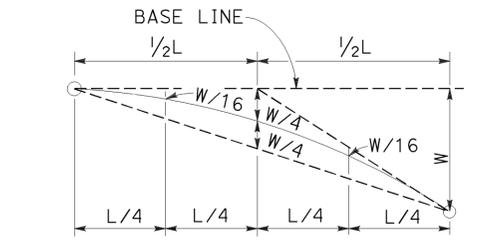


TYPICAL PARABOLIC LAYOUT

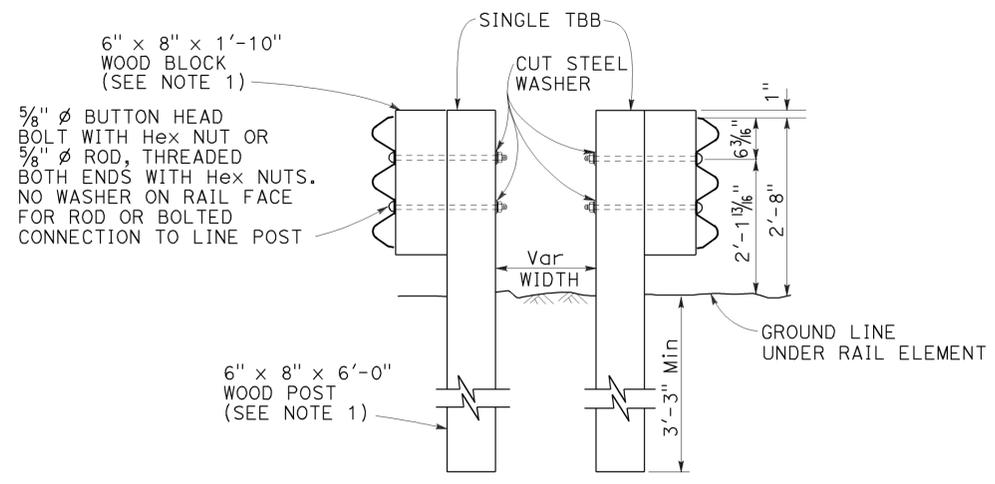

SECTION A-A

Wood post with wood block shown
See Note 1

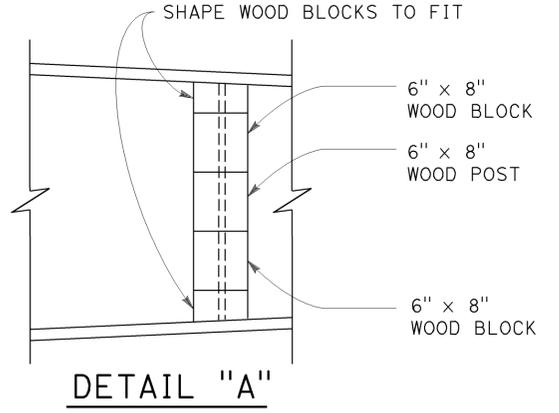

DETAIL "A"

- NOTES:**
- Where applicable and when specified, (W6 x 8.5 or W6 x 9) x 6'-8" steel post with 6" x 8" x 1'-10" notched wood blocks or notched recycled plastic blocks may be used for 6" x 8" x 6'-0" wood post with 6" x 8" x 1'-10" wood block.
 - Where applicable and when specified, (W6 x 15) x 8'-0" steel post with 8" x 8" x 1'-10" notched wood blocks or notched recycled plastic blocks may be used for the 10" x 10" x 8'-0" wood post with 8" x 8" x 1'-10" wood blocks shown at 3'-1/2" center to center spacing.
 - Where a minimum clearance of 4'-0" or more can be obtained between the face of the thrie beam rail and the face of the fixed object(s), the following substitutions may be made:
 - 6" x 8" x 6'-0" wood posts with 6" x 8" x 1'-10" wood blocks for the 10" x 10" x 8'-0" wood post with 8" x 8" x 1'-10" wood blocks shown.
 - 6'-3" post spacing for the 3'-1/2" spacing shown.
 - Where the clearance between the face of the railing and the face of a fixed object is less than 2'-3", a concrete barrier should be constructed to shield the fixed object(s).
 - For typical flare offsets for 25'-0" length parabola with maximum offset of 1'-0", see Revised Standard Plan RSP A77P1.

STATE OF CALIFORNIA
DEPARTMENT OF TRANSPORTATION

**THRIE BEAM BARRIER
AT FIXED OBJECTS
IN MEDIAN**

NO SCALE

RSP A78D1 DATED JULY 19, 2013 SUPERSEDES STANDARD PLAN A78D1
DATED MAY 20, 2011 - PAGE 97 OF THE STANDARD PLANS BOOK DATED 2010.

2010 REVISED STANDARD PLAN RSP A78D1

Dist	COUNTY	ROUTE	POST MILES TOTAL PROJECT	SHEET No.	TOTAL SHEETS
07	LA	5	13.8/19.2	222	262

Randell D. Hiatt
REGISTERED CIVIL ENGINEER

July 19, 2013
PLANS APPROVAL DATE


THE STATE OF CALIFORNIA OR ITS OFFICERS OR AGENTS SHALL NOT BE RESPONSIBLE FOR THE ACCURACY OR COMPLETENESS OF SCANNED COPIES OF THIS PLAN SHEET.

REGISTERED PROFESSIONAL ENGINEER
Randell D. Hiatt
No. C50200
Exp. 6-30-15
CIVIL
STATE OF CALIFORNIA

TO ACCOMPANY PLANS DATED 2-1-16

NOTES:

1. Line post, blocks and hardware to be used are shown on Standard Plans A78A, A78B and A78C1 and Revised Standard Plan RSP A78C2.
2. Post spacing to be 6'-3" center to center, except as otherwise noted.
3. Except as noted, line posts are 6" x 8" x 6'-0" wood with 6" x 8" x 1'-10" wood blocks. (W6 x 8.5 or W6 x 9) steel posts, 6'-8" in length, with 6" x 8" x 1'-10" notched wood blocks or notched recycled plastic blocks may be used for 6" x 8" x 6'-0" wood posts with 6" x 8" x 1'-10" wood blocks where applicable and when specified.
4. For Transition Railing (Type DTB) details, see Standard Plan A78K.
5. The 15:1 or flatter flare is measured off of the edge of traveled way.

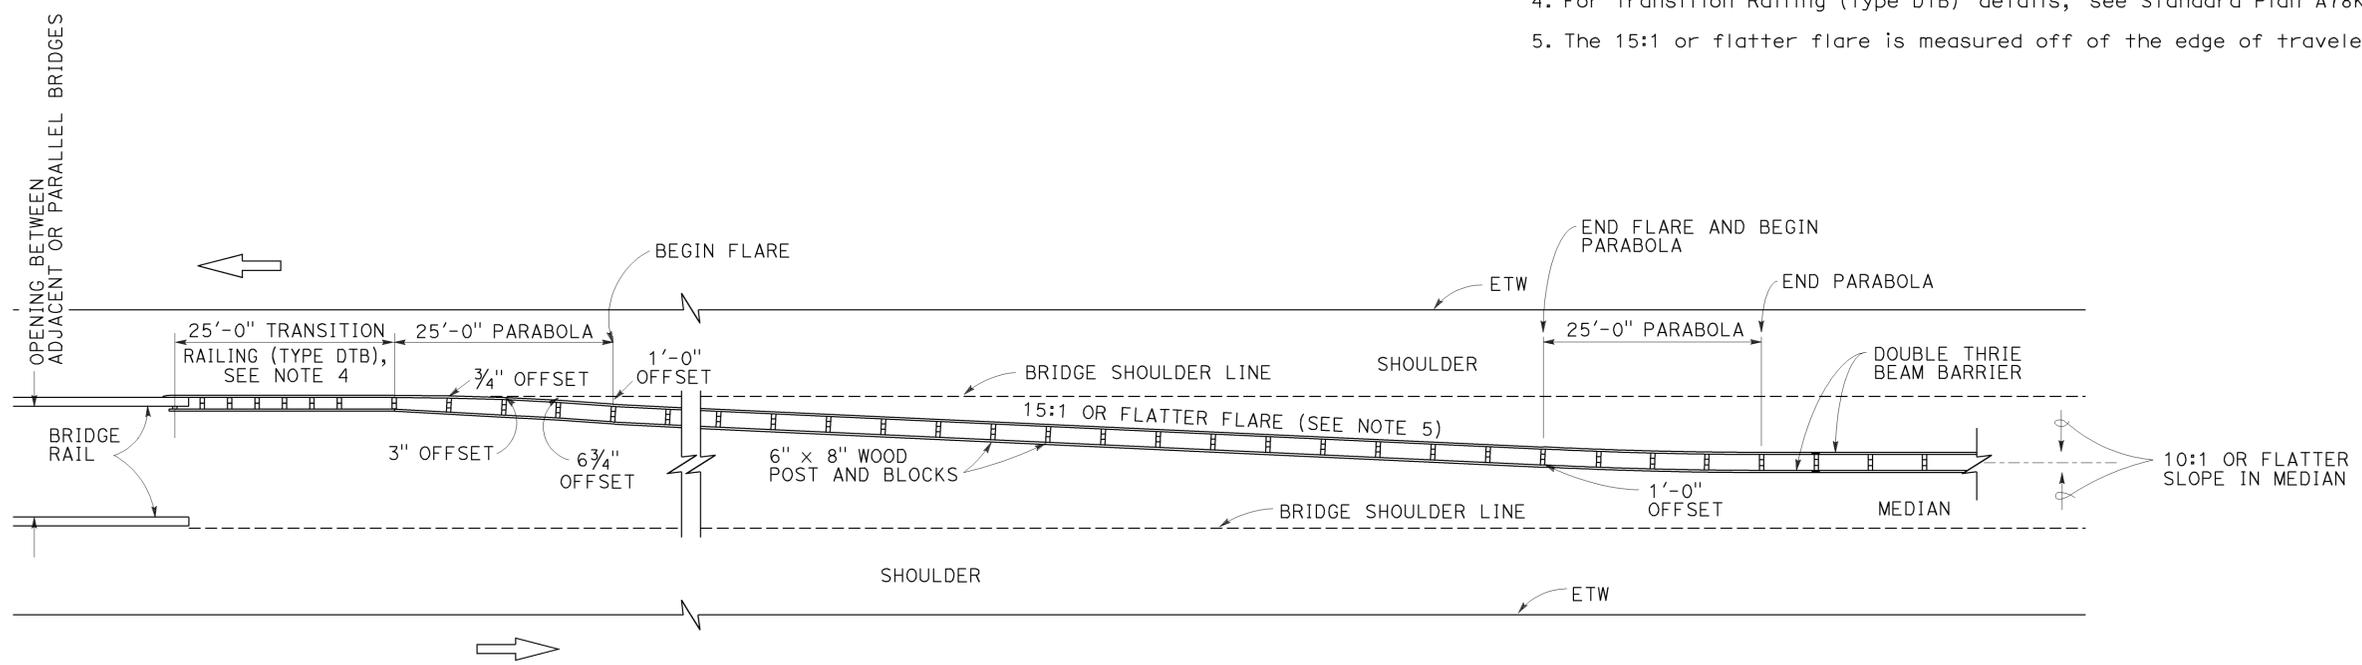

TYPE 25A CONNECTION LAYOUT

STATE OF CALIFORNIA
DEPARTMENT OF TRANSPORTATION


**THRIE BEAM BARRIER
TYPICAL LAYOUT
FOR CONNECTION TO
BRIDGE RAILING**

NO SCALE


RSP A78H DATED JULY 19, 2013 SUPERSEDES STANDARD PLAN A78H DATED MAY 20, 2011 - PAGE 105 OF THE STANDARD PLANS BOOK DATED 2010.

REVISED STANDARD PLAN RSP A78H


2010 REVISED STANDARD PLAN RSP A78H

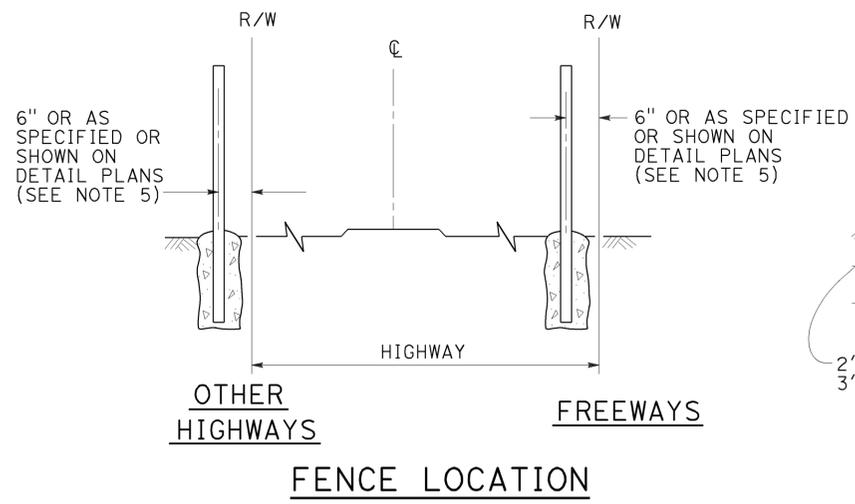


FENCE LOCATION

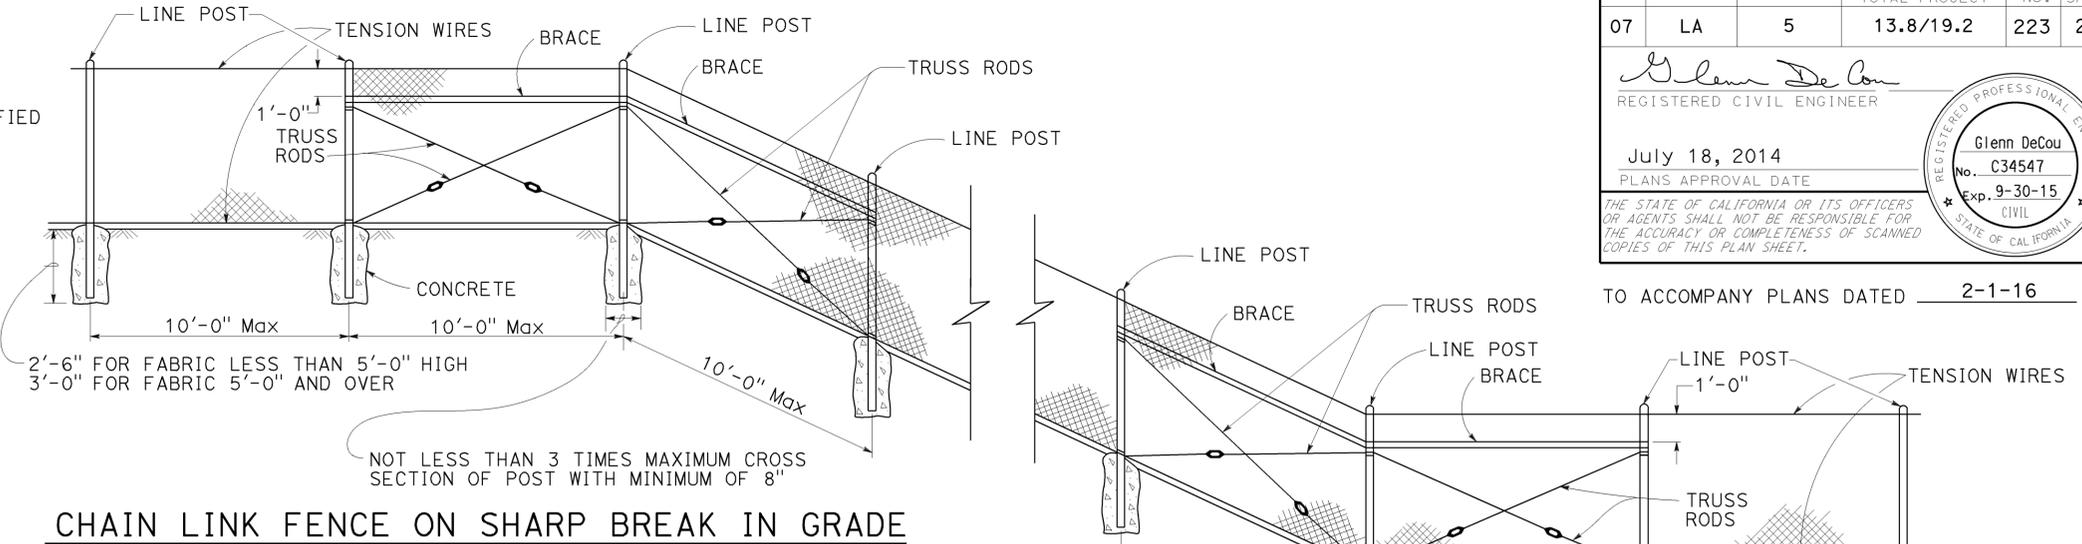

CHAIN LINK FENCE ON SHARP BREAK IN GRADE

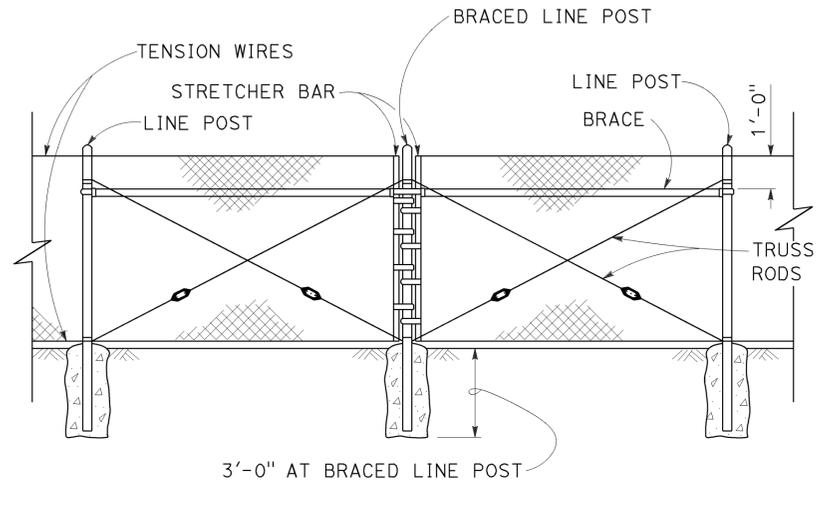

BRACED LINE POST INSTALLATION
Braced line post at intervals not exceeding 1000'

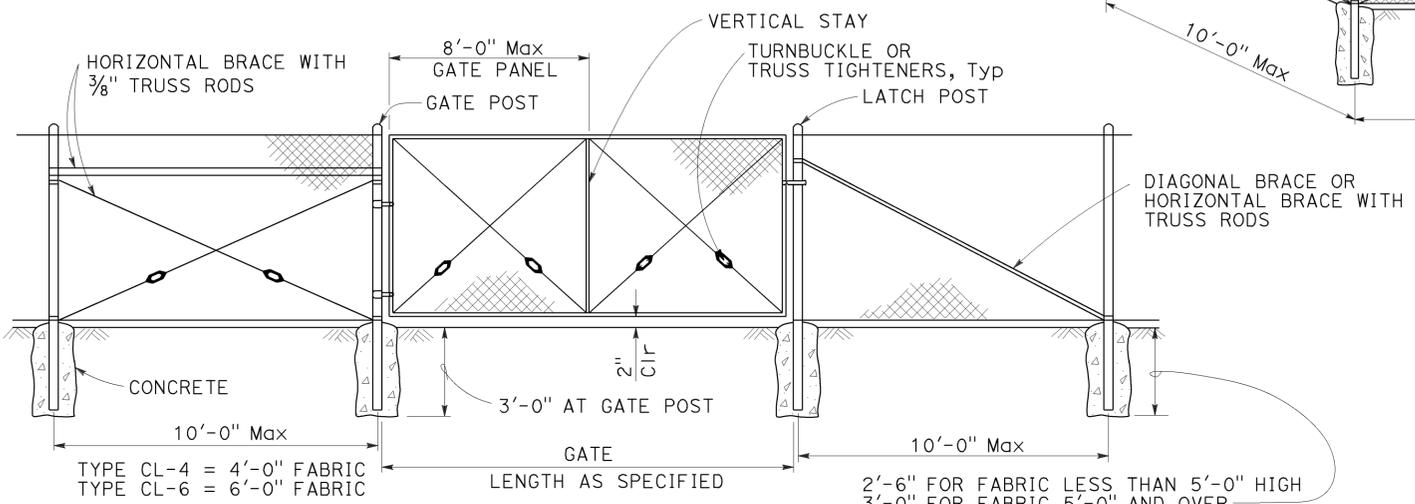

CHAIN LINK GATE INSTALLATION


GATE POST			
FENCE HEIGHT	GATE WIDTHS	ROUND OD PIPE	WEIGHT (lb/ft)
6'-0" AND LESS	UP THRU 6'-0"	2.875"	5.80
	OVER 6'-0" THRU 12'-0"	4.500"	10.80
	OVER 12'-0" THRU 18'-0"	5.563"	14.63
OVER 6'-0" TO 8'-0" Max	OVER 18'-0" TO 24'-0" Max	6.625"	18.99
	UP THRU 6'-0"	3.500"	7.58
	OVER 6'-0" THRU 12'-0"	5.563"	14.63
	OVER 12'-0" THRU 18'-0"	6.625"	18.99
	OVER 18'-0" TO 24'-0" Max	8.625"	28.58

Above post dimensions and weights are minimums. Larger sizes may be used upon approval.

NOTES:

- The table below shows minimum sized posts and braces complying with the specifications. Larger or heavier post and brace sizes may be used upon approval.
- Sections shown in the tables must also comply with the strength requirements and other provisions of the Specifications.
- Other sections which comply with the strength requirements and other provisions of the Specifications may be used upon approval.
- Options exercised shall be uniform on any one project.
- Offset to be 2'-0" at monument locations, measured at right angles to R/W lines. Taper to achieve offset to be at least 20'-0" long.
- See Revised Standard Plan RSP A85B for Brace, Stretcher Bar, and Truss Tightener Details.

TYPICAL MEMBER DIMENSIONS (See Notes)										
FENCE HEIGHT	LINE POSTS				END, LATCH AND CORNER POSTS		BRACES			
	ROUND OD PIPE	WEIGHT (lb/ft)	ROLL FORMED		ROUND OD PIPE	WEIGHT (lb/ft)	ROUND OD PIPE	WEIGHT (lb/ft)	ROLL FORMED	
			SECTION	WEIGHT (lb/ft)					SECTION	WEIGHT (lb/ft)
6'-0" AND LESS	1.900"	2.72	1.875" x 1.625"	1.85	2.375"	3.65	1.66"	2.27	1.625" x 1.25"	1.35
OVER 6'-0" TO 8'-0" Max	2.375"	3.65	2.25" x 1.70"	2.78	2.875"	5.80	1.66"	2.27	1.625" x 1.25"	1.35

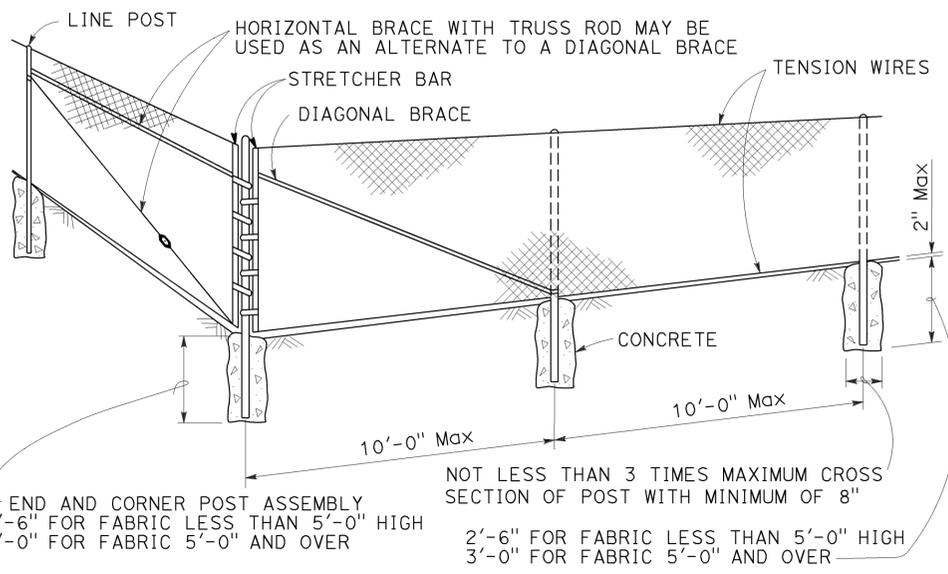

CORNER POST

RSP A85 DATED JULY 18, 2014 SUPERSEDES STANDARD PLAN A85 DATED MAY 20, 2011 - PAGE 112 OF THE STANDARD PLANS BOOK DATED 2010.


2010 REVISED STANDARD PLAN RSP A85

Dist	COUNTY	ROUTE	POST MILES TOTAL PROJECT	SHEET No.	TOTAL SHEETS
07	LA	5	13.8/19.2	224	262


Glenn DeCou
 REGISTERED CIVIL ENGINEER
 No. C34547
 Exp. 9-30-13
 CIVIL
 STATE OF CALIFORNIA

October 19, 2012
 PLANS APPROVAL DATE


THE STATE OF CALIFORNIA OR ITS OFFICERS OR AGENTS SHALL NOT BE RESPONSIBLE FOR THE ACCURACY OR COMPLETENESS OF SCANNED COPIES OF THIS PLAN SHEET.

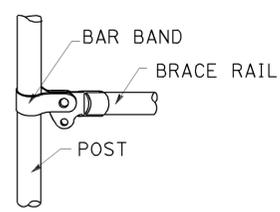

BRACE RAIL

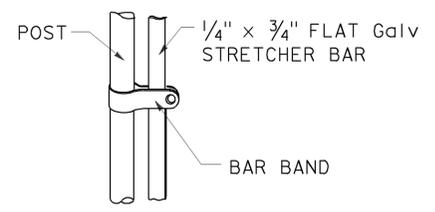

STRETCHER BAR

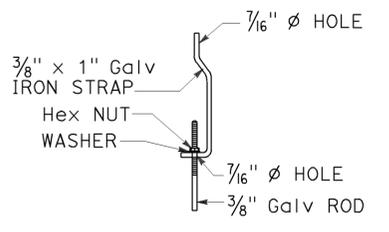


TRUSS TIGHTENER


NOTES:

1. All material for abutment connection to be galvanized.
2. The chain link fabric shall be replaced by barbed wire strands at 12" maximum centers between the double posts.
3. When the width of the culvert makes it necessary to anchor a post to the top of the culvert, a cast iron shoe or other device approved by the Engineer shall be used.
4. Fencing over stream and around headwall may also use Barbed Wire or Wire Mesh fencing with either wood post or steel post installation.
5. See Standard Plan A85 for Chain Link fence dimensions. See Standard Plan A86 for Barbed Wire and Wire Mesh fence dimensions and for wood post and steel post installation.


TO ACCOMPANY PLANS DATED 2-1-16

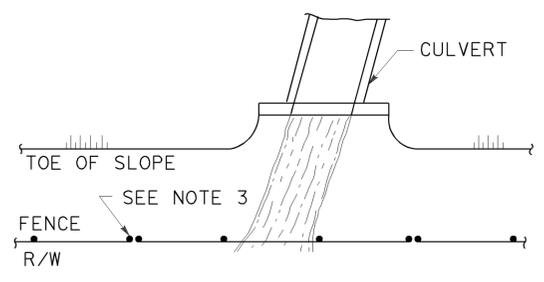


PLAN

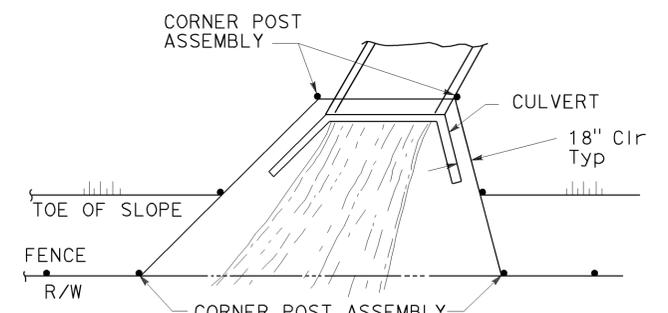


PLAN

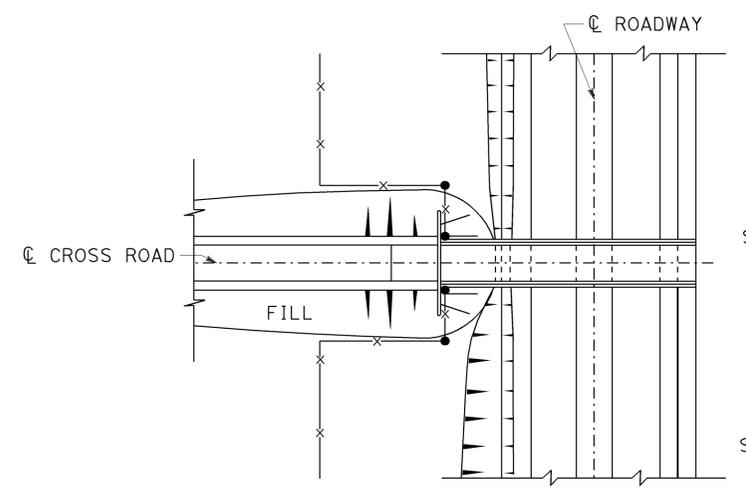

PLAN OF ROADWAY - OVERCROSSING

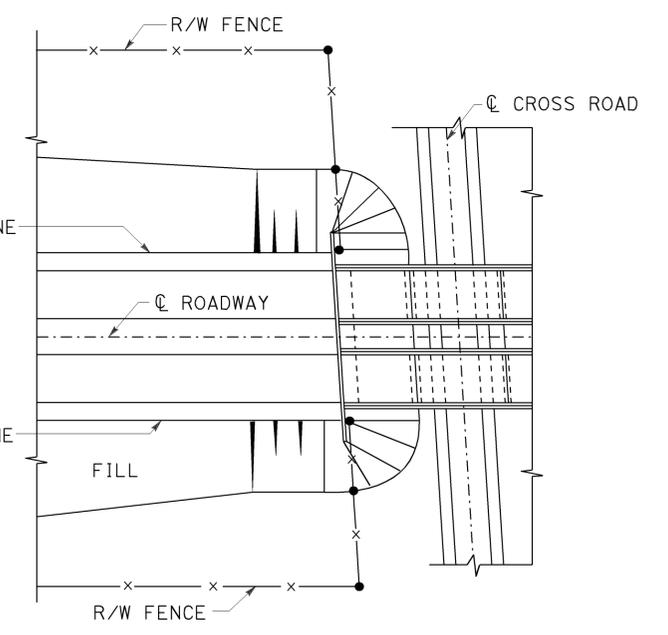


PLAN OF ROADWAY - UNDERCROSSING

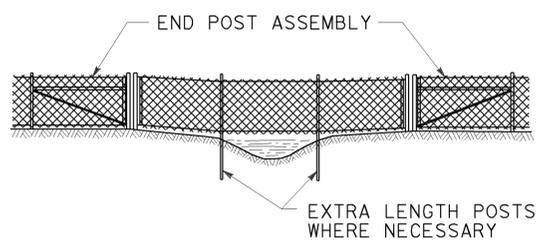

ELEVATION


INSTALLATION OVER STREAM

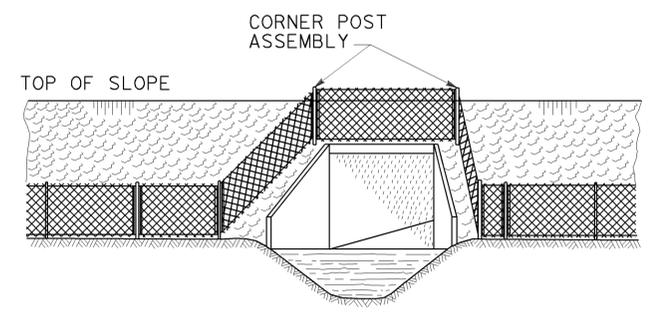

ELEVATION

INSTALLATION AROUND HEADWALL

See Note 4

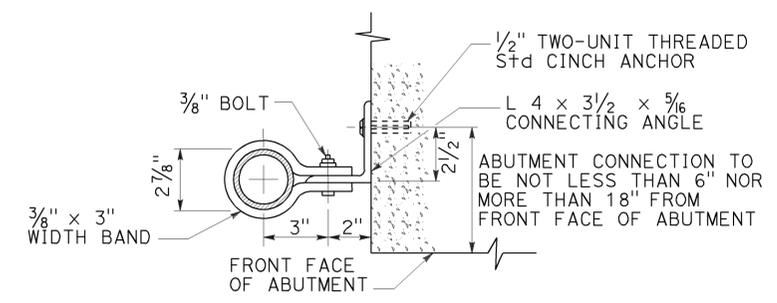

ABUTMENT CONNECTION

TYPICAL INSTALLATION AT BRIDGES

ABUTMENT CONNECTION TO BE NOT LESS THAN 6" NOR MORE THAN 18" FROM FRONT FACE OF ABUTMENT

STATE OF CALIFORNIA
DEPARTMENT OF TRANSPORTATION

CHAIN LINK FENCE DETAILS

NO SCALE

RSP A85B DATED OCTOBER 19, 2012 SUPERSEDES STANDARD PLAN A85B DATED MAY 20, 2011 - PAGE 114 OF THE STANDARD PLANS BOOK DATED 2010.




REVISED STANDARD PLAN RSP A85B

2010 REVISED STANDARD PLAN RSP A85B

TO ACCOMPANY PLANS DATED 2-1-16

CURB QUANTITIES

TYPE	CUBIC YARDS PER LINEAR FOOT
A1-6	0.02585
A1-8	0.03084
A2-6	0.05903
A2-8	0.06379
A3-6	0.01036
A3-8	0.01435
B1-4	0.02185
B1-6	0.02930
B2-4	0.05515
B2-6	0.06171
B3-4	0.00641
B3-6	0.01074
B4	0.05709
D-4	0.04083
D-6	0.06804
E	0.06661

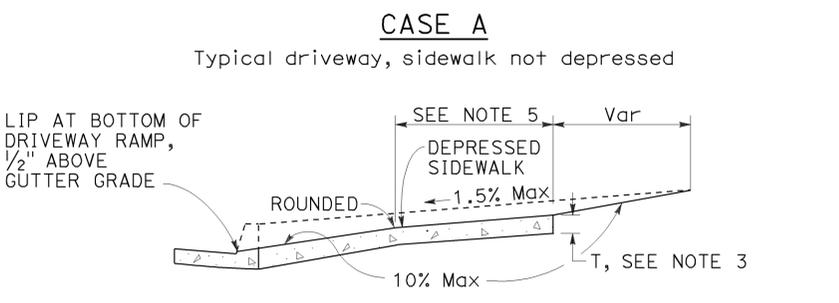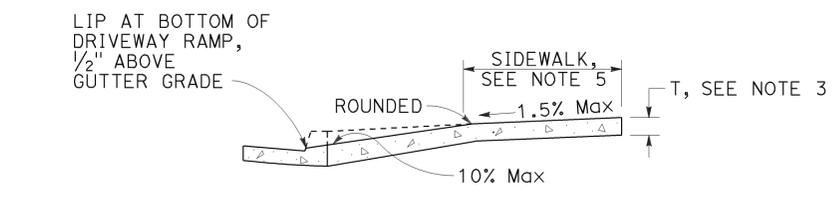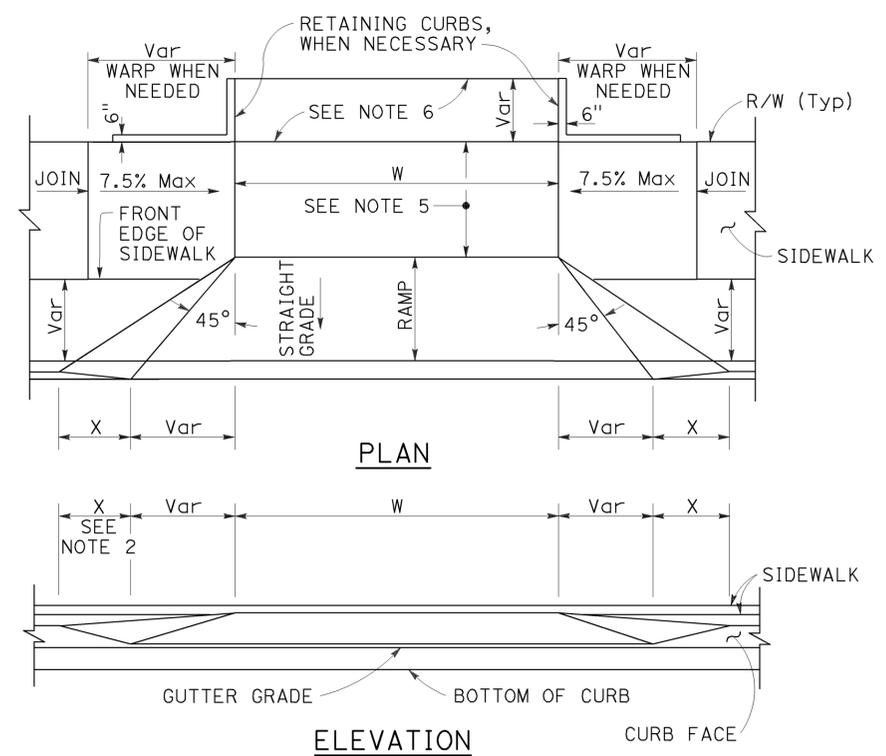

CASE A

Typical driveway, sidewalk not depressed

CASE B


Driveway with depressed sidewalk

SECTIONS


TABLE A

CURB TYPE	DIMENSIONS			
	"H1"	"H2"	"W1"	"W2"
A1-6	1'-2"	6"	7 1/2"	1 1/2"
A1-8	1'-4"	8"	8"	2"
A2-6	1'-0"	6"	2'-7 1/2"	1 1/2"
A2-8	1'-2"	8"	2'-8"	2"
A3-6	6"	5"	7 1/4"	1 1/4"
A3-8	8"	7"	7 3/4"	1 3/4"
B1-4	1'-0"	4"	7 1/2"	2 1/2"
B1-6	1'-2"	6"	9"	4"
B2-4	10"	4"	2'-7 1/2"	2 1/2"
B2-6	1'-0"	6"	2'-9"	4"
B3-4	4"	3"	7"	2"
B3-6	6"	5"	8 1/2"	3 1/2"
D-4	10"	4"	1'-6"	1'-1"
D-6	1'-0"	6"	2'-2"	1'-9"


DRIVEWAYS

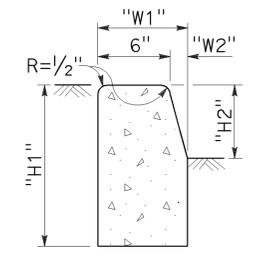


TYPE A1 CURBS
See Table A

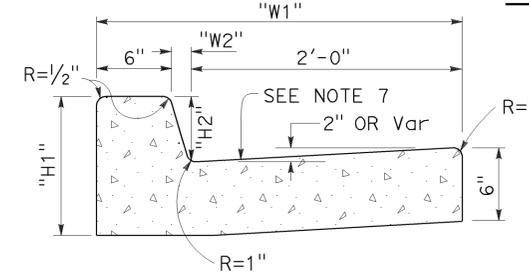


TYPE A2 CURBS
See Table A

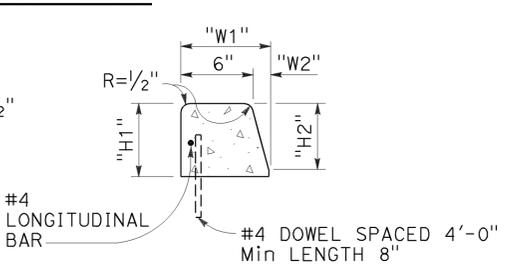


TYPE A3 CURBS
Superimposed on existing pavement
See Table A

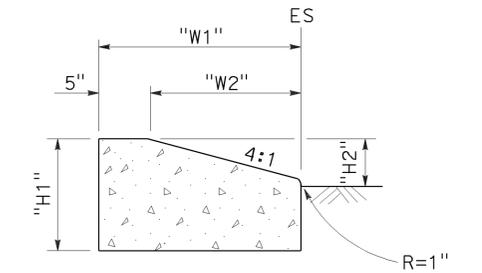


TYPE D CURBS
See Table A

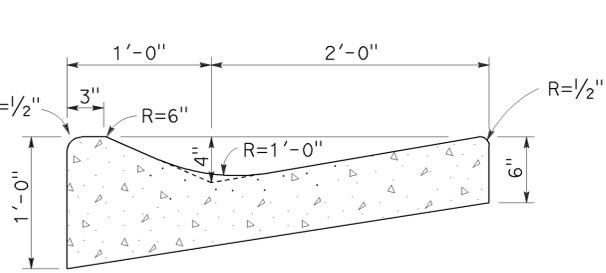


TYPE E CURB

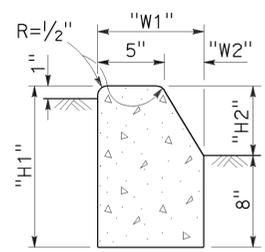


TYPE B1 CURBS
See Table A

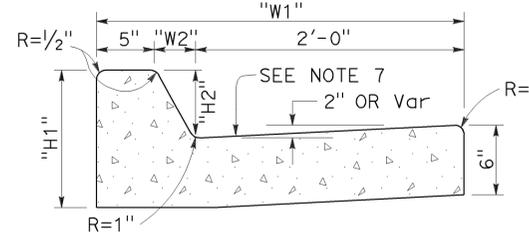


TYPE B2 CURBS
See Table A

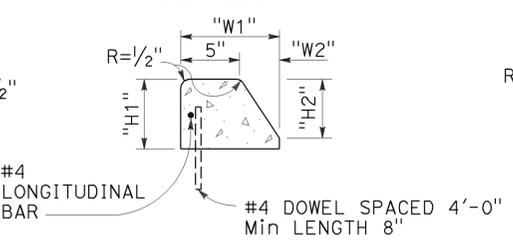

TYPE B3 CURBS
Superimposed on existing pavement
See Table A

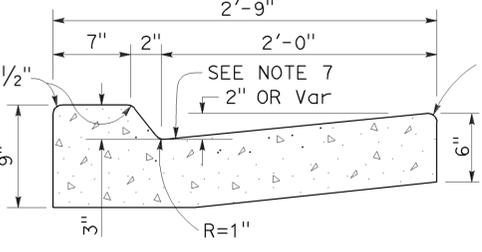

TYPE B4 CURBS

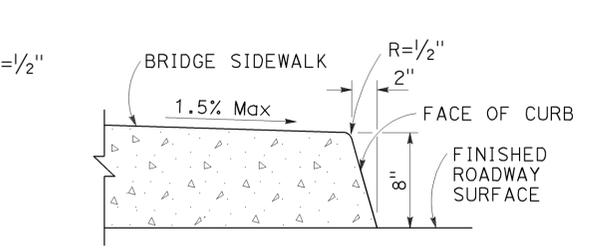

TYPE H CURB
On Bridges

CURBS

- NOTES:**
- Case A driveway section typically applies.
 - X=3'-0" except for curb heights over 10" where 4:1 slopes shall be used on curb slope.
 - Sidewalk and ramp thickness "T" at driveway shall be 4" for residential and 6" for commercial.
 - Difference in slope of the driveway ramp and the slope of a line between the gutter and a point on the roadway 5'-0" from gutter line shall not exceed 15%. Reduce driveway ramp slope, not gutter slope, where required.
 - Minimum width of clear passageway for sidewalk shall be 4'-2".
 - Retaining curbs and acquisition of construction easement may be necessary for narrow sidewalks or curb heights in excess of 6".
 - Across the pedestrian route at curb ramp locations, the gutter pan slope shall not exceed 1" of depth for each 2'-0" of width.

STATE OF CALIFORNIA
DEPARTMENT OF TRANSPORTATION

CURBS AND DRIVEWAYS


NO SCALE

RSP A87A DATED JULY 19, 2013 SUPERSEDES STANDARD PLAN A87A
DATED MAY 20, 2011 - PAGE 119 OF THE STANDARD PLANS BOOK DATED 2010.


REVISED STANDARD PLAN RSP A87A

2010 REVISED STANDARD PLAN RSP A87A


TO ACCOMPANY PLANS DATED 2-1-16

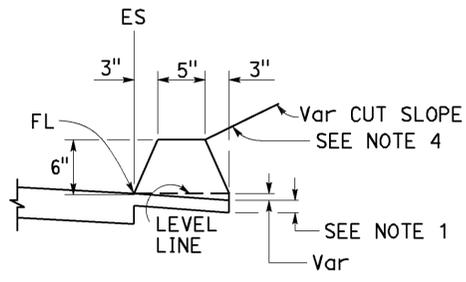


TYPE A
See Notes 3 and 5

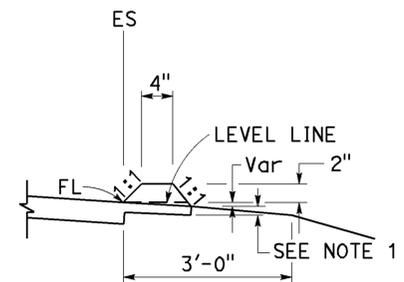


TYPE C

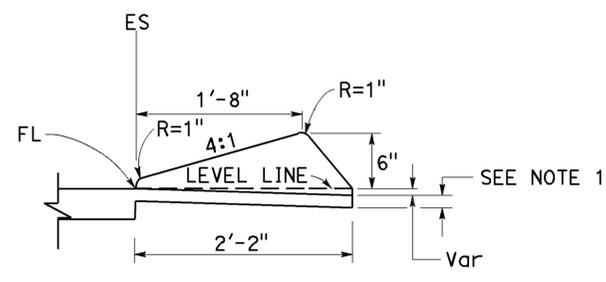

TYPE D

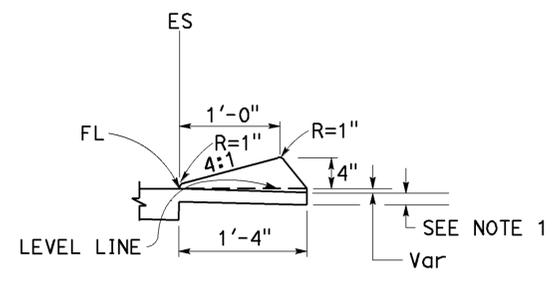


TYPE E

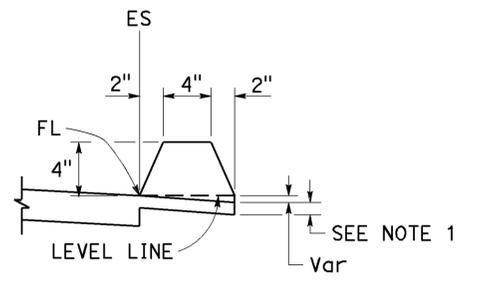


TYPE F
See Note 5


DIKES

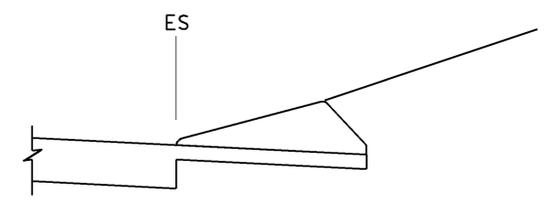


CASE C-1
Cut Slope

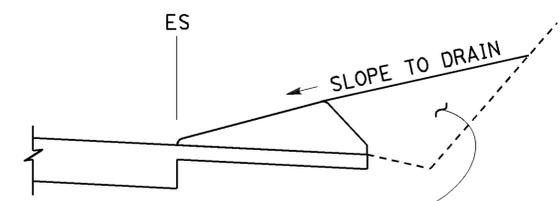

CASE C-2
Cut Slope

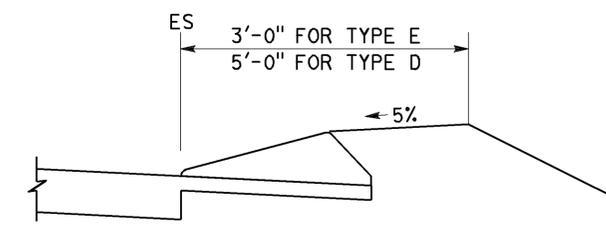

CASE F

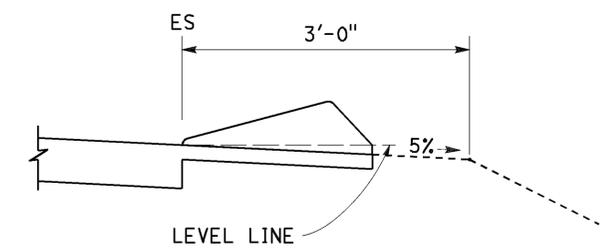

CASE R
See Note 2

TYPE D AND E BACKFILL DETAILS

NOTES:

- For HMA shoulders only, extend top layer of HMA placed on the shoulder under dike with no joint at the ES. For projects with OGFC shoulders, do not extend OGFC under dike. See project plans for modified dike detail.
- Case R applies to retrofit only projects where restrictive conditions do not provide enough width for Case F backfill.
- Type A dike only to be used where restrictive slope conditions do not provide enough width to use Type D or Type E dike.
- Fill and compact with excavated material to top of dike.
- Use Type A or F dike, where dike is required with guardrail installations. See Revised Standard Plan RSP A77N4 for dike positioning details. See Revised Standard Plan RSP A77N3 for hinge point offsets with guardrail.

DIKE QUANTITIES

TYPE	CUBIC YARDS PER LINEAR FOOT
A	0.0135
C	0.0038
D	0.0293
E	0.0130
F	0.0066

Quantities based on 5% cross slope.

STATE OF CALIFORNIA
DEPARTMENT OF TRANSPORTATION

HOT MIX ASPHALT DIKES

NO SCALE

RSP A87B DATED JANUARY 15, 2016 SUPERSEDES RSP A87B DATED JULY 19, 2013 AND STANDARD PLAN A87B DATED MAY 20, 2011 - PAGE 120 OF THE STANDARD PLANS BOOK DATED 2010.


REVISED STANDARD PLAN RSP A87B

2010 REVISED STANDARD PLAN RSP A87B


Dist	COUNTY	ROUTE	POST MILES TOTAL PROJECT	SHEET No.	TOTAL SHEETS
07	LA	5	13.8/19.2	227	262

H. David Cordova
 REGISTERED CIVIL ENGINEER
 No. C41957
 Exp. 3-31-16
 CIVIL
 STATE OF CALIFORNIA


July 3, 2015
 PLANS APPROVAL DATE
 THE STATE OF CALIFORNIA OR ITS OFFICERS OR AGENTS SHALL NOT BE RESPONSIBLE FOR THE ACCURACY OR COMPLETENESS OF SCANNED COPIES OF THIS PLAN SHEET.

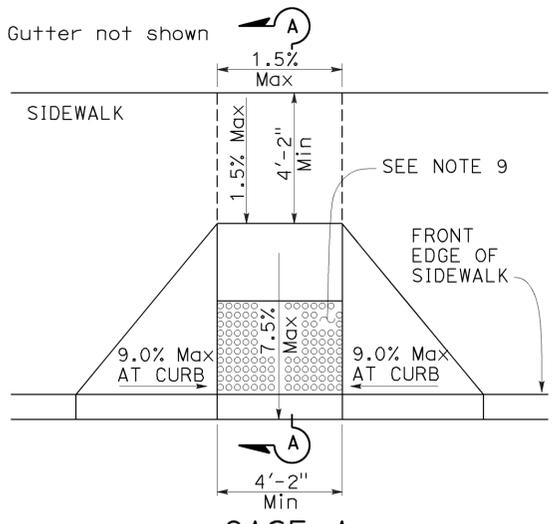


CASE A

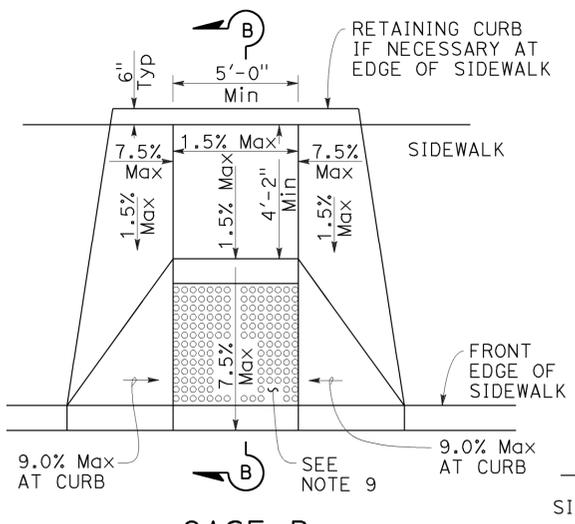


CASE B

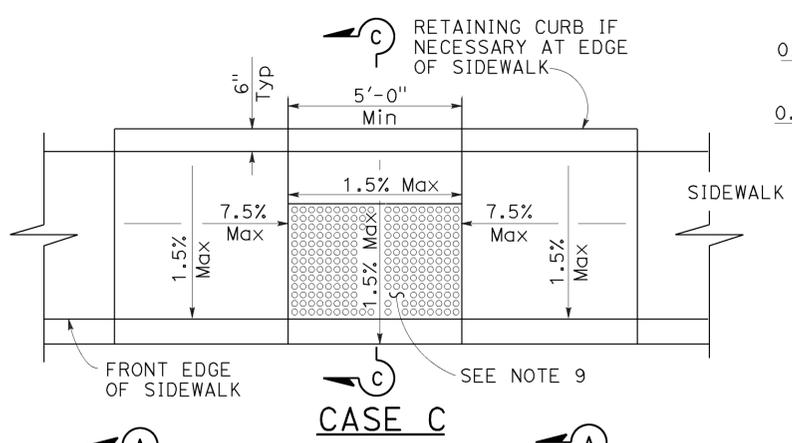


CASE C

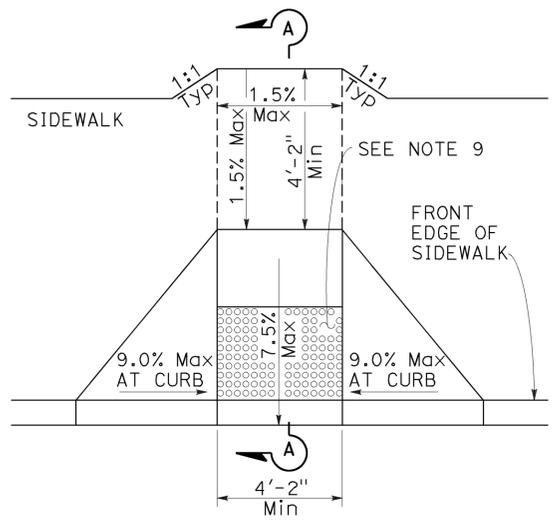


CASE D

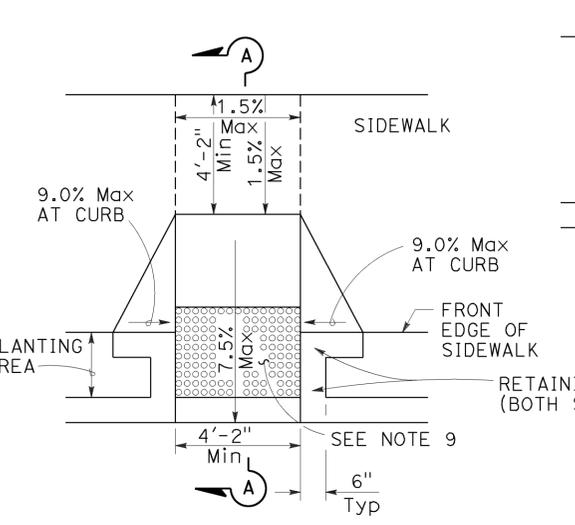

CASE E

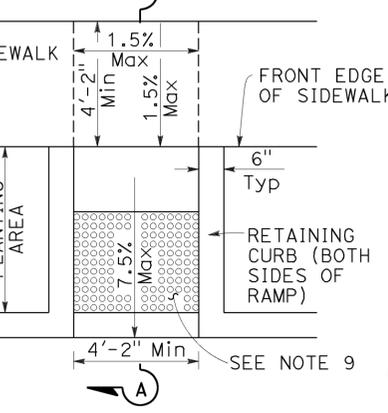


CASE F

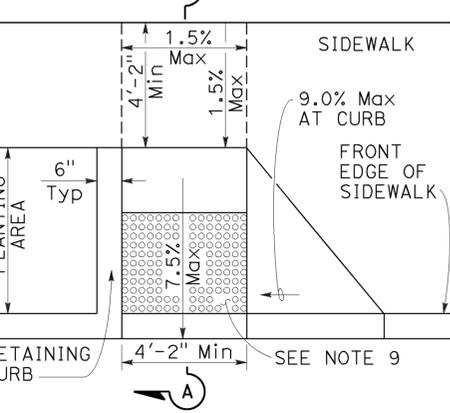


CASE G

RAISED TRUNCATED DOME

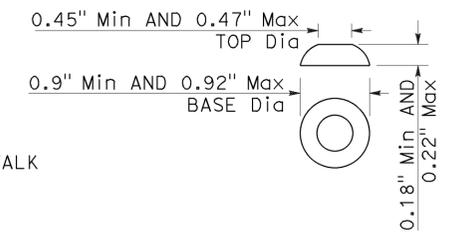


NOTES:


- As site conditions dictate, Case A through Case G curb ramps may be used for corner installations similar to those shown in Detail A and Detail B. The case of curb ramps used in Detail A do not have to be the same. Case A through Case G curb ramps also may be used at mid block locations, as site conditions dictate.
- If distance from curb to back of sidewalk is too short to accommodate ramp and 4'-2" platform (landing) as shown in Case A, the sidewalk may be depressed longitudinally as in Case B, or C or may be widened as in Case D.
- When ramp is located in center of curb return, crosswalk configuration must be similar to that shown for Detail B.
- As site conditions dictate, the retaining curb side and the flared side of the Case G ramp shall be constructed in reversed position.
- If located on a curve, the sides of the ramp need not be parallel, but the minimum width of the ramp shall be 4'-2".
- Side slope of ramp flares vary uniformly from a maximum of 9.0% at curb to conform with longitudinal sidewalk slope adjacent to top of the ramp, except in Case C and Case F.
- Transitions from ramps and landing to walks, gutters or streets shall be flush (no lip) and free of abrupt changes.
- Counter slopes of adjoining gutters and road surfaces immediately adjacent to and within 24 inches of the curb ramp shall not be steeper than 1:20 (5.0%). Gutter pan slope shall not exceed 1" of depth for each 2'-0" of width.
- Curb ramps shall have a detectable warning surface that extends the full width and 3'-0" depth of the ramp. A 4'-0" wide detectable warning surface may be used on a 4'-2" wide curb ramp. Detectable Warning Surfaces shall conform to the requirements in the Standard Specifications.
- Sidewalk and ramp thickness, "T", shall be 3 1/2" minimum.
- Utility pull boxes, manholes, vaults and all other utility facilities within the boundaries of the curb ramp will be relocated or adjusted to grade by the owner prior to, or in conjunction with, curb ramp construction.
- Detectable warning surface may have to be cut to allow removal of utility covers while maintaining full detectable warning width and depth.

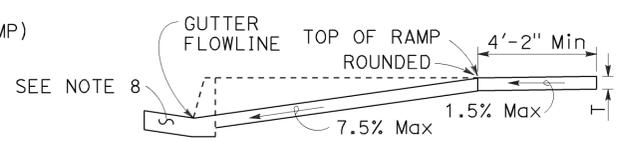

SECTION A-A

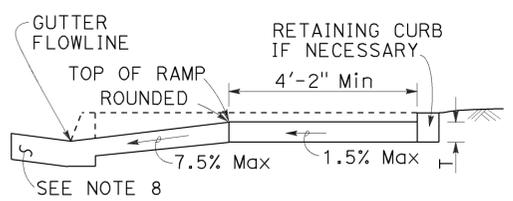

SECTION B-B

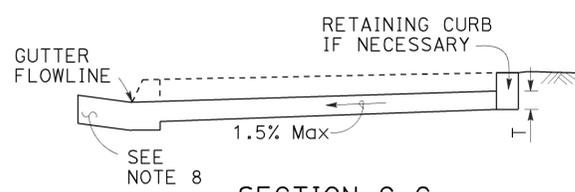


SECTION C-C



**RAISED TRUNCATED DOME PATTERN (IN-LINE)
DETECTABLE WARNING SURFACE**


See Note 9

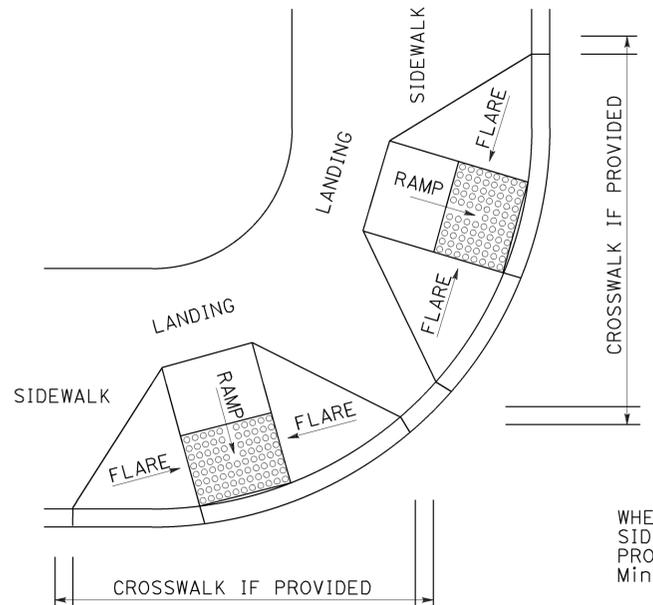

DETAIL A

**TYPICAL TWO-RAMP
CORNER INSTALLATION**


See Note 1

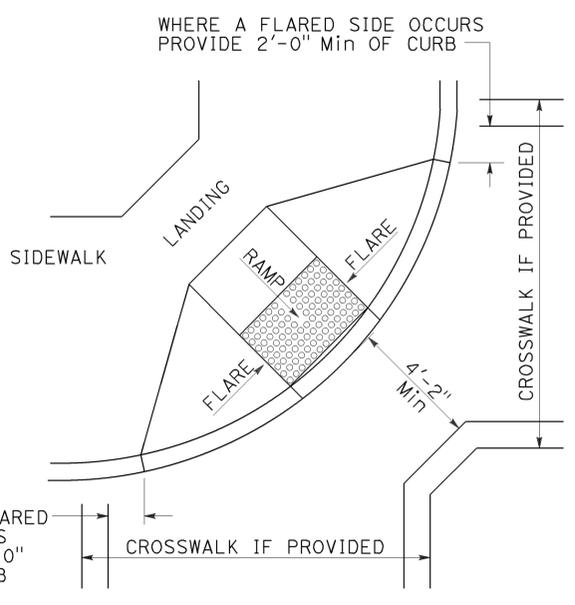

DETAIL B

**TYPICAL ONE-RAMP
CORNER INSTALLATION**

See Notes 1 and 3

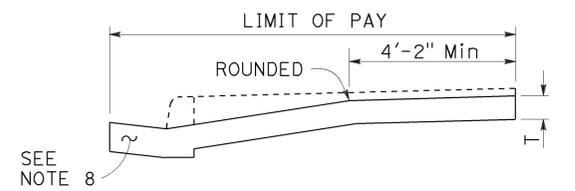

RETROFIT PAY LIMITS

Existing curb and sidewalk

**CURB RAMP DETAILS
NO SCALE**


RSP A88A DATED JULY 3, 2015 SUPERSEDES RSP A88A DATED MARCH 21, 2014 AND RSP A88A DATED JULY 19, 2013 AND STANDARD PLAN A88A DATED MAY 20, 2011 - PAGE 121 OF THE STANDARD PLANS BOOK DATED 2010.

REVISED STANDARD PLAN RSP A88A


2010 REVISED STANDARD PLAN RSP A88A

Dist	COUNTY	ROUTE	POST MILES TOTAL PROJECT	SHEET No.	TOTAL SHEETS
07	LA	5	13.8/19.2	229	262

William K. Farnbach
 REGISTERED CIVIL ENGINEER
 July 19, 2013
 PLANS APPROVAL DATE
THE STATE OF CALIFORNIA OR ITS OFFICERS OR AGENTS SHALL NOT BE RESPONSIBLE FOR THE ACCURACY OR COMPLETENESS OF SCANNED COPIES OF THIS PLAN SHEET.

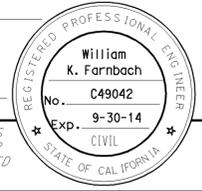


TO ACCOMPANY PLANS DATED 2-1-16

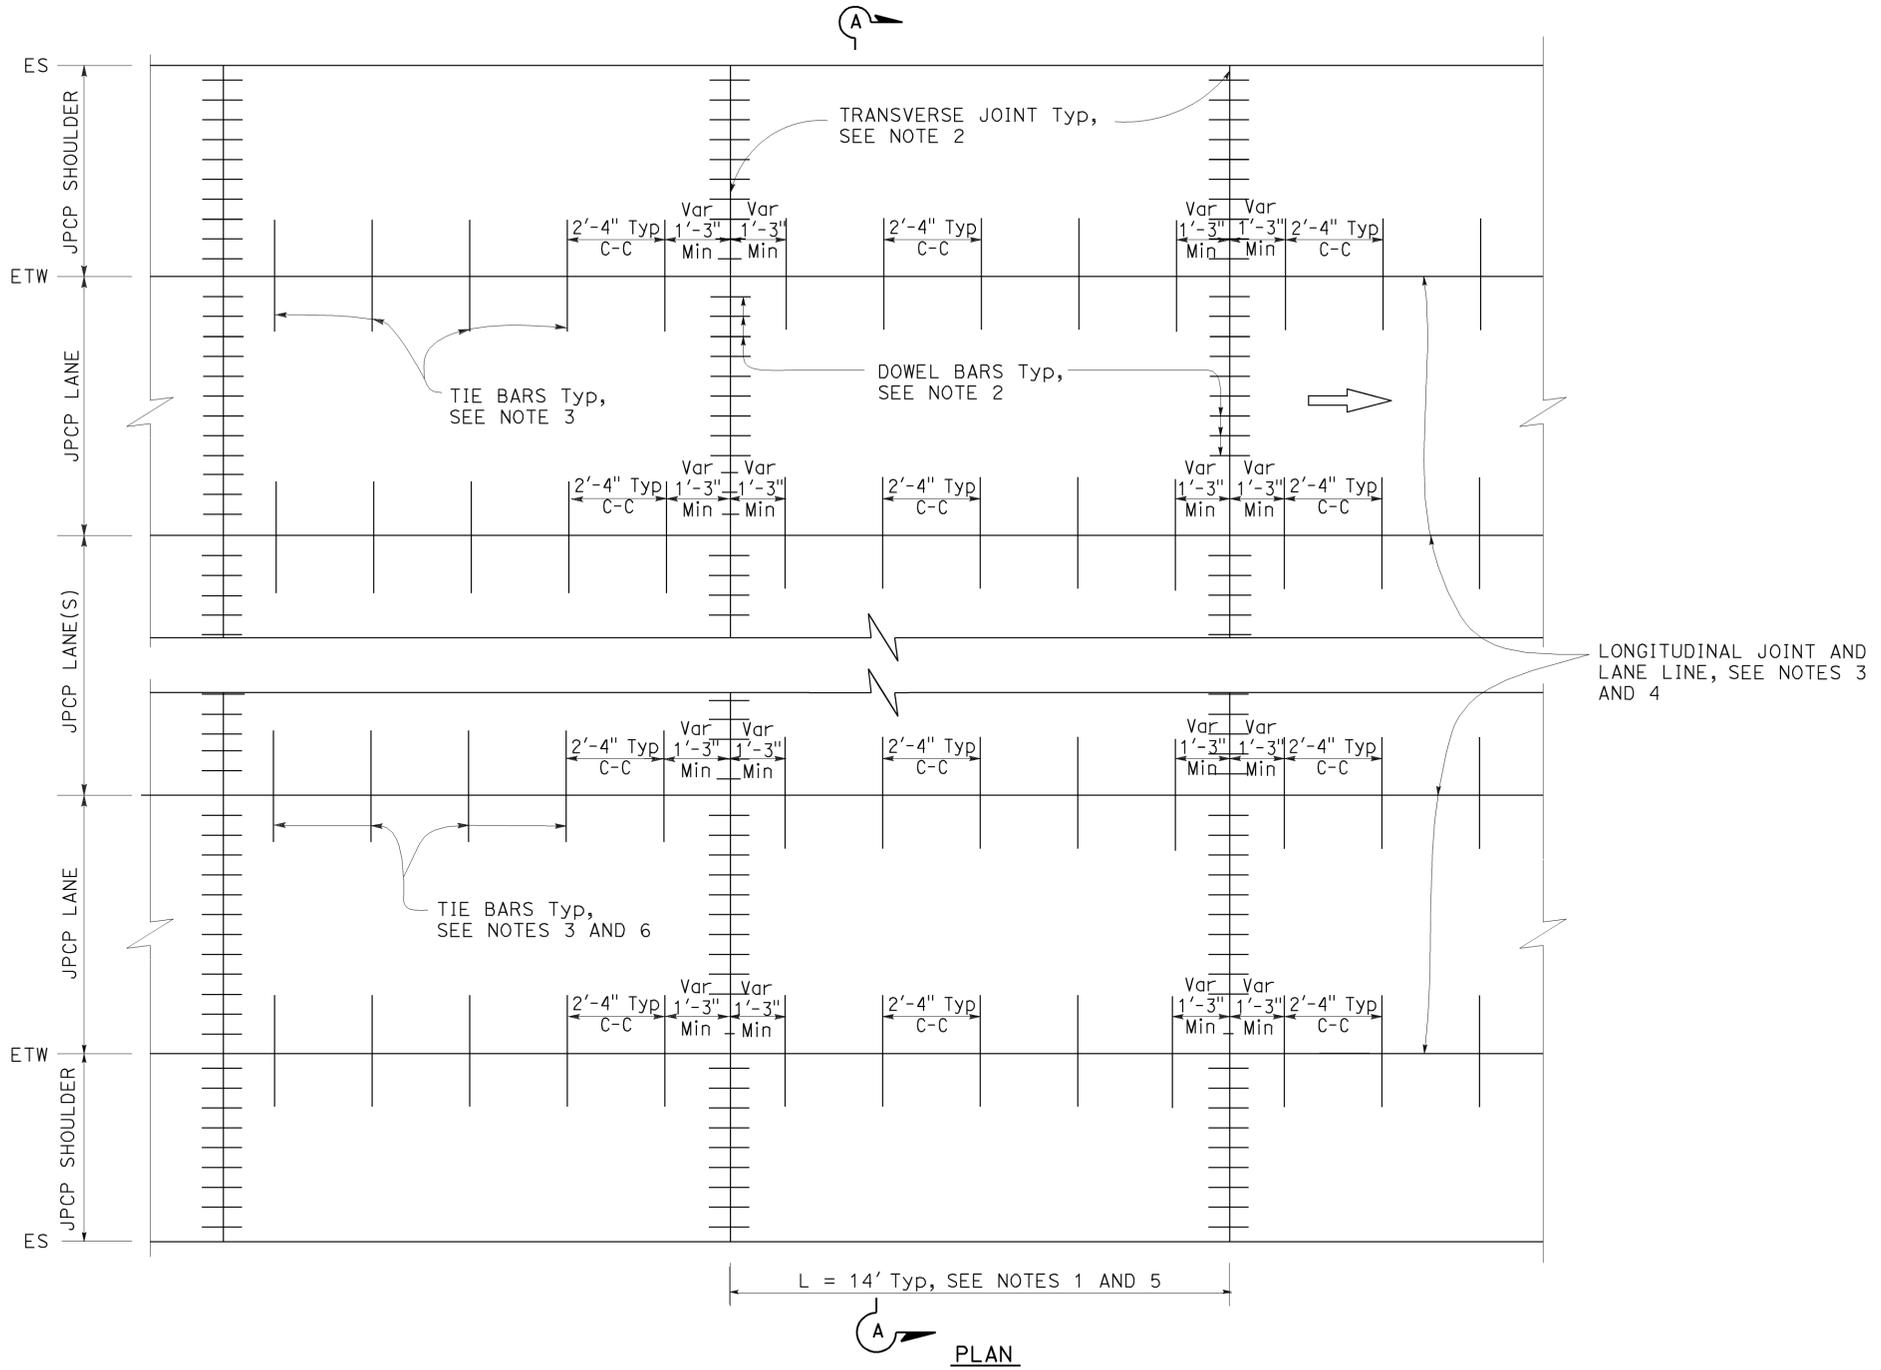

NOTES:

1. Transverse joint spacing may be adjusted to no less than 10' and no more than 14' to conform to bridges, change in pavement type, and hardened concrete pavement.
2. For transverse joint and dowel bar details not shown, see Revised Standard Plan RSP P10.
3. For longitudinal joint and tie bar details not shown, see Revised Standard Plan RSP P15.
4. For additional longitudinal joint layout details, see Revised Standard Plan RSP P18.
5. For joint layout at intersections, see Project Plans.
6. For dowel bars at longitudinal joint. see Revised Standard Plan RSP P18.

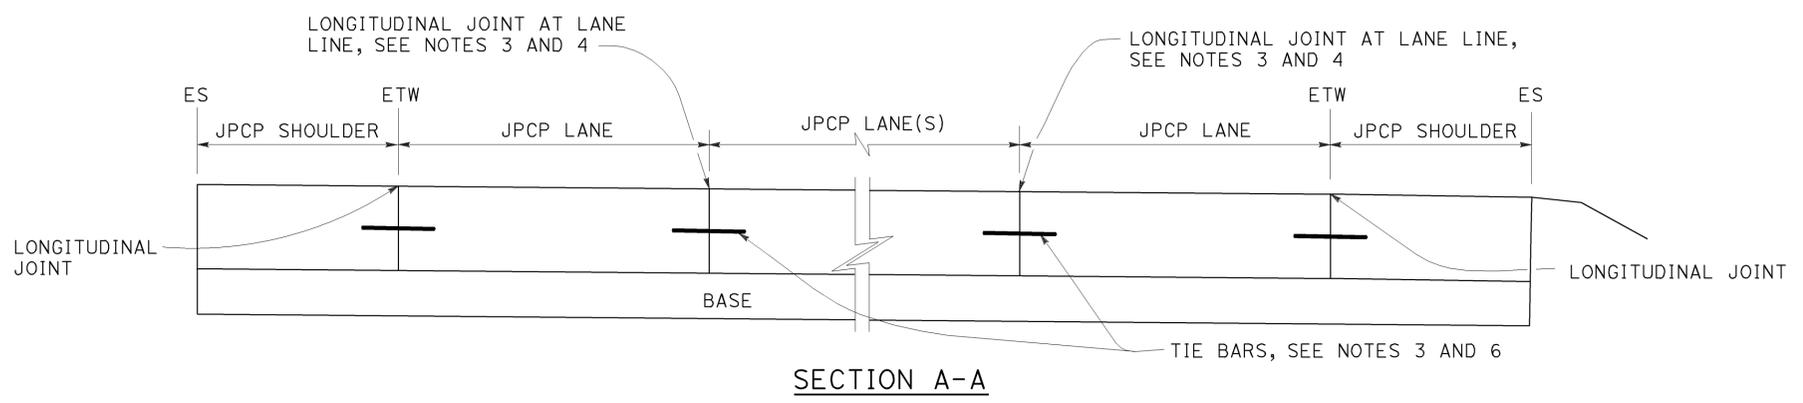

STATE OF CALIFORNIA
 DEPARTMENT OF TRANSPORTATION
**JOINTED PLAIN
 CONCRETE PAVEMENT
 NEW CONSTRUCTION**
 NO SCALE

RSP P1 DATED JULY 19, 2013 SUPERSEDES STANDARD PLAN P1
 DATED MAY 20, 2011 - PAGE 125 OF THE STANDARD PLANS BOOK DATED 2010.

REVISED STANDARD PLAN RSP P1


2010 REVISED STANDARD PLAN RSP P1

Dist	COUNTY	ROUTE	POST MILES TOTAL PROJECT	SHEET No.	TOTAL SHEETS
07	LA	5	13.8/19.2	230	262

William K. Farnbach
 REGISTERED CIVIL ENGINEER
 No. C49042
 Exp. 9-30-14
 CIVIL
 STATE OF CALIFORNIA

July 19, 2013
 PLANS APPROVAL DATE

THE STATE OF CALIFORNIA OR ITS OFFICERS OR AGENTS SHALL NOT BE RESPONSIBLE FOR THE ACCURACY OR COMPLETENESS OF SCANNED COPIES OF THIS PLAN SHEET.

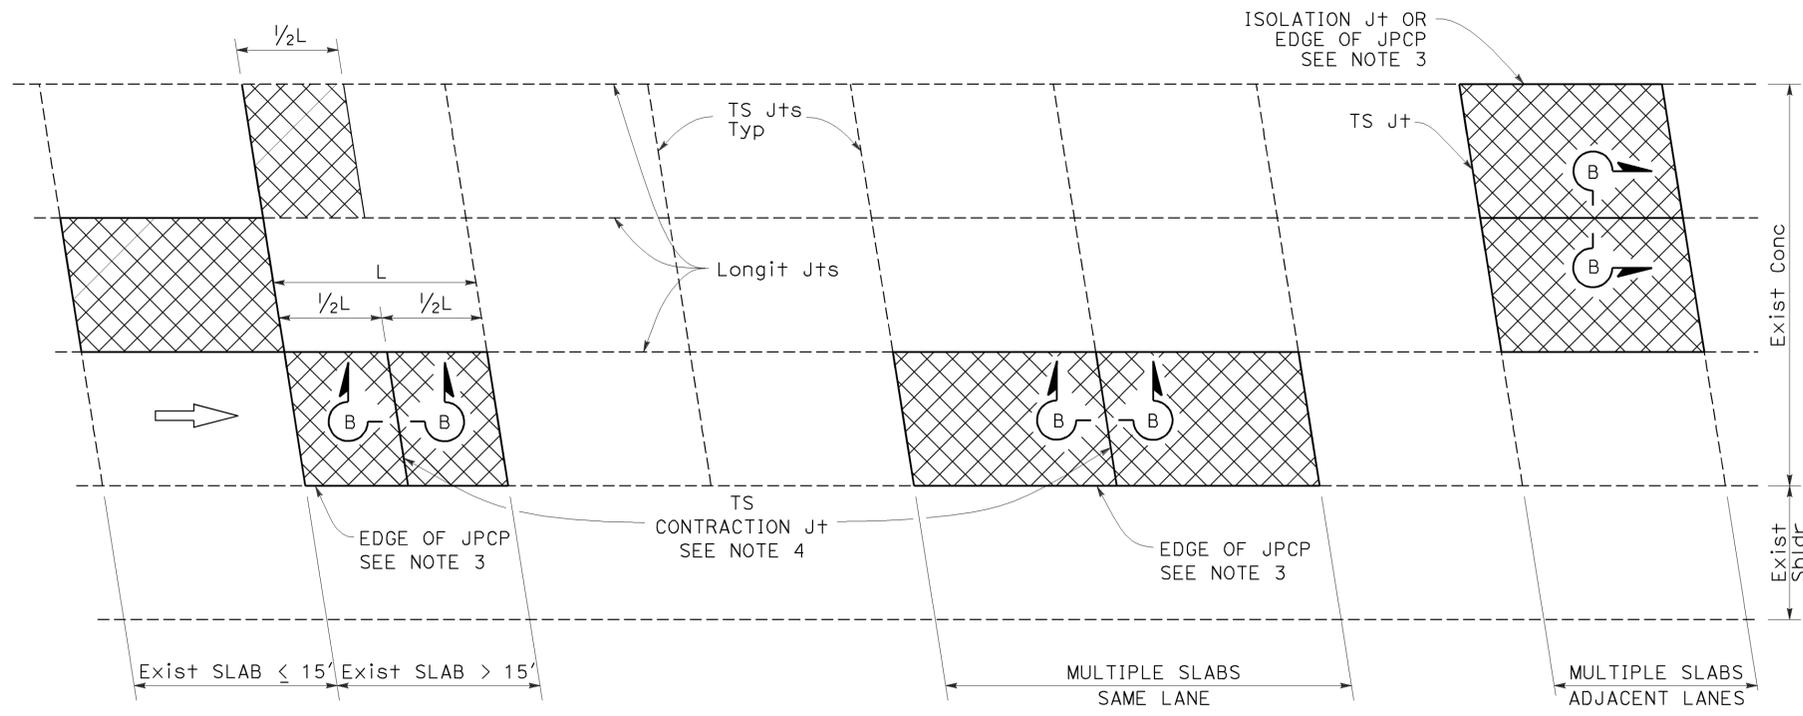

PLAN

LEGEND:


- RSC RAPID STRENGTH CONCRETE
- INDIVIDUAL SLAB REPLACEMENT WITH RSC

NOTES:


- For details not shown, see Revised Standard Plan RSP P10.
- Where the existing outside shoulder is asphalt concrete pavement, "a" = 1'-0" and "b" = 2'-0".
- Use side forms where edge of RSC pavement is adjacent to asphalt concrete.
- Transverse contraction joint to match skew of existing joint. Omit dowel bars.
- Do not place tie bars at longitudinal joints.

DESIGN NOTES:


- For concrete slab repair with at least 5 years design life.
- For short term repairs < 5 yrs design life or for slab replacements with cracking and seating.

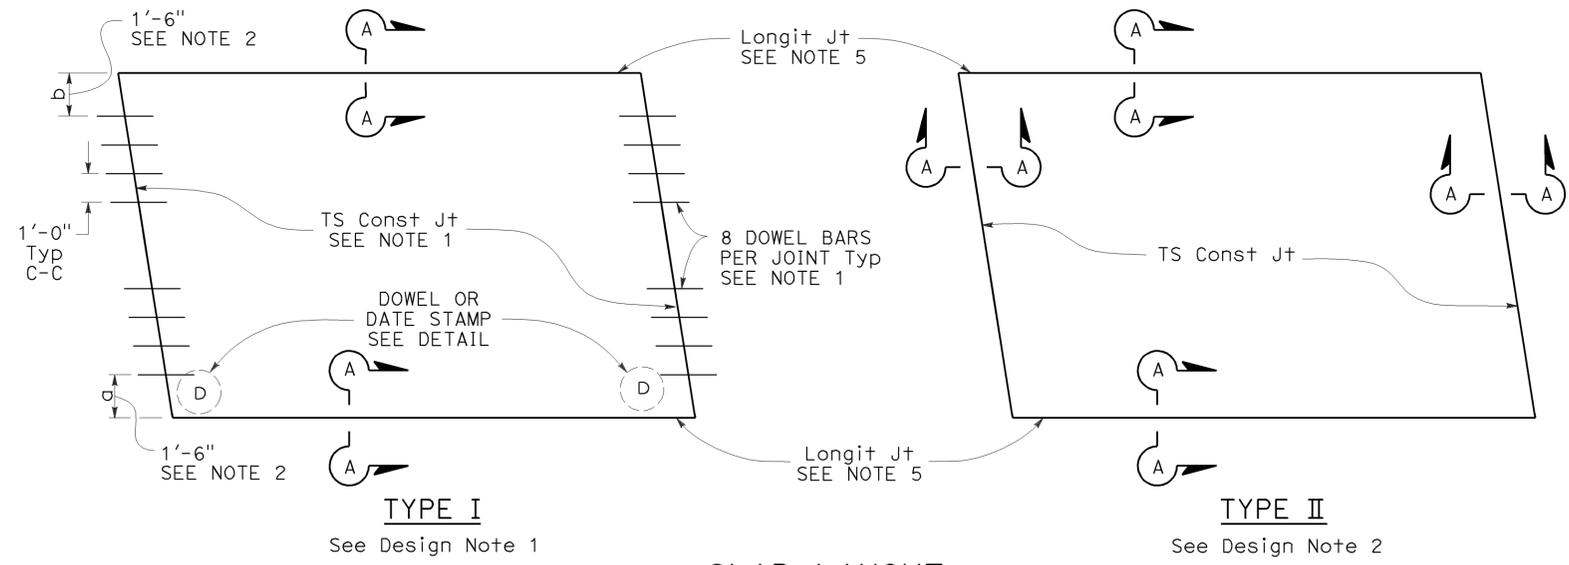


SLAB LAYOUT

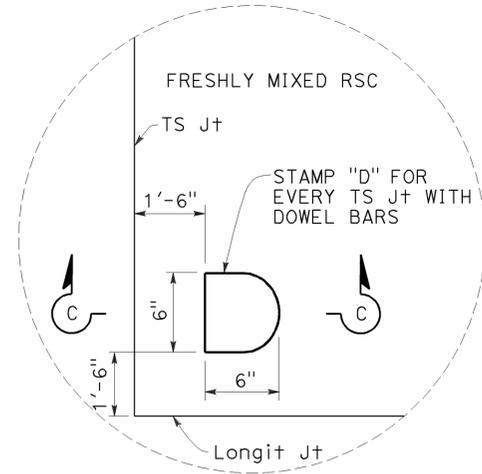


DOWEL STAMP DETAIL

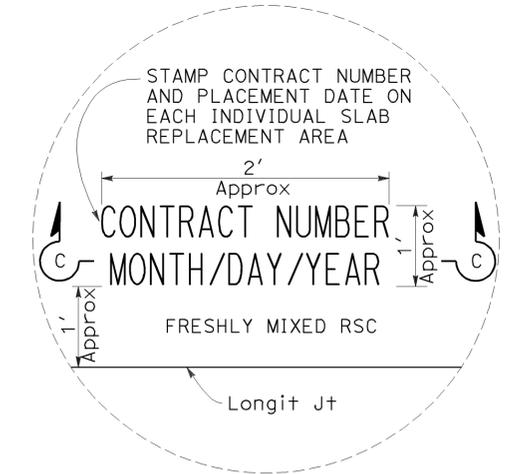


DATE STAMP DETAIL

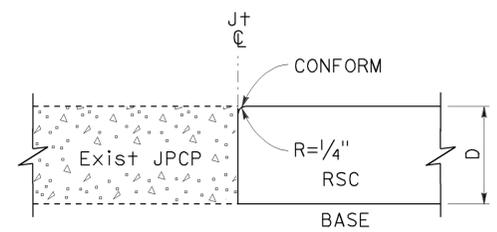

SECTION A-A

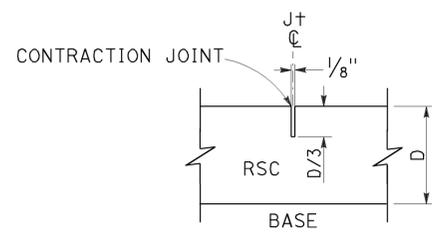

SECTION B-B

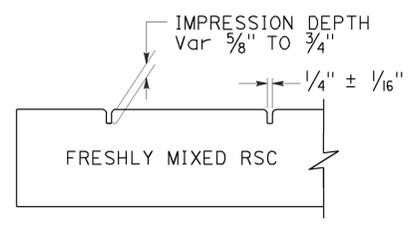

SECTION C-C

INDIVIDUAL SLAB REPLACEMENT WITH RAPID STRENGTH CONCRETE

NO SCALE


RSP P8 DATED JULY 19, 2013 SUPERSEDES RSP P8 DATED APRIL 20, 2012 AND STANDARD PLAN P8 DATED MAY 20, 2011 - PAGE 130 OF THE STANDARD PLANS BOOK DATED 2010.

REVISED STANDARD PLAN RSP P8


2010 REVISED STANDARD PLAN RSP P8

TO ACCOMPANY PLANS DATED 2-1-16


- NOTES:**
- See Revised Standard Plan RSP P1 for typical dowel bar placement and locations.
 - Where fresh concrete pavement is placed against new concrete or existing concrete pavement, rounding the corner of the existing concrete pavement is not required.
 - May also use 3/4" Dia dowel bars 2'-4" ± 1/4" in length. Center the length of dowel bars at the centerline of longitudinal joint.

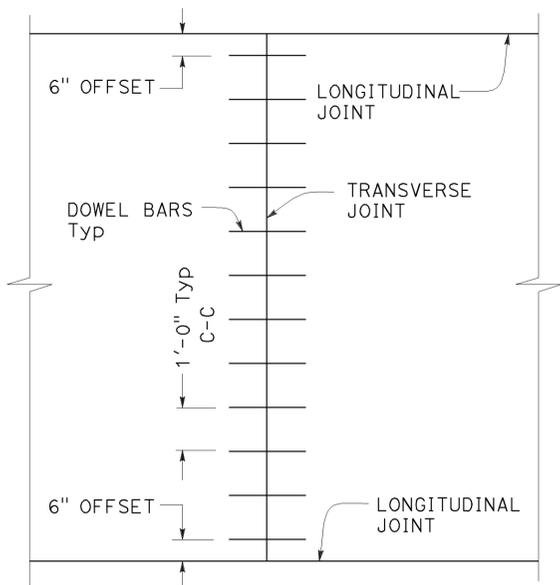


**TRANSVERSE JOINT
DOWEL BAR LAYOUT**

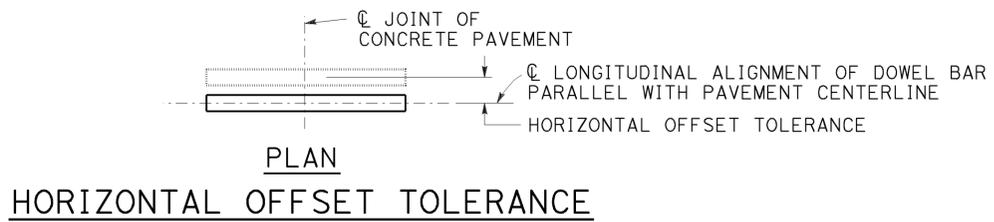


**PLAN
HORIZONTAL OFFSET TOLERANCE**

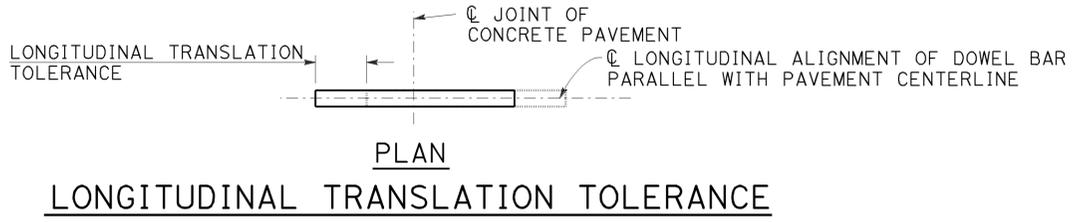


**PLAN
LONGITUDINAL TRANSLATION TOLERANCE**

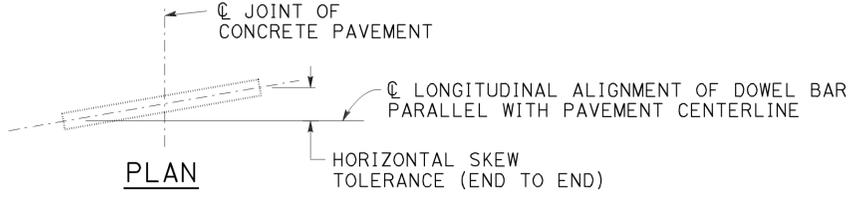


**PLAN
HORIZONTAL SKEW TOLERANCE**

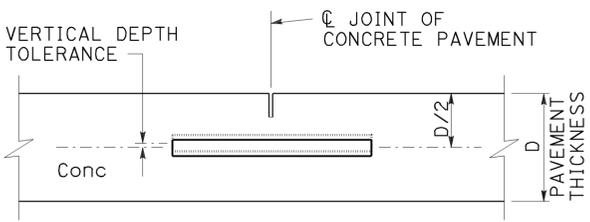


**ELEVATION
VERTICAL DEPTH TOLERANCE**

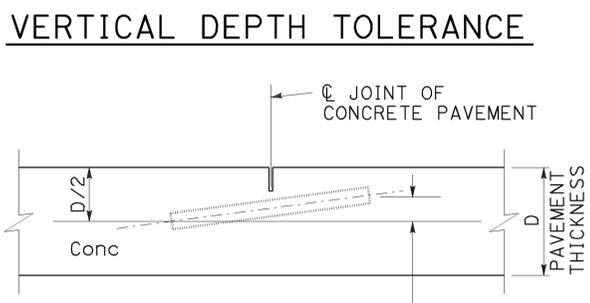


**ELEVATION
VERTICAL SKEW TOLERANCE**

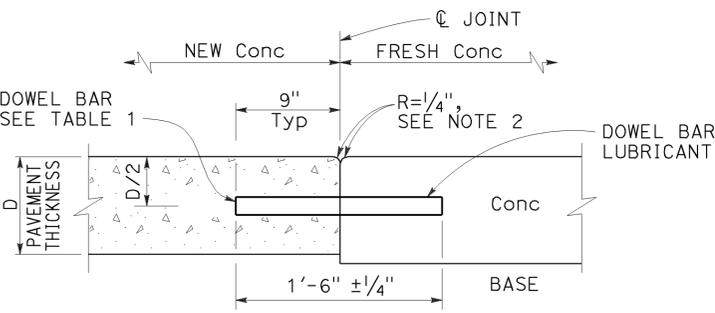

**TRANSVERSE
CONSTRUCTION JOINT DETAIL**

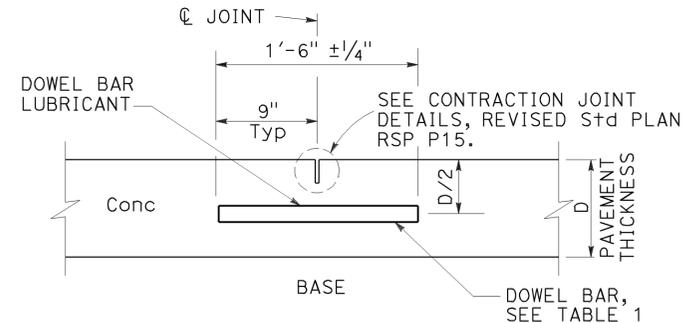

TRANSVERSE CONTRACTION JOINT

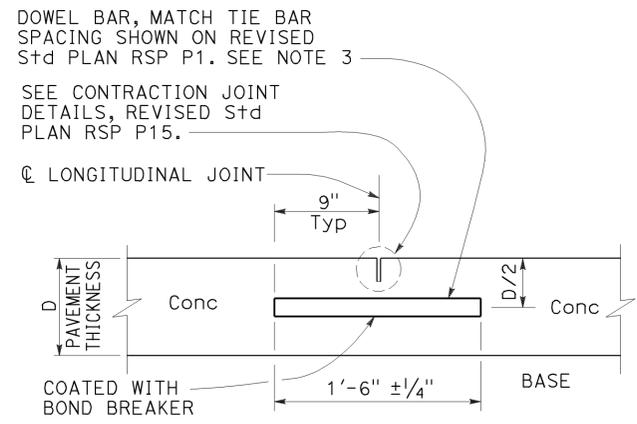


**LONGITUDINAL CONTRACTION
JOINT WITH DOWEL BARS**
See Revised Std Plan RSP P18


**TABLE 1
DOWEL BAR DIAMETER TABLE**

PAVEMENT THICKNESS	0.65'	> 0.65' - 0.85'	> 0.85'
MINIMUM DOWEL * BAR DIAMETER	1"	1 1/4"	1 1/2"

* The drilled hole diameter must be 1/8" to 3/16" larger than the bar diameter.

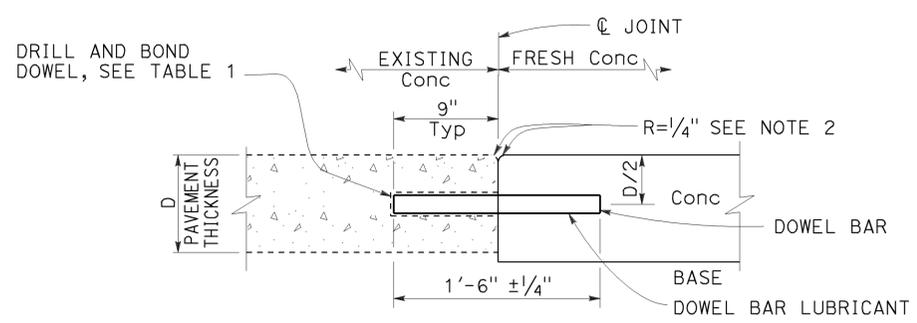

**TRANSVERSE CONSTRUCTION JOINT
FOR EXISTING CONCRETE PAVEMENT**

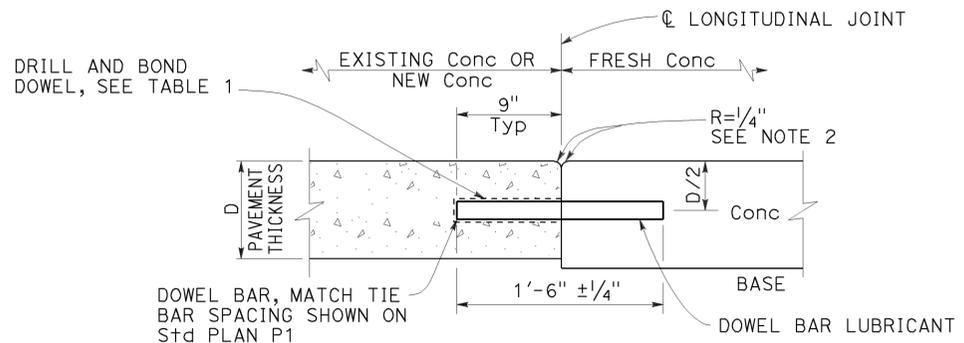

**LONGITUDINAL CONSTRUCTION JOINT
WITH DOWEL BARS**
See Revised Std Plan RSP P18

STATE OF CALIFORNIA
DEPARTMENT OF TRANSPORTATION
**CONCRETE PAVEMENT
DOWEL BAR
DETAILS**
NO SCALE

RSP P10 DATED JULY 19, 2013 SUPERSEDES RSP P10 DATED APRIL 20, 2012 AND STANDARD PLAN P10 DATED MAY 20, 2011 - PAGE 131 OF THE STANDARD PLANS BOOK DATED 2010.


2010 REVISED STANDARD PLAN RSP P10

Dist	COUNTY	ROUTE	POST MILES TOTAL PROJECT	SHEET No.	TOTAL SHEETS
07	LA	5	13.8/19.2	232	262


William K. Farnbach
 REGISTERED CIVIL ENGINEER
 July 19, 2013
 PLANS APPROVAL DATE
 THE STATE OF CALIFORNIA OR ITS OFFICERS OR AGENTS SHALL NOT BE RESPONSIBLE FOR THE ACCURACY OR COMPLETENESS OF SCANNED COPIES OF THIS PLAN SHEET.

REGISTERED PROFESSIONAL ENGINEER
 William K. Farnbach
 No. C49042
 Exp. 9-30-14
 CIVIL
 STATE OF CALIFORNIA


TO ACCOMPANY PLANS DATED 2-1-16

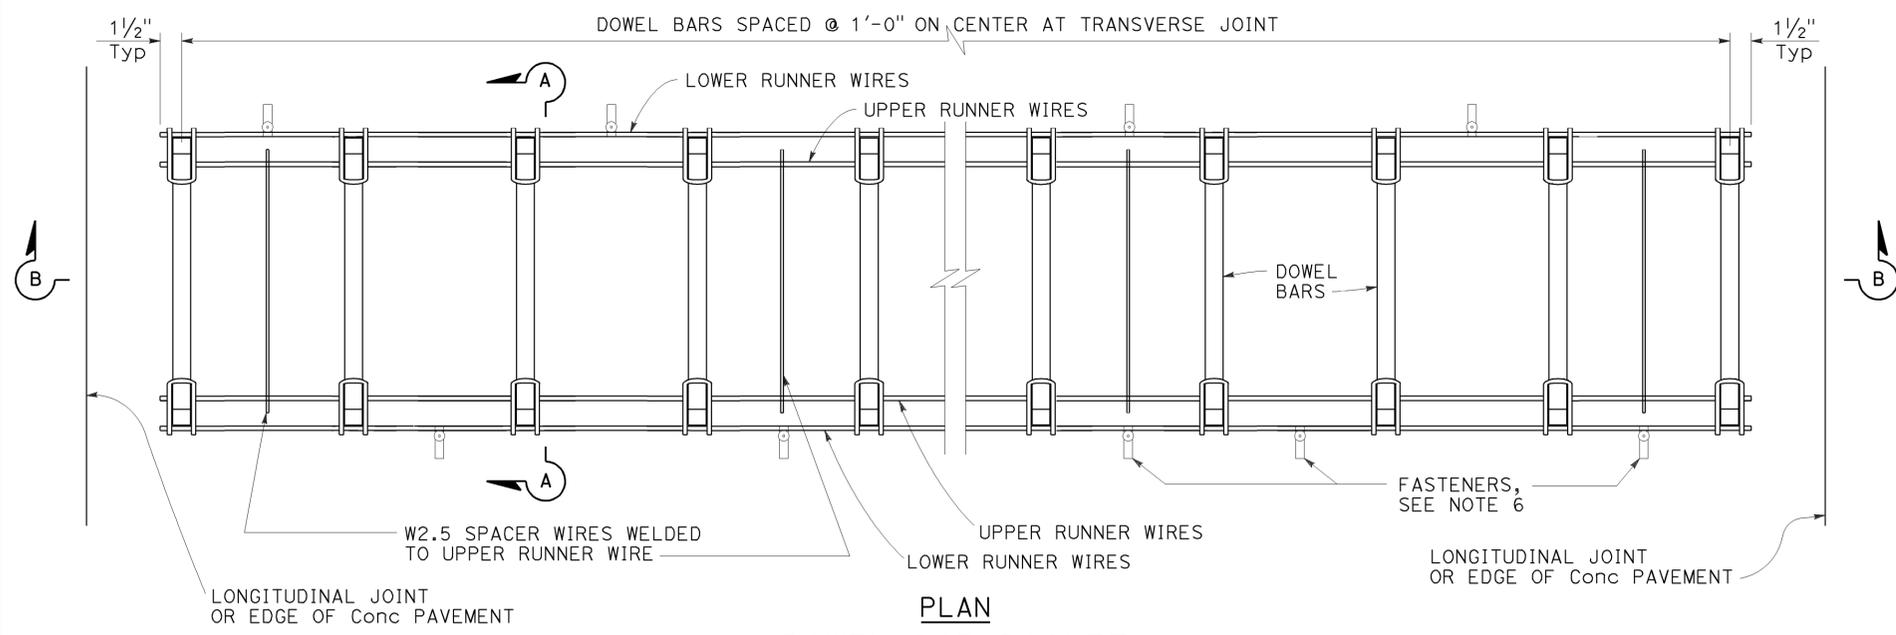


PLAN
DOWEL BAR BASKET
(TRANSVERSE JOINT)
 See Note 1

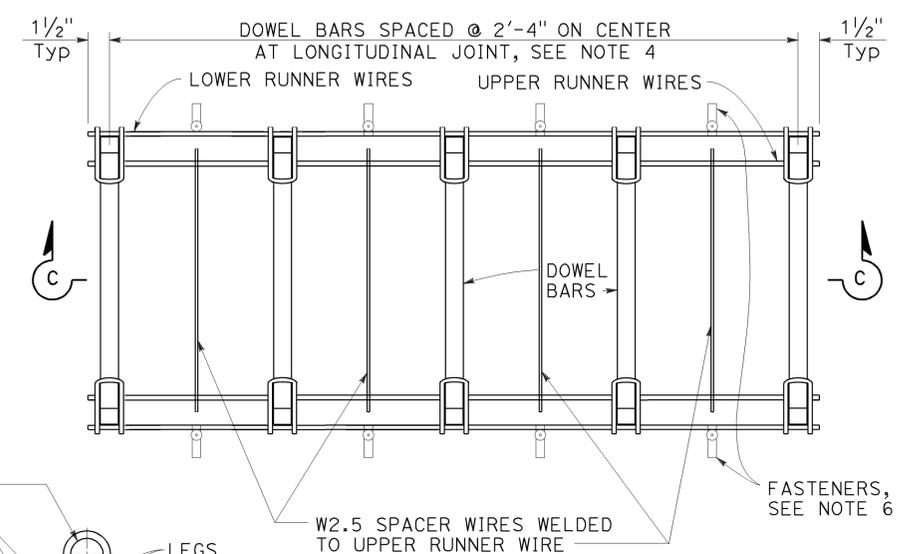


PLAN
DOWEL BAR BASKET
(LONGITUDINAL JOINT)
 See Note 1

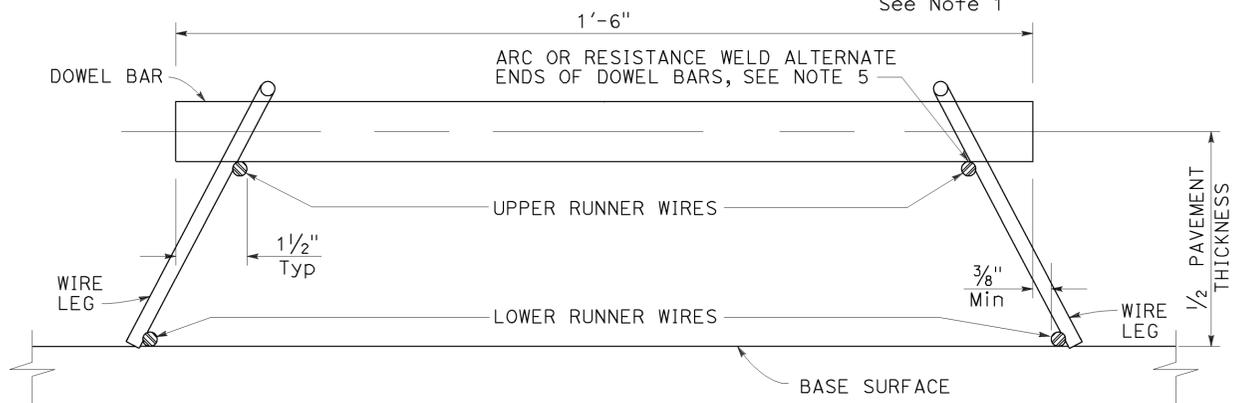


SECTION A-A

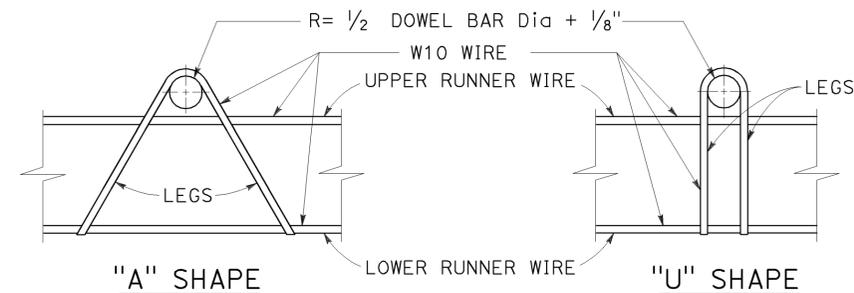


ASSEMBLY FRAME DETAILS

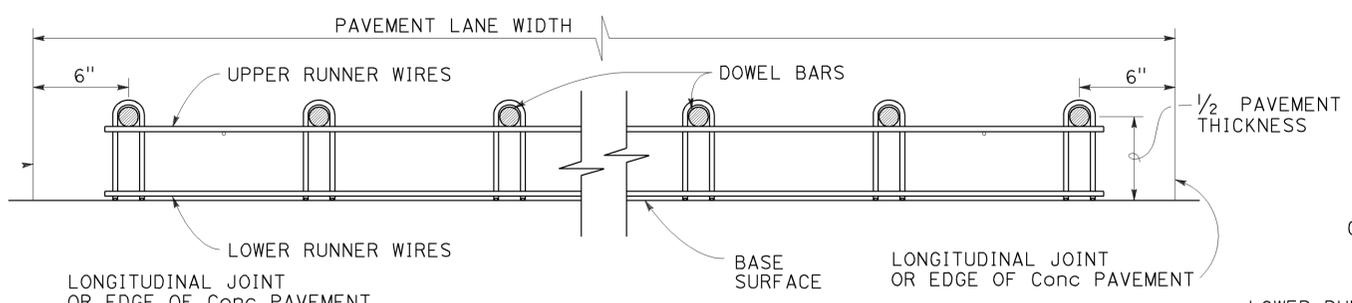

SECTION B-B

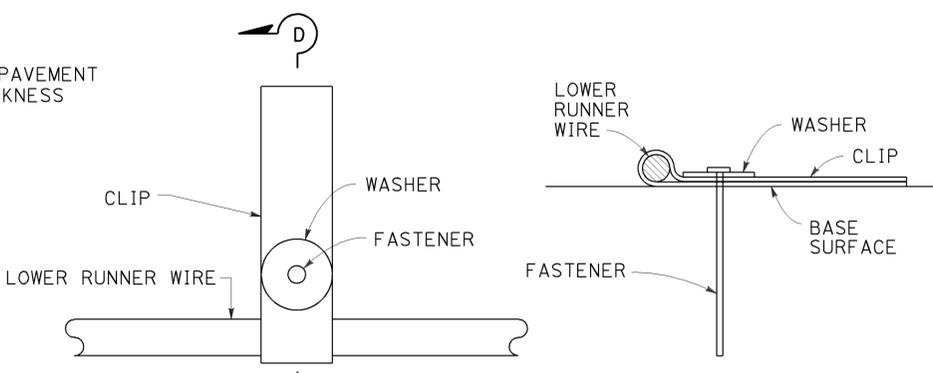

FASTENER DETAIL
 See Note 6

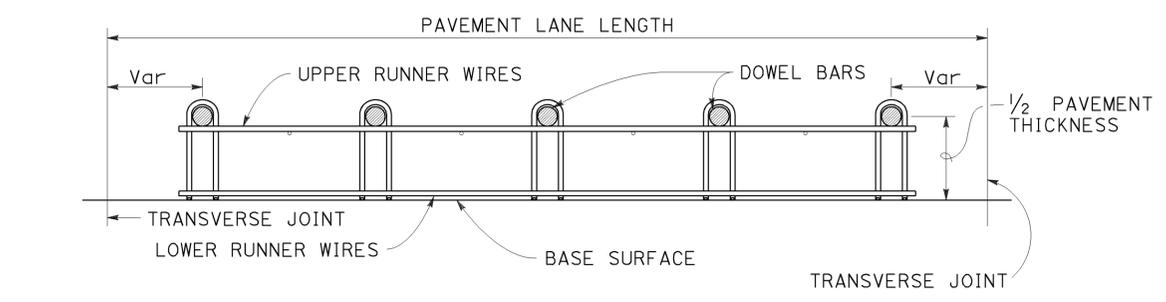

SECTION C-C
 See Notes 1 and 4

NOTES:

- "U" frame shape assembly shown. Use either "U" frame shape or "A" frame shape.
- Wire sizes shown are the minimum required.
- All wire intersections must be resistance welded.
- Use tie bar spacing for longitudinal dowel bar locations. See Revised Standard Plans RSP P1, RSP P2, RSP P3A, and RSP P3B for tie bar requirements.
- Weld may be at the top or bottom of the dowel bar.
- Use anchor pins where soil or granular base is used. See Revised Standard Plan RSP P17 for Anchor Pin Detail.

STATE OF CALIFORNIA
 DEPARTMENT OF TRANSPORTATION
CONCRETE PAVEMENT
DOWEL BAR BASKET
DETAILS
 NO SCALE

RSP P12 DATED JULY 19, 2013 SUPERSEDES STANDARD PLAN P12
 DATED MAY 20, 2011 - PAGE 132 OF THE STANDARD PLANS BOOK DATED 2010.

REVISED STANDARD PLAN RSP P12


2010 REVISED STANDARD PLAN RSP P12




TO ACCOMPANY PLANS DATED 2-1-16

NOTES:

1. Details do not apply to isolation joints and longitudinal construction joints.
2. Tie bars, dowel bars, and bar reinforcement are not shown.
3. Depths are measured from the final concrete pavement surface elevation after any grinding.

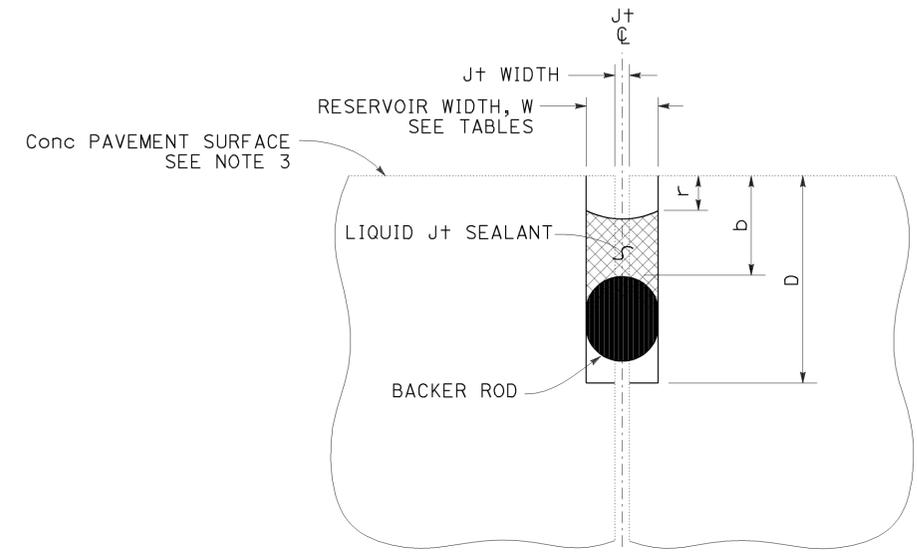

LIQUID JOINT SEALANT

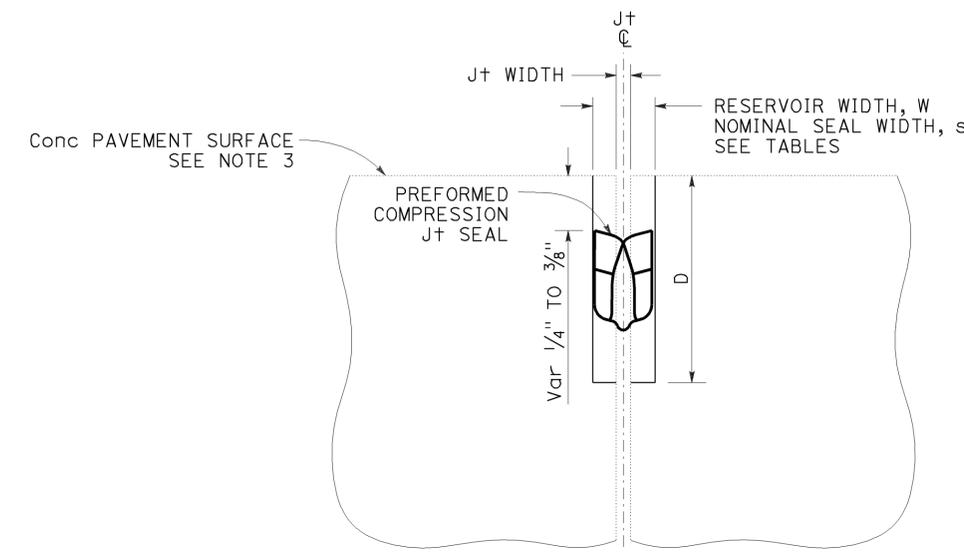

PREFORMED COMPRESSION JOINT SEAL

Const SEASON	Min RESERVOIR WIDTH * W ± 1/16"
WINTER	1/4"
SPRING	3/8"
SUMMER	
FALL	

* Minimum reservoir width for replace joint seal = existing joint width + 1/8"

RESERVOIR WIDTH W ± 1/16"	LIQUID JOINT SEALANT DIMENSIONS					
	BACKER ROD NOMINAL Dia *	DEPTHS (ASPHALT RUBBER) **		DEPTHS (SILICONE)		
		RESERVOIR D ± 1/4"	BACKER ROD b ± 1/16"	RESERVOIR D ± 1/4"	BACKER ROD b ± 1/16"	RECESS r ± 1/16"
1/4"	3/8"	1 3/4"	7/8"	1 3/8"	1/2"	1/4"
3/8"	1/2"	1 7/8"	7/8"	1 1/2"	1/2"	1/4"
1/2"	3/4"	2"	7/8"	1 3/4"	9/16"	5/16"
5/8"	7/8"	2 1/4"	1"	2"	5/8"	5/16"
3/4"	1"	2 3/4"	1 1/8"	2 1/4"	3/4"	3/8"
7/8"	1 1/4"	3"	1 1/4"	2 1/2"	13/16"	3/8"
1"	1 1/2"	3 1/4"	1 3/8"	2 5/8"	7/8"	3/8"
1 1/8"	1 1/2"	3 1/2"	1 1/2"	2 13/16"	1"	1/2"

* Larger diameter backer rods may be substituted according to manufacturer recommendations if reservoir depth is increased equivalently.

** Asphalt rubber sealant recess depth "r" varies from 1/4" to 3/8"

RESERVOIR WIDTH W ± 1/16"	PREFORMED COMPRESSION JOINT SEAL DIMENSIONS	
	NOMINAL SEAL WIDTH s	RESERVOIR DEPTH D ± 1/4"
1/4"	7/16"	1 1/4"
3/8"	11/16"	1 1/16"
1/2"	13/16"	1 1/8"
5/8"	1"	1 7/8"
3/4"	1 1/4"	2 1/8"
7/8"	1 5/8"	2 5/8"
1"	1 7/8"	2 3/8"
1 1/8"	2"	2 7/8"

STATE OF CALIFORNIA
DEPARTMENT OF TRANSPORTATION


JOINT SEALS

NO SCALE

RSP P20 DATED JULY 19, 2013 SUPERSEDES STANDARD PLAN P20
DATED MAY 20, 2011 - PAGE 136 OF THE STANDARD PLANS BOOK DATED 2010.

2010 REVISED STANDARD PLAN RSP P20

Dist	COUNTY	ROUTE	POST MILES TOTAL PROJECT	SHEET No.	TOTAL SHEETS
07	LA	5	13.8/19.2	234	262

 
 REGISTERED CIVIL ENGINEER
 July 19, 2013
 PLANS APPROVAL DATE



THE STATE OF CALIFORNIA OR ITS OFFICERS OR AGENTS SHALL NOT BE RESPONSIBLE FOR THE ACCURACY OR COMPLETENESS OF SCANNED COPIES OF THIS PLAN SHEET.

TO ACCOMPANY PLANS DATED 2-1-16

TABLE 1

TAPER LENGTH CRITERIA AND CHANNELIZING DEVICE SPACING							
SPEED (S)	MINIMUM TAPER LENGTH * FOR WIDTH OF OFFSET 12 FEET (W)				MAXIMUM CHANNELIZING DEVICE SPACING		
	TANGENT 2L	MERGING L	SHIFTING L/2	SHOULDER L/3	Z **		
					TAPER	TANGENT	CONFLICT
mph	ft	ft	ft	ft	ft	ft	ft
20	160	80	40	27	20	40	10
25	250	125	63	42	25	50	12
30	360	180	90	60	30	60	15
35	490	245	123	82	35	70	17
40	640	320	160	107	40	80	20
45	1080	540	270	180	45	90	22
50	1200	600	300	200	50	100	25
55	1320	660	330	220	55	110	27
60	1440	720	360	240	60	120	30
65	1560	780	390	260	65	130	32
70	1680	840	420	280	70	140	35

* - For other offsets, use the following merging taper length formula for L:
 For speed of 40 mph or less, $L = WS^2/60$
 For speed of 45 mph or more, $L = WS$

Where: L = Taper length in feet
 W = Width of offset in feet
 S = Posted speed limit, off-peak 85th-percentile speed prior to work starting, or the anticipated operating speed in mph

** - Use for taper and tangent sections where there are no pavement markings or where there is a conflict between existing pavement markings and channelizers (CA).

TABLE 2

LONGITUDINAL BUFFER SPACE AND FLAGGER STATION SPACING				
SPEED *	Min D **	DOWNGRADE Min D ***		
		-3%	-6%	-9%
		ft	ft	ft
20	115	116	120	126
25	155	158	165	173
30	200	205	215	227
35	250	257	271	287
40	305	315	333	354
45	360	378	400	427
50	425	446	474	507
55	495	520	553	593
60	570	598	638	686
65	645	682	728	785
70	730	771	825	891

* - Speed is posted speed limit, off-peak 85th-percentile speed prior to work starting, or the anticipated operating speed in mph
 ** - Longitudinal buffer space or flagger station spacing
 *** - Use on sustained downgrade steeper than -3 percent and longer than 1 mile.

TABLE 3

ADVANCE WARNING SIGN SPACING			
ROAD TYPE	DISTANCE BETWEEN SIGNS *		
	A	B	C
	ft	ft	ft
URBAN - 25 mph OR LESS	100	100	100
URBAN - MORE THAN 25 mph TO 40 mph	250	250	250
URBAN - MORE THAN 40 mph	350	350	350
RURAL	500	500	500
EXPRESSWAY / FREEWAY	1000	1500	2640

* - The distances are approximate, are intended for guidance purposes only, and should be applied with engineering judgment. These distances should be adjusted by the Engineer for field conditions, if necessary, by increasing or decreasing the recommended distances.

STATE OF CALIFORNIA
 DEPARTMENT OF TRANSPORTATION

TRAFFIC CONTROL SYSTEM TABLES FOR LANE AND RAMP CLOSURES

NO SCALE

RSP T9 DATED JULY 19, 2013 SUPERSEDES RSP T9 DATED APRIL 19, 2013 THAT SUPPLEMENTS THE STANDARD PLANS BOOK DATED 2010.

REVISED STANDARD PLAN RSP T9


2010 REVISED STANDARD PLAN RSP T9

DIST	COUNTY	ROUTE	POST MILES TOTAL PROJECT	SHEET No.	TOTAL SHEETS
07	LA	5	13.8/19.2	235	262

REGISTERED CIVIL ENGINEER
 April 19, 2013
 PLANS APPROVAL DATE

Gurinderpal Bhullar
 No. C48815
 Exp. 9-30-14
 CIVIL ENGINEER
 STATE OF CALIFORNIA

THE STATE OF CALIFORNIA OR ITS OFFICERS OR AGENTS SHALL NOT BE RESPONSIBLE FOR THE ACCURACY OR COMPLETENESS OF SCANNED COPIES OF THIS PLAN SHEET.

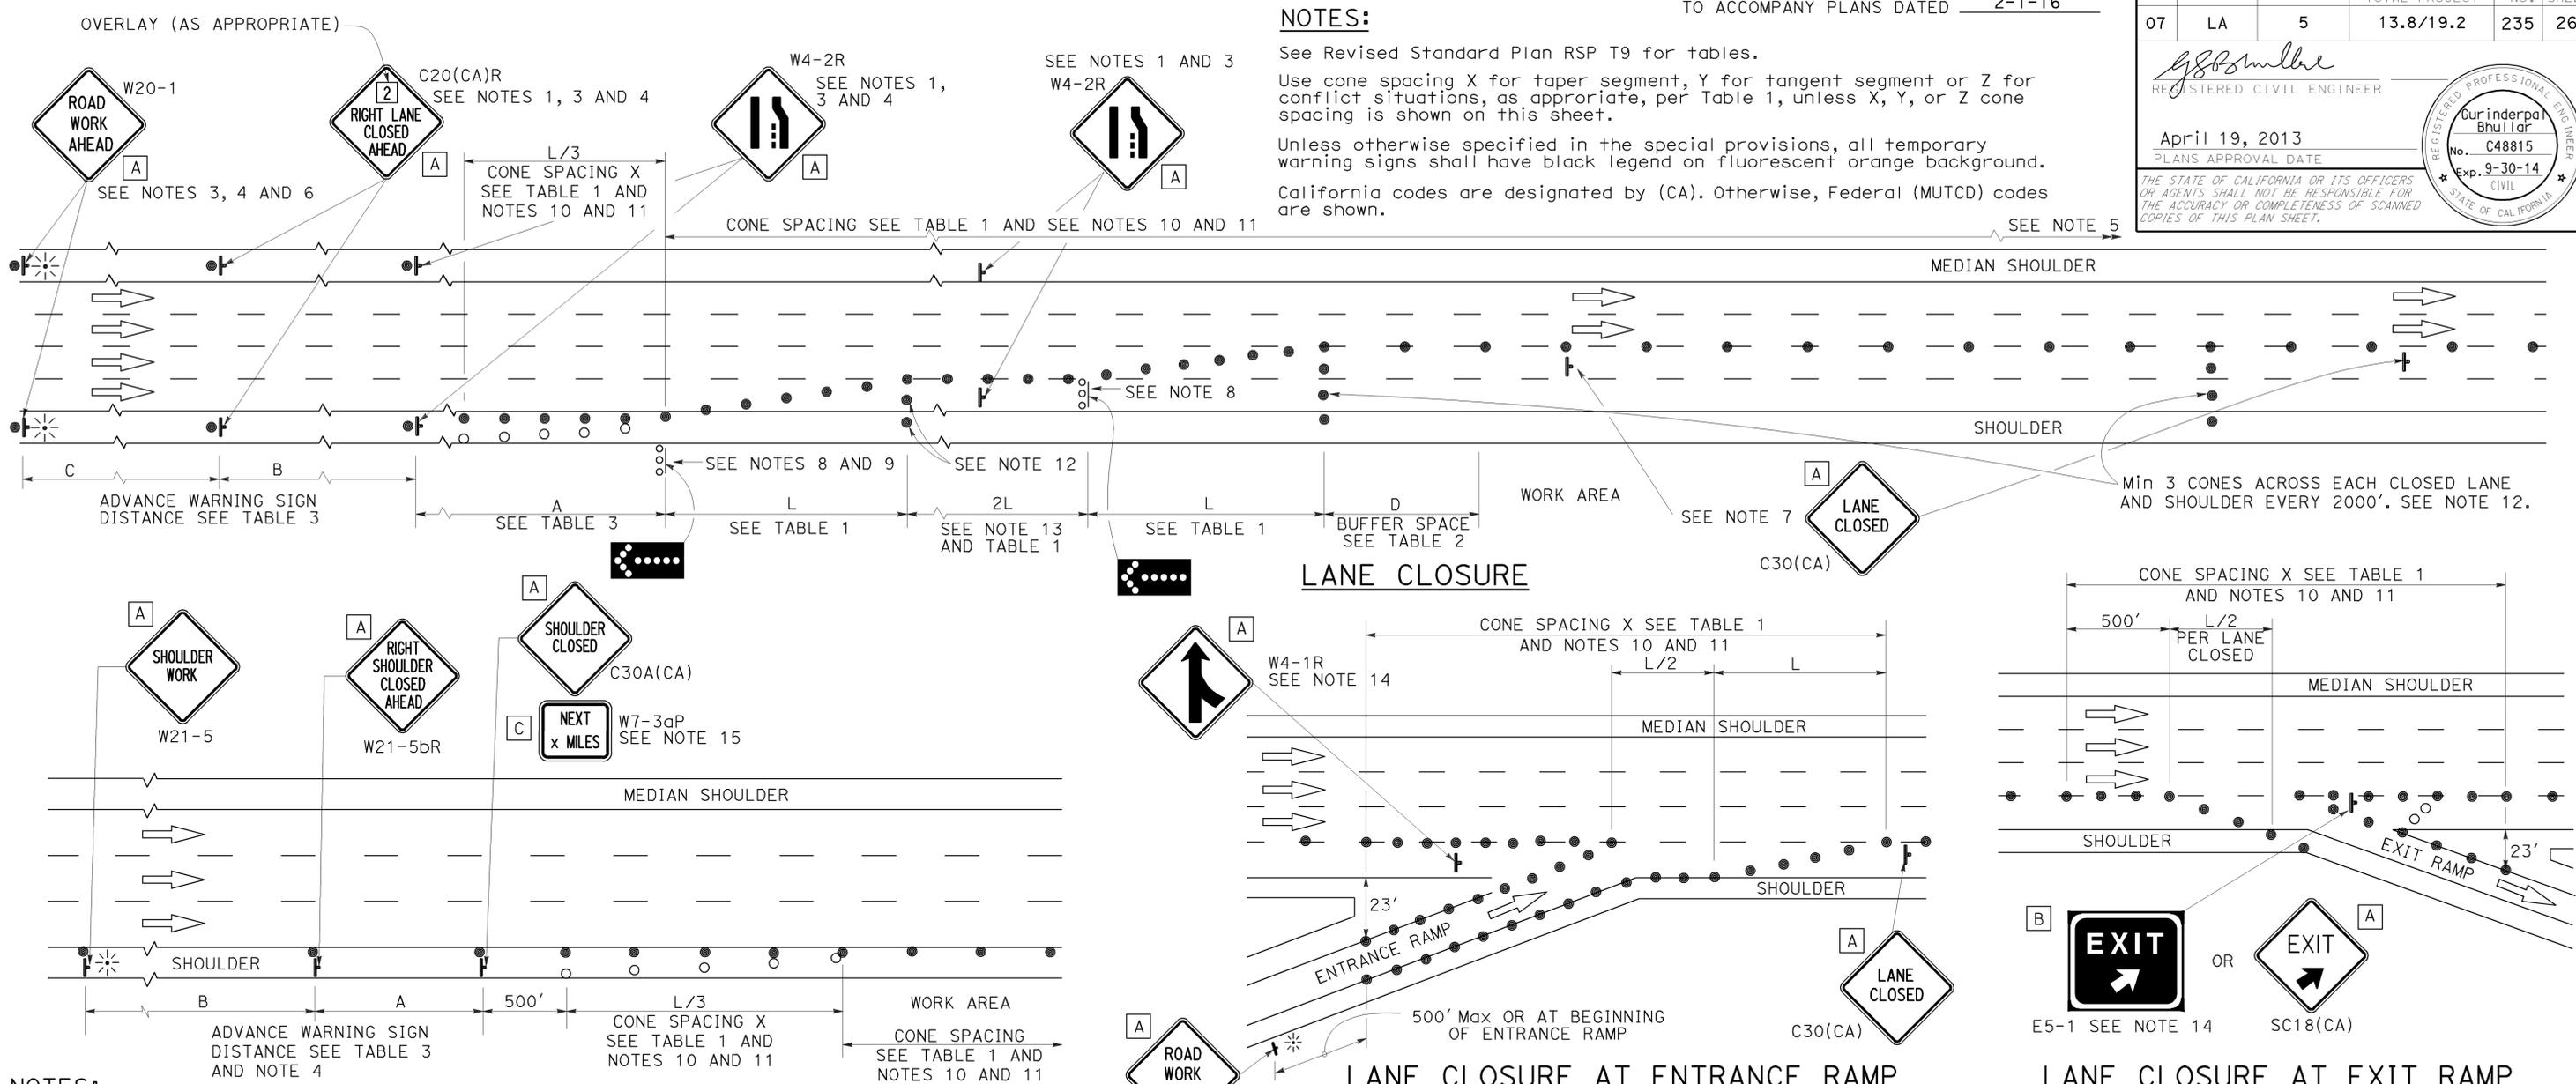

- NOTES:**
1. Median lane closures shall conform to the details as shown except that C20(CA)L and W4-2L signs shall be used.
 2. At least one person shall be assigned to provide full time maintenance of traffic control devices for lane closures.
 3. Duplicate sign installations are not required:
 - a) On opposite shoulder if at least one-half of the available lanes remain open to traffic.
 - b) In the median if the width of the median shoulder is less than 8' and the outside lanes are to be closed.
 4. Each advance warning sign on each side of the roadway shall be equipped with at least two flags for daytime closure. Each flag shall be at least 16" x 16" in size and shall be orange or fluorescent red-orange in color. Flashing beacons shall be placed at the locations indicated for lane closure during hours of darkness.
 5. A G20-2 "END ROAD WORK" sign, with minimum size of 48" x 24" as appropriate, shall be placed at the end of the lane closure unless the end of work area is obvious or ends within a larger project's limits.

- SHOULDER CLOSURE**
6. If the W20-1 sign would follow within 2000' of a stationary W20-1 or G20-1 "ROAD WORK NEXT _____ MILES", use a C20(CA)L and W4-2L signs shall be used.
 7. Place a C30(CA) sign every 2000' throughout length of lane closure.
 8. One flashing arrow sign for each lane closed. The flashing arrow signs shall be Type I.
 9. A minimum 1500' of sight distance shall be provided where possible for vehicles approaching the first flashing arrow sign. Lane closures shall not begin at top of crest vertical curve or on a horizontal curve.
 10. All cones used for lane closures during the hours of darkness shall be fitted with retroreflective bands (or sleeves) as specified in the specifications.
 11. Portable delineators, placed at one-half the spacing indicated for traffic cones may be used instead of cones for daytime closures only.

- LANE CLOSURE AT ENTRANCE RAMP**
- LANE CLOSURE AT EXIT RAMP**
12. Unless otherwise specified in the special provisions, a minimum of 3 cones shall be placed transversely across each closed lane and shoulder at each location where a taper across a traffic lane ends and every 2000' as shown on the "Lane Closure" detail. Two Type II barricades may be used instead of the 3 cones. The transverse alignment of the cones or barricades on the closed shoulder may be shifted from the transverse alignment to provide access to the work.
 13. Unless otherwise specified in the special provisions, the 2L tangent shown along lane lines shall be used between the L tapers required for each closed traffic lane.
 14. Unless otherwise specified in the special provisions, the E5-1 or SC18(CA) and W4-1 signs shall be used as shown.
 15. A W7-3aP "NEXT _____ MILES" plaque must be used if the shoulder closure extends beyond the distance that can be perceived by road users.

LEGEND

- TRAFFIC CONE
- TRAFFIC CONE (OPTIONAL TAPER)
- † TEMPORARY TRAFFIC CONTROL SIGN
- FLASHING ARROW SIGN (FAS)
- FAS SUPPORT OR TRAILER
- ⚡ PORTABLE FLASHING BEACON

SIGN PANEL SIZE (Min)

A	48" x 48"
B	72" x 60"
C	36" x 30"

STATE OF CALIFORNIA
 DEPARTMENT OF TRANSPORTATION

**TRAFFIC CONTROL SYSTEM
 FOR LANE CLOSURE ON
 FREEWAYS AND EXPRESSWAYS**

NO SCALE

RSP T10 DATED APRIL 19, 2013 SUPERSEDES STANDARD PLAN T10 DATED MAY 20, 2011 - PAGE 237 OF THE STANDARD PLANS BOOK DATED 2010.

REVISED STANDARD PLAN RSP T10

2010 REVISED STANDARD PLAN RSP T10

DIST	COUNTY	ROUTE	POST MILES TOTAL PROJECT	SHEET No.	TOTAL SHEETS
07	LA	5	13.8/19.2	236	262


REGISTERED CIVIL ENGINEER
 Gurinderpal Bhullar
 No. C48815
 Exp. 9-30-14
 CIVIL
 STATE OF CALIFORNIA

April 19, 2013
 PLANS APPROVAL DATE

THE STATE OF CALIFORNIA OR ITS OFFICERS OR AGENTS SHALL NOT BE RESPONSIBLE FOR THE ACCURACY OR COMPLETENESS OF SCANNED COPIES OF THIS PLAN SHEET.


NOTES: See Revised Standard Plan RSP T9 for tables.
 Use cone spacing X for taper segment, Y for tangent segment or Z for conflict situations, as appropriate, per Table 1, unless X, Y, or Z cone spacing is shown on this sheet.
 Unless otherwise specified in the special provisions, all temporary warning signs shall have black legend on fluorescent orange background.
 California codes are designated by (CA). Otherwise, Federal (MUTCD) codes are shown.

SEE NOTES 3 AND 5

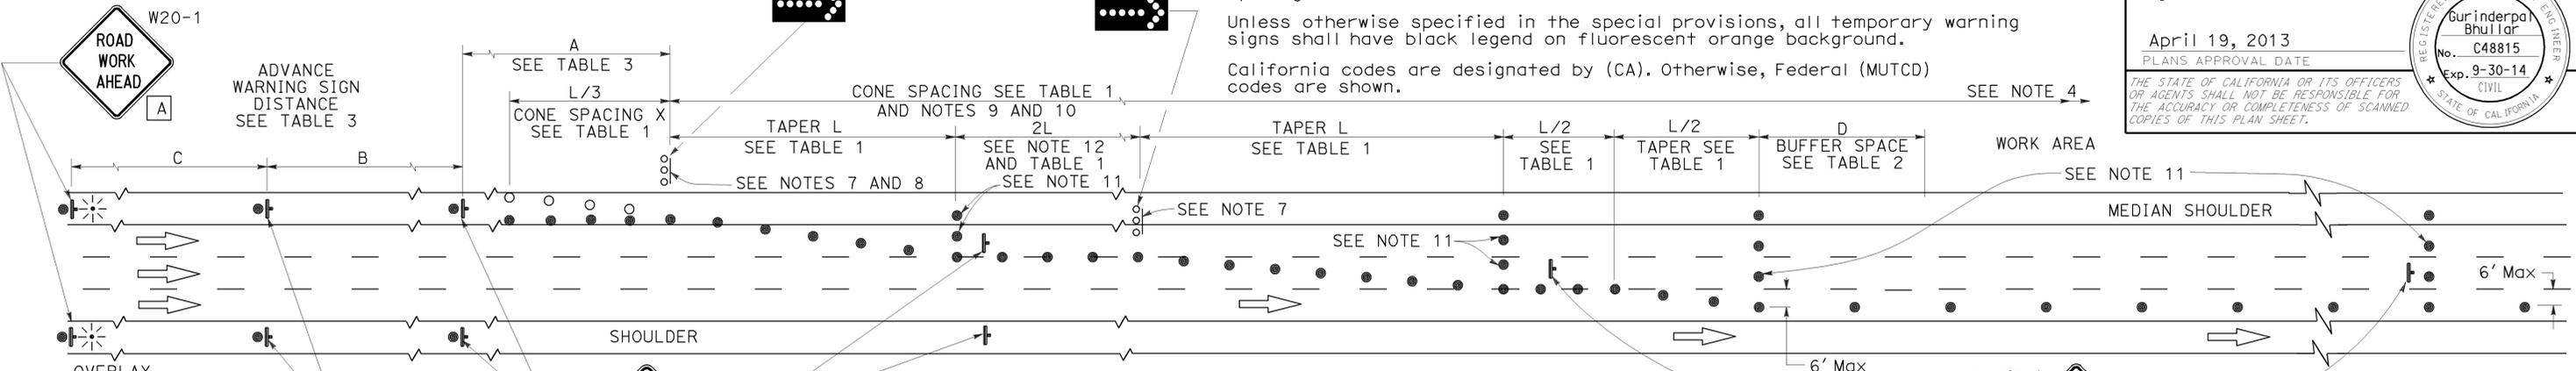

LANE CLOSURE WITH PARTIAL SHOULDER USE

SEE NOTES 3 AND 5

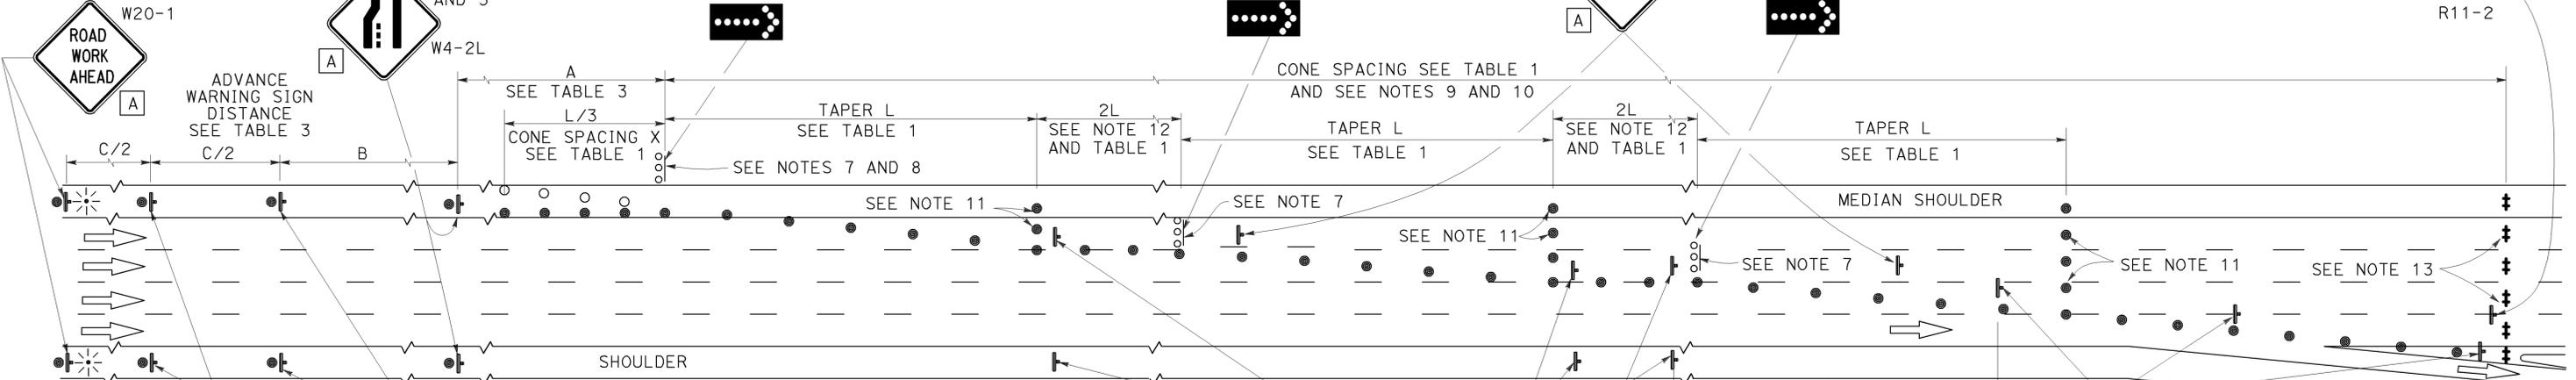

COMPLETE CLOSURE

NOTES:

- Lane closures on the right side using partial median shoulder as a traffic lane shall conform to the details as shown except that C20(CA)R and W4-2R signs shall be used.
- At least one person shall be assigned to provide full time maintenance of traffic control devices for lane closures.
- Each advance warning sign on each side of the roadway shall be equipped with at least two flags for daytime closure. Each flag shall be at least 16" X 16" in size and shall be orange or fluorescent red-orange in color. Flashing beacons shall be placed at the locations indicated for lane closure during hours of darkness.
- A G20-2 "END ROAD WORK" sign, with minimum size of 48" x 24" as appropriate, shall be placed at the end of the lane closure unless the end of work area is obvious or ends within a larger project's limits.
- If the W20-1 sign would follow within 2000' of a stationary W20-1 or G20-1 "ROAD WORK NEXT ___ MILES", use a C20(CA) sign for the first advance warning sign.
- Place a C30(CA) sign every 2000' throughout length of lane closure.
- One flashing arrow sign for each lane closed. The flashing arrow signs shall be Type I.
- A minimum 1500' of sight distance shall be provided where possible for vehicles approaching the first flashing arrow sign. Lane closures shall not begin at the top of crest vertical curve or on a horizontal curve.
- All cones used for lane closures during the hours of darkness shall be fitted with retroreflective bands (or sleeves) as specified in the specifications.
- Portable delineators, placed at one-half the spacing indicated for traffic cones, may be used instead of cones for daytime closures only.
- Unless otherwise specified in the special provisions, a minimum of 3 cones shall be placed transversely across each closed lane and shoulder at each location where a taper across a traffic lane ends and every 2000' as shown on the "Lane Closure With Partial Shoulder Use" detail. Two Type II barricades may be used instead of the 3 cones. The transverse alignment of the cones or barricades on the closed shoulder may be shifted from the transverse alignment to provide access to the work.

- Unless otherwise specified in the special provisions, the 2L tangent shown along lane lines shall be used between the L tapers required for each closed traffic lane.
- A minimum of Two Type II or III barricades shall be placed across each closed lane and shoulder at the location shown and every 2000' within the complete closure area. Within the complete closure area, the transverse alignment of the barricades on the closed shoulder may be shifted from the transverse alignment to provide access to the work.
- When specified in the special provisions, a W20-2 "DETOUR AHEAD" sign is to be used in place of the W20-3 "FREEWAY CLOSED AHEAD" sign.

SIGN PANEL SIZE (Min)

- A 48" x 48"
- B 48" x 18"
- C 48" x 30"

LEGEND

- TRAFFIC CONE
- TRAFFIC CONE (OPTIONAL TAPER)
- † TEMPORARY TRAFFIC CONTROL SIGN
- FLASHING ARROW SIGN (FAS)
- FAS SUPPORT OR TRAILER
- ⚡ PORTABLE FLASHING BEACON


STATE OF CALIFORNIA
 DEPARTMENT OF TRANSPORTATION
**TRAFFIC CONTROL SYSTEM
 FOR LANE CLOSURES ON
 FREEWAYS AND EXPRESSWAYS**
 NO SCALE

RSP T10A DATED APRIL 19, 2013 SUPERSEDES STANDARD PLAN T10A DATED MAY 20, 2011 - PAGE 238 OF THE STANDARD PLANS BOOK DATED 2010.

REVISED STANDARD PLAN RSP T10A

2010 REVISED STANDARD PLAN RSP T10A


Dist	COUNTY	ROUTE	POST MILES TOTAL PROJECT	SHEET No.	TOTAL SHEETS
07	LA	5	13.8/19.2	237	262

 
 REGISTERED CIVIL ENGINEER
 April 19, 2013
 PLANS APPROVAL DATE

THE STATE OF CALIFORNIA OR ITS OFFICERS OR AGENTS SHALL NOT BE RESPONSIBLE FOR THE ACCURACY OR COMPLETENESS OF SCANNED COPIES OF THIS PLAN SHEET.

TO ACCOMPANY PLANS DATED 2-1-16

2010 REVISED STANDARD PLAN RSP T11

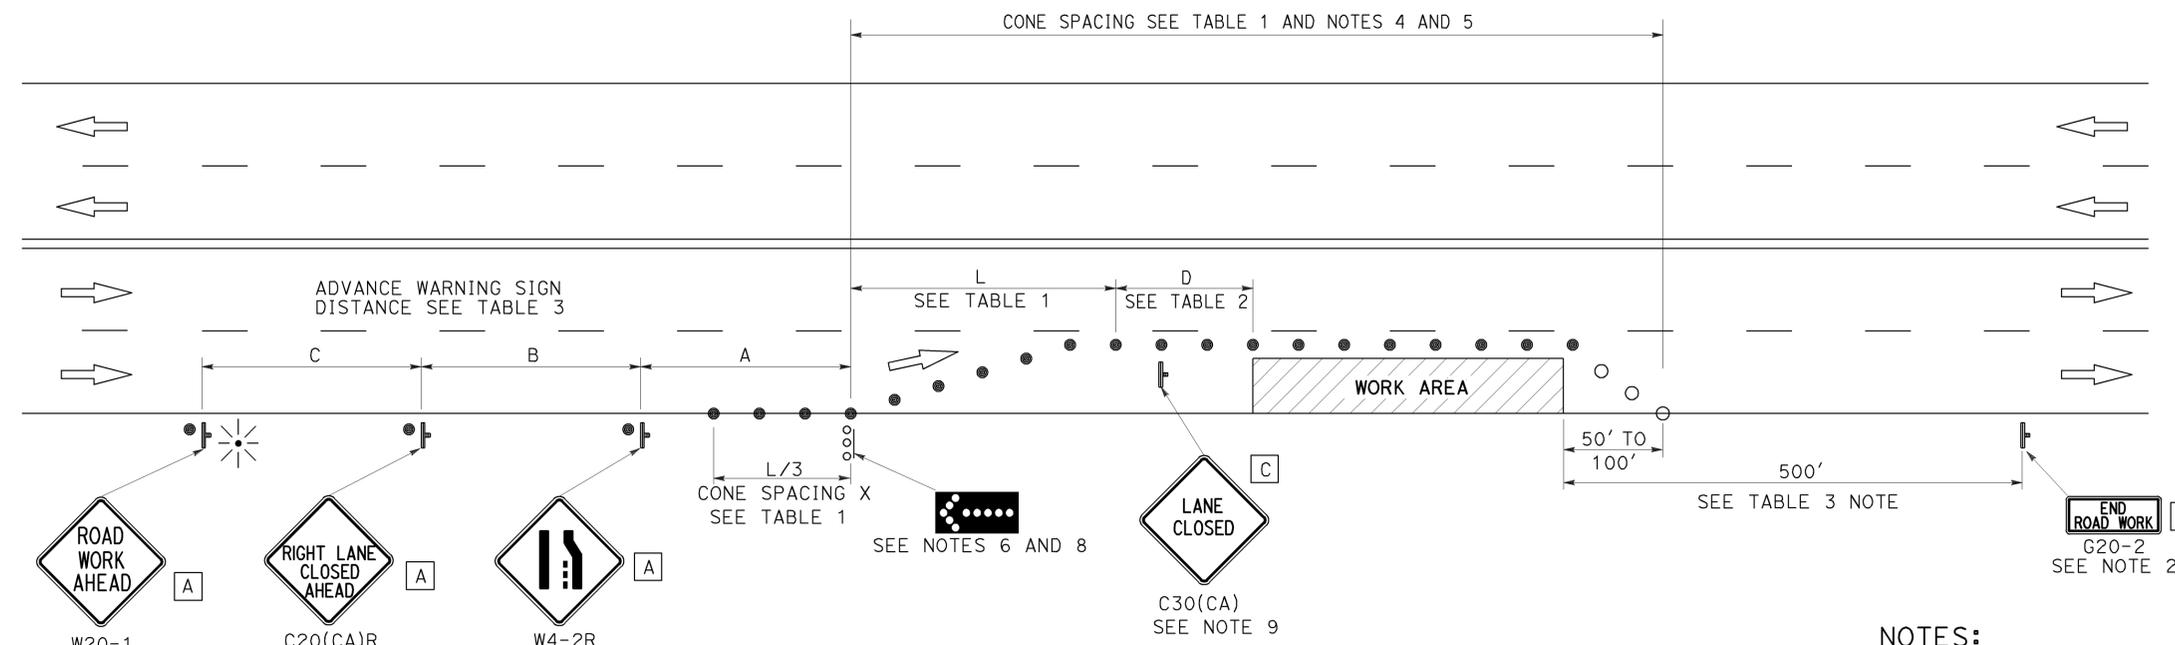

TYPICAL LANE CLOSURE

NOTES:

See Revised Standard Plan RSP T9 for tables.

Use cone spacing X for taper segment, Y for tangent segment or Z for conflict situations, as appropriate, per Table 1, unless X, Y, or Z cone spacing is shown on this sheet.

Unless otherwise specified in the special provisions, all temporary warning signs shall have black legend on fluorescent orange background.

California codes are designated by (CA). Otherwise, Federal (MUTCD) codes are shown.

NOTES:

- Each advance warning sign shall be equipped with at least two flags for daytime closure. Each flag shall be at least 16" x 16" in size and shall be orange or fluorescent red-orange in color. Flashing beacons shall be placed at the locations indicated for lane closure during hours of darkness.
- A G20-2 "END ROAD WORK" sign, as appropriate, shall be placed at the end of the lane closure unless the end of work area is obvious, or ends within a larger project's limits.
- If the W20-1 sign would follow within 2000' of a stationary W20-1 or G20-1 "ROAD WORK NEXT _____ MILES", use a C20(CA) sign for the first advance warning sign.
- All cones used for lane closures during the hours of darkness shall be fitted with retroreflective bands (or sleeves) as specified in the specifications.
- Portable delineators, placed at one-half the spacing indicated for traffic cones, may be used instead of cones for daytime closures only.
- Flashing arrow sign shall be either Type I or Type II.
- For approach speeds over 50 mph, use the "Traffic Control System for Lane Closure On Freeways And Expressways" plan for lane closure details and requirements.
- A minimum 1500' of sight distance shall be provided where possible for vehicles approaching the first flashing arrow sign. Lane closures shall not begin at the top of crest vertical curve or on a horizontal curve.
- Place a C30(CA) sign every 2000' throughout length of lane closure.
- Median lane closures shall conform to the details as shown except that C20(CA)L and W4-2L signs shall be used.
- At least one person shall be assigned to provide full time maintenance of traffic control devices for lane closure unless, otherwise directed by the Engineer.

LEGEND

- TRAFFIC CONE
- TRAFFIC CONE (OPTIONAL TAPER)
- ⌋ TEMPORARY TRAFFIC CONTROL SIGN
-  FLASHING ARROW SIGN (FAS)
-  FAS SUPPORT OR TRAILER
-  PORTABLE FLASHING BEACON

SIGN PANEL SIZE (Min)

- A 48" x 48"
- B 36" x 18"
- C 30" x 30"

STATE OF CALIFORNIA
DEPARTMENT OF TRANSPORTATION

**TRAFFIC CONTROL SYSTEM
FOR LANE CLOSURE ON
MULTILANE CONVENTIONAL
HIGHWAYS**

NO SCALE

RSP T11 DATED APRIL 19, 2013 SUPERSEDES STANDARD PLAN T11 DATED MAY 20, 2011 - PAGE 239 OF THE STANDARD PLANS BOOK DATED 2010.

REVISED STANDARD PLAN RSP T11

TYPICAL RAMP CLOSURES

SIGN PANEL SIZE (Min)

- A 48" x 48"
- B 48" x 30"
- C 36" x 36"
- D 48" x 36"

LEGEND

- TRAFFIC CONE
- † TEMPORARY TRAFFIC CONTROL SIGN
- ‡ BARRICADES
- ⚡ PORTABLE FLASHING BEACON


Dist	COUNTY	ROUTE	POST MILES TOTAL PROJECT	SHEET No.	TOTAL SHEETS
07	LA	5	13.8/19.2	238	262

Gurinderpal Bhullar
 REGISTERED CIVIL ENGINEER
 April 19, 2013
 PLANS APPROVAL DATE


THE STATE OF CALIFORNIA OR ITS OFFICERS OR AGENTS SHALL NOT BE RESPONSIBLE FOR THE ACCURACY OR COMPLETENESS OF SCANNED COPIES OF THIS PLAN SHEET.

TO ACCOMPANY PLANS DATED 2-1-16


2010 REVISED STANDARD PLAN RSP T14

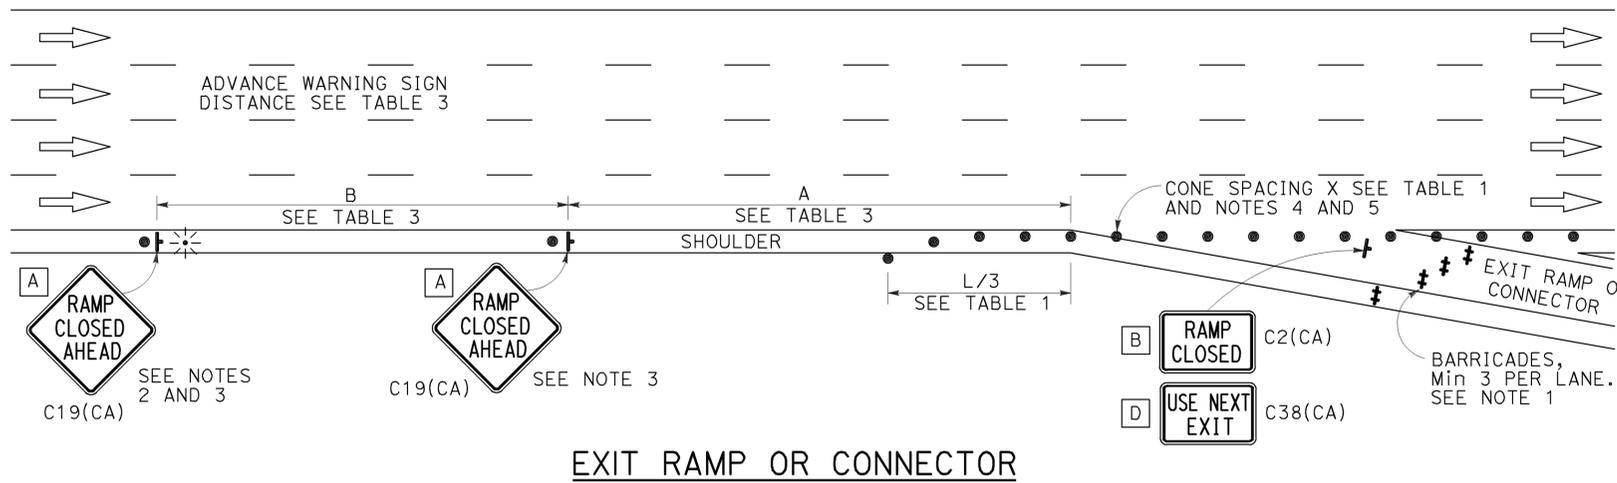


EXIT RAMP OR CONNECTOR

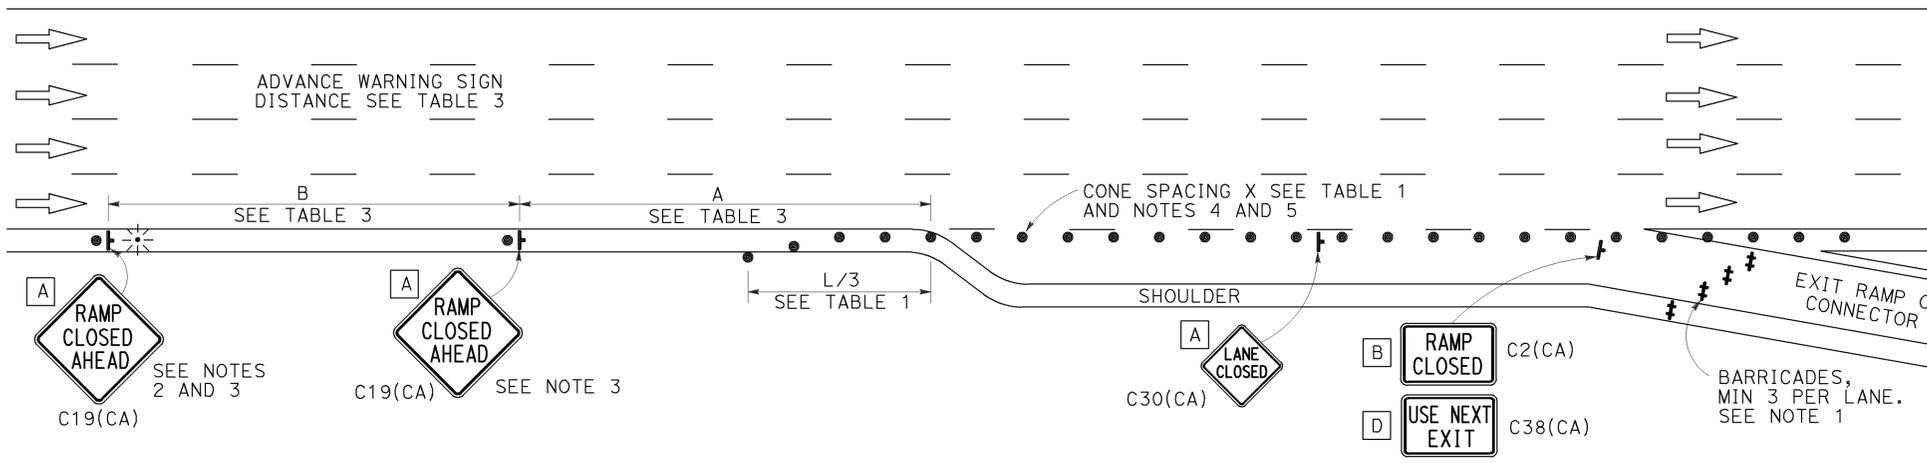

EXIT RAMP OR CONNECTOR WITH ADDITIONAL LANE

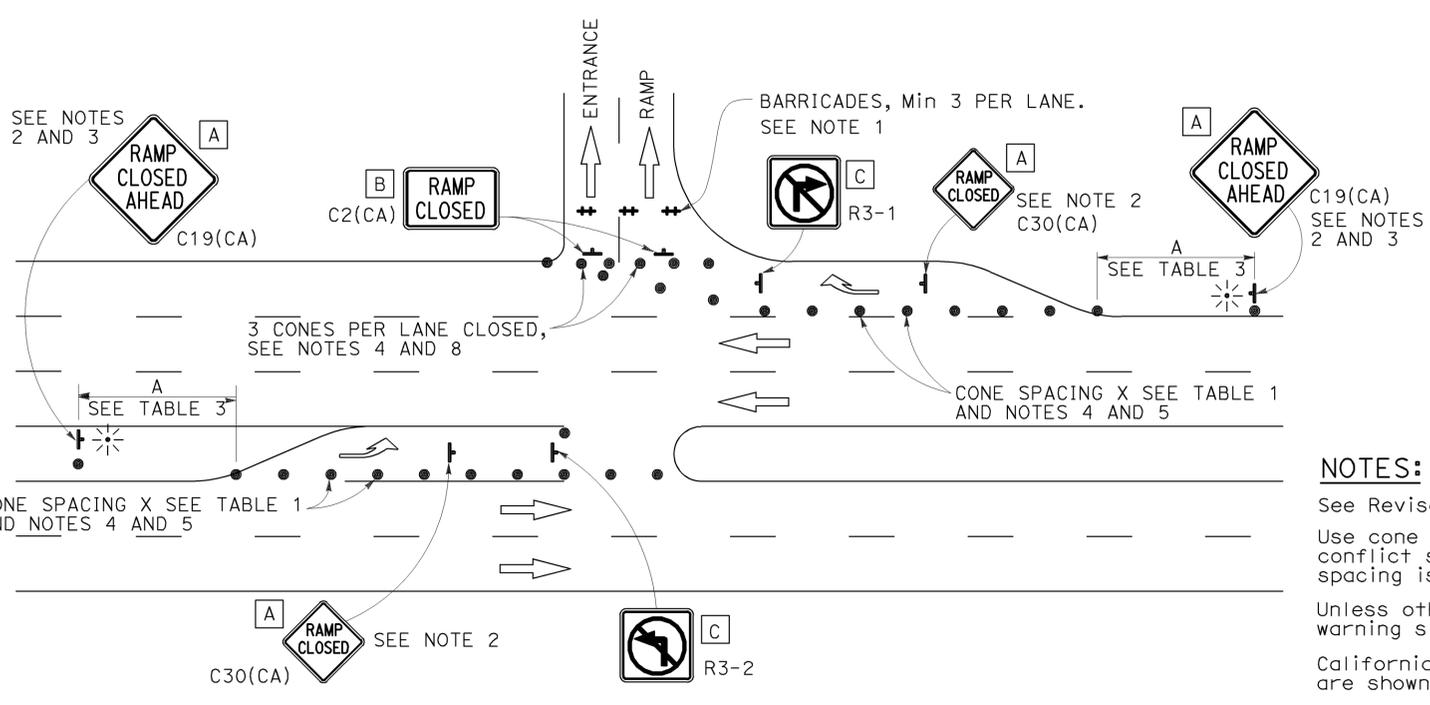

ENTRANCE RAMP WITH TURNING POCKETS

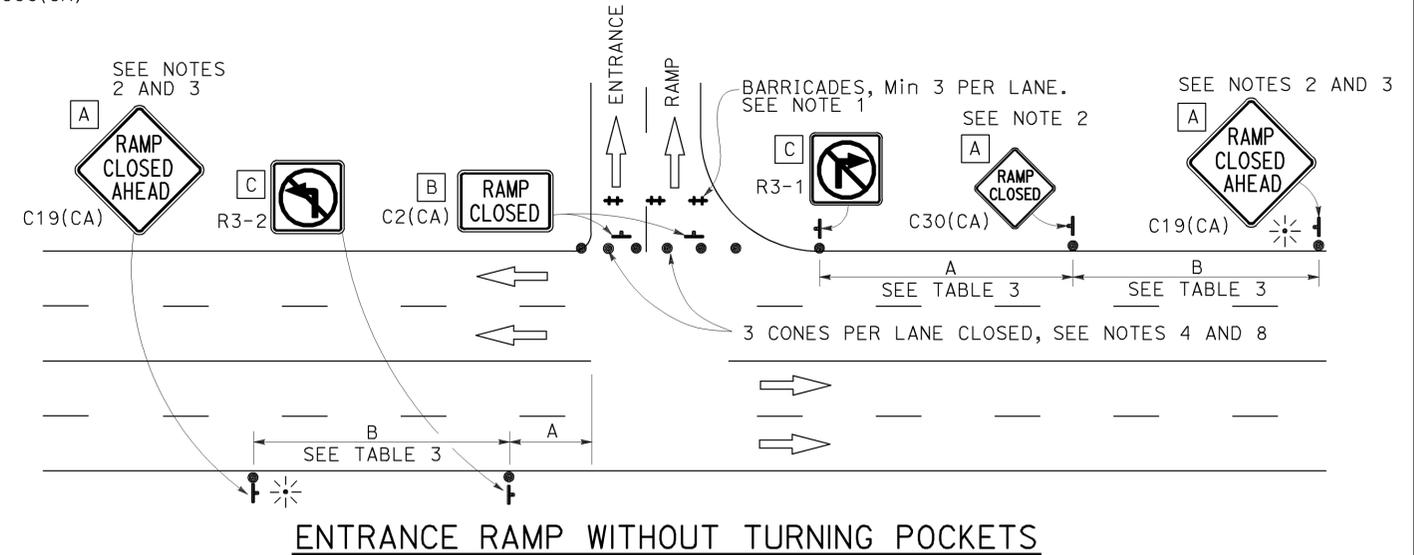

ENTRANCE RAMP WITHOUT TURNING POCKETS

NOTES:

1. See Revised Standard Plan RSP T9 for tables.
2. Use cone spacing X for taper segment, Y for tangent segment or Z for conflict situations, as appropriate, per Table 1, unless X, Y, or Z cone spacing is shown on this sheet.
3. Unless otherwise specified in the special provisions, all temporary warning signs shall have black legend on fluorescent orange background.
4. California codes are designated by (CA). Otherwise, Federal (MUTCD) codes are shown.

NOTES:

1. Barricades shall be Type I, II, or III for closures lasting one week or less and Type III for closures lasting longer than one week.
2. In addition to placing the C19(CA) "RAMP CLOSED AHEAD" and C30(CA) "RAMP CLOSED" signs, black on orange overlay plates with the word "CLOSED" may be mounted, as directed by the Engineer, on all guide signs that refer to the closed ramp. The letter size on the overlay shall be the same as the guide sign.
3. Each advance C19(CA) "RAMP CLOSED AHEAD" sign shall be equipped with at least two flags for daytime closure. Each flag shall be at least 16" x 16" in size and shall be orange or fluorescent red-orange in color. A flashing beacon shall be placed on top of the first C19(CA) sign during hours of darkness.
4. All cones used for ramp closures during the hours of darkness shall be fitted with retroreflective bands (or sleeves) as specified in the specifications.
5. Portable delineators, placed at one-half the spacing indicated for traffic cones, may be used instead of cones for daytime ramp closures only.
6. At least one person shall be assigned to provide full time maintenance of traffic control devices, unless otherwise directed by the Engineer.
7. The existing "EXIT" signs shall be covered during ramp closures.
8. A minimum of 3 cones shall be placed transversely across each closed lane and shoulder.

STATE OF CALIFORNIA
DEPARTMENT OF TRANSPORTATION

TRAFFIC CONTROL SYSTEM FOR RAMP CLOSURE


NO SCALE

RSP T14 DATED APRIL 19, 2013 SUPERSEDES STANDARD PLAN T14 DATED MAY 20, 2011 - PAGE 242 OF THE STANDARD PLANS BOOK DATED 2010.

REVISED STANDARD PLAN RSP T14



TO ACCOMPANY PLANS DATED 2-1-16

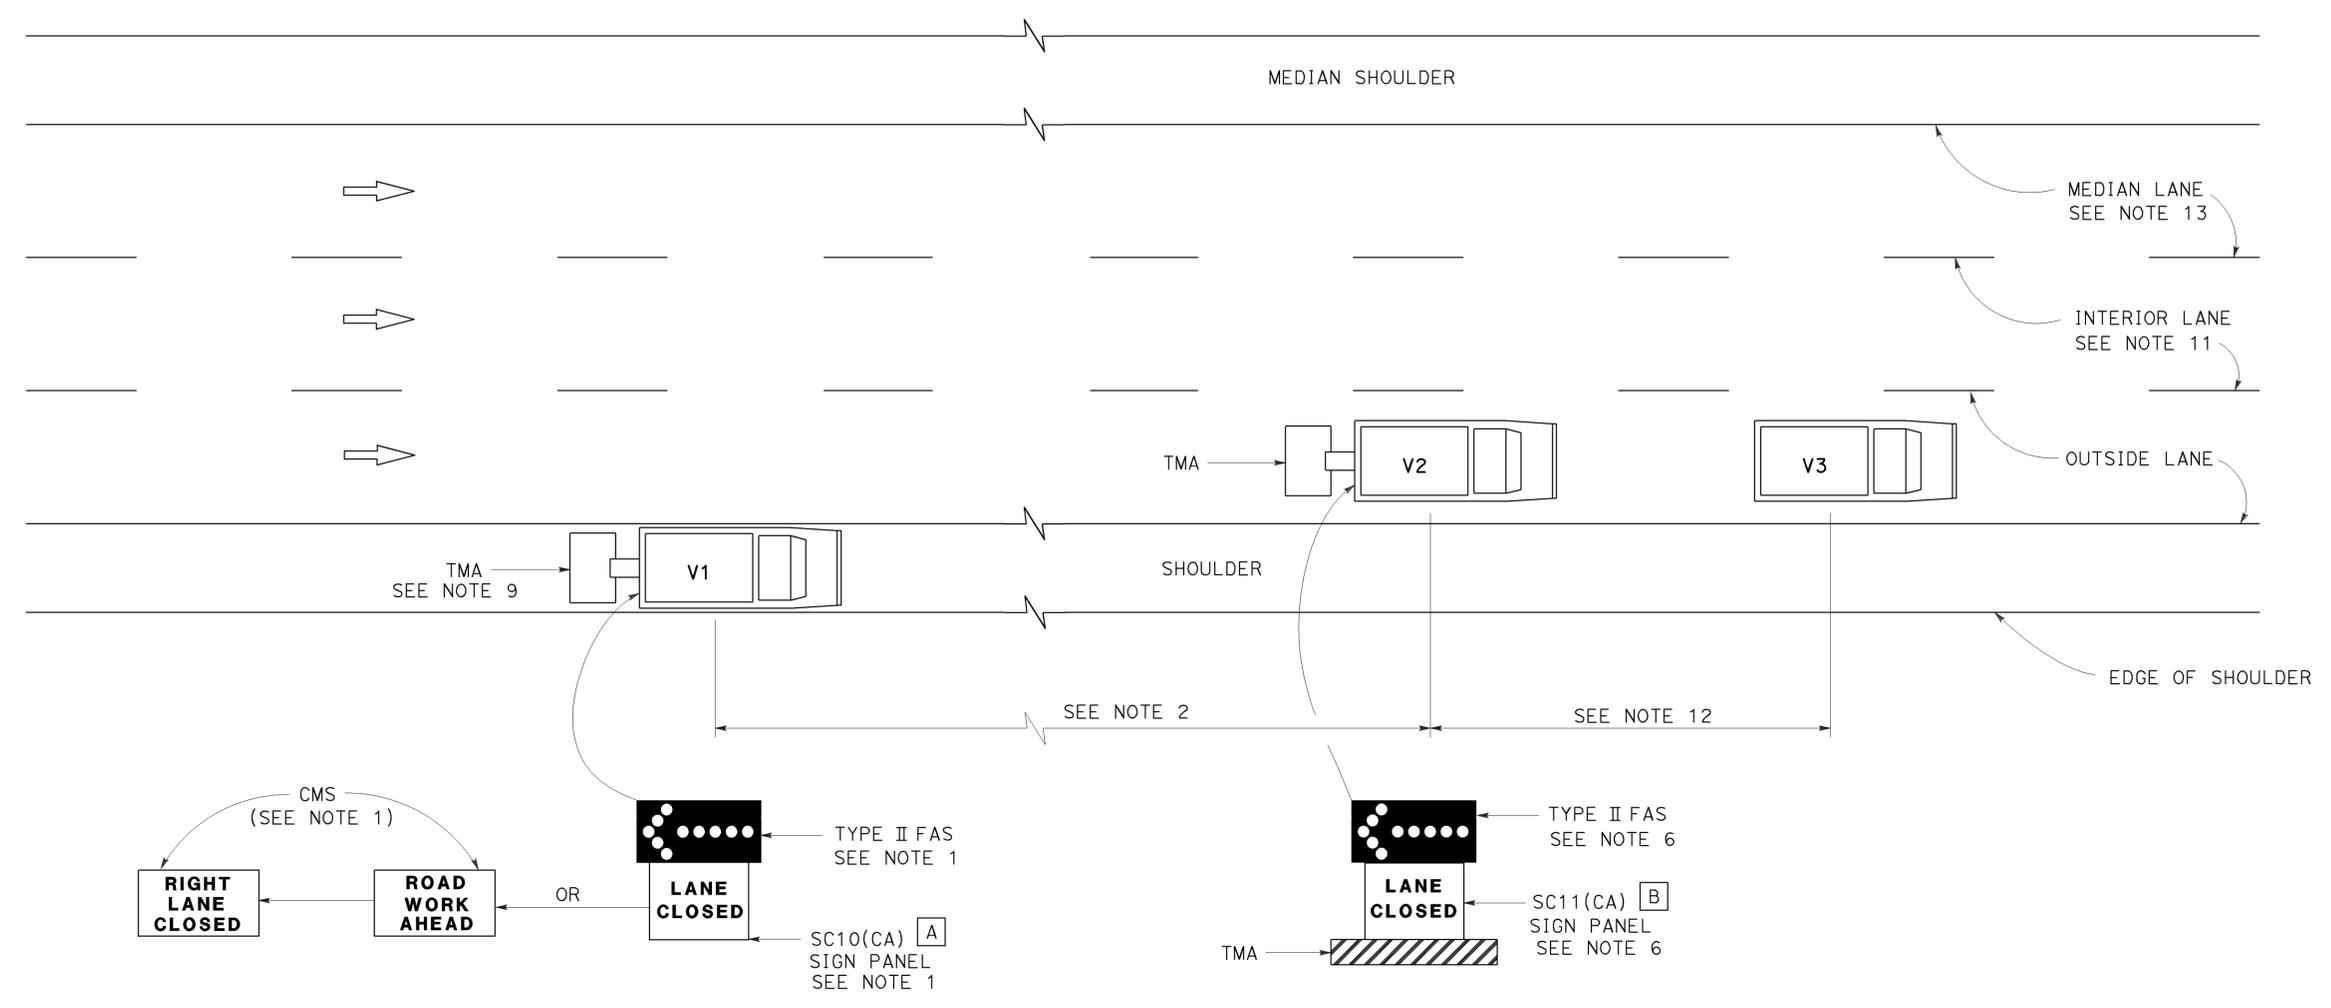

SIGN PANEL SIZE (Min)

- A 66" x 36"
- B 54" x 42"

LEGEND

- V1 SIGN VEHICLE
- V2 SHADOW VEHICLE
- V3 WORK/APPLICATION VEHICLE
-  FLASHING ARROW SIGN (FAS)
- CMS CHANGEABLE MESSAGE SIGN
- TMA TRUCK-MOUNTED ATTENUATOR

**MOVING LANE CLOSURE ON MEDIAN LANE OR
OUTSIDE LANE OF MULTILANE HIGHWAYS**

NOTES:

1. Either a changeable message sign or a SC10(CA) sign panel and a Type II flashing arrow sign shall be mounted on the rear of sign vehicle V1. The changeable message sign shall be sequenced to show the "ROAD WORK AHEAD" message first, followed by the "RIGHT LANE CLOSED" message. For median lane closure, the flashing arrow symbol shall be reversed with the arrowhead on the right and the changeable message sign shall show "LEFT LANE CLOSED".
2. If traffic queues develop, sign vehicle V1 should be positioned upstream from the end of queue. Sign vehicle V1 shall be positioned where highly visible when shoulders are not available.
3. A minimum sight distance of 1500' should be provided in advance of sign vehicle V1.
4. Sign vehicle V1 should remain at the beginning of horizontal or vertical curves until the other vehicles (V2 and V3) are far enough beyond the curve to resume the minimum sight distance of 1500'.
5. Vehicle-mounted sign panels shall have Type III or above retroreflective sheeting, black on white, or black on fluorescent orange, with 6" minimum series D letters per Caltrans sign specifications.
6. Shadow vehicle V2 shall be equipped with a truck-mounted attenuator. The sign panel shown and a Type II flashing arrow sign shall be mounted on the rear of shadow vehicle V2. For median lane closure the flashing arrow sign symbol shall be displayed with the arrowhead on the right.
7. All vehicles used for lane closures shall be equipped with two-way radios, and the vehicle operators shall maintain communication during the work or application operation.
8. All vehicles shall be equipped with flashing or rotating amber lights.
9. If sign vehicle V1 encroaches into the traffic lane due to insufficient shoulder width, sign vehicle V1 shall be equipped with a truck-mounted attenuator. Sign vehicle V1 shall stay as close to the edge of shoulder as practicable.
10. Where workers would be on foot in the work area, a stationary type lane closure (Revised Standard Plan T10, T11, etc., as applicable) shall be used instead of this plan.
11. For moving lane closure on interior lane of multilane highways, use Revised Standard Plan T16.
12. The spacing between work vehicle(s) and the shadow vehicles, and between each shadow vehicle should be minimized to deter road users from driving in between.
13. When the work/application vehicle V3 occupies the median lane, sign vehicle V1 should drive in the median shoulder and indicate left lane closed ahead.

STATE OF CALIFORNIA
DEPARTMENT OF TRANSPORTATION

**TRAFFIC CONTROL SYSTEM
FOR MOVING LANE CLOSURE
ON MULTILANE HIGHWAYS**
NO SCALE


RSP T15 DATED APRIL 19, 2013 SUPERSEDES STANDARD PLAN T15
DATED MAY 20, 2011 - PAGE 243 OF THE STANDARD PLANS BOOK DATED 2010.

REVISED STANDARD PLAN RSP T15


2010 REVISED STANDARD PLAN RSP T15

Dist	COUNTY	ROUTE	POST MILES TOTAL PROJECT	SHEET No.	TOTAL SHEETS
07	LA	5	13.8/19.2	240	262

Registered Civil Engineer
 April 19, 2013
 PLANS APPROVAL DATE
 THE STATE OF CALIFORNIA OR ITS OFFICERS OR AGENTS SHALL NOT BE RESPONSIBLE FOR THE ACCURACY OR COMPLETENESS OF SCANNED COPIES OF THIS PLAN SHEET.

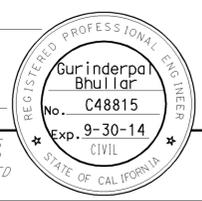

TO ACCOMPANY PLANS DATED 2-1-16

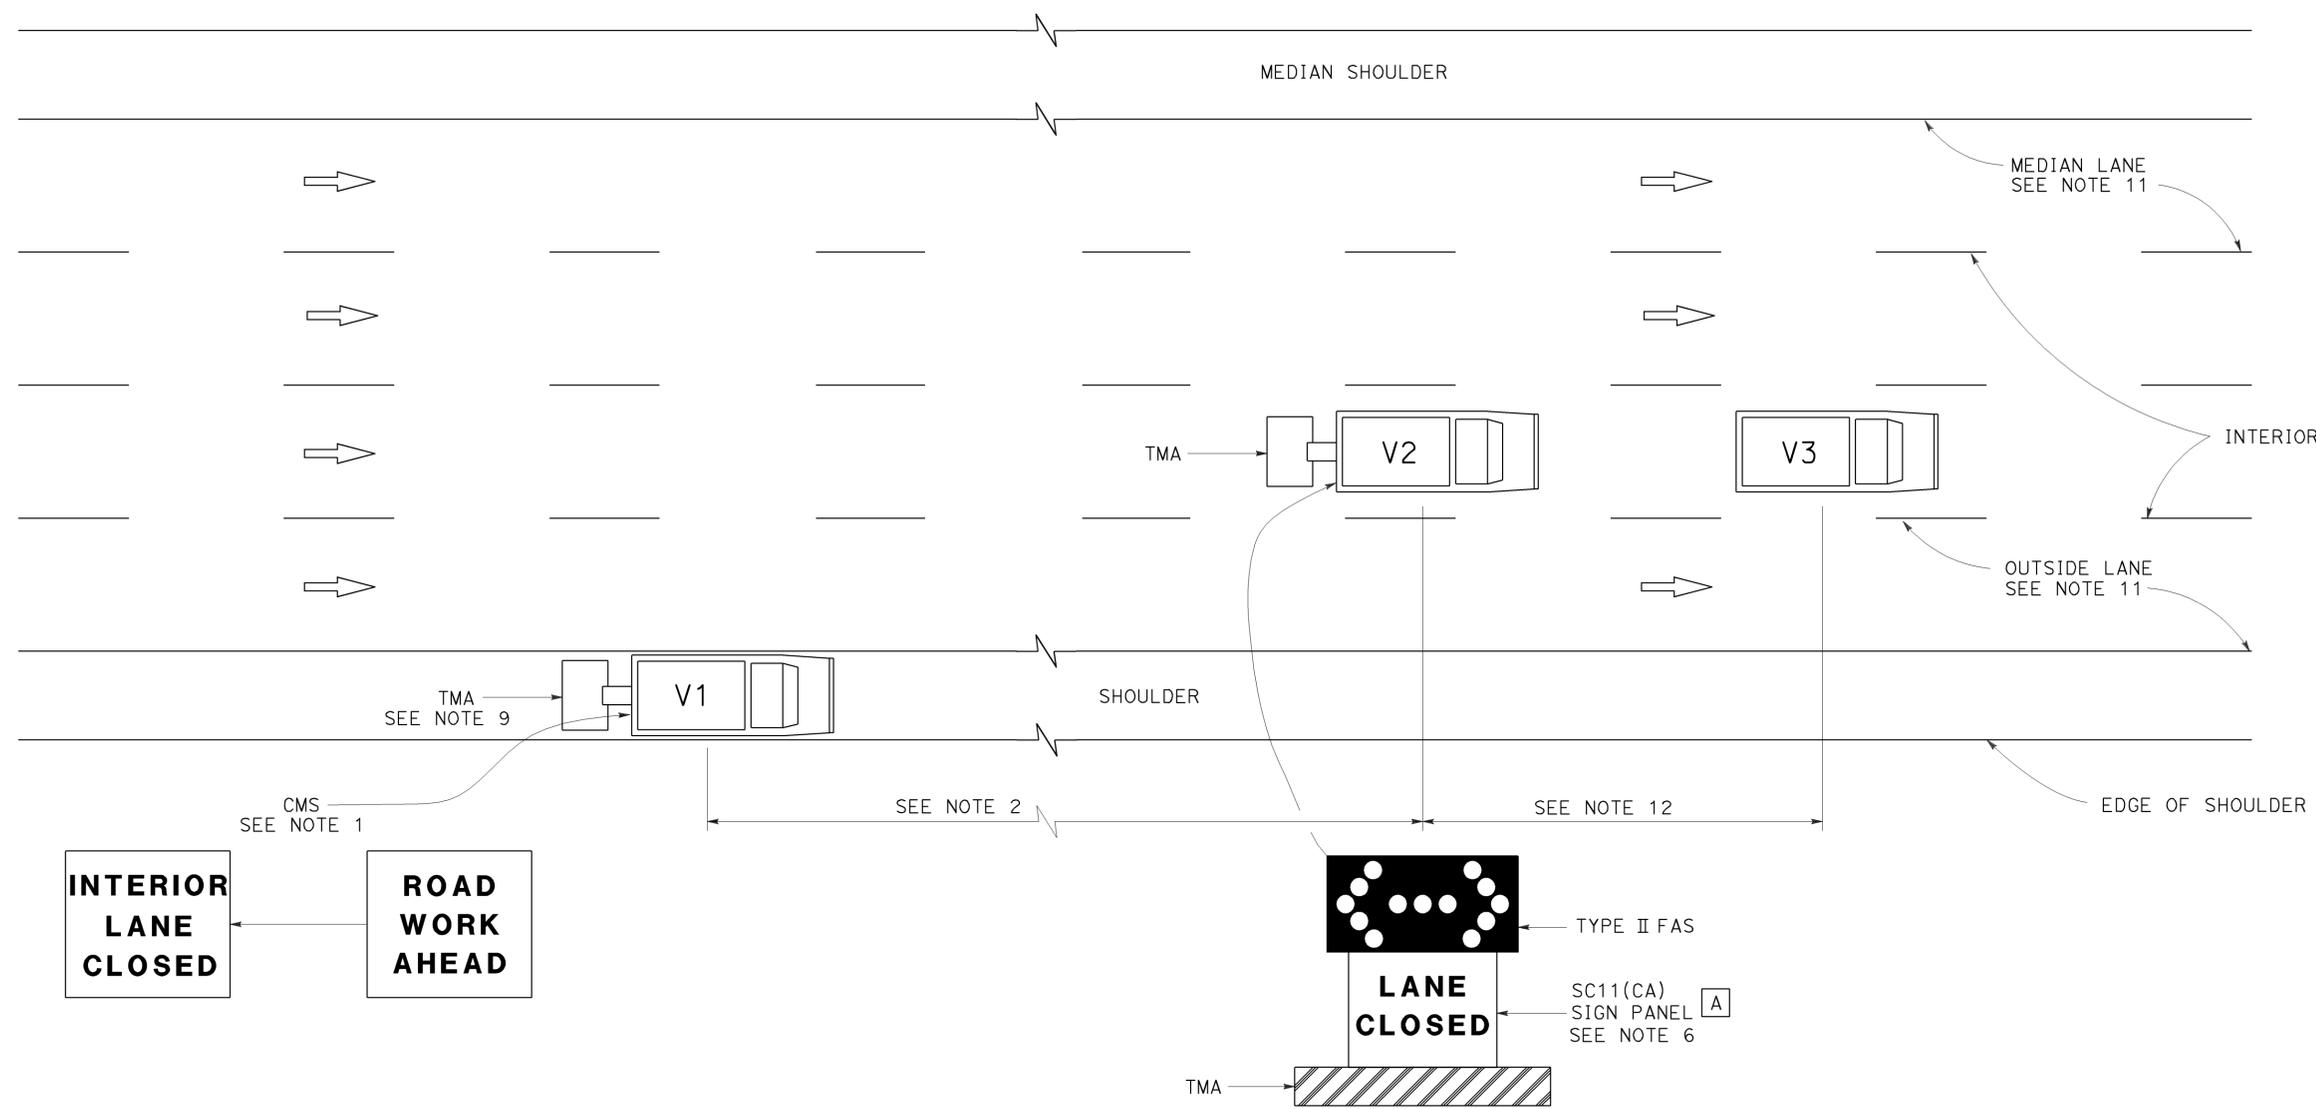

SIGN PANEL SIZE (Min)

A 54" x 42"

LEGEND

- V1 SIGN VEHICLE
- V2 SHADOW VEHICLE
- V3 WORK/APPLICATION VEHICLE
- FLASHING ARROW SIGN (FAS) IN FLASHING DOUBLE ARROW MODE
- CMS CHANGEABLE MESSAGE SIGN
- TMA TRUCK-MOUNTED ATTENUATOR

MOVING LANE CLOSURE ON INTERIOR LANE OF MULTILANE HIGHWAYS

NOTES:



1. A changeable message sign shall be mounted on the rear of sign vehicle V1. The changeable message sign shall be sequenced to show the "ROAD WORK AHEAD" message first, followed by the "INTERIOR LANE CLOSED" message. The message "CENTER LANE CLOSED" may be used in place of the "INTERIOR LANE CLOSED" message.
2. If traffic queues develop, sign vehicle V1 should be positioned upstream from the end of queue. Sign vehicle V1 shall be positioned where highly visible when shoulders are not available.
3. A minimum sight distance of 1500' should be provided in advance of sign vehicle V1.
4. Sign vehicle V1 should remain at the beginning of horizontal or vertical curves until the other vehicles (V2 and V3) are far enough beyond the curve to resume the minimum sight distance of 1500'.
5. Vehicle-mounted sign panels shall have Type III or above retroreflective sheeting, black on white, or black on fluorescent orange, with 6" minimum series D letters per Caltrans sign specifications.
6. Shadow vehicle V2 shall be equipped with a truck-mounted attenuator. The sign panel shown and a Type II flashing arrow sign shall be mounted on the rear of shadow vehicle V2.
7. All vehicles used for lane closures shall be equipped with two-way radios, and the vehicle operators shall maintain communication during the work or application operation.
8. All vehicles shall be equipped with flashing or rotating amber lights.
9. If sign vehicle V1 encroaches into the traffic lane due to insufficient shoulder width, sign vehicle V1 shall be equipped with a truck-mounted attenuator. Sign vehicle V1 shall stay as close to the edge of shoulder as practicable.
10. Where workers would be on foot in the work area, a stationary type lane closure (Revised Standard Plan T10, T11 etc., as applicable) shall be used instead of this plan.
11. For moving lane closure on median lane or outside lane of multilane highways, use Revised Standard Plan T15.
12. The spacing between work vehicle(s) and the shadow vehicles, and between each shadow vehicle should be minimized to deter road users from driving in between.

STATE OF CALIFORNIA
 DEPARTMENT OF TRANSPORTATION
**TRAFFIC CONTROL SYSTEM
 FOR MOVING LANE CLOSURE
 ON MULTILANE HIGHWAYS**
 NO SCALE

RSP T16 DATED APRIL 19, 2013 SUPERSEDES STANDARD PLAN T16 DATED MAY 20, 2011 - PAGE 244 OF THE STANDARD PLANS BOOK DATED 2010.


REVISED STANDARD PLAN RSP T16

2010 REVISED STANDARD PLAN RSP T16

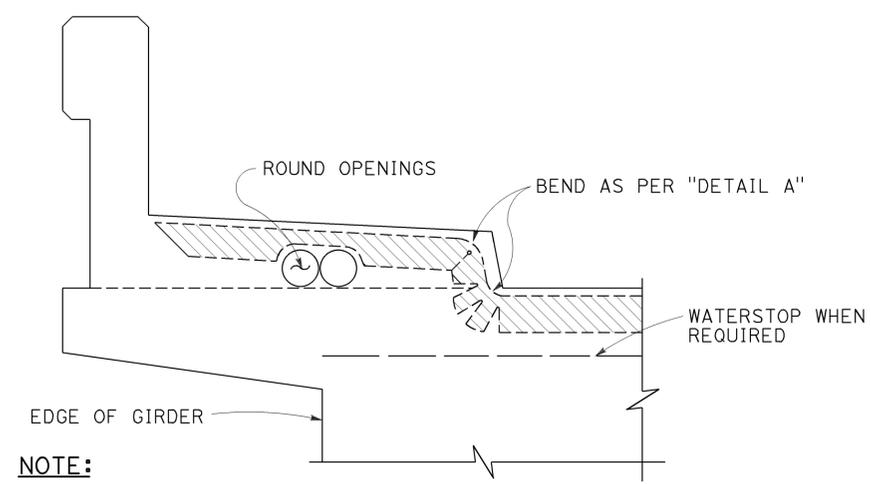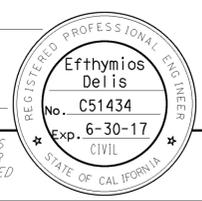


NOTE:
 Type "B" seal shown. Type "A" seals to conform to the general path of seal shown, cuts for bending not required. Bend type "A" seals 3" up into curb or barrier rail on only the low end of the seal.

CONCRETE BARRIER AND SIDEWALK

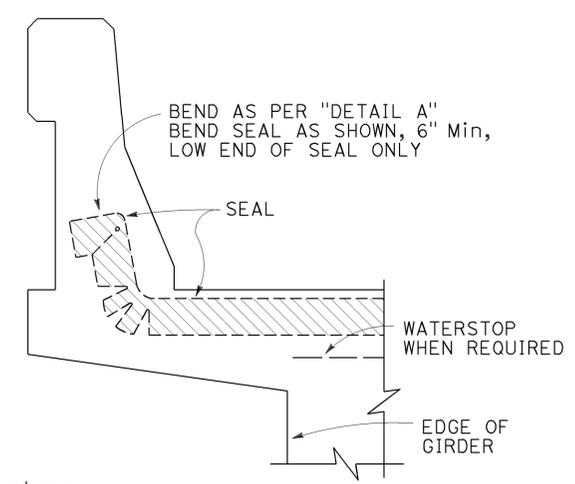


CONCRETE BARRIER

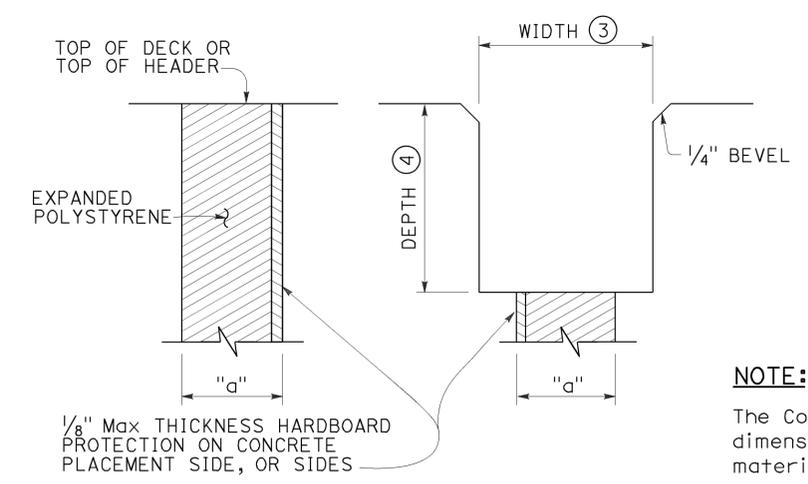

FORMING DETAIL SAWCUT DETAIL


NOTE:
 The Contractor shall verify all controlling field dimensions before ordering or fabricating any material.

JOINT SEALS DETAILS

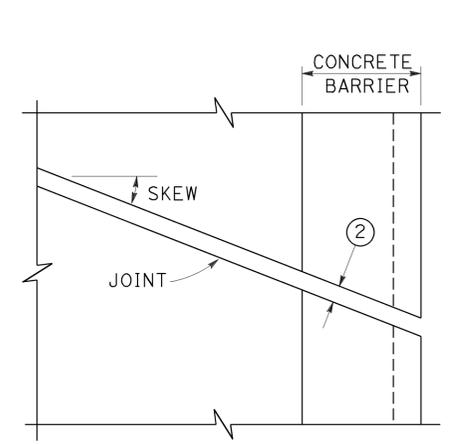


PLAN OF JOINT (SKEW ≤ 20°)

Min ϕ RADIUS TO BE 4 TIMES UNCOMPRESSED WIDTH OF SEAL OR AS RECOMMENDED BY THE MANUFACTURER, WHICHEVER IS GREATER

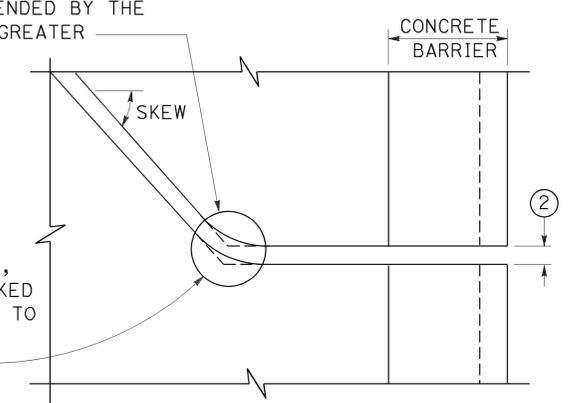

PLAN OF JOINT (SKEW > 20°)

IN LIEU OF SAW CUTTING, THIS AREA MAY BE BLOCKED OUT AND RECONSTRUCTED TO MATCH SAW CUTTING ON BOTH SIDES.

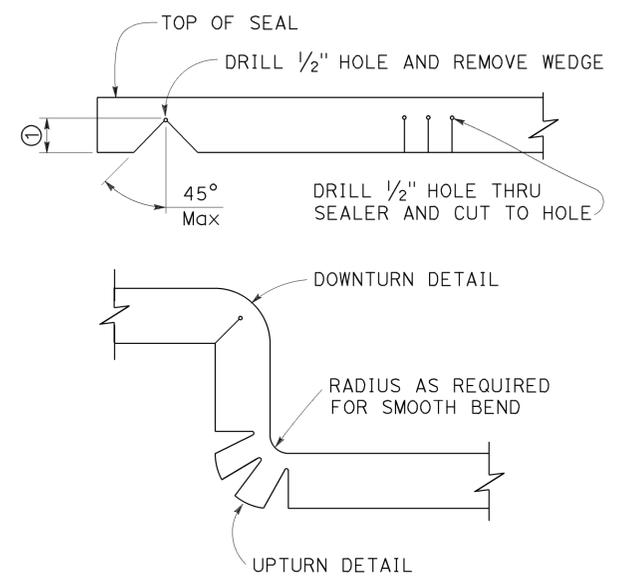


DETAIL A

- NOTES:**
- Make smooth cuts from the bottom of seal to 1/2" clear of top leaving at least one complete cell between the top of the cut and top of the seal. When necessary cut back of seal to clear conduit and round openings.
 - Opening in barrier to match width of sawn deck joint.
 - Sawcut groove widths shall be as ordered by the Engineer.
 - Depth of sawcut: Type A - Depth to be 2" minimum. Type B - Depth to be equal to or greater than the depth of seal measured along the contact surface, when compressed to minimum width position (W₂) plus dimensions shown.
 - MR (movement rating) as shown on other plan sheets.
 - Other depths must be approved by the Engineer.
 - A sidewalk joint shall be covered by an expansion joint armor.

DIMENSIONS "a" OF JOINT REQUIRED

MOVEMENT RATING (MR) (5)	BRIDGE TYPE	"a" DIMENSION		
		DECK CONCRETE PLACED		
		WINTER	FALL-SPRING	SUMMER
2"	ALL EXCEPT CIP/PS	1 1/2"	1 1/4"	3/4"
	CIP/PS	1 1/4"	1"	1/2"
1 1/2"	ALL EXCEPT CIP/PS	1 1/4"	1"	1/2"
	CIP/PS	1"	3/4"	1/2"
1"	ALL EXCEPT CIP/PS	1"	3/4"	1/2"
	CIP/PS	3/4"	1/2"	1/2"
1/2"	ALL EXCEPT CIP/PS	3/4"	3/4"	1/2"
	CIP/PS	1/2"	1/2"	1/2"

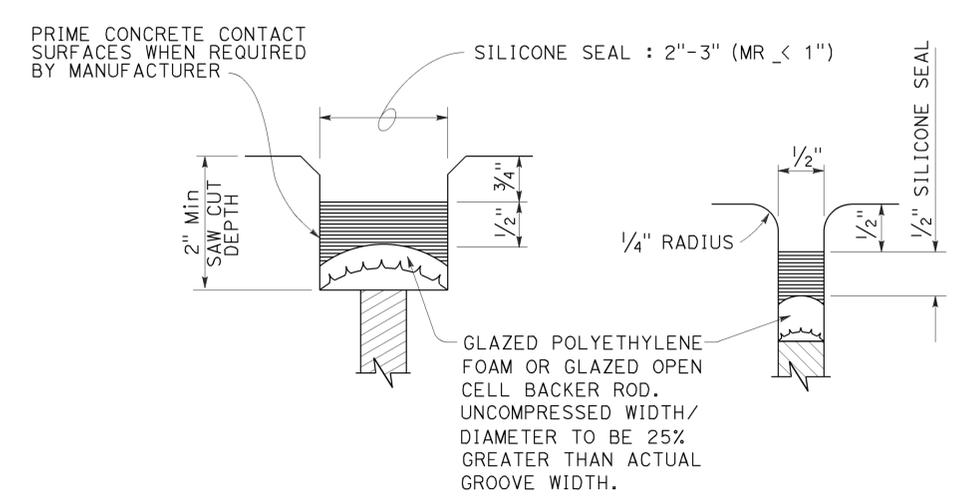


TYPE A SEAL

Movement rating : Silicone = 1" Max

TYPE AL SEAL

Longitudinal joints only

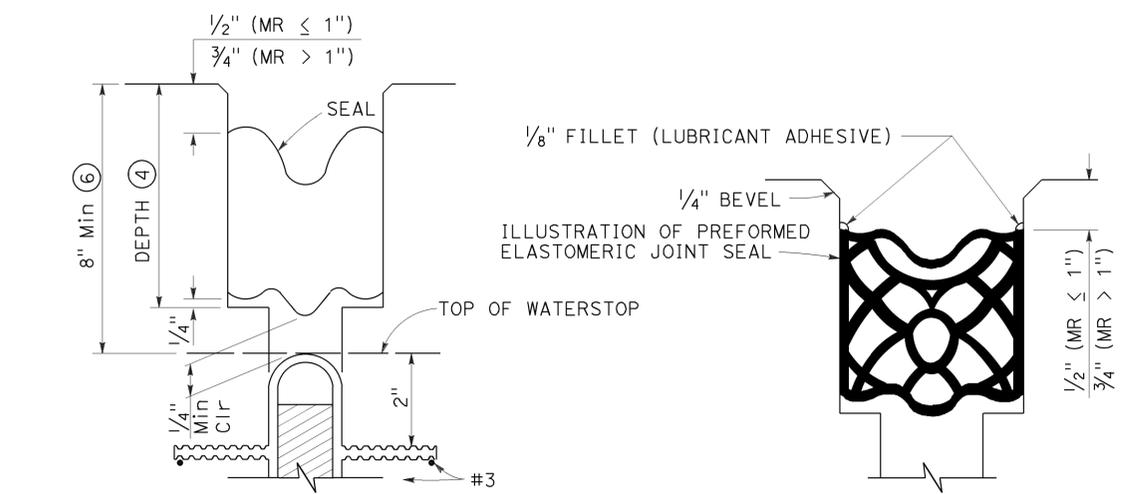

TYPE B JOINT SEAL IN MINIMUM WIDTH POSITION (W₂)

TYPE B SEAL

Movement Rating ≤ 2"

STATE OF CALIFORNIA
 DEPARTMENT OF TRANSPORTATION
JOINT SEALS
(MAXIMUM MOVEMENT RATING = 2")

NO SCALE
 RSP B6-21 DATED OCTOBER 30, 2015 SUPERSEDES STANDARD PLAN B6-21 DATED MAY 20, 2011 - PAGE 283 OF THE STANDARD PLANS BOOK DATED 2010.


Dist	COUNTY	ROUTE	POST MILES TOTAL PROJECT	SHEET No.	TOTAL SHEETS
07	LA	5	13.8/19.2	242	262

REGISTERED CIVIL ENGINEER


November 15, 2013
PLANS APPROVAL DATE

REGISTERED PROFESSIONAL ENGINEER
Tillett Satter
No. C42892
Exp. 3-31-14
CIVIL
STATE OF CALIFORNIA

TO ACCOMPANY PLANS DATED 2-1-16

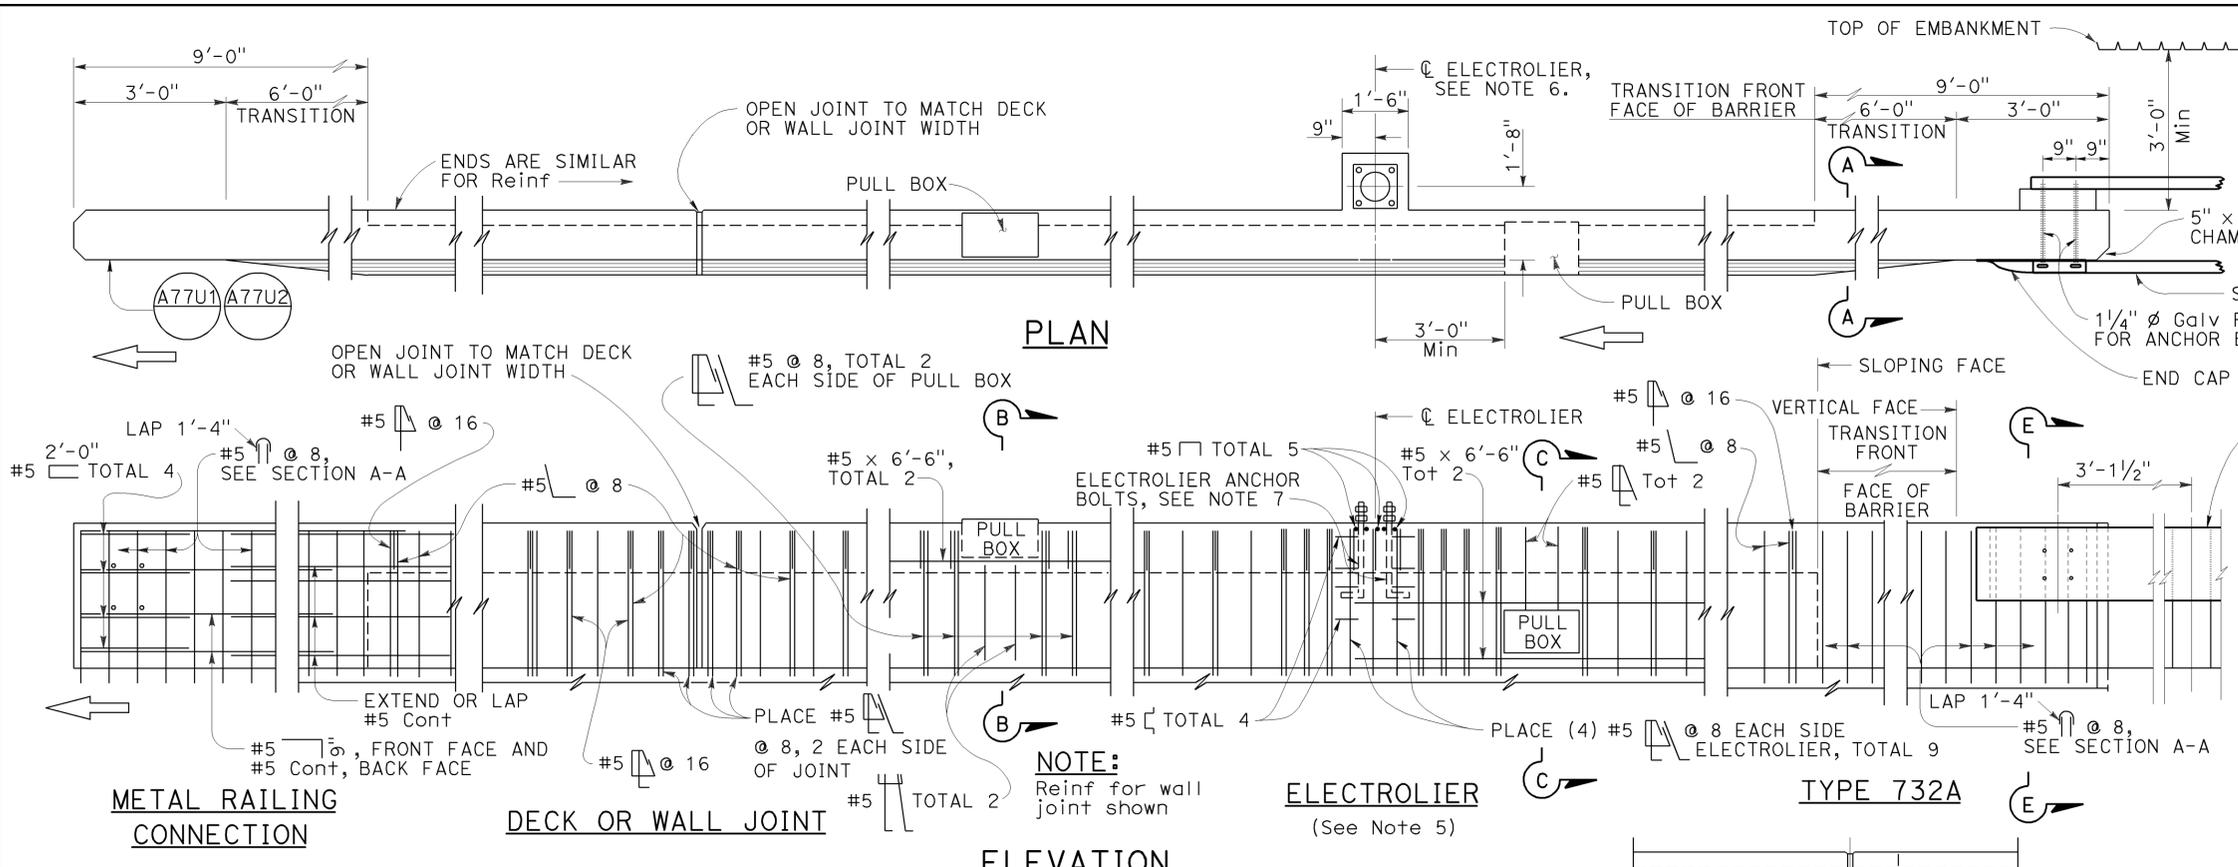

- NOTES:**
- Walls are to be backfilled before barrier is placed.
 - Clearance to reinforcing steel in barrier to be 1", except as noted. Longitudinal reinforcement to stop at all expansion joints.
 - Dimensions may vary with roadway cross slope and with certain thickness of surfacing. See Project Plans.
 - For typical metal railing connection details not shown, see Revised Standard Plans RSP A77U1 and RSP A77U2.
 - See Standard Plans ES-9A, ES-9B, ES-9C, ES-9D and ES-9E for electrical details. The maximum number of conduits in the barrier is limited to two 2" conduits along with one 3" conduit. When a 3" conduit is used, it is restricted to the base of the barrier.
 - For electrolier mounting details, See Standard Plans ES-6A and ES-6B.
 - Minimum concrete edge distance, to the reinforcing shown, shall be maintained. Edge distance may be adjusted to accommodate increase in concrete cover for architectural treatment.

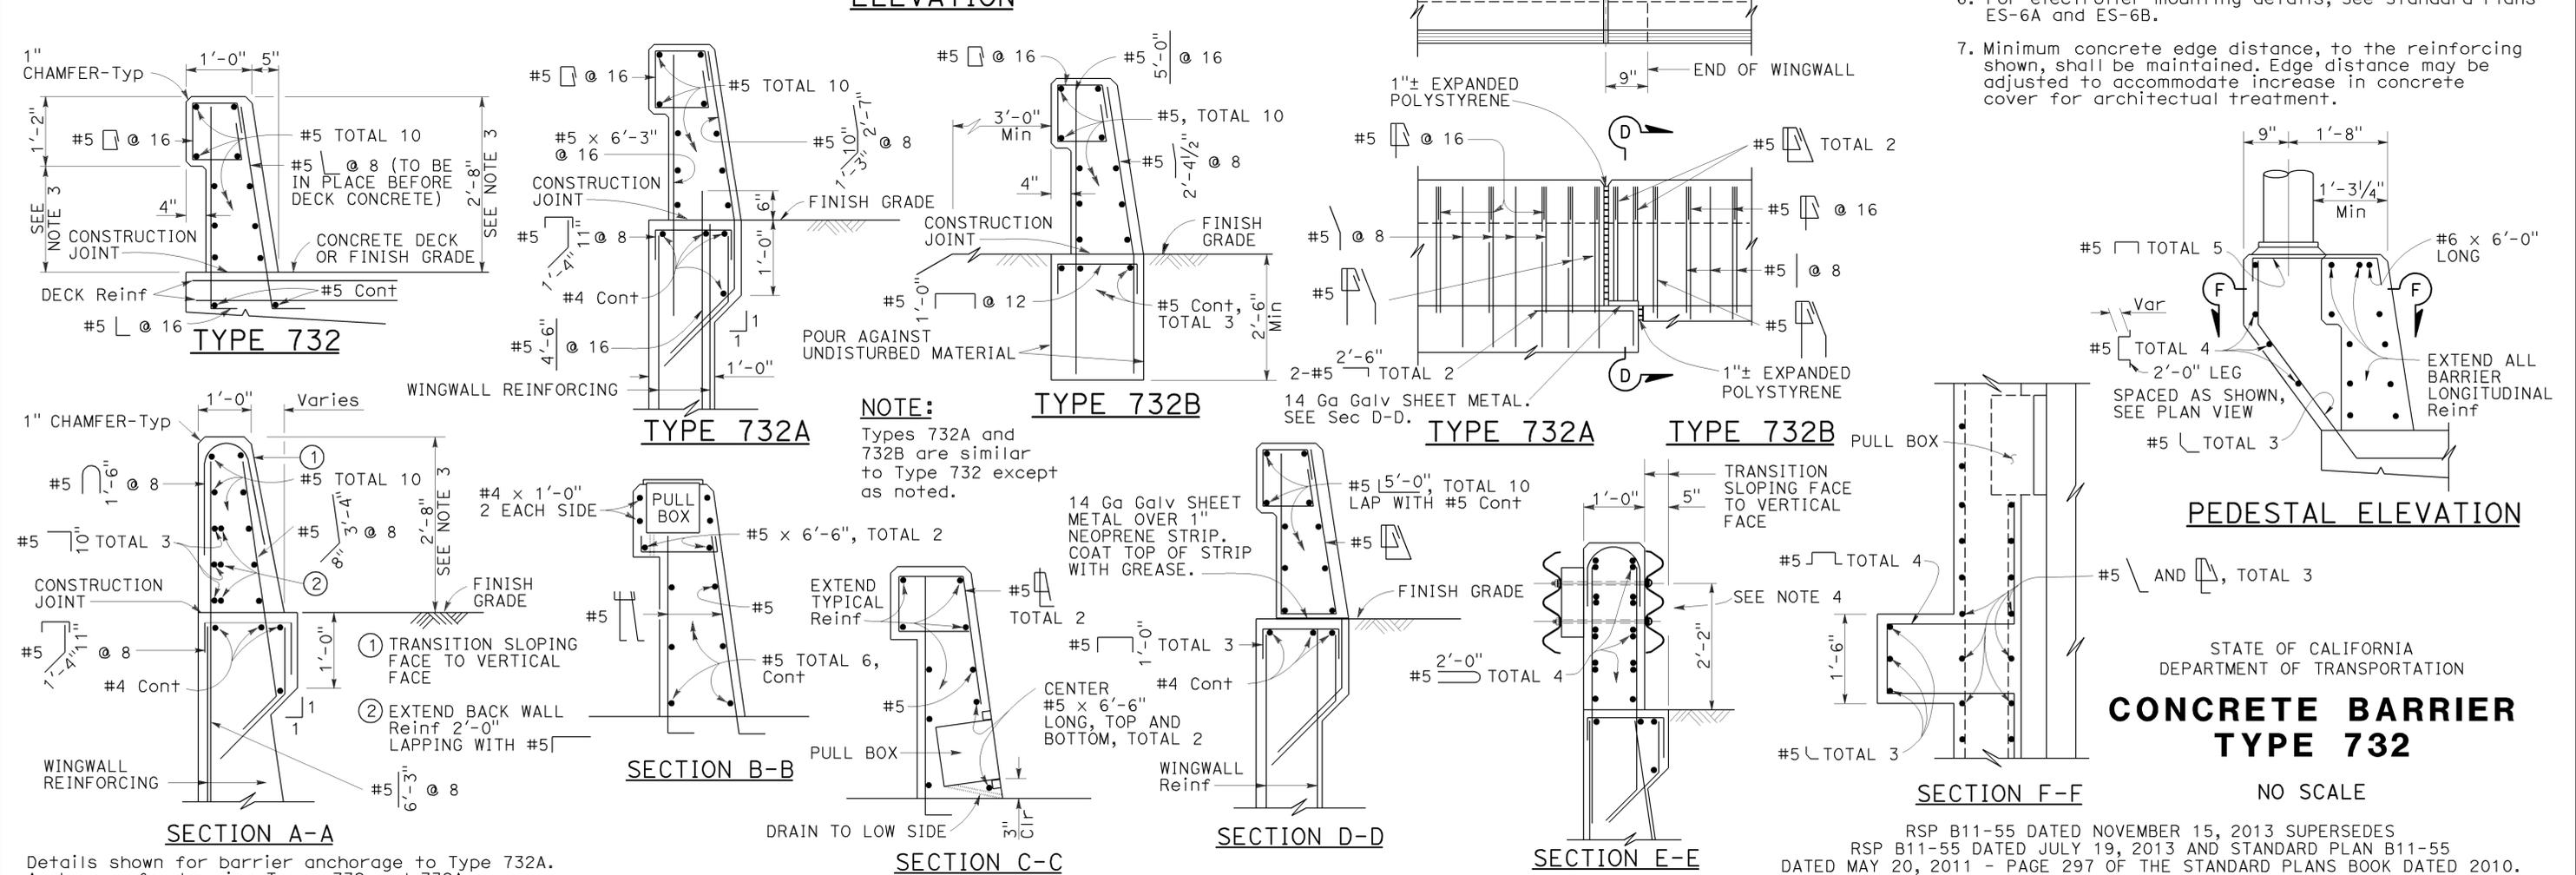

Details shown for barrier anchorage to Type 732A. Anchorage for barrier Types 732 and 732A are similar to their respective details.

2010 REVISED STANDARD PLAN RSP B11-55

STATE OF CALIFORNIA
DEPARTMENT OF TRANSPORTATION
**CONCRETE BARRIER
TYPE 732**
NO SCALE

RSP B11-55 DATED NOVEMBER 15, 2013 SUPERSEDES
RSP B11-55 DATED JULY 19, 2013 AND STANDARD PLAN B11-55
DATED MAY 20, 2011 - PAGE 297 OF THE STANDARD PLANS BOOK DATED 2010.


REGISTERED CIVIL ENGINEER

October 19, 2012
PLANS APPROVAL DATE

THE STATE OF CALIFORNIA OR ITS OFFICERS OR AGENTS SHALL NOT BE RESPONSIBLE FOR THE ACCURACY OR COMPLETENESS OF SCANNED COPIES OF THIS PLAN SHEET.

REGISTERED PROFESSIONAL ENGINEER
Tillett Satter
No. C42892
Exp. 3-31-14
CIVIL
STATE OF CALIFORNIA

TO ACCOMPANY PLANS DATED 2-1-16

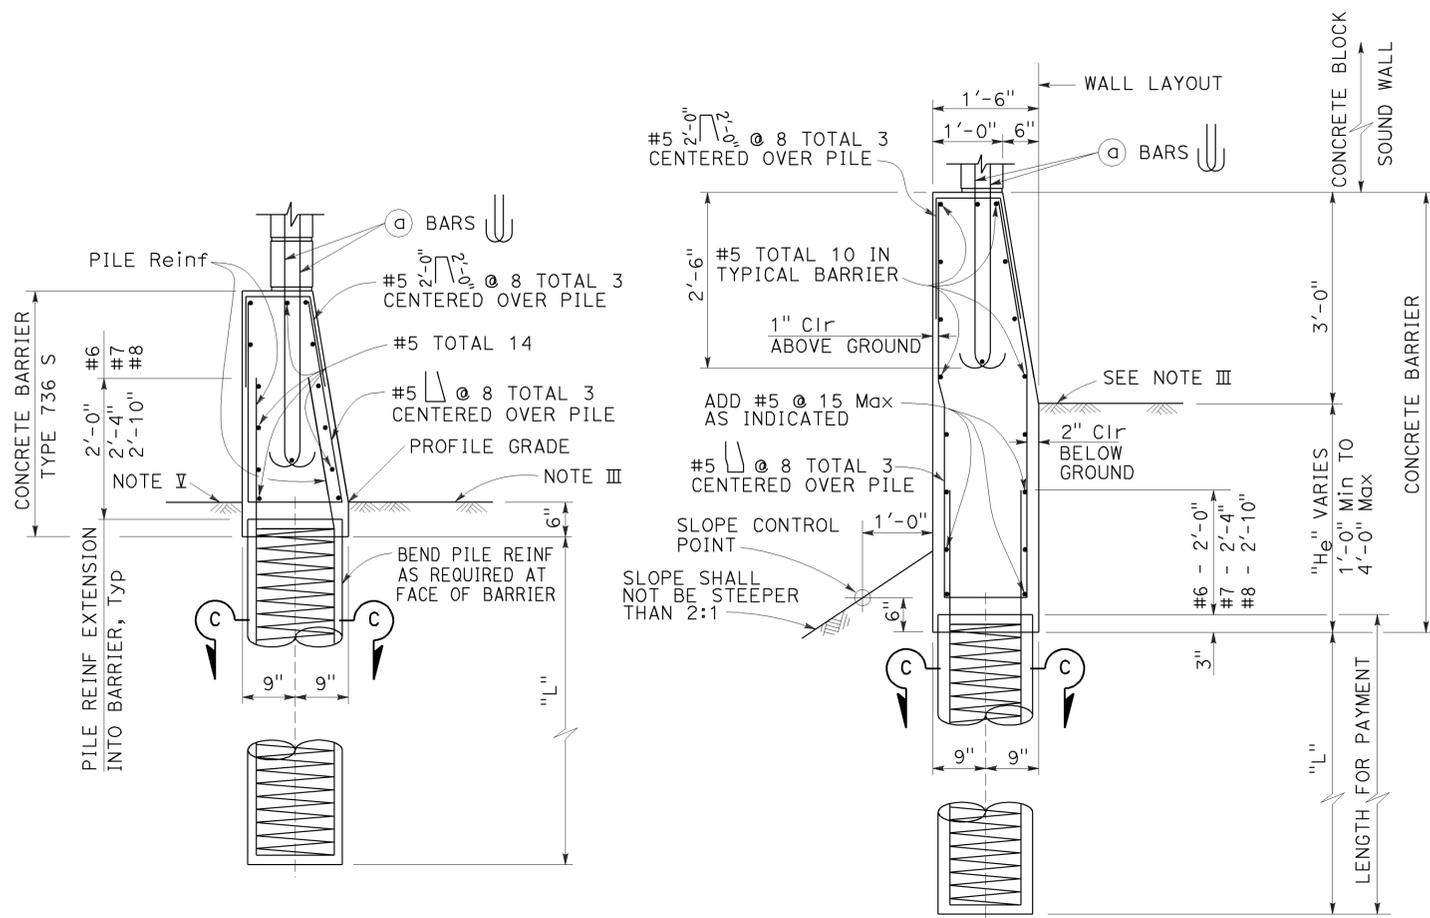


CASE 1

For details not shown, See Case 2.
Level ground ±10% on both sides of barrier.

CASE 2

For details not shown, See Case 1.
Level ground ±10% at the traffic side of barrier and sloping ground on the opposite side.

BARRIER SECTIONS

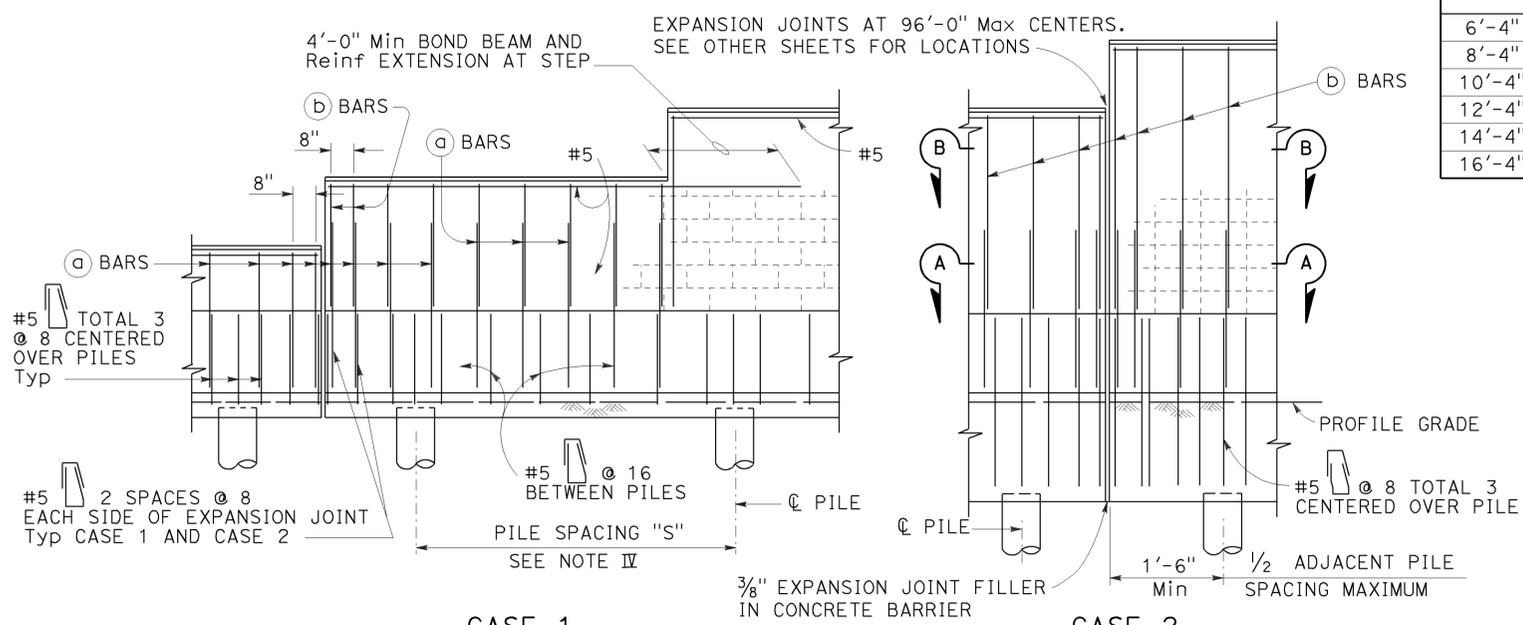


CASE 1

For details not shown, See Case 2.

CASE 2

For details not shown, See Case 1.

PARTIAL ELEVATIONS

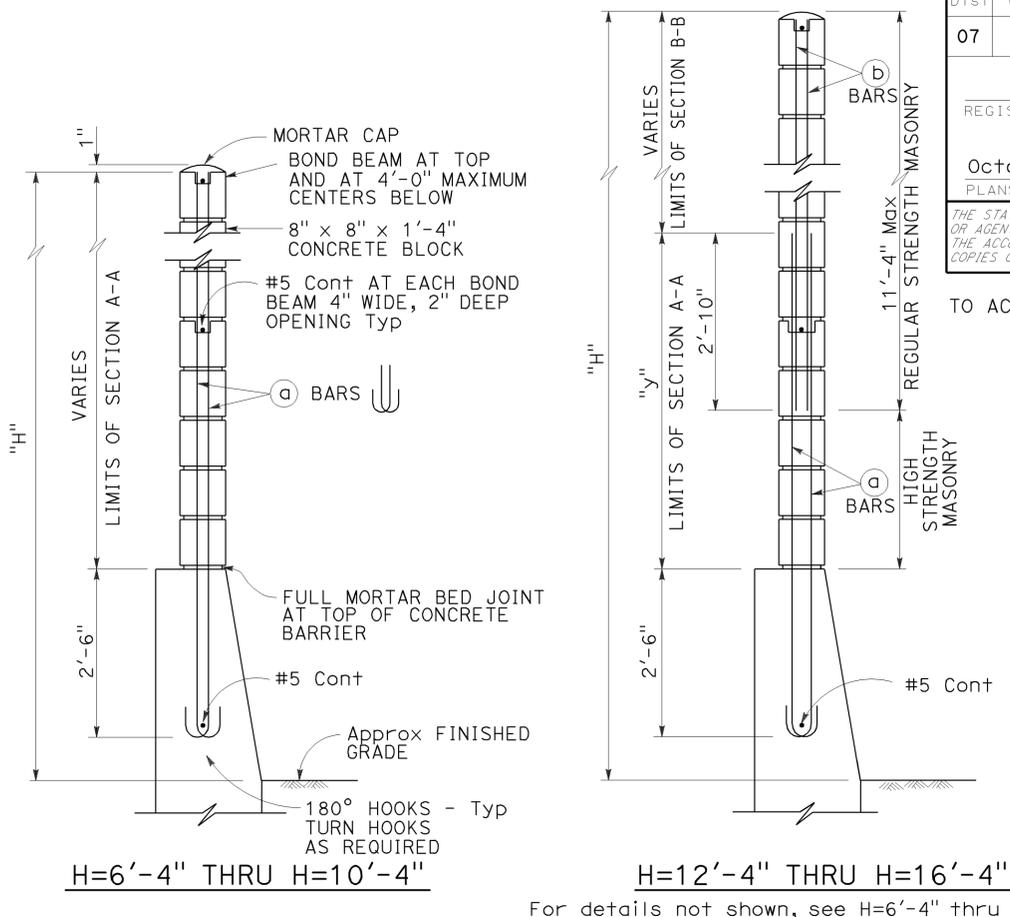

TYPICAL SECTIONS

See Standard Plan B15-8 for pile details.

SOUND WALL REINFORCEMENT TABLE

MAXIMUM H	(a) BARS @ 1'-4" Max	(b) BARS @ 1'-4" Max	"y"	f'm (psi)	COMPRESSIVE STRENGTH OF CMU (psi)	H
6'-4"	#4	---	---	1500	1900	6'-4"
8'-4"	#4	---	---	1500	1900	8'-4"
10'-4"	#4	---	---	1500	1900	10'-4"
12'-4"	#5	#4	5'-0"	1500	1900	12'-4"
14'-4"	#6	#4	7'-0"	1500	1900	14'-4"
16'-4"	#6	#4	9'-0"	2500	3750	16'-4"

NOTES I THROUGH VI:

- I. Details shown are primarily to conform design of sound walls to Type 736S and Type 736 SV Concrete Barriers. For sound wall details conforming with barriers see Standard Plans B15-7 and B15-8.
- II. For details and sections not shown, see Standard Plans B15-7 and B15-8.
- III. Slope ground at traffic side of barrier to drain. Maximum slope ±10%. See Std Plan B11-56, Note 3.
- IV. Pile spacing may be varied, but shall not exceed the tabular values. See Standard Plan B15-8.
- V. For Case 1 - ground line to be at the same elevation on both sides of the barrier. Barrier shall not be used to retain earth.
- VI. See Standard Plan B15-9 for other details.

NOTES A THROUGH F:

- A. For type of block, type of block bond, and joint finish, see other sheets.
- B. When blocks are laid in stacked bond, ladder type, galvanized joint reinforcement shall be provided. A minimum of 2-9 gauge wires continuous at 4'-0" maximum to be used. Locate reinforcement in joints that are at the approximate midpoint between bond beams.
- C. Horizontal joints shall be tooled concave or may be weathered. Vertical joints shall be tooled concave or may be raked.
- D. For intermediate wall heights (H), or barrier depths (H_e), that are between the values given, use the tabular information for the next higher (H) or (H_e).
- E. Concrete to be used for the barrier shall contain not less than 590 pounds of cementitious material per cubic yard.
- F. Masonry strengths are listed in the "SOUND WALL REINFORCEMENT TABLE".

STATE OF CALIFORNIA
DEPARTMENT OF TRANSPORTATION

SOUND WALL MASONRY BLOCK ON TYPE 736S/SV BARRIER DETAILS (1)

NO SCALE

RSP B15-6 DATED OCTOBER 19, 2012 SUPERSEDES STANDARD PLAN B15-6 DATED MAY 20, 2011 - PAGE 320 OF THE STANDARD PLANS BOOK DATED 2010.

REVISED STANDARD PLAN RSP B15-6

2010 REVISED STANDARD PLAN RSP B15-6

LEGEND:

AB	ABANDON. IF APPLIED TO CONDUIT, REMOVE CONDUCTORS
BC	INSTALL PULL BOX IN EXISTING CONDUIT RUN
BP	PEDESTRIAN BARRICADE, TYPE AS INDICATED ON PLAN
CB	INSTALL CONDUIT INTO EXISTING PULL BOX
CC	CONNECT NEW AND EXISTING CONDUIT. REMOVE EXISTING CONDUCTORS AND INSTALL CONDUCTORS AS INDICATED
CF	CONDUIT TO REMAIN FOR FUTURE USE. REMOVE CONDUCTORS. INSTALL PULL TAPE
DH	DETECTOR HANDHOLE
FA	FOUNDATION TO BE ABANDONED
IS	INSTALL SIGN ON SIGNAL MAST ARM
NS	NO SLIP BASE ON STANDARD
PEC	PHOTOELECTRIC CONTROL
PEU	PHOTOELECTRIC UNIT
RC	EQUIPMENT OR MATERIAL TO BE REMOVED AND BECOME THE PROPERTY OF THE CONTRACTOR
RE	REMOVE ELECTROLIER, FUSES AND BALLAST. TAPE ENDS OF CONDUCTORS
RL	RELOCATE EQUIPMENT
RR	REMOVE AND REUSE EQUIPMENT
RS	REMOVE AND SALVAGE EQUIPMENT
SC	SPLICE NEW TO EXISTING CONDUCTORS
SD	SERVICE DISCONNECT
TSP	TELEPHONE SERVICE POINT

ABBREVIATIONS

AC+	UNDERGROUNDED CONDUCTOR	MAT	MAST ARM MOUNTING TOP ATTACHMENT
APS	ACCESSIBLE PEDESTRIAN SIGNAL	MAS	MAST ARM MOUNTING SIDE ATTACHMENT
Batt	BATTERY	MBPS	MANUAL BYPASS SWITCH
BBS	BATTERY BACKUP SYSTEM	M/M	MULTIPLE TO MULTIPLE TRANSFORMER
BC	BOLT CIRCLE	Mtg	MOUNTING
BIK	BLACK	MV	MERCURY VAPOR LIGHTING FIXTURE
BP	BYPASS	MVDS	MICROWAVE VEHICLE DETECTION SYSTEM
BPB	BICYCLE PUSH BUTTON	N	NEUTRAL (GROUNDED CONDUCTOR)
C	CONDUIT	NB	NEUTRAL BUS
CB	CIRCUIT BREAKER	NC	NORMALLY CLOSE
CCTV	CLOSED CIRCUIT TELEVISION	NO	NORMALLY OPEN
Ckt	CIRCUIT	P	CIRCUIT BREAKER'S POLE
CMS	CHANGEABLE MESSAGE SIGN	PB	PULL BOX
Ctid	CALTRANS IDENTIFICATION	PBA	PUSH BUTTON ASSEMBLY
Comm	COMMUNICATION	PEC	PHOTOELECTRIC CONTROL
Cn+l	CONTROL	Ped	PEDESTRIAN
DF	DEPARTMENT-FURNISHED	PEU	PHOTOELECTRIC UNIT
DLC	LOOP DETECTOR LEAD-IN CABLE	PT	CONDUIT WITH PULL TAPE
EMS	EXTINGUISHABLE MESSAGE SIGN	PTR	POWER TRANSFER RELAY
EVUC	EMERGENCY VEHICLE UNIT CABLE	RE	RELOCATED EQUIPMENT
EVUD	EMERGENCY VEHICLE UNIT DETECTOR	RM	RAMP METERING
FB	FLASHING BEACON	RWIS	ROADSIDE WEATHER INFORMATION SYSTEM
FBCA	FLASHING BEACON CONTROL ASSEMBLY	SB	SLIP BASE
FBS	FLASHING BEACON WITH SLIP BASE	SIC	SIGNAL INTERCONNECT CABLE
FO	FIBER OPTIC	Sig	SIGNAL
G	EQUIPMENT GROUNDING CONDUCTOR	SMA	SIGNAL MAST ARM
GB	GROUND BUS	SNS	STREET NAME SIGN
GFCI	GROUND FAULT CIRCUIT INTERRUPTER	SP	SERVICE POINT
Grn	GREEN	TB	TERMINAL BOARD
HAR	HIGHWAY ADVISORY RADIO	TDC	TELEPHONE DEMARCATION CABINET
Hex	HEXAGONAL	Temp	TEMPERATURE
HPS	HIGH PRESSURE SODIUM	TMS	TRAFFIC MONITORING STATION
IISNS	INTERNALLY ILLUMINATED STREET NAME SIGN	TOS	TRAFFIC OPERATIONS SYSTEM
ISL	INDUCTION SIGN LIGHTING	UPS	UNINTERRUPTABLE POWER SUPPLY
LED	LIGHT EMITTING DIODE	UPSC	UNINTERRUPTABLE POWER SUPPLY CONTROLLER
LMA	LUMINAIRE MAST ARM	Veh	VEHICLE
LPS	LOW PRESSURE SODIUM	VIVDS	VIDEO IMAGE VEHICLE DETECTION SYSTEM
Ltg	LIGHTING	Wht	WHITE
Lum	LUMINAIRE	WIM	WEIGH-IN-MOTION
M	METERED	Xfmr	TRANSFORMER

Dist	COUNTY	ROUTE	POST MILES TOTAL PROJECT	SHEET No.	TOTAL SHEETS
07	LA	5	13.8/19.2	244	262

Theresa Gabriel
REGISTERED ELECTRICAL ENGINEER

October 30, 2015
PLANS APPROVAL DATE

Theresa
Aziz Gabriel
No. E15129
Exp. 6-30-16
ELECTRICAL
STATE OF CALIFORNIA

THE STATE OF CALIFORNIA OR ITS OFFICERS OR AGENTS SHALL NOT BE RESPONSIBLE FOR THE ACCURACY OR COMPLETENESS OF SCANNED COPIES OF THIS PLAN SHEET.

TO ACCOMPANY PLANS DATED 2-1-16

SOFFIT AND WALL-MOUNTED LUMINAIRES

- PENDANT SOFFIT LUMINAIRE, 70 W HPS UNLESS OTHERWISE SPECIFIED
- FLUSH-MOUNTED SOFFIT LUMINAIRE, 70 W HPS UNLESS OTHERWISE SPECIFIED
- WALL-MOUNTED LUMINAIRE, 70 W HPS UNLESS OTHERWISE SPECIFIED
- EXISTING SOFFIT OR WALL-MOUNTED LUMINAIRE TO REMAIN UNMODIFIED
- EXISTING SOFFIT OR WALL-MOUNTED LUMINAIRE TO BE MODIFIED AS SPECIFIED

NOTE:
Arrow indicates "street side" of luminaire.

COMMONLY USED SYMBOLS FOR UNITED STATES CUSTOMARY UNITS OF MEASUREMENT:

SYMBOL	DEFINITIONS
Ω	OHMS
min	MINUTE
s	SECOND
bps	BITS PER SECOND
Bps	BYTES PER SECOND
A	AMPERE
V	VOLT
V(dc)	VOLT (DIRECT CURRENT)
V(ac)	VOLT (ALTERNATING CURRENT)
FC	FOOT - CANDLE
W	WATTS
VA	VOLT-AMPERE
M	MEGA
k	KILO
m	MILLI
μ	MICRO
P	PICO
Hz	HERTZ

MISCELLANEOUS ELECTROLIERS

NEW	EXISTING	
		LUMINAIRE ON WOOD POLE
		NON-STANDARD ELECTROLIER (SEE PROJECT LEGEND)
		CITY ELECTROLIER
		ELECTROLIER FOUNDATION (FUTURE INSTALLATION)

- NOTES:**
- LED luminaires shall be 235 W when installed on Type 21, 21D, 30, 31 and 32 Standards, unless otherwise specified. LED luminaires shall be 165 W when installed on other type standards or poles, unless otherwise specified.
 - Luminaires shall be the cutoff type, ANSI Type III medium cutoff lighting distribution, unless otherwise specified.

STANDARD ELECTROLIER

NEW	EXISTING	STANDARD TYPE
		15
		15D
		15 STRUCTURE
		15D STRUCTURE
		21
		21D
		21 STRUCTURE
		21D STRUCTURE
		30
		31
		32

STATE OF CALIFORNIA
DEPARTMENT OF TRANSPORTATION

ELECTRICAL SYSTEMS (LEGEND AND ABBREVIATIONS)

NO SCALE

RSP ES-1A DATED OCTOBER 30, 2015 SUPERSEDES RSP ES-1A DATED JULY 19, 2013 AND STANDARD PLAN ES-1A DATED MAY 20, 2011 - PAGE 425 OF THE STANDARD PLANS BOOK DATED 2010.

REVISED STANDARD PLAN RSP ES-1A

2010 REVISED STANDARD PLAN RSP ES-1A

Dist	COUNTY	ROUTE	POST MILES TOTAL PROJECT	SHEET No.	TOTAL SHEETS
07	LA	5	13.8/19.2	245	262

Theresa Gabriel
 REGISTERED ELECTRICAL ENGINEER
 October 30, 2015
 PLANS APPROVAL DATE

THE STATE OF CALIFORNIA OR ITS OFFICERS OR AGENTS SHALL NOT BE RESPONSIBLE FOR THE ACCURACY OR COMPLETENESS OF SCANNED COPIES OF THIS PLAN SHEET.

TO ACCOMPANY PLANS DATED 2-1-16

CONDUIT

NEW	EXISTING	
		LIGHTING CONDUIT, UNLESS OTHERWISE INDICATED OR NOTED
		TRAFFIC SIGNAL CONDUIT
		COMMUNICATION CONDUIT
		TELEPHONE CONDUIT
		FIRE ALARM CONDUIT
		FIBER OPTIC CONDUIT
		CONDUIT TERMINATION
		CONDUIT RISER ATTACHED TO THE STRUCTURE OR SERVICE POLE


SIGNAL EQUIPMENT

NEW	EXISTING	
		PEDESTRIAN SIGNAL HEAD
		PUSH BUTTON ASSEMBLY POST
		PEDESTRIAN BARRICADE
		VEHICLE SIGNAL HEAD (WITH BACKPLATE AND 3-SECTIONS: RED, YELLOW AND GREEN)
		VEHICLE SIGNAL HEAD WITH ANGLE VISOR
		MODIFICATIONS OF BASIC SYMBOL: "L" INDICATES ALL NON-ARROW SECTIONS LOUVERED "LG" INDICATES LOUVERED GREEN SECTION ONLY "PV" INDICATES ALL 12" SECTIONS PROGRAMMED VISIBILITY "8" INDICATES ALL 8" SECTIONS (ONLY WHEN SPECIFIED)
		VEHICLE SIGNAL HEAD CONSISTING OF RED, YELLOW AND GREEN LEFT ARROW SECTIONS
		VEHICLE SIGNAL HEAD CONSISTING OF RED AND YELLOW SECTIONS WITH AN UP GREEN ARROW SECTION
		VEHICLE SIGNAL HEAD (5 SECTION) CONSISTING OF RED, YELLOW AND GREEN SECTIONS WITH YELLOW AND GREEN RIGHT ARROW SECTIONS
		TYPE 15TS STANDARD WITH VEHICLE SIGNAL HEAD AND LUMINAIRE
		TYPE 21TS STANDARD WITH VEHICLE SIGNAL HEAD AND LUMINAIRE
		STANDARD WITH LUMINAIRE AND SIGNAL MAST ARMS AND ATTACHED VEHICLE SIGNAL HEADS
		TYPE 1 STANDARD WITH ATTACHED VEHICLE SIGNAL HEADS
		STANDARD WITH A SIGNAL MAST ARM, ATTACHED VEHICLE SIGNAL HEADS AND INTERNALLY ILLUMINATED STREET NAME SIGN
		CONTROLLER ASSEMBLY. DOOR INDICATES FRONT OF CABINET

SERVICE EQUIPMENT

NEW	EXISTING	
		OVERHEAD LINES
		WOOD POLE, "U" INDICATES UTILITY OWNED
		POLE GUY WITH ANCHOR
		UTILITY TRANSFORMER - GROUND MOUNTED
		SERVICE EQUIPMENT ENCLOSURE TYPE. DOOR INDICATES FRONT OF ENCLOSURE
		TELEPHONE DEMARCATION CABINET

 POLE-MOUNTED SERVICE DESIGNATION



FLASHING BEACON

NEW	EXISTING	
		FLASHING BEACON (ONE VEHICLE SIGNAL HEAD WITH BACKPLATE AND VISOR) "R" INDICATES RED INDICATION, "Y" INDICATES YELLOW INDICATION
		FLASHING BEACON WITH TYPE 15-FBS STANDARD AND A SIGN.
		FLASHING BEACON WITH TYPES 9, 9A OR 9B SIGN UNLESS OTHERWISE SPECIFIED OR INDICATED

SIGNAL EQUIPMENT Cont

NEW	EXISTING	
		GUARD POST
		TYPE 1 STANDARD WITH RAMP METERING SIGN
		OPTICAL DETECTOR FOR THE EMERGENCY VEHICLE DETECTION

NOTES:

- All signal sections shall be 12" unless shown otherwise.
- Signal heads shall be provided with backplates unless shown otherwise.

ILLUMINATED OVERHEAD SIGN

NEW	EXISTING	
		SINGLE POST, SINGLE ILLUMINATED SIGN, BALANCED BUTTERFLY
		SINGLE POST, DOUBLE ILLUMINATED SIGN, BALANCED BUTTERFLY
		SINGLE POST, SINGLE ILLUMINATED SIGN, FULL CANTILEVER
		DOUBLE POST, SINGLE ILLUMINATED SIGN
		SINGLE ILLUMINATED SIGN MOUNTED ON STRUCTURE
		DOUBLE POST, SINGLE ILLUMINATED SIGN WITH ELECTROLIER

STATE OF CALIFORNIA
DEPARTMENT OF TRANSPORTATION

ELECTRICAL SYSTEMS (LEGEND AND ABBREVIATIONS)

NO SCALE

RSP ES-1B DATED OCTOBER 30, 2015 SUPERSEDES RSP ES-1B DATED JULY 19, 2013 AND STANDARD PLAN ES-1B DATED MAY 20, 2011 - PAGE 426 OF THE STANDARD PLANS BOOK DATED 2010.

REVISED STANDARD PLAN RSP ES-1B


2010 REVISED STANDARD PLAN RSP ES-1B




TO ACCOMPANY PLANS DATED 2-1-16

EQUIPMENT IDENTIFICATION


ILLUMINATED SIGN IDENTIFICATION NUMBER:

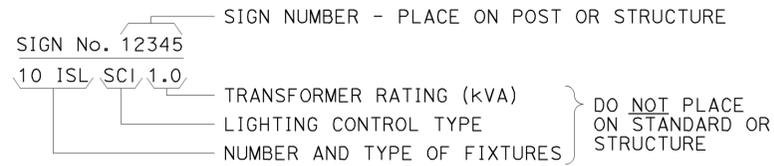


ELECTROLIER OR EQUIPMENT IDENTIFICATION NUMBER:

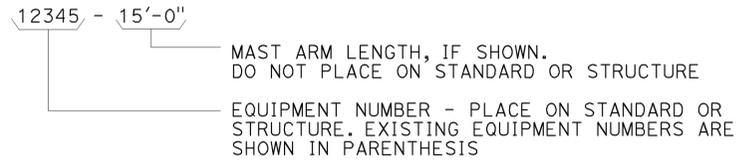


CONDUIT AND CONDUCTOR IDENTIFICATION:

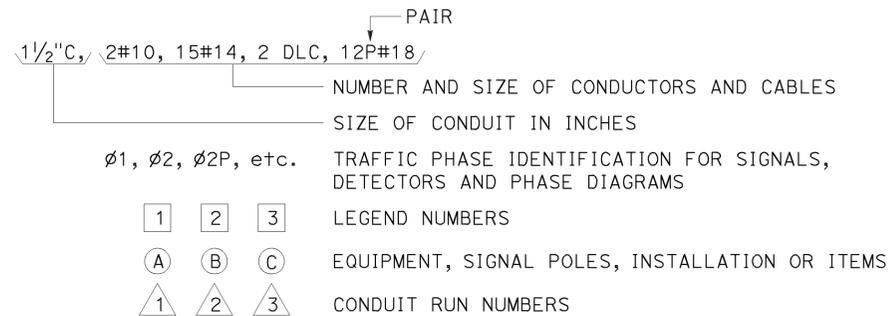


SIGNAL AND LIGHTING STANDARD (TYPICAL DESIGNATION):

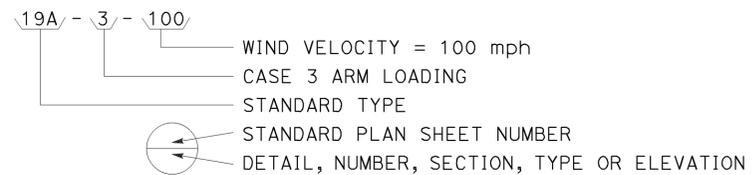


MISCELLANEOUS EQUIPMENT

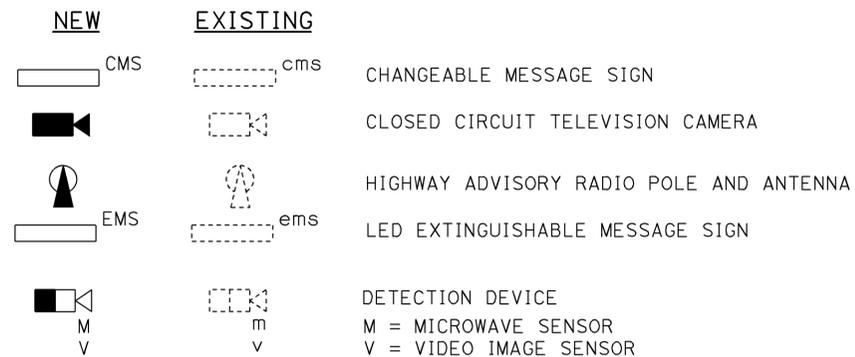



WIRING DIAGRAM LEGEND

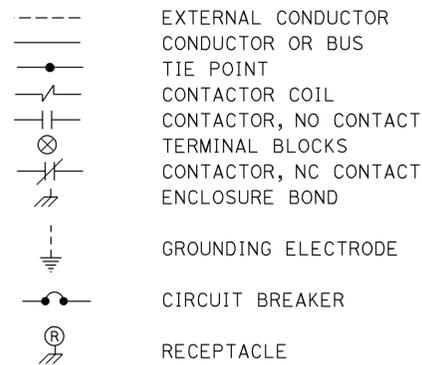

PULL BOXES

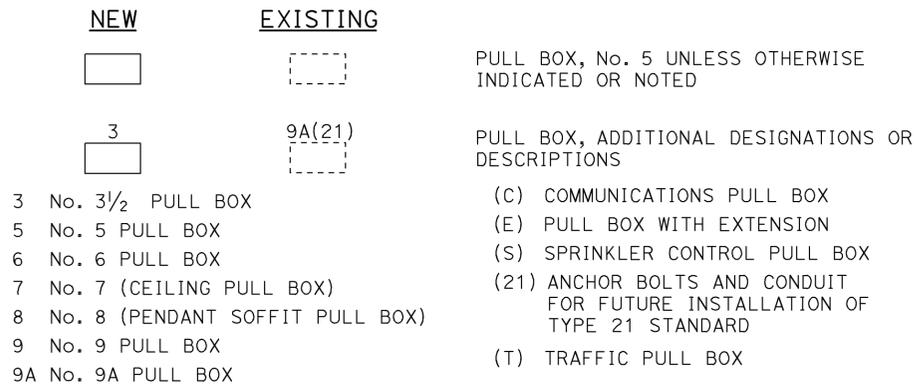

VEHICLE DETECTORS

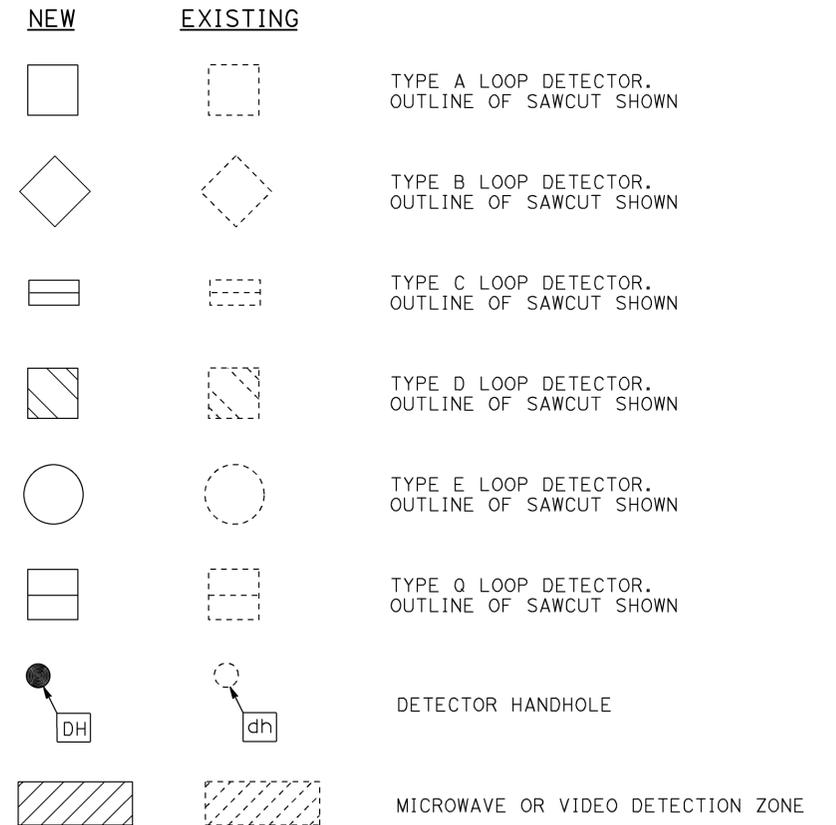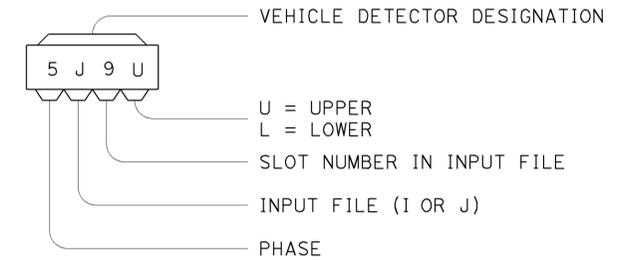

STATE OF CALIFORNIA
 DEPARTMENT OF TRANSPORTATION

 
ELECTRICAL SYSTEMS (LEGEND AND ABBREVIATIONS)

NO SCALE

RSP ES-1C DATED OCTOBER 30, 2015 SUPERSEDES RSP ES-1C DATED JULY 19, 2013 AND STANDARD PLAN ES-1C DATED MAY 20, 2011 - PAGE 427 OF THE STANDARD PLANS BOOK DATED 2010.


REVISED STANDARD PLAN RSP ES-1C

2010 REVISED STANDARD PLAN RSP ES-1C


Dist	COUNTY	ROUTE	POST MILES TOTAL PROJECT	SHEET No.	TOTAL SHEETS
07	LA	5	13.8/19.2	247	262
 REGISTERED ELECTRICAL ENGINEER					
October 30, 2015 PLANS APPROVAL DATE					
					
<small>THE STATE OF CALIFORNIA OR ITS OFFICERS OR AGENTS SHALL NOT BE RESPONSIBLE FOR THE ACCURACY OR COMPLETENESS OF SCANNED COPIES OF THIS PLAN SHEET.</small>					

TO ACCOMPANY PLANS DATED 2-1-16

 
2010 REVISED STANDARD PLAN RSP ES-4A




SV-2-TD

 


SV-2-TC

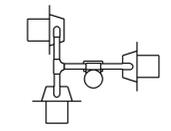


SV-3-TC

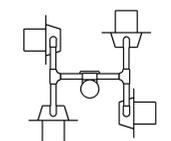


SV-4-TC

 


SV-2B

 

SV-2-TB

 


SV-3-TB

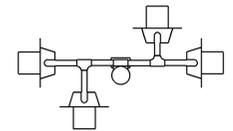

SV-4-TB

 
PLAN VIEW OF OTHER
SIDE MOUNTINGS




SV



 
SV-1




SV-2A

 


SV-1-T

 

SV-2-TA

 

SV-3-TA

 

SV-4-TA

SIDE MOUNTINGS

ABBREVIATIONS:

 
- SV SIDE MOUNTED SIGNAL HEADS
- T TERMINAL COMPARTMENT
- TV TOP MOUNTED SIGNAL HEADS
- 1, 2, 3, 4 NUMBER OF SIGNAL FACES
(3 - SECTION, UNLESS OTHERWISE INDICATED)
- A, B, C, D CONFIGURATION OF SIGNALS

NOTES:


1. Mountings shall be oriented to provide maximum horizontal clearance to adjacent roadway.
2. Bracket arms shall be long enough to permit proper alignment of signals and backplate installation.
3. See Revised Standard Plans RSP ES-4D and RSP ES-4E for attachment fitting details.




TV-1




TV-2

 


TV-1-T

 

TV-2-T

 

TV-3-T

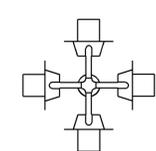

TV-4-T

PLAN VIEW OF
TOP MOUNTINGS

TOP MOUNTINGS

STATE OF CALIFORNIA
DEPARTMENT OF TRANSPORTATION
**ELECTRICAL SYSTEMS
(SIGNAL HEADS AND MOUNTINGS)**
NO SCALE





RSP ES-4A DATED OCTOBER 30, 2015 SUPERSEDES RSP ES-4A DATED JULY 19, 2013 AND
STANDARD PLAN ES-4A DATED MAY 20, 2011 - PAGE 443 OF THE STANDARD PLANS BOOK DATED 2010.

REVISED STANDARD PLAN RSP ES-4A

DIST	COUNTY	ROUTE	POST MILES TOTAL PROJECT	SHEET No.	TOTAL SHEETS
07	LA	5	13.8/19.2	248	262

Theresa Gabriel
 REGISTERED ELECTRICAL ENGINEER
 October 30, 2015
 PLANS APPROVAL DATE
 Theresa Aziz Gabriel
 No. E15129
 Exp. 6-30-16
 ELECTRICAL
 STATE OF CALIFORNIA
THE STATE OF CALIFORNIA OR ITS OFFICERS OR AGENTS SHALL NOT BE RESPONSIBLE FOR THE ACCURACY OR COMPLETENESS OF SCANNED COPIES OF THIS PLAN SHEET.

TO ACCOMPANY PLANS DATED 2-1-16

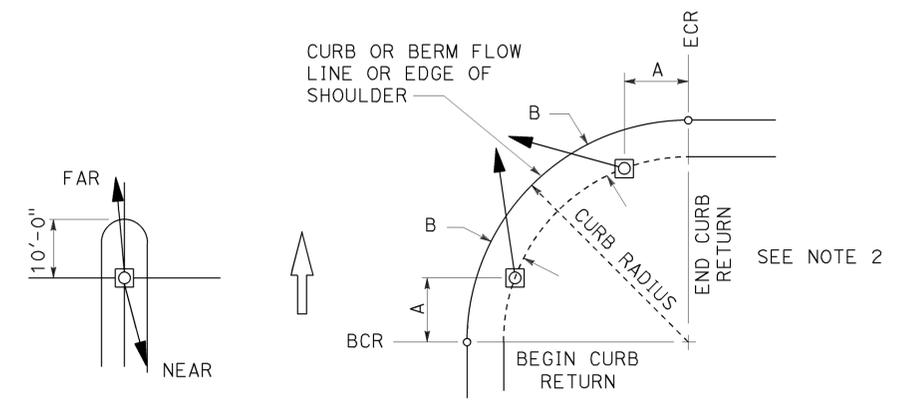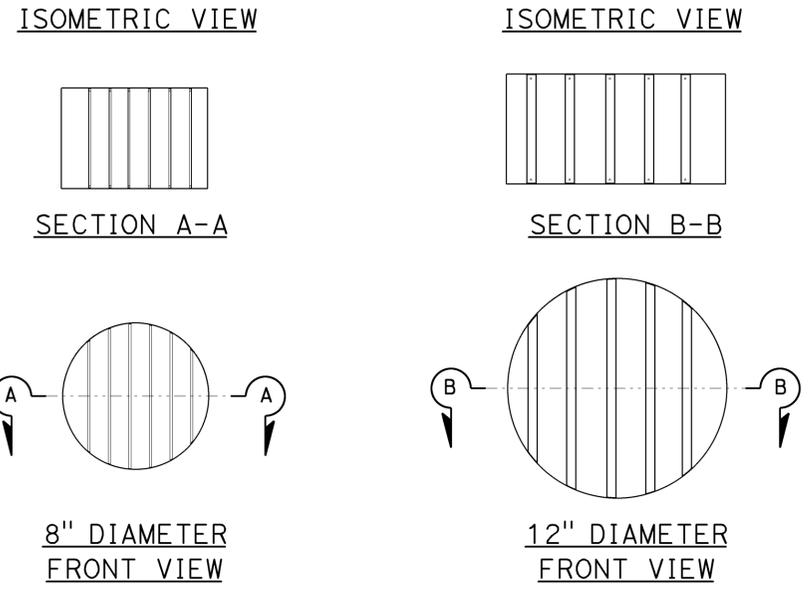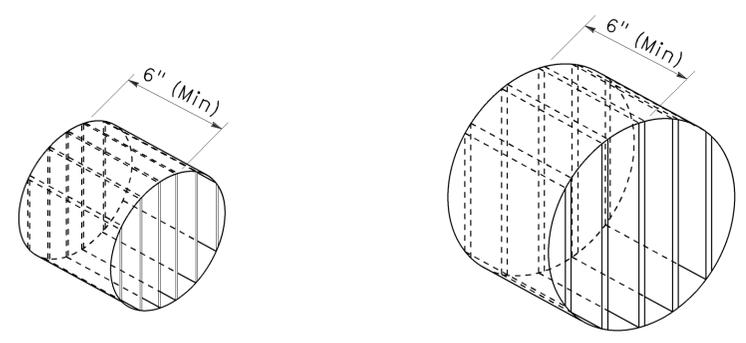
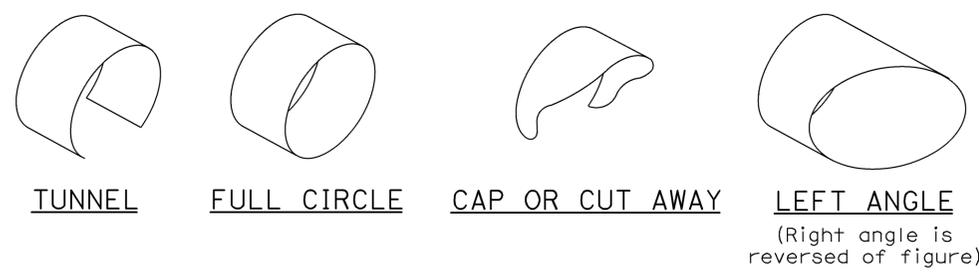


- NOTES:**
1. Typical signal pole placement unless dimensioned on plans.
 2. For A and B dimensions, see Pole Schedule.

DIRECTIONAL LOUVER

Directional louvers shall be oriented and secured in place with one plated brass machine screw and nut.

SIGNAL STANDARD PLACEMENT DIMENSIONS AND EQUIPMENT LOCATIONS

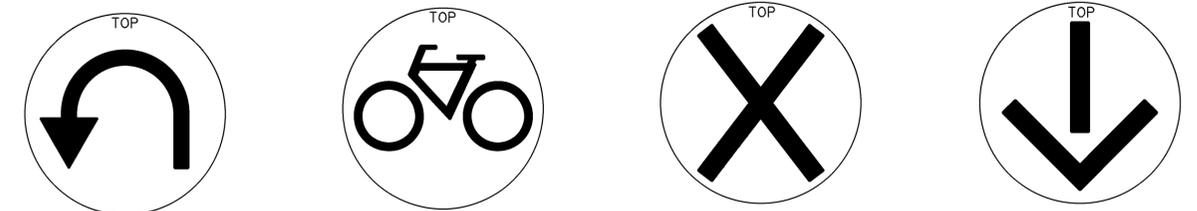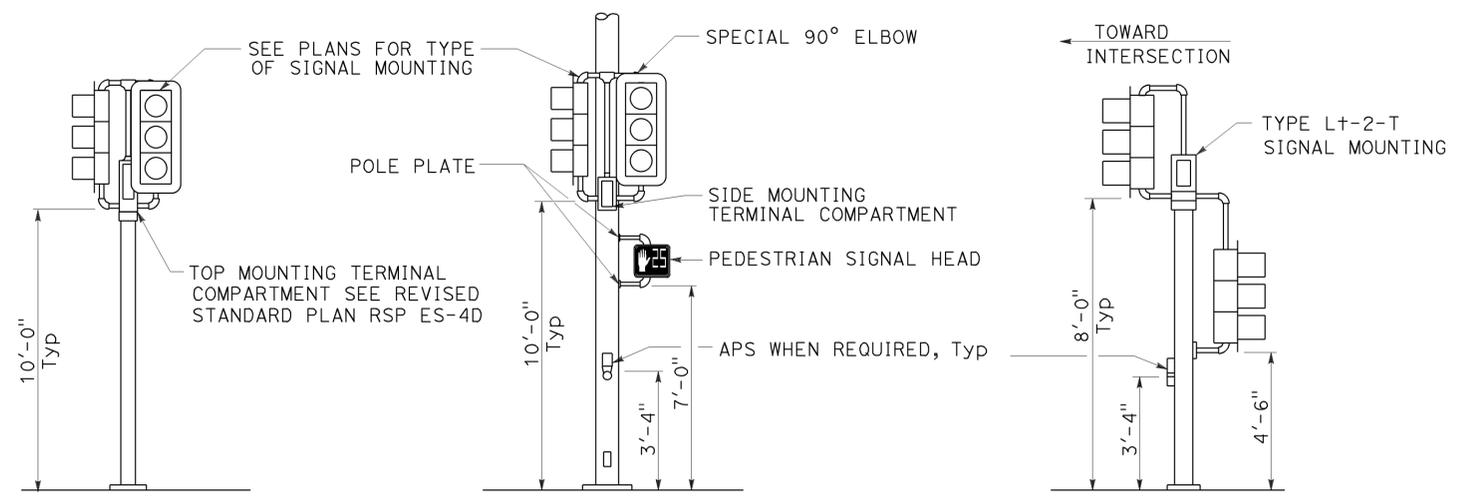

SIGNAL FACES

STATE OF CALIFORNIA
 DEPARTMENT OF TRANSPORTATION

ELECTRICAL SYSTEMS (SIGNAL HEADS AND MOUNTINGS)

NO SCALE

RSP ES-4C DATED OCTOBER 30, 2015 SUPERSEDES RSP ES-4C DATED JULY 19, 2013 AND STANDARD PLAN ES-4C DATED MAY 20, 2011 - PAGE 445 OF THE STANDARD PLANS BOOK DATED 2010.

REVISED STANDARD PLAN RSP ES-4C

2010 REVISED STANDARD PLAN RSP ES-4C

TYPICAL SIGNAL HEAD INSTALLATIONS

Type 1-A, 1-B, 1-C and 1-D standard as indicated on the plans

Normally used on standards with luminaire or signal mast arm


Type 1-A, 1-B, 1-C and 1-D standard as indicated on plans

Dist	COUNTY	ROUTE	POST MILES TOTAL PROJECT	SHEET No.	TOTAL SHEETS
07	LA	5	13.8/19.2	249	262


Theresa Gabriel
 REGISTERED ELECTRICAL ENGINEER
 October 30, 2015
 PLANS APPROVAL DATE
THE STATE OF CALIFORNIA OR ITS OFFICERS OR AGENTS SHALL NOT BE RESPONSIBLE FOR THE ACCURACY OR COMPLETENESS OF SCANNED COPIES OF THIS PLAN SHEET.




TO ACCOMPANY PLANS DATED 2-1-16

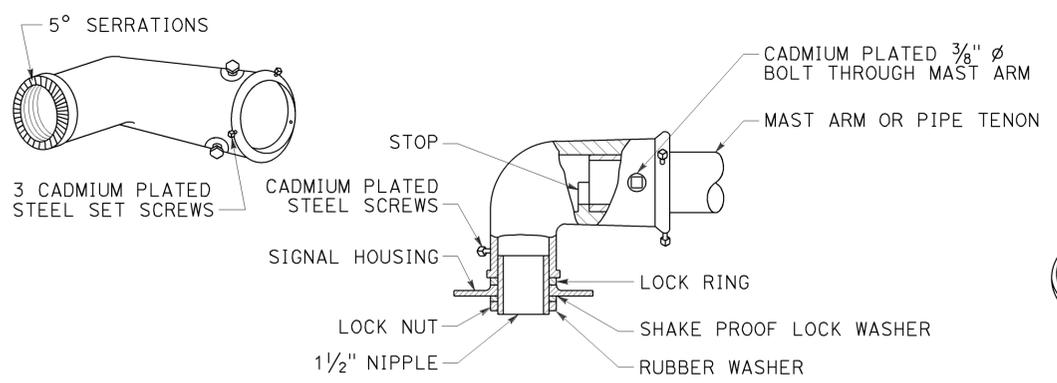

TYPE MAT
MAST ARM MOUNTING
For 2 NPS pipe, see Note 1.

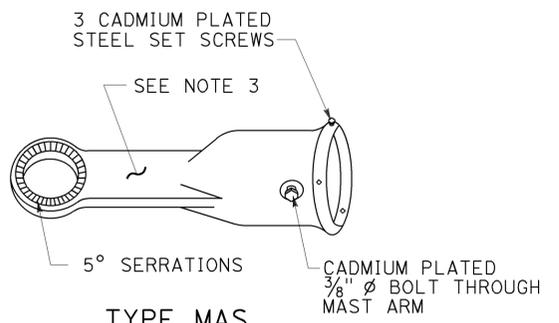


TYPE MAS
MAST ARM MOUNTING
For 2 NPS pipe, see Note 1.

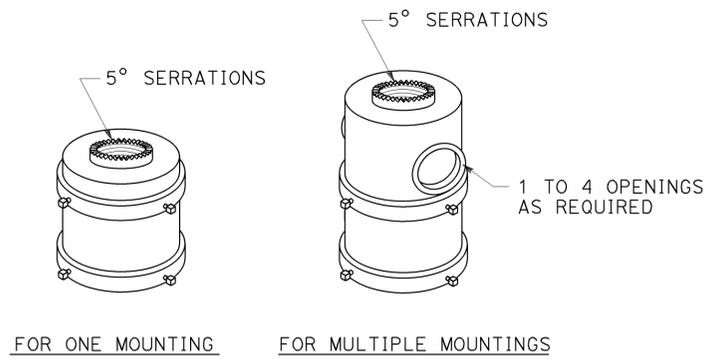


TOP MOUNTINGS
For 4 NPS pipe, see Note 2.


SIGNAL SLIP FITTERS

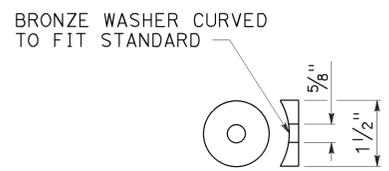

DETAIL C

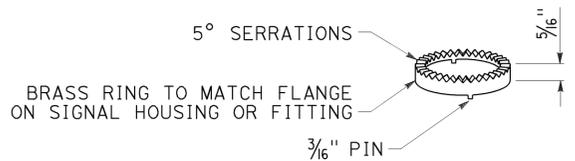


LOCK RING
Use where locking ring is not integral with signal housing or fitting.

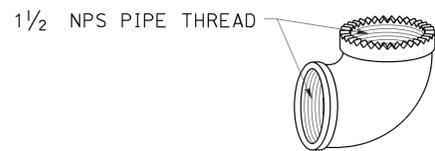


SPECIAL 90° ELBOW
One for each signal head, except those with special slip fitter mounting

- NOTES:**
- After mast arm signal has been plumbed and secured, drill $\frac{1}{16}$ " hole through mast arm tenon in line with slip fitter hole. Place a cadmium plated $\frac{3}{8}$ " ϕ galvanized bolt with washer under bolt head through hole and secure with washer, nut, and locknut. Seal openings between mast arm mountings and mast arm with mastic.
 - (A) Threaded top mounted slip fitter openings shall be $1\frac{1}{2}$ NPS.
(B) Serrations in fittings shall match those on bottom of signal heads or in lock ring.
(C) Top opening shall be offset when backplate is used.
 - Wireway shall have a cross section area of 0.95 square inch minimum. Minimum width of $\frac{1}{2}$ ".


MISCELLANEOUS MOUNTING HARDWARE

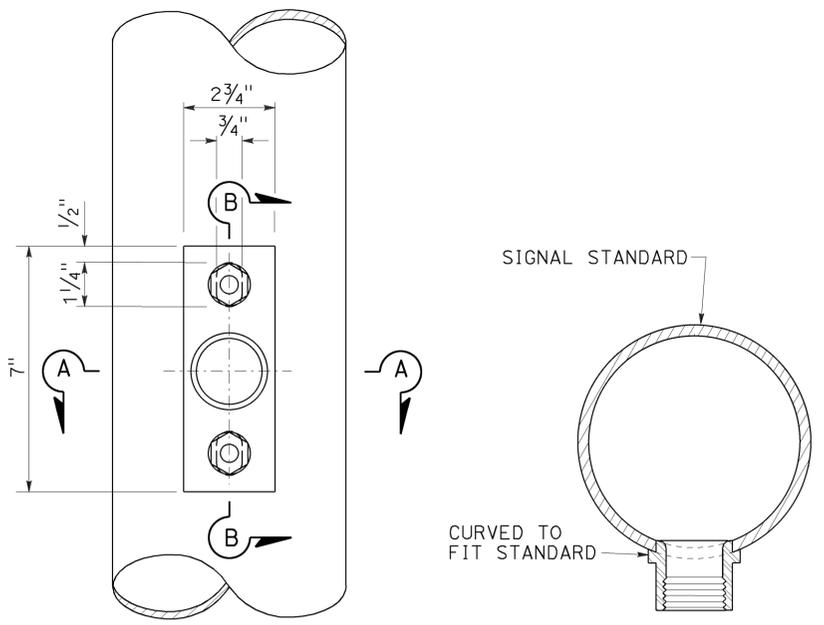

TOP VIEW

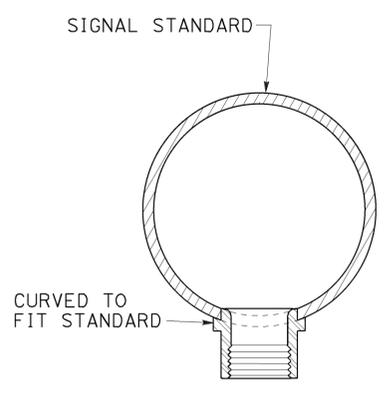


SECTION A-A

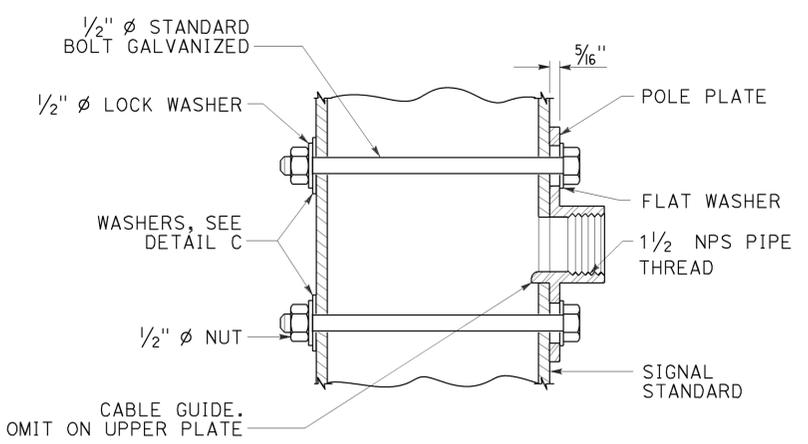

SECTION B-B

POLE PLATE FOR SIDE MOUNTED SIGNAL HEAD WITHOUT TERMINAL COMPARTMENT

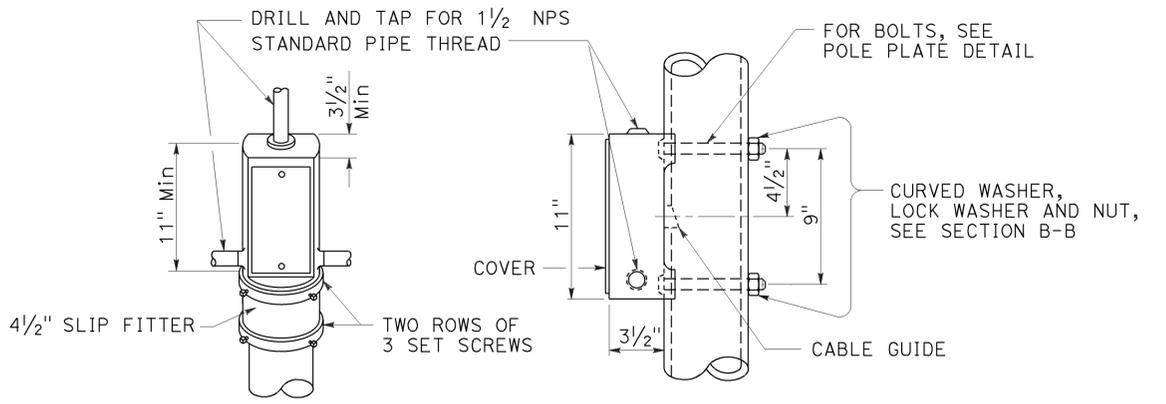

TOP MOUNTING

SIDE MOUNTING

TERMINAL COMPARTMENT

STATE OF CALIFORNIA
DEPARTMENT OF TRANSPORTATION
ELECTRICAL SYSTEMS
(SIGNAL HEAD MOUNTING)
NO SCALE

RSP ES-4D DATED OCTOBER 30, 2015 SUPERSEDES STANDARD PLAN ES-4D DATED MAY 20, 2011 - PAGE 446 OF THE STANDARD PLANS BOOK DATED 2010.

REVISED STANDARD PLAN RSP ES-4D


2010 REVISED STANDARD PLAN RSP ES-4D

Dist	COUNTY	ROUTE	POST MILES TOTAL PROJECT	SHEET No.	TOTAL SHEETS
07	LA	5	13.8/19.2	250	262

Theresa Gabriel
 REGISTERED ELECTRICAL ENGINEER
 October 30, 2015
 PLANS APPROVAL DATE
THE STATE OF CALIFORNIA OR ITS OFFICERS OR AGENTS SHALL NOT BE RESPONSIBLE FOR THE ACCURACY OR COMPLETENESS OF SCANNED COPIES OF THIS PLAN SHEET.




TO ACCOMPANY PLANS DATED 2-1-16

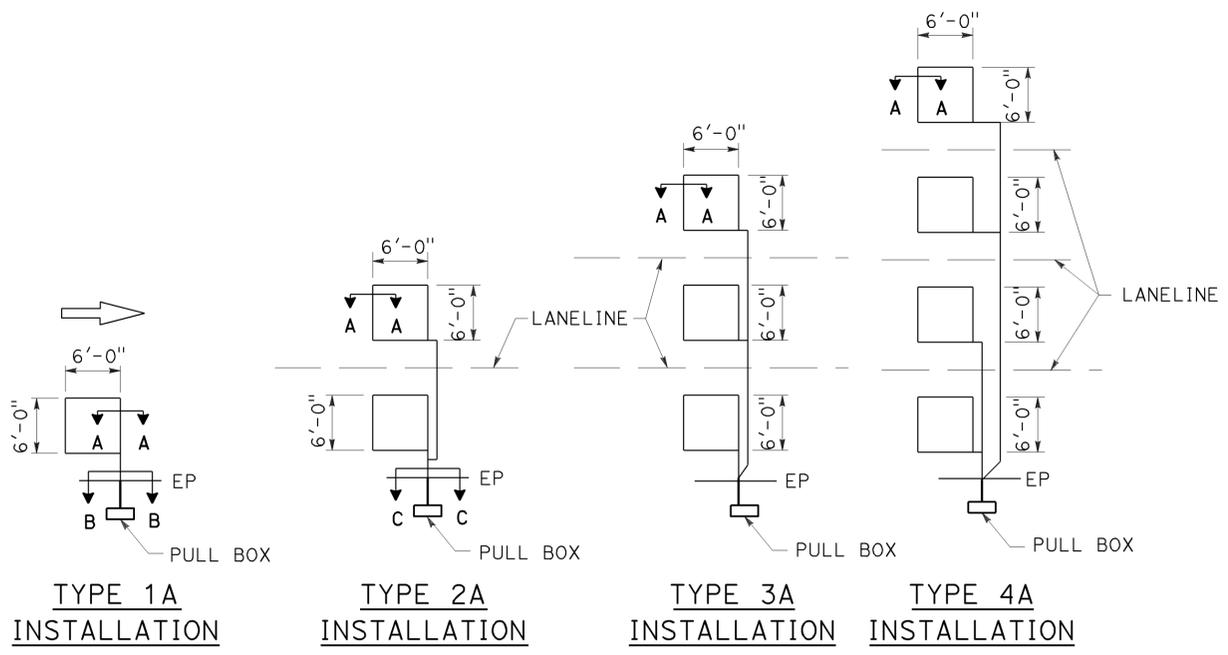


SAWCUT DETAILS

- Type A loop detector configurations illustrated
- 1A thru 4A = 1 Type A loop configuration in each lane.
 - 1B thru 4B = 1 Type B loop configuration in each lane.
 - 1C = 1 Type C loop configuration entering lanes as required.
 - 1D thru 4D = 1 Type D loop configuration in each lane.
 - 1E thru 4E = 1 Type E loop configuration in each lane.
 - 1Q thru 4Q = 1 Type Q loop configuration in each lane.
- Use Type A, B, C, D, E or Q loop detector configurations only when specified or shown on plans.

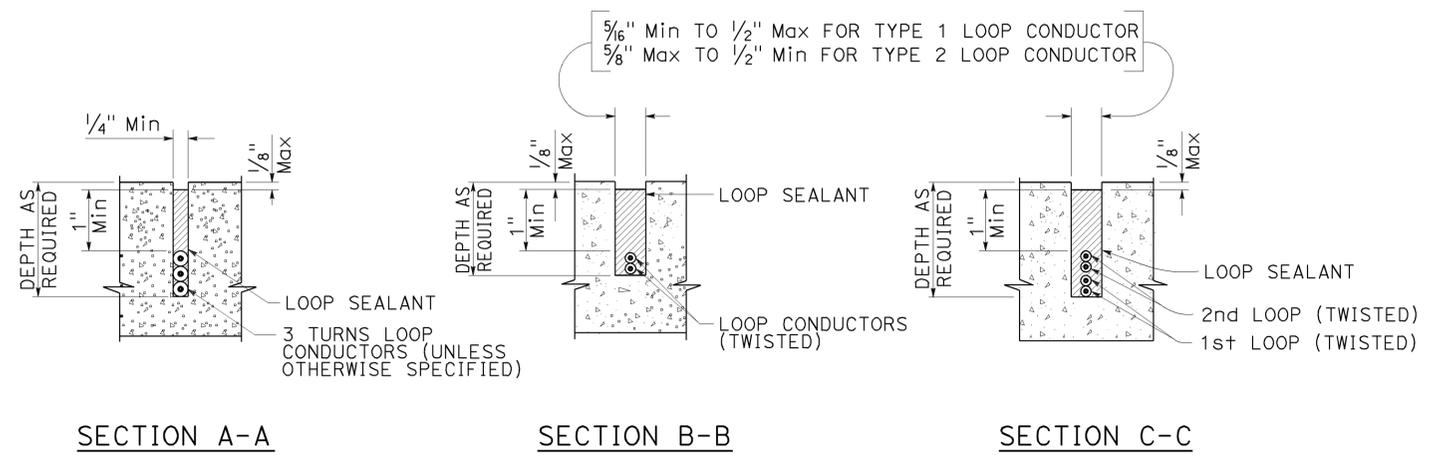


SLOT DETAILS - TYPE 1 AND TYPE 2 LOOP CONDUCTOR

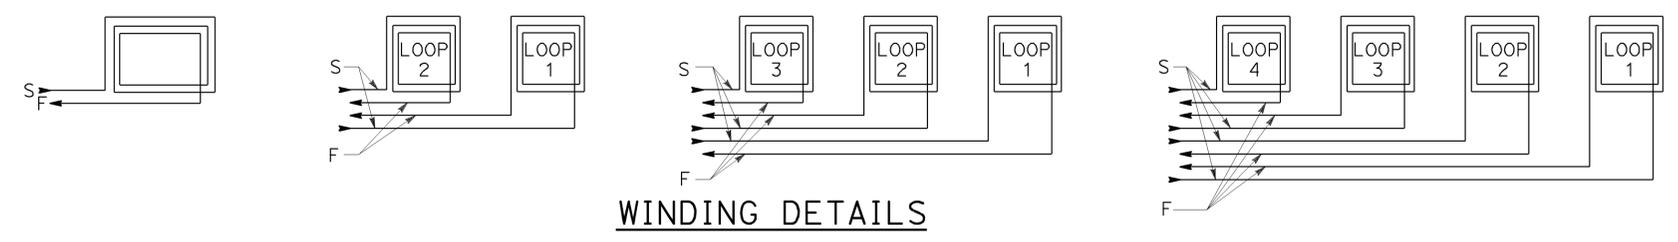

WINDING DETAILS

ABBREVIATIONS:
 S - START
 F - FINISH

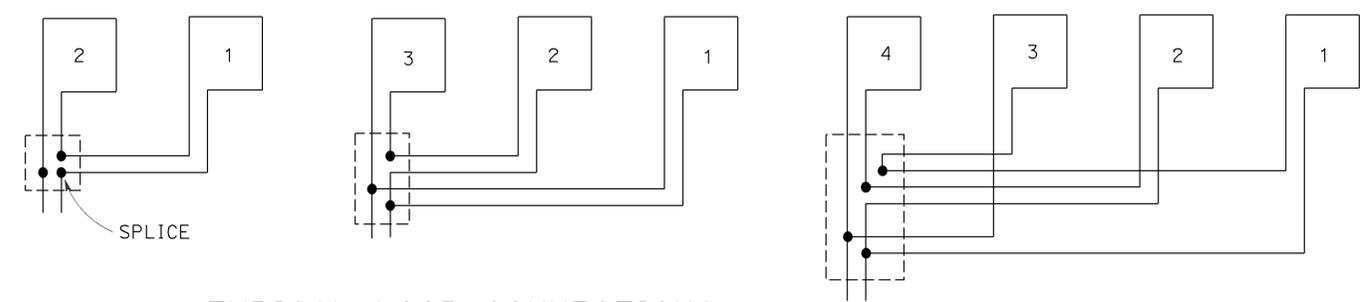

TYPICAL LOOP CONNECTIONS
 Dashed lines represent the pull box

STATE OF CALIFORNIA
 DEPARTMENT OF TRANSPORTATION
**ELECTRICAL SYSTEMS
 (LOOP DETECTORS)**
 NO SCALE

RSP ES-5A DATED OCTOBER 30, 2015 SUPERSEDES STANDARD PLAN ES-5A DATED MAY 20, 2011 - PAGE 448 OF THE STANDARD PLANS BOOK DATED 2010.

REVISED STANDARD PLAN RSP ES-5A

2010 REVISED STANDARD PLAN RSP ES-5A


Dist	COUNTY	ROUTE	POST MILES TOTAL PROJECT	SHEET No.	TOTAL SHEETS
07	LA	5	13.8/19.2	251	262

Theresa Gabriel
 REGISTERED ELECTRICAL ENGINEER
 Theresa
 Aziz Gabriel
 No. E15129
 Exp. 6-30-16
 ELECTRICAL
 STATE OF CALIFORNIA


October 30, 2015
 PLANS APPROVAL DATE
THE STATE OF CALIFORNIA OR ITS OFFICERS OR AGENTS SHALL NOT BE RESPONSIBLE FOR THE ACCURACY OR COMPLETENESS OF SCANNED COPIES OF THIS PLAN SHEET.

TO ACCOMPANY PLANS DATED 2-1-16


2010 REVISED STANDARD PLAN RSP ES-5B

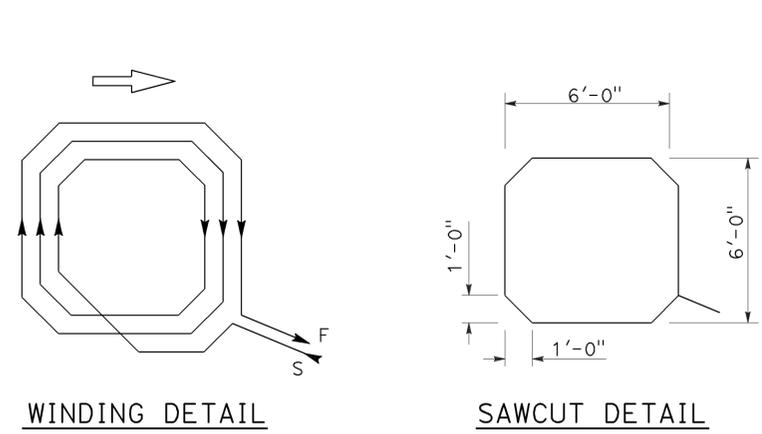


WINDING DETAIL
SAWCUT DETAIL
TYPE A LOOP DETECTOR CONFIGURATION

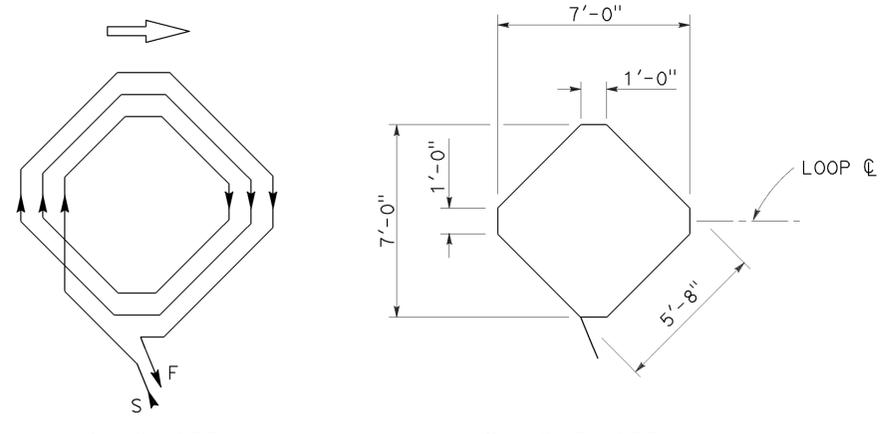


WINDING DETAIL
SAWCUT DETAIL
TYPE B LOOP DETECTOR CONFIGURATION

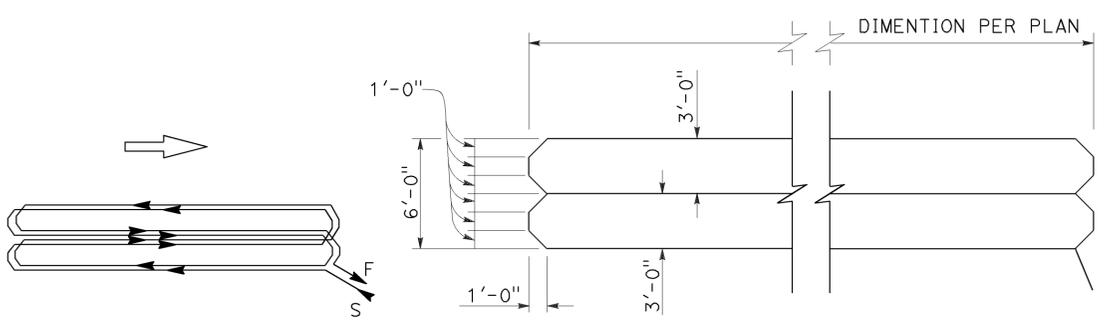


WINDING DETAIL
SAWCUT DETAIL
TYPE C LOOP DETECTOR CONFIGURATION

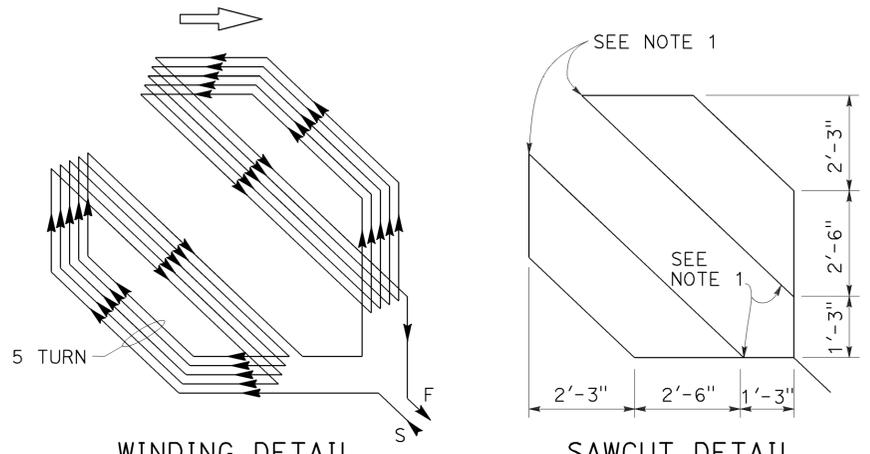


WINDING DETAIL
SAWCUT DETAIL
TYPE D LOOP DETECTOR CONFIGURATION

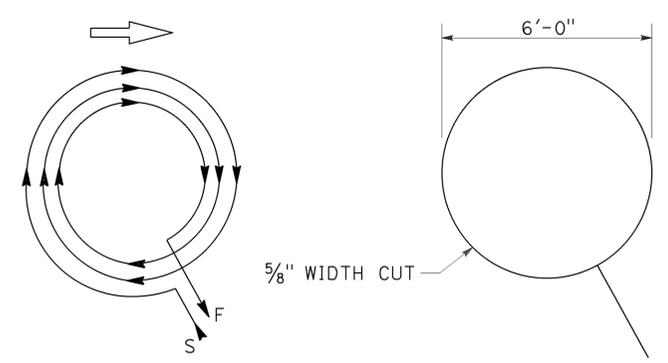

WINDING DETAIL
SAWCUT DETAIL
TYPE E LOOP DETECTOR CONFIGURATION

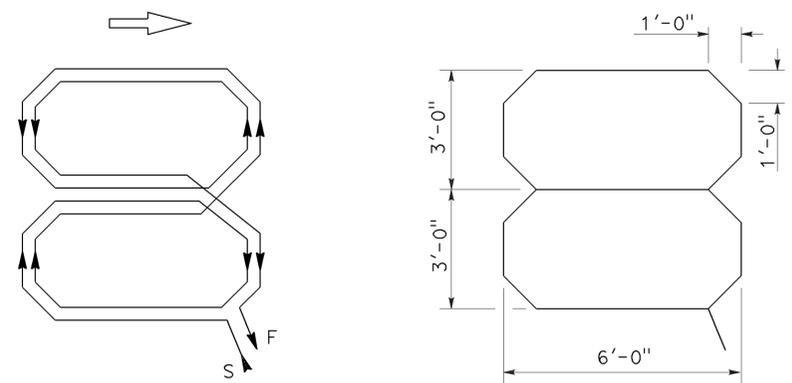

WINDING DETAIL
SAWCUT DETAIL
TYPE Q LOOP DETECTOR CONFIGURATION

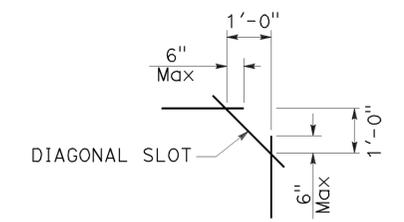

**PLAN VIEW OF
DIAGONAL SLOT
AT CORNERS**

- NOTES:**
1. Round corners of acute angle sawcuts to prevent damage to conductors.
 2. Typical distance separating loops from edge to edge is 10' for Type A, B, D and E installation in single lane.
 3. Use Type D loops for limit line detector installations in left turn and bicycle lanes.

STATE OF CALIFORNIA
DEPARTMENT OF TRANSPORTATION
**ELECTRICAL SYSTEMS
(DETECTORS)**
NO SCALE

RSP ES-5B DATED OCTOBER 30, 2015 SUPERSEDES RSP ES-5B DATED JULY 19, 2013 AND STANDARD PLAN ES-5B DATED MAY 20, 2011 - PAGE 449 OF THE STANDARD PLANS BOOK DATED 2010.


REVISED STANDARD PLAN RSP ES-5B

Dist	COUNTY	ROUTE	POST MILES TOTAL PROJECT	SHEET No.	TOTAL SHEETS
07	LA	5	13.8/19.2	252	262



October 30, 2015
PLANS APPROVAL DATE

Stanley P. Johnson
REGISTERED CIVIL ENGINEER
No. C57793
Exp. 3-31-16
STATE OF CALIFORNIA


TO ACCOMPANY PLANS DATED 2-1-16

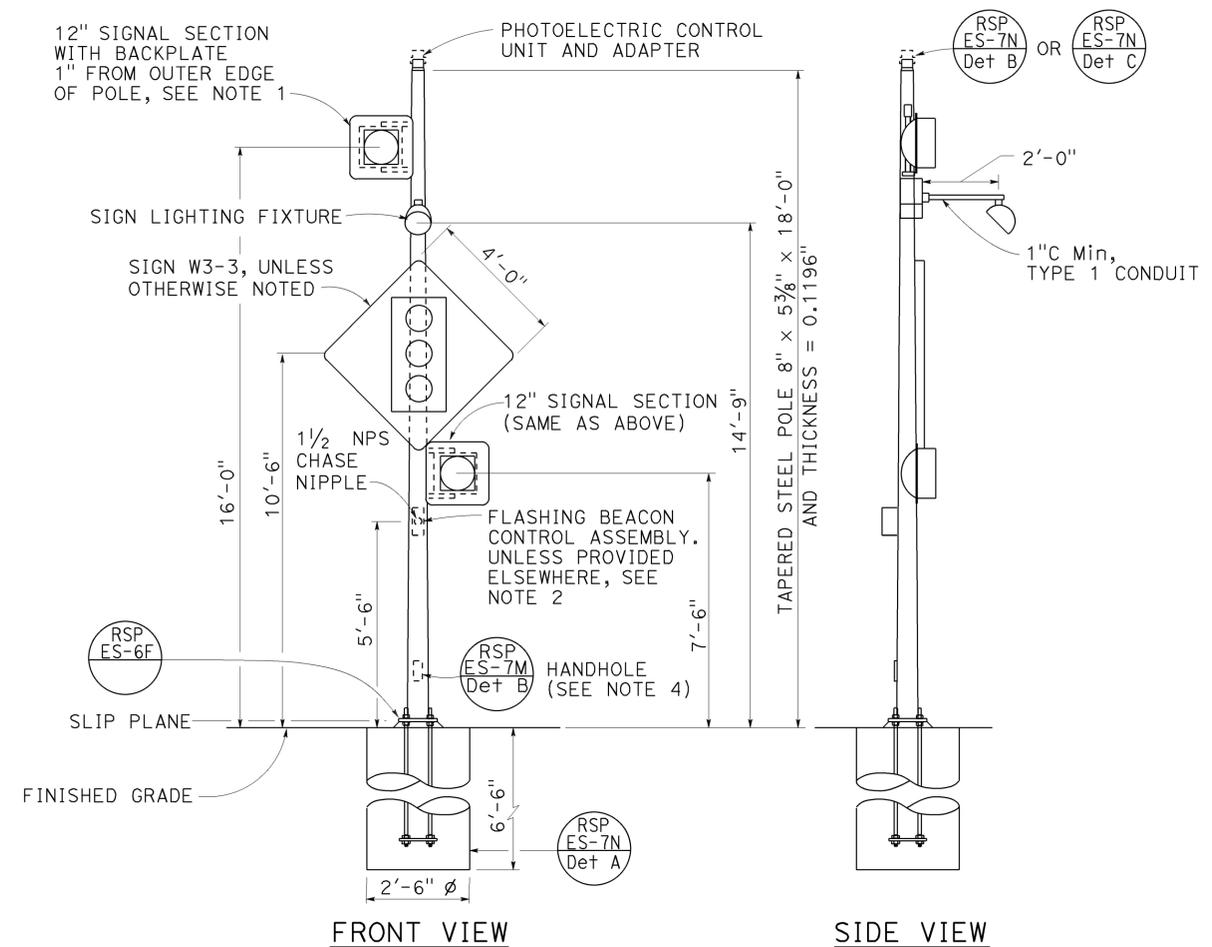



FRONT VIEW SIDE VIEW
TYPE 15-FBS
ADVANCE FLASHING BEACON WITH SLIP BASE INSTALLATION
DETAIL A

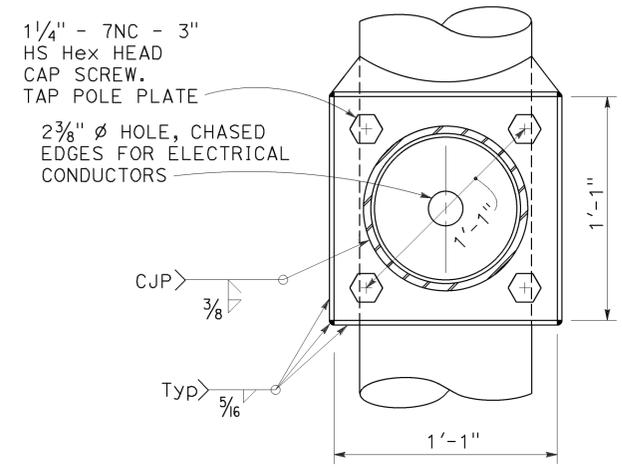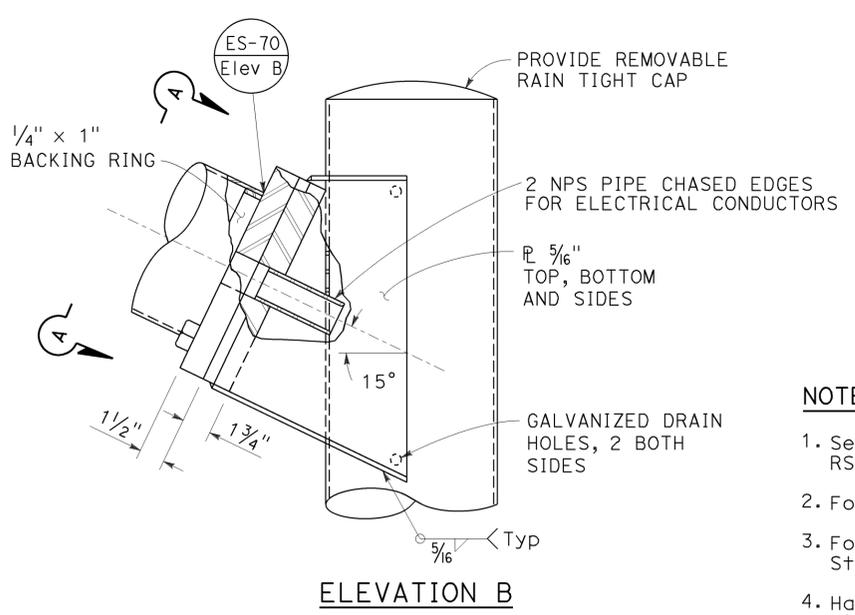

- NOTES:
1. See Revised Standard Plans RSP ES-4A and RSP ES-4D for attachment fitting details.
 2. For wiring diagram, see Standard Plan ES-14B.
 3. For additional notes and details, see Revised Standard Plans RSP ES-7M and RSP ES-7N.
 4. Handhole shall be located on the downstream side of traffic.
 5. See project plans for type of standard to be installed.

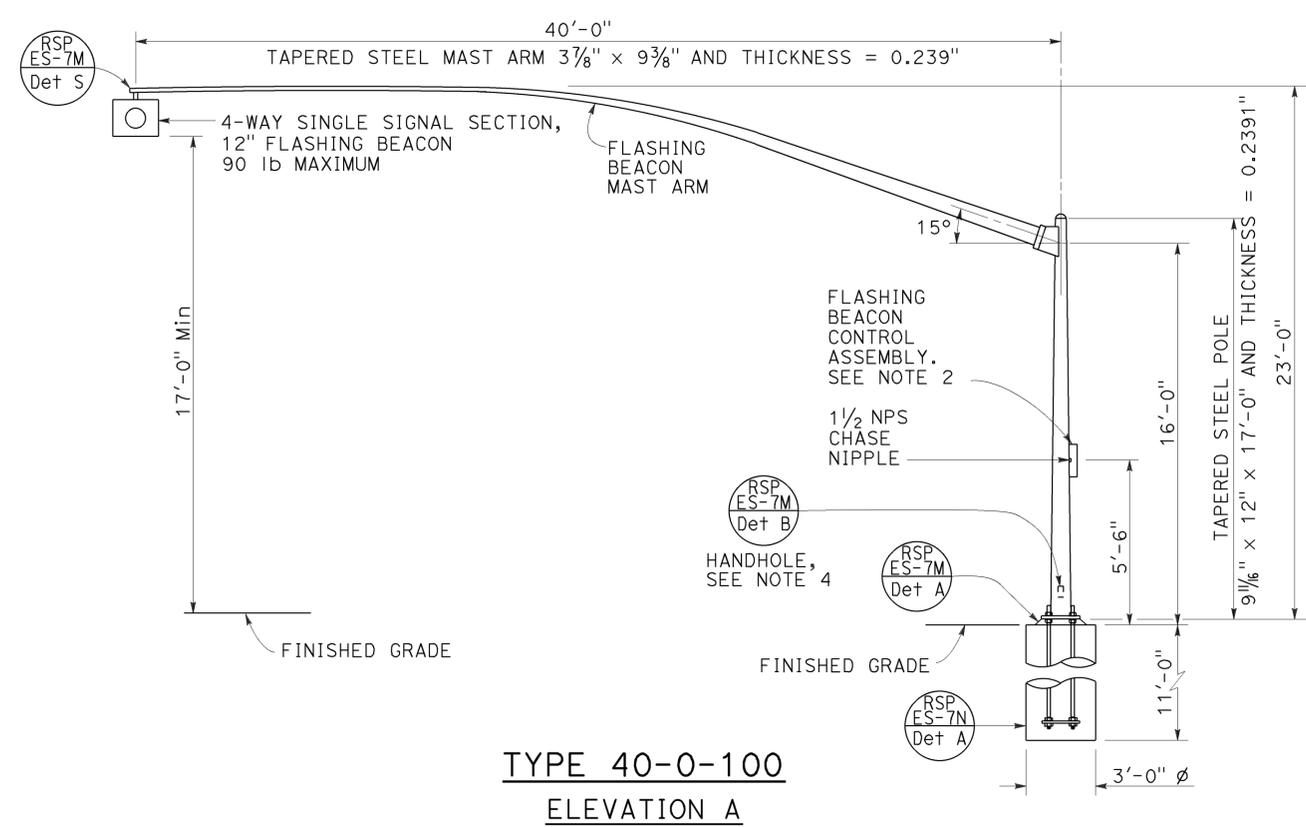

TYPE 40-0-100
ELEVATION A

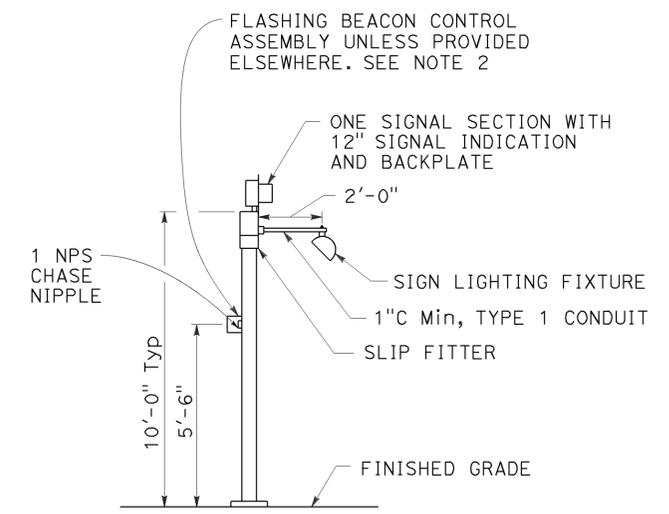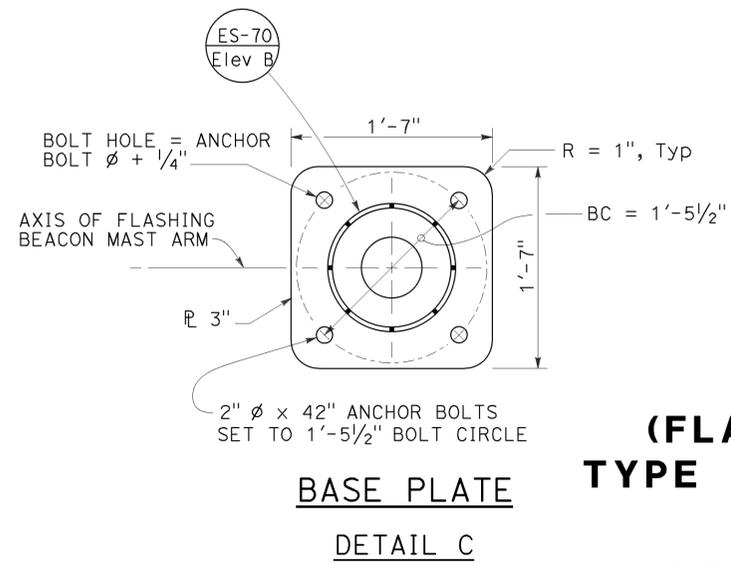

TYPE 1-A, 1-B, 1-C, AND 1-D
ADVANCE FLASHING BEACON INSTALLATION
DETAIL D
See Note 5

STATE OF CALIFORNIA
DEPARTMENT OF TRANSPORTATION
ELECTRICAL SYSTEMS
(FLASHING BEACON ON A TYPE 1, TYPE 15-FBS, AND TYPE 40 STANDARD)
NO SCALE

RSP ES-7J DATED OCTOBER 30, 2015 SUPERSEDES RSP ES-7J DATED JULY 19, 2013 AND STANDARD PLAN ES-7J DATED MAY 20, 2011 - PAGE 471 OF THE STANDARD PLANS BOOK DATED 2010.


2010 REVISED STANDARD PLAN RSP ES-7J

DIST	COUNTY	ROUTE	POST MILES TOTAL PROJECT	SHEET NO.	TOTAL SHEETS
07	LA	5	13.8/19.2	253	262


Theresa Gabriel
 REGISTERED ELECTRICAL ENGINEER
 October 30, 2015
 PLANS APPROVAL DATE
THE STATE OF CALIFORNIA OR ITS OFFICERS OR AGENTS SHALL NOT BE RESPONSIBLE FOR THE ACCURACY OR COMPLETENESS OF SCANNED COPIES OF THIS PLAN SHEET.

REGISTERED PROFESSIONAL ENGINEER
 Theresa Aziz Gabriel
 No. E15129
 Exp. 6-30-16
 ELECTRICAL
 STATE OF CALIFORNIA


TO ACCOMPANY PLANS DATED 2-1-16

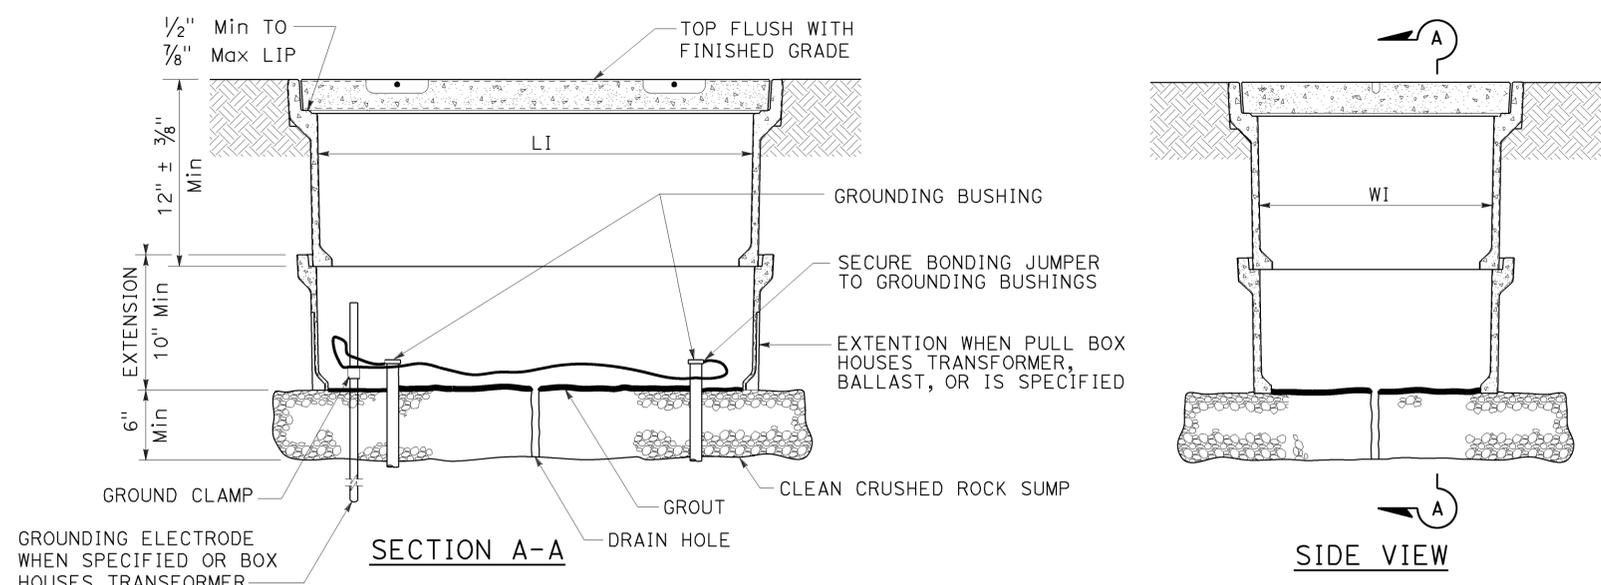


INSTALLATION DETAILS
DETAIL A

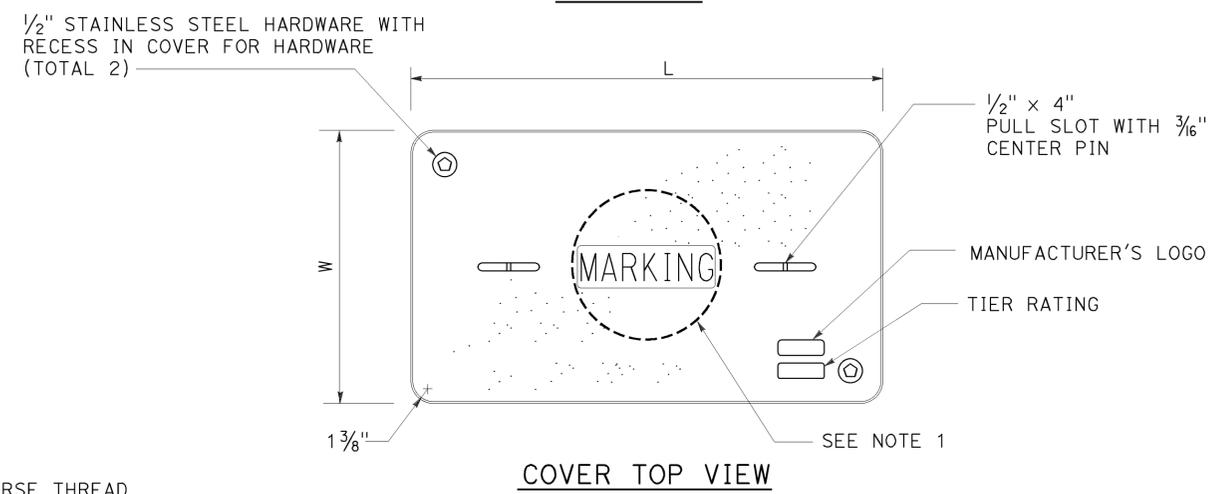

COVER TOP VIEW

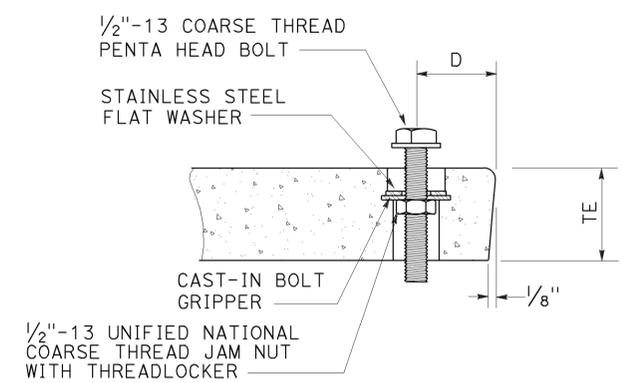

TYPICAL COVER CAPTIVE BOLT
OR SIMILAR

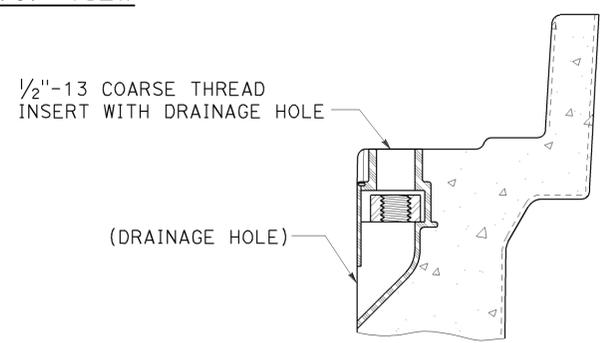

TYPICAL THREADED INSERT
OR SIMILAR

NOTES:

- Pull box covers shall be marked as follows: "SERVICE" Service circuits between service point and service disconnect; "SPRINKLER-CONTROL" sprinkler control circuits, 50 V or less; "CALTRANS" on all pull boxes, except pull boxes marked "SPRINKLER-CONTROL"; and "TELEPHONE" Telephone service;
 - No. 3 1/2 pull box.
 - "SIGNAL" - Traffic signal circuits with or without lighting or sign lighting circuits.
 - "LIGHTING" - Lighting or sign lighting circuits where voltage is under 600 V.
 - No. 5, 6, 9 or 9A pull box.
 - "TRAFFIC SIGNAL" - Traffic signal circuits with or without lighting or sign lighting circuits.
 - "LIGHTING" - Lighting or sign lighting circuits where voltage is under 600 V.
 - "LIGHTING-HIGH VOLTAGE" - Lighting or sign lighting circuits where voltage is above 600 V.
 - "IRRIGATION" - Circuits to irrigation controller 120 V or more.
 - "RAMP METER" - Ramp meter circuits.
 - "COUNT STATION" - Count or speed monitor circuits.
 - "COMMUNICATIONS" - Communication circuits.
 - "TOS COMMUNICATIONS" - TOS communication line.
 - "TOS POWER" - TOS power.
 - "TDC POWER" - Telephone demarcation cabinet power.
 - "CCTV" - Closed circuit television circuits.
 - "TMS" - Traffic monitoring station circuits.
 - "CMS" - Changeable message sign circuits.
 - "HAR" - Highway advisory radio circuits.
 - "BOOSTER PUMP" - Booster pump circuit.
- The nominal dimensions of the opening in which the cover sets shall be the same as the cover dimensions except the length and width dimensions shall be 1/8" greater.
- Covers and boxes shall be interchangeable with California standard male and female gages. When interchanged with a standard male or female gage, the top surfaces shall be flush within 1/8". Top outside radius of covers and pull boxes shall have a 1/8" radius.
- Pull box extension may be another pull box as long as the bottom edge of the pull box can fit into the cover opening.
- Dimensions for the cover for non-traffic pull box are nominal values.

DIMENSION TABLE										
PULL BOX	PULL BOX			COVER						
	MINIMUM DEPTH BOX	MINIMUM DEPTH EXTENSION	MINIMUM WEIGHT	LI Min	WI Min	TE	D	L	W	MINIMUM WEIGHT
No. 3 1/2	12"	N/A	40 lb	1' - 3"	9"	1 3/4"	1 3/4"	1'-3 1/4" - 1'-3 3/8"	10" - 10 1/8"	30 lb
No. 5	12"	10"	55 lb	1' - 8"	11"	2"	1 3/4"	1'-11 1/4"	1'-1 3/4"	60 lb
No. 6	12"	10"	70 lb	2' - 4 1/4"	1' - 3 1/4"	2"	2"	2'-6 1/2"	1'-5 1/2"	85 lb

STATE OF CALIFORNIA
DEPARTMENT OF TRANSPORTATION
ELECTRICAL SYSTEMS
(NON-TRAFFIC PULL BOX)
NO SCALE

RSP ES-8A DATED OCTOBER 30, 2015 SUPERSEDES RSP ES-8A DATED JULY 19, 2013 AND RSP ES-8A DATED JANUARY 20, 2012 THAT SUPPLEMENTS THE STANDARD PLANS BOOK DATED 2010.

REVISED STANDARD PLAN RSP ES-8A

2010 REVISED STANDARD PLAN RSP ES-8A


Dist	COUNTY	ROUTE	POST MILES TOTAL PROJECT	SHEET No.	TOTAL SHEETS
07	LA	5	13.8/19.2	254	262

Theresa Gabriel
 REGISTERED ELECTRICAL ENGINEER
 Theresa
 Aziz Gabriel
 No. E15129
 Exp. 6-30-16
 ELECTRICAL
 STATE OF CALIFORNIA

October 30, 2015
 PLANS APPROVAL DATE


THE STATE OF CALIFORNIA OR ITS OFFICERS OR AGENTS SHALL NOT BE RESPONSIBLE FOR THE ACCURACY OR COMPLETENESS OF SCANNED COPIES OF THIS PLAN SHEET.

TO ACCOMPANY PLANS DATED 2-1-16

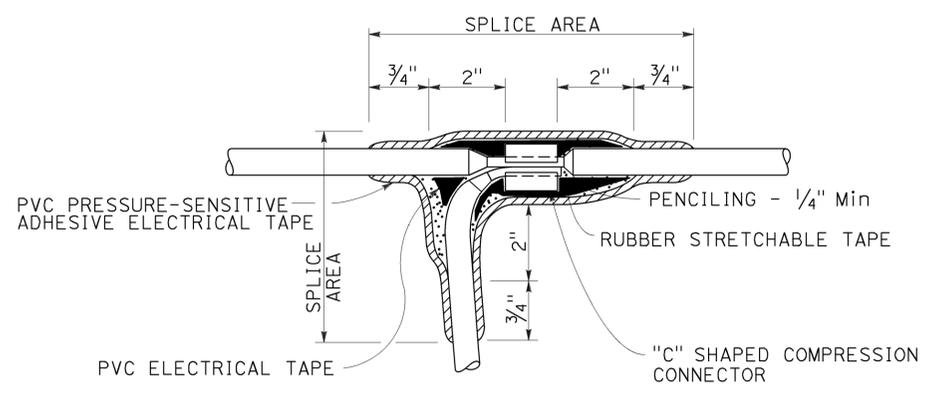

TYPE C SPLICE

See Note 3

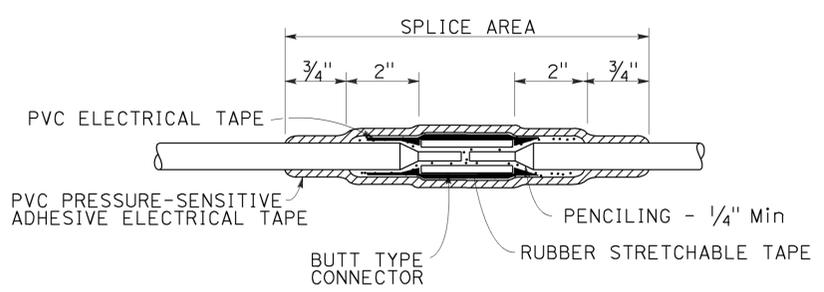


TYPE S SPLICE

See Note 4


NOTES:

1. Dimensions are minimum.
2. Rubber tapes shall be rolled after application.
3. Between 1 free-end and 1 through conductor.
4. Between 2 free-end conductors.
5. Between 3 free-end conductors.

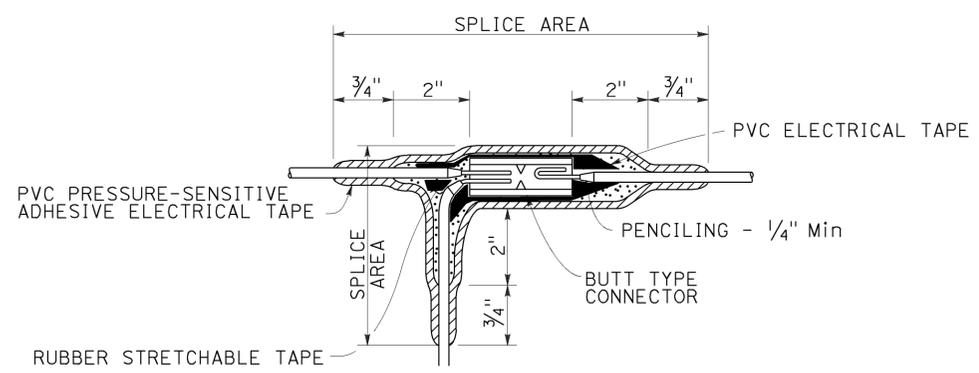

TYPE ST SPLICE

See Note 5

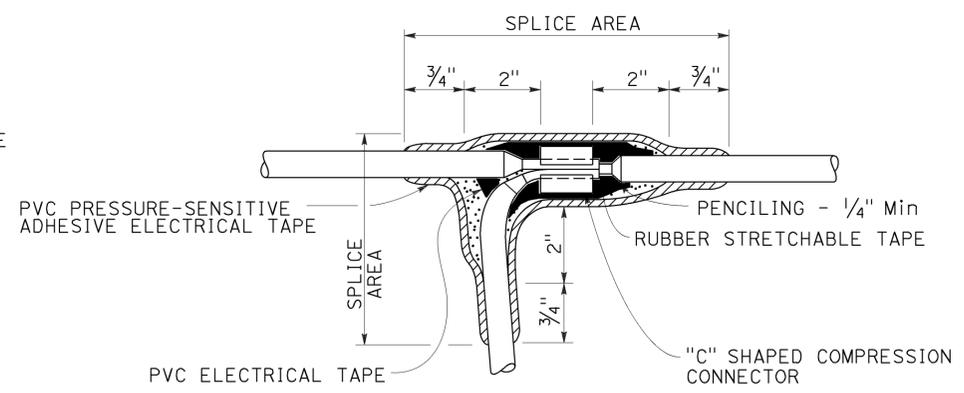

TYPE T SPLICE

See Note 5

STATE OF CALIFORNIA
 DEPARTMENT OF TRANSPORTATION
**ELECTRICAL SYSTEMS
 (SPlicing DETAILS)**
 NO SCALE

RSP ES-13A DATED OCTOBER 30, 2015 SUPERSEDES STANDARD PLAN ES-13A DATED MAY 20, 2011 - PAGE 491 OF THE STANDARD PLANS BOOK DATED 2010.

REVISED STANDARD PLAN RSP ES-13A


2010 REVISED STANDARD PLAN RSP ES-13A

INDEX TO PLANS

SHEET NO.	TITLE
1	GENERAL PLAN NO. 1
2	GENERAL PLAN NO. 2
3	GENERAL PLAN NO. 3
4	GENERAL PLAN NO. 4
5	APPROACH SLAB DETAILS NO. 1
6	APPROACH SLAB DETAILS NO. 2
7	STRUCTURE APPROACH TYPE R(30D)
8	STRUCTURE APPROACH TYPE R(30S)(MOD)

STANDARD PLANS DATED 2010

A10A	ABBREVIATIONS (SHEET 1 OF 2)
RSP A10B	ABBREVIATIONS (SHEET 2 OF 2)
B6-21	JOINT SEALS (MAXIMUM MOVEMENT RATING = 2")
RSP P10	CONCRETE PAVEMENT-DOWEL BAR DETAILS

 

NOTE:

1. For "SECTION A-A" see "APPROACH SLAB DETAILS NO.1" sheet.

LEGEND:

- * Indicates limits of Paving Notch Extension
- ** Indicates limits of Clean Expansion Joint
- Indicates Existing Structure.
- Indicates limits of Structure Approach Type R(30D) and removal of existing roadway section: {1'-0"± PCC (unreinforced) }6"± LCB
- Indicates limits of Existing Joint Seal removal and placement of new Joint Seal. For details, see "APPROACH SLAB DETAILS NO. 1" sheet and

GENERAL NOTES

DESIGN:

AASHTO LRFD BRIDGE DESIGN SPECIFICATIONS, 4th Edition and California Amendments, dated November, 2011

LIVE LOADING:

HL 93 and permit design load.


REINFORCED CONCRETE:

fy = 60 ksi (Yield Strength of Reinforcement)
f'c = 3.6 ksi (Compressive Strength at 28 days)

DIST	COUNTY	ROUTE	POST MILES TOTAL PROJECT	SHEET No.	TOTAL SHEETS
07	LA	5	13.8/19.2	255	262

<i>Ulysses N. Smpardos</i>		3-13-15
REGISTERED CIVIL ENGINEER	DATE	
2-1-16		
PLANS APPROVAL DATE		

The State of California or its officers or agents shall not be responsible for the accuracy or completeness of scanned copies of this plan sheet.

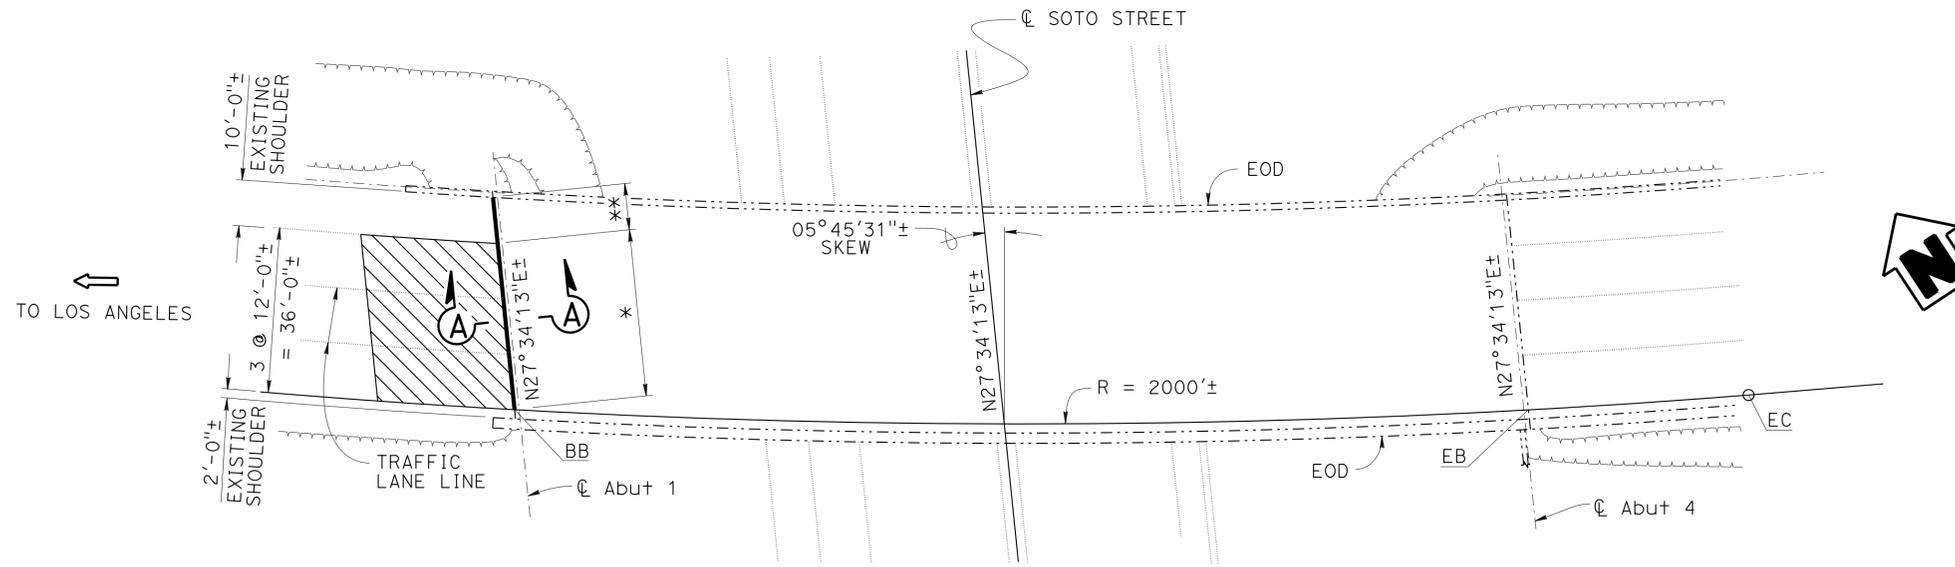

PLAN

1" = 20'-0"

SOTO STREET UNDERCROSSING BRIDGE No. 53-1390R, PM 16.59

SOTO STREET UC

QUANTITIES

STRUCTURAL CONCRETE, APPROACH SLAB (TYPE R)	60	CY
PAVING NOTCH EXTENSION	28	CF
CLEAN EXPANSION JOINT	10	LF
JOINT SEAL (MR 1")	46	LF

NOTE:
THE CONTRACTOR MUST VERIFY ALL CONTROLLING FIELD DIMENSIONS BEFORE ORDERING OR FABRICATING ANY MATERIAL.

Jose Higuera DESIGN ENGINEER	DESIGN	BY Ulysses Smpardos	CHECKED Suzan Moradi	LOAD & RESISTANCE FACTOR DESIGN	LIVE LOADING: HL93 W/"LOW-BOY"; PERMIT DESIGN VEHICLE	STATE OF CALIFORNIA DEPARTMENT OF TRANSPORTATION	DIVISION OF ENGINEERING SERVICES STRUCTURE DESIGN DESIGN BRANCH 15	BRIDGE NO.	VARIES	
	DETAILS	BY Herman Mauroschadt	CHECKED Suzan Moradi	LAYOUT	BY Ulysses Smpardos			CHECKED Suzan Moradi	POST MILE	VARIES
	QUANTITIES	BY Ulysses Smpardos	CHECKED S. Moradi/H. Mauroschadt	SPECIFICATIONS	BY K. Doll			PLANS AND SPECS COMPARED K. Doll		

ORIGINAL SCALE IN INCHES FOR REDUCED PLANS

0 1 2 3

UNIT: 3604

PROJECT NUMBER & PHASE: 07 1300 0492

CONTRACT NO.: 07-30070

DISREGARD PRINTS BEARING EARLIER REVISION DATES

REVISION DATES	SHEET	OF
3-14-14 12-1-14 2-1-15 3-11-15	1	8


DIST	COUNTY	ROUTE	POST MILES TOTAL PROJECT	SHEET No.	TOTAL SHEETS
07	LA	5	13.8/19.2	256	262

Ulysses N. Smpardos 3-13-15
REGISTERED CIVIL ENGINEER DATE

2-1-16
PLANS APPROVAL DATE

Ulysses N. Smpardos
REGISTERED PROFESSIONAL ENGINEER
No. 61018
Exp. 12-31-16
CIVIL
STATE OF CALIFORNIA


The State of California or its officers or agents shall not be responsible for the accuracy or completeness of scanned copies of this plan sheet.

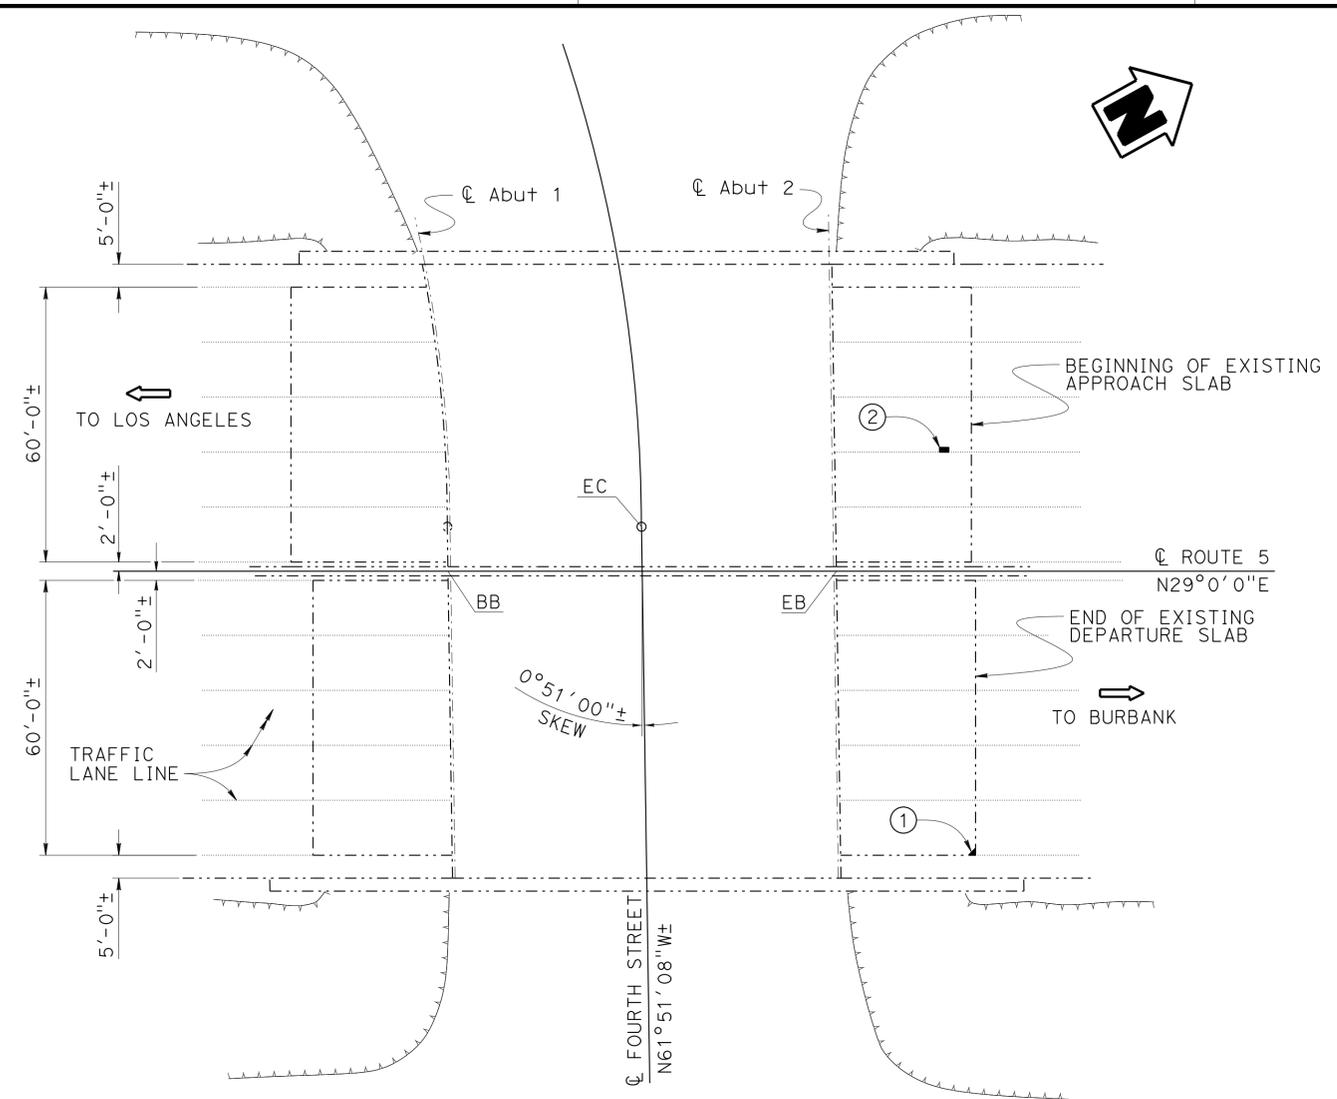

PLAN

1" = 20'-0"

FOURTH STREET UNDERCROSSING
BRIDGE No. 53-1304, PM 17.56

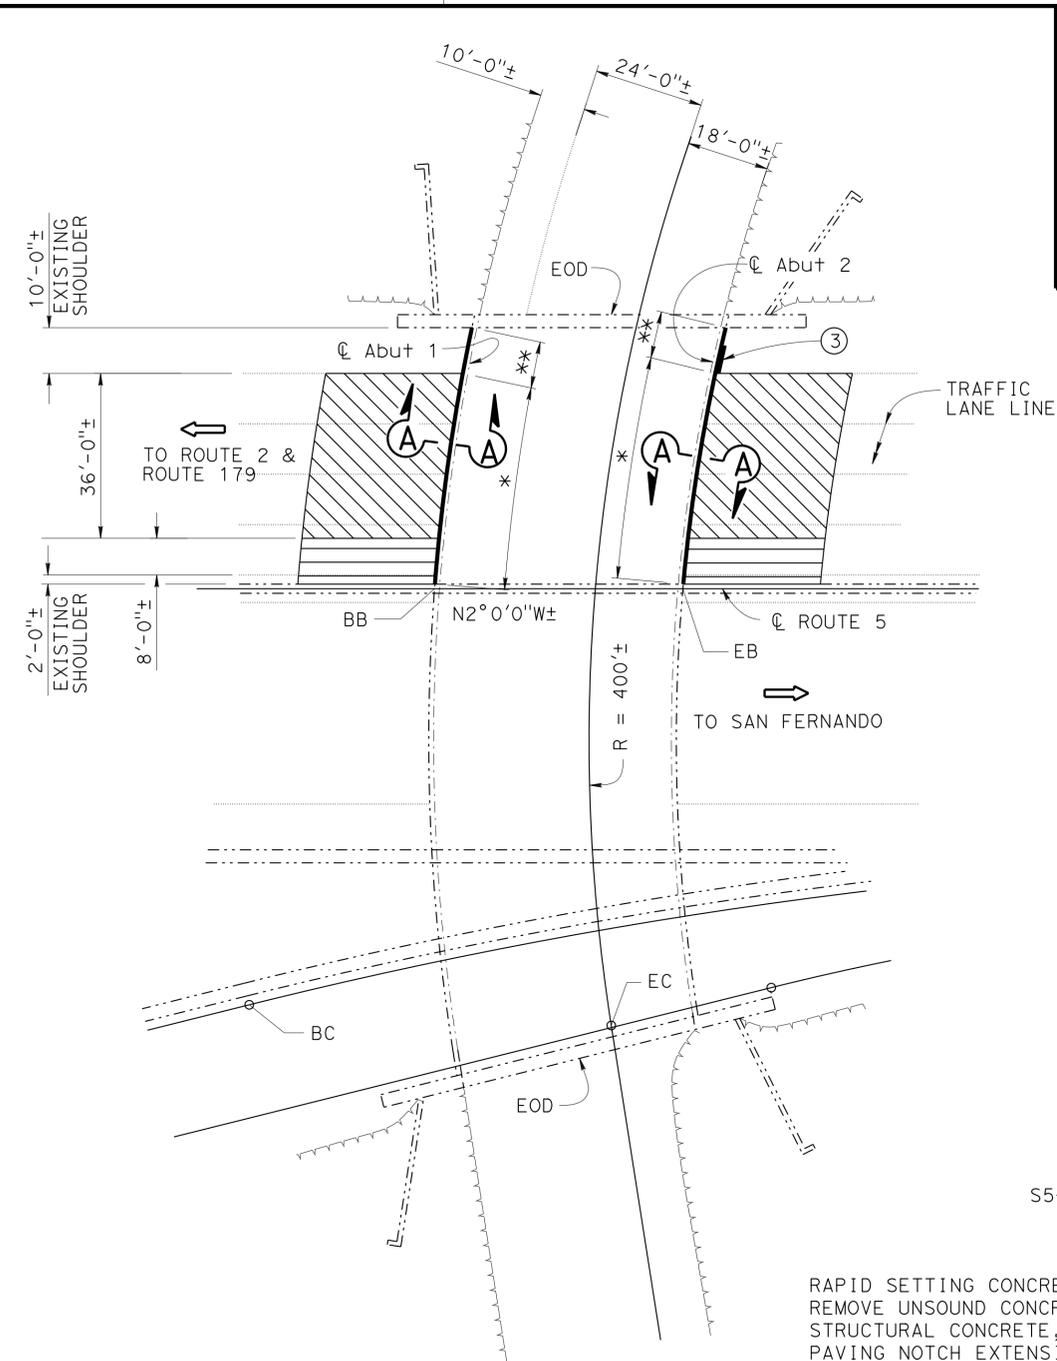

PLAN

1" = 20'-0"

S5-E10 CONNECTOR UNDERCROSSING
BRIDGE No. 53-1316, PM 18.38

S5-E10 CONNECTOR UC
QUANTITIES

RAPID SETTING CONCRETE (PATCH)	1	CF
REMOVE UNSOUND CONCRETE	1	CF
STRUCTURAL CONCRETE, APPROACH SLAB (TYPE R)	109	CY
PAVING NOTCH EXTENSION	69	CF
CLEAN EXPANSION JOINT	20	LF
JOINT SEAL (MR 1/2")	112	LF

FOURTH STREET UC
QUANTITIES

RAPID SETTING CONCRETE (PATCH)	1	CF
REMOVE UNSOUND CONCRETE	1	CF

- LEGEND:**
- * Indicates limits of Paving Notch Extension
 - ** Indicates limits of Clean Expansion Joint
 - Indicates existing structure.
 - Indicates approximate location of remove unsound concrete (as necessary) at existing spall and patch with rapid setting concrete. For additional information, see "REMOVE UNSOUND CONCRETE AND RAPID SETTING CONCRETE (PATCH)" table on "APPROACH SLAB DETAILS NO. 1" sheet.
 - ▨ Indicates limits of Structure Approach Type R(30D) and removal of existing roadway section: {9"± PCC (unreinforced) }4"± CTB
 - ▧ Indicates limits of Structure Approach Type R(30D) and removal of existing roadway section: {5"± AC pavement }7"± LCB
 - | Indicates limits of Existing Joint Seal removal and placement of new Joint Seal. For details, see "APPROACH SLAB DETAILS NO. 1" sheet and B6-21.

NOTE:
THE CONTRACTOR MUST VERIFY ALL CONTROLLING FIELD DIMENSIONS BEFORE ORDERING OR FABRICATING ANY MATERIAL.

DESIGN	BY Ulysses Smpardos	CHECKED Suzan Moradi	LOAD & RESISTANCE FACTOR DESIGN	LIVE LOADING: HL93 W/"LOW-BOY"; PERMIT DESIGN VEHICLE
DETAILS	BY Herman Mauroschat	CHECKED Suzan Moradi	LAYOUT	BY Ulysses Smpardos
QUANTITIES	BY Ulysses Smpardos	CHECKED S. Moradi/H. Mauroschat	SPECIFICATIONS	BY K. Doll

STATE OF CALIFORNIA DEPARTMENT OF TRANSPORTATION	DIVISION OF ENGINEERING SERVICES STRUCTURE DESIGN DESIGN BRANCH 15	BRIDGE NO. VARIES POST MILE VARIES
---	--	---------------------------------------


ROUTE 5 BRIDGE APPROACH AND DEPARTURE SLAB CONSTRUCTION AND PAVEMENT REHABILITATION
GENERAL PLAN NO. 2

DIST	COUNTY	ROUTE	POST MILES TOTAL PROJECT	SHEET No.	TOTAL SHEETS
07	LA	5	13.8/19.2	257	262

Ulysses N. Smpardos 3-13-15
 REGISTERED CIVIL ENGINEER DATE
 2-1-16
 PLANS APPROVAL DATE
 Ulysses N. Smpardos
 No. 61018
 Exp. 12-31-16
 CIVIL
 STATE OF CALIFORNIA
 The State of California or its officers or agents shall not be responsible for the accuracy or completeness of scanned copies of this plan sheet.

LEGEND:

-  Indicates limits of Structure Approach Type R(30S) Mod and removal of existing roadway section: {9"± PCC (unreinforced) } 4"± CTB
-  Indicates limits of Structure Approach Type R(30S) Mod and removal of existing roadway section: {5"± AC pavement } 7"± LCB
-  Indicates limits of Existing Joint Seal removal and placement of new Joint Seal. For details, see "APPROACH SLAB DETAILS NO. 1" sheet and 
-  Indicates Existing Structure.
-  Indicates limits of Clean Expansion Joint

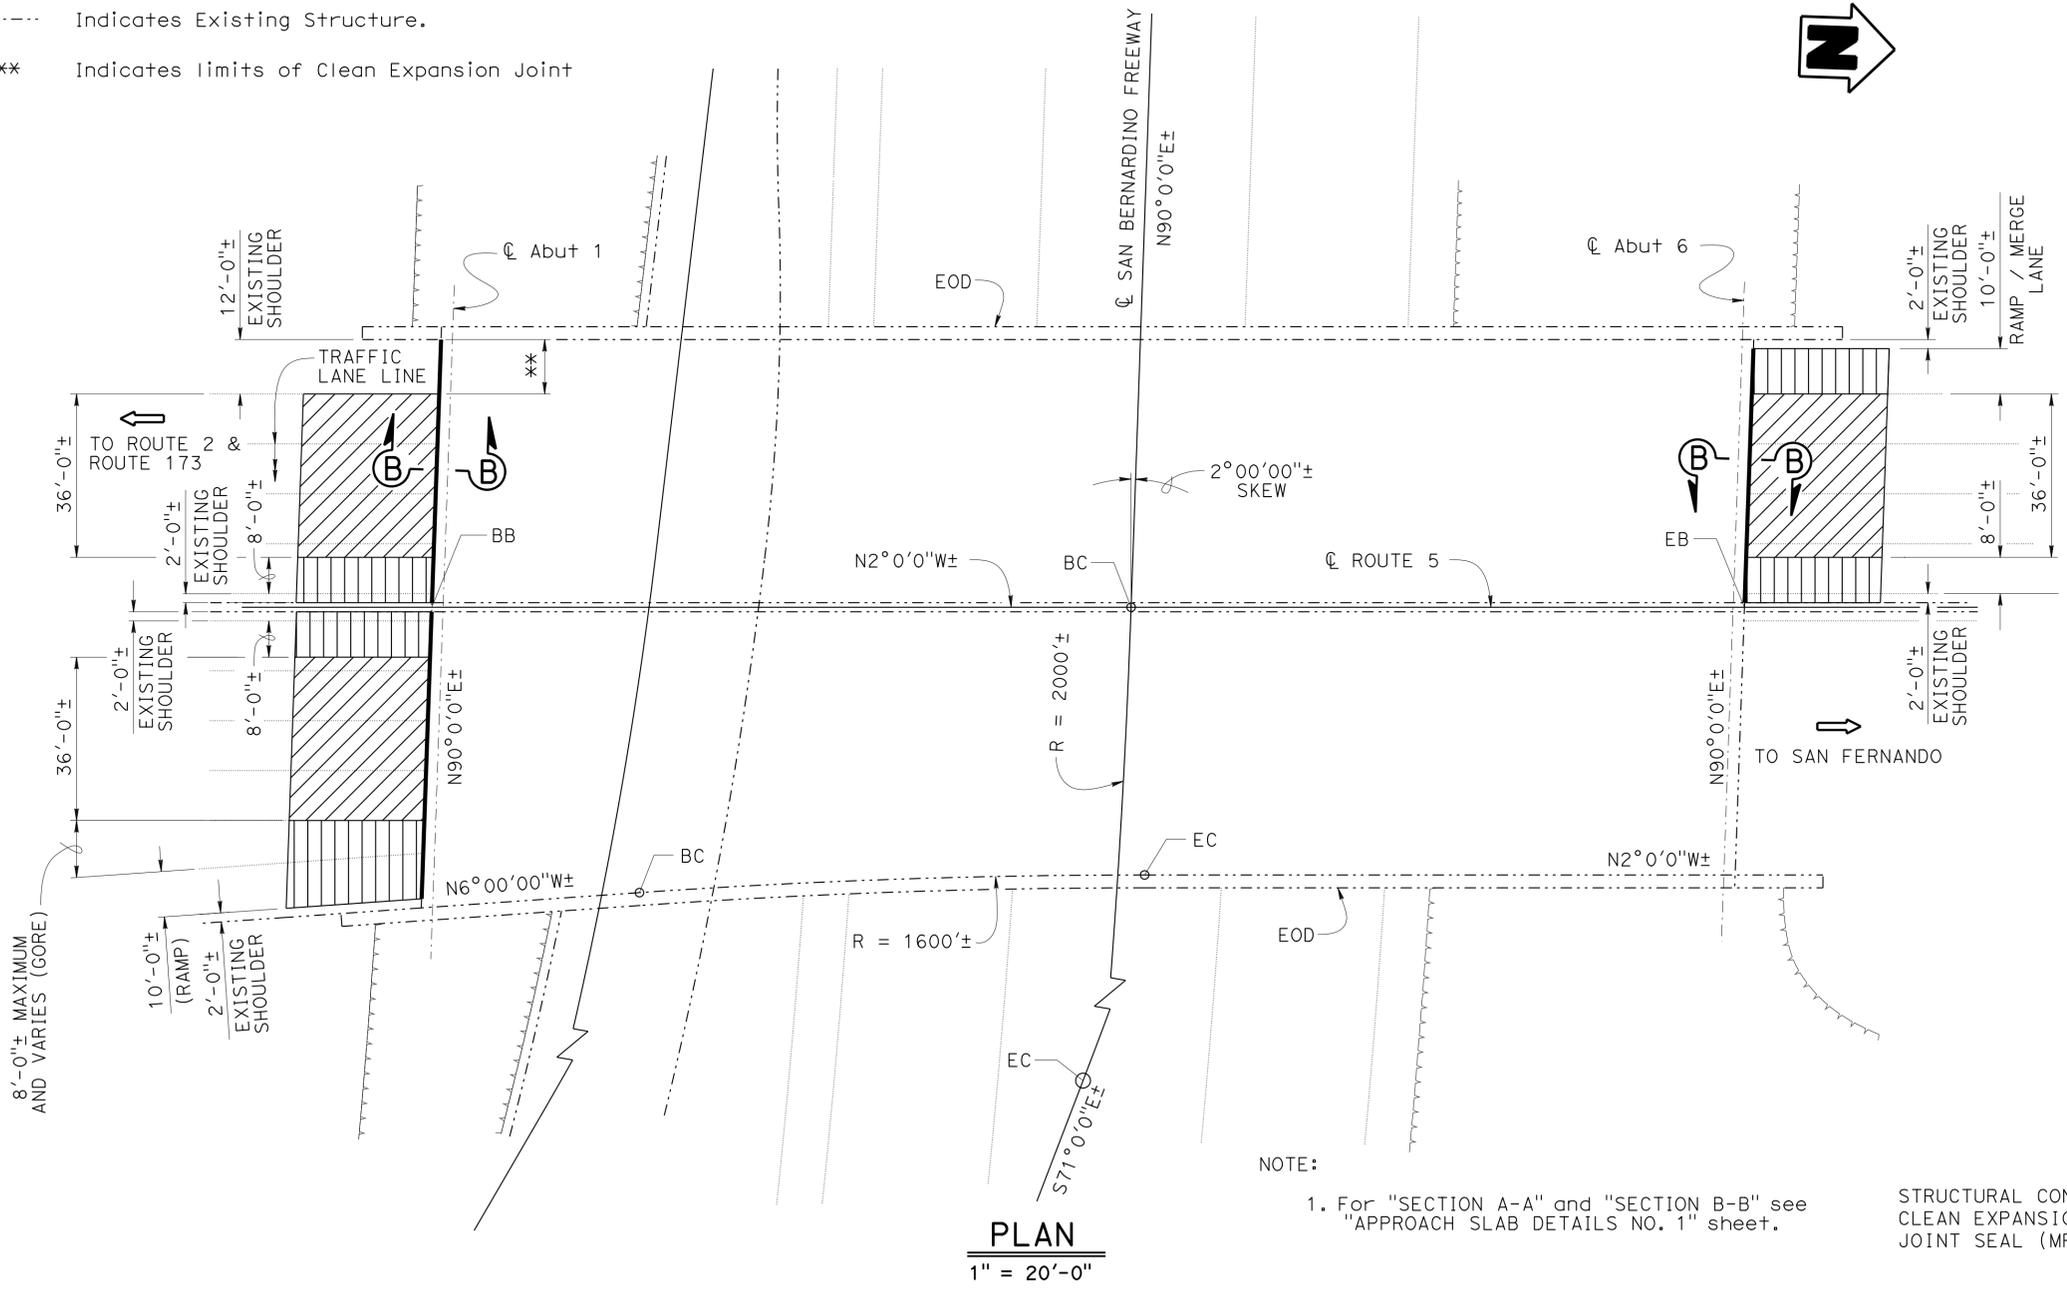

PLAN
1" = 20'-0"

ROUTE 5/10 SEPARATION
QUANTITIES

STRUCTURAL CONCRETE, APPROACH SLAB (TYPE R MODIFIED)	205	CY
CLEAN EXPANSION JOINT	12	LF
JOINT SEAL (MR 1")	178	LF

NOTE:
THE CONTRACTOR MUST VERIFY ALL CONTROLLING FIELD DIMENSIONS BEFORE ORDERING OR FABRICATING ANY MATERIAL.

**ROUTE 5/10 SEPARATION
BRIDGE No. 53-1329, PM 18.42**

**ROUTE 5 BRIDGE APPROACH AND DEPARTURE SLAB CONSTRUCTION AND PAVEMENT REHABILITATION
GENERAL PLAN NO. 3**

Jose Higareda DESIGN ENGINEER	DESIGN	BY Ulysses Smpardos	CHECKED Suzan Moradi	LOAD & RESISTANCE FACTOR DESIGN	LIVE LOADING: HL93 W/"LOW-BOY"; PERMIT DESIGN VEHICLE	STATE OF CALIFORNIA DEPARTMENT OF TRANSPORTATION	DIVISION OF ENGINEERING SERVICES STRUCTURE DESIGN DESIGN BRANCH 15	BRIDGE NO.	VARIES	
	DETAILS	BY Herman Mauroschat	CHECKED Suzan Moradi	LAYOUT	BY Ulysses Smpardos			CHECKED Suzan Moradi	POST MILE	VARIES
	QUANTITIES	BY Ulysses Smpardos	CHECKED S. Moradi/H. Mauroschat	SPECIFICATIONS	BY K. Doll			CHECKED K. Doll	PLANS AND SPECS COMPARED	

ORIGINAL SCALE IN INCHES FOR REDUCED PLANS

0 1 2 3

UNIT: 3604
PROJECT NUMBER & PHASE: 07 1300 0492 CONTRACT NO.: 07-30070


DISREGARD PRINTS BEARING EARLIER REVISION DATES	REVISION DATES	SHEET	OF
	3-1-14 12-1-14 2-2-15 3-11-15	3	8

DIST	COUNTY	ROUTE	POST MILES TOTAL PROJECT	SHEET No.	TOTAL SHEETS
07	LA	5	13.8/19.2	258	262

Ulysses N. Smpardos 3-13-15
 REGISTERED CIVIL ENGINEER DATE
 2-1-16
 PLANS APPROVAL DATE

Ulysses N. Smpardos
 No. 61018
 Exp. 12-31-16
 CIVIL
 STATE OF CALIFORNIA

The State of California or its officers or agents shall not be responsible for the accuracy or completeness of scanned copies of this plan sheet.

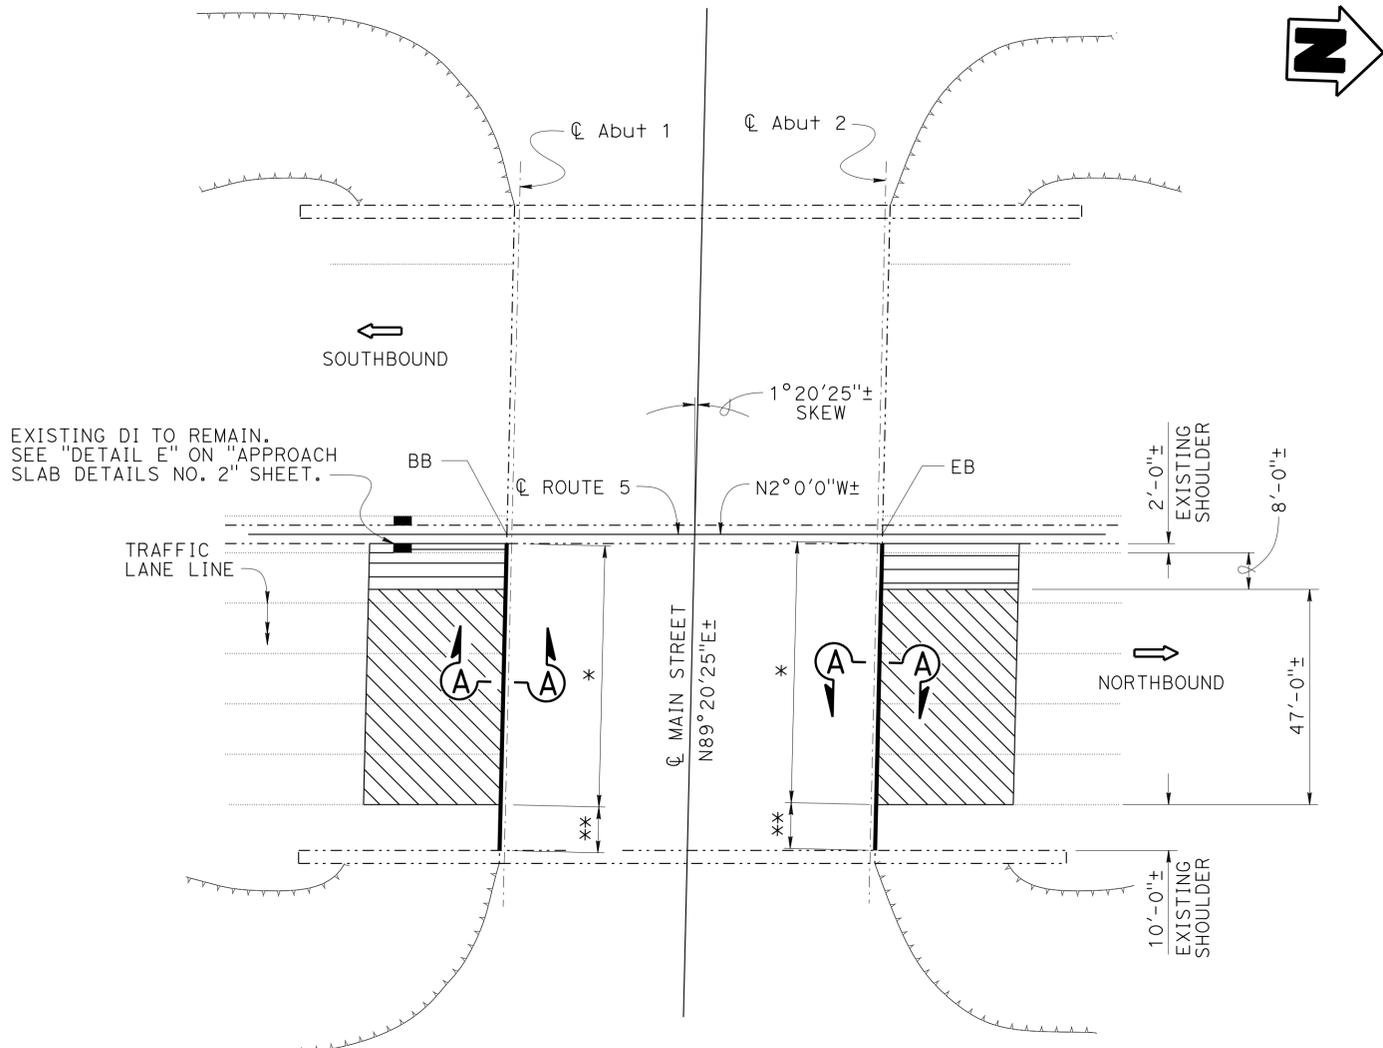

PLAN
 1" = 20'-0"
MAIN STREET UNDERCROSSING
BRIDGE No. 53-1360, PM 19.20

NOTE:
 1. For "SECTION A-A" see "APPROACH SLAB DETAILS NO. 1" sheet.

- LEGEND:
- * Indicates limits of Paving Notch Extension
 - ** Indicates limits of Clean Expansion Joint
 - Indicates Existing Structure.
 - Indicates limits of Structure Approach Type R(30D) and removal of existing roadway section: {9"± PCC (unreinforced) / 4"± CTB
 - Indicates limits of Structure Approach Type R(30D) and removal of existing roadway section: {5"± AC pavement / 7"± LCB
 - Indicates limits of Existing Joint Seal removal and placement of new Joint Seal. For details, see "APPROACH SLAB DETAILS NO. 1" sheet and

MAIN STREET UNDERCROSSING

QUANTITIES

STRUCTURAL CONCRETE, APPROACH SLAB (TYPE R)	136	CY
PAVING NOTCH EXTENSION	86	CF
CLEAN EXPANSION JOINT	20	LF
JOINT SEAL (MR 1/2")	134	LF

NOTE:
 THE CONTRACTOR MUST VERIFY ALL CONTROLLING FIELD DIMENSIONS BEFORE ORDERING OR FABRICATING ANY MATERIAL.

Jose Higuera DESIGN ENGINEER	DESIGN	BY Ulysses Smpardos	CHECKED Suzan Moradi	LOAD & RESISTANCE FACTOR DESIGN	LIVE LOADING: HL93 W/"LOW-BOY"; PERMIT DESIGN VEHICLE	STATE OF CALIFORNIA DEPARTMENT OF TRANSPORTATION	DIVISION OF ENGINEERING SERVICES STRUCTURE DESIGN	BRIDGE NO.
	DETAILS	BY Herman Mauroschadt	CHECKED Suzan Moradi	LAYOUT	BY Ulysses Smpardos		CHECKED Suzan Moradi	VARIES
	QUANTITIES	BY Ulysses Smpardos	CHECKED S. Moradi/H. Mauroschadt	SPECIFICATIONS	BY K. Doll		PLANS AND SPECS COMPARED K. Doll	POST MILE

ROUTE 5 BRIDGE APPROACH AND DEPARTURE SLAB CONSTRUCTION AND PAVEMENT REHABILITATION
GENERAL PLAN NO. 4

DIST	COUNTY	ROUTE	POST MILES TOTAL PROJECT	SHEET No.	TOTAL SHEETS
07	LA	5	13.8/19.2	259	262
Ulysses N. Smpardos REGISTERED CIVIL ENGINEER			3-13-15 DATE		
2-1-16 PLANS APPROVAL DATE					
<small>The State of California or its officers or agents shall not be responsible for the accuracy or completeness of scanned copies of this plan sheet.</small>					

JOINT SEAL TABLE


BRIDGE NAME	BRIDGE NO.	MINIMUM "MR" (in)	APPROXIMATE LENGTH (LF)	EXISTING WATERSTOP (Y/N)	APPROXIMATE DEPTH TO CLEAN EXPANSION JOINT (IN)	
SOTO STREET UC	53-1390R	Abut 1 PN	1	46	N	12
S5-E10 CONNECTOR UC	53-1316	Abut 1 PN	1/2	56	N	12
		Abut 2 PN	1/2	56	N	12
ROUTE 5/10 SEPARATION	53-1329	Abut 1	1	122	N	12
		Abut 6	1	56	N	N/A
MAIN STREET UC	53-1360	Abut 1 PN	1/2	67	N	12
		Abut 2 PN	1/2	67	N	12

REMOVE UNSOUND CONCRETE AND RAPID SETTING CONCRETE (PATCH)

BRIDGE NAME	BRIDGE NO.	LOCATION	APPROXIMATE DIMENSIONS (in)	APPROXIMATE AREA (ft ²)	APPROXIMATE DEPTH (in)
FOURTH STREET UC	53-1304	①	6 X 6	0.3	2
		②	8 X 4	0.2	2
S5-E10 CONNECTOR UC	53-1316	③	72 X 12	6.0	2

NOTE:
 For "JOINT SPALL REPAIR DETAIL" and "APPROACH SLAB REPAIR DETAIL" see "APPROACH SLAB DETAILS NO. 2" sheet.



LEGEND:
 - - - - - Indicates Existing Structure
 X X X X X Indicates Limits of Backwall Removal

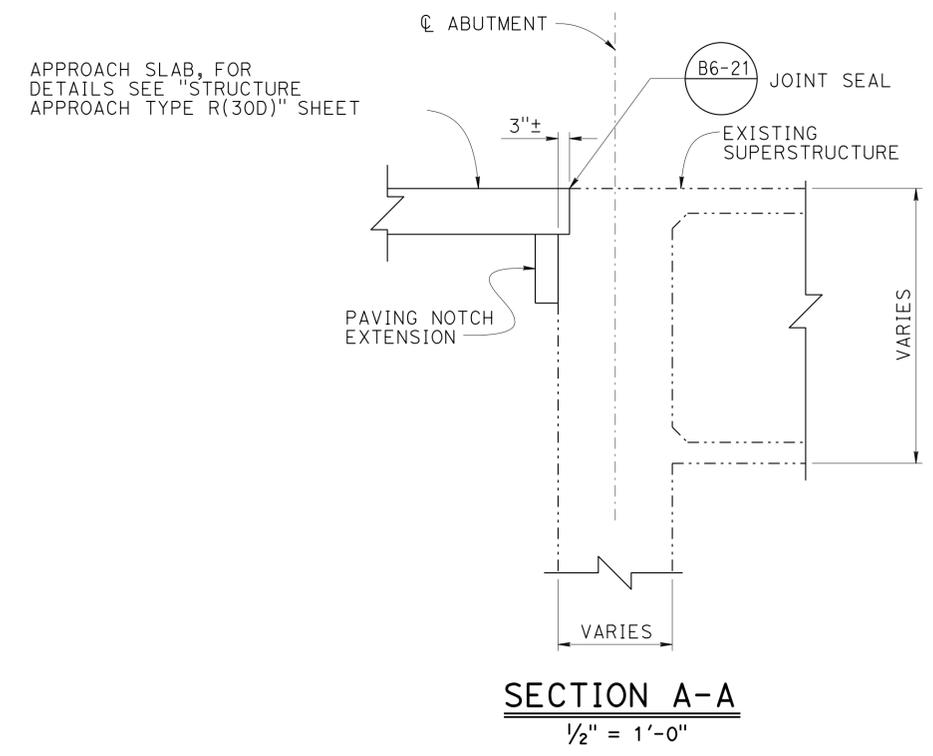

SECTION A-A
 1/2" = 1'-0"


JOINT SEAL NOTES

- JOINT SEAL TYPE A:
1. Install Type A joint seal 3" up into curb or rail on the low side of the deck where joint matches curb or rail joint. For details see, (B6-21)
- JOINT SEAL TYPE B:
1. Seal must satisfy both minimum Movement Rating (MR) and minimum W1 requirements.
 2. Minimum W1 is the calculated maximum width of the joint based on field measurements. After the joints have been cleaned, minimum W1 is to be recalculated by the Engineer.
 3. W1 shall be the smaller of the values determined as follows:
 - A) 0.85 times the manufacturer's designed minimum uncompressed width of the seal.
 - B) The width of the seal on the third successive test cycle of the pressure deflection test, when compressed to an average pressure of 3 psi.
 4. Bend Type B joint seal 6" up into curb or rail on the low side of the deck where deck joint matches curb or rail joint.
 5. For details, see (B6-21)

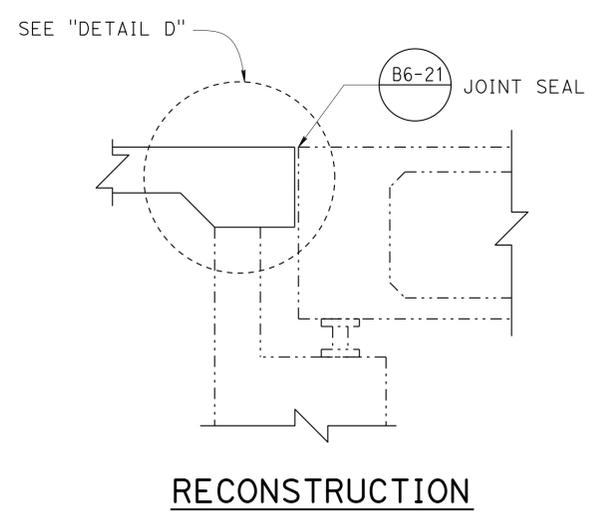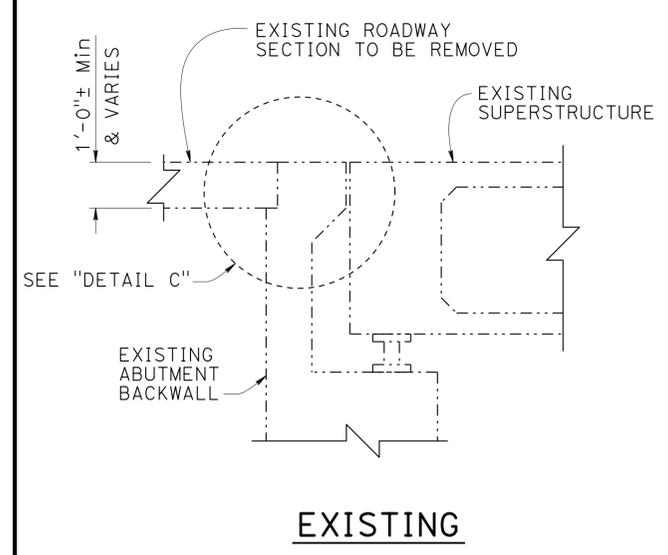


SECTION B-B
 1/2" = 1'-0"

NOTE:
 THE CONTRACTOR MUST VERIFY ALL CONTROLLING FIELD DIMENSIONS BEFORE ORDERING OR FABRICATING ANY MATERIAL.

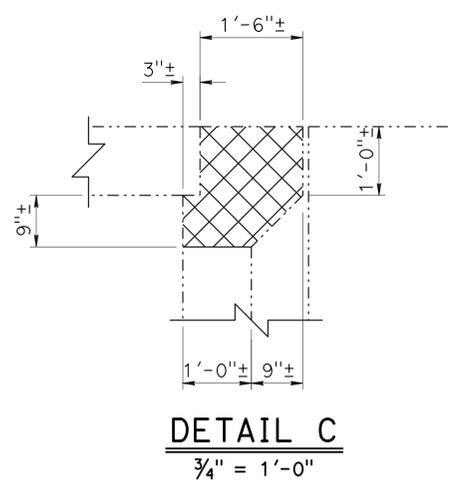

DETAIL C
 3/4" = 1'-0"

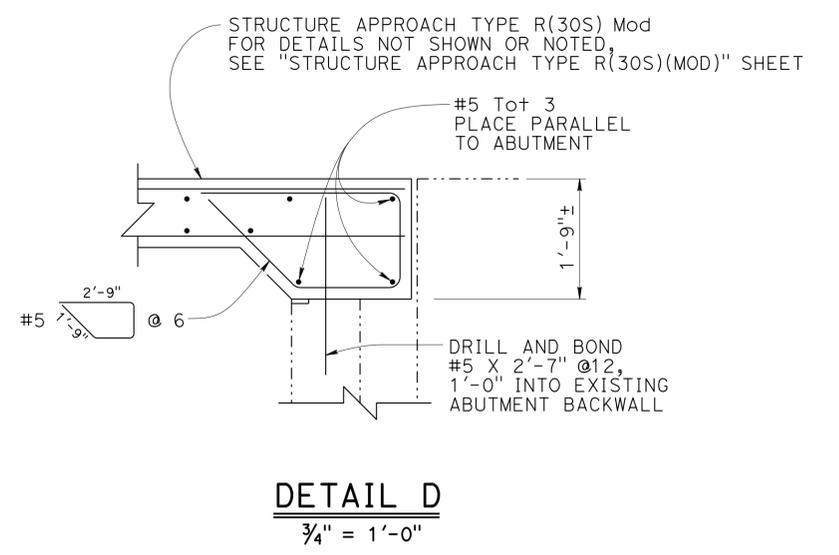

DETAIL D
 3/4" = 1'-0"

ROUTE 5 BRIDGE APPROACH AND DEPARTURE SLAB CONSTRUCTION AND PAVEMENT REHABILITATION APPROACH SLAB DETAILS NO. 1


DESIGN	BY Ulysses Smpardos	CHECKED Suzan Moradi
DETAILS	BY Herman Mauroschat	CHECKED Suzan Moradi
QUANTITIES	BY Ulysses Smpardos	CHECKED S. Moradi/H. Mauroschat

STATE OF CALIFORNIA
 DEPARTMENT OF TRANSPORTATION

DIVISION OF ENGINEERING SERVICES
 STRUCTURE DESIGN
DESIGN BRANCH 15


BRIDGE NO.	VARIES
POST MILE	VARIES
BRIDGE NO.	VARIES

DIST	COUNTY	ROUTE	POST MILES TOTAL PROJECT	SHEET No.	TOTAL SHEETS
07	LA	5	13.8/19.2	260	262
Ulysses N. Smpardos REGISTERED CIVIL ENGINEER			3-13-15 DATE		
2-1-16 PLANS APPROVAL DATE			The State of California or its officers or agents shall not be responsible for the accuracy or completeness of scanned copies of this plan sheet.		

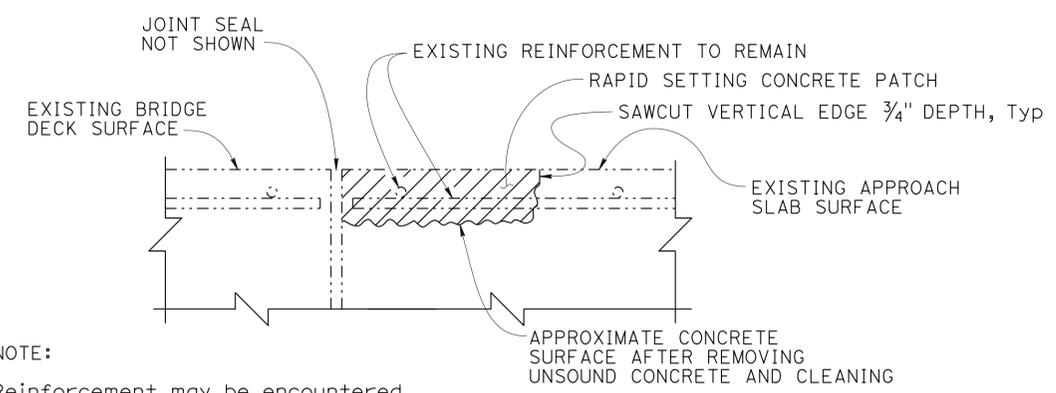


NOTE:
Reinforcement may be encountered during concrete removal and must remain undamaged.

JOINT SPALL REPAIR DETAIL
NO SCALE

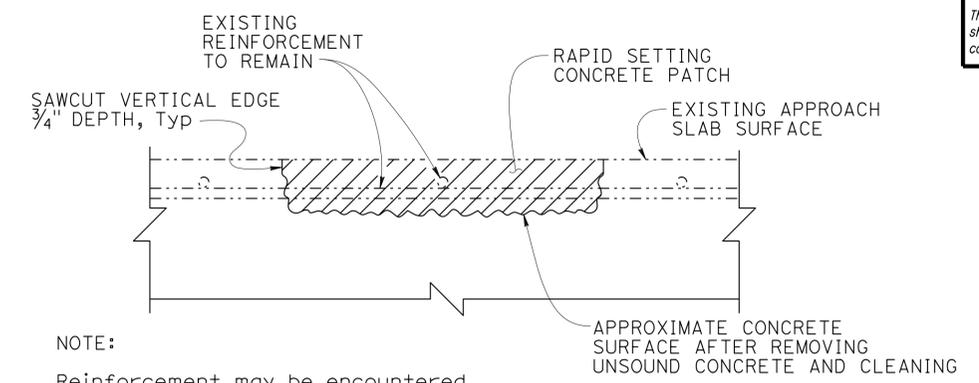

NOTE:
Reinforcement may be encountered during concrete removal and must remain undamaged.


APPROACH SLAB REPAIR DETAIL
NO SCALE

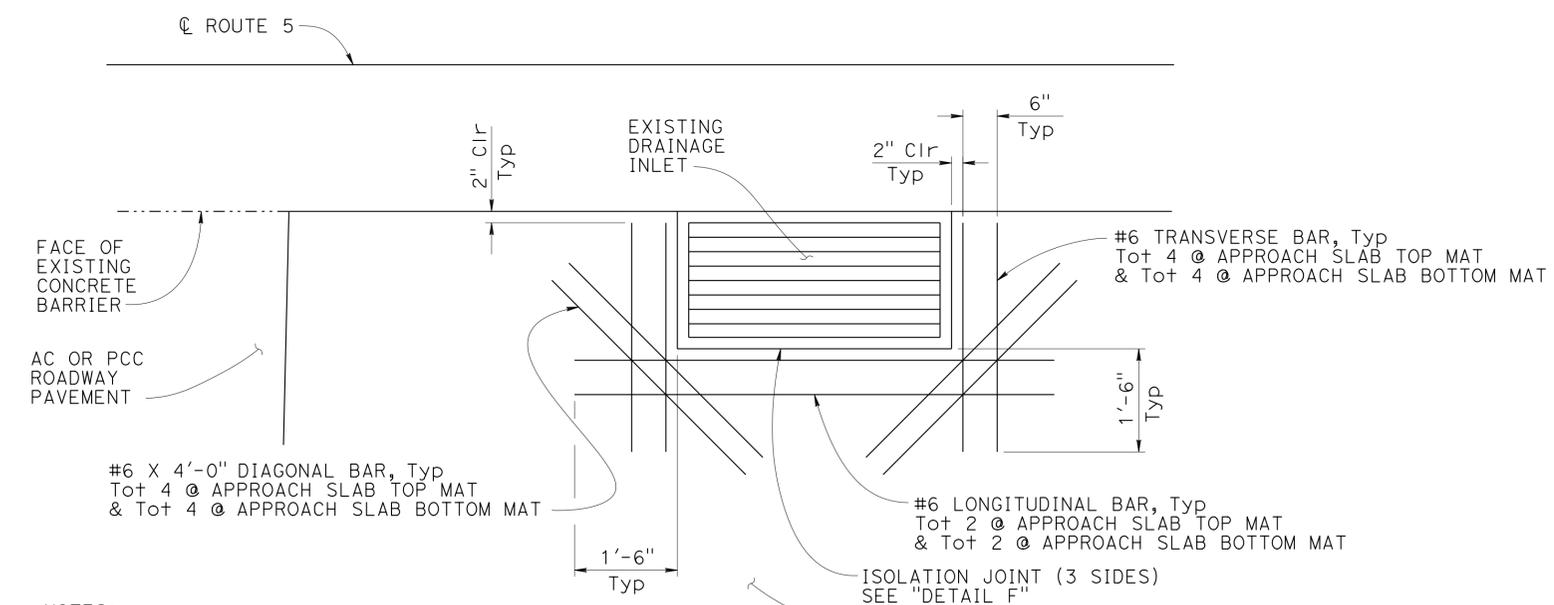

- NOTES:
1. Reinforcement shown is in addition to typical Approach Slab reinforcement. Typical Approach Slab reinforcement is not shown for clarity.
 2. Terminate typical Approach Slab reinforcement 2" clear from all outside edges of Isolation Joint.

DETAIL E
NO SCALE

NOTE:
THE CONTRACTOR MUST VERIFY ALL CONTROLLING FIELD DIMENSIONS BEFORE ORDERING OR FABRICATING ANY MATERIAL.

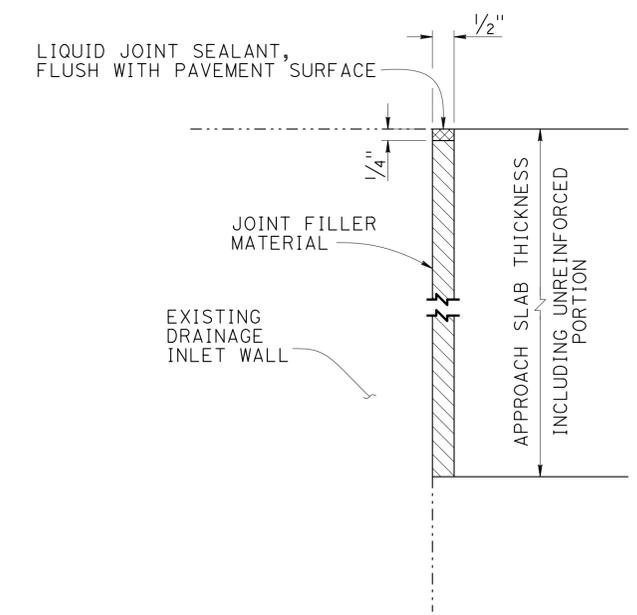

DETAIL F
NO SCALE

ISOLATION JOINT AROUND EXISTING DRAINAGE INLET

DESIGN BY Ulysses Smpardos CHECKED Suzan Moradi DETAILS BY Herman Mauroschadt CHECKED Suzan Moradi QUANTITIES BY Ulysses Smpardos CHECKED S. Moradi/H. Mauroschadt		STATE OF CALIFORNIA DEPARTMENT OF TRANSPORTATION	DIVISION OF ENGINEERING SERVICES STRUCTURE DESIGN DESIGN BRANCH 15	BRIDGE NO. VARIES POST MILE VARIES	ROUTE 5 BRIDGE APPROACH AND DEPARTURE SLAB CONSTRUCTION AND PAVEMENT REHABILITATION APPROACH SLAB DETAILS NO. 2
STRUCTURES DESIGN DETAIL SHEET (ENGLISH) (REV. 09-01-10)		ORIGINAL SCALE IN INCHES FOR REDUCED PLANS	UNIT: 3604 PROJECT NUMBER & PHASE: 07 1300 0492	CONTRACT NO.: 07-30070	DISREGARD PRINTS BEARING EARLIER REVISION DATES
			REVISION DATES	SHEET 6 OF 8	FILE => 07-300701-e-apps\bdet+02.dgn



DIST	COUNTY	ROUTE	POST MILES TOTAL PROJECT	SHEET No.	TOTAL SHEETS
07	LA	5	13.8/19.2	261	262

Ulysses N. Smpardos 3-13-15
REGISTERED CIVIL ENGINEER DATE










2-1-16
PLANS APPROVAL DATE

The State of California or its officers or agents shall not be responsible for the accuracy or completeness of electronic copies of this plan sheet.

Ulysses N. Smpardos
No. 61018
Exp. 12-31-16
CIVIL
STATE OF CALIFORNIA

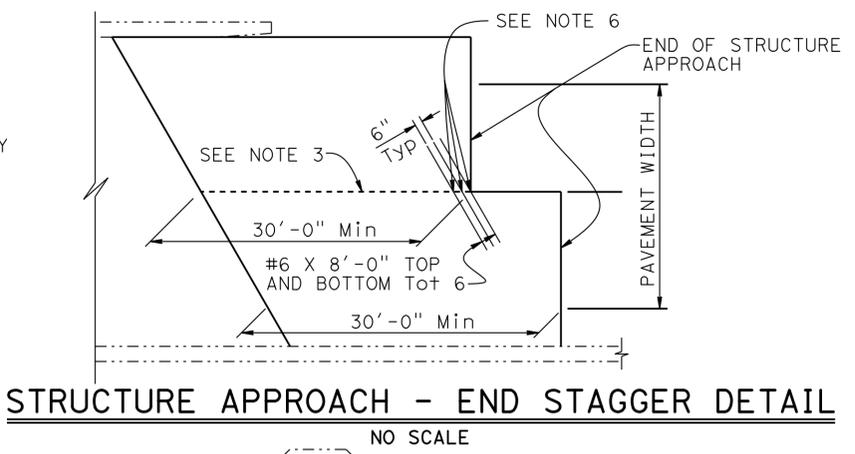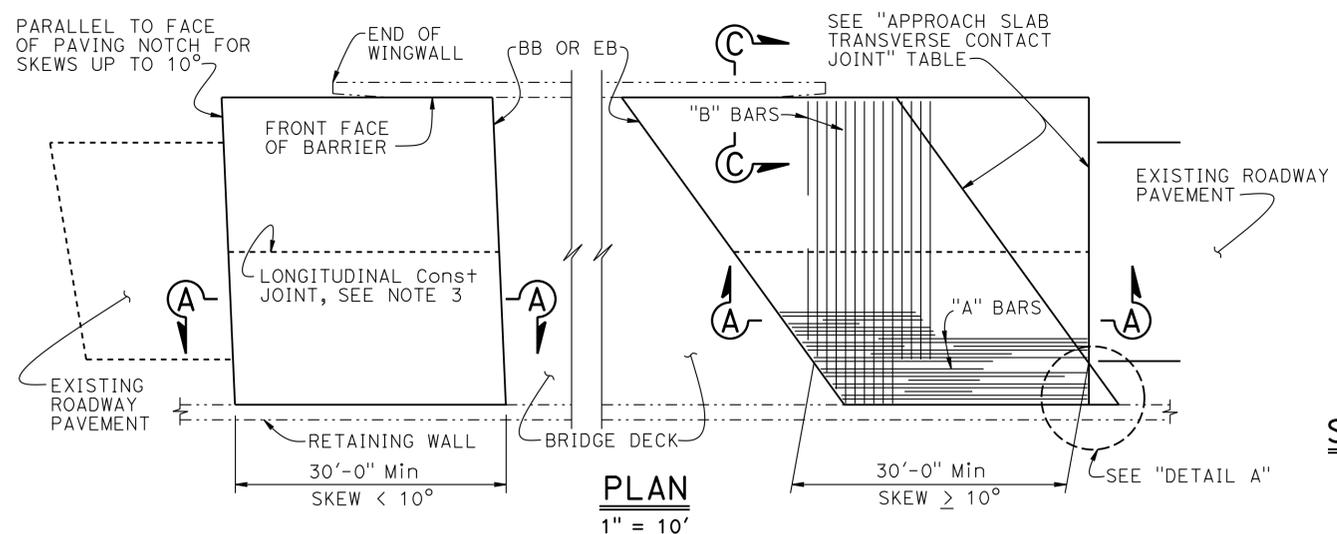

APPROACH SLAB TRANSVERSE CONTACT JOINT		
APPROACH SKEW	WITH AC ROADWAY PAVEMENT	WITH PCC ROADWAY PAVEMENT
< 10°	PARALLEL TO FACE OF PN	PARALLEL TO FACE OF PAVING NOTCH
10° - 45°	PARALLEL TO FACE OF PN USE "DETAIL A"	STAGGER LINES 24' TO 36' APART
> 45°	PARALLEL TO FACE OF PN USE "DETAIL A"	STAGGER AT EACH LANE LINE

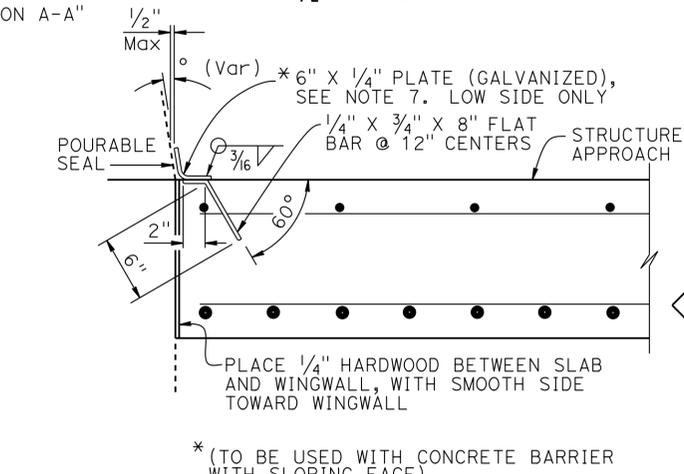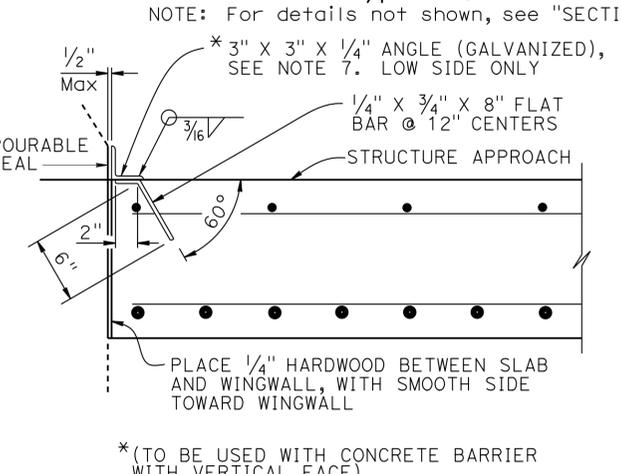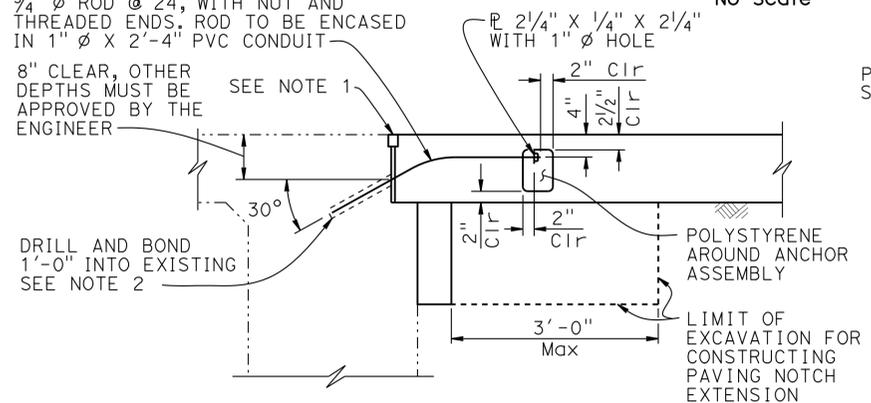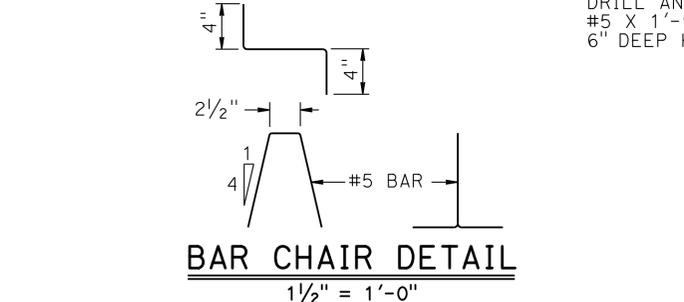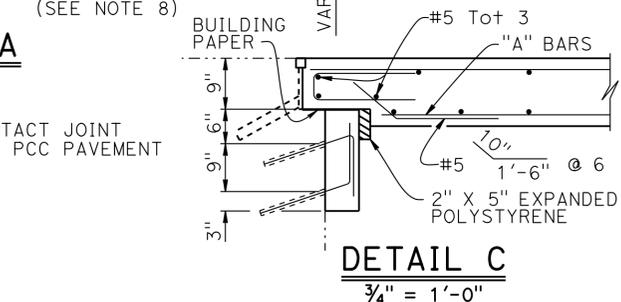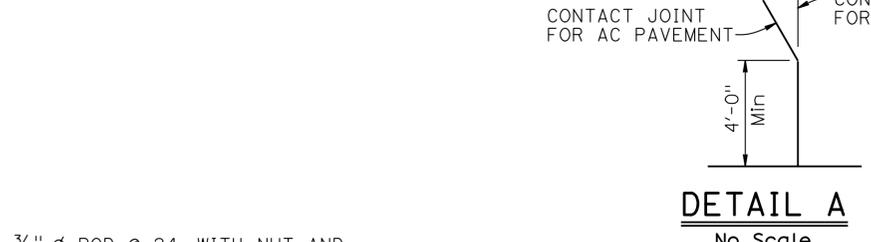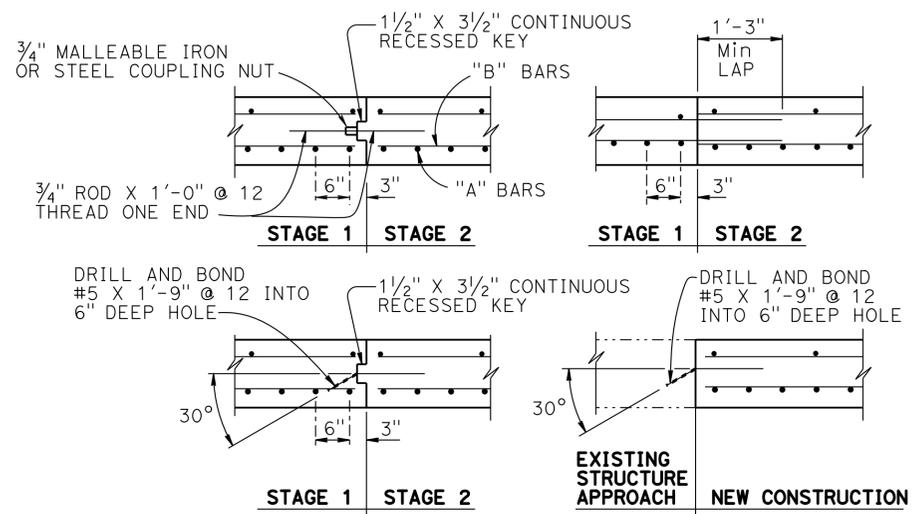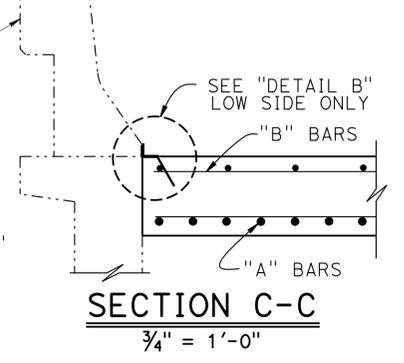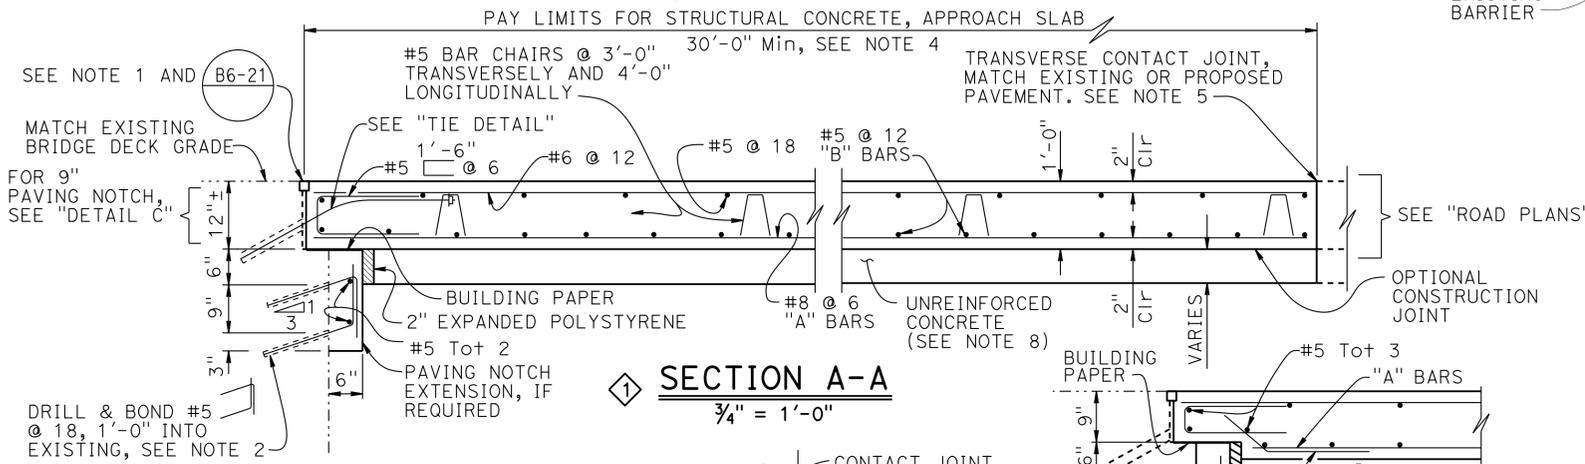

- NOTES:
- For details not shown or noted, see Structure Plans. Adjust bar reinforcement to clear a sawcut for sealed joint, when required
 - Space to avoid existing prestress anchorages and main reinforcement
 - Longitudinal construction joints, when permitted by the Engineer, shall be located on lane lines
 - Transverse contact joint shall be a minimum of 5'-0" from an existing or constructed weakened plane joint
 - For transverse contact joint with new PCC paving, refer to Revised Standard Plan RSP P10
 - Couplers are required for stage construction
 - End angle or plate at beginning of barrier transition, end of wingwall or end of structure approach as applicable
 - Thickness of unreinforced concrete varies according to thickness of existing roadway section removal shown on "GENERAL PLAN" sheets.


NOTE: THE CONTRACTOR MUST VERIFY ALL CONTROLLING FIELD DIMENSIONS BEFORE ORDERING OR FABRICATING ANY MATERIAL.

REVISED STANDARD DRAWING	1 MODIFIED DETAIL
FILE NO. xs3-150	2 MODIFIED NOTE
APPROVAL DATE July 2011	


STATE OF CALIFORNIA	DIVISION OF ENGINEERING SERVICES
DEPARTMENT OF TRANSPORTATION	

BRIDGE NO. VARIES	UNIT: 3604
POST MILE VARIES	PROJECT NUMBER & PHASE: 0713000492
	CONTRACT NO.: 07-30070


ROUTE 5 BRIDGE APPROACH AND DEPARTURE SLAB CONSTRUCTION AND PAVEMENT REHABILITATION	
STRUCTURE APPROACH TYPE R(30D)	

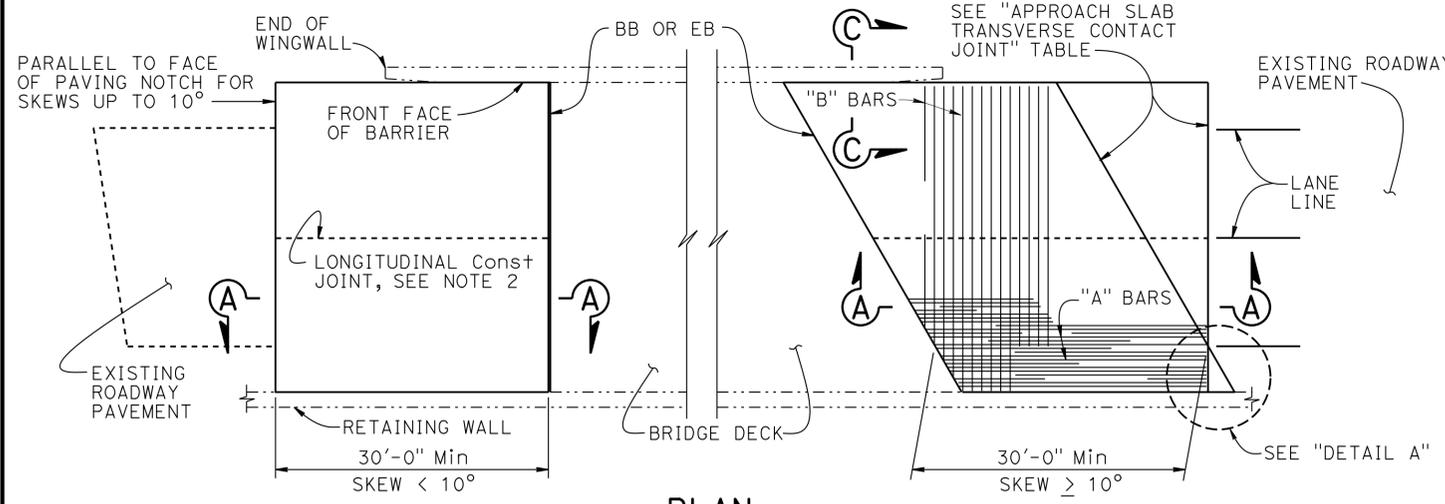


PLAN
1" = 10'

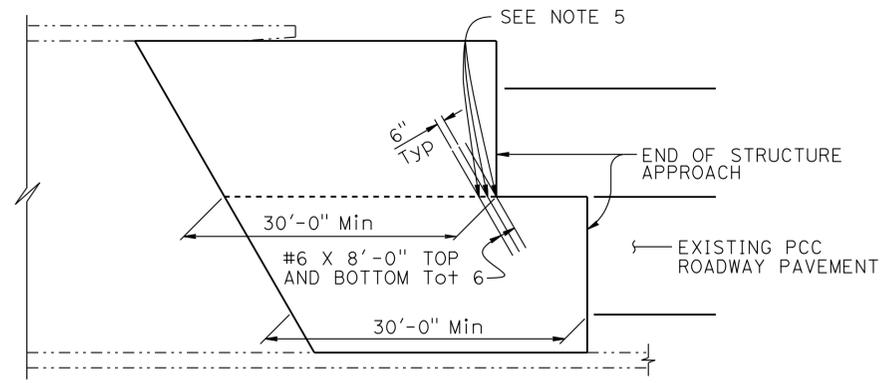

STRUCTURE APPROACH - END STAGGER DETAIL
NO SCALE


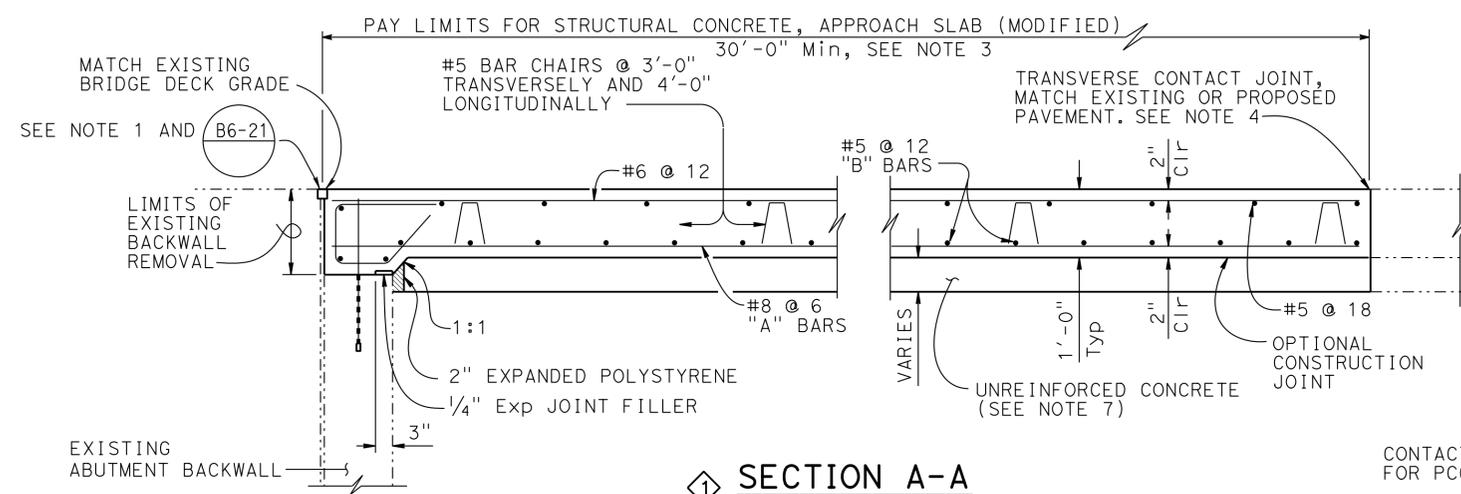


SECTION A-A
3/4" = 1'-0"

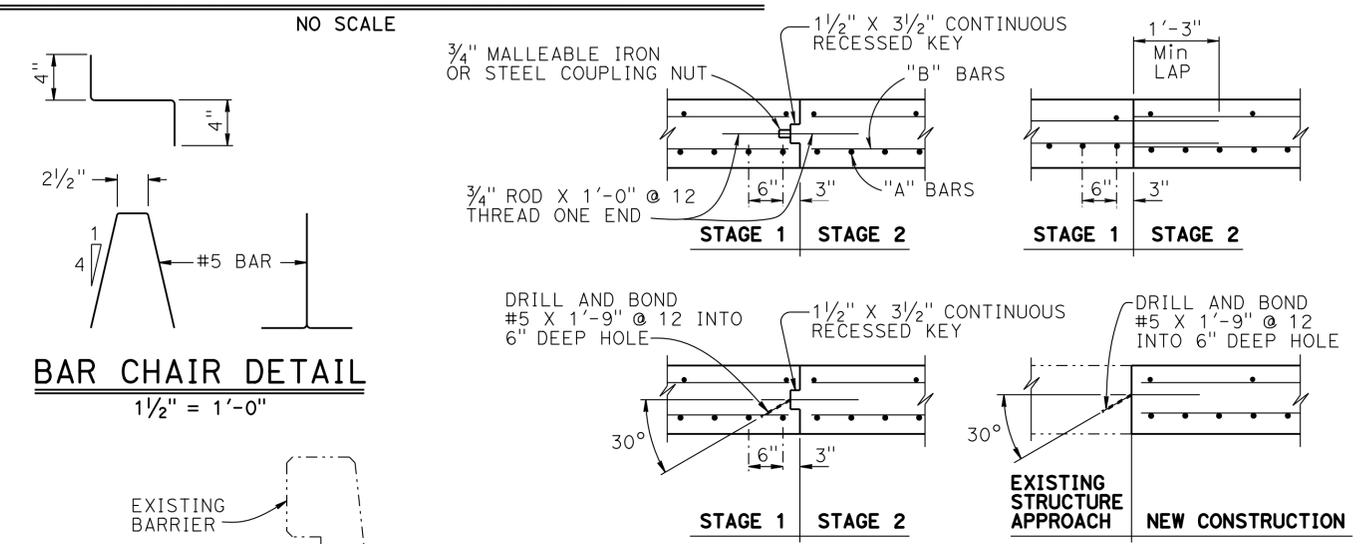


BAR CHAIR DETAIL
1/2" = 1'-0"

LONGITUDINAL CONSTRUCTION JOINT ALTERNATIVES
3/4" = 1'-0"

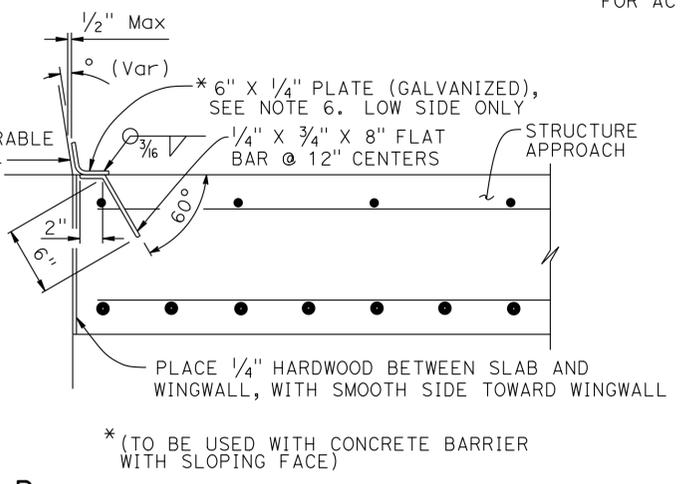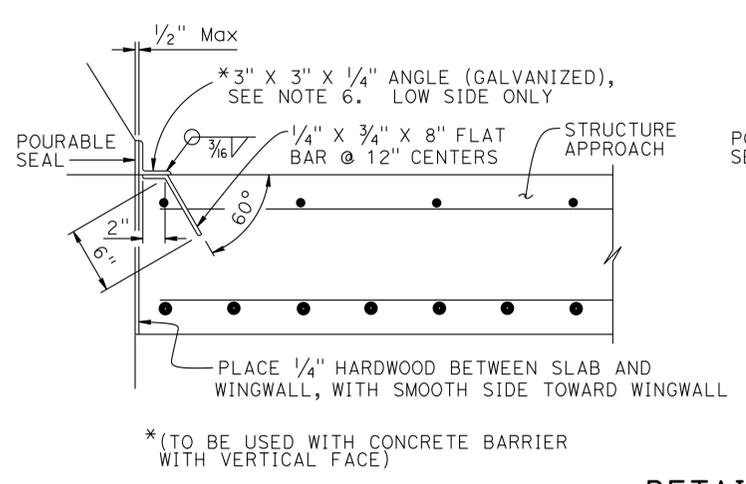

DETAIL B
1/2" = 1'-0"

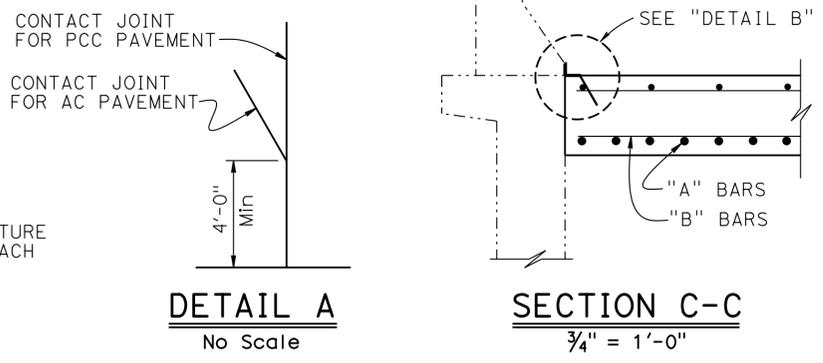

APPROACH SLAB TRANSVERSE CONTACT JOINT		
APPROACH SKEW	WITH AC ROADWAY PAVEMENT	WITH PCC ROADWAY PAVEMENT
< 10°	PARALLEL TO FACE OF PN	PARALLEL TO FACE OF PN
10° - 45°	PARALLEL TO FACE OF PN USE "DETAIL A"	STAGGER LINES 24' TO 36' APART
> 45°	PARALLEL TO FACE OF PN USE "DETAIL A"	STAGGER AT EACH LANE LINE

- NOTES:
- Sealed joint, for MR see Structure Plans. Adjust bar reinforcement to clear a sawcut for sealed joint, when required
 - Longitudinal construction joints, when permitted by Engineer, shall be located on lane lines
 - Transverse contact joint shall be a minimum of 5'-0" from an existing or constructed weakened plane joint
 - For transverse contact joint with new PCC paving, refer to Revised Standard Plan RSP P10
 - Couplers are required for stage construction
 - End angle or plate at beginning of barrier transition, end of wingwall or end of structure approach as applicable
 - Thickness of unreinforced concrete varies according to thickness of existing roadway section removal shown on "GENERAL PLAN" sheets.

SPECIAL DETAILS

ROUTE 5 BRIDGE APPROACH AND DEPARTURE SLAB CONSTRUCTION AND PAVEMENT REHABILITATION
STRUCTURE APPROACH TYPE R(30S)(MOD)

NOTE:
THE CONTRACTOR MUST VERIFY ALL CONTROLLING FIELD DIMENSIONS BEFORE ORDERING OR FABRICATING ANY MATERIAL.

REVISED STANDARD DRAWING
FILE NO. **xs3-130**
APPROVAL DATE July 2011

1 MODIFIED DETAIL
2 MODIFIED NOTE

STATE OF CALIFORNIA
DEPARTMENT OF TRANSPORTATION

DIVISION OF ENGINEERING SERVICES

BRIDGE NO. VARIES
POST MILE VARIES