

INDEX OF PLANS

SHEET No.	DESCRIPTION
1	TITLE AND LOCATION MAP
2	TYPICAL CROSS SECTIONS
3-4	KEY MAP AND LINE INDEX
5	PROJECT CONTROL
6-23	LAYOUTS
24-28	CONSTRUCTION DETAILS
29-46	TEMPORARY WATER POLLUTION CONTROL PLANS AND QUANTITIES
47-66	UTILITY PLANS
67	CONSTRUCTION AREA SIGNS
68-76	TRAFFIC HANDLING PLANS AND QUANTITIES
77-80	PAVEMENT DELINEATION PLANS, DETAILS AND QUANTITIES
81-93	SIGN DETAILS, SPECIAL DESIGN SIGNS AND QUANTITIES
94-95	SUMMARY OF QUANTITIES
96-101	LANDSCAPE PLANS
102-172	ELECTRICAL PLANS AND SPECIAL ELECTRICAL STRUCTURE
173-213	REVISED STANDARD PLANS


STATE OF CALIFORNIA **ACNHPI-008-1(321)E**
DEPARTMENT OF TRANSPORTATION

PROJECT PLANS FOR CONSTRUCTION ON STATE HIGHWAY
IN SAN DIEGO COUNTY
IN SAN DIEGO, LA MESA, AND NEAR EL CAJON
FROM 0.2 MILE WEST OF ROUTE 15/8 SEPARATION
TO FLETCHER PARKWAY OVERCROSSING
AND FROM LOS COCHES ROAD UNDERCROSSING
0.2 MILE WEST OF LAKE JENNINGS PARK ROAD UNDERCROSSING




THE STANDARD PLANS LIST APPLICABLE TO THIS CONTRACT IS INCLUDED IN THE NOTICE TO BIDDERS AND SPECIAL PROVISIONS BOOK.

TO BE SUPPLEMENTED BY STANDARD PLANS DATED 2010

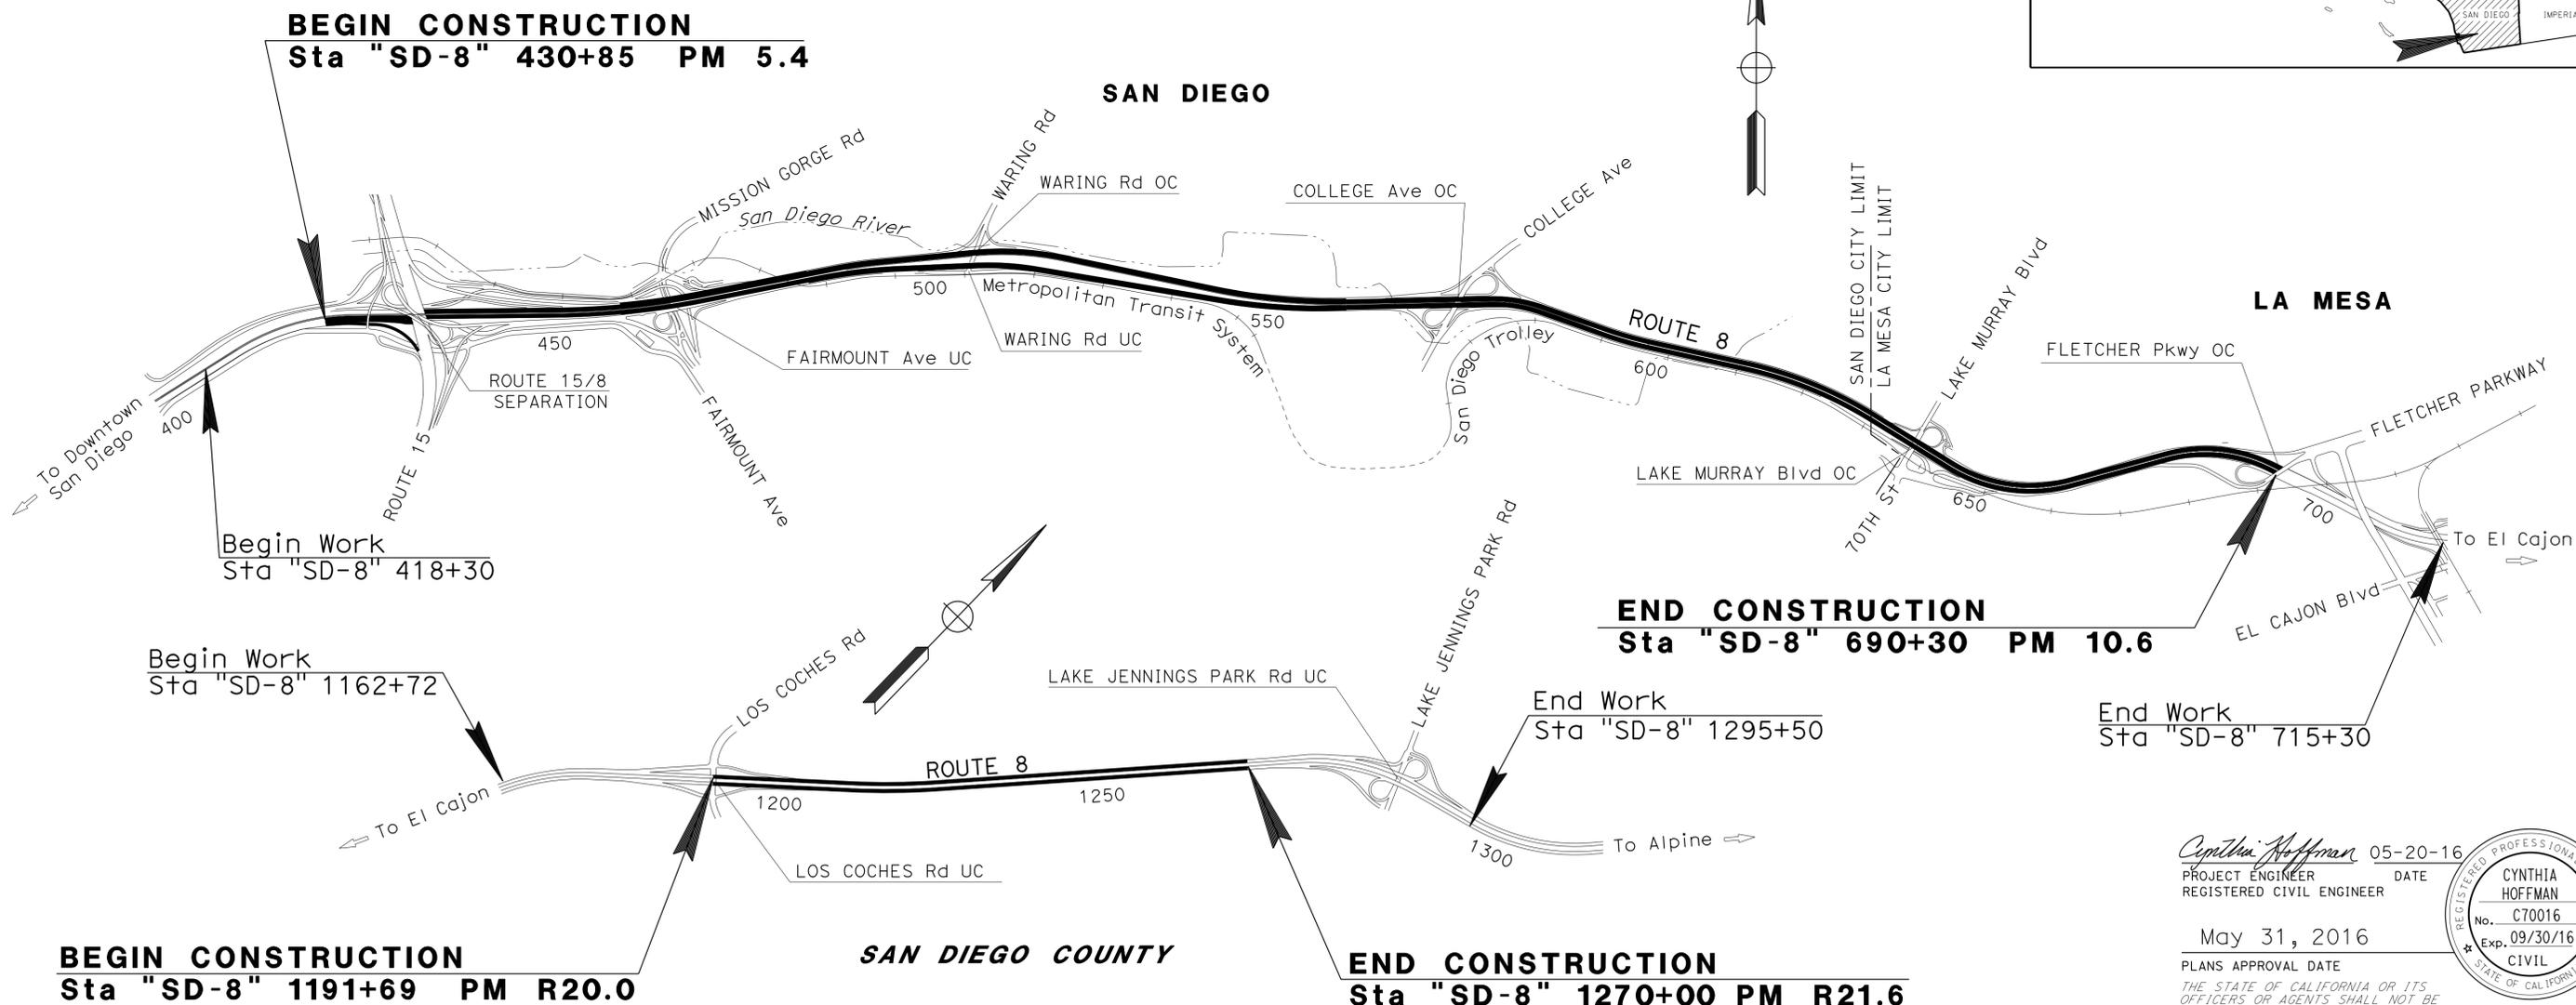

PROJECT MANAGER
 SHAHIN SEPASSI
 DESIGN MANAGER
 DUY TON

Cynthia Hoffman 05-20-16
 PROJECT ENGINEER DATE
 REGISTERED CIVIL ENGINEER

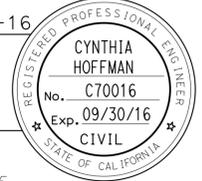

May 31, 2016
 PLANS APPROVAL DATE
 THE STATE OF CALIFORNIA OR ITS OFFICERS OR AGENTS SHALL NOT BE RESPONSIBLE FOR THE ACCURACY OR COMPLETENESS OF SCANNED COPIES OF THIS PLAN SHEET.

CONTRACT No.	11-237964
PROJECT ID	1114000046

1 REPLACED PER ADDENDUM No. 1 DATED AUGUST 2, 2016

NO SCALE

DATE PLOTTED => 01-AUG-2016 TIME PLOTTED => 14:42 07-25-16