

INDEX OF PLANS

SHEET No.	DESCRIPTION
1	TITLE AND LOCATION MAP
2	TYPICAL CROSS SECTIONS
3-18	LAYOUTS
19-29	CONSTRUCTION DETAILS
30	DRAINAGE PLAN
31-46	UTILITY PLANS
47	CONSTRUCTION AREA SIGNS
48-64	PAVEMENT DELINEATION PLANS AND QUANTITIES
65-87	SIGN PLANS, DETAILS, AND QUANTITIES
88	SUMMARY OF QUANTITIES
89-93	ELECTRICAL PLANS AND QUANTITIES
94-130	REVISED STANDARD PLANS

THE STANDARD PLANS LIST APPLICABLE TO THIS CONTRACT IS INCLUDED IN THE NOTICE TO BIDDERS AND SPECIAL PROVISIONS BOOK


STATE OF CALIFORNIA
DEPARTMENT OF TRANSPORTATION
PROJECT PLANS FOR CONSTRUCTION ON STATE HIGHWAY

ACSTP-P001(583)E



**IN ORANGE COUNTY
 IN HUNTINGTON BEACH
 FROM GOLDENWEST STREET TO WARNER AVENUE**

TO BE SUPPLEMENTED BY STANDARD PLANS DATED 2010

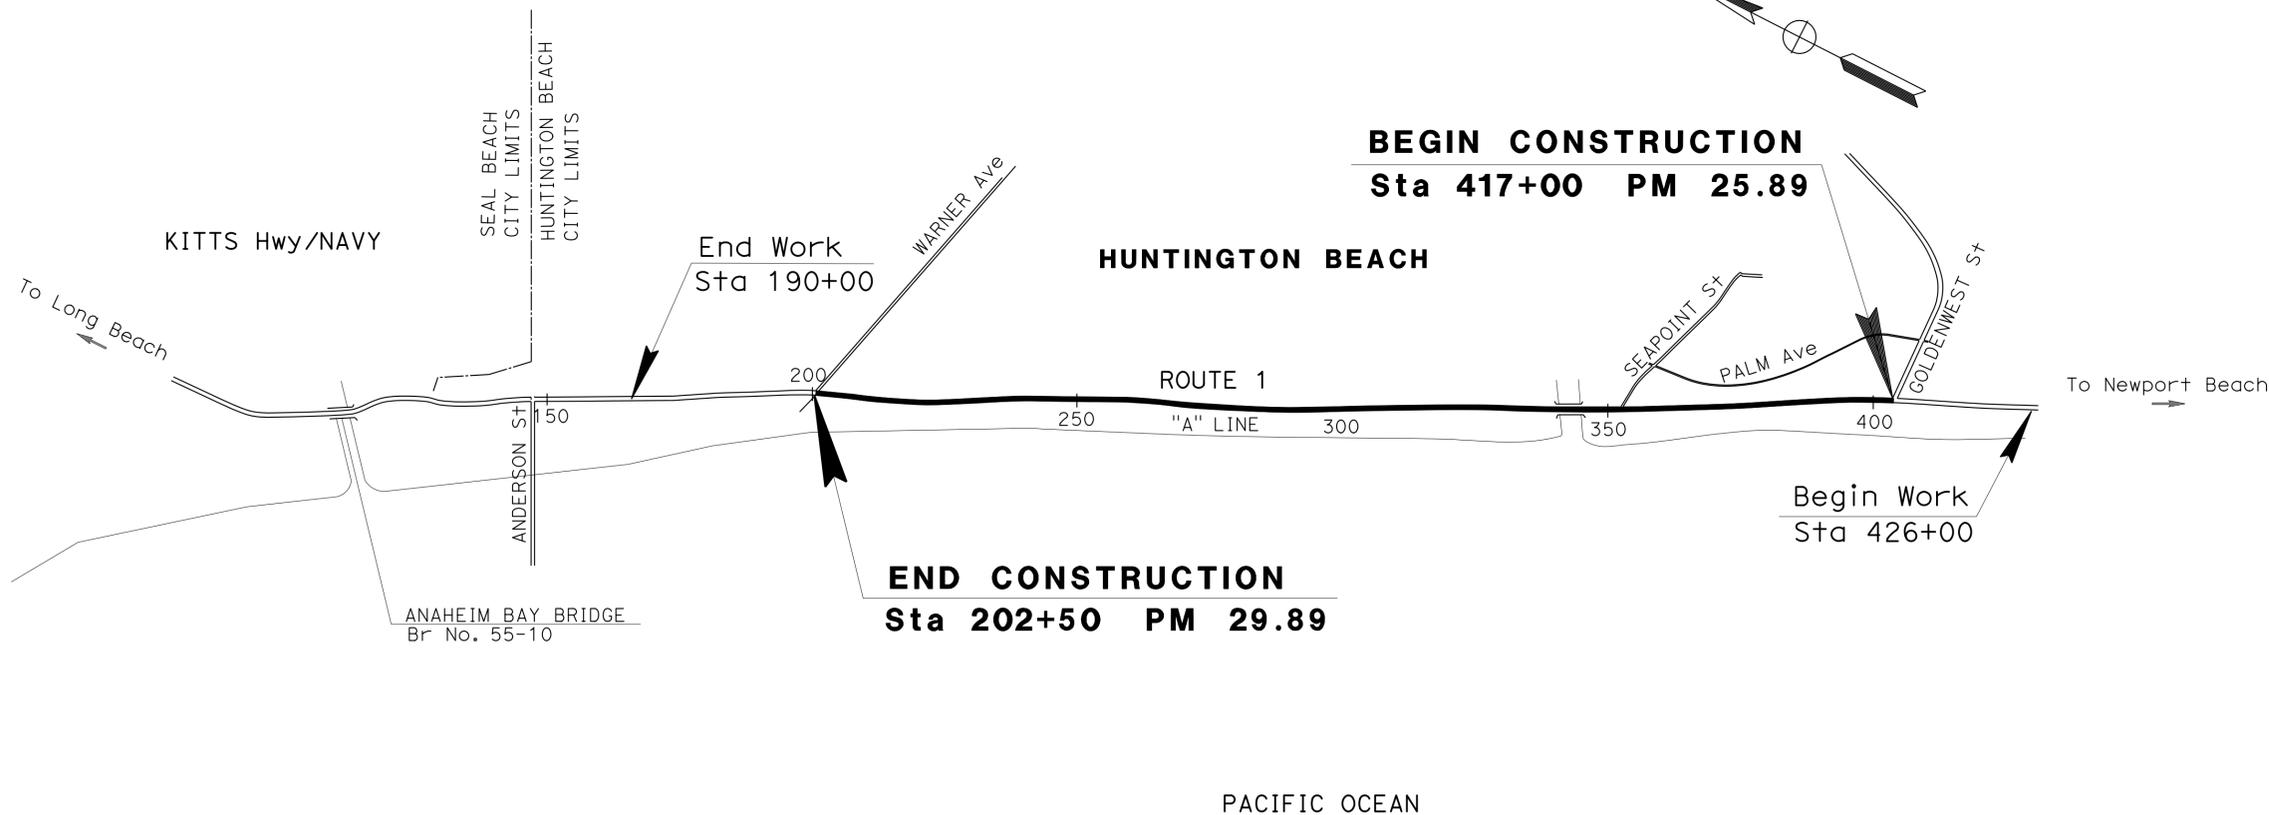


PROJECT MANAGER
NOOSHIN YOUSEFI

DESIGN ENGINEER
LY PHAN

Ly Phan 02/21/14
 PROJECT ENGINEER DATE
 REGISTERED CIVIL ENGINEER

03/24/14
 PLANS APPROVAL DATE

THE STATE OF CALIFORNIA OR ITS OFFICERS OR AGENTS SHALL NOT BE RESPONSIBLE FOR THE ACCURACY OR COMPLETENESS OF SCANNED COPIES OF THIS PLAN SHEET.

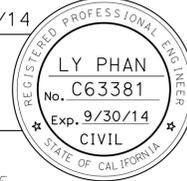

1 REPLACED PER ADDENDUM No. 1 DATED JULY 29, 2014

THE CONTRACTOR SHALL POSSESS THE CLASS (OR CLASSES) OF LICENSE AS SPECIFIED IN THE "NOTICE TO BIDDERS."

NO SCALE

CONTRACT No.	12-OH1604
PROJECT ID	1212000032

DATE PLOTTED => 24-JUL-2014 TIME PLOTTED => 10:06