

STATE OF CALIFORNIA - DEPARTMENT OF TRANSPORTATION  
**Caltrans**



DIST	COUNTY	ROUTE	KILOMETER POST TOTAL PROJECT	SHEET No	TOTAL SHEETS
04	SF	80	13.2/13.9	45R2	1204



*Bobby J. Melvin* 12/19/2002  
 REGISTERED MECHANICAL ENGINEER DATE

12-6-04  
 PLANS APPROVAL DATE

PARSONS BRINCKERHOFF QUADE & DOUGLAS, INC.  
 303 SECOND STREET, SUITE 700 N  
 SAN FRANCISCO, CA 94107

*The State of California or its officers or agents shall not be responsible for the accuracy or completeness of electronic copies of this plan sheet.*

To get to the web site, go to <http://www.dot.ca.gov>

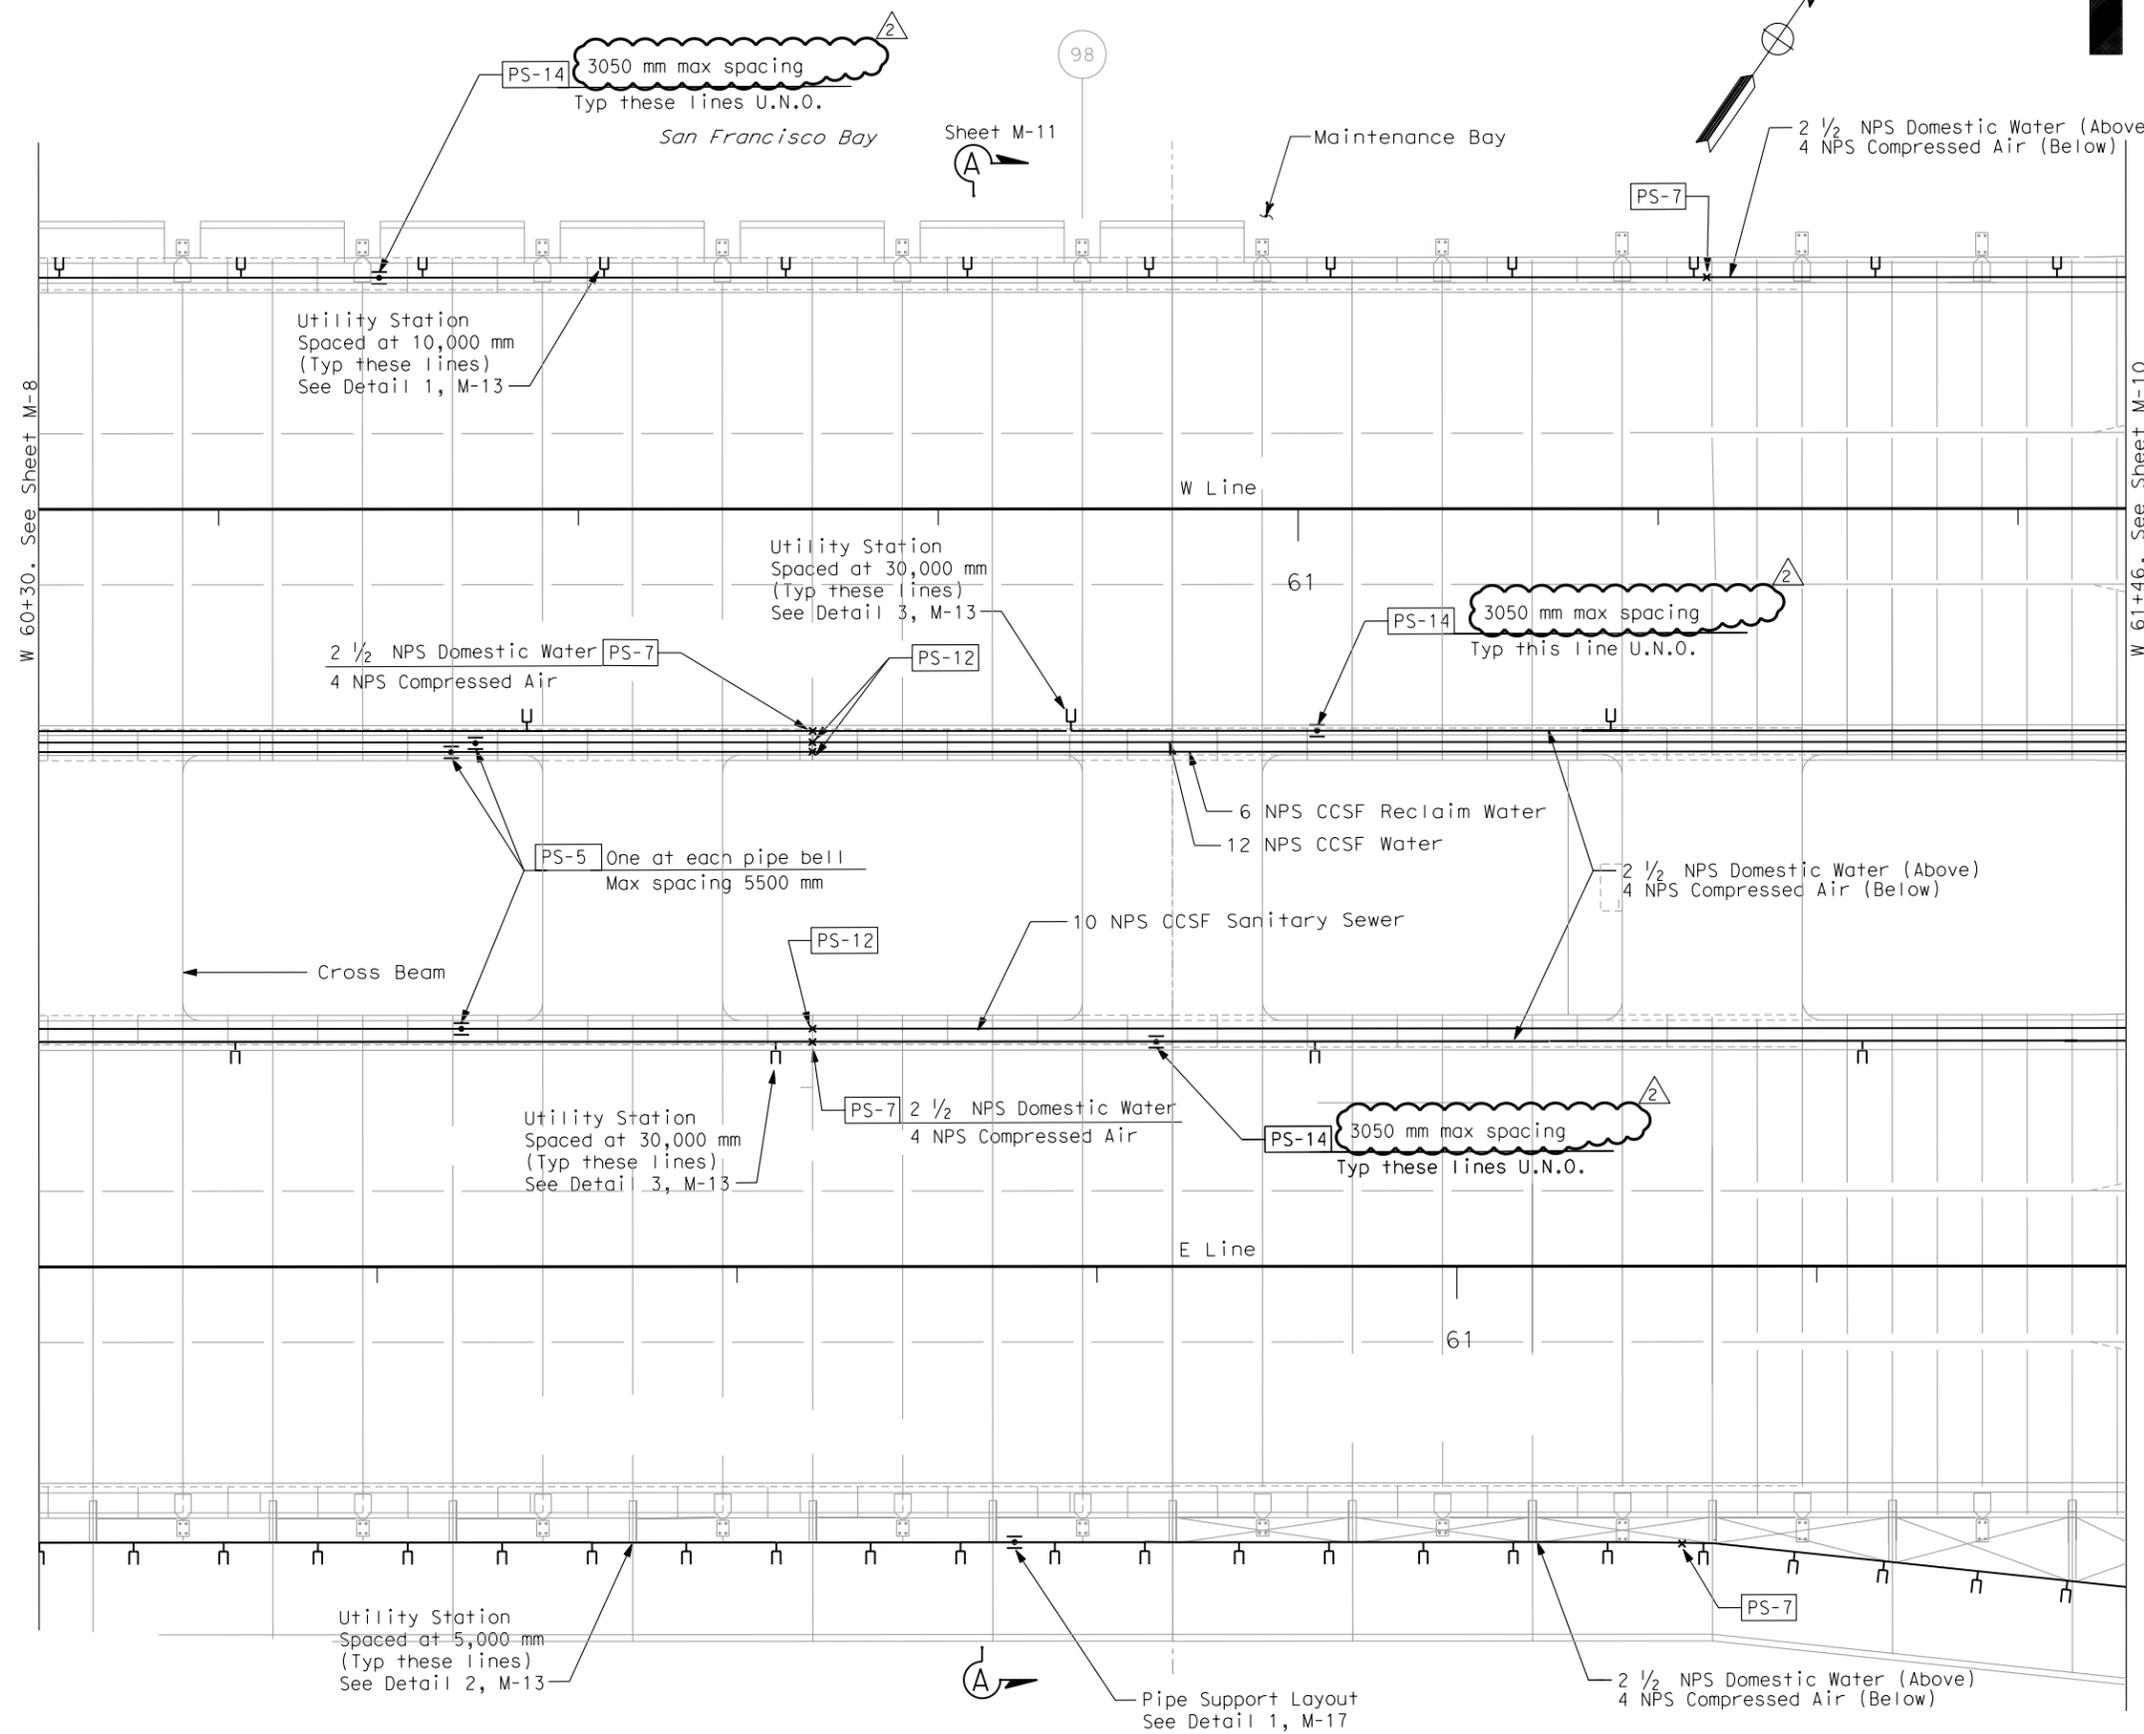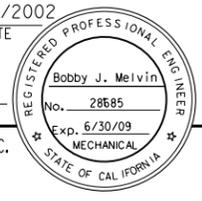

- NOTES:**
- All Stationing are in meters.
  - No  $\triangle$  mark numbers used on this sheet for CCO 31

REQUEST FOR INFORMATION NOT ADDRESSED IN THIS CCO REMAIN IN FORCE					
MARK	DATE	DESCRIPTIONS	BY	CH'D	CCO#
$\triangle$ 2	1/18/08	MECHANICAL MODIFICATIONS	VY	BM	31
$\triangle$ 1	9/05/07	MECHANICAL MODIFICATIONS	BM	RM	31
REVISIONS					

CONTRACT CHANGE ORDER NO. \_\_\_\_\_  
 SHEET \_\_\_\_\_ OF \_\_\_\_\_

ALL DIMENSIONS ARE IN MILLIMETERS UNLESS OTHERWISE SHOWN

# MAIN SPAN STRUCTURE PIPING PLAN

SCALE: 1:200

## M-9

FOR REDUCED PLANS ORIGINAL SCALE IS IN MILLIMETERS

LAST REVISION 00-00-00  
 DATE PLOTTED => 2/29/2008  
 TIME PLOTTED => 3:10:56 PM