




DIST	COUNTY	ROUTE	KILOMETER TOTAL PROJECT	POST PROJECT	SHEET No	TOTAL SHEETS
04	SF	80	13.2/13.9		273R1	1204


12/19/02
 REGISTERED ELECTRICAL ENGINEER DATE
 12-6-04
 PLANS APPROVAL DATE
 PB POWER, Inc.
 A Parsons Brinckerhoff Company
 303 Second St., Suite 700N
 San Francisco, CA 94107-1317

The State of California or its officers or agents shall not be responsible for the accuracy or completeness of electronic copies of this plan sheet.
 Caltrans now has a web site! To get to the web site, go to <http://www.dot.ca.gov>


STATE OF CALIFORNIA - DEPARTMENT OF TRANSPORTATION
 DESIGN OVERSIGHT
 BEHZAD GOLEMOHAMMADI
 REVISIONS
 DATE 10/01
 DATE 11/01
 FK
 EDC
 CHECKED BY
 DESIGNED BY
 AB
 DATE REVISED 2/04

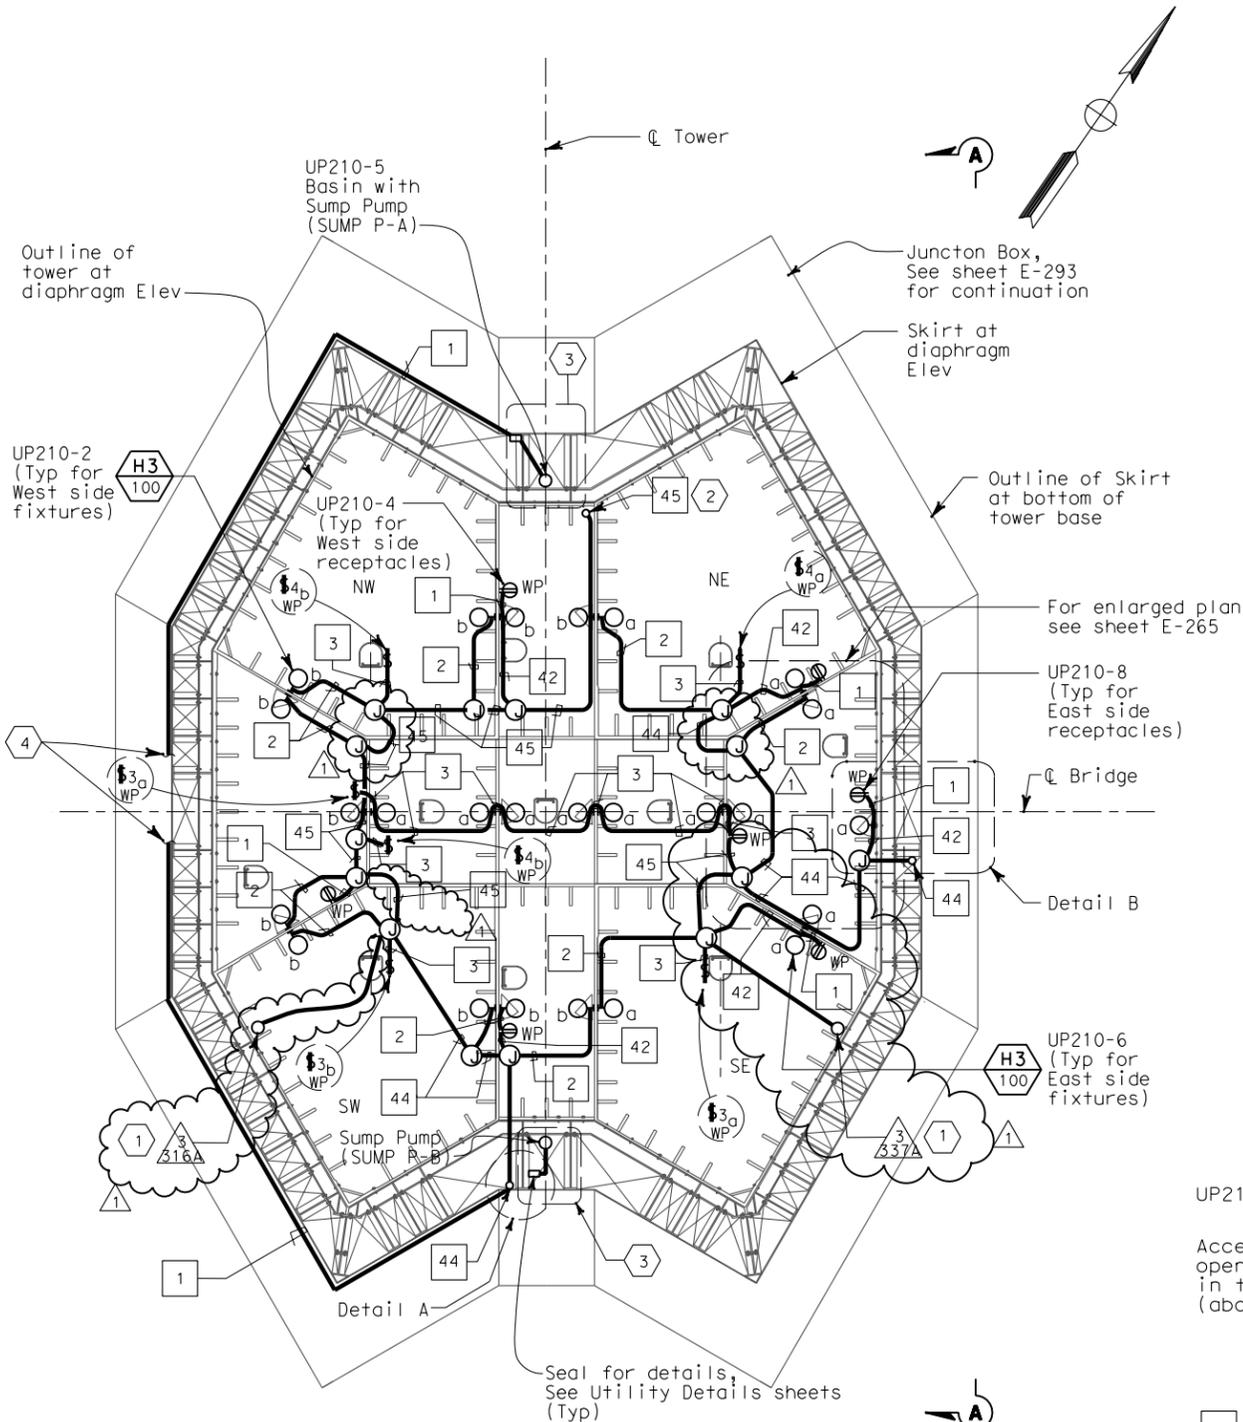


PLAN AT ELEV 9.0 m
SCALE 1:100

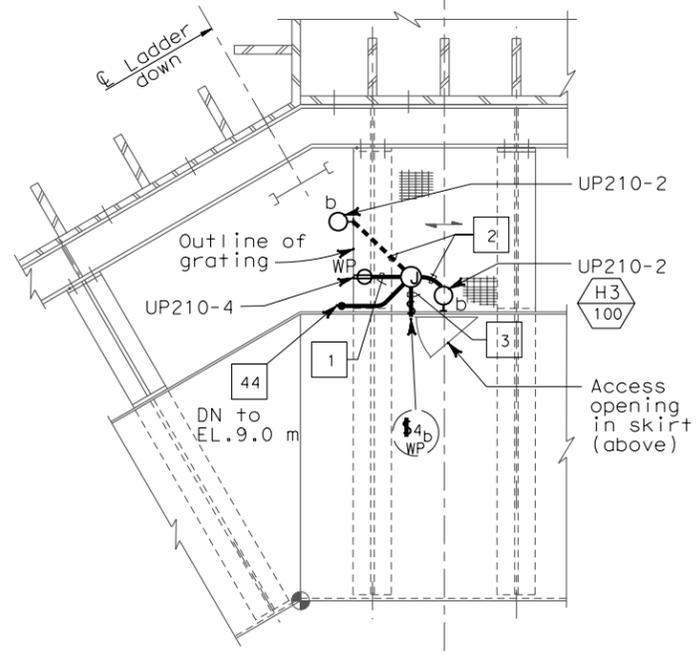

DETAIL A
SCALE 1:25

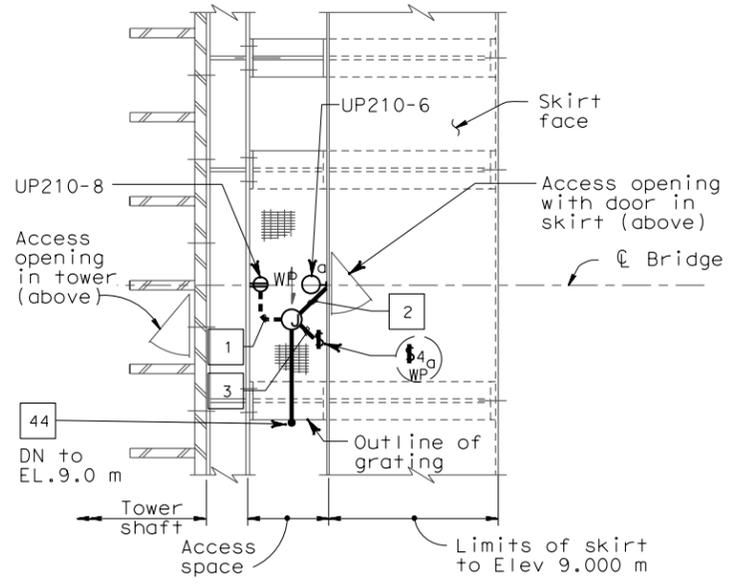

DETAIL B
1:25

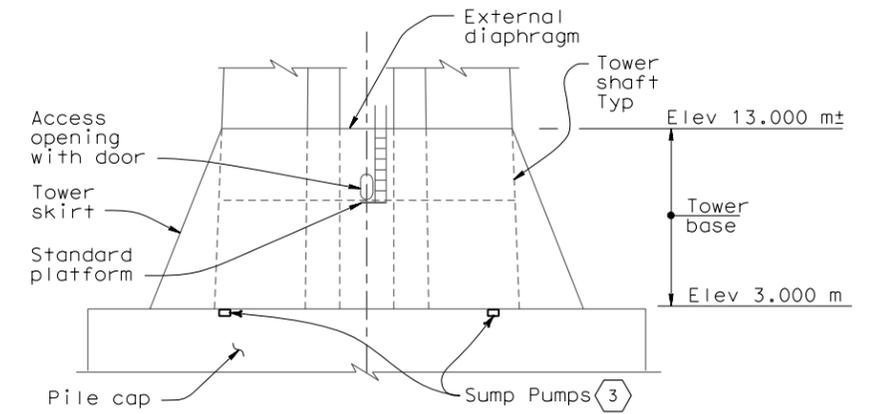

SECTION A-A
1:200

**DETAILS
TOWER AND SUSPENSION CABLE
TOWER POWER AND LIGHTING**
SCALE AS NOTED

- SHEET NOTES:**
- Up to 600V cable tray at Elevation 13m.
 - For continuation, see sheet E-265.
 - For Sump Pump Basin installation, see Detail 6 on sheet E-267.
 - Continue conduit to junction box on E-231.

 
- NOTES:**
- References:
 - For vertical conduit runs support system, see sheet E-287.
 - For utility panel UP-210 schedule, see sheet E-278.
 - For types of pull boxes, splice boxes and enclosures, see sheets E-83 and E-169.
 - For conduit and cable tray schedule, see sheets starting at E-401.
 - For lighting installation details, see sheet E-267.
 - For lighting fixture schedule, see sheet E-273.
 - For typical conduit installation details, see sheet E-268.
 - All conduits and fittings routed exposed at grating shall be rigid galvanized steel, PVC coated.
 - Electrical conduits shall enter the tower shafts between stiffeners A3 and A4 only. For conduit entry details, see Structural Utility drawings.
 - Fixture mounting height elevation shall be 2.4 m above floor/platform elevation UNO.
 - For other related work not shown on this sheet, see Electrical Special Provisions.



CONTRACT CHANGE ORDER NO. _____
 SHEET _____ OF _____
 FOR REVISION ONLY

THIS PLAN ACCURATE FOR ELECTRICAL WORK ONLY.

ALL DIMENSIONS ARE IN MILLIMETERS UNLESS OTHERWISE SHOWN.



DATE PLOTTED => 4/4/2008
 TIME PLOTTED => 4:56:25 PM
 LAST REVISION 00-00-00