



DIST	COUNTY	ROUTE	KILOMETER TOTAL PROJECT	POST SHEET No	TOTAL SHEETS
04	SF	80	13.2/13.9	124R1	1204

*Jens Erlingsson* 12/19/02  
 REGISTERED ELECTRICAL ENGINEER DATE


12-6-04  
 PLANS APPROVAL DATE

PB POWER, Inc.  
 A Parsons Brinckerhoff Company  
 303 Second St., Suite 700N  
 San Francisco, CA 94107-1317

*Jens Erlingsson*  
 REGISTERED PROFESSIONAL ENGINEER  
 No. 8249  
 Exp. 9/30/06  
 ELECTRICAL  
 STATE OF CALIFORNIA

*The State of California or its officers or agents shall not be responsible for the accuracy or completeness of electronic copies of this plan sheet.*

Caltrans now has a web site! To get to the web site, go to <http://www.dot.ca.gov>

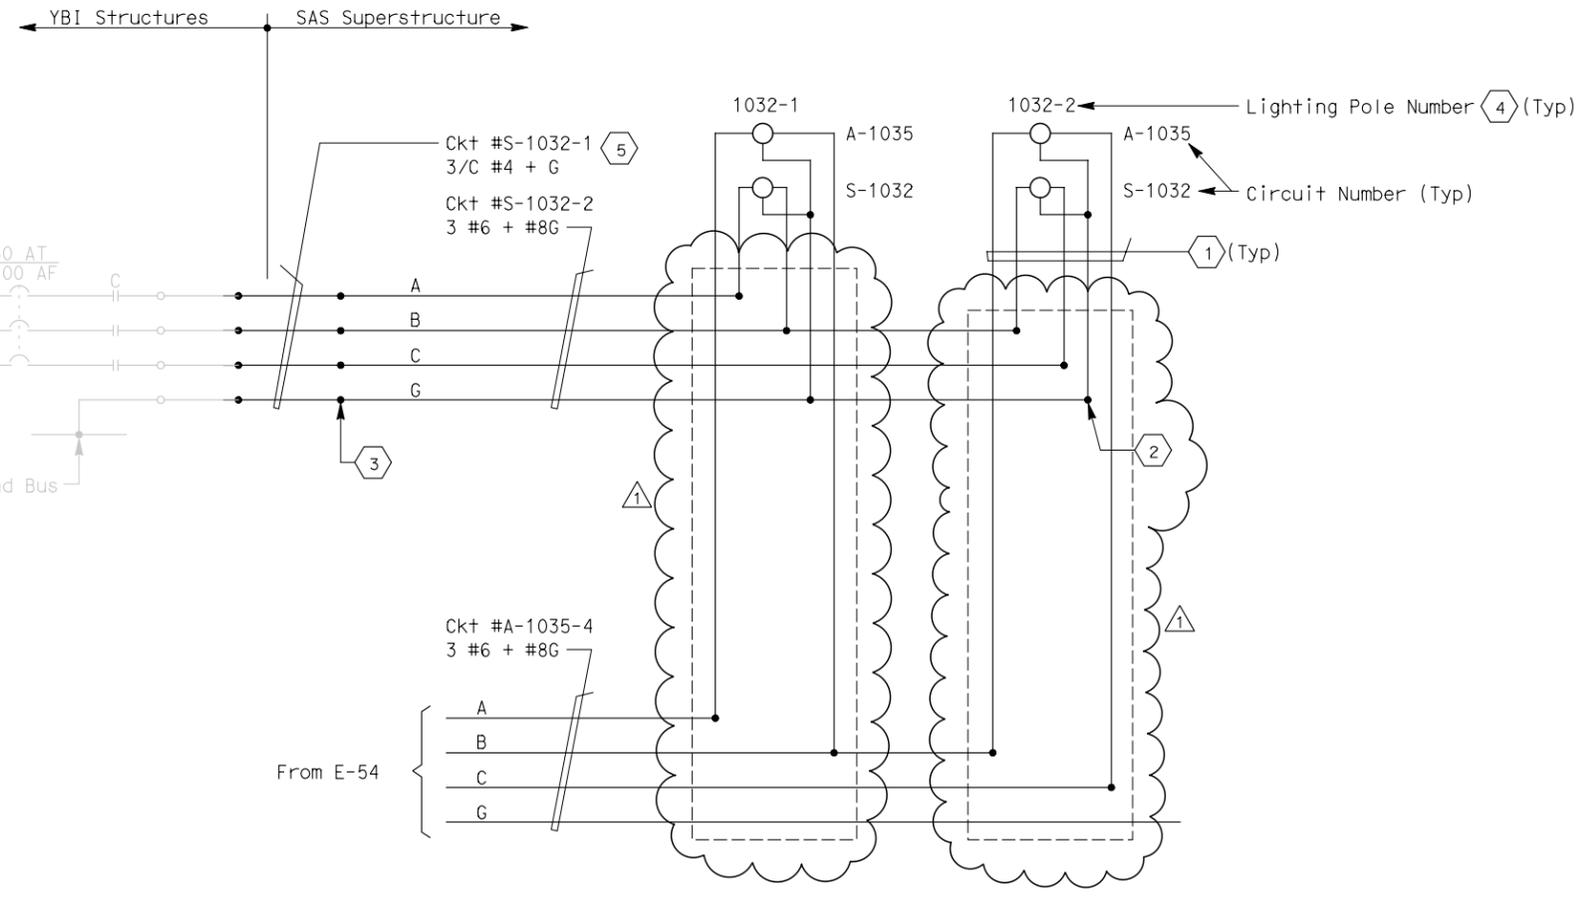

**SHEET NOTES:**

- (1) 4#10 + #10 G single conductors.
- (2) Conductors spliced inside pull box PB-LTG. (Pole #1032-2 only).
- (3) Conductors spliced inside junction box PB-2A located inside girder.
- (4) For SAS superstructure roadway westbound lighting schedule, see sheet E-82.
- (5) The Contractor shall extend and coil 5 meters of cable in manhole 25. All cables shall be tagged with circuit numbers as shown. For location of manhole 25, see sheet E-11.

**NOTES:**

- 1. References:
  - For pull box schedule, see sheet E-83.
  - For circuit and conduit/cable tray schedules, see sheets starting at E-401.
  - For single line diagram, see sheets E-29 through E-34.

(1)	8-06-07	Electrical modifications.	MP	RR	42
MARK	DATE	DESCRIPTIONS	BY	CK	CCO
REVISIONS					

CONTRACT CHANGE ORDER NO. 42  
 SHEET \_\_\_\_\_ OF \_\_\_\_\_



*M. F. Takai*  
 FOR REVISION ONLY

**DETAILS**  
**SAS SUPERSTRUCTURE ROADWAY WESTBOUND**  
**480 V ROADWAY LIGHTING WIRING DIAGRAM**  
 NO SCALE

STATE OF CALIFORNIA - DEPARTMENT OF TRANSPORTATION  
 DESIGN OVERSIGHT  
 BEHZAD GOLEMOHAMMADI  
 CALCULATED/DESIGNED BY  
 CHECKED BY  
 DATE REVISION BY  
 DATE REVISION

DATE PLOTTED => 12/19/2007  
 TIME PLOTTED => \$TIME  
 LAST REVISION  
 00-00-00