



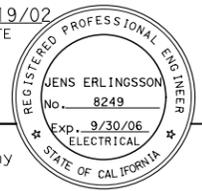

Jens Erlingsson 12/19/02
 REGISTERED ELECTRICAL ENGINEER DATE
 12-6-04
 PLANS APPROVAL DATE
 PB POWER, Inc.
 A Parsons Brinckerhoff Company
 303 Second St., Suite 700N
 San Francisco, CA 94107-1317



The State of California or its officers or agents shall not be responsible for the accuracy or completeness of electronic copies of this plan sheet.
 Caltrans now has a web site! To get to the web site, go to: <http://www.dot.ca.gov>

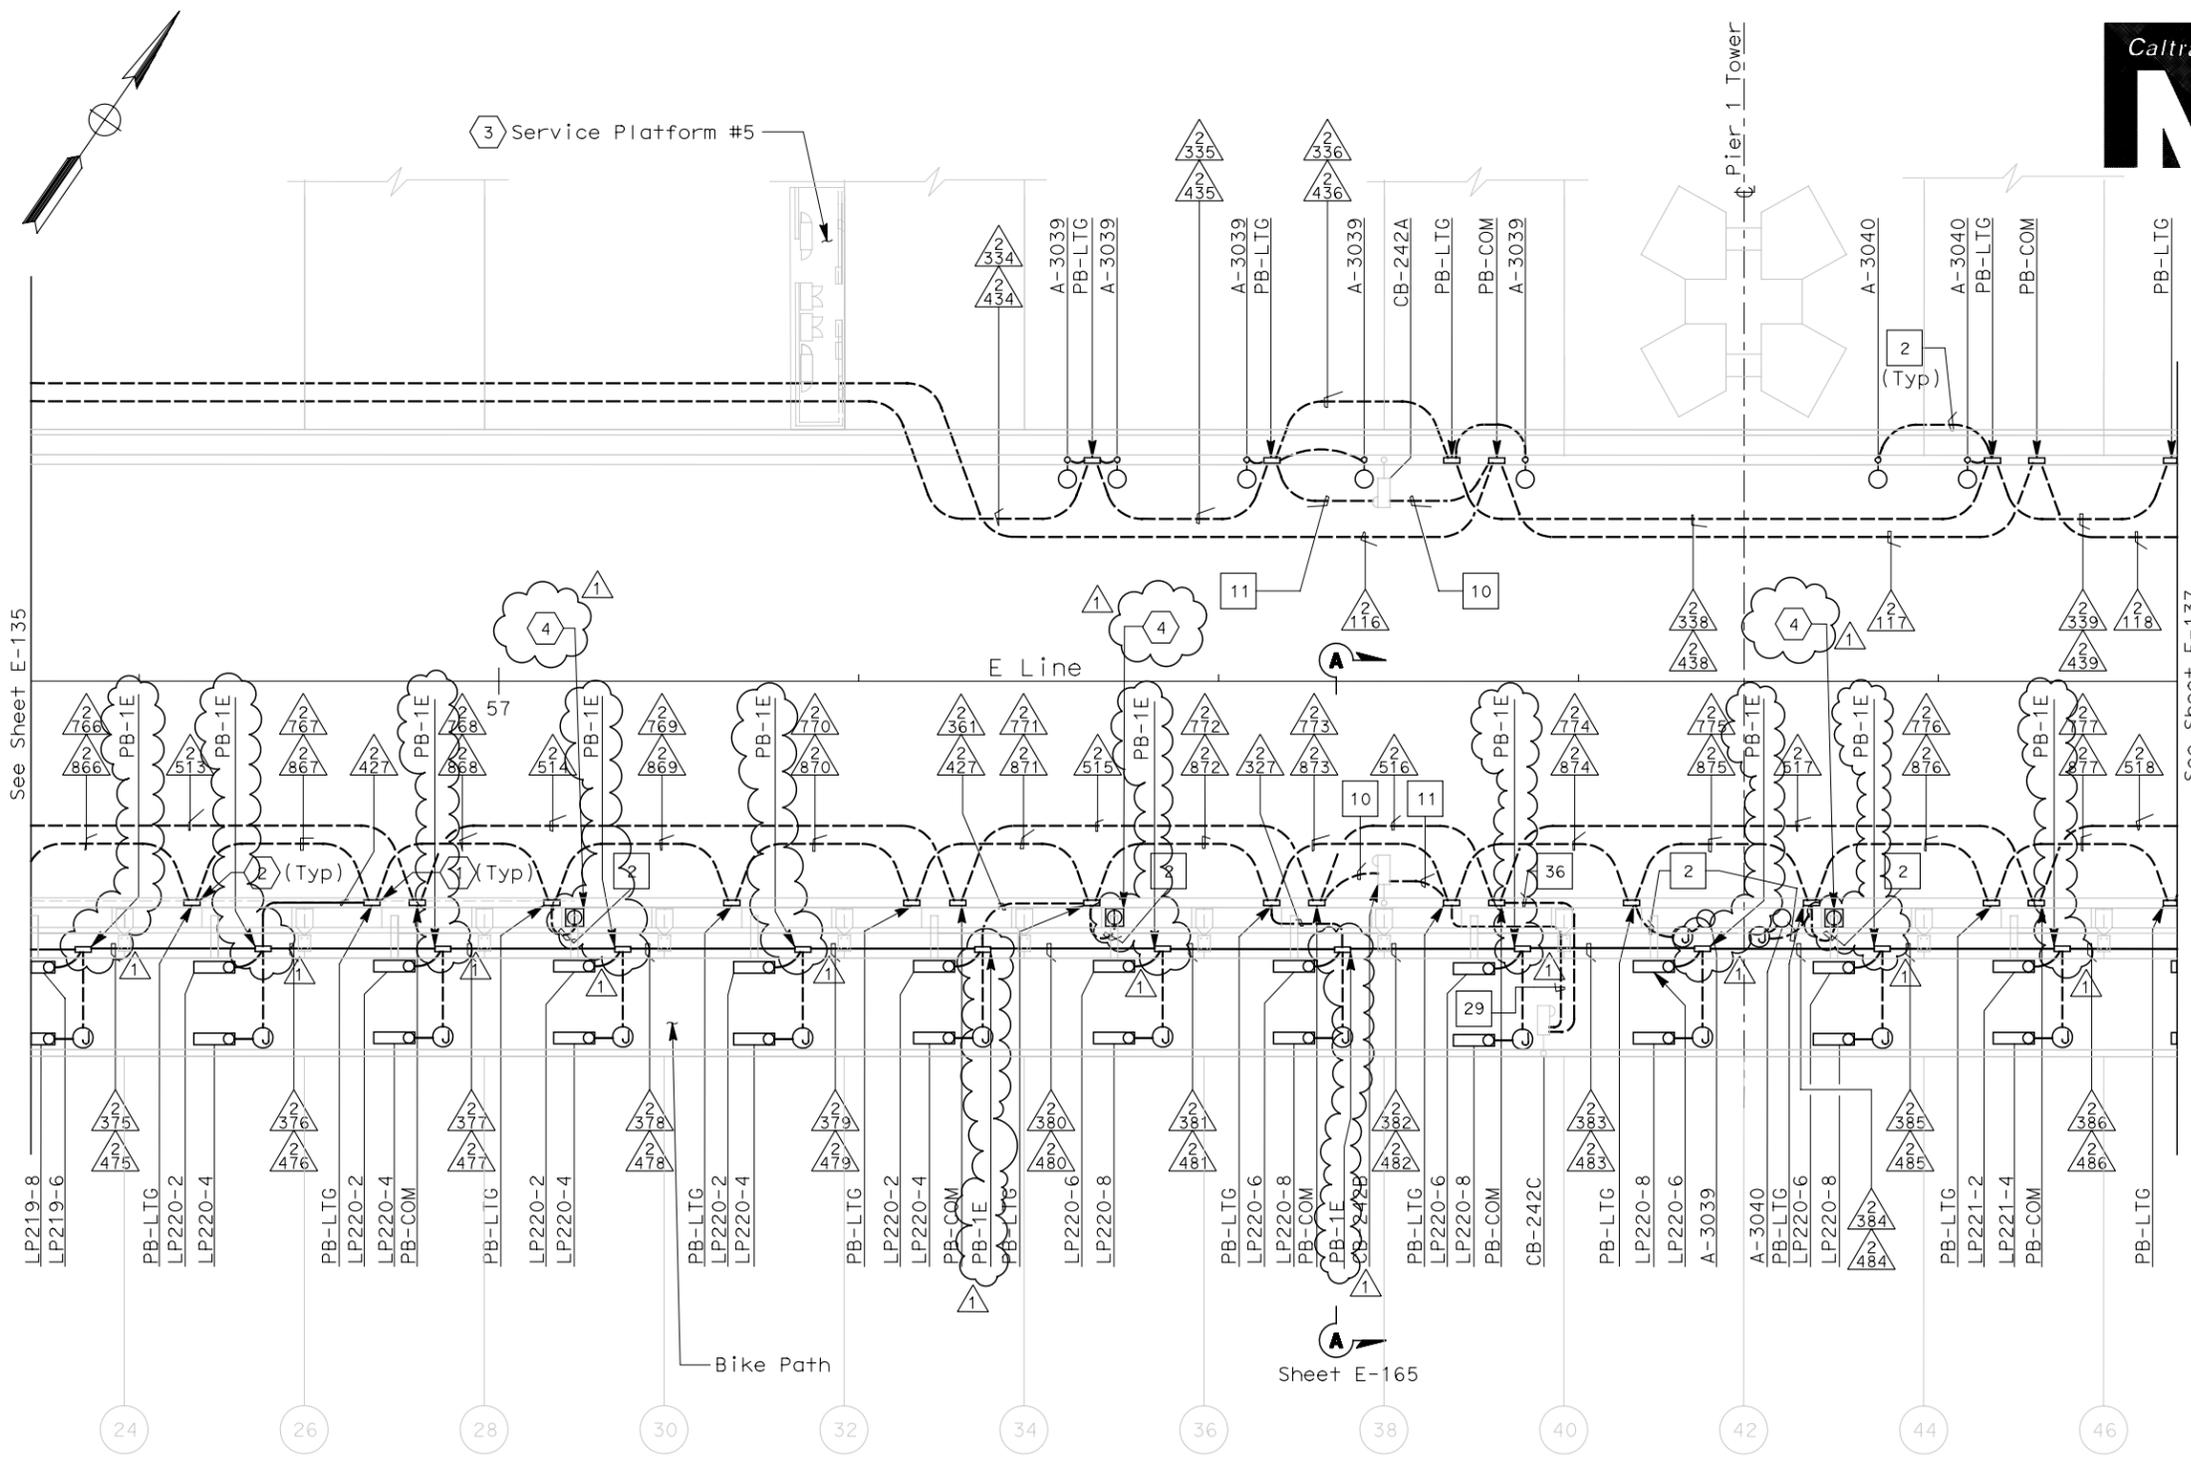

- SHEET NOTES:**
- Conduit from barrier pullbox or other equipment down into Girder Box, see sheet E-182.
 - For conduit to tower and suspension cable lighting see sheet E-227.
 - Contractor shall furnish and install UP-205 and LP-220 per sheet E-72. For complete scope of work on platform and other related work not shown on this sheet, see Electrical Special Provisions.
 - Roadway Barrier Receptacle, see Detail 1, sheet E-162.

- NOTES:**
- References:
 - For typical details and locations of conduit connections to light poles, barrier outlet boxes, call boxes, overhead sign lighting, CMS, CCTV and MVDS, see sheets E-160 thru E-162 and E-169.
 - TOS equipment is shown for conduit routing only. For typical details of TOS controller and devices, see sheets E-344 through E-357.
 - For types of pull boxes, splice boxes and enclosures, see sheet E-169.
 - For circuit and conduit/cable tray schedules, see sheets starting at E-401.
 - For Roadway Level Call Boxes, refer to sheet E-396.
 - For Roadway level, Bike Path and Belvedere Lighting Fixture Schedules, see sheets E-146, E-147 and E-165.
 - For Roadway level and Bike Path Call Box Schedule, see sheet E-397.
 - For number of lighting fixtures (main tower lights) see lighting schedule sheets E-271 and E-272.
 - All conduits and fittings routed exposed between the Bike Path and the roadway shall be galvanized rigid steel, PVC coated.
 - See sheets E-160 thru E-165 for conduit locations.

SAS SUPERSTRUCTURE CONDUIT - PLAN

MARK	DATE	DESCRIPTIONS	BY	CK	CCO	
1	8-06-07	Electrical modifications.	MP	EL	RR	42
REVISIONS						

CONTRACT CHANGE ORDER NO. 42
 SHEET _____ OF _____

 


M. F. Tamki
 FOR REVISION ONLY

SAS SUPERSTRUCTURE ROADWAY EASTBOUND LIGHTING AND ELECTRICAL SYSTEMS

SCALE 1:200

THIS PLAN ACCURATE FOR ELECTRICAL WORK ONLY.



DATE PLOTTED => 12/19/2007
 TIME PLOTTED => \$TIME
 LAST REVISION 00-00-00