
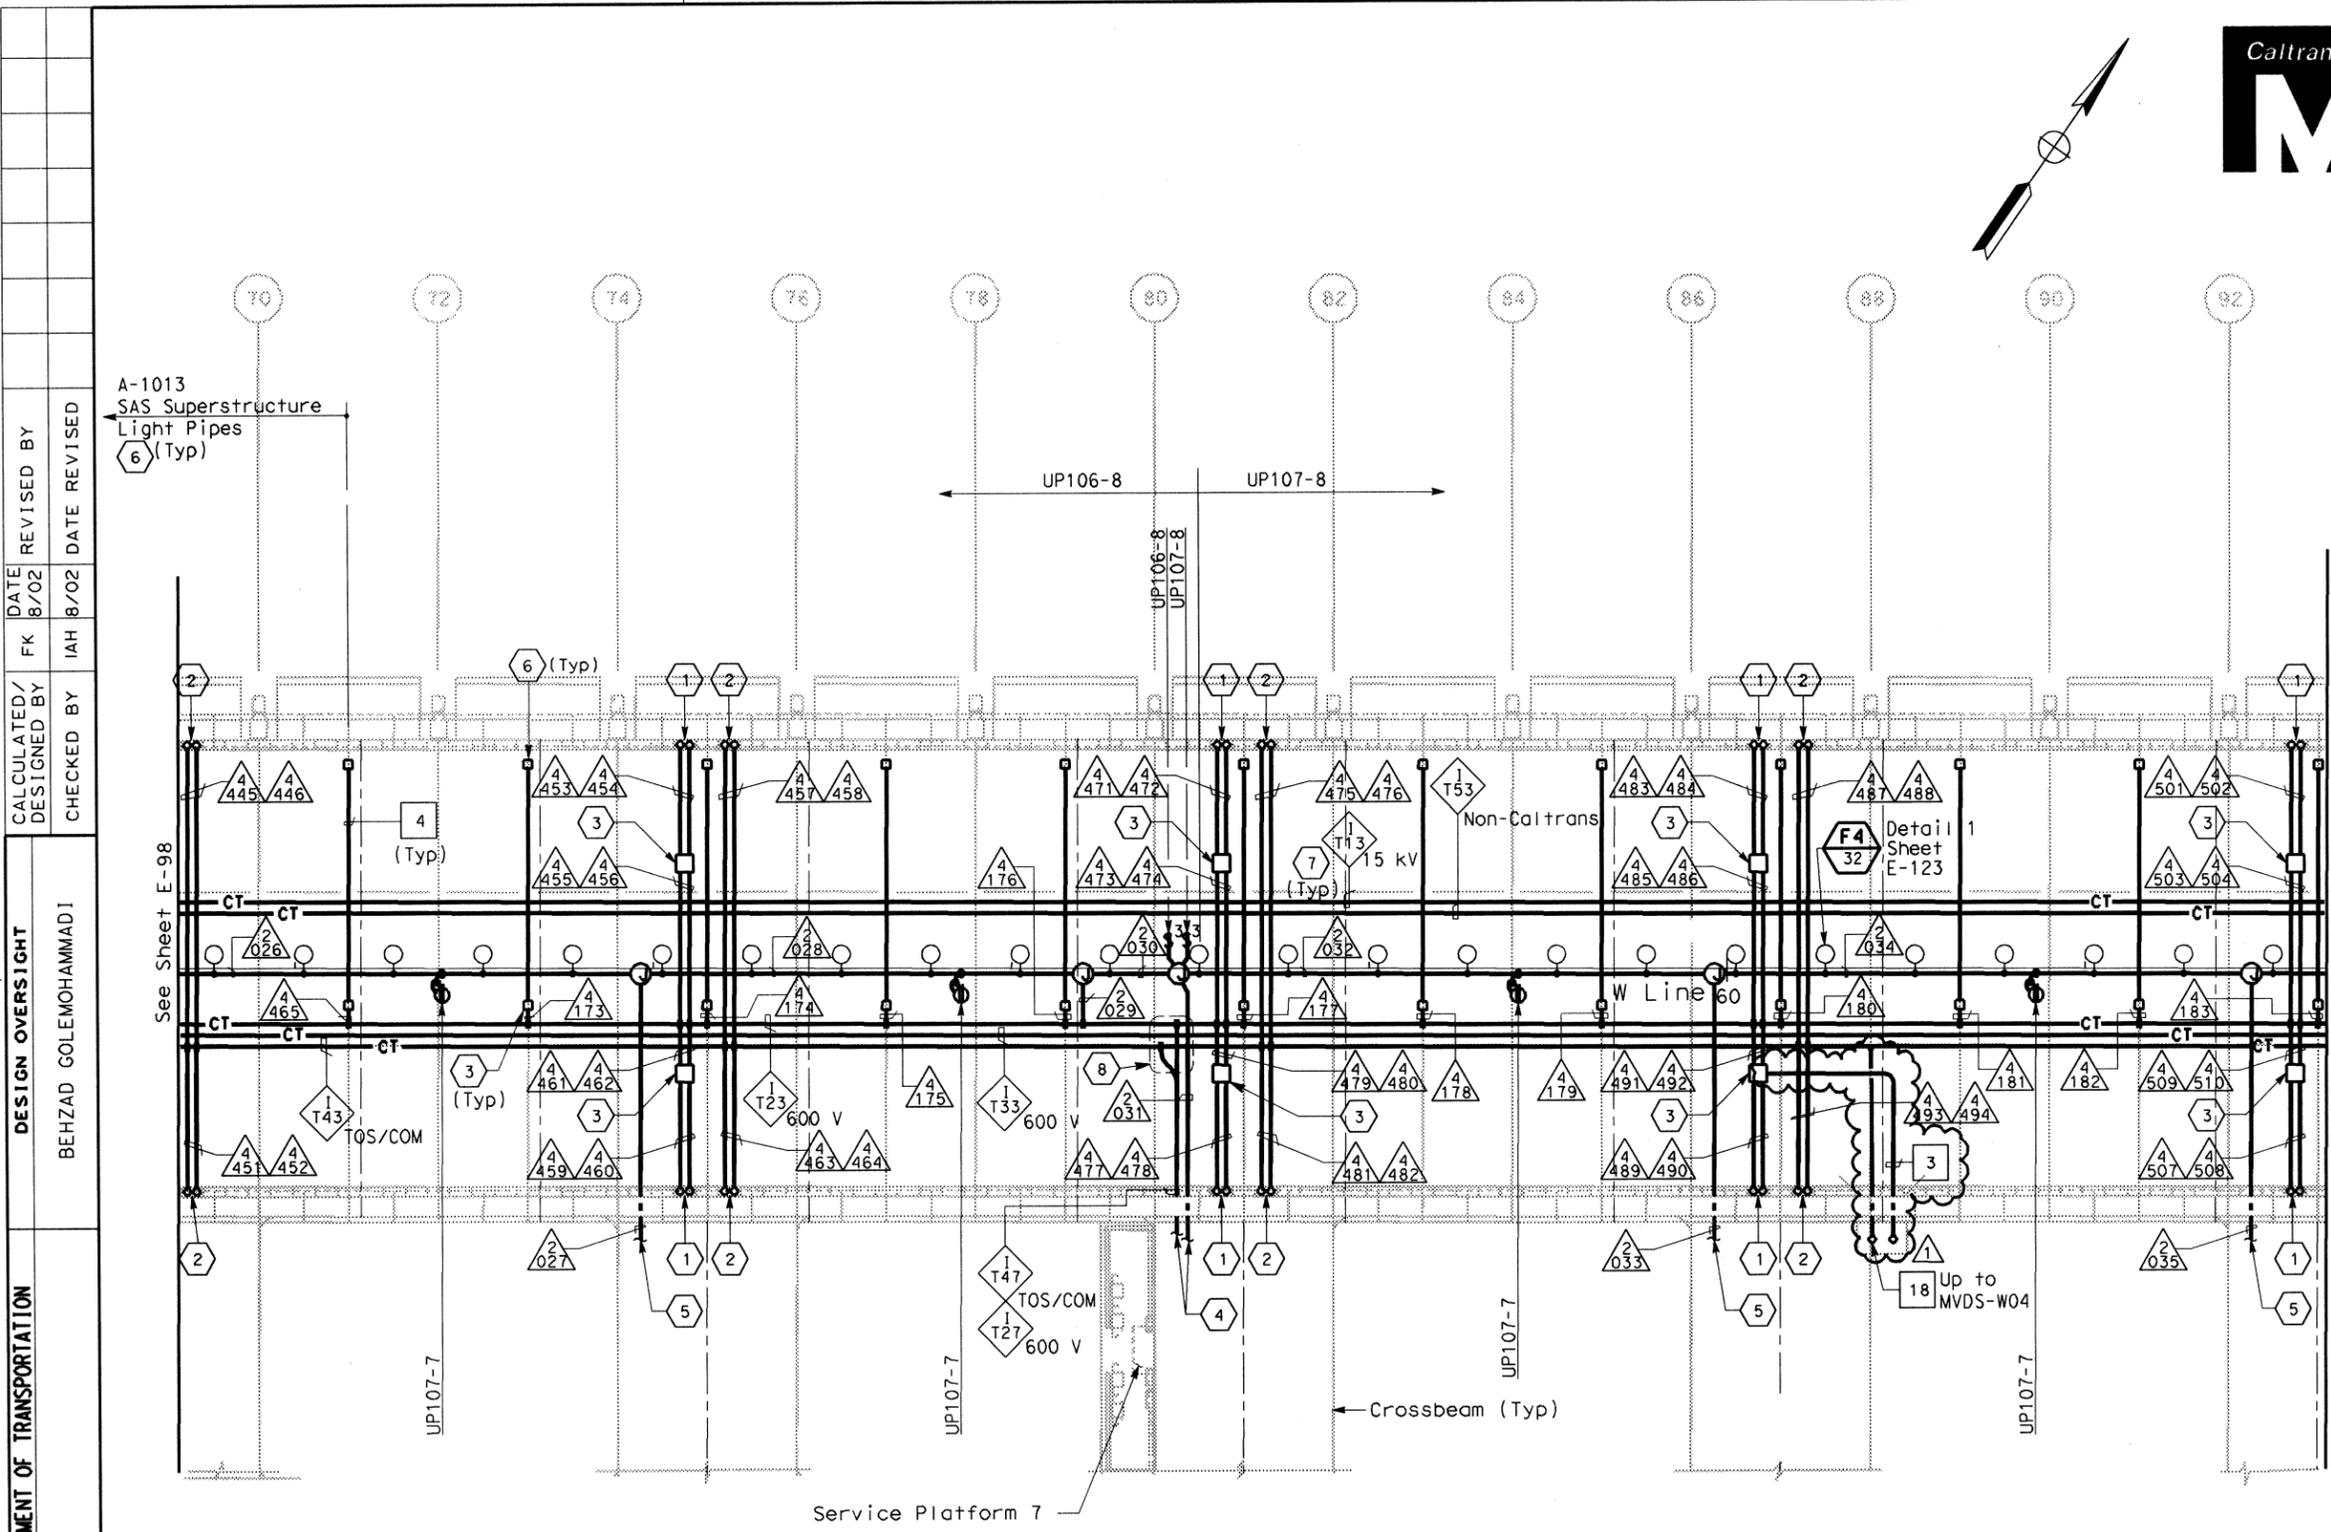


DIST	COUNTY	ROUTE	KILOMETER POST TOTAL PROJECT	SHEET No	TOTAL SHEETS
04	SF	80	13.2/13.9	152R1	1204

12-6-04
 PLANS APPROVAL DATE
 PB POWER, Inc.
 A Parsons Brinckerhoff Company
 303 Second St., Suite 700N
 San Francisco, CA 94107-1317

The State of California or its officers or agents shall not be responsible for the accuracy or completeness of electronic copies of this plan sheet.
 Caltrans now has a web site! To get to the web site, go to <http://www.dtl.ca.gov>

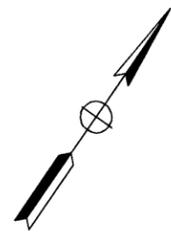

- SHEET NOTES:**
- Conduit up to PB-LTG located in barrier, see sheet E-49.
 - Conduit up to PB-COM located in barrier, see sheet E-49.
 - PB-2A, locate on top of floor.
 - For cable tray run and lighting inside crossbeam, see sheet E-117.
 - For lighting inside crossbeam, see sheet E-119.
 - PB-2L with circuit for future light pipes. See sheet E-121 for installation details and E-130 for lighting schedule.
 - For cable tray and ground bar support, refer to sheet E-125.
 - For fiber splice tray detail, refer to sheet E-356.

- NOTES:**
- References:
 - TOS equipment is shown for conduit routing only. For typical details of TOS controller and devices, see sheets E-344 through E-357.
 - For types of pull boxes, splice boxes and enclosures, see sheet E-83.
 - For bridge grounding plan, see sheet E-111.
 - For circuit and conduit/cable tray schedules, see sheets starting at E-401.
 - For other related work not shown on this sheet, see Electrical Special Provisions.
 - The girder lighting fixtures are shown diagrammatically. Contractor shall install fixtures at railing posts with a maximum of 8000 mm between fixtures. For types and typical lighting fixture installation details, see sheet E-123.
 - The cable trays are shown diagrammatically. For typical girder cable tray plans and sections, see sheets E-124 and E-125.

SAS SUPERSTRUCTURE - CONDUIT AND CABLE TRAY PLAN

STATE OF CALIFORNIA - DEPARTMENT OF TRANSPORTATION
 DESIGN OVERSIGHT
 BEHZAD GOLEMOHAMMADI
 CALCULATED/DESIGNED BY
 DATE 8/02
 FK
 IAH 8/02
 REVISOR
 DATE
 REVISIONS



REQUEST FOR INFORMATION NOT ADDRESSED IN THIS CCO REMAIN IN FORCE			
1	02/19/08	ELECTRICAL MODIFICATIONS	MP EL RR 42
MARK	DATE	DESCRIPTIONS	BY CH'D LCCO#
		REVISIONS	

CONTRACT CHANGE ORDER NO. _____
 SHEET _____ OF _____
 FOR REVISION ONLY

SAS SUPERSTRUCTURE GIRDER WESTBOUND LIGHTING AND ELECTRICAL SYSTEMS

SCALE 1:200

ALL DIMENSIONS ARE IN MILLIMETERS UNLESS OTHERWISE SHOWN.