

STATE OF CALIFORNIA - DEPARTMENT OF TRANSPORTATION  
**Caltrans**

DESIGN OVERSIGHT  
 BEHZAD GOLEMOHAMMADI

DESIGNED BY  
 JP

REVISOR  
 DATE  
 REVISION



| DIST | COUNTY | ROUTE | KILOMETER TOTAL PROJECT | POST PROJECT | SHEET No | TOTAL SHEETS |
|------|--------|-------|-------------------------|--------------|----------|--------------|
| 04   | SF     | 80    | 13.2/13.9               | 124R1        | 1204     |              |




*Jens Erlingsson* 12/19/02  
 REGISTERED ELECTRICAL ENGINEER DATE

12-6-04  
 PLANS APPROVAL DATE

PB POWER, Inc.  
 A Parsons Brinckerhoff Company  
 303 Second St., Suite 700N  
 San Francisco, CA 94107-1317

*The State of California or its officers or agents shall not be responsible for the accuracy or completeness of electronic copies of this plan sheet.*

*Caltrans now has a web site! To get to the web site, go to <http://www.dot.ca.gov>*

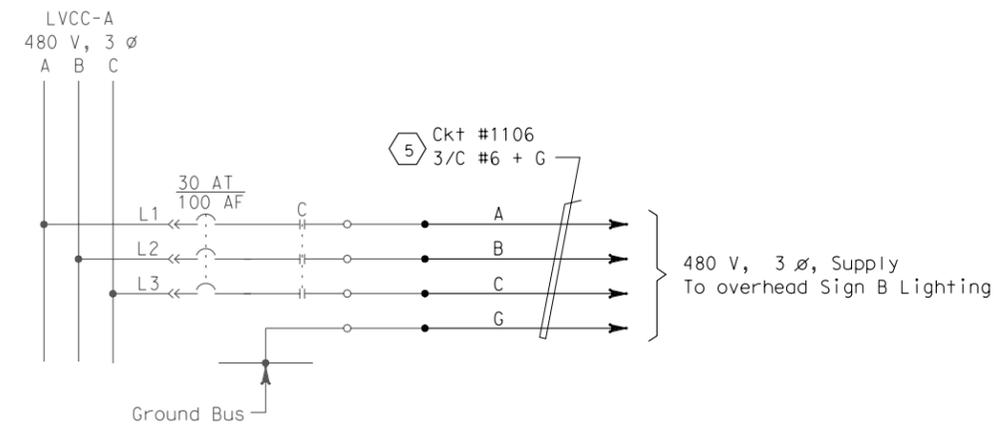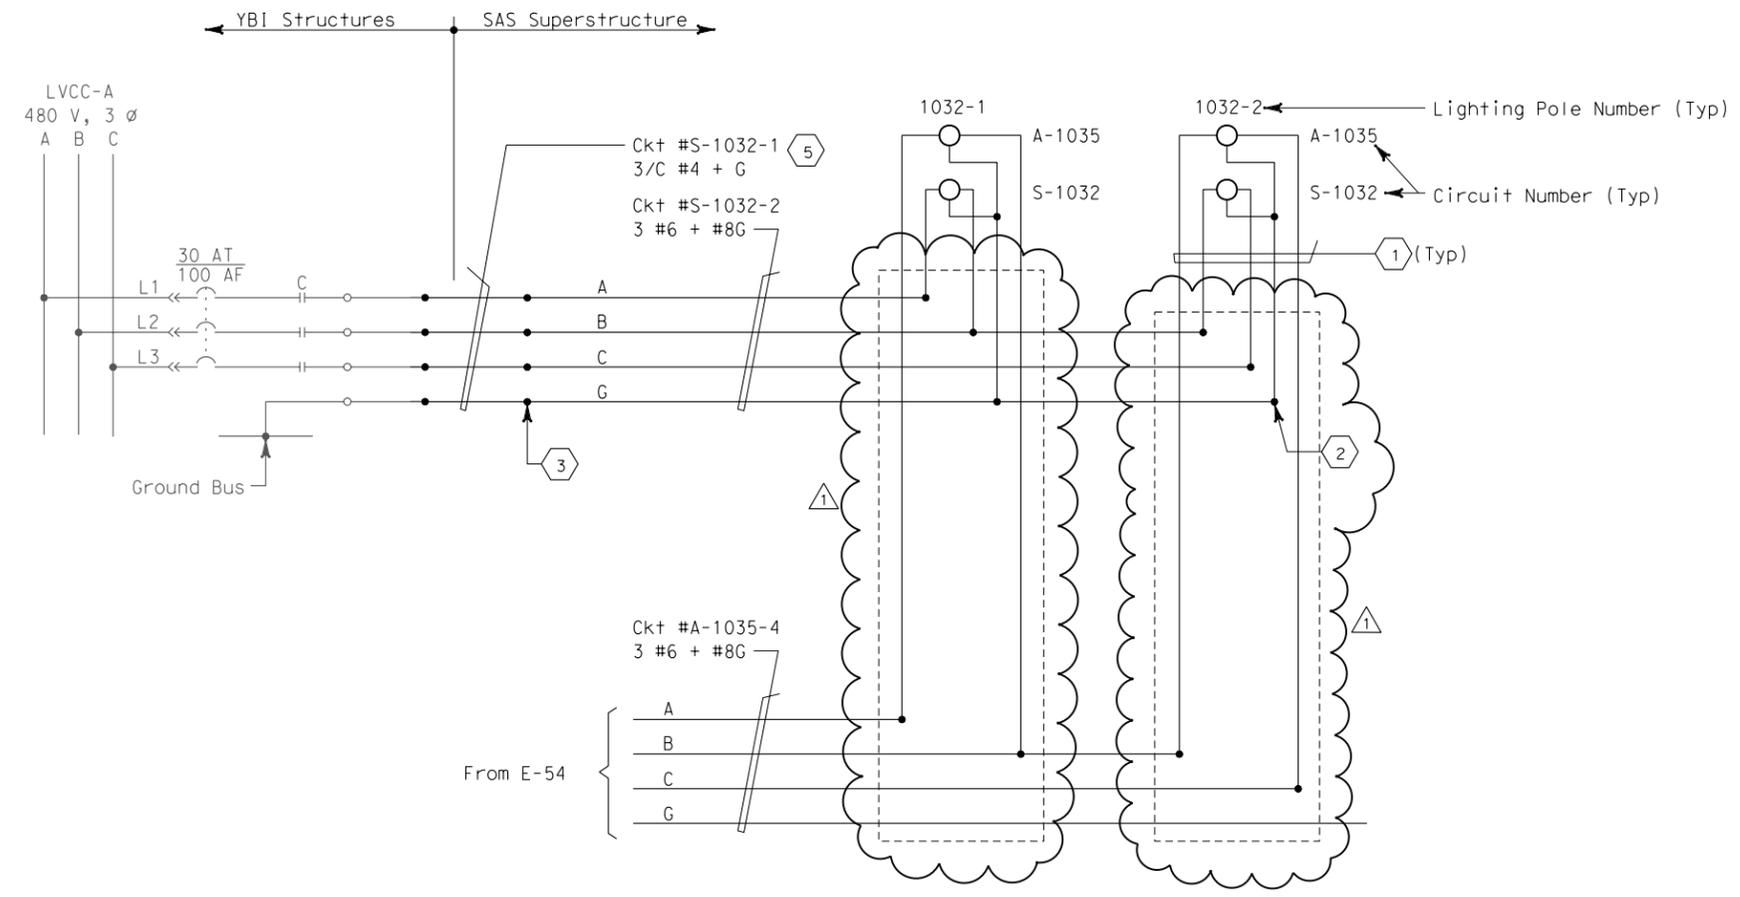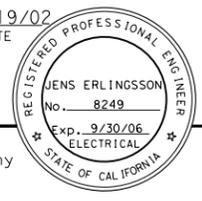


**480 V OVERHEAD SIGN**

**SHEET NOTES:**

- ① 4#10 + #10 G single conductors.
- ② Conductors spliced inside pull box PB-LTG. (Pole #1032-2 only).
- ③ Conductors spliced inside junction box PB-2A located inside girder.
- ④ For SAS superstructure roadway westbound lighting schedule, see sheet E-82.
- ⑤ The Contractor shall extend and coil 5 meters of cable in manhole 25. All cables shall be tagged with circuit numbers as shown. For location of manhole 25, see sheet E-11.

**NOTES:**

- 1. References:
  - For pull box schedule, see sheet E-83.
  - For circuit and conduit/cable tray schedules, see sheets starting at E-401.
  - For single line diagram, see sheets E-29 through E-34.

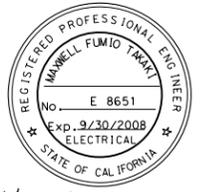

*M. F. Takai*  
 FOR REVISION ONLY

REQUEST FOR INFORMATION NOT ADDRESSED IN THIS CCO REMAIN IN FORCE

| MARK      | DATE     | DESCRIPTIONS             | BY | CH'D | CCO# |
|-----------|----------|--------------------------|----|------|------|
| ①         | 02/19/08 | ELECTRICAL MODIFICATIONS | MP | RR   | 42   |
| REVISIONS |          |                          |    |      |      |

CONTRACT CHANGE ORDER NO. \_\_\_\_\_  
 SHEET \_\_\_\_\_ OF \_\_\_\_\_

**DETAILS**  
**SAS SUPERSTRUCTURE ROADWAY WESTBOUND**  
**480 V ROADWAY LIGHTING WIRING DIAGRAM**  
 NO SCALE

DATE PLOTTED => 4/4/2008  
 TIME PLOTTED => 3:18:30 PM  
 00-00-00