



DIST	COUNTY	ROUTE	KILOMETER TOTAL PROJECT	POST PROJECT	SHEET No	TOTAL SHEETS
04	SF	80	13.2/13.9	194R1	1204	


12-6-04  
 PLANS APPROVAL DATE  
 PB POWER, Inc.  
 A Parsons Brinckerhoff Company  
 303 Second St., Suite 700N  
 San Francisco, CA 94107-1317

*Jens Erlingsson* 12/19/02  
 REGISTERED ELECTRICAL ENGINEER DATE

REGISTERED PROFESSIONAL ENGINEER  
 JENS ERLINGSSON  
 No. 8249  
 Exp. 9/30/06  
 ELECTRICAL  
 STATE OF CALIFORNIA

The State of California or its officers or agents shall not be responsible for the accuracy or completeness of electronic copies of this plan sheet.

Caltrans now has a web site! To get to the web site, go to <http://www.dot.ca.gov>

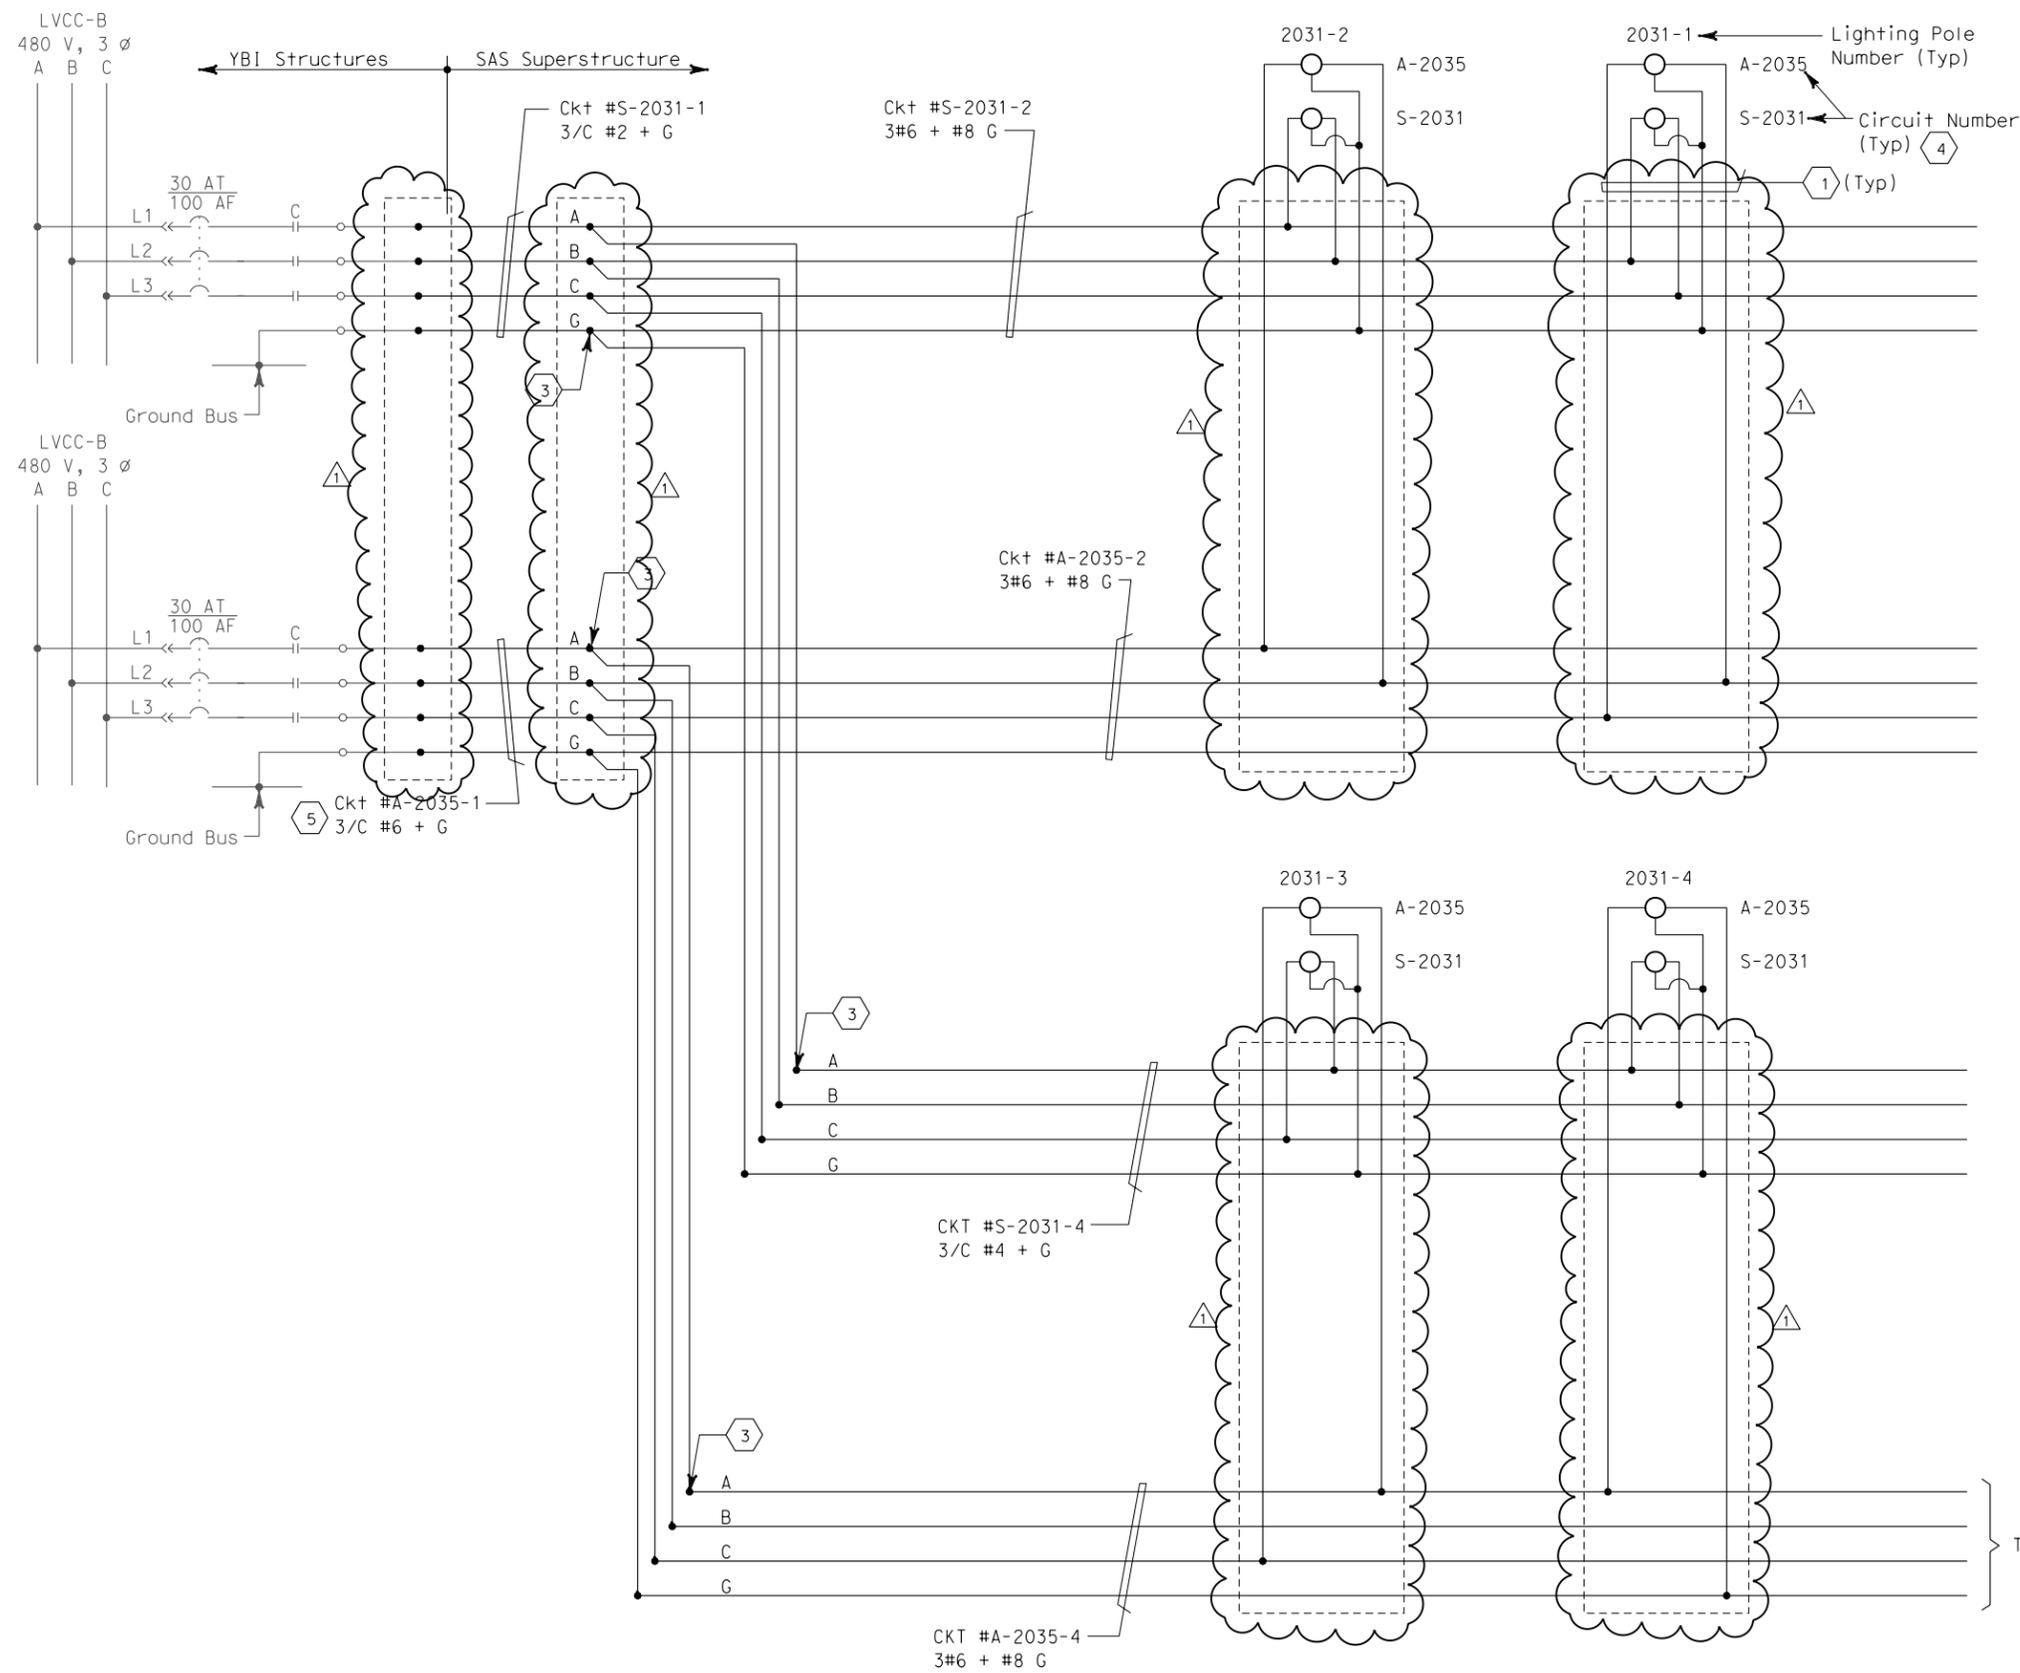

**SHEET NOTES:**

- ① 4#10 + #10 G, single conductors.
- ② Deleted.
- ③ conductors spliced inside junction box located inside girder.
- ④ For Main Span Roadway Eastbound lighting schedule, see sheet E-168.
- ⑤ The Contractor shall extend and coil 5 meters of cable in manhole 25. All cables shall be tagged with circuit numbers as shown.

**NOTES:**

- 1. Use multi-conductor cable if circuit is routed via cable trays.
- 2. References:  
 - For LVCC-B single line diagrams, see sheets E-32 to E-34  
 - For circuit and conduit/cable tray schedules, see sheets starting at E-401.
- 3. For SAS Superstructure Roadway Eastbound 480 V Roadway Lighting, see sheets E-135 thru E-140.



*M. F. Takai*  
 FOR REVISION ONLY

REQUEST FOR INFORMATION NOT ADDRESSED IN THIS CCO REMAIN IN FORCE						
①	02/19/08	ELECTRICAL MODIFICATIONS	MP	EL	RR	42
MARK	DATE	DESCRIPTIONS	BY	CH'D	CCO#	
		REVISIONS				

CONTRACT CHANGE ORDER NO. \_\_\_\_\_  
 SHEET \_\_\_\_\_ OF \_\_\_\_\_

**DETAILS**  
**SAS SUPERSTRUCTURE ROADWAY EASTBOUND**  
**480 V ROADWAY LIGHTING WIRING DIAGRAM**  
 NO SCALE