



DIST	COUNTY	ROUTE	KILOMETER TOTAL PROJECT	POST PROJECT	SHEET NO	TOTAL SHEETS
04	SF	80	13.2/13.9		197R1	1204

REGISTERED ELECTRICAL ENGINEER  
 JENS ERLINGSSON  
 No. 8249  
 Exp. 9/30/06  
 ELECTRICAL  
 STATE OF CALIFORNIA


12/19/02  
 REGISTERED ELECTRICAL ENGINEER DATE

12-6-04  
 PLANS APPROVAL DATE

PB POWER, Inc.  
 A Parsons Brinckerhoff Company  
 303 Second St., Suite 700N  
 San Francisco, CA 94107-1317

The State of California or its officers or agents shall not be responsible for the accuracy or completeness of electronic copies of this plan sheet.

Caltrans now has a web site! To get to the web site, go to <http://www.dot.ca.gov>

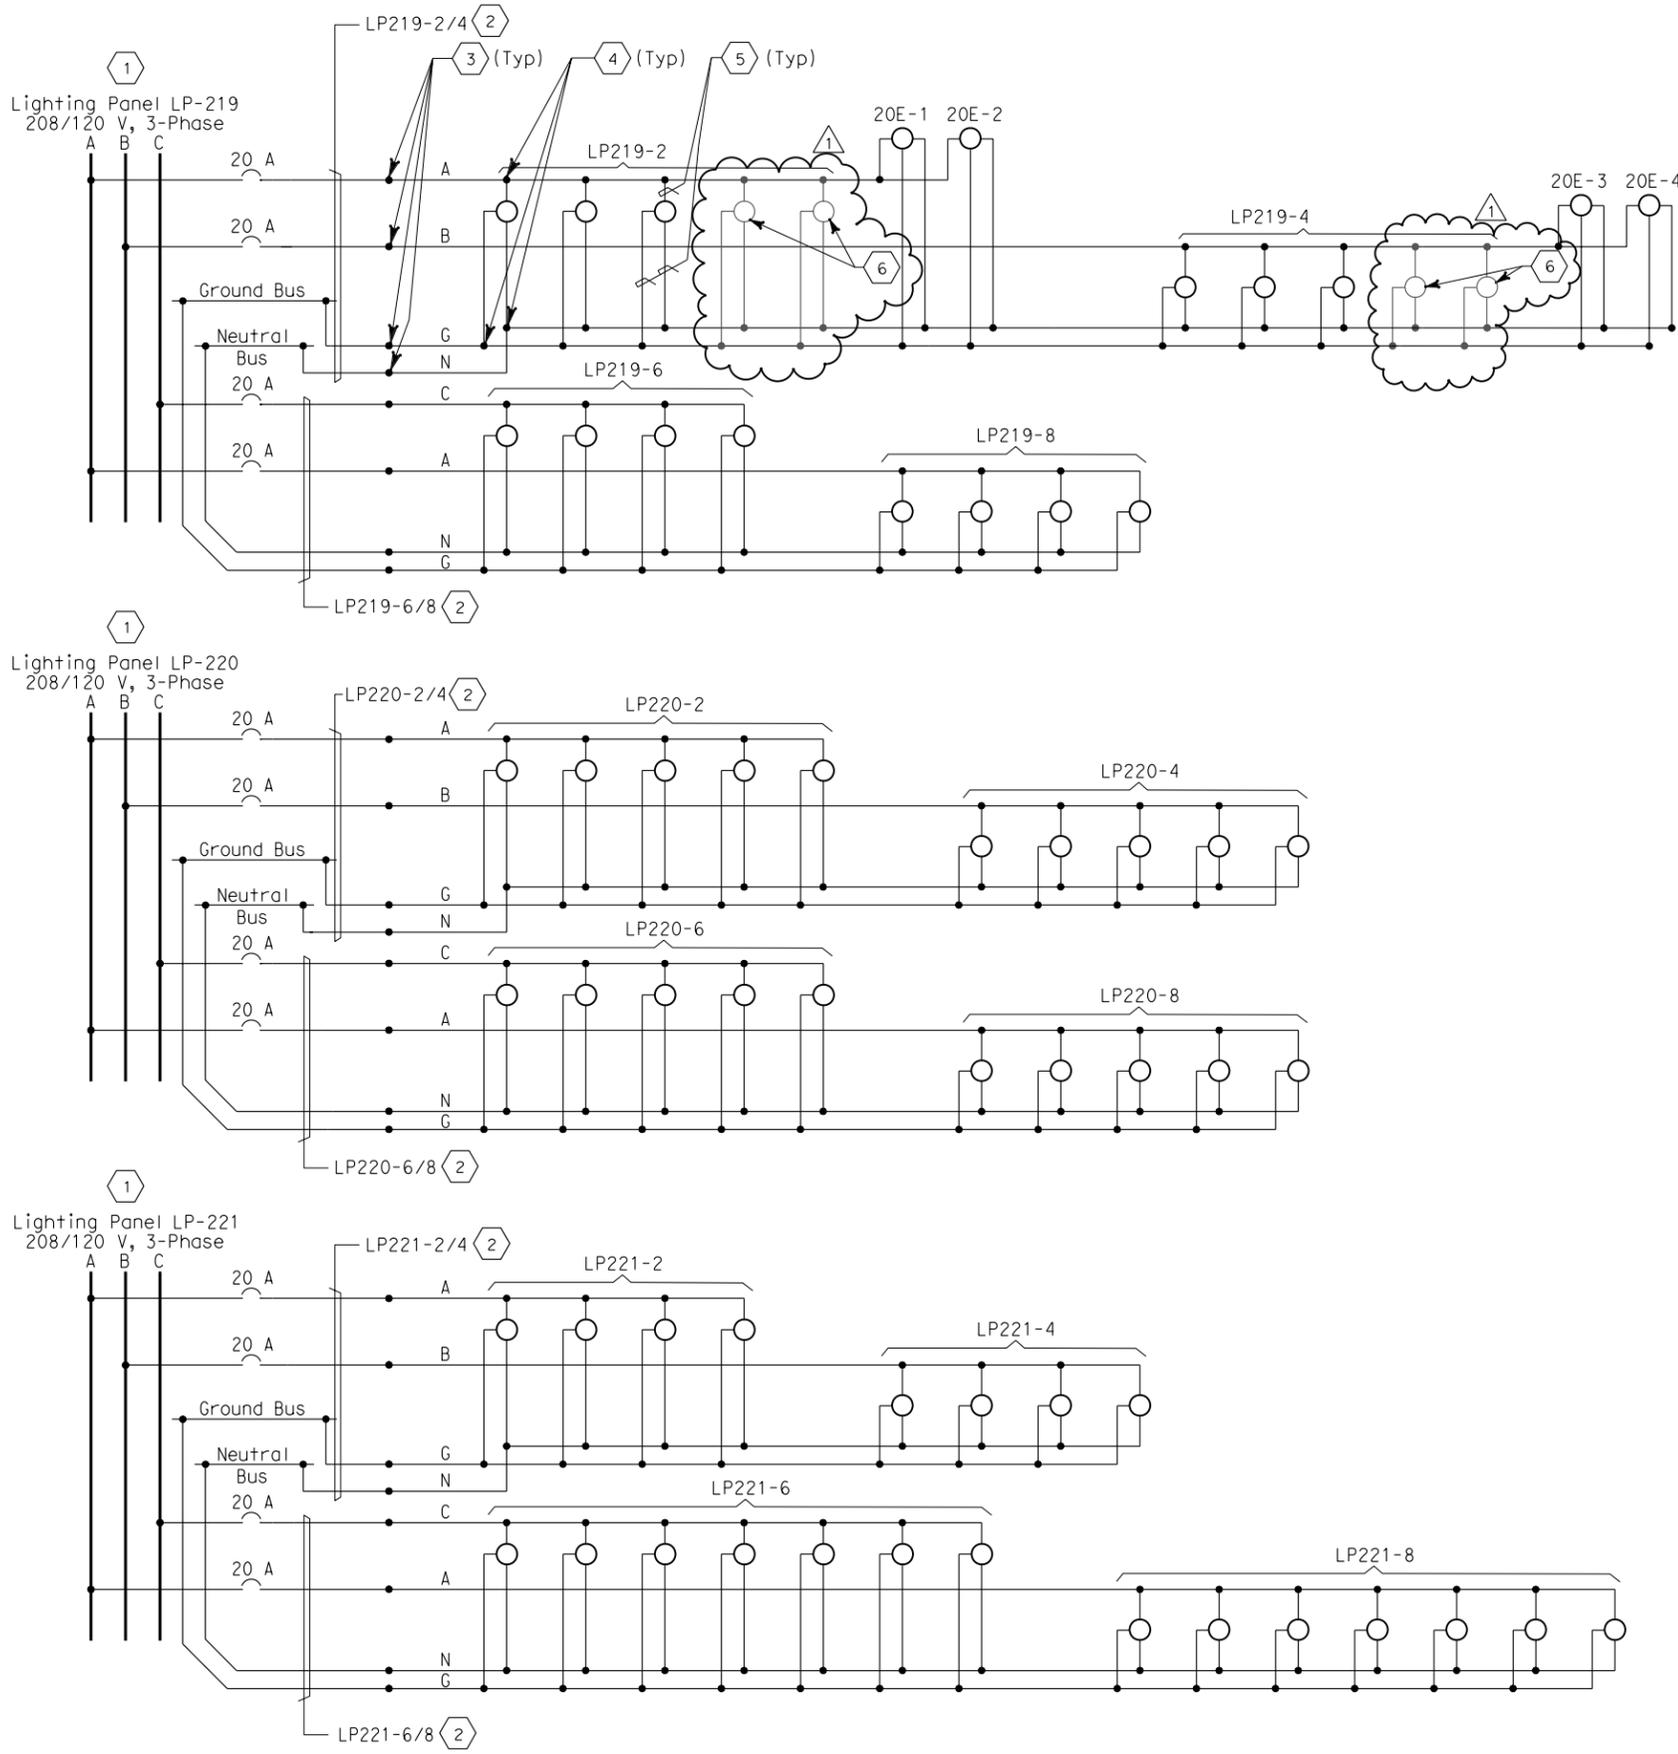

**SHEET NOTES:**

- 1 For lighting panel schedule LP-219, LP-220, LP-221, see sheets E-155 and E-156.
- 2 Lighting feeder cable is 3/C #6 + G.
- 3 Conductors spliced inside PB-LTG located in barrier.
- 4 Conductors spliced inside PB-LTG (PB-9A) located next to bike path.
- 5 2#10 + #10 G single conductors.
- 6 Railing lights are contractor furnished and installed by others.

**NOTES:**

- 1. For circuit and conduit/cable tray schedules, see sheets starting at E-401.



M F Takai  
 FOR REVISION ONLY

REQUEST FOR INFORMATION NOT ADDRESSED IN THIS CCO REMAIN IN FORCE					
1	02/19/08	ELECTRICAL MODIFICATIONS	MP	RR	42
MARK	DATE	DESCRIPTIONS	BY	CH'D	CCO#
		REVISIONS			

CONTRACT CHANGE ORDER NO. \_\_\_\_\_  
 SHEET \_\_\_\_\_ OF \_\_\_\_\_

**DETAILS**  
**SAS SUPERSTRUCTURE ROADWAY EASTBOUND**  
**120 V BIKE PATH LIGHTING WIRING DIAGRAMS**  
 NO SCALE

STATE OF CALIFORNIA - DEPARTMENT OF TRANSPORTATION  
 Caltrans

DESIGN OVERSIGHT  
 BEHZAD GOLEMOHAMMADI

DESIGNED BY	REVISOR	DATE
CHECKED BY	DATE	DATE
JP	BL	II/OI

DATE PLOTTED => 4/4/2008  
 TIME PLOTTED => 4:48:56 PM  
 LAST REVISION 00-00-00