




STATE OF CALIFORNIA - DEPARTMENT OF TRANSPORTATION
Caltrans
 DESIGN OVERSIGHT
 BEHZAD GOLEMOHAMMADI
 REVISIONS
 DATE 12/06
 TW
 EUL
 CHECKED BY
 DESIGNED BY
 DATE REVISIONS

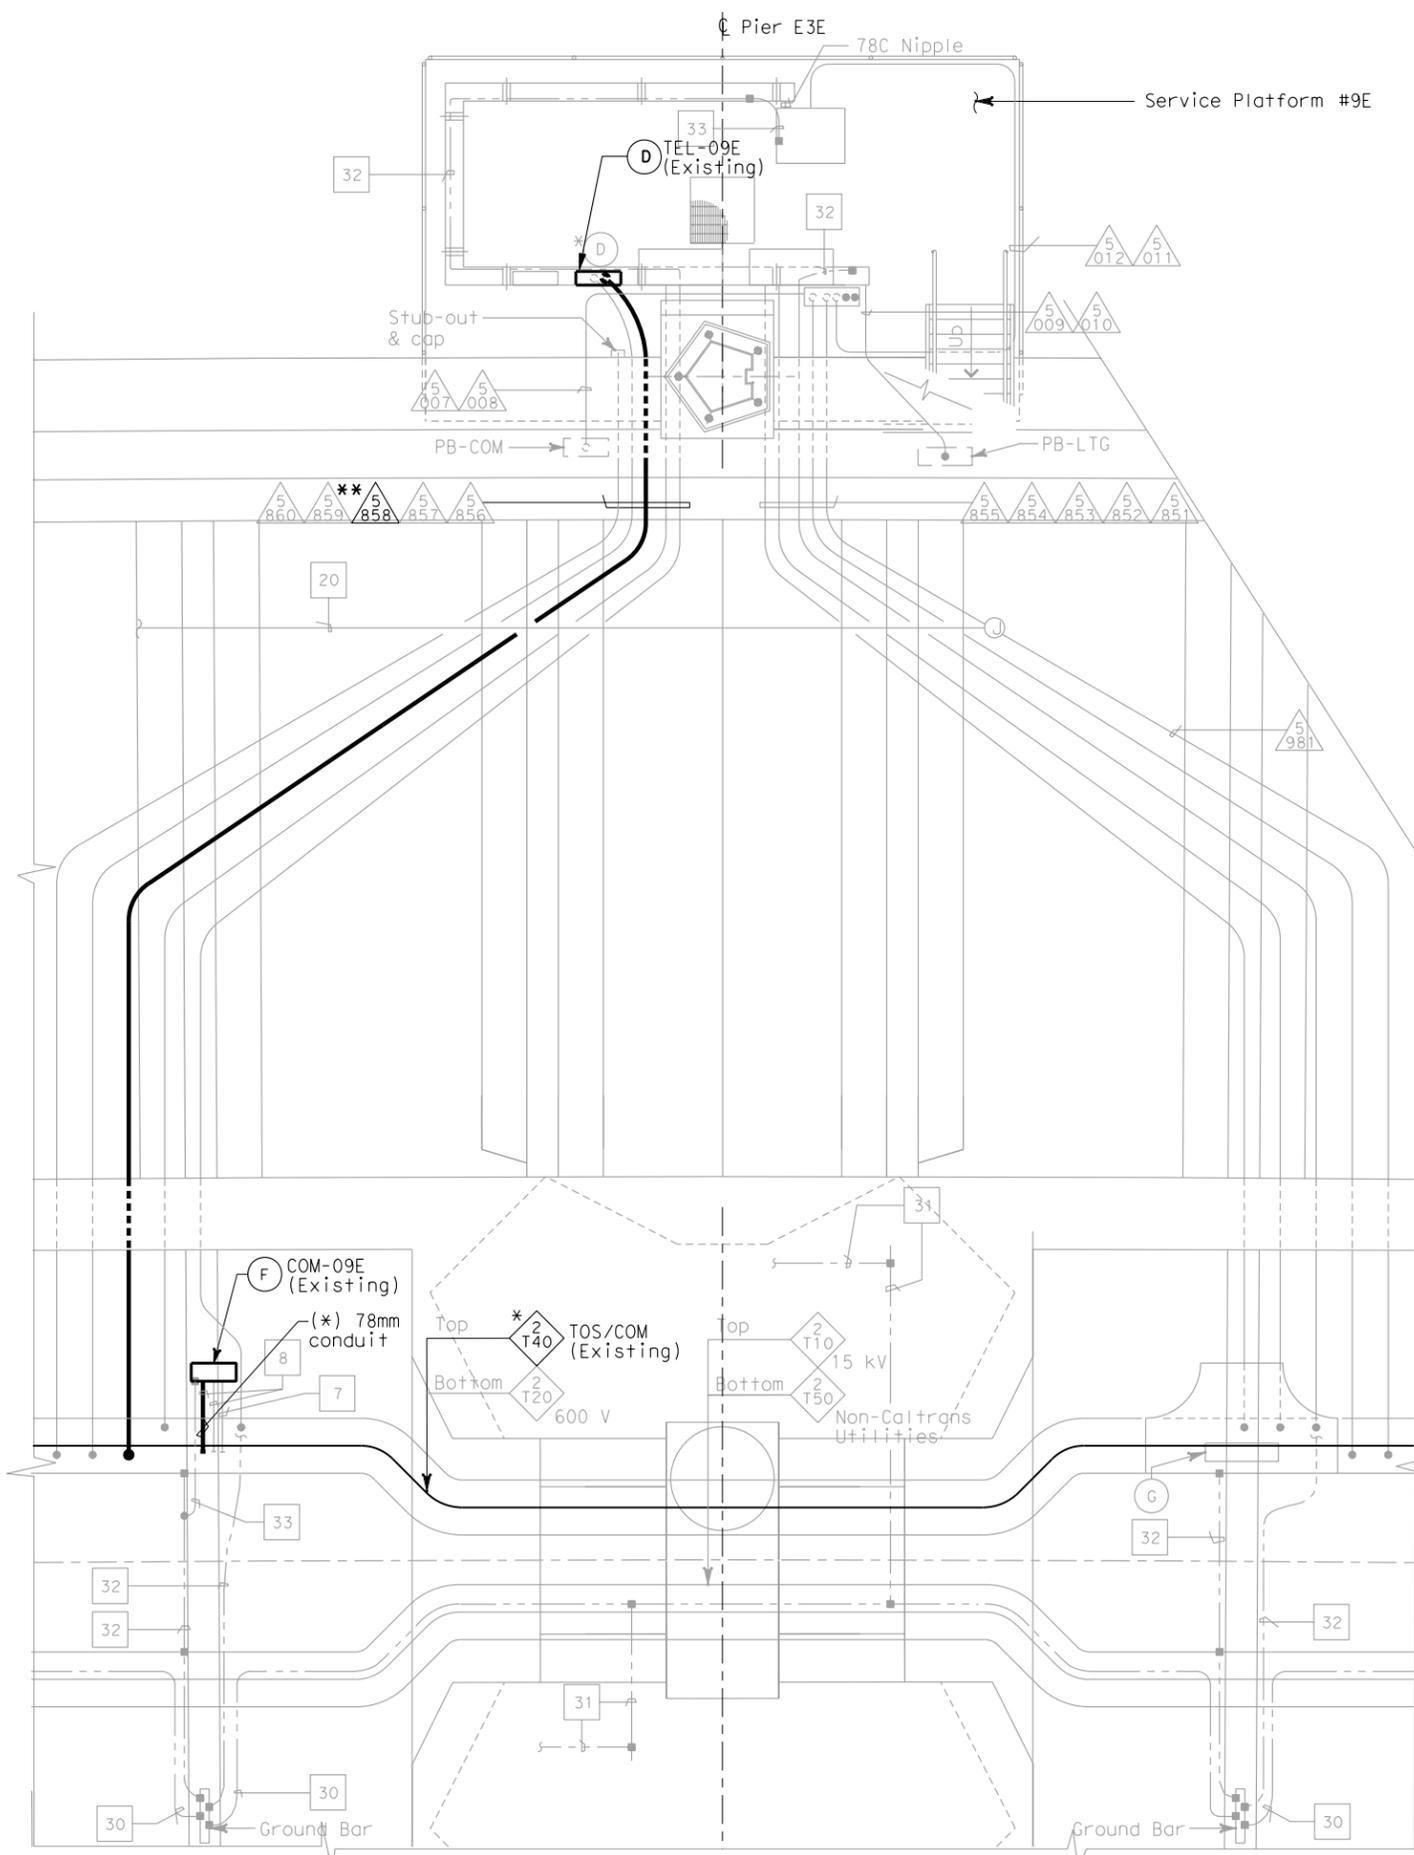

CONDUIT AND GROUNDING PLAN - EB
 SCALE: 1:40

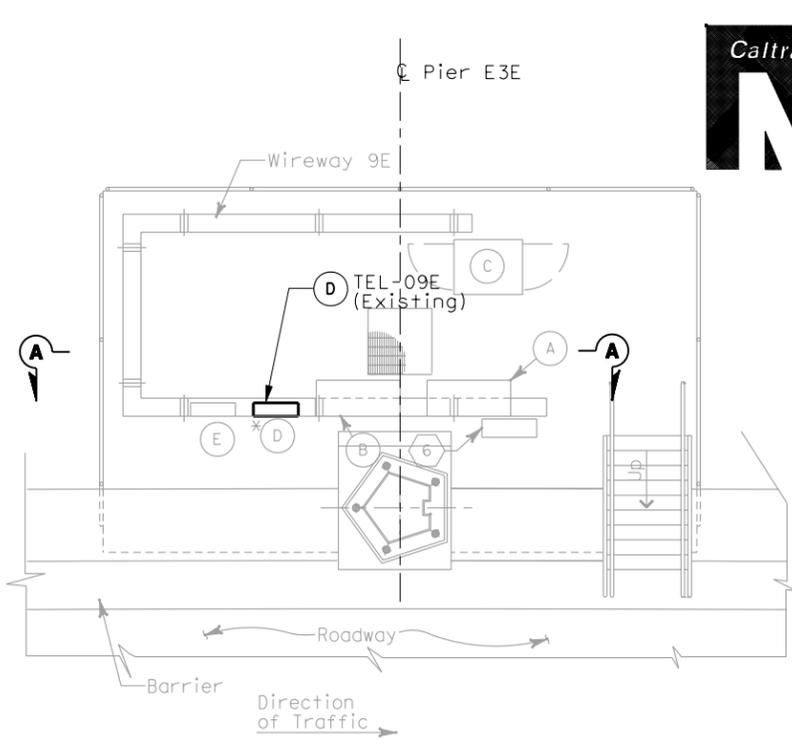

SERVICE PLATFORM #9E EQUIPMENT ARRANGEMENT PLAN
 SCALE: 1:40

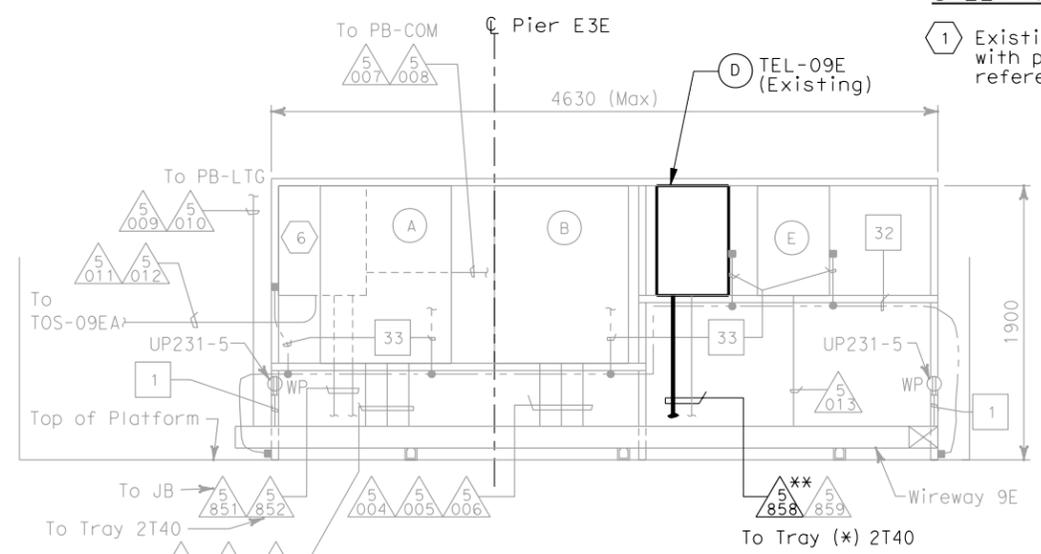

SECTION A-A
 SCALE: 1:25

REQUEST FOR INFORMATION NOT ADDRESSED IN THIS CCO REMAIN IN FORCE					
△	02/25/08	CABLE TRAY CHANGES	JD	RG	42S1
MARK	DATE	DESCRIPTIONS	BY	CH'D	CCO#
		REVISIONS			

CONTRACT CHANGE ORDER NO. _____
 SHEET _____ OF _____

SAS SUPERSTRUCTURE AND SKYWAY STRUCTURE GIRDER INTERFACE EASTBOUND SERVICE PLATFORM #9W
 SCALE AS NOTED

Caltrans
Metric

DIST	COUNTY	ROUTE	KILOMETER TOTAL PROJECT	POST TOTAL PROJECT	SHEET No	TOTAL SHEETS
04	SF	80	13.2/13.9		221/53	1204

REGISTERED ELECTRICAL ENGINEER
 DATE 2/22/08
 No. E-10151
 Exp. 12/31/2008
 STATE OF CALIFORNIA

PLANS APPROVAL DATE
 PB AMERICAS, Inc.
 A Parsons Brinckerhoff Company
 303 Second St., Suite 700N
 San Francisco, CA 94107-1317

 
The State of California or its officers or agents shall not be responsible for the accuracy or completeness of electronic copies of this plan sheet.
 Caltrans now has a web site! To get to the web site, go to <http://www.dot.ca.gov>

- EQUIPMENT SCHEDULE:**
- (A) Utility Panel UP-231
100 A, 208/120 V, 3-Phase, 4-Wire
 - (B) Lighting Panel LP-251
100 A, 208/120 V, 3-Phase, 4-Wire
 - (C) Controller Cabinet #TOS-09EA
 - (D) Telephone Terminal Box #TEL-09E (Existing)
 - (E) Navigation Relay Cabinet #NAP-9E
 - (F) Scada Communication Terminal Box #COM-09E (Existing)
 - (G) Fiber Optic Splice Box.

- SHEET NOTES:**
- 1 Existing conduits and cable trays with prefixed (*) and (**) are for reference and cable routing only.

THIS PLAN ACCURATE FOR ELECTRICAL WORK ONLY.

ALL DIMENSIONS ARE IN MILLIMETERS UNLESS OTHERWISE SHOWN



DGN FILE => T:\13103\MS\pse\SAS Struc\CCO\SAS CC04251\04-0120F1_0221S03.dgn
 USERNAME => llorico
 CU 04251

EA 0120F1

E-186D

DATE PLOTTED => 2/26/2008
 TIME PLOTTED => 1:46:13 PM
 LAST REVISION 00-00-00