

DESIGNED BY	BEHZAD GOLEMOHAMMADI
CHECKED BY	
DATE	
REVISIONS	

DESIGN OVERSIGHT	BEHZAD GOLEMOHAMMADI
CALCULATED/DESIGNED BY	
DATE	
REVISIONS	

DATE	10/01	REVISIONS	
FK		EDC	
DATE	11/01	DATE	REVIS



DIST	COUNTY	ROUTE	KILOMETER POST TOTAL PROJECT	SHEET No	TOTAL SHEETS
04	SF	80	13.2/13.9	286 R1	1204


12/19/02
 REGISTERED ELECTRICAL ENGINEER DATE

12-6-04
 PLANS APPROVAL DATE

PB POWER, Inc.
 A Parsons Brinckerhoff Company
 303 Second St., Suite 700N
 San Francisco, CA 94107-1317

The State of California or its officers or agents shall not be responsible for the accuracy or completeness of electronic copies of this plan sheet.

Caltrans now has a web site! To get to the web site, go to <http://www.dot.ca.gov>

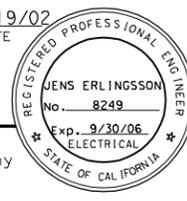


- SHEET NOTES:**
- 1 Not used
 - 2 At Elev 53 and 89 provide lights and switches from circuits above and below level. See sheets E-284 & E-284A, for details.
 - 3 To lighting and receptacle junction boxes or switches.
 - 4 For lighting fixture locations and conduit routing see Dwg E282, E264B, E285 and E285B.

- NOTES:**
1. References:
- For lighting fixture schedules, see sheet E-273.
 - For light and switch wiring, see sheets E-274, E-275, and E-275A.
 - For typical tower ladder platform lighting, see E-284 and E-284A.
 - For typical lighting installation, see sheet E-267.
 - For switches/receptacles mounting see Detail 11, Sheet E-268


REQUEST FOR INFORMATION NOT ADDRESSED IN THIS CCO REMAIN IN FORCE					
1	12/02/09	TOWER UTILITY PANELS	JS	RG	70
MARK	DATE	DESCRIPTIONS	BY	CH'D	CCO#
REVISIONS					

CONTRACT CHANGE ORDER NO. _____
 SHEET _____ OF _____

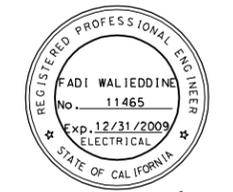


FOR REVISION ONLY


DETAILS
TOWER AND SUSPENSION CABLE
TOWER LADDER PLATFORM LIGHTING
 SCALE AS NOTED

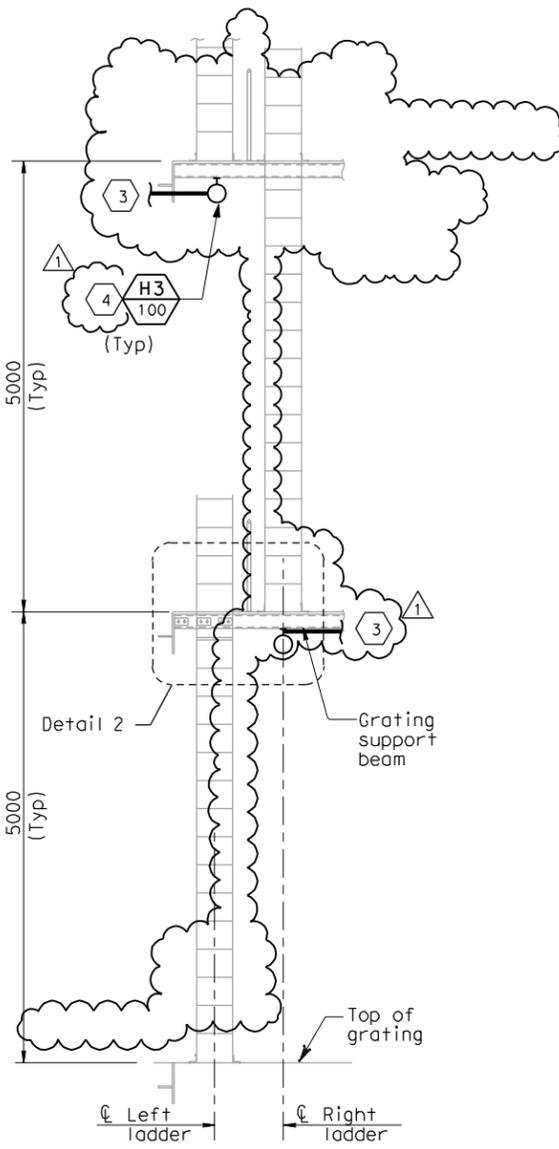


FRONT VIEW
TYPICAL LADDER PLATFORM LIGHTING LAYOUT
 SCALE: 1:40

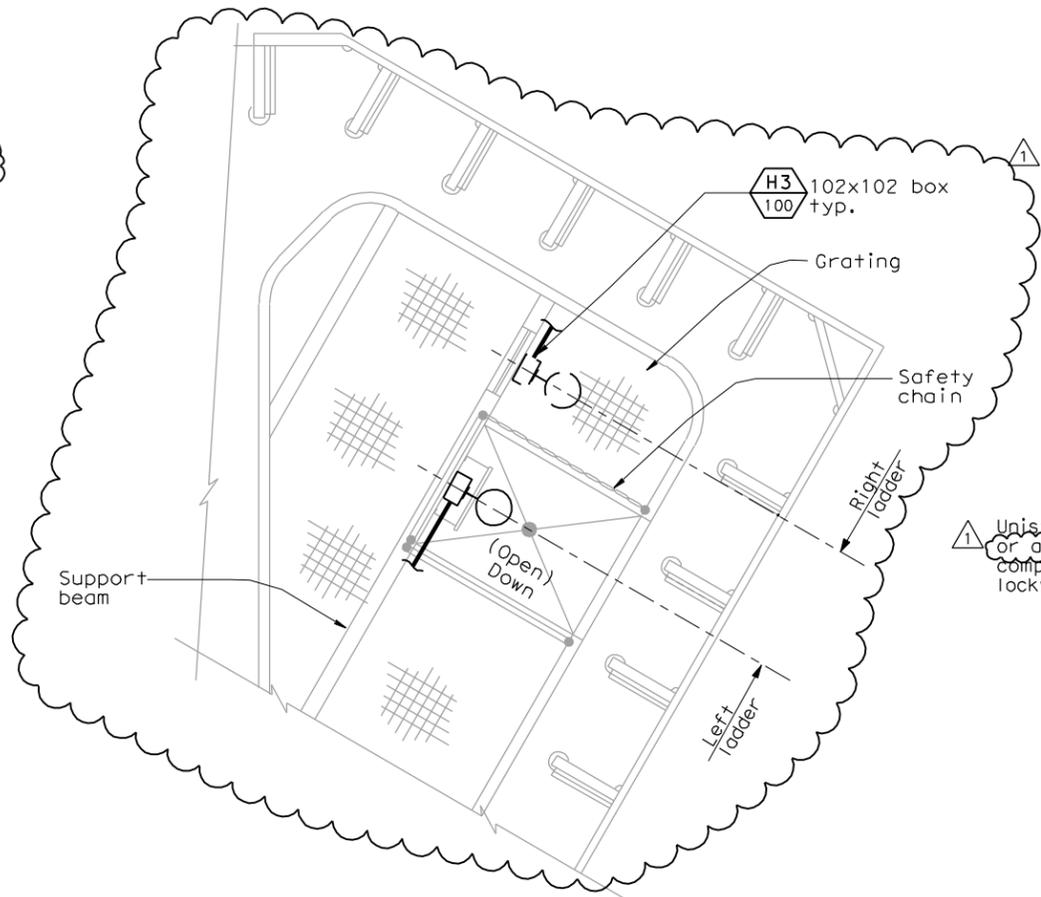

TYPICAL LIGHTING FIXTURE SUPPORT FROM SUPPORT BEAM
 SCALE: 1:10

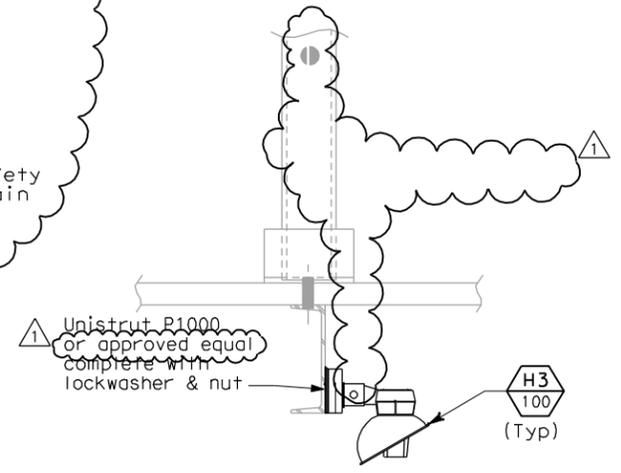

SECTION B-B
 SCALE: 1:5

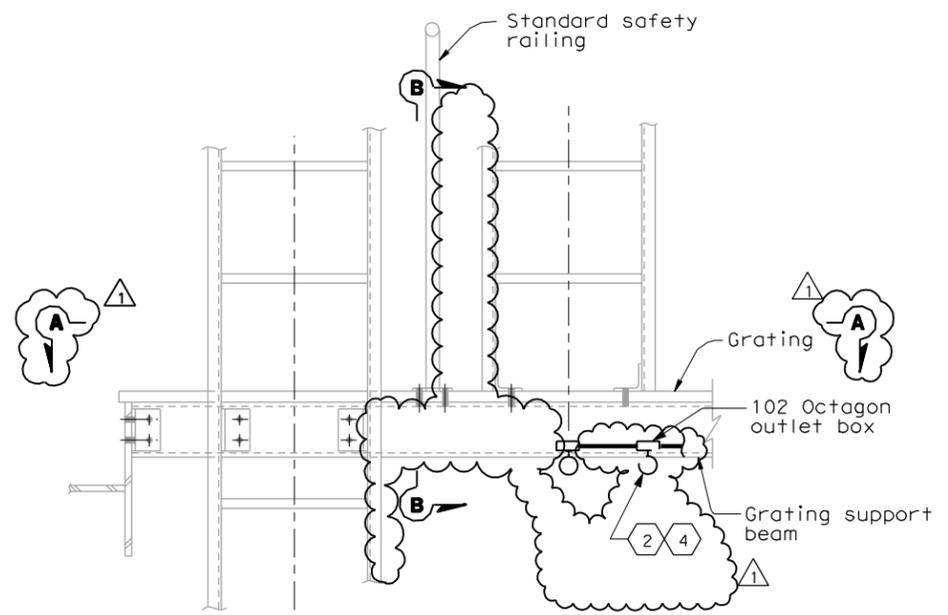

DETAIL 2
 SCALE: 1:10
 (Typ for El. 53.85 & El. 89.85)

THIS PLAN ACCURATE FOR ELECTRICAL WORK ONLY.

ALL DIMENSIONS ARE IN MILLIMETERS UNLESS OTHERWISE SHOWN



DATE PLOTTED => 12/10/2009
 TIME PLOTTED => 4:00:40 PM
 LAST REVISION 00-00-00