


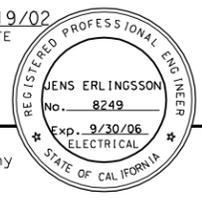


DIST	COUNTY	ROUTE	KILOMETER TOTAL PROJECT	POST TOTAL PROJECT	SHEET No	TOTAL SHEETS
04	SF	80	13.2/13.9		289 R2	1204

12/19/02
 REGISTERED ELECTRICAL ENGINEER DATE
 12-6-04
 PLANS APPROVAL DATE
 PB POWER, Inc.
 A Parsons Brinckerhoff Company
 303 Second St., Suite 700N
 San Francisco, CA 94107-1317
 The State of California or its officers or agents shall not be responsible for the accuracy or completeness of electronic copies of this plan sheet.
 Caltrans now has a web site! To get to the web site, go to <http://www.dot.ca.gov>



STATE OF CALIFORNIA - DEPARTMENT OF TRANSPORTATION
 DESIGN OVERSIGHT
 BEHZAD GOLEMOHAMMADI
 REVISIONS
 DATE 10/01
 DATE 11/01
 FK
 EDC
 CHECKED BY
 REVISOR BY
 DATE REVISOR
 DATE REVISOR

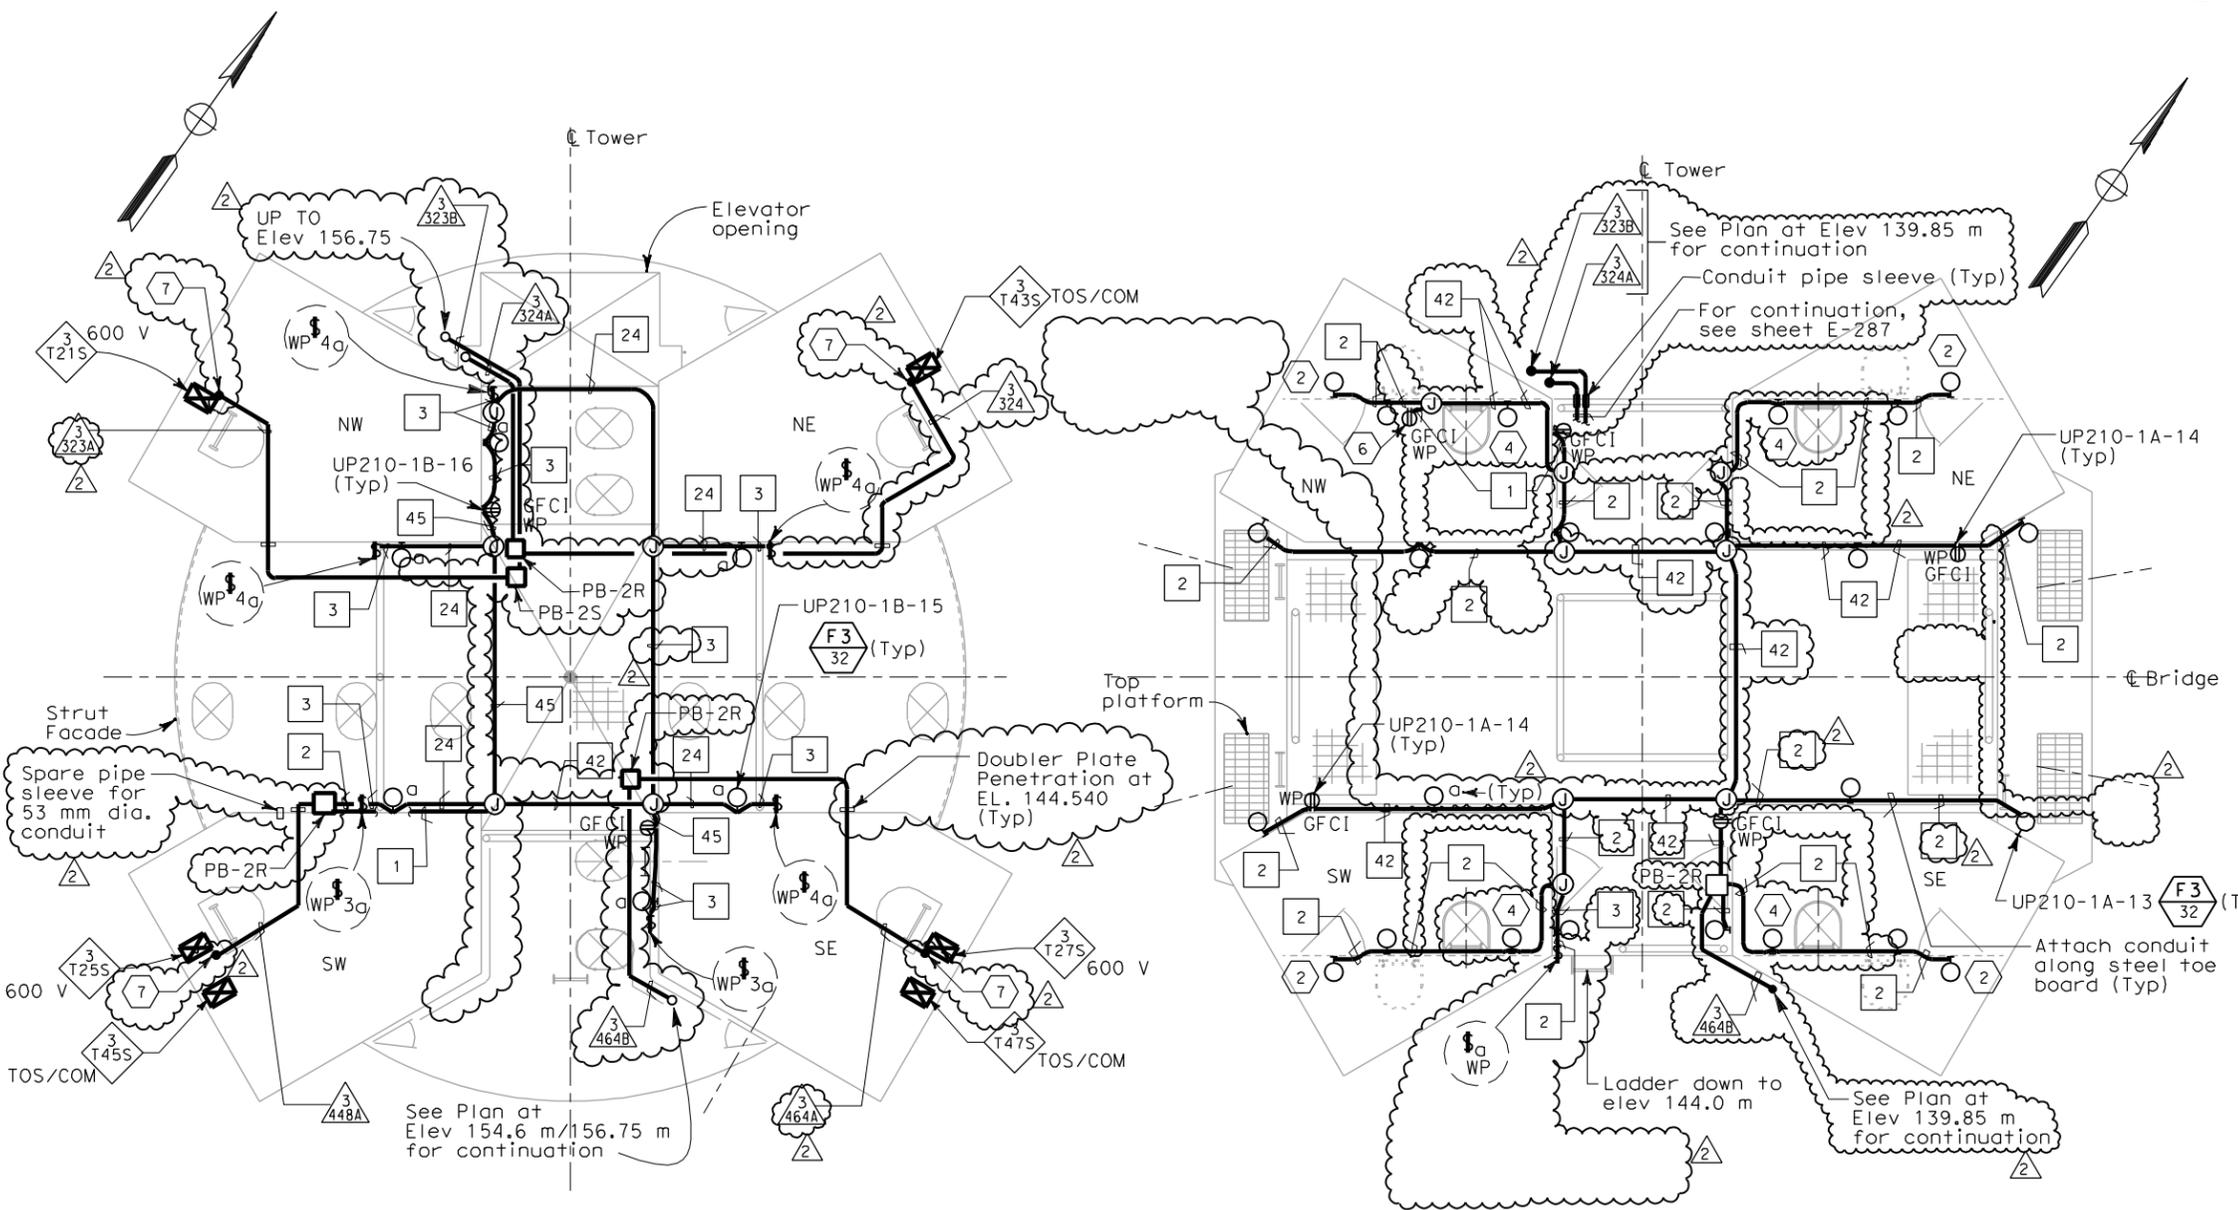

PLAN AT ELEVATION 139.85 m
SCALE: 1:40

PLAN AT ELEVATIONS 154.6 m TO 156.75 m
SCALE: 1:40

SHEET NOTES:

- ① Deleted.
- ② Fixture mounting height elevation shall be 158.5 m.
- ③ Deleted.
- ④ Fixture mounting height elevation shall be 159.25 m.
- ⑤ Conduit from elevation 89.85 up to elevation 156.75.
- ⑥ Receptacle mounting height elevation shall be 158.450 m.
- ⑦ Conduit down to cable tray located below EL. 143.00 diaphragm.

NOTES:

1. References:
 - For utility panels UP210-1A and UP210-1B, panel schedules see sheets E-279 and E-280.
 - For types of pull boxes, splice boxes and enclosures, see sheets E-83 and E-169.
 - For conduit and cable tray schedules, see sheets starting at E-401.
 - For lighting installation details, see sheet E-267.
 - For lighting fixture schedule, see sheet E-263.
 - Deleted.
 - For typical conduit installation details, see sheet E-268.
2. All conduits and fittings routed exposed at grating shall be rigid galvanized steel, PVC coated.
3. Fixture mounting height shall be 2.125 m above floor/platform elevation UNO.
4. Electrical conduits shall enter the tower shafts between stiffeners A3 and A4 only. For conduit entry details, see Structural Utility drawings.
5. For other related work not shown on this sheet, see Electrical Special Provisions.

REQUEST FOR INFORMATION NOT ADDRESSED IN THIS CCO REMAIN IN FORCE						
MARK	DATE	DESCRIPTIONS	BY	CH'D	CCO#	
②	12/11/09	TOWER UTILITY PANELS	SYC	FW	70	
①	02/19/08	ELECTRICAL MODIFICATIONS	MP	RR	42	
		REVISIONS				

CONTRACT CHANGE ORDER NO. _____
SHEET _____ OF _____



FOR REVISION ONLY




FOR REVISION ONLY

**DETAILS
TOWER AND SUSPENSION CABLE
TOWER POWER AND LIGHTING**

SCALE 1:50

E-286

 THIS PLAN ACCURATE FOR ELECTRICAL WORK ONLY.



DATE PLOTTED => 12/10/2009
TIME PLOTTED => 4:04:22 PM
LAST REVISION 00-00-00